


This drawing is the copyright of LDM Deisgn.
All dimensions to be checked on site.
Do not scale.
All levels to be checked on site and refer to Ordnance Survey Datum Newlyn unless alternative datum given.
All errors and omissions to be reported to the Architect prior to commencement.
This drawing must be read in conjunction with the relevant specification clauses.
This drawing must not be used on site unless issued for construction.

Underground Refuse Systems:



Single 3m3 waste collection container and is typically specified where the required excavation space is limited due to below ground services or available surface footprint at street level.

Underground waste systems are designed around a sealed precast concrete chamber set into the ground. Within this concrete chamber a galvanised steel frame locates the waste containers and incorporates safety doors that cover the chamber when the waste container is removed for emptying and maintenance.



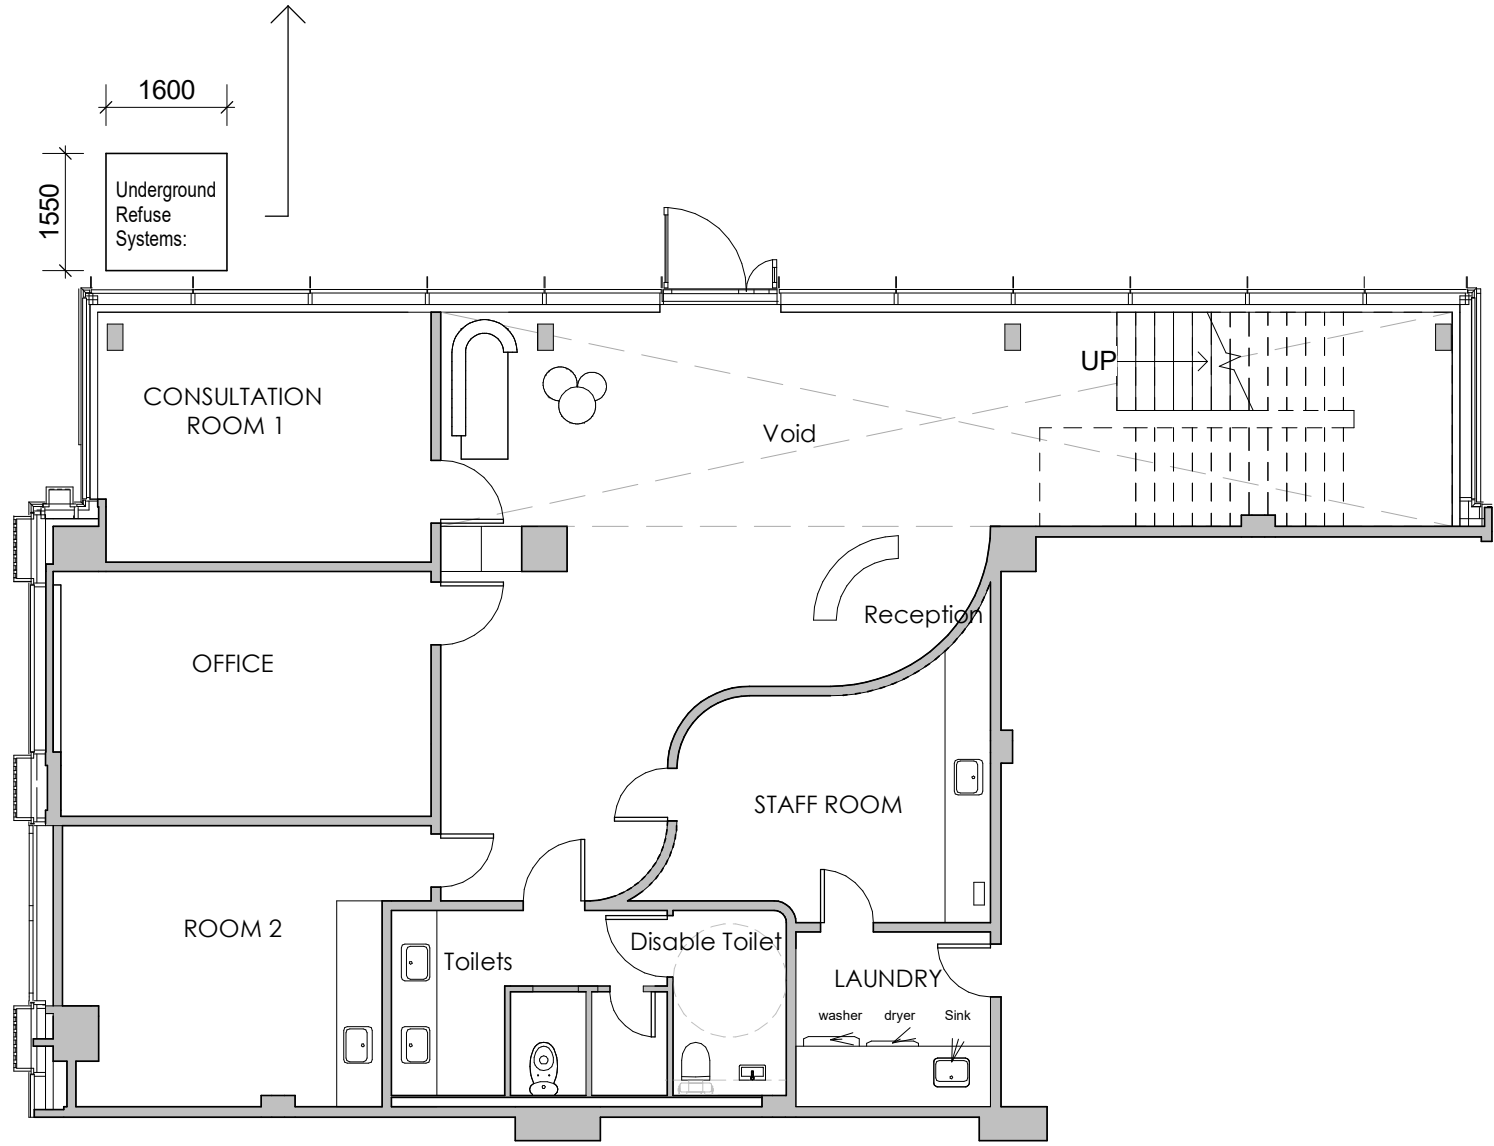


Proposed Ground Floor
1 : 100

Underground Refuse Systems:

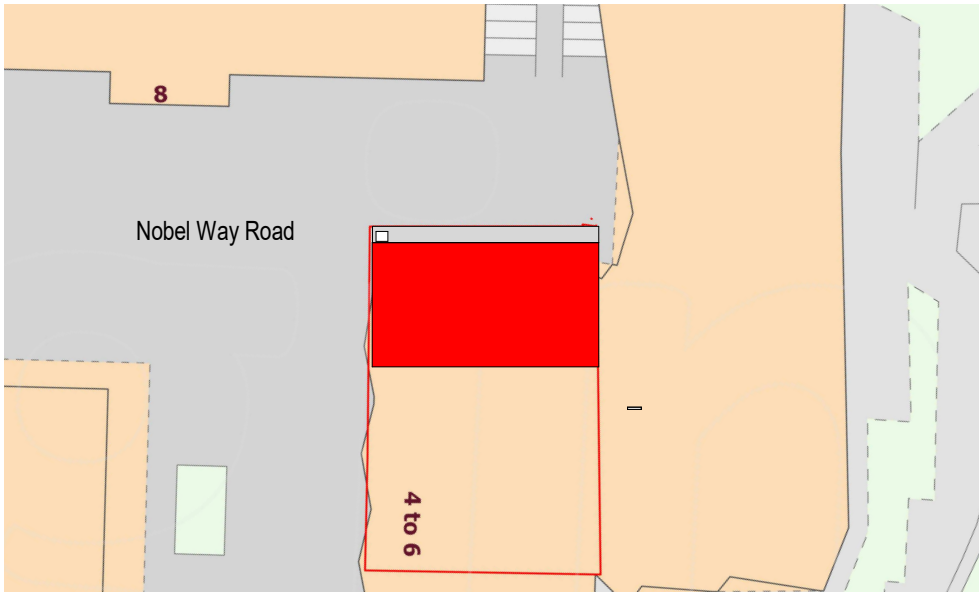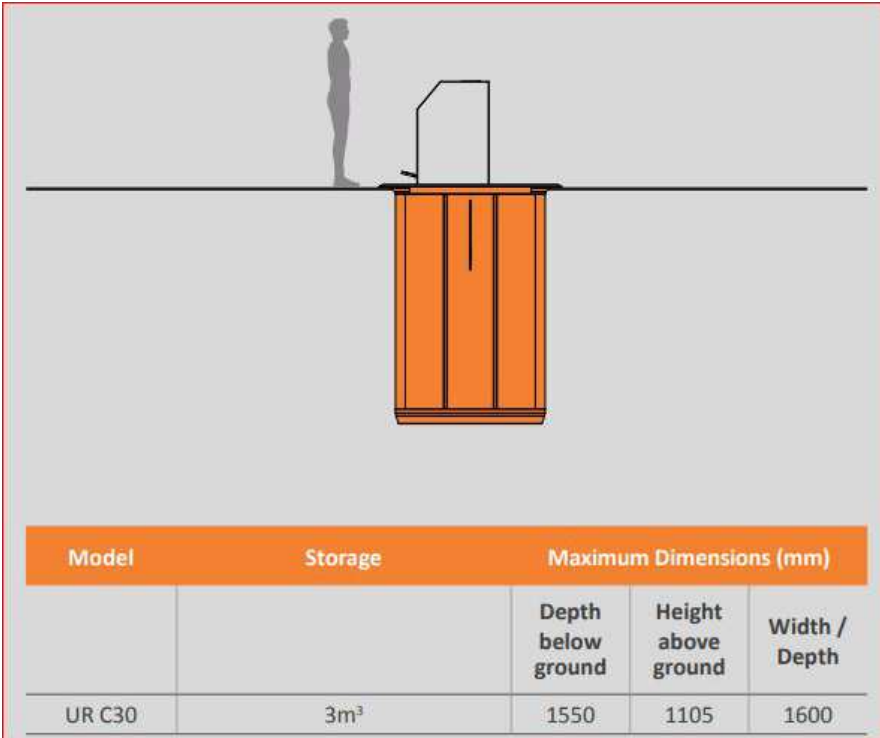

Proposed Site Plan
1 : 500

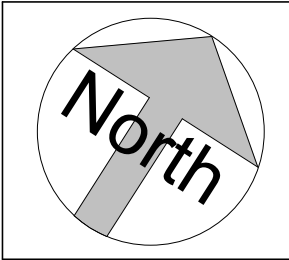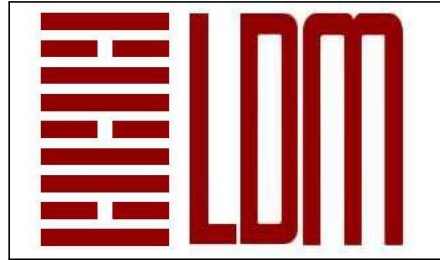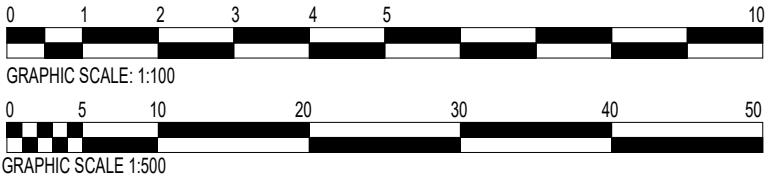

LDM Design

PROJECT
Unit L4 Vita East Circle Square 9
Nobel Way Manchester M1 7FT

SHEET
Bin Storage Drawing

CLIENT			
Scale (@ A3)		As indicated	
Drawn by	BA	DRAWING NUMBER A3-141	REV A
Checked by	BA		