


THIS DRAWING IS TO BE READ IN CONJUNCTION WITH
SUTCLIFFE DRAINAGE PLAN REF:

- 33029-SUT-ZZ-XX-DR-C-6201 - P03

CONTRACTOR TO CHECK BOTH THIS DRAWING AND THE ABOVE
LISTED DRAWING ARE BOTH THE CURRENT REVISION PRIOR TO
USING THIS INFORMATION.

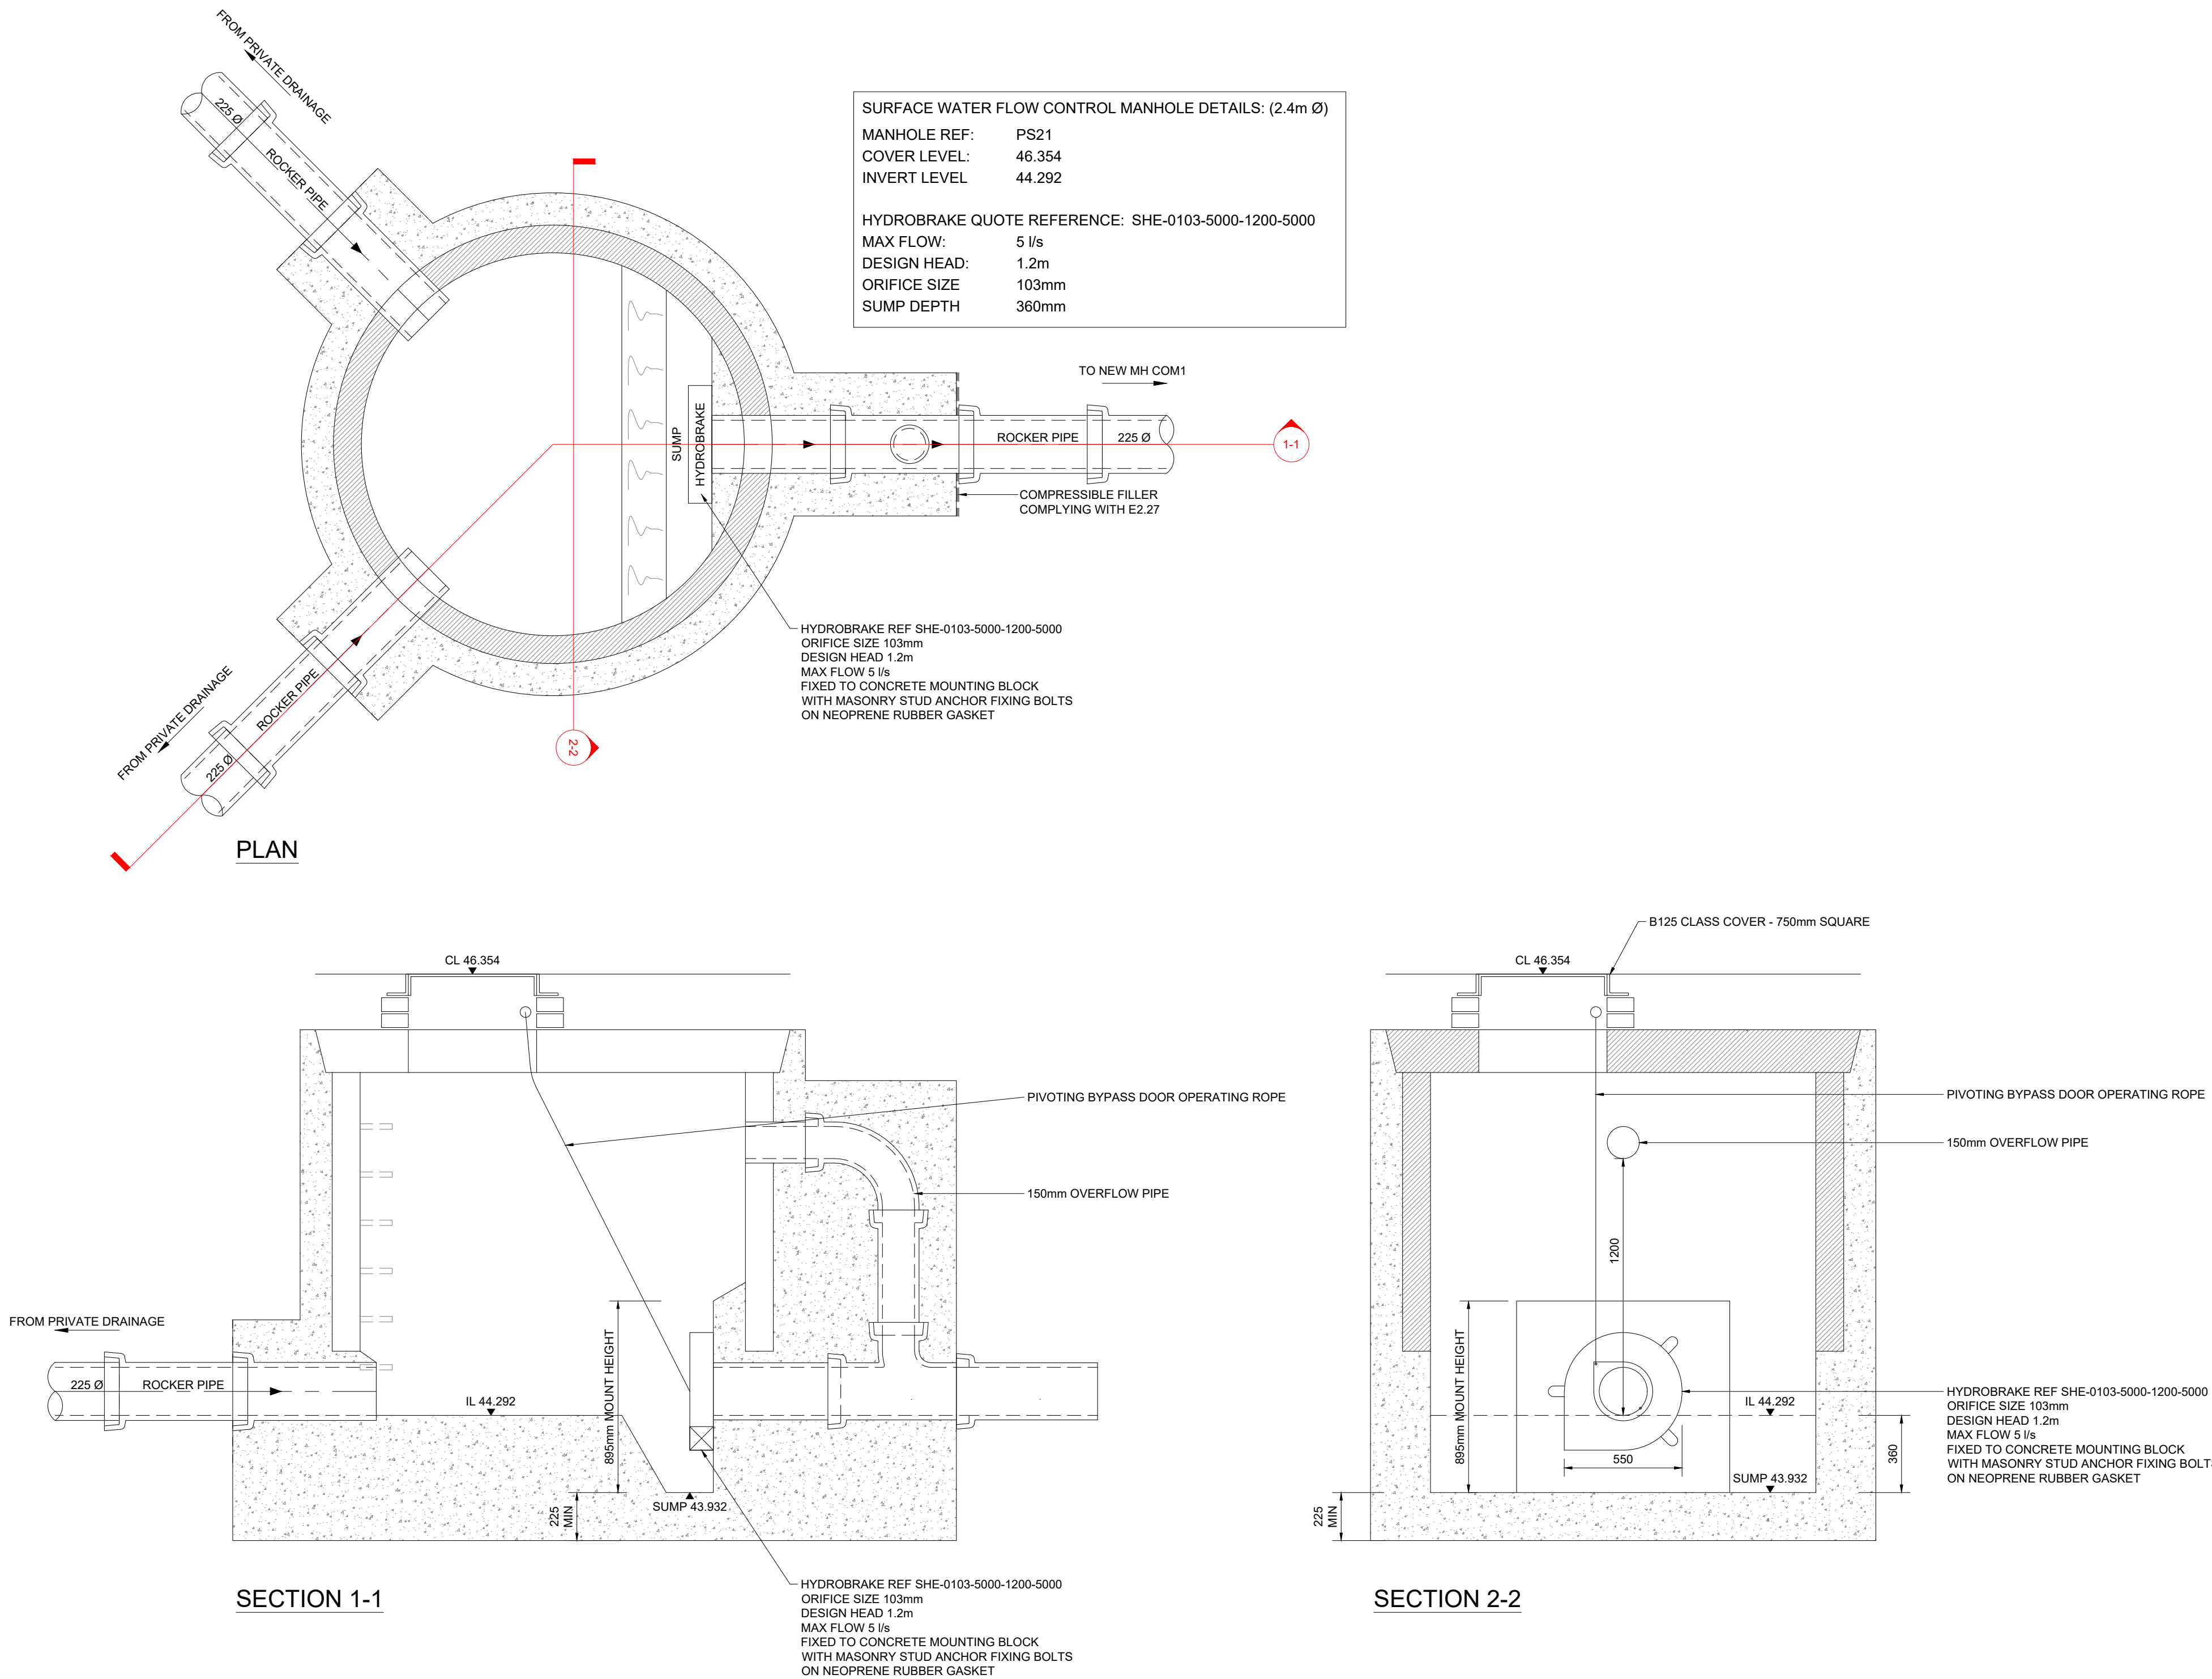

P01	PRELIMINARY DRAWING	21.06.23	CR	SB
Rev	Description	Date	By	Chkd

Drawing Status

PRELIMINARY DRAWING



Sutcliffe

Structural & Civil Engineering
Geotechnical & Environmental Investigations
Building Surveying
Pre Planning Services

Liverpool Head Office: 0151 227 3115
Manchester Office: 0161 817 5180
North Wales Office: 01708 644107
Leeds Office: 0111 8014 4200

www.sutcliffe.co.uk

Accredited by:
BSI
PAS
ISO 9001
ISO 14001
ISO 45001

Client
WYTHENSHAW COMMUNITY HOUSING

Project
**THE ENTERPRISE CENTRE
BENCHILL ROAD
MANCHESTER**

Drawing Title
**FLOW CONTROL MANHOLE
DETAILS**

Date 05.06.24	Drawn By CR	Checked By SB
Scale at A1 NA	Project Number 33029	
Sheet Number 33029-SUT-ZZ-XX-DR-C-6301	Revision P01	