

Notes

This drawing is the property of Mike Macpherson Architects and copyright is reserved by them. This drawing is not to be copied or disclosed by or to any unauthorised persons without the prior written consent of Mike Macpherson Architects.

Do not scale for construction purposes.
All dimensions are to be checked on site prior to construction, manufacture of any components and ordering of materials and equipment.

Any discrepancies are to be reported to the architect for clarification.

All materials and workmanship to be in accordance with the current British Standards and codes of practice.

KEY



Suspended 600x600mm grid with lay-in white tile system with integrated fluorescent light panels



 
Surface mounted circular LED type light fitting



Surface mounted fluorescent tube type light fitting




Recessed LED downlight fitting



Antique mirror finish to Dining Room ceiling recessed central panel



New suspended feature light fitting to Dining Room

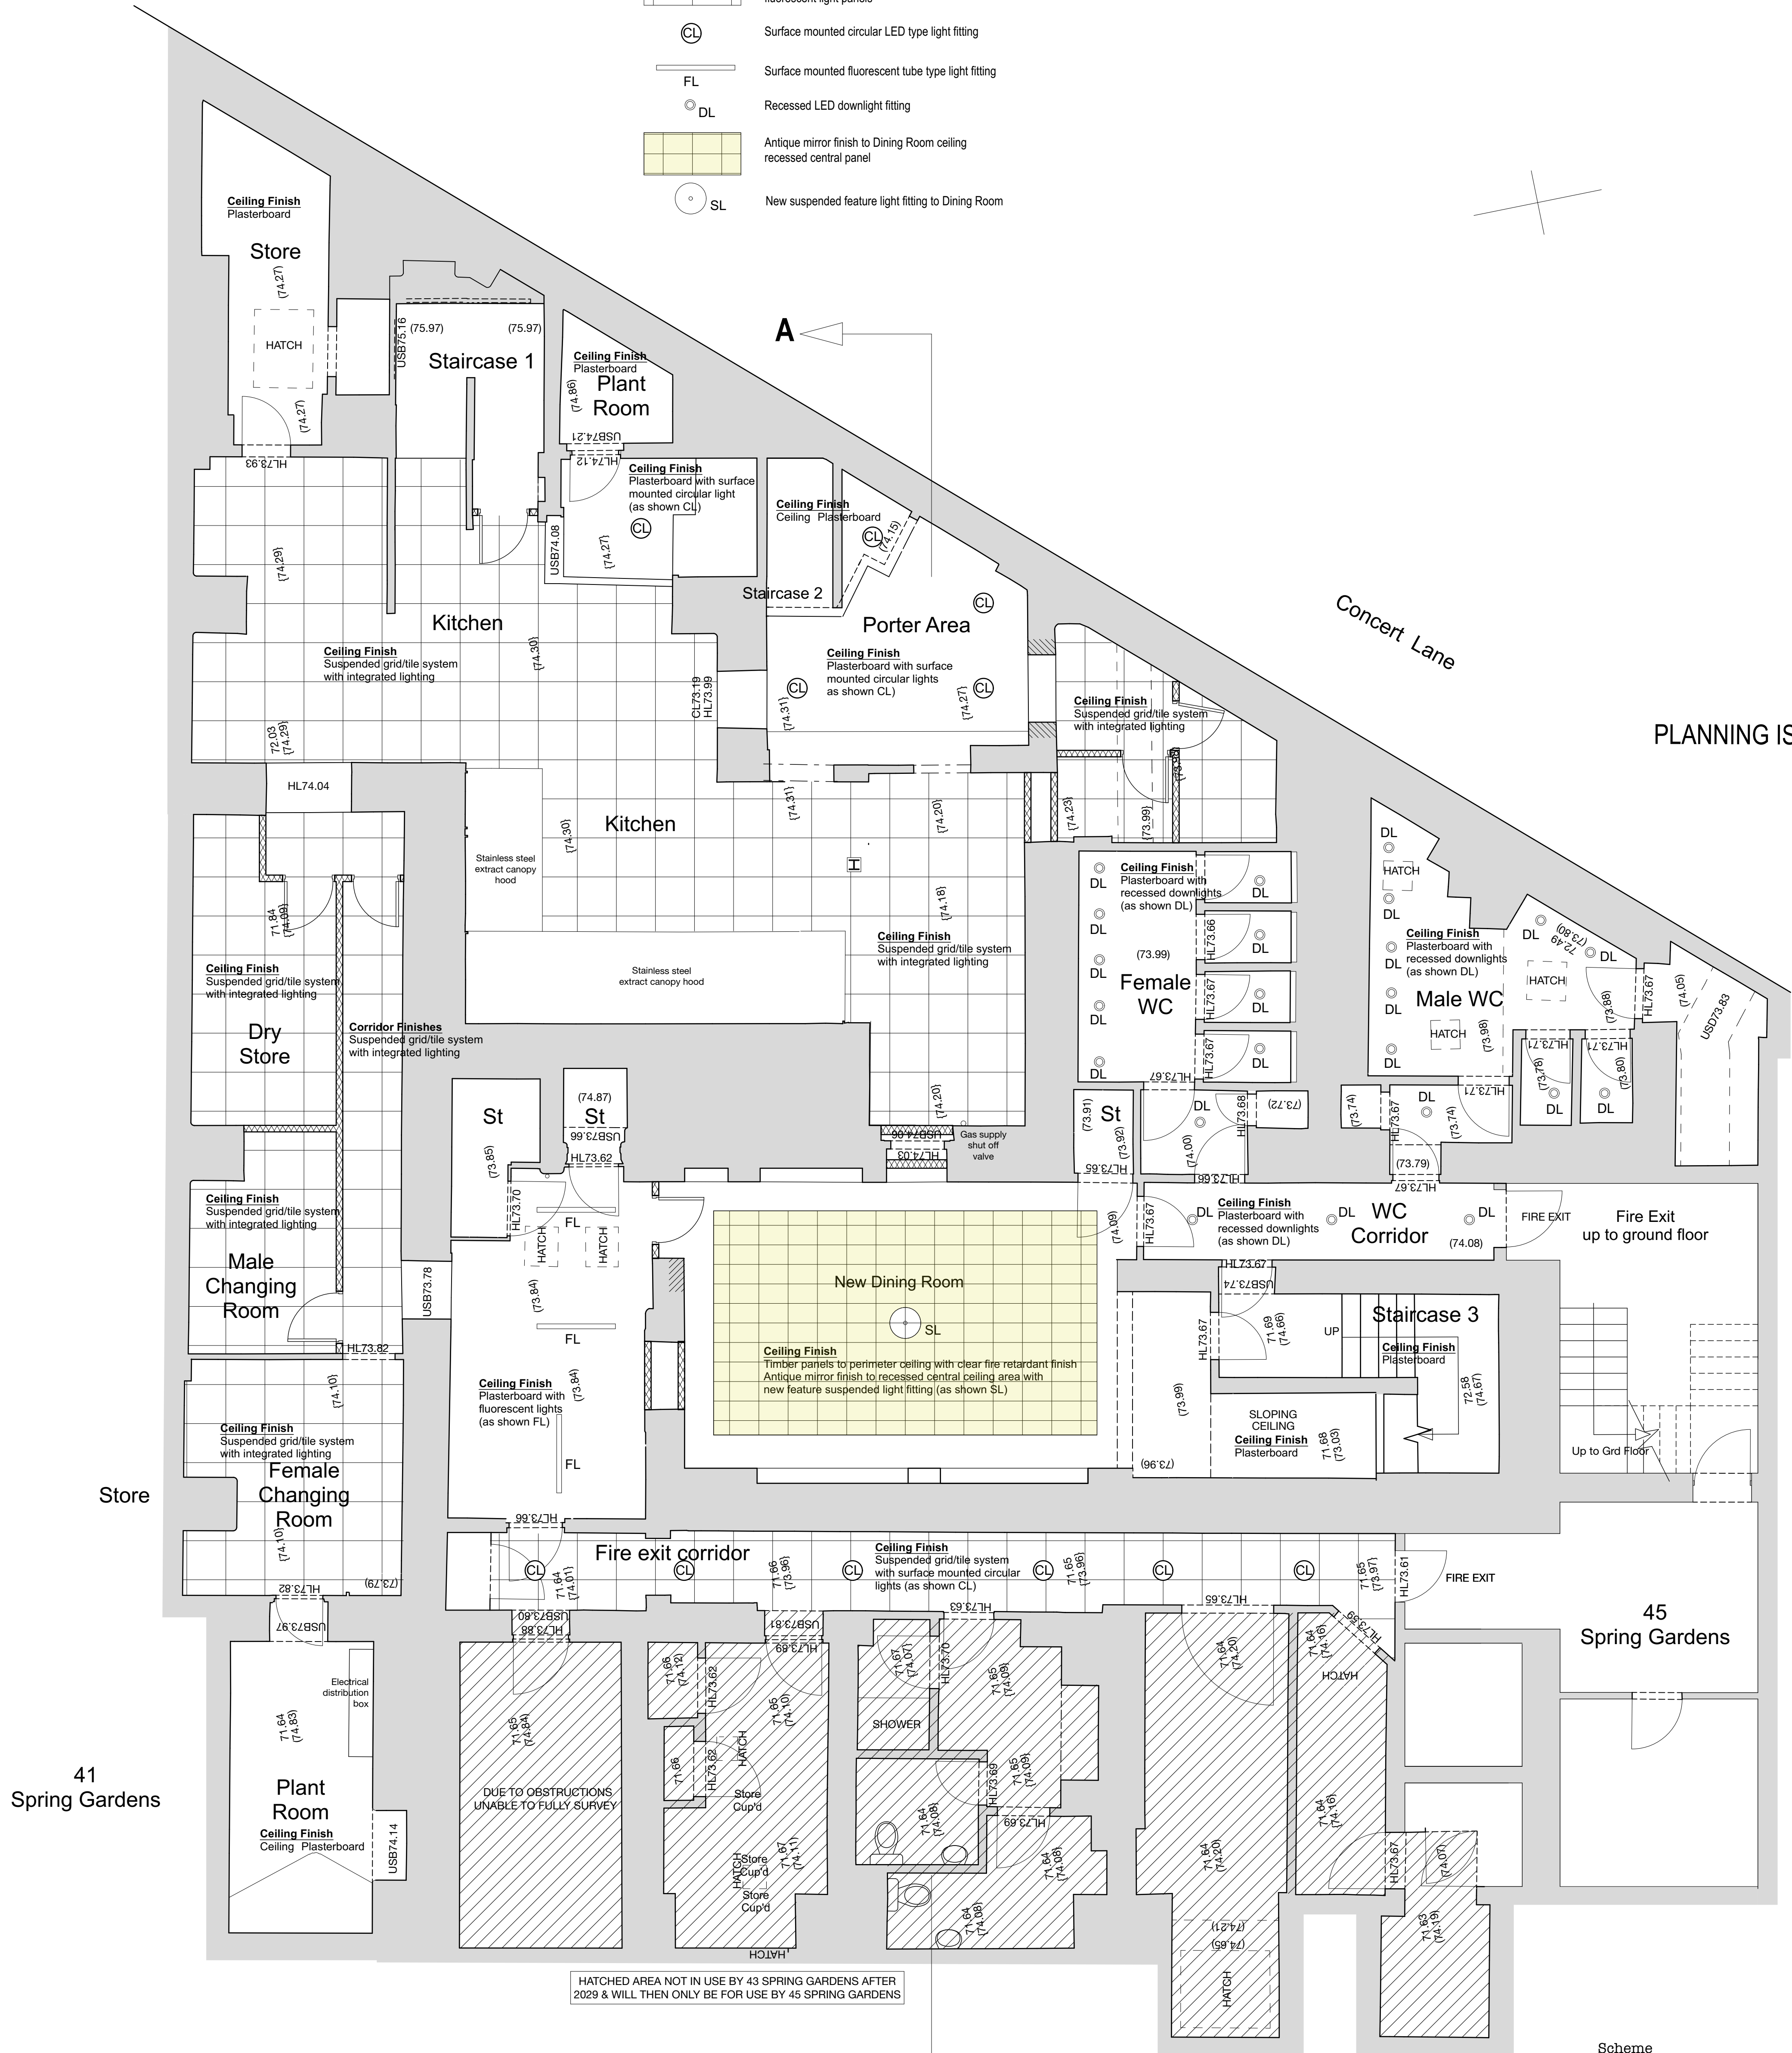

PLANNING ISSUE

45
Spring Gardens

Spring Gardens

Scheme
Fit Out & Alteration Works
Cibo Restaurant
Basement & Ground Floors
43 Spring Gardens
Manchester M2 2BG

Client
MRV Restaurant Group Ltd

Title
Proposed Basement
Reflected Ceiling Plan

Scale	Date	Drawn
1:50	12.2.24	MM
Job No	Dwg No	Rev
P390	22	

Mike Macpherson Architects
88 Reynard Road, Chorlton, Manchester M21 8DD

T: 0161 870 8129
E: mail@mikemacpherson-architects.co.uk
www.mikemacpherson-architects.co.uk

PROPOSED BASEMENT REFLECTED CELING PLAN 1:50@A1 (1:100@A3)