



FEEDER PILLAR REQUIRMENTS

NOTES

Copyright
This Drawing is the Copyright of Brian Mellor Associates
and must not be reproduced without their written consent

All dimensions must be verified on site by the Contractor
prior to preparation of Working Drawings
No dimensions to be scaled from this Drawing

1. THIS DRAWING SHALL BE READ IN CONJUNCTION WITH STUDIO DEKKA LIGHTING LAYOUT AND ARCHITECTS
DRAWINGS FOR DETAILS IN TERMS OF EQUIPMENT POSITIONS AND PROPOSED WORKS BY OTHERS.

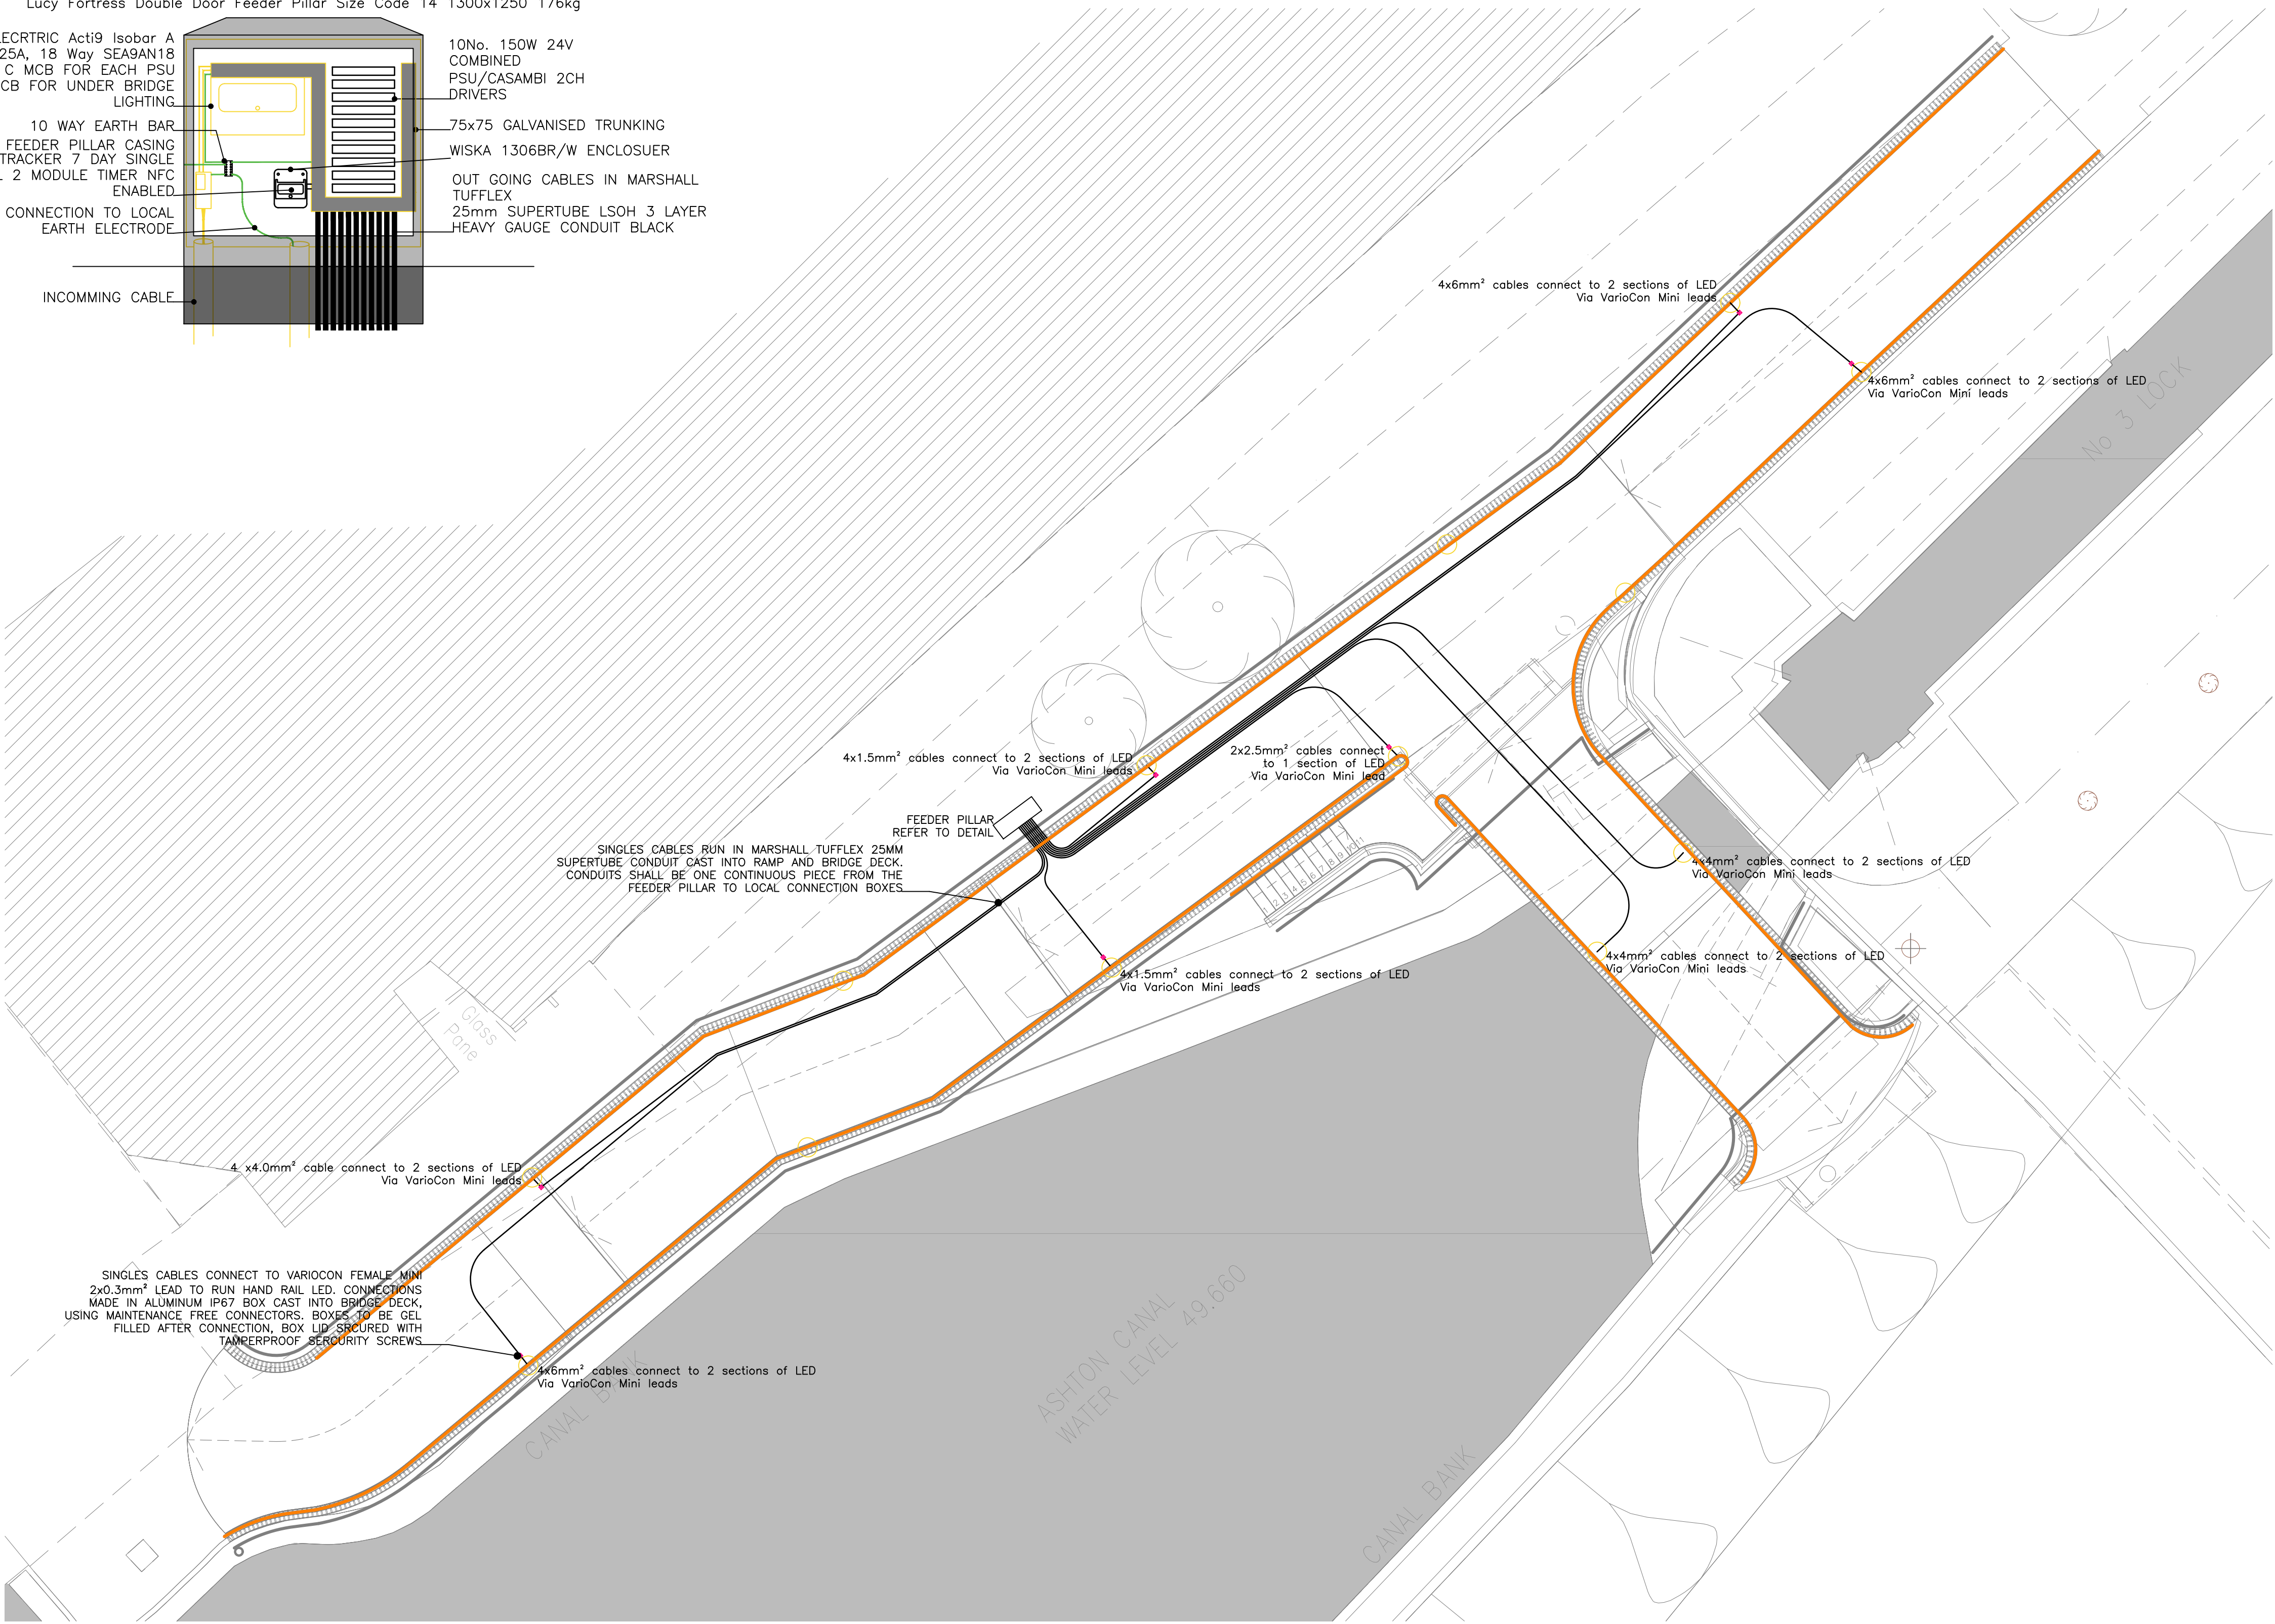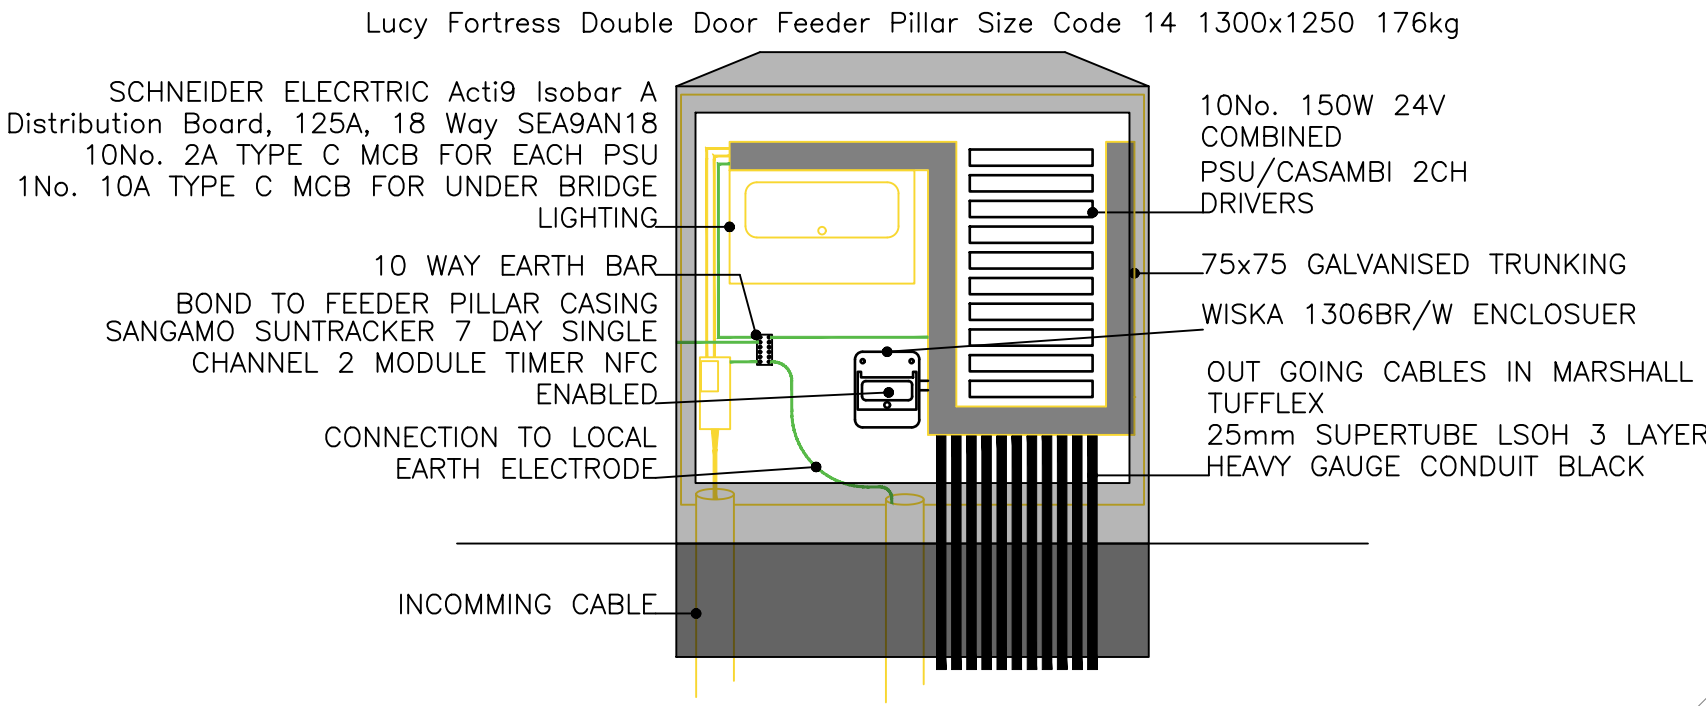

 Brian Mellor Associates CONSULTING ENGINEERS		2nd FLOOR BRITANNIC BUILDING 2 UPPER HEAD ROW HUDDERSFIELD HD1 2JL Tel: 01484 513973 Email: general@bmmellorasc.co.uk		PROJECT ISLINGTON CYCLE BRIDGE LOCK No.3 ASHTON CANAL MANCHESTER	
		TITLE ELECTRICAL REQUIRMENTS RAMP AND BIDGE LEVEL 1 of 2		Rev 2022-101/E/201 PO1	
Scale: 1:100 @ A1		Date: OCTOBER 2022		Drawing Issue Status ☐ PRELIMINARY ☒ TENDER ☐ CONSTRUCTION	
Drawn: GPR		Chkd:			