


DRAINAGE LONGITUDINAL SECTION
(1:100)

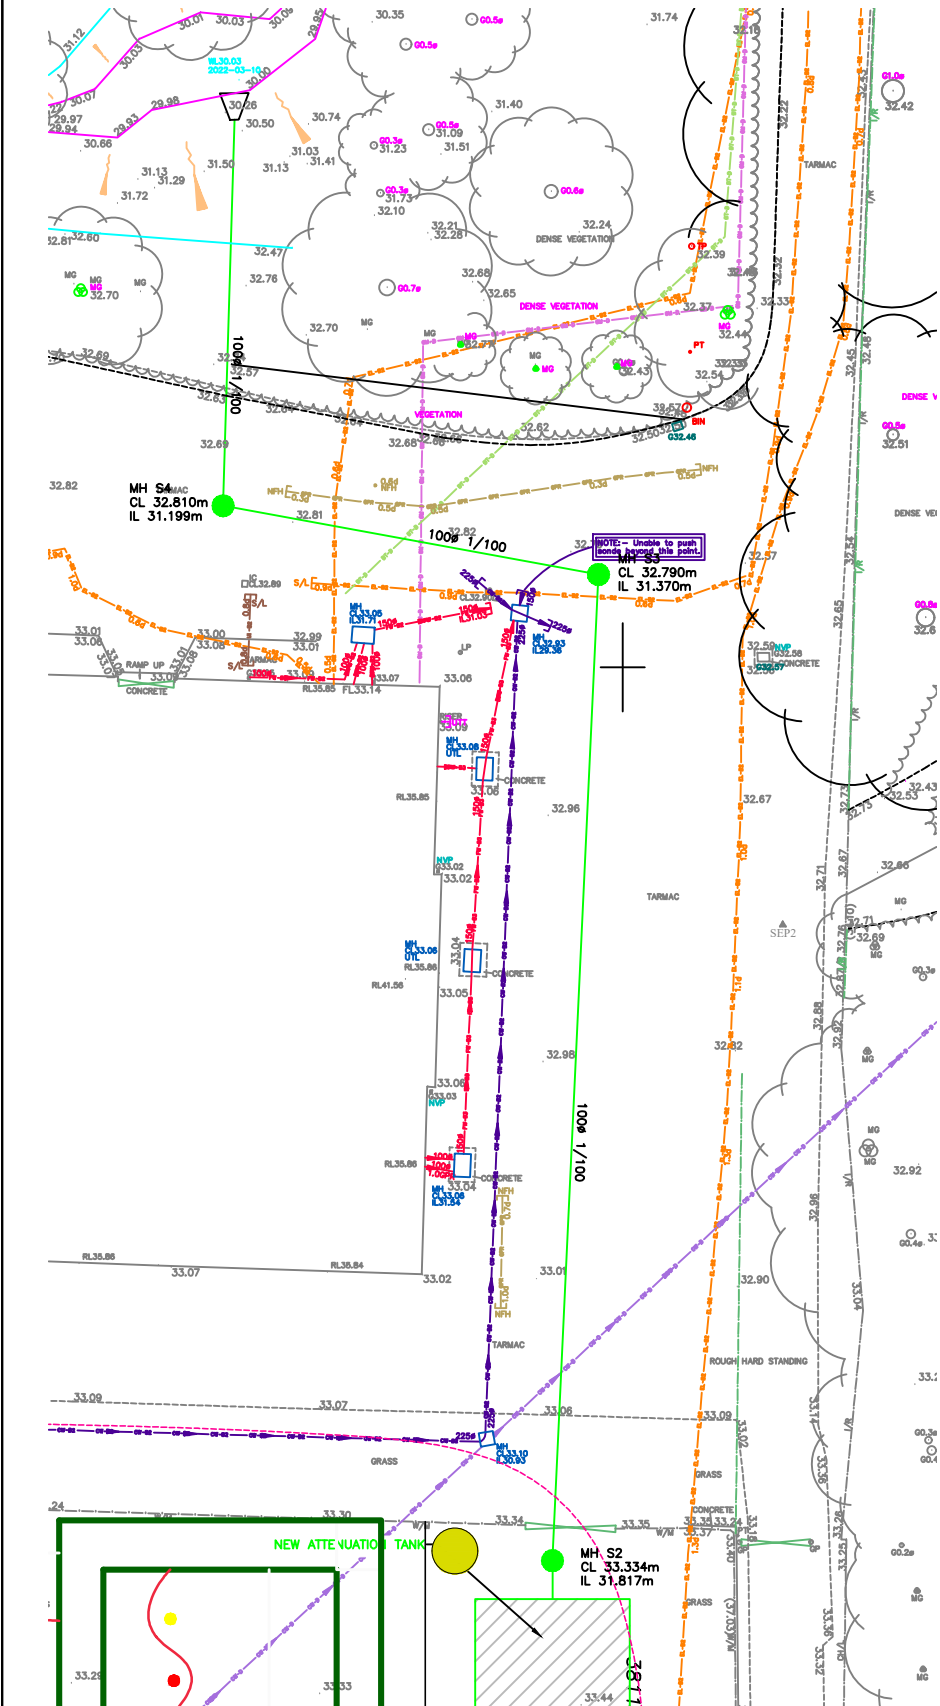

DRAINAGE PLAN
(1:125)

- NOTES:**
1. ALL DIMENSIONS ARE IN MILLIMETRES UNLESS NOTED OTHERWISE.
 2. THIS DRAWING IS TO BE READ IN CONJUNCTION WITH ALL OTHER RELEVANT DRAWINGS AND SPECIFICATIONS.
 3. ALL CONCRETE WORK AND MATERIALS TO BE IN ACCORDANCE WITH BS EN 1992, OR BS 8110-1:1997, BS 8500-2006 PT 1 & 2, BS EN206-1:2000
 4. PRIOR TO CASTING CHECK WITH ARCHITECTS DRAWING.
 5. CONCRETE COMPRESSIVE STRENGTH C30/37.
 6. ANY AMBIGUITIES, OMISSIONS AND ERRORS ON DRAWINGS, SHALL BE BROUGHT TO THE ENGINEERS ATTENTION IMMEDIATELY.
 7. THE CONTRACTOR SHALL CONFIRM THE LOCATION AND LEVEL OF EXISTING DRAINAGE PRIOR TO COMMENCEMENT OF THE DRAINAGE WORKS.
 8. EXACT LOCATIONS OF PROPOSED MANHOLES AND INSPECTION CHAMBERS TO BE DETERMINED ON SITE.
 9. THE CONTRACTOR SHALL CONFIRM THE LOCATION OF ALL EXISTING STATUTORY UNDERTAKERS APPARATUS AND SERVICE CONNECTIONS BY TRAILING PRIOR TO OPENING UP FOR THE WORKS.
 10. ALL WORKS TO BE UNDERTAKEN IN ACCORDANCE WITH SEWERS FOR ADOPTION 7TH EDITION.

REFERENCE DRAWINGS:

S22720-01-03 - UTILITY SURVEY SHEET 1-3 - BY SURVEY & ENGINEERING PROJECTS

LEGEND

[illegible]

A	ISSUED FOR AS BUILT	JKT	PKD	A
A	ISSUED FOR CONSTRUCTION	JKT	PKD	A
P1	ISSUED FOR DISCUSSION	JKT	PKD	M
Rev	Description	Drawn	Chkd	

Sir Frederick Snow & Partners Ltd
Consulting Engineers



211 - 213 Higher Hillgate
Stockport
Cheshire
SK1 3RB

Tel: 0161 477 3365
e-mail: northwest@fsnow.co.uk

Client
MANCHESTER CITY COUNCIL

Project Title
WYTHENSHAW PARK - BIKE PARK

Drawing Title
PUMP TRACK AREA DRAINAGE OUTLET

Scale(s)	(Do not scale off this drawing)
1:125	work to figured dimensions)

Scalebar Original Drawing Size A0
0 10 50 100mm