


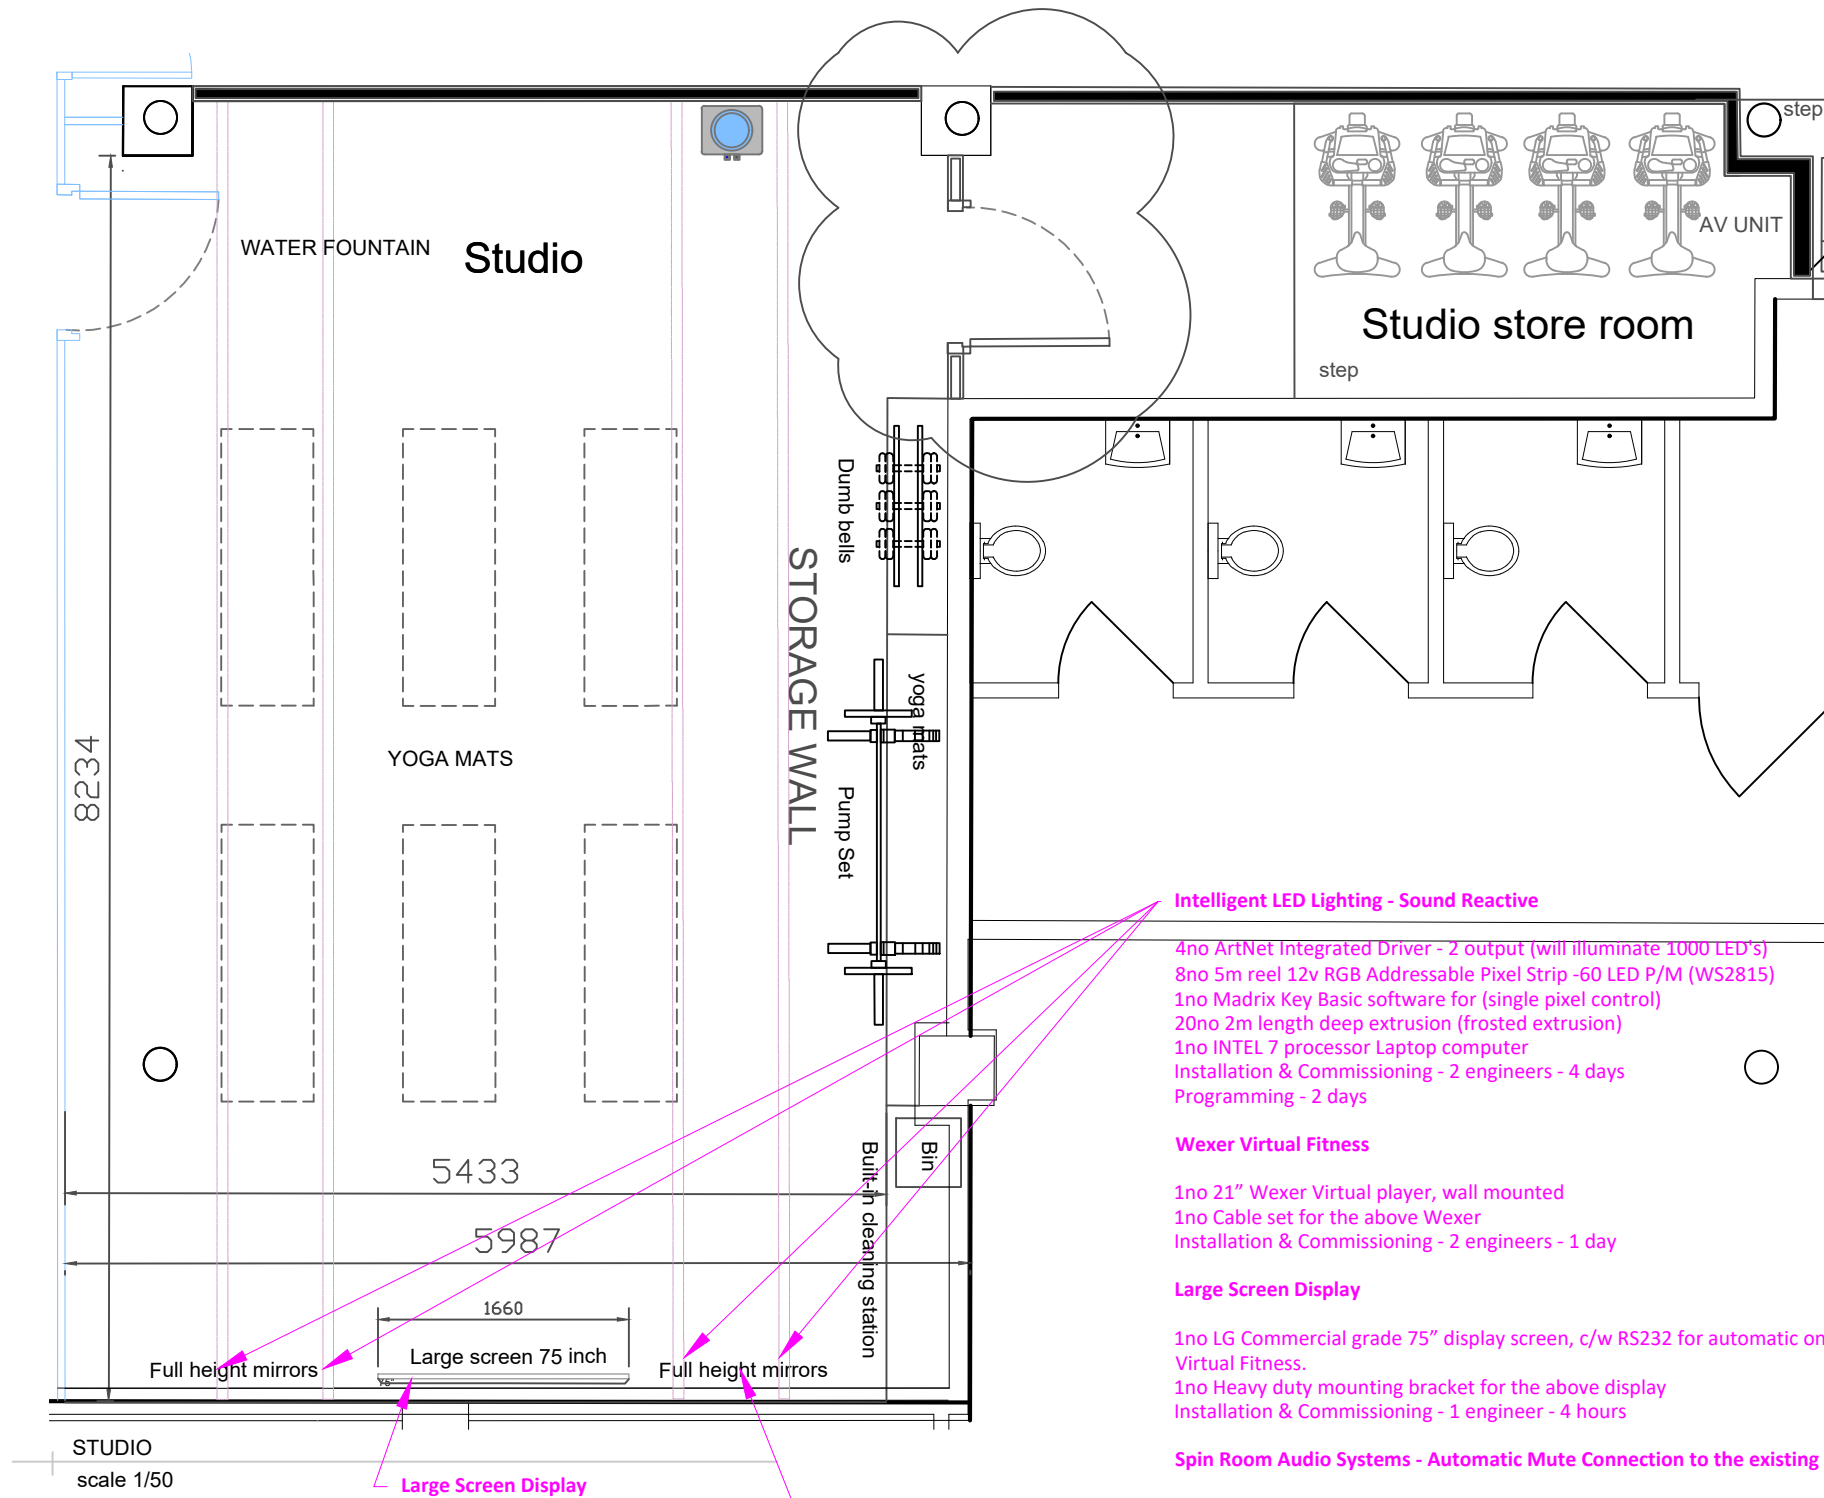

Intelligent LED Lighting - Sound Reactive

4no ArtNet Integrated Driver - 2 output (will illuminate 1000 LED's)
8no 5m reel 12v RGB Addressable Pixel Strip -60 LED P/M (WS2815)
1no Madrix Key Basic software for (single pixel control)
20no 2m length deep extrusion (frosted extrusion)
1no INTEL 7 processor Laptop computer
Installation & Commissioning - 2 engineers - 4 days
Programming - 2 days

Wexer Virtual Fitness

1no 21" Wexer Virtual player, wall mounted
1no Cable set for the above Wexer
Installation & Commissioning - 2 engineers - 1 day

Large Screen Display

1no LG Commercial grade 75" display screen, c/w RS232 for automatic on/off when used with the Wexer Virtual Fitness.
1no Heavy duty mounting bracket for the above display
Installation & Commissioning - 1 engineer - 4 hours

Spin Room Audio Systems - Automatic Mute Connection to the existing Fire Alarm System

4no JBL Control pendant speakers
1no 12U Wall mounted lockable equipment rack c/w 1U; 2U & 3U Rack shelves, 6 way power bar & rack screws
1no QSC Amplifier with relay connection to the existing fire alarm
1no Cable set
Installation & commissioning - 2 engineers - 3

Please note, we will have to liaise with the mirror manufacturer to ensure the depth and spacing between each mirror is correct, so that we can flush mount the intelligent lighting correctly.

Smoked mirror

E	STEP INSIDE STUDIO STORE ROOM ADDED	11/01/23	RG
D	DOOR TO STUDIO ADDED BACK IN	09/11/23	RG
C	UPDATED PLAN	01/11/23	RG
B	UPDATED PLAN	26/10/23	RG
A	Added water fountain removed studio door due to fire regs	15/10/23	RG

-	First issue	21/09/23	RG
---	-------------	----------	----

REV	DESCRIPTION	DATE	BY	CHK
-----	-------------	------	----	-----

CLIENT NAME

Philip J Davies Holdings plc

PROJECT NAME

Sevendale House

DWG TITLE:

Lower Ground - Proposed GA - STUDIO

DWG NO: 10_- 002 REVISION: -

SCALE 1 : 200 @A3 DRAWN: RG

DWG STATUS:

TENDER