



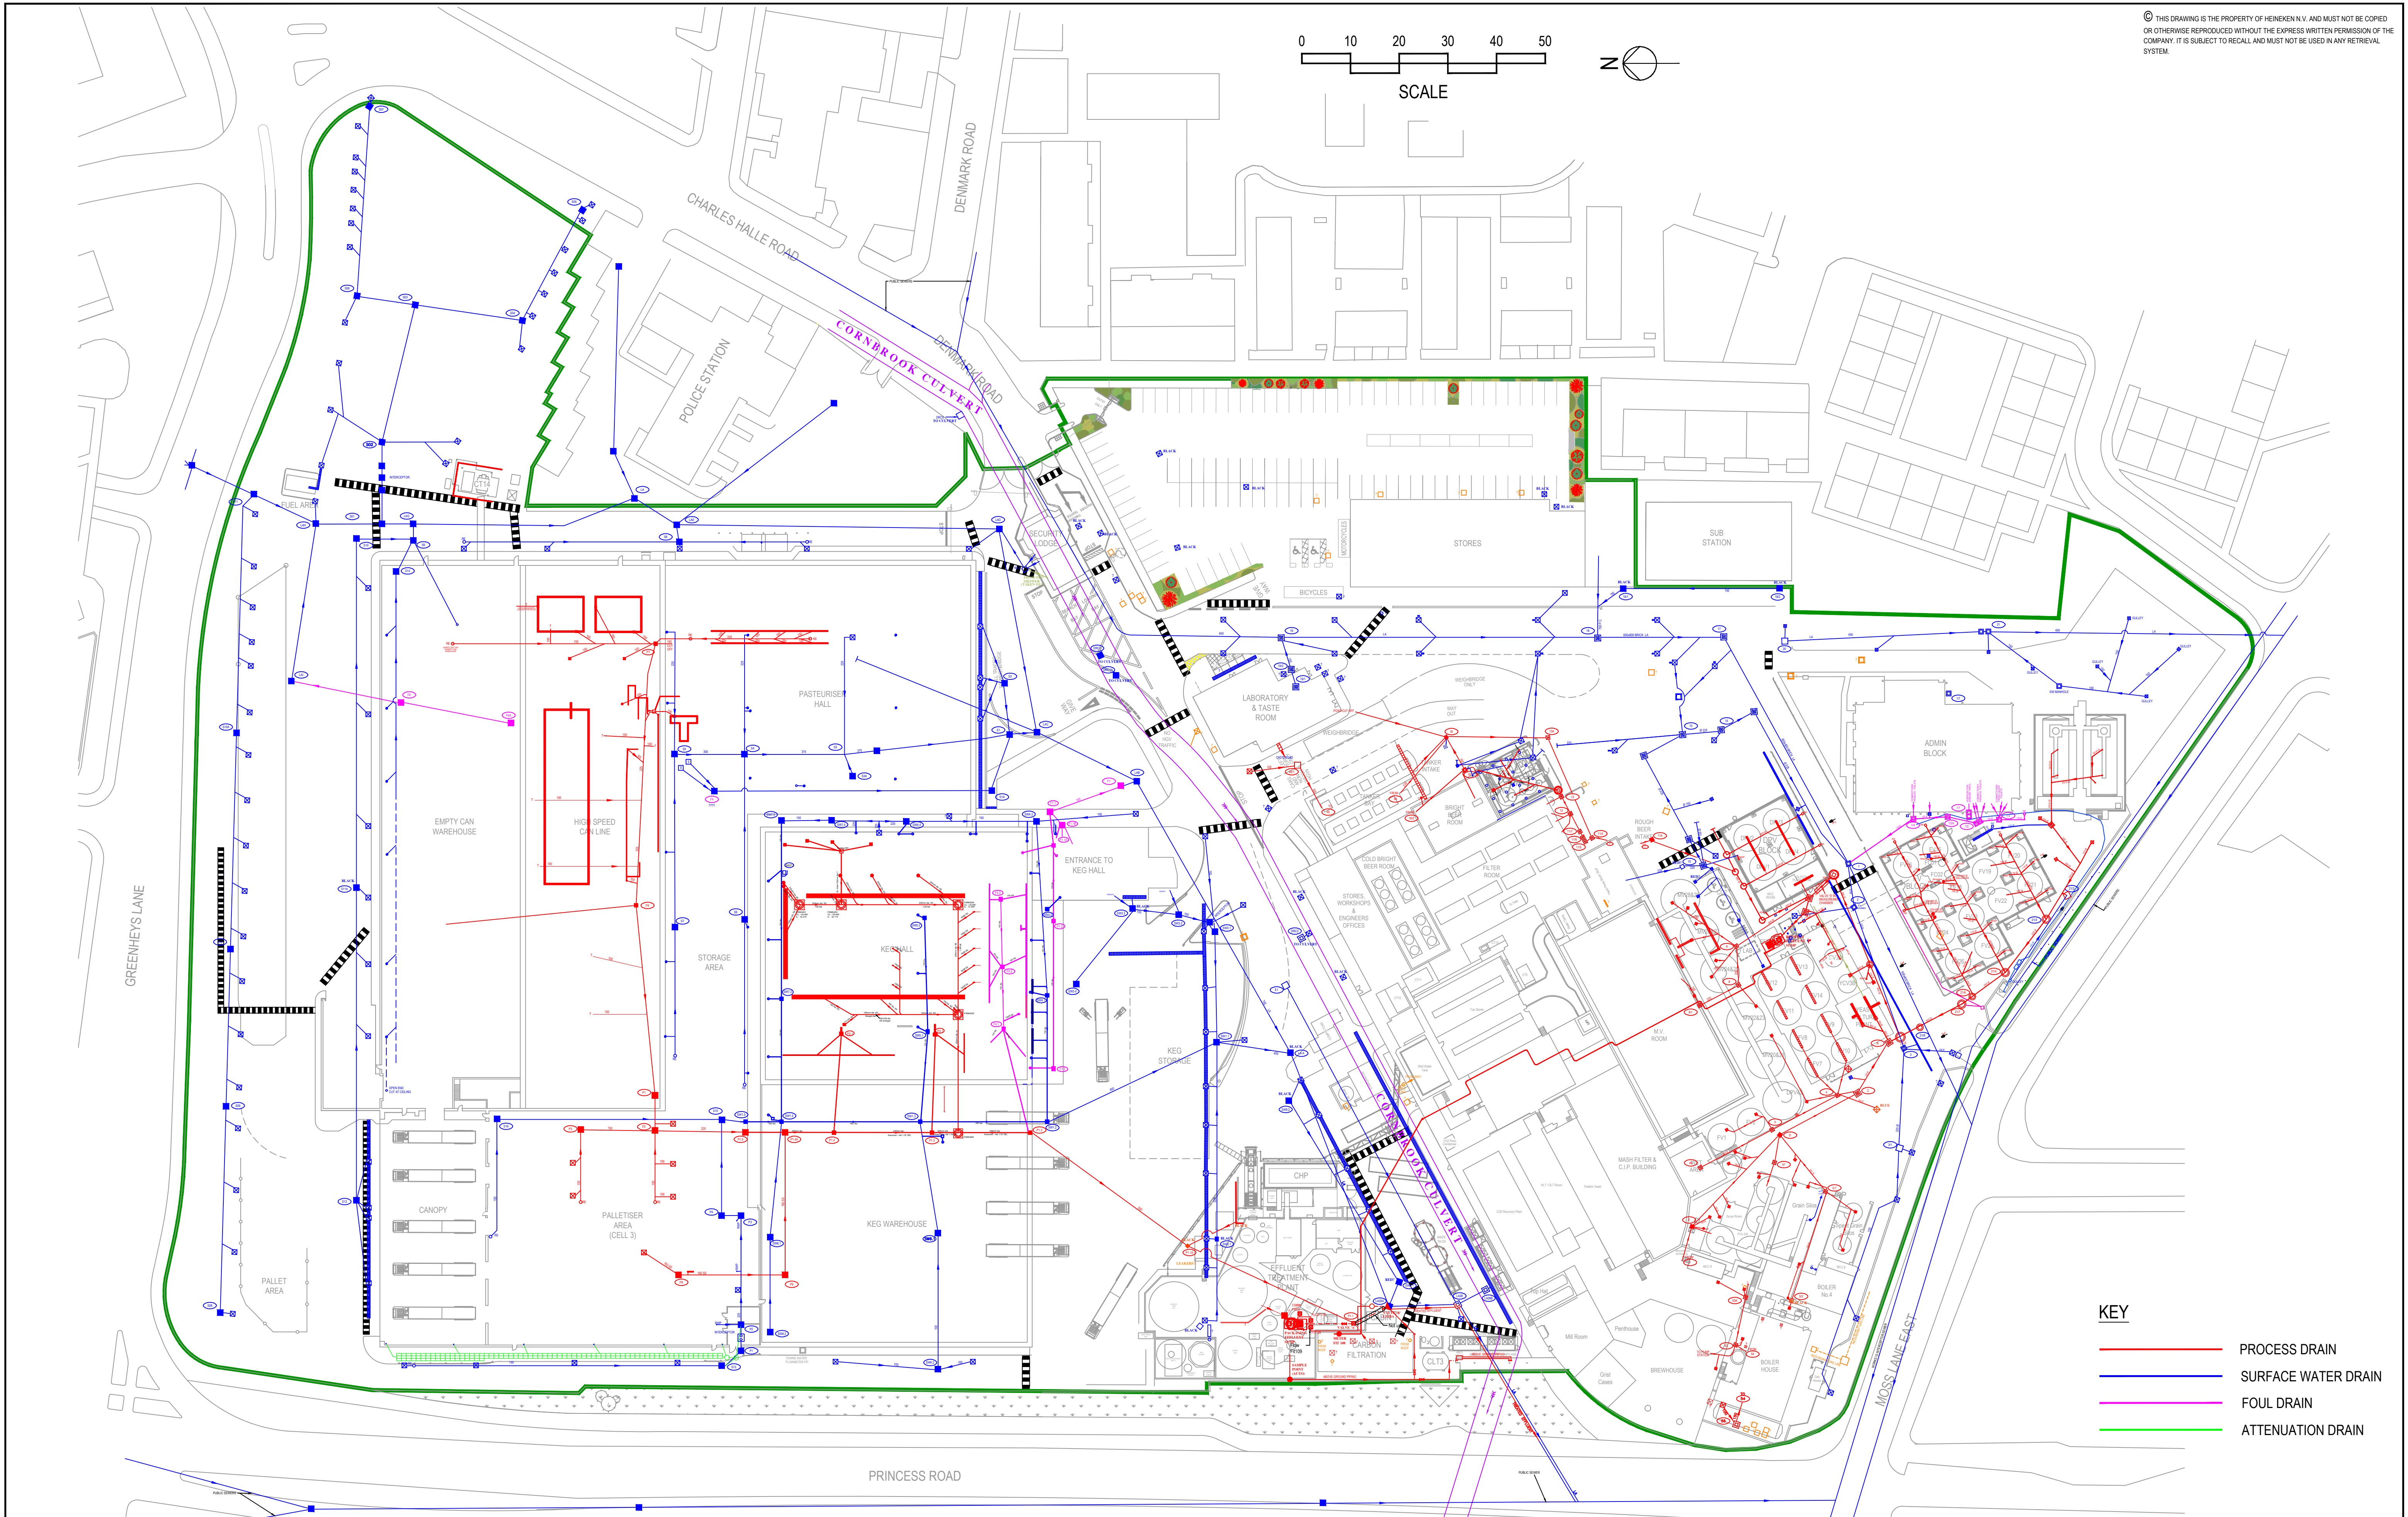

KEY

- PROCESS DRAIN
- SURFACE WATER DRAIN
- FOUL DRAIN
- ATTENUATION DRAIN

U	18/01/01	SPB	DRY 1 - BLOCK & REVEAL DRAINAGE ADDED.
U	15/12/00	SPB	ETP OUTLET PIPE & SAMPLE POINT SHOWN.
T	28/06/00	DJ	UPDATES TO DRAINS AROUND THE PALLETISER AREA & ATTENUATION DRAIN INSTALLED.
S	27/04/18	SPB	UPDATES TO DRAINS AROUND NEW FV BLOCK, HORAP TANKS AND NEW YEAST CULTURE PLANT.
P	13/02/16	AP	UPDATED FURTHER TO SURVEY.
P	18/05/15	AP	UPDATED FURTHER TO SITE LAYOUT CHANGES.
N	28/07/14	AP	FOUL DRAINS LAYER COLOUR CHANGE.
N	28/05/14	AP	CHIMNEY LINE UPDATES.
L	26/06/12	AP	SITE PLAN UPDATED, HOWELL'S DEMOLISHED.
K	28/09/10	AP	BRICK SUMP P1.1 POSITION CORRECTED.
REV	DATE	DRN	DESCRIPTION

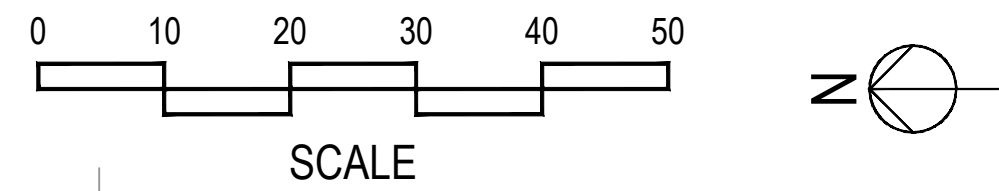

Heineken UK Limited
Manchester Brewery
201 Denmark Road, Manchester, M15 6LD
Tel: 0161 226 4371

LOCATION	MANCHESTER BREWERY
PROJECT	DRAINAGE MASTER DRAWING

DRAWN BY:	BR
DATE:	07/01/99
APPROVED BY:	
DATE:	

TITLE	DRAINAGE SITE PLAN
-------	-----------------------

DRAWING No.:	87-001 Sheet 2
STATUS	AS BUILT

REV:	V
SCALE @ A1:	1:600