
 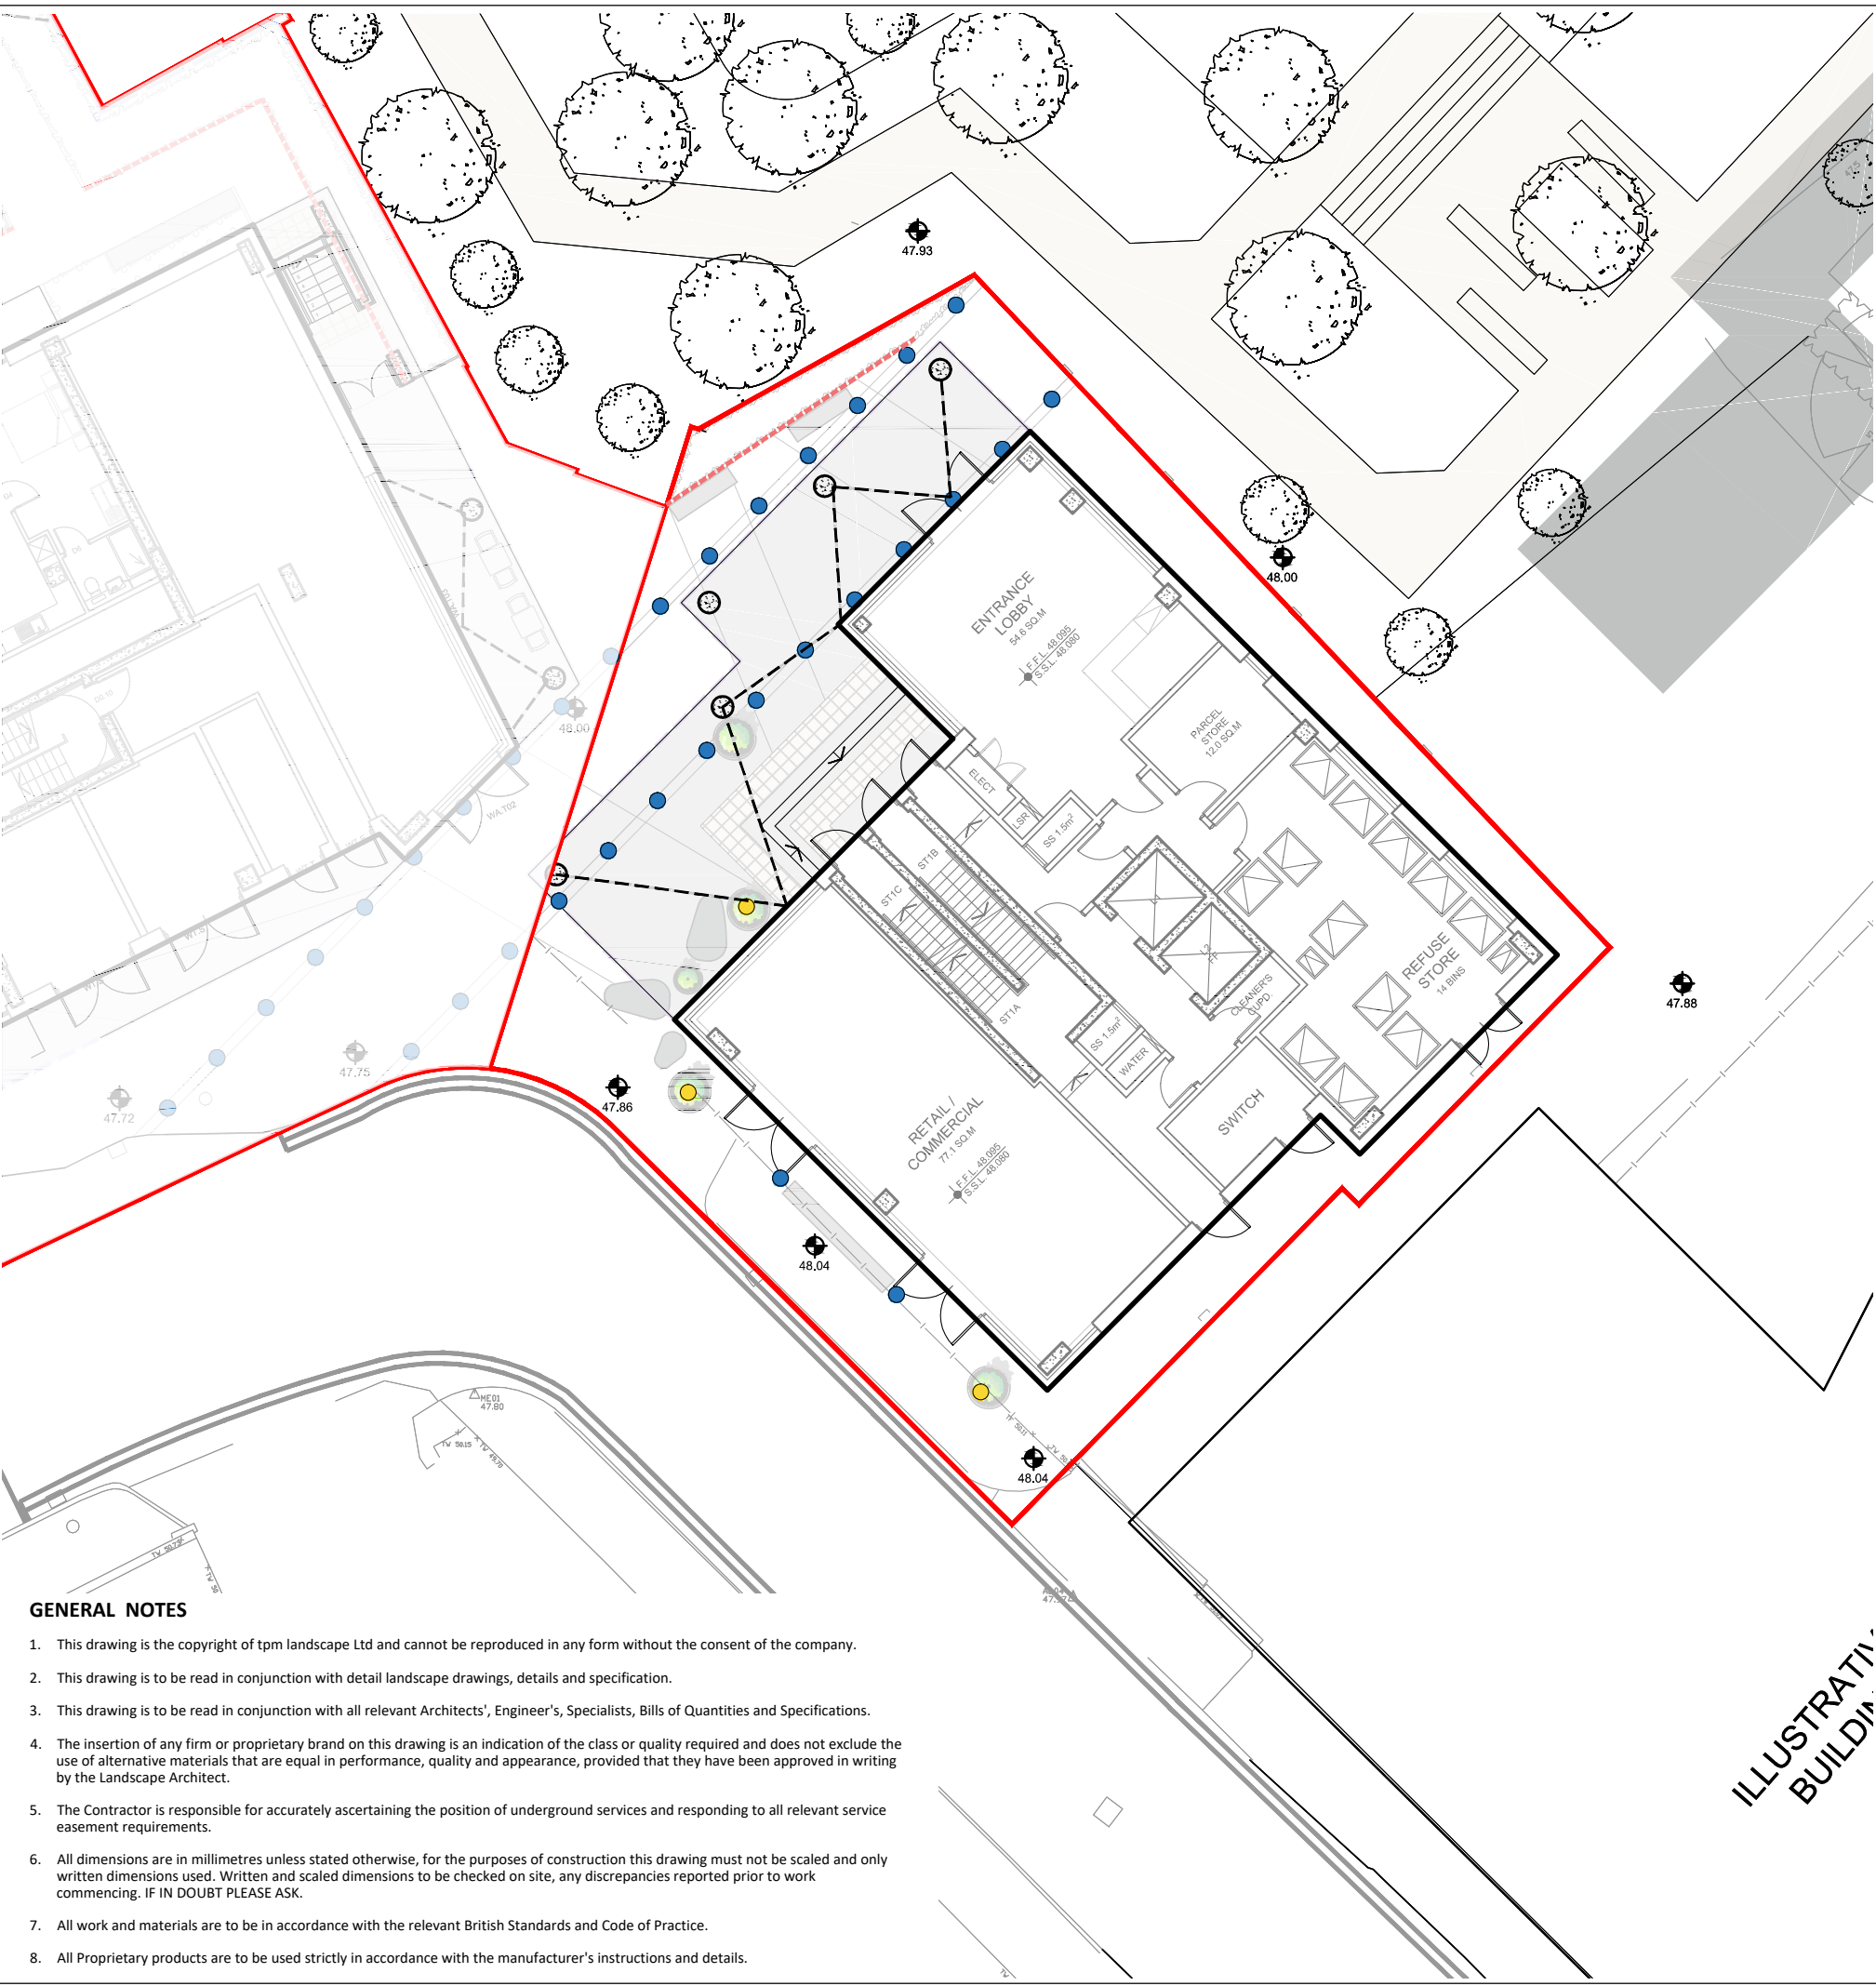
 
 
 




GENERAL NOTES

1. This drawing is the copyright of tpm landscape Ltd and cannot be reproduced in any form without the consent of the company.
2. This drawing is to be read in conjunction with detail landscape drawings, details and specification.
3. This drawing is to be read in conjunction with all relevant Architects', Engineer's, Specialists, Bills of Quantities and Specifications.
4. The insertion of any firm or proprietary brand on this drawing is an indication of the class or quality required and does not exclude the use of alternative materials that are equal in performance, quality and appearance, provided that they have been approved in writing by the Landscape Architect.
5. The Contractor is responsible for accurately ascertaining the position of underground services and responding to all relevant service easement requirements.
6. All dimensions are in millimetres unless stated otherwise, for the purposes of construction this drawing must not be scaled and only written dimensions used. Written and scaled dimensions to be checked on site, any discrepancies reported prior to work commencing. IF IN DOUBT PLEASE ASK.
7. All work and materials are to be in accordance with the relevant British Standards and Code of Practice.
8. All Proprietary products are to be used strictly in accordance with the manufacturer's instructions and details.

LEGEND
LIGHTING

-  **Proposed Uplighters to Trees**
SL030, 1W LED spike light
As supplied by Collingwood Lighting or similar approve
-  **Proposed Uplighters to Paths**
GL019, 1W mini LED ground light
As supplied by Collingwood Lighting or similar approv
-  **Proposed String Lights**
Catenary Lights
As supplied by StudioTech or similar approved
-  **Proposed Linear Lights**
VarioLED™ OCEANOS IP67
As supplied by LedLinear or similar approved

REVISION NOTES

Rev	By	Description	Date
A	MC	Updated in line with new architect's layout	06.09.23

Client	Axis-Re						
Project	Tariff Street, Manchester						
Description	Lighting Plan						
Status	For Approval						
Scale @ A3	1:200	Drawn	MC	Checked	CT	Date	19.06.23
Job number	4267	Drawing number	108	Revision	A		