


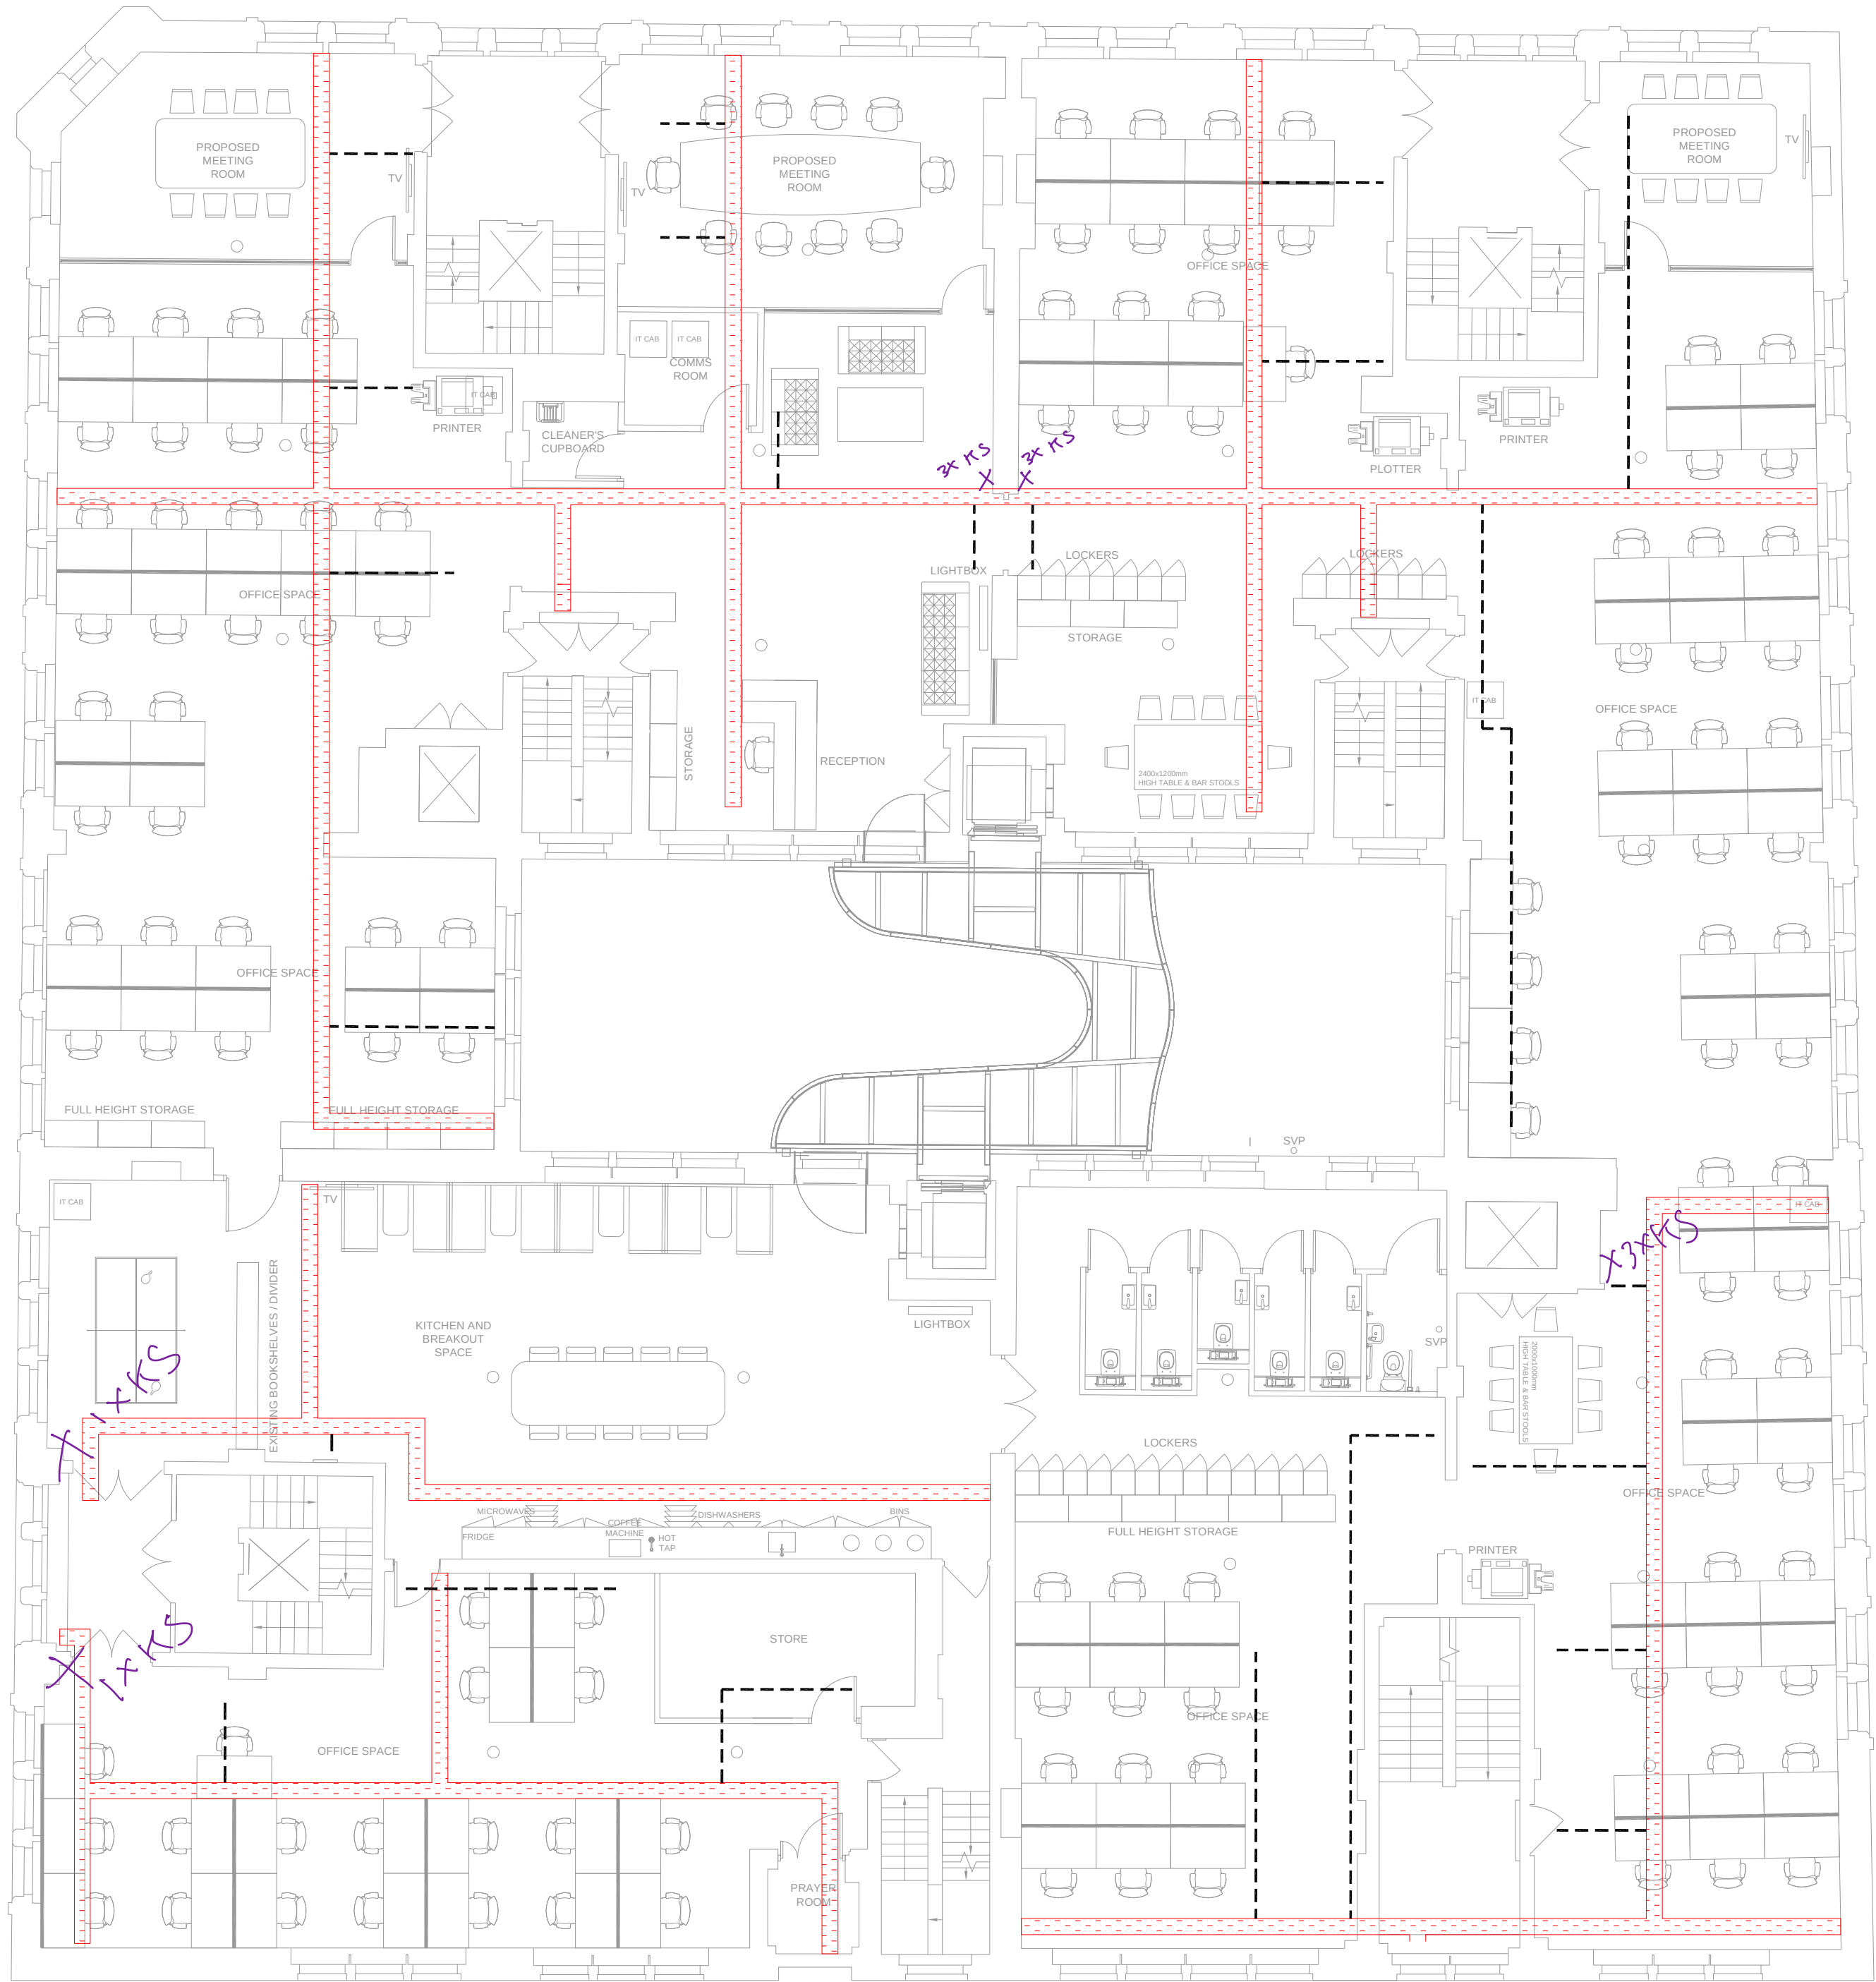

General Notes:

1. This drawing shall be read in conjunction with all general conditions, performance specifications and landlord requirements.
2. This drawing shall be read in conjunction with all associated specialist service drawings, architects, and structural drawings.
3. All equipment selections are indicative, and the contractor shall be responsible for all final calculations and equipment sizing and selection.
4. The project is to be a flush mounted installation throughout except for any plant room which can be surface mounted.
5. This drawing was produced in AutoCAD, DO NOT scale from this drawing. contractor must verify all dimensions on site.
6. All wall and ceiling penetrations for services to be sealed in compliance with fire regulations and building control requirements.

LEGEND

- 300mm GALVANISED TRAY C/W DIVIDER
- 20mm GALVANISED CONDUIT FOR LIGHTING

NOTES:

1. ELECTRICAL CONTRACTOR TO INCLUDE FIXINGS AT SPACING AS REQUIRED BY MANUFACTURERS RECOMMENDATIONS.
2. CONTRACTOR TO INCLUDE FOR ALL SECONDARY CONTAINMENT FOR ALL ELECTRICAL SERVICES.
3. CONTRACTOR TO INCLUDE FOR ALL SECONDARY CONTAINMENT REQUIRED BY SPECIALIST SUB CONTRACTORS FOR ELV SERVICE. CONTRACTOR TO INCLUDE TO LIAISE WITH SUB CONTRACTOR TO ENSURE A COMPLETE INSTALLATION.
4. CONTRACTOR TO INCLUDE TO PROVIDE ALL NECESSARY CONTAINMENT TO RISE BETWEEN FLOORS AND TO ROOF PLANT AREA TO ENSURE A COMPLETE FUNCTION INSTALLATION.
5. LV & ELV SERVICES TO BE KEPT A MINIMUM 200MM SEPARATION WHEN ROUTED TOGETHER.
6. CONTAINMENT SUSPENDED USING GRIPPLE PRODUCTS
7. PRIMARY CONTAINMENT ONLY. SECONDARY CONTAINMENT REQUIRED AND TO BE COORDINATED AT SITE LEVEL.

Revisions

Rev.	Date	Init.	Description

Client
Fourways

Job Title
Fourways

Drawing Title
Containment Layout

Scale 1 : 100 A1 Drawn by JF

Date 08/04/2024 Checked JM

Status Stage 4

Dwg. No.
002-E-03

Rev.