



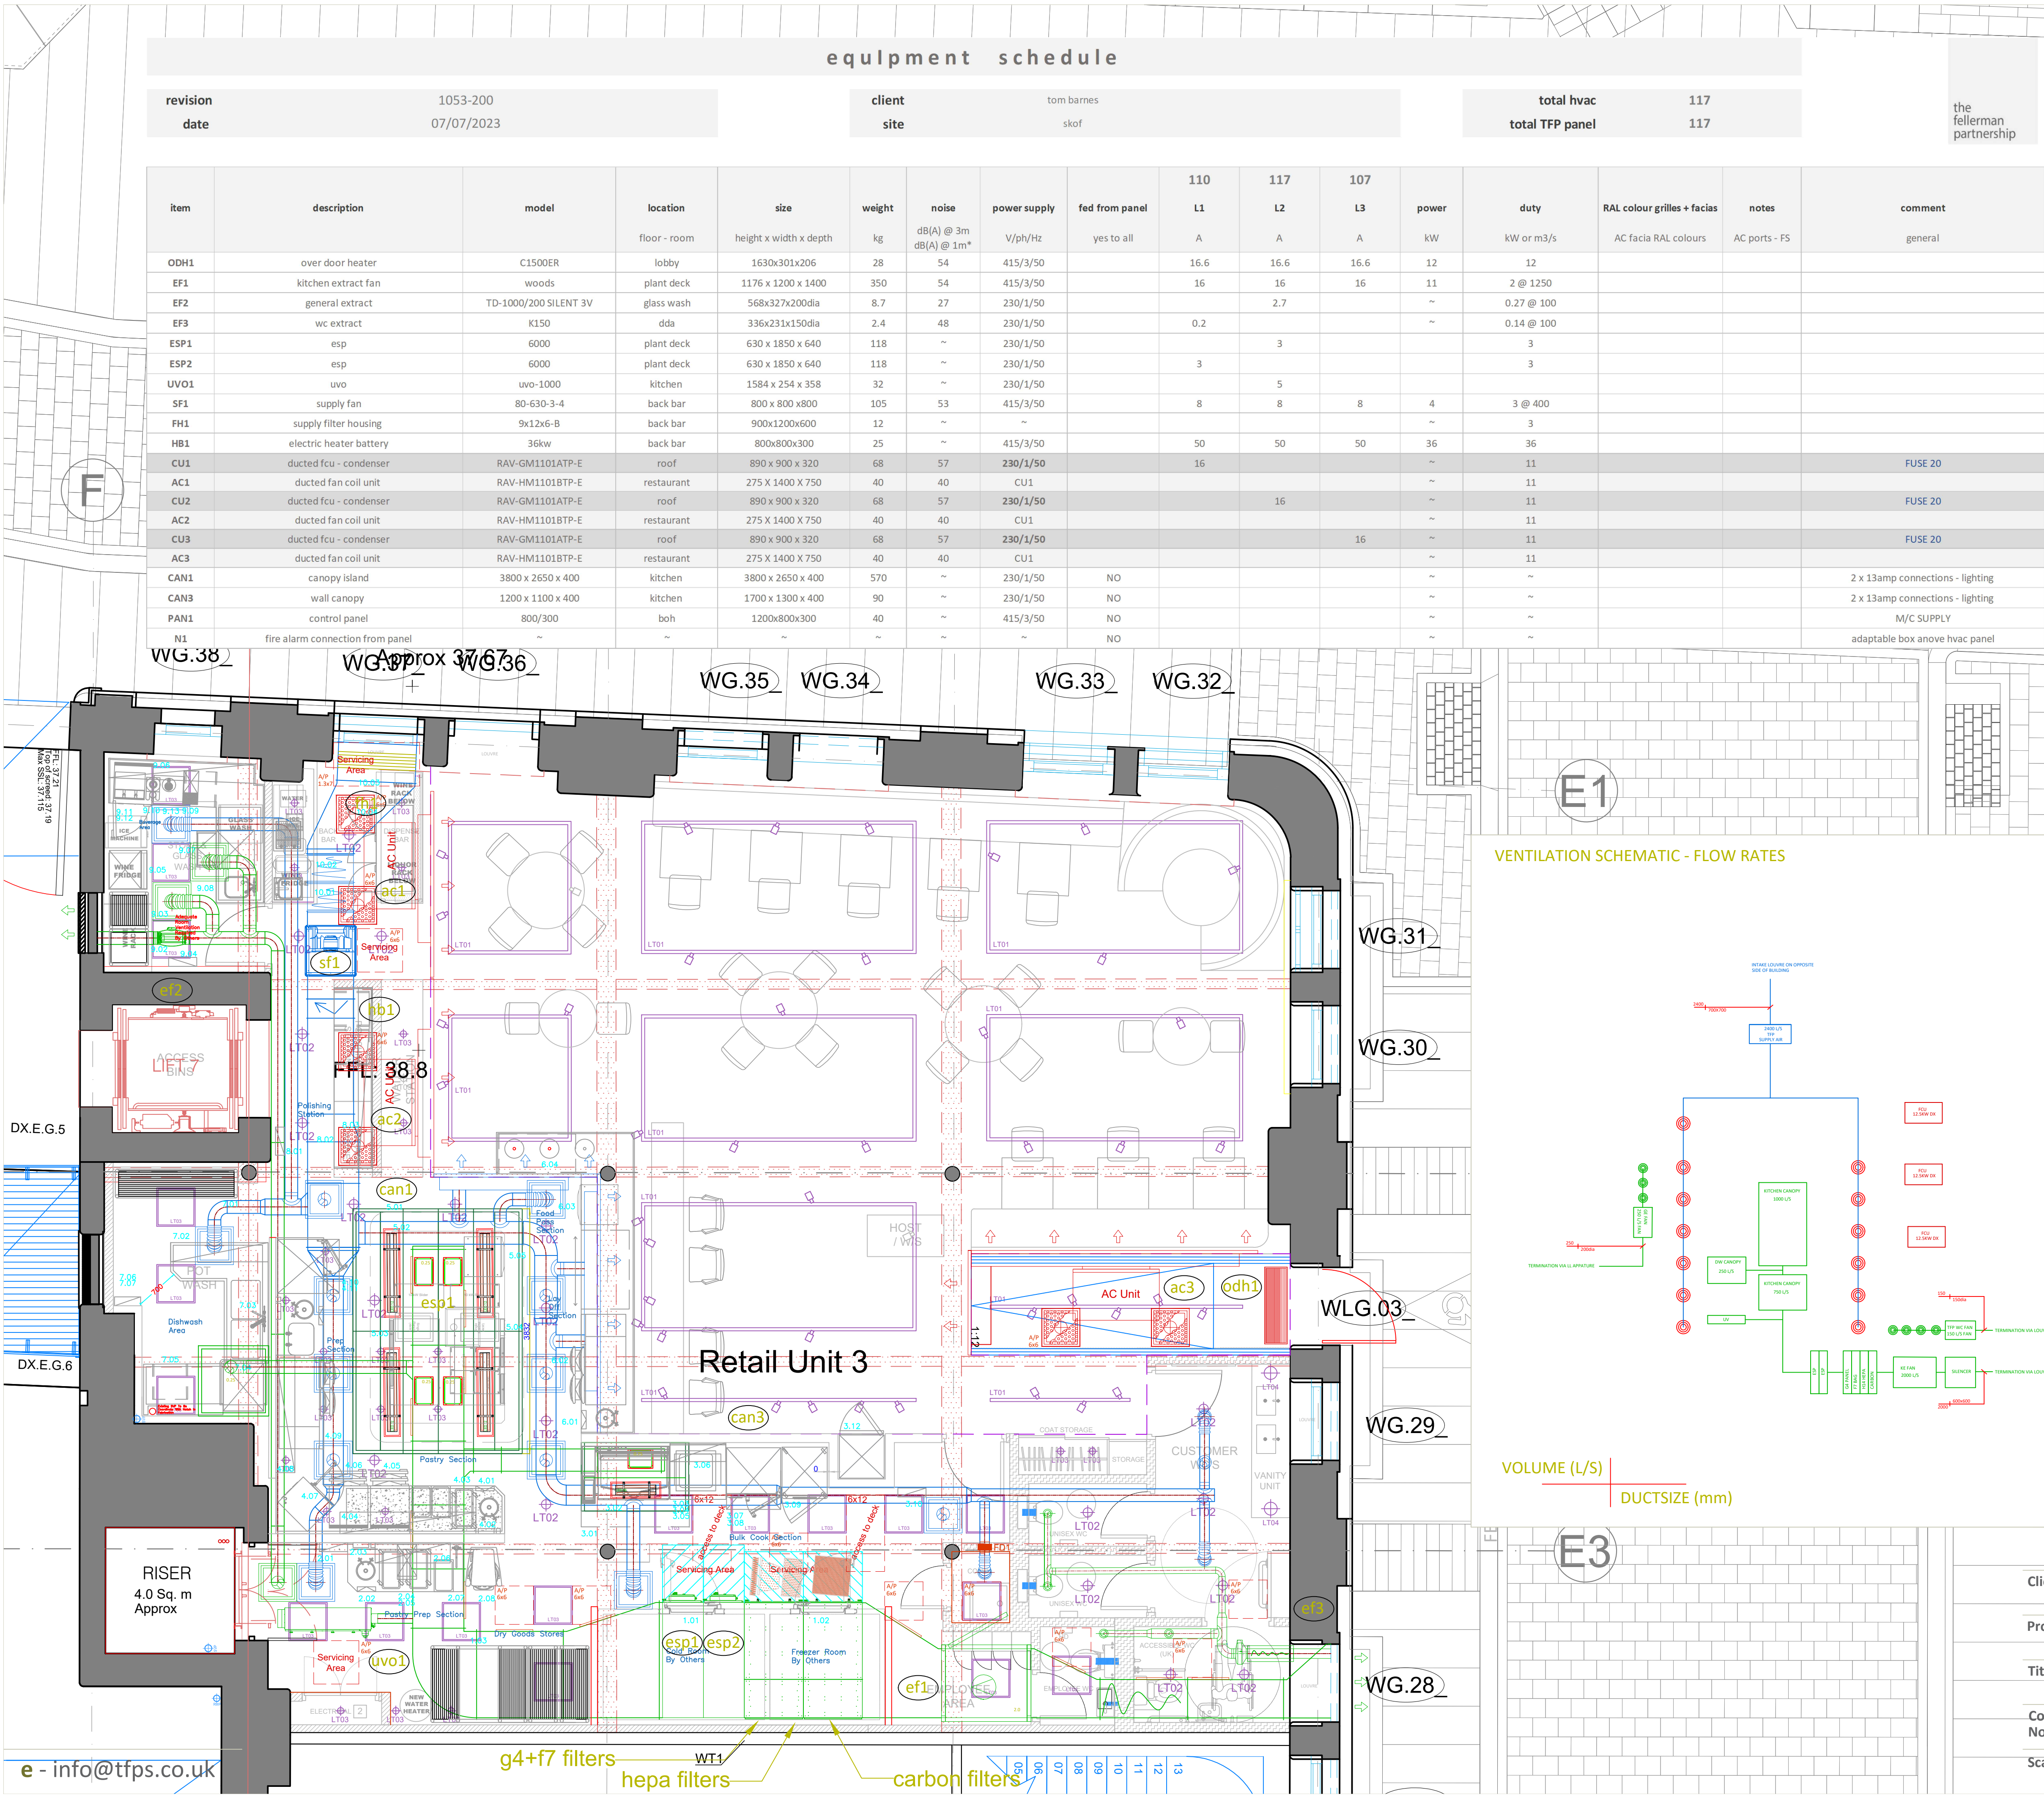

Specific Extract Flow Rate Calculation Sheet										Based on the THERMAL CORRECTION METHOD as recommended in HVCA Specification DW12:2019									
Floor Level:					From:					Tom Barnes					the fellerman partnership				
Area:					Job No.:					1053-201									
Canopy / Ceiling Ref:					Client Org No.:					#									
Canopy Type:					Date:					09/07/2024									
					Assessed By:					EF									
Item	Cooking Equipment	Power	Plan Size		Area (m²)	DW12:2019 Method		Flow Rate (m³/s)			Flow Rate (m³/s)			Flow Rate (m³/s)			Flow Rate (m³/s)		
			X(m)	Y(m)		TCC (m³/s/m²)	Flow Rate (m³/s)												
	Induction Griddle, Electric	Electric	0.77	0.36	0.2772	0.27	0.07												
	Induction Griddle, Electric	Electric	0.77	0.36	0.2772	0.27	0.07												
	Induction Griddle, Electric	Electric	0.44	0.40	0.176	0.27	0.07												
	Induction Griddle, Electric	Electric	0.44	0.40	0.176	0.27	0.07												
	Induction Hob / Ceramic Stove, Electric	Electric	0.75	0.72	0.54	0.20	0.11												
	Deep Fryer, Electric	Electric	0.60	0.54	0.324	0.15	0.08												
										Theoretical Flow Rate: 0.29 m³/s									
										X Factor for Canopy / Ceiling Type: 1.00									
										Capture and Efficiency factor: 0.80									
										Specific Extract Flow Rate: 0.36 m³/s									
										Make-up Air Ratio: 0.80									
										Make-up Air Flow Rate: 0.29 m³/s									
										For support or enquiries please e-mail: ed@fellermanpartnership.co.uk									
										Page: Page 1 of 1									

Specific Extract Flow Rate Calculation Sheet										Based on the THERMAL CORRECTION METHOD as recommended in HVCA Specification DW12:2019									
Floor Level:					From:					Tom Barnes					the fellerman partnership				
Area:					Job No.:					1053-201									
Canopy / Ceiling Ref:					Client Org No.:					#									
Canopy Type:					Date:					09/07/2024									
					Assessed By:					EF									
Item	Cooking Equipment	Power	Plan Size		Area (m²)	DW12:2019 Method		Flow Rate (m³/s)			Flow Rate (m³/s)			Flow Rate (m³/s)			Flow Rate (m³/s)		
			X(m)	Y(m)		TCC (m³/s/m²)	Flow Rate (m³/s)												
	Roast Pan, Electric	Electric	1.35	0.75	1.0125	0.30	0.31												
										Theoretical Flow Rate: 0.31 m³/s									
										X Factor for Canopy / Ceiling Type: 1.00									
										Capture and Efficiency factor: 0.80									
										Specific Extract Flow Rate: 0.39 m³/s									
										Make-up Air Ratio: 0.80									
										Make-up Air Flow Rate: 0.31 m³/s									
										For support or enquiries please e-mail: ed@fellermanpartnership.co.uk									
										Page: Page 1 of 1									

VENTILATION SCHEMATIC - FLOW RATES

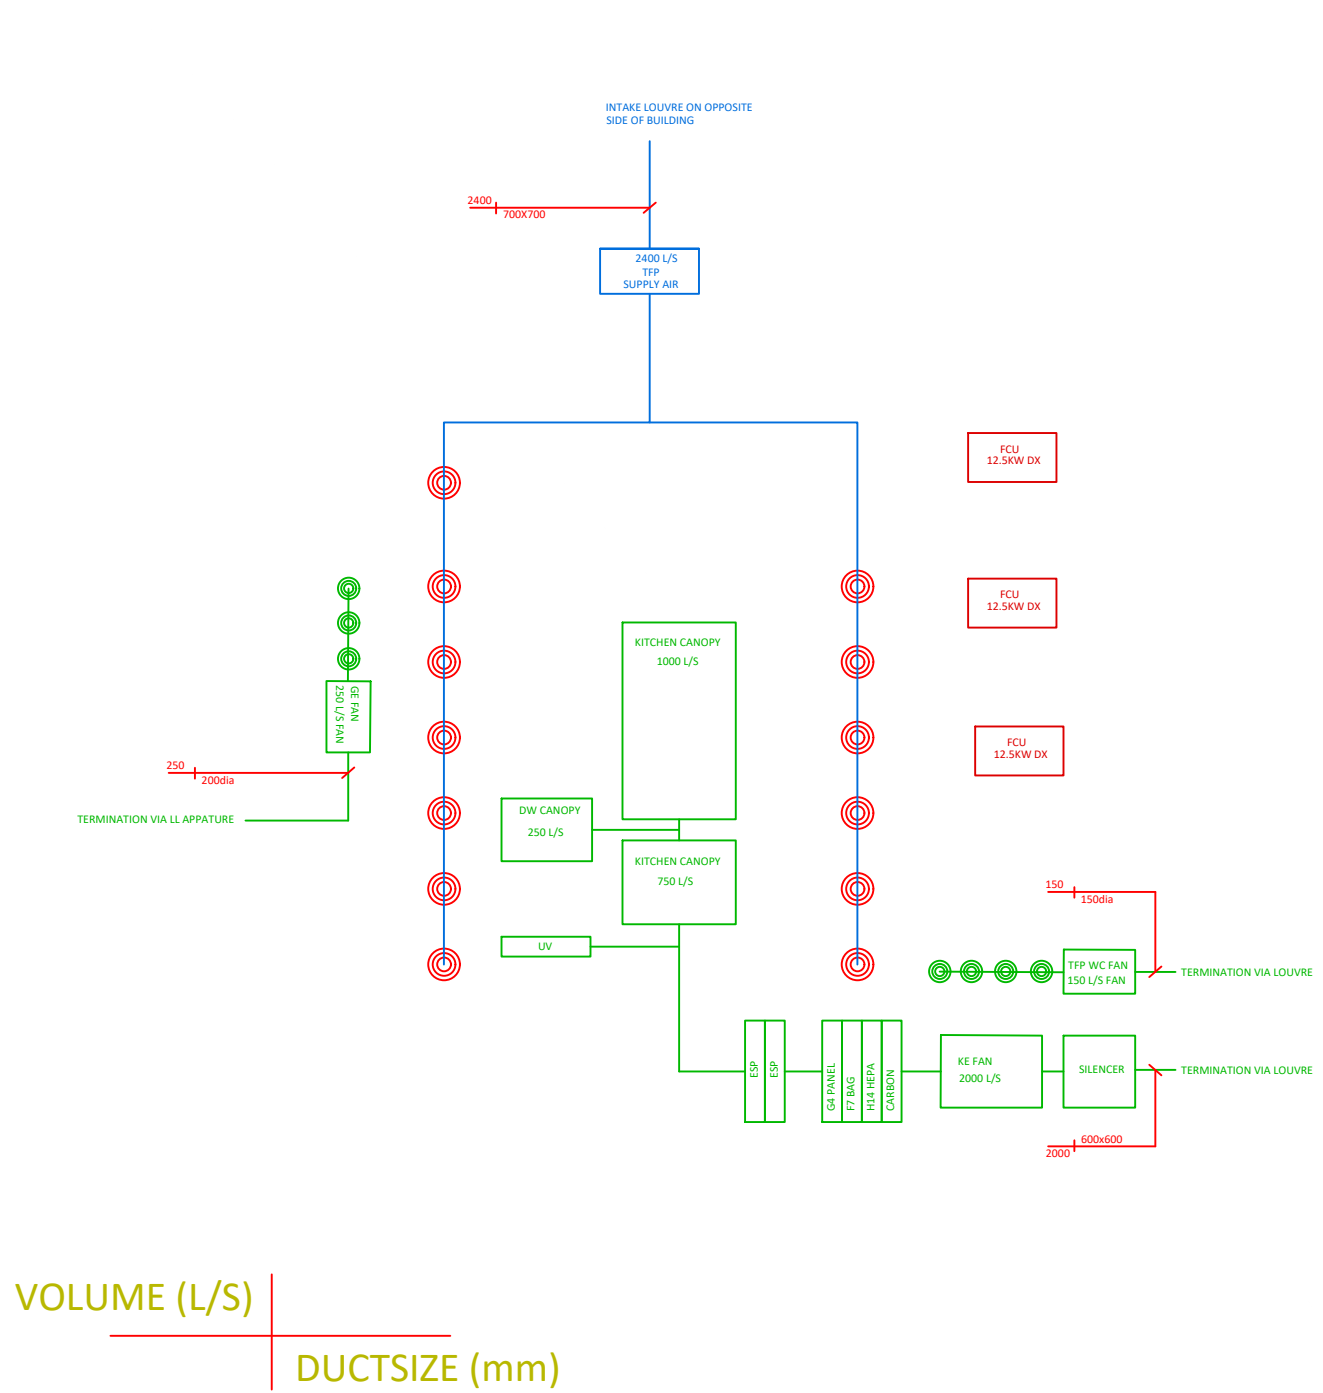

Client	TOM BARNES				the fellerman partnership
Project	SKOF - MANCHESTER				
Title	VENTILATION LAYOUT - GROUND FLOOR				
Contract No.	1053	Drawing No.	TFP-1053-201	D	
Scale	1:50:A1 1:100:A3		Date	27/06/2023	

D	29/02/2024	updated catering layout
C	27/12/2023	updated filtration to purified air
B	03/11/2023	condensers added to roof layout (removed from ground)
A	31/08/2023	updated access