


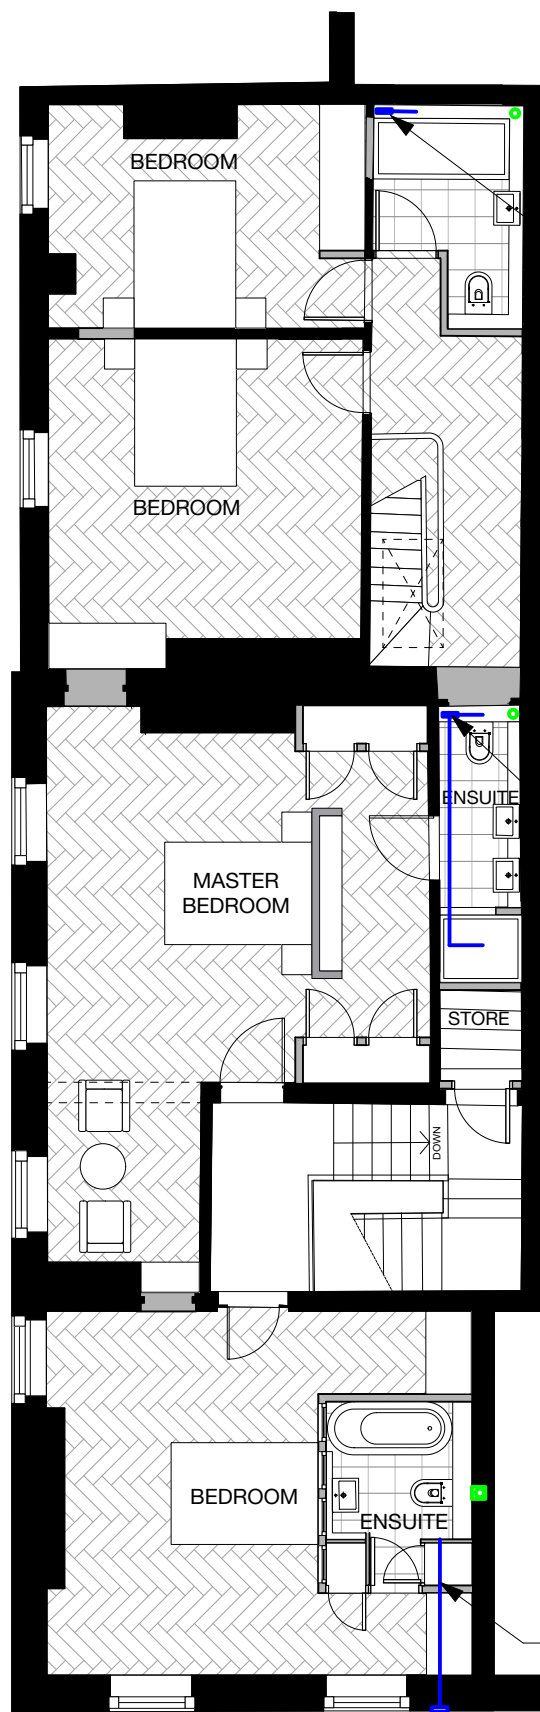


PROPOSED 2ND FLOOR PLAN

Vertical extract duct picking up extract from shower room.

Vertical extract duct picking up extract from ensuite

Extract duct from ensuite taken down into raised floor and positioned to run to outside wall between joists, within depth of existing floor. Bespoke wall terminal to outside - see opposite for details of proposed terminal.

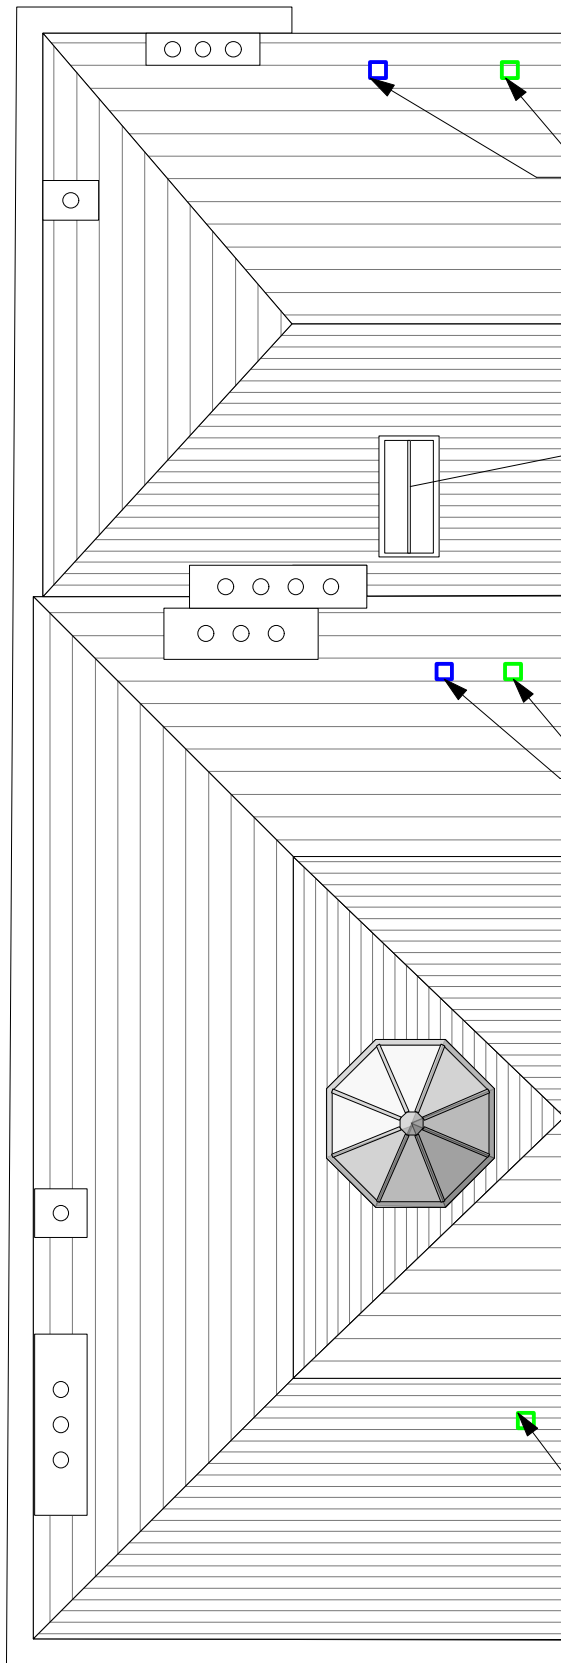

PROPOSED SECOND FLOOR PLAN

In-line slate ventilator terminal to vertical extract duct & svp

NEW CONSERVATIC ROOFLIGHT

In-line slate ventilator terminal to vertical extract duct & svp

In-line slate ventilator terminal to svp

0 1 2 3 4 5 M

PROPOSED MECHANICAL VENTILATION, ELECTRIC RISERS/ROUTES & SOIL PIPE SCHEMATIC PLANS 2ND FLOOR & ROOF PLAN
1:100 @ A3



© Copyright Ollier Smurthwaite Architects

PLANNING

- KEY:
- DENOTES NEW WALLS
 - MECHANICAL EXTRACT DUCT RUN
 - VERTICAL EXTRACT DUCT
 - SOIL PIPE

A	15.04.2024	Master bedroom ensuite amended.
REVISION	DATE	DESCRIPTION

CLIENT: LEASING OPTIONS LTD	
PROJECT: PROPOSED RESIDENTIAL DEVELOPMENT	
ADDRESS: 28 ST JOHN STREET	
DRAWING TITLE: PROPOSED MECH VENT & SOIL PIPE SCHEMATIC 2 of 2	
SCALE: 1:100 @A3	DATE: DECEMBER 2022
DRAWING NO: A665_P_3007A	

OLLIER SMURTHWAITE ARCHITECTS

40 King Street, Manchester, M2 6BA

T 0161 883 0838
F 0161 883 0839
E mail@olliersmurthwaite.com