
 


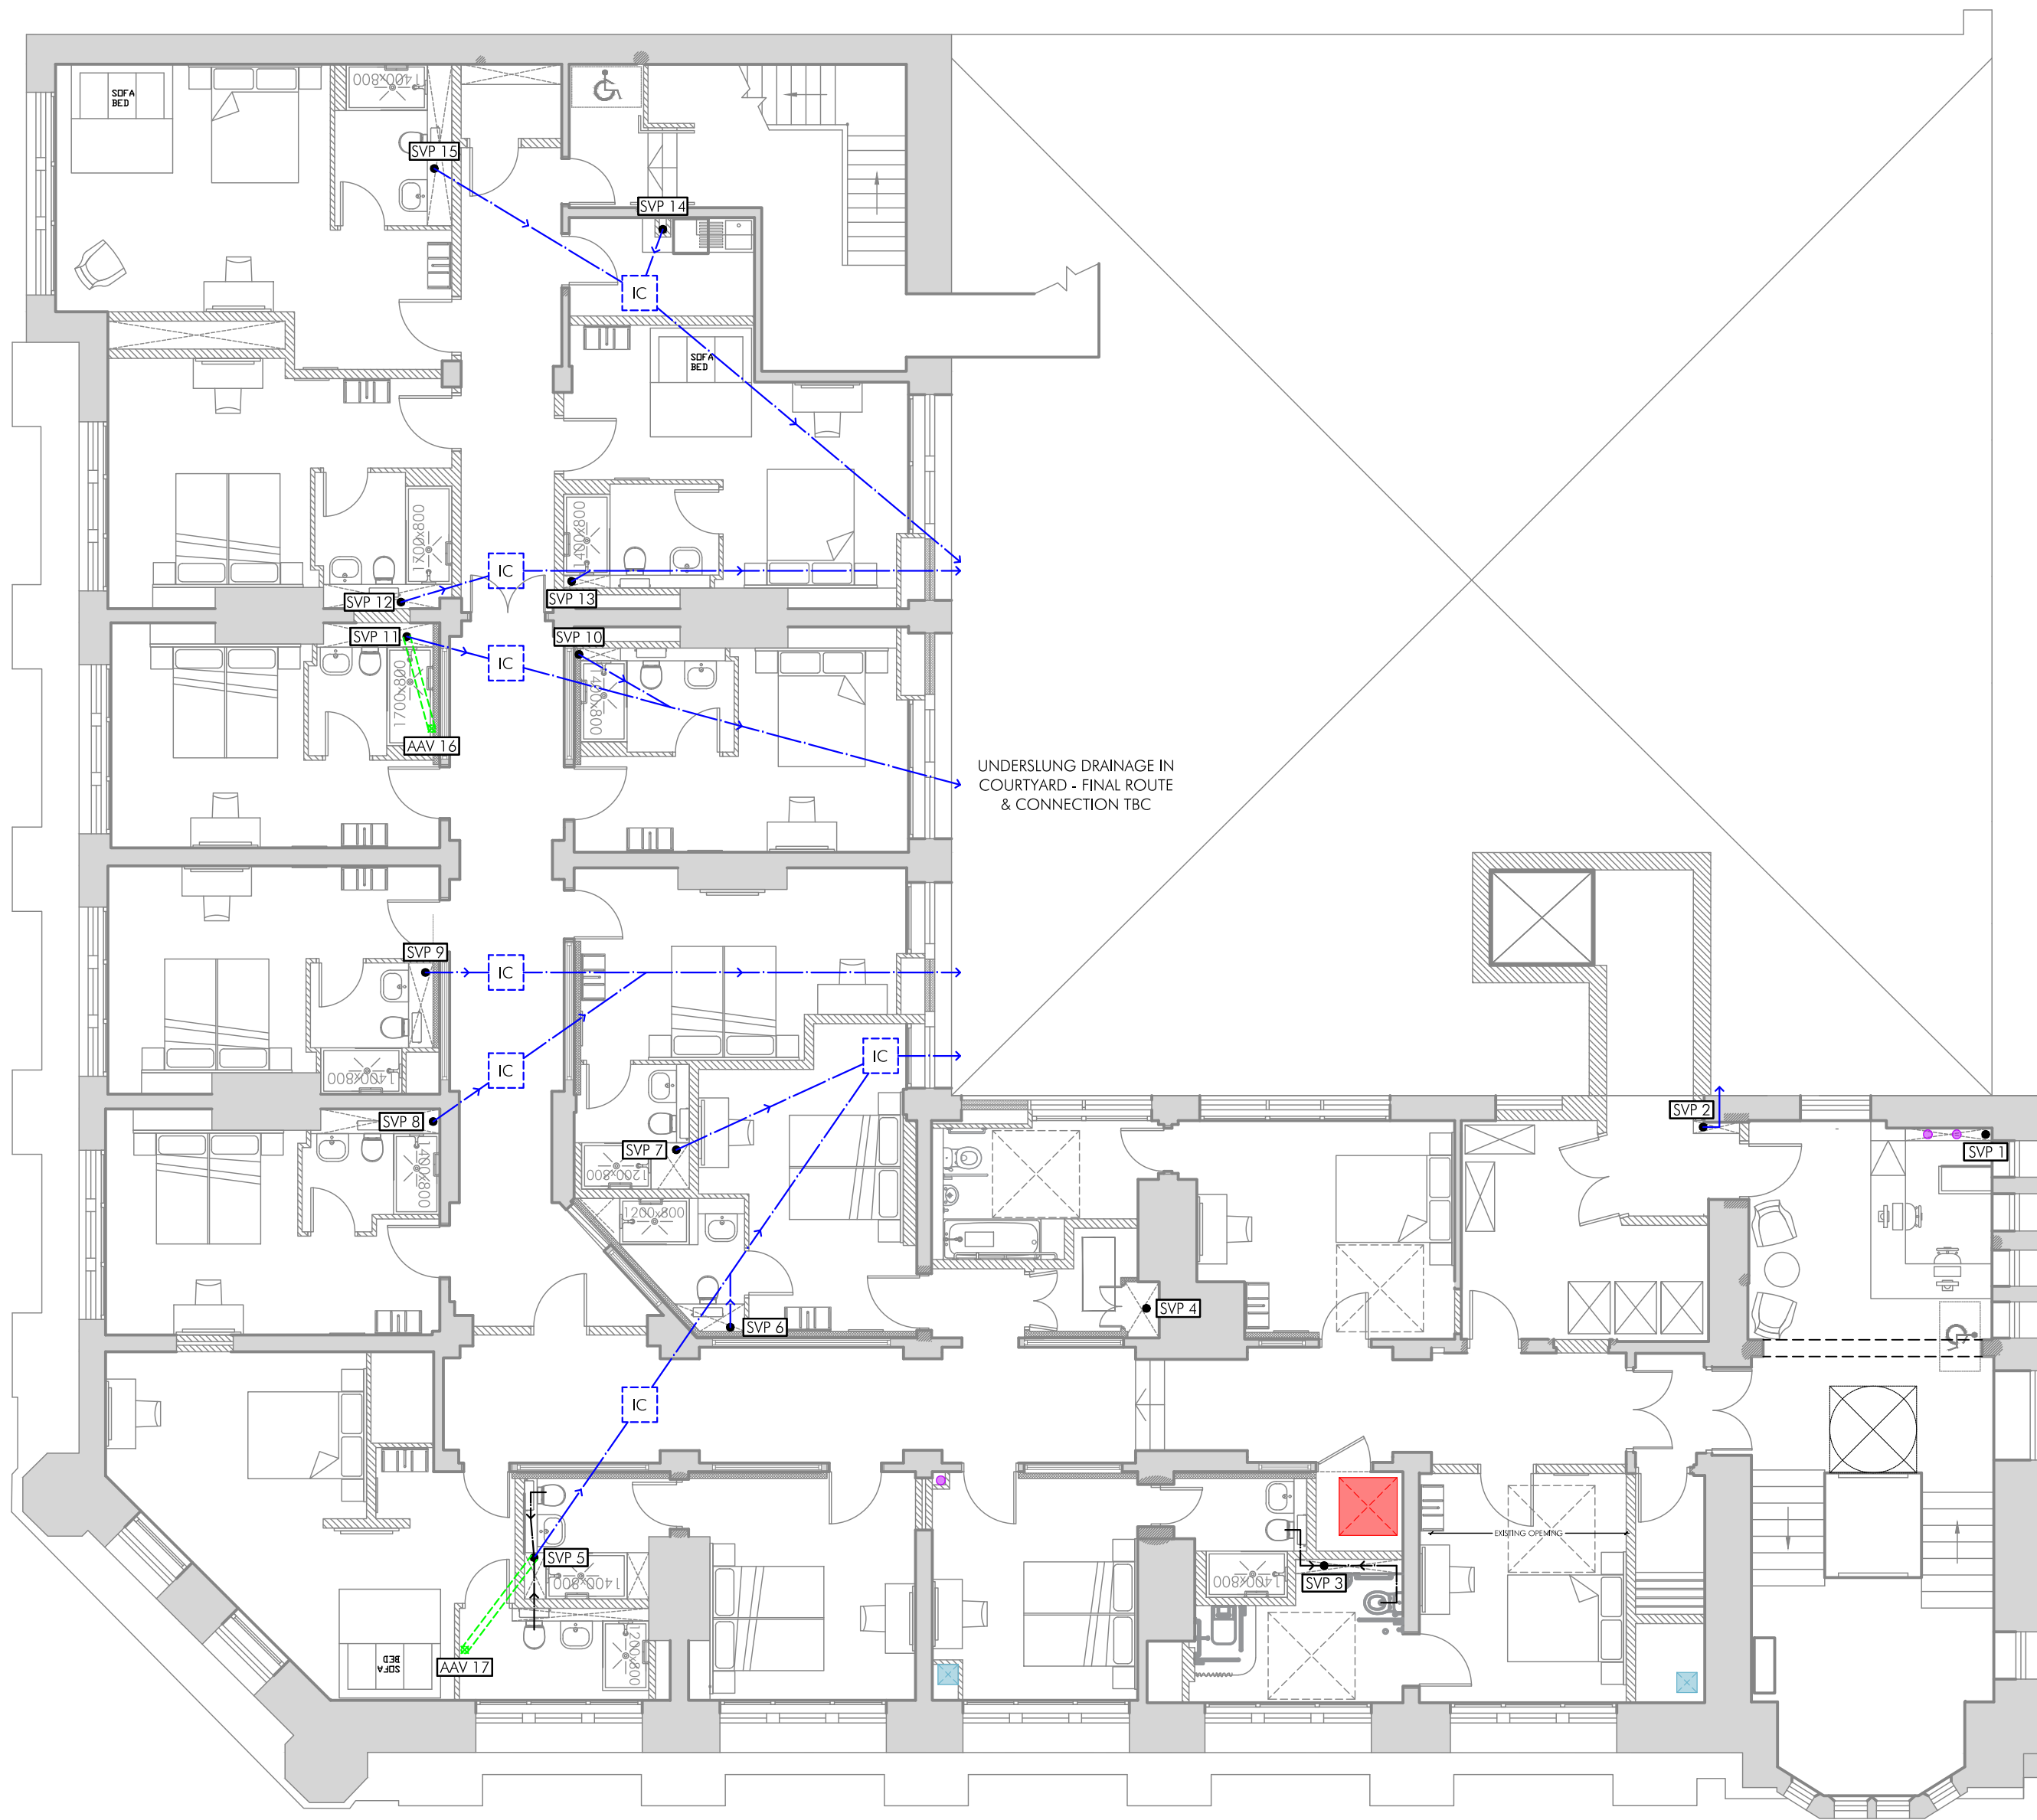

PROPOSED SECOND FLOOR PLAN
SCALE 1:100 @ A2



- | | | |
|---|---|---|
| SVP # | TYPE 1 - INDICATES APPROX LOCATION OF 120MM DIA CORE DRILLED HOLE FOR SVP | TYPE 2 - INDICATES APPROX LOCATION OF 350MM SQ HOLE FOR SUPPLY AND EXTRACT DUCTWORK |
| TYPE 1 - INDICATES APPROX LOCATION OF 150MM DIA CORE DRILLED HOLE FOR PIPE SERVICES | TYPE 3 - INDICATES APPROX LOCATION OF LARGER HOLE TO FORM SERVICE RISER | |
| INDICATIVE LINE OF BELOW FLOOR DRAINAGE RUN | INDICATIVE LINE OF ABOVE FLOOR DRAINAGE RUN | INDICATIVE LINE OF BRANCH FROM LOCAL AAV POSITION |
| | APPROX LOCATION OF INSPECTION CHAMBER | APPROX LOCATION OF RODDING EYE |
- ALL DRAINAGE RUNS AND POSITIONS OF SVPS / HOLES THRU FLOOR ETC. ARE INDICATIVE - EXACT POSITIONS TO BE DETERMINED O SITE

BN	REV B: PLANS UPDATED AS PER PLANNING COMMENTS TIO MATCH UPDATED SCHEME	JUN 23	SP
SH	'A' - UPDATED TO CONCUR WITH AP02	JAN 23	
DRAWN	REVISION	DATE	VER



ARCHITECTS & DESIGNERS

7 Buxton Road West, Disley,
Stockport, Cheshire, SK12 2AE.
Website: www.allisonpike.com

Telephone: 01663 763000
Facsimile: 01663 766772
Email: studio@allisonpike.com

© Allison Pike Partnership Limited.

PLANNING ISSUE	PROJECT	INNKEEPERS COLLECTION 1-3 YORK STREET (BROWNS) MANCHESTER		
	TITLE	PROPOSED SECOND FLOOR PLAN HOLES THROUGH FLOORS & DRAINAGE		
	SCALE	1:100 @ A2		
	JOB No	DRAWING No	REV	
	MAB46	AP29	B	