


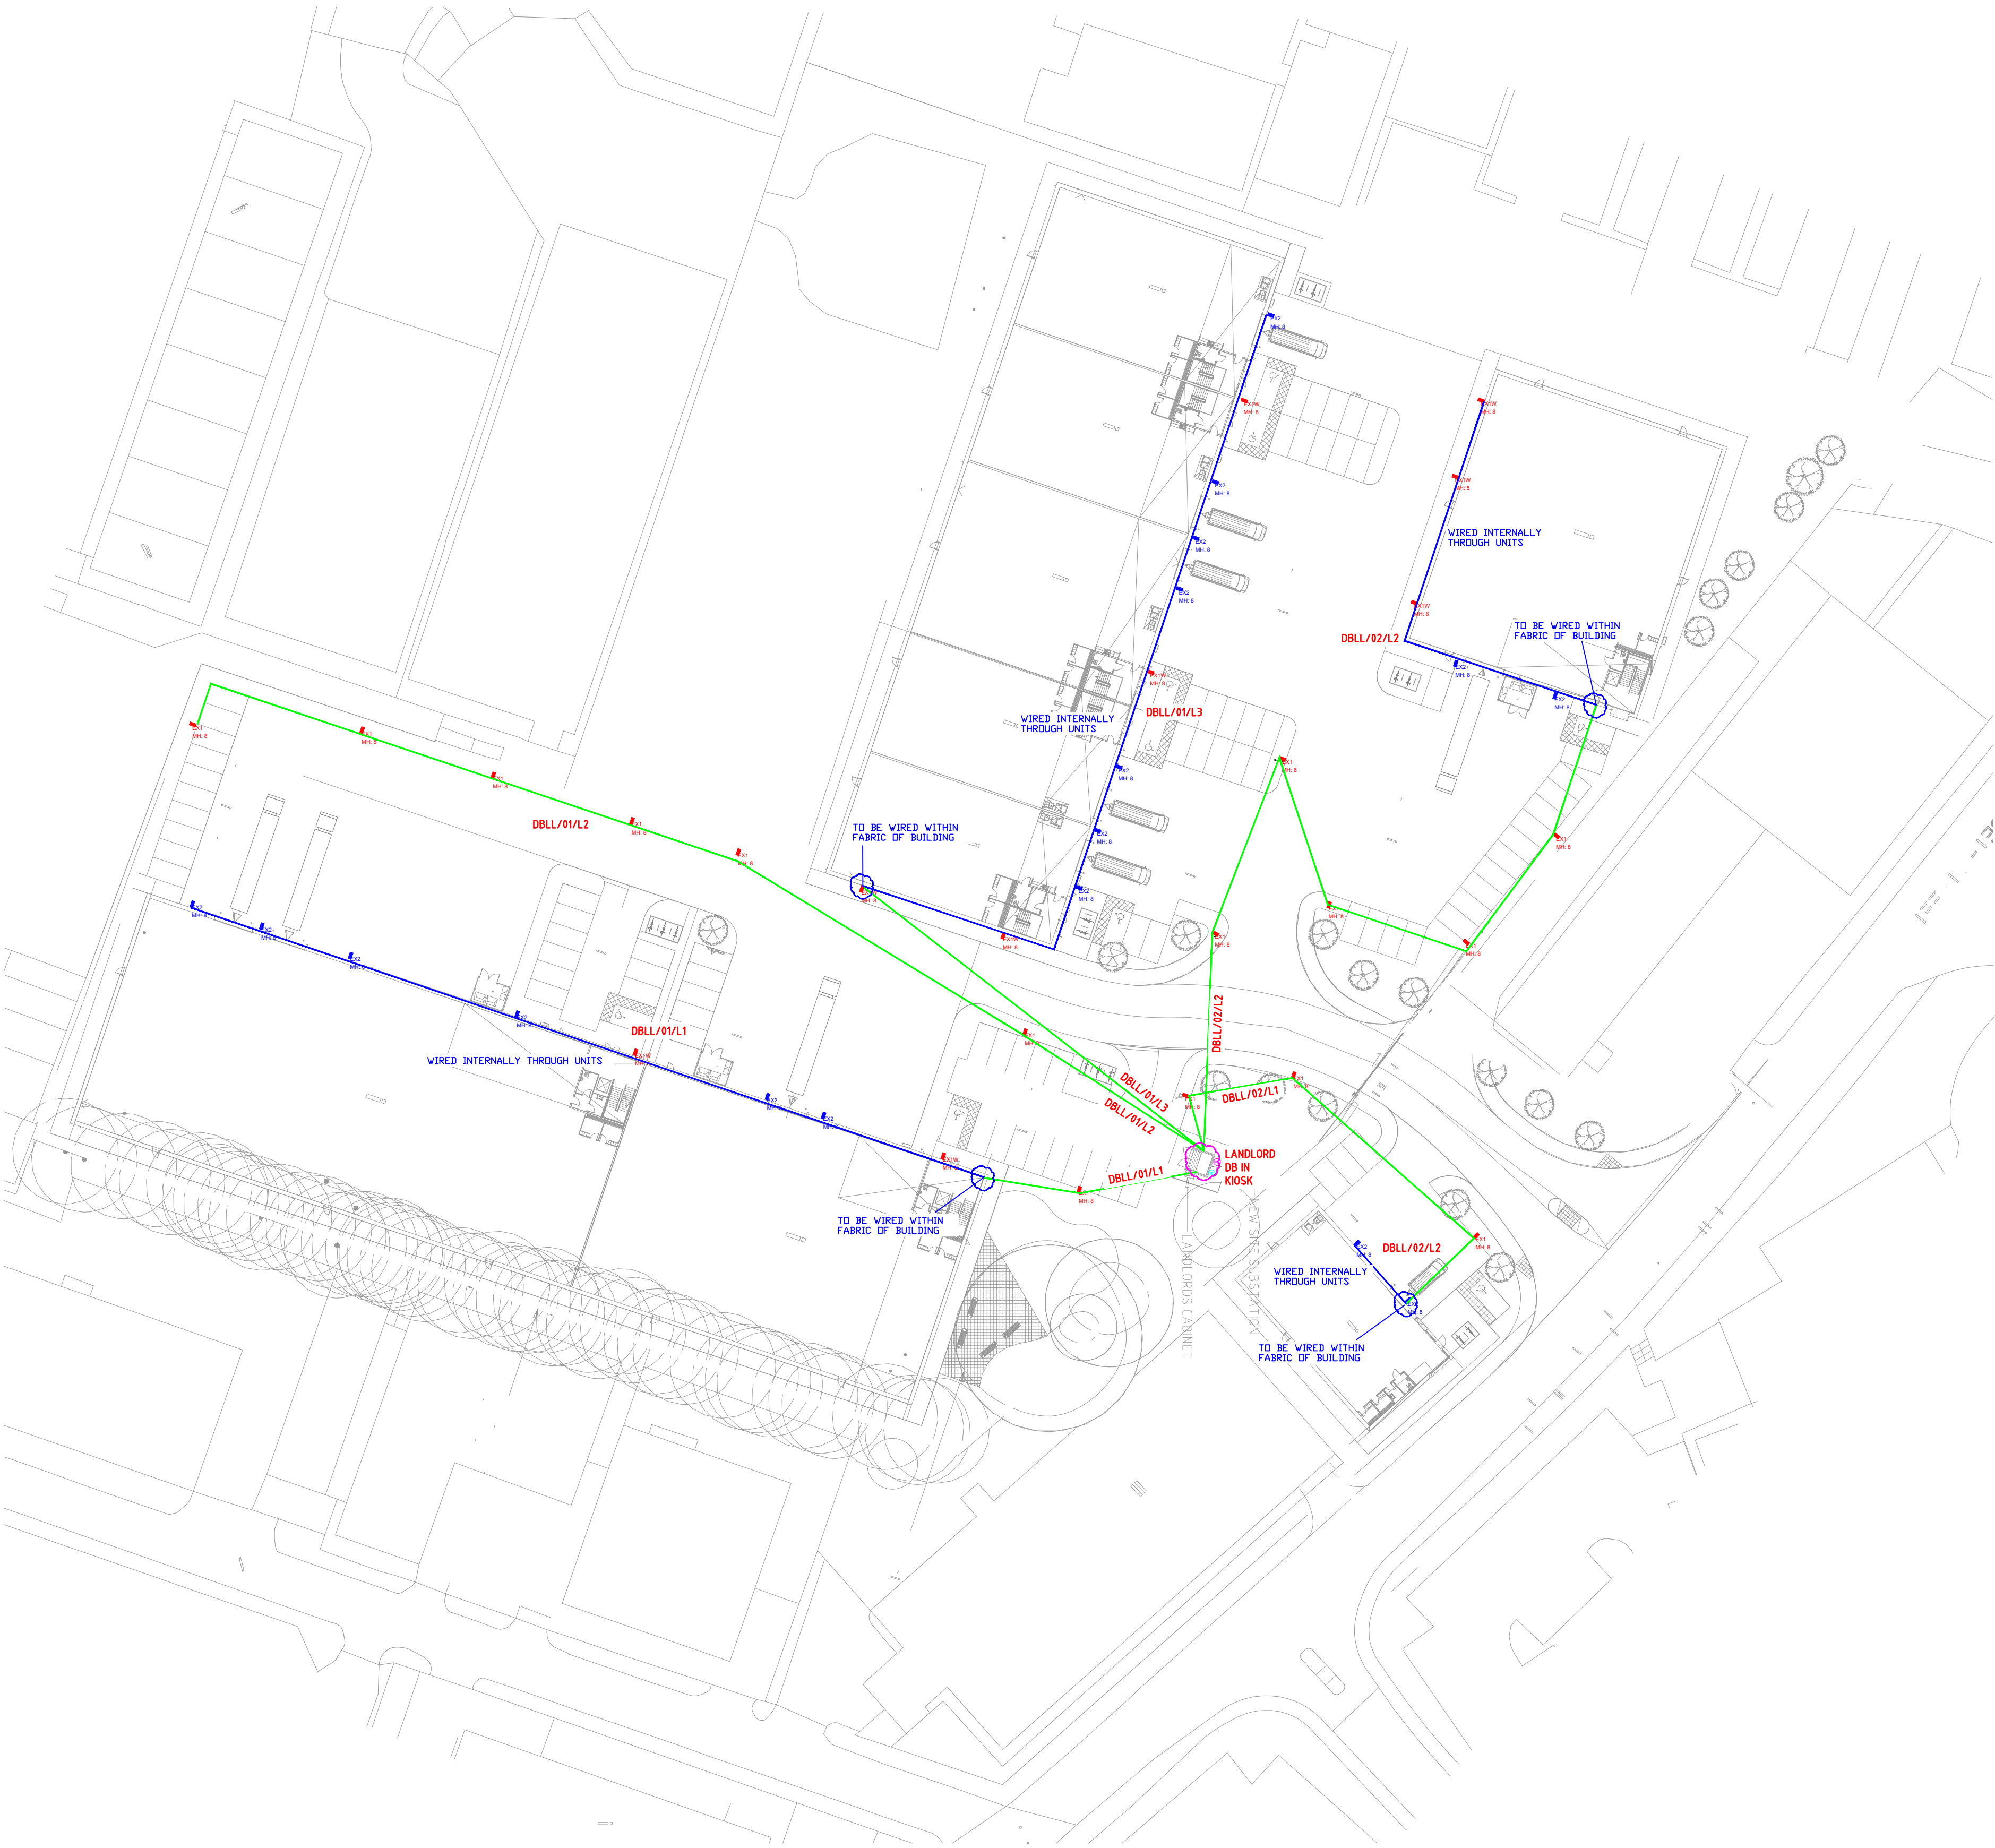

Copyright
This drawing is copyright and may not be altered, reproduced or used other than for the Contract Works for which it is issued, without the written permission of JDL Property Ltd.
Do not scale this drawing. Verify all dimensions and structural details on site. If in doubt, ask before acting.
This drawing is to be read in conjunction with the appropriate Specification(s), and contract documentation.

rev	date	revision notes	dwn	chkd
D	02/02/24	Circuits Added	MS	LG

Notes

LEGEND	
	INTERNAL WIRING
	100mm DUCT <BY OTHERS>
	PHOTOCELL
	TIMECLOCK
	WIRING WITHIN FABRIC OF BUILDING
	LANDLORDS DB
	EXT 1 - LIGHTING COLUMN <WALL MOUNTED LABELLED W>
	EXT 2 - LIGHTING COLUMN <WALL MOUNTED LABELLED W>

APPROVAL

client		TRITON CONSTRUCTION	
project		ELIZABETH ST	
		JDEL	
		Unit 19 Waters Meeting Britannia Way Bolton BL2 2HH 01204 302 600 enquires@jdel.uk	
drawing title			
EXTERNAL LIGHTING LAYOUT			
engineer	LG	checked	RD
contracts manager	JS		
scale	1:500	date	drawn by
			MS
project No.	23-0704	drawing No.	JDEL 9164-100
rev	D		