


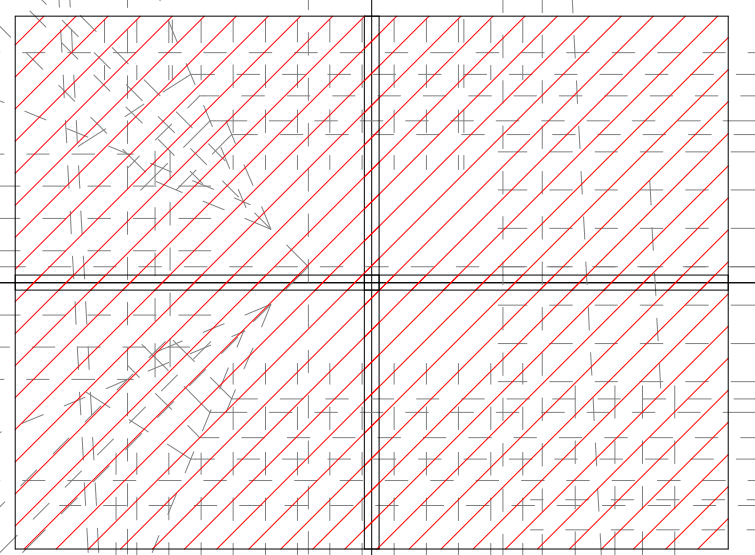


KEY PLAN

COLUMN REFERENCES

- CCTV WEC - STAND ALONE CCTV COLUMN CW CCTV CAMERA'S ONLY (TO MATCH CAMPUS)
- CCTV/L WEC - CCTV COLUMN CW CCTV AND LIGHTING BRACKET FOR KINGFISHER HEAD
- EC1 MIKADO TECHNIUM - 6M STAND ALONE LIGHTING COLUMN CW KINGFISHER HEAD
- EC2 MIKADO TECHNIUM - 6M MIKADO LIGHTING COLUMN WITH KINGFISHER DOUBLE HEAD
- EC3 KINGFISHER HEAD - KINGFISHER HEAD MOUNTED TO TOP OF TURRET (WALL MOUNTED)
- EC4 6M KINGFISHER LIGHTING COLUMN WITH KINGFISHER HEAD

SERVICES CONNECTIONS FOR TREE LIGHTING DETAILS

- DETAIL A:
1 X 16A SOCKET FOR TREE LIGHTING
BOX DIMENSIONS MIN 300MM L X 150MM W X 200MM D (NON STANDARD)
- DETAIL B:
2 X 16A SOCKET FOR TREE LIGHTING
BOX DIMENSIONS MIN 600MM L X 150MM W X 200MM D (NON STANDARD)

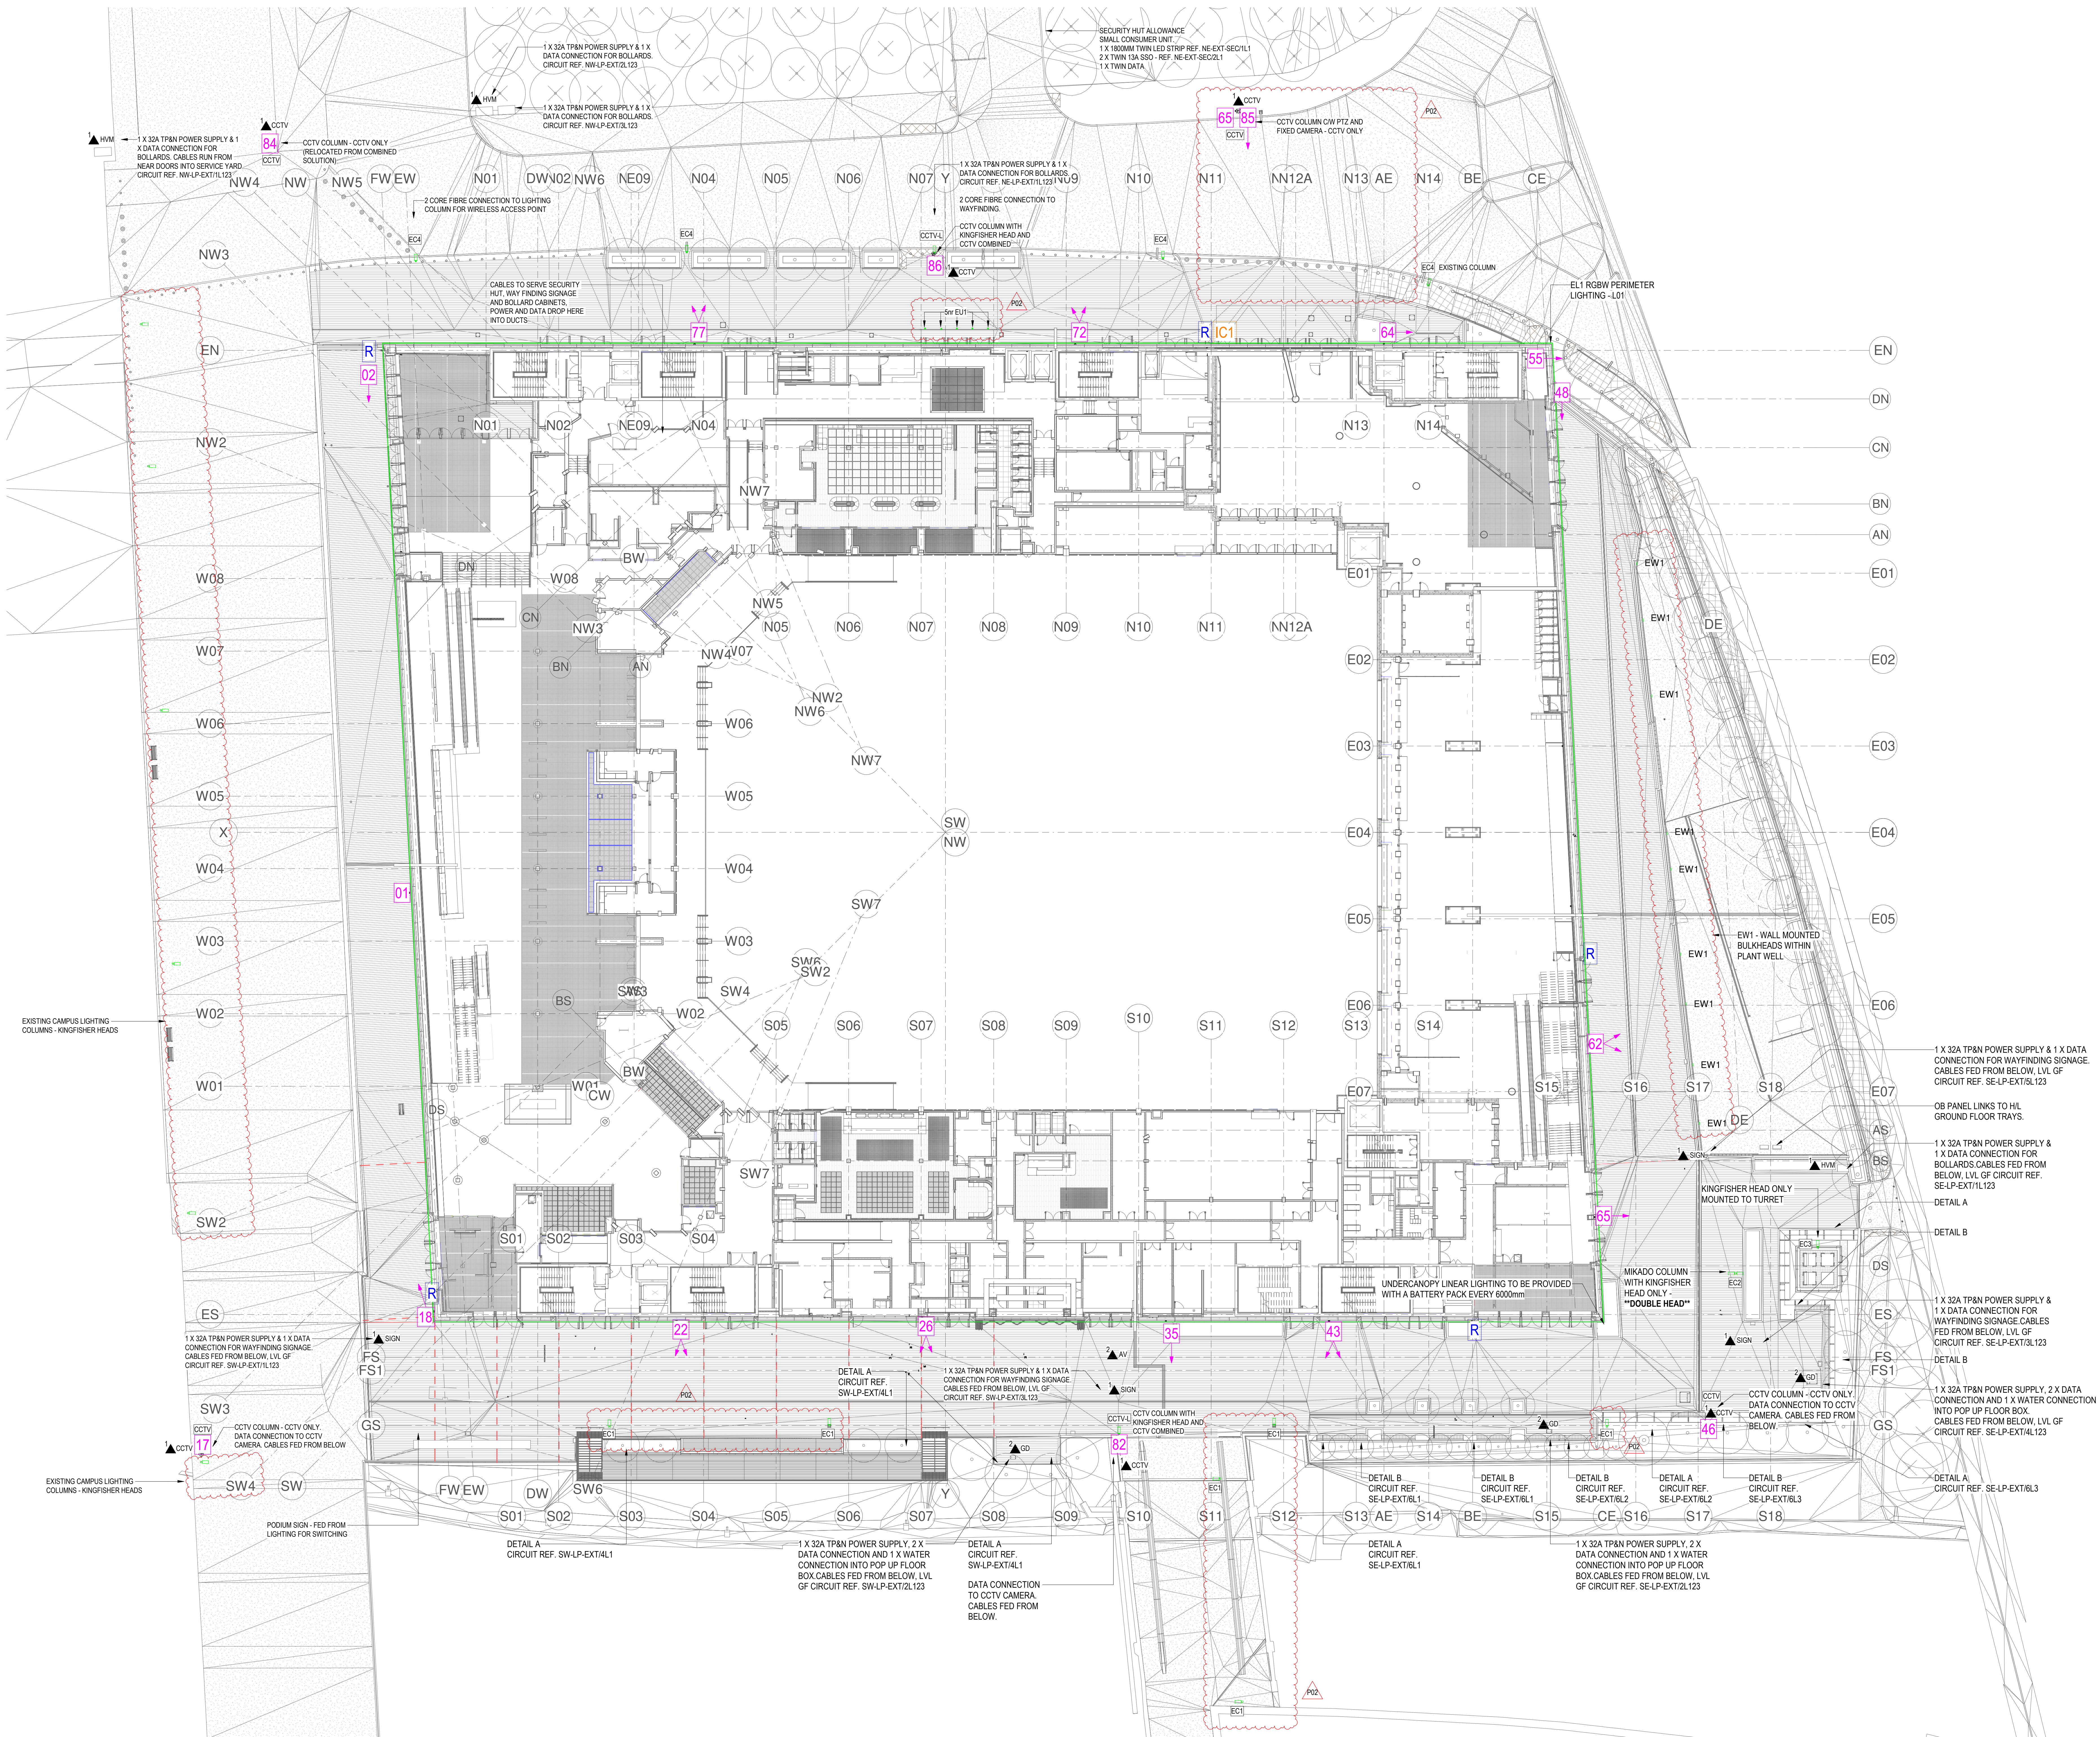

Rev P02	Comment: ISSUED FOR APPROVAL				
	Drawn: JSD	Date: 01.09.23	Checked: AM	Date: 01.09.23	Approved: DK
Rev P01	Comment: ISSUED FOR APPROVAL				
	Drawn: JSD	Date: 14.08.23	Checked: AM	Date: 14.08.23	Approved: DK
Scale		Original		Uniclass Classification	
1 : 250		A0			
Status				Stage	
S4 FOR APPROVAL				4C	
Client					
BAM					

16
EXTERNAL LIGHTING & CCTV LAYOUT

Drawing No.
BRA-SES-ZZ-ZZ-DR-X-62804

Revision
P02