
 


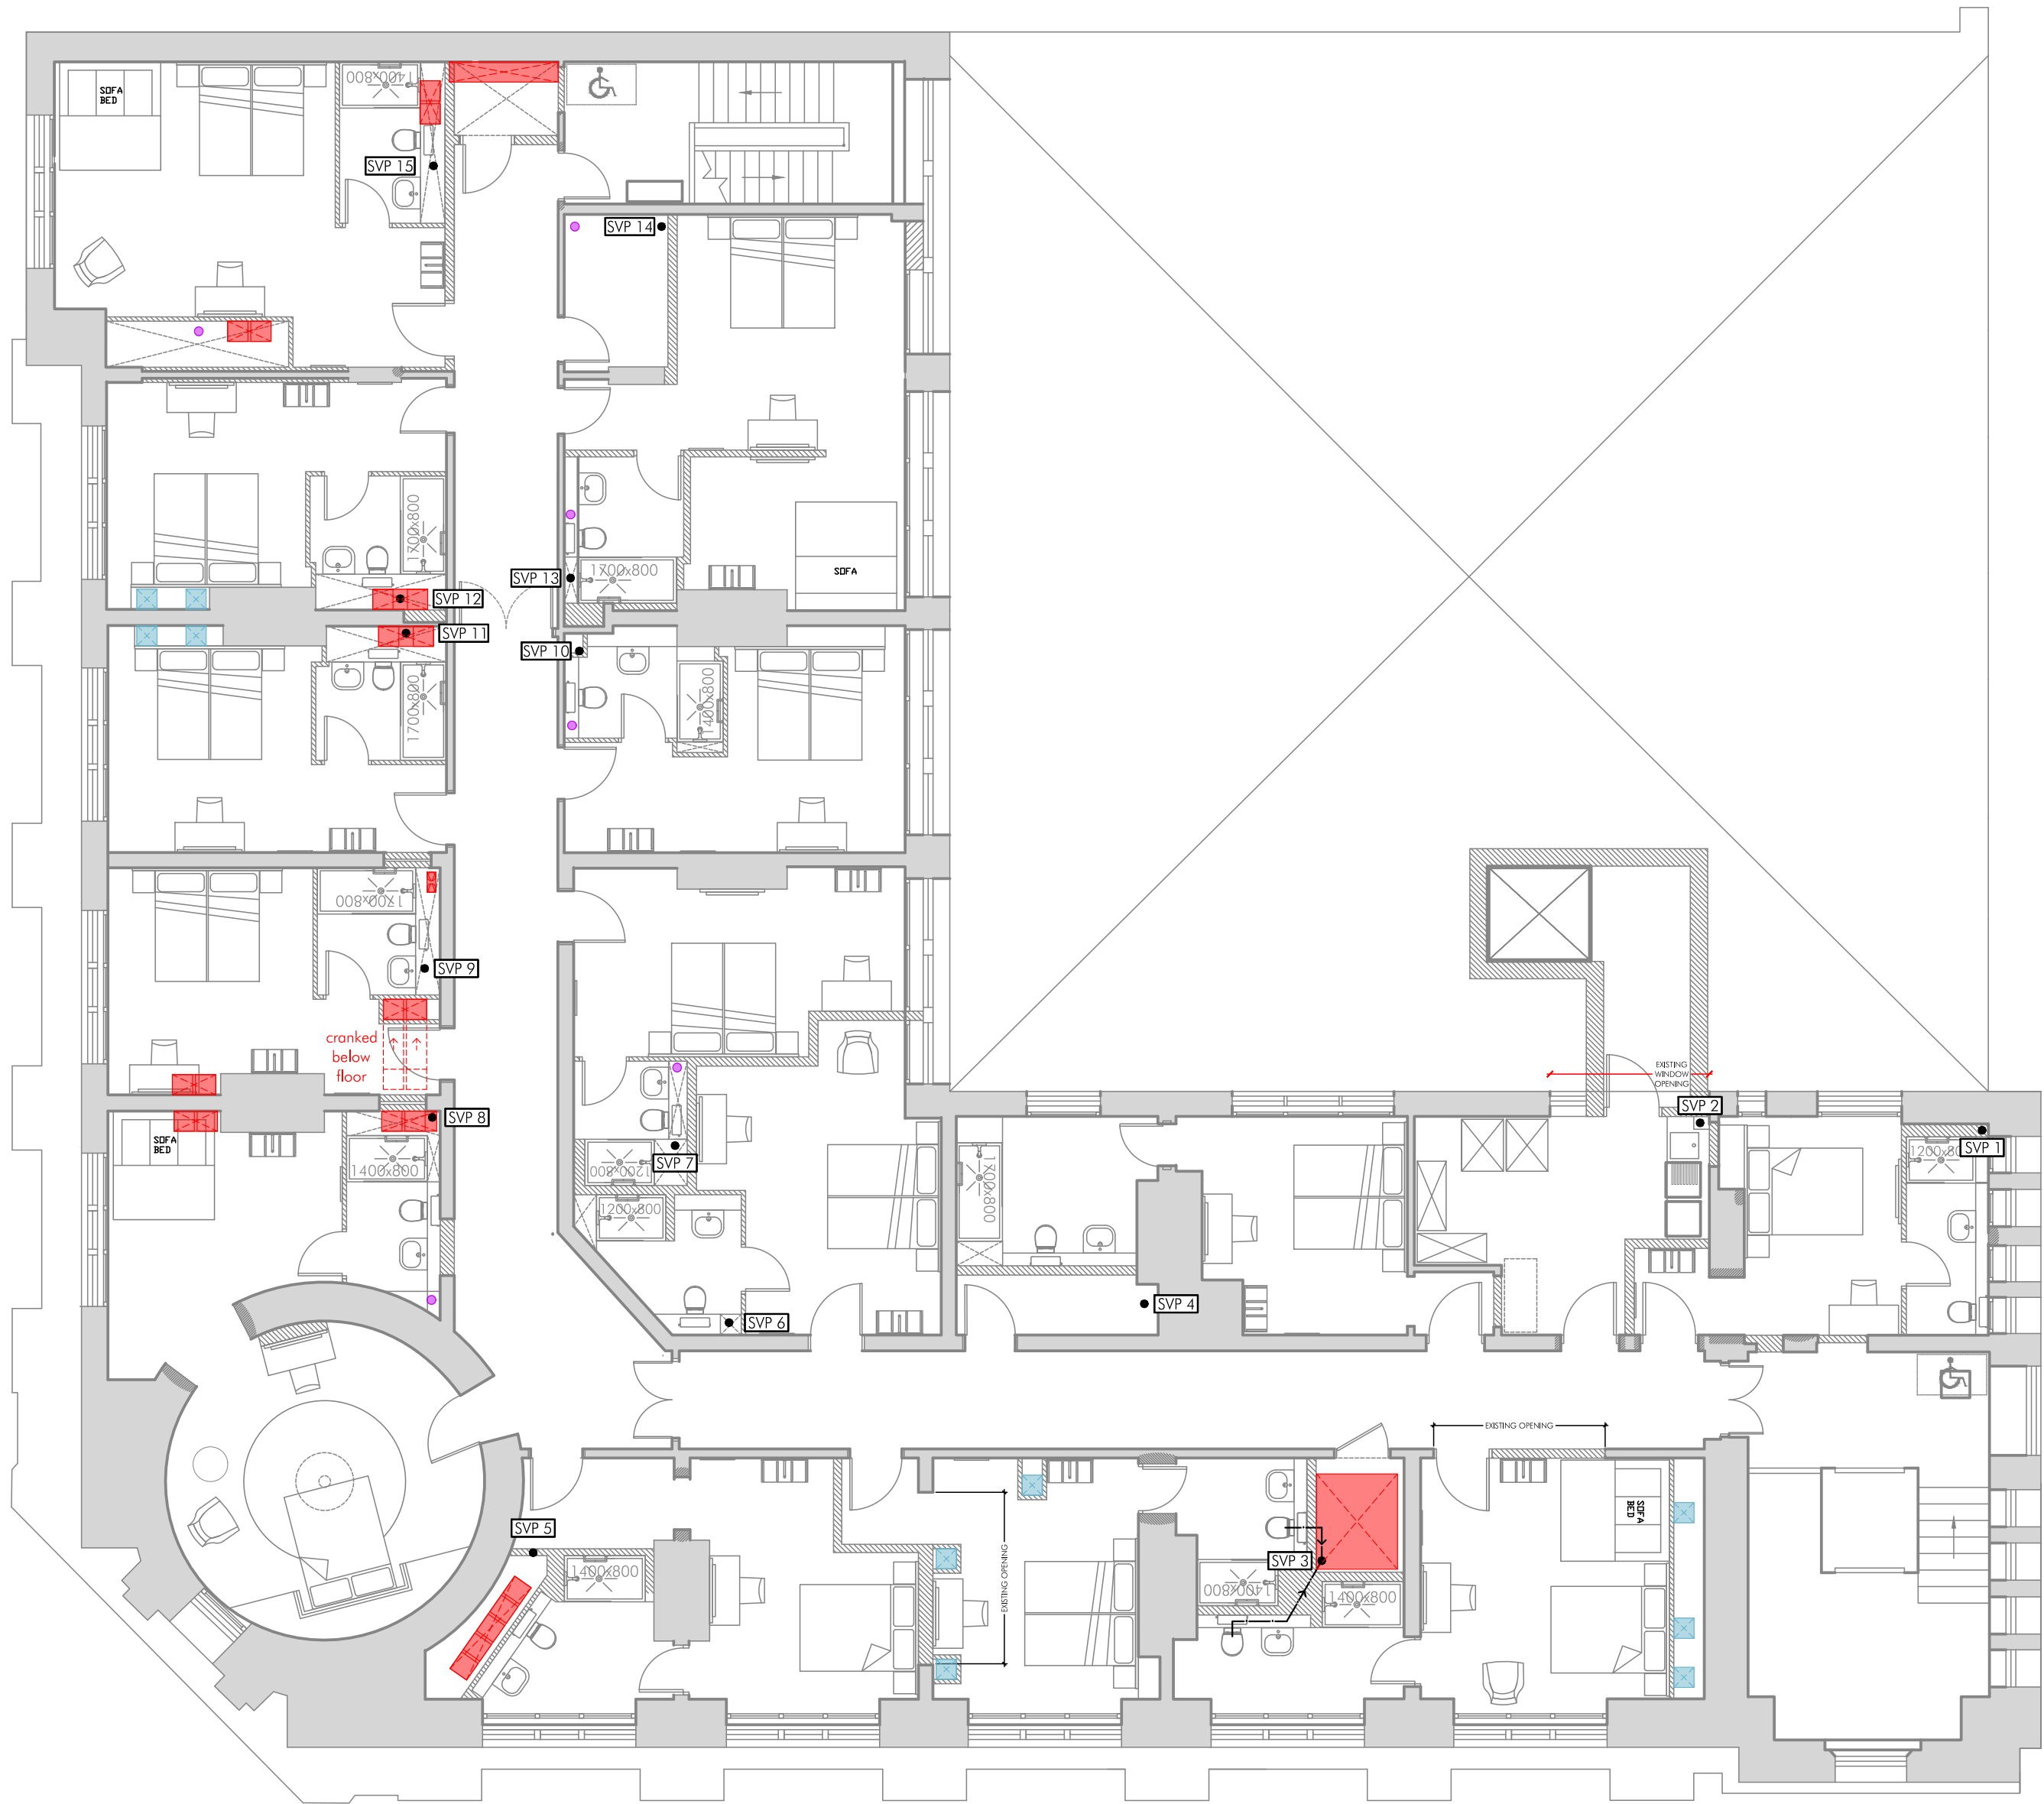

PROPOSED FOURTH FLOOR PLAN
SCALE 1:100 @ A2



- SVP #** • TYPE 1 - INDICATES APPROX LOCATION OF 120MM DIA CORE DRILLED HOLE FOR SVP
- TYPE 1 - INDICATES APPROX LOCATION OF 150MM DIA CORE DRILLED HOLE FOR PIPE SERVICES
- INDICATIVE LINE OF BELOW FLOOR DRAINAGE RUN
- INDICATIVE LINE OF ABOVE FLOOR DRAINAGE RUN
- INDICATIVE LINE OF BRANCH FROM LOCAL AAV POSITION
- IC APPROX LOCATION OF INSPECTION CHAMBER
- RE APPROX LOCATION OF RODDING EYE
- ALL DRAINAGE RUNS AND POSITIONS OF SVPS / HOLES THRU FLOOR ETC. ARE INDICATIVE - EXACT POSITIONS TO BE DETERMINED O SITE
- TYPE 2 - INDICATES APPROX LOCATION OF 350MM SQ HOLE FOR SUPPLY AND EXTRACT DUCTWORK
- TYPE 3 - INDICATES APPROX LOCATION OF LARGER HOLE TO FORM SERVICE RISER

SP	REV C: PLANS UPDATED	01.12.23	
BN	REV B: PLANS UPDATED AS PER PLANNING COMMENTS TO MATCH UPDATED SCHEME	JUN 23	SP
SH	'A' - UPDATED TO CONCUR WITH AP04	JAN 23	
DRAWN	REVISION	DATE	VER



ARCHITECTS & DESIGNERS

7 Buxton Road West, Disley,
Stockport, Cheshire, SK12 2AE.
Website: www.allisonpike.com

Telephone: 01663 763000
Facsimile: 01663 766772
Email: studio@allisonpike.com

© Allison Pike Partnership Limited.

PLANNING ISSUE

PROJECT
INNKEEPERS COLLECTION
1-3 YORK STREET (BROWNS)
MANCHESTER

TITLE
PROPOSED FOURTH FLOOR PLAN
HOLES THROUGH FLOORS & DRAINAGE

SCALE
1:100 @ A2

JOB No MAB46	DRAWING No AP31	REV C
-----------------	--------------------	----------