


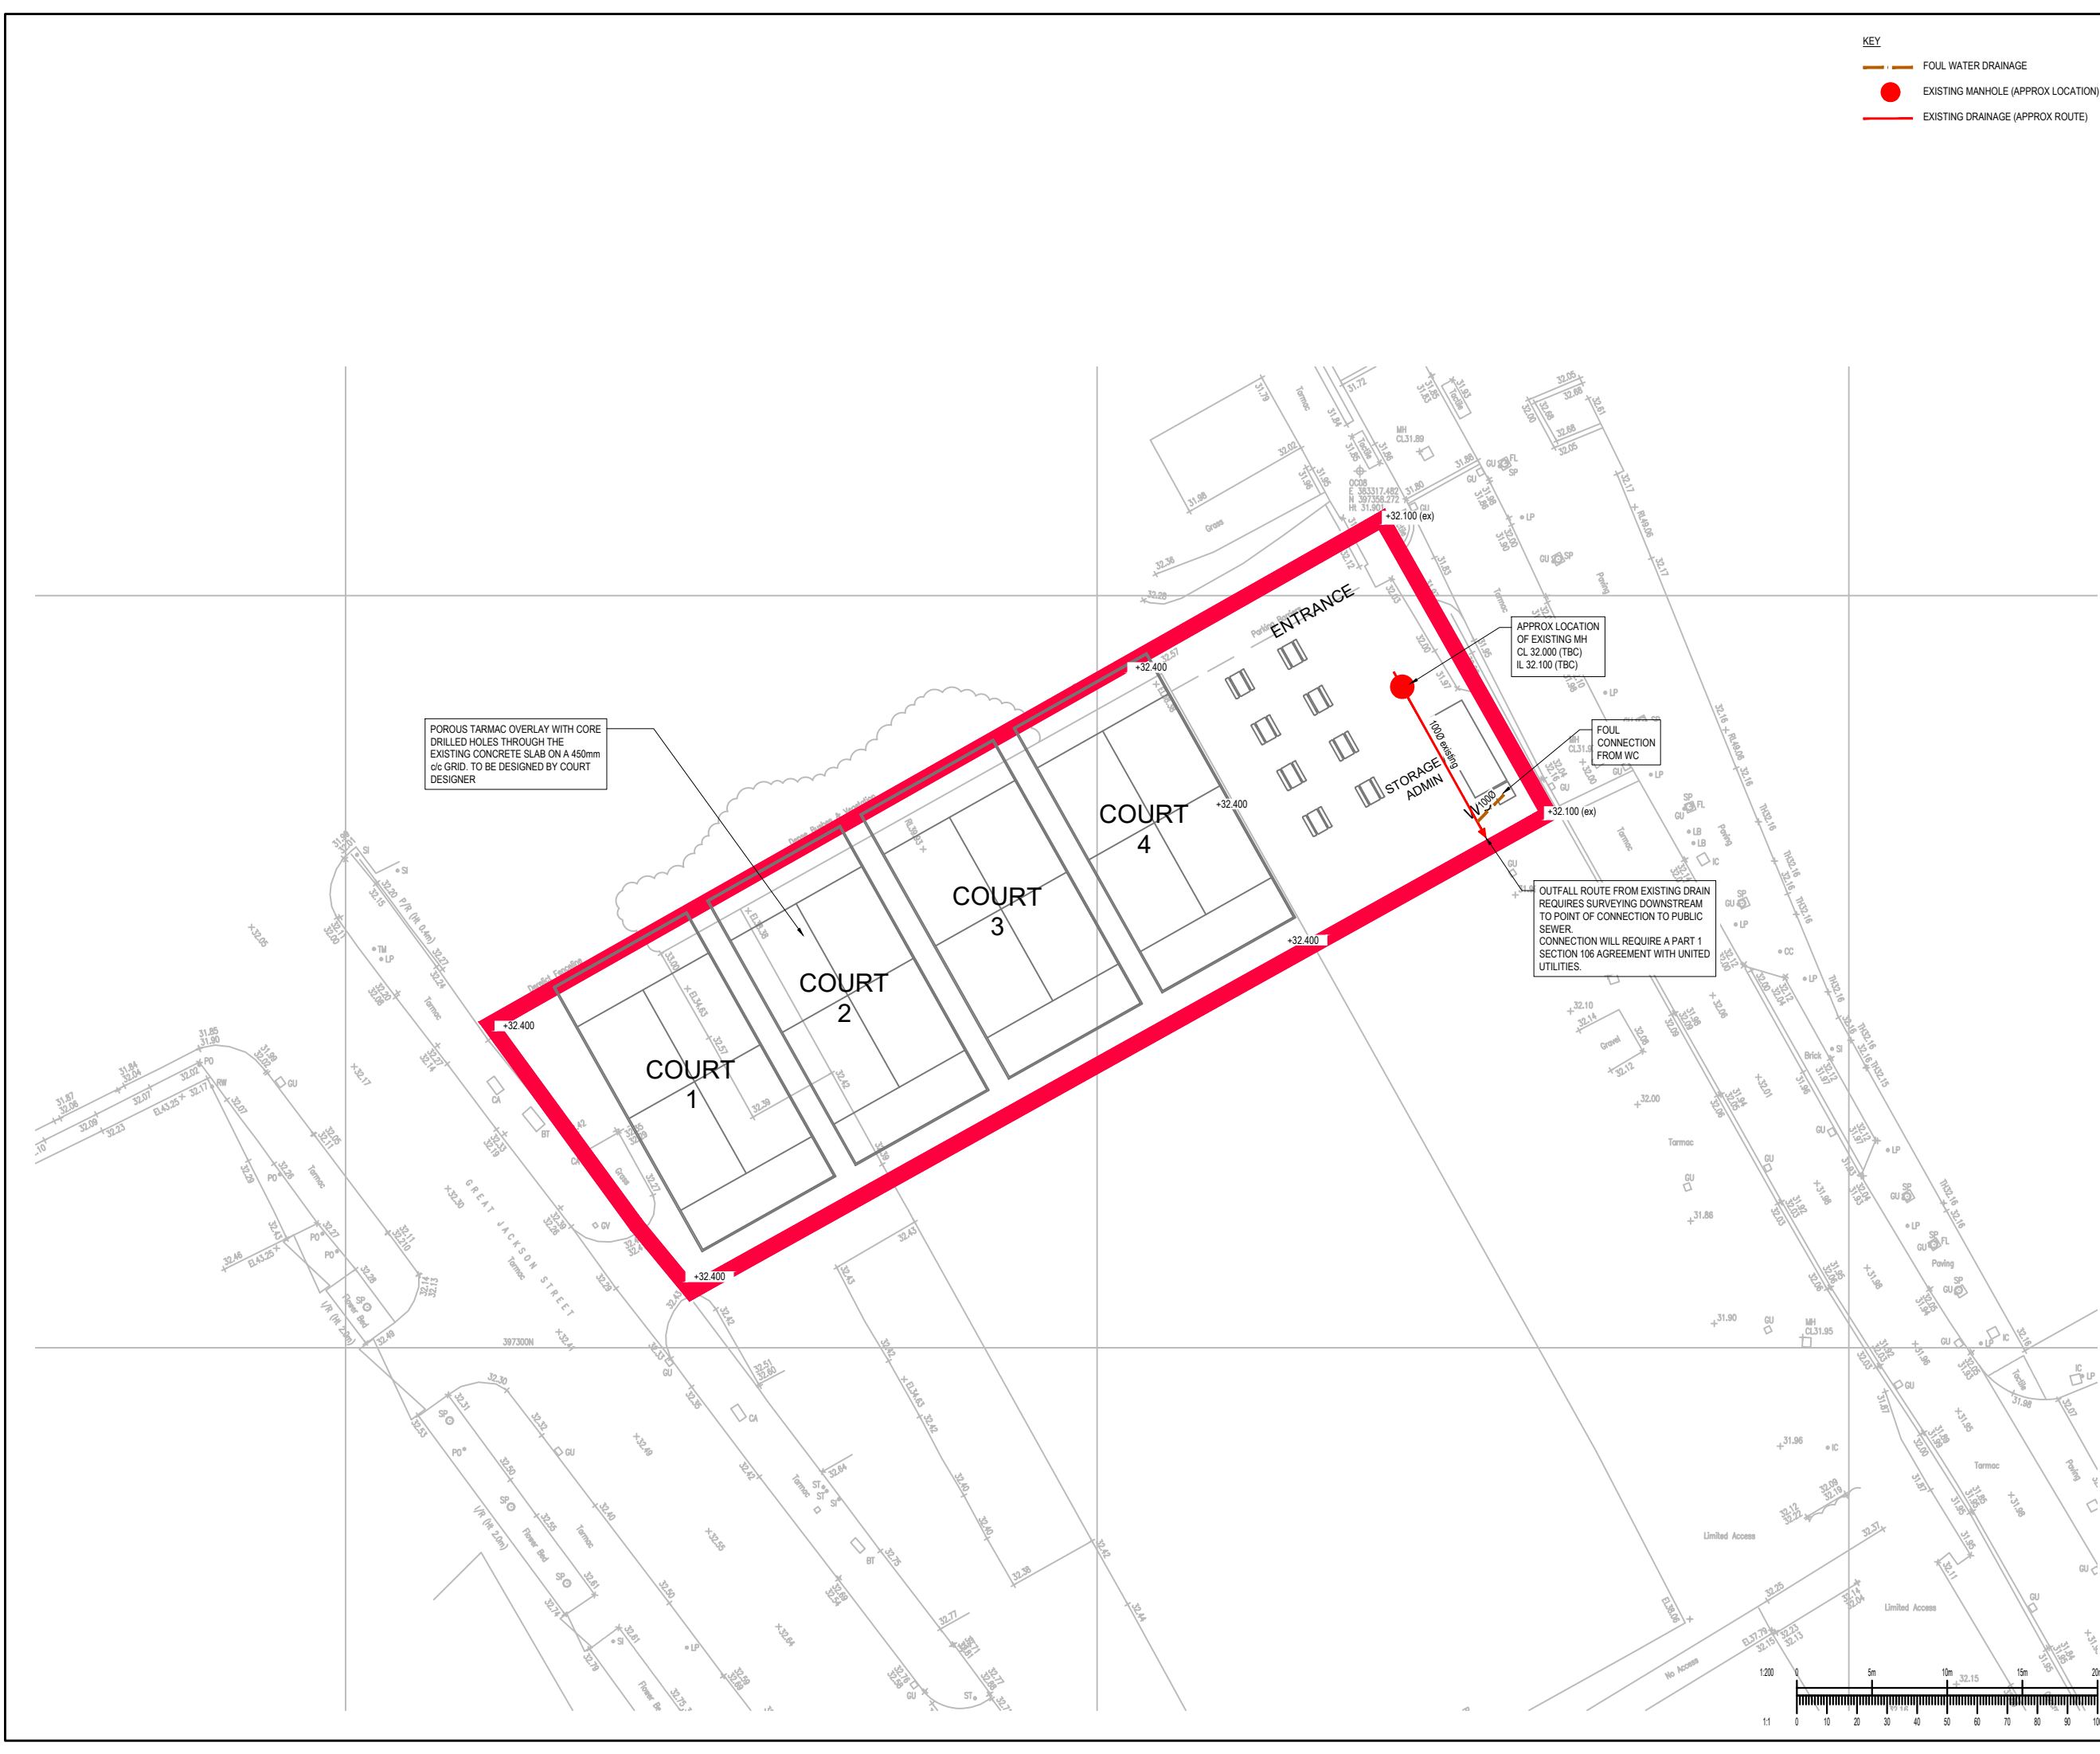

GENERAL NOTES:

- THIS DRAWING IS TO BE READ IN CONJUNCTION WITH ALL RELEVANT ARCHITECTS AND ENGINEERS DRAWINGS AND SPECIFICATIONS.
- DESIGN BASED ON TOPOGRAPHICAL SURVEY AND CCTV SURVEY INFORMATION AVAILABLE AT THE TIME OF DESIGN.
- ALL EXISTING SEWERS, CONNECTIONS, PIPE SIZES AND INVERT LEVELS TO BE CONFIRMED BY CONTRACTOR PRIOR TO COMMENCEMENT OF WORKS TO ENSURE CONNECTIVITY. ANY VARIANCE FROM THE INFORMATION SHOWN SHOULD BE REPORTED TO THE ENGINEER FOR REVIEW.
- DO NOT SCALE THIS DRAWING. ANY AMBIGUITIES, OMISSIONS AND ERRORS ON DRAWINGS SHALL BE BROUGHT TO THE ENGINEERS ATTENTION IMMEDIATELY. ALL DIMENSIONS MUST BE CHECKED / VERIFIED ON SITE.
- ALL DIMENSIONS ARE IN METRES AND LEVELS IN METRES ABOVE ORDNANCE DATUM UNLESS OTHERWISE NOTED.
- WHERE EXISTING DRAINAGE IS BEING USED, ALLOWANCES SHOULD BE MADE TO REMEDIATE THIS DRAINAGE IN LINE WITH AVAILABLE CCTV SURVEY INFORMATION. IF NO SURVEY IS AVAILABLE, IT IS ADVISED TO OBTAIN ONE PRIOR TO COMMENCEMENT OF WORKS.
- ALL EXISTING SERVICES TO BE LOCATED PRIOR TO COMMENCEMENT OF ANY DRAINAGE WORKS, AND WHERE NECESSARY PROTECTION OR DIVERSIONS TO BE UNDERTAKEN TO AVOID CONFLICT WITH THE PROPOSED WORK.
- FOUL POP UPS LOCATIONS AND SIZES TO BE CONFIRMED BY THE ARCHITECT.
- COVER LEVELS AND GROUND LEVELS ARE APPROXIMATE AND SHALL BE CONFIRMED BY ARCHITECT.
- ALL PIPE DIAMETERS GIVEN ARE NOMINAL INTERNAL PIPE DIAMETERS.
- OUTFALL CONNECTION(S) SUBJECT TO AGREEMENT WITH THE APPROVING AUTHORITY.

DRAINAGE BASED ON:

- ARCHITECTS PLANS
 - 1940_100 Proposed Site Plan June 2023.
- TOPO SURVEY
 - 11072_001B Topographical Survey by ND Oliver December 2022

P03	ISSUED FOR PLANNING	07/11/23	CG	CG
P02	ISSUED FOR REVIEW	03/11/23	CG	CG
P01	DRAFT FOR REVIEW	27/10/23	JC	CG
Rev:	Description:	Date:	By:	Chkd:

Curtins

Office
Telephone
Email
Web

Civils & Structures • Transport Planning • Environmental • Infrastructure • Geotechnical • Conservation & Heritage • Principal Designer
Birmingham • Bristol • Cambridge • Cardiff • Douglas • Dublin • Edinburgh • Glasgow • Kenton • Leeds • Liverpool • London • Manchester • Nottingham

Status: **SUITABLE FOR INFORMATION**

Project: **CROWN STREET**

Orig Title: **TEMPORARY PADEL COURT DRAINAGE STRATEGY**

Drawn By	Designed By	Checked By
JC	CG	CG
Date		Scales @ A1
27/10/23		1:200
Project No - Originator - Function - Spatial - Form - Discipline - Number		
082430 - CUR - XX - XX - DR - C - 92004		
Revision		
P03		

11 0 10 20 30 40 50 60 70 80 90 100

1:200

0 5m 10m 15m 20m

\\ms-fs-11\Pages\082430 - 083000\082430 - Crown Street 3 Plot D04-Production\4-Models Drawings\CAD\02