


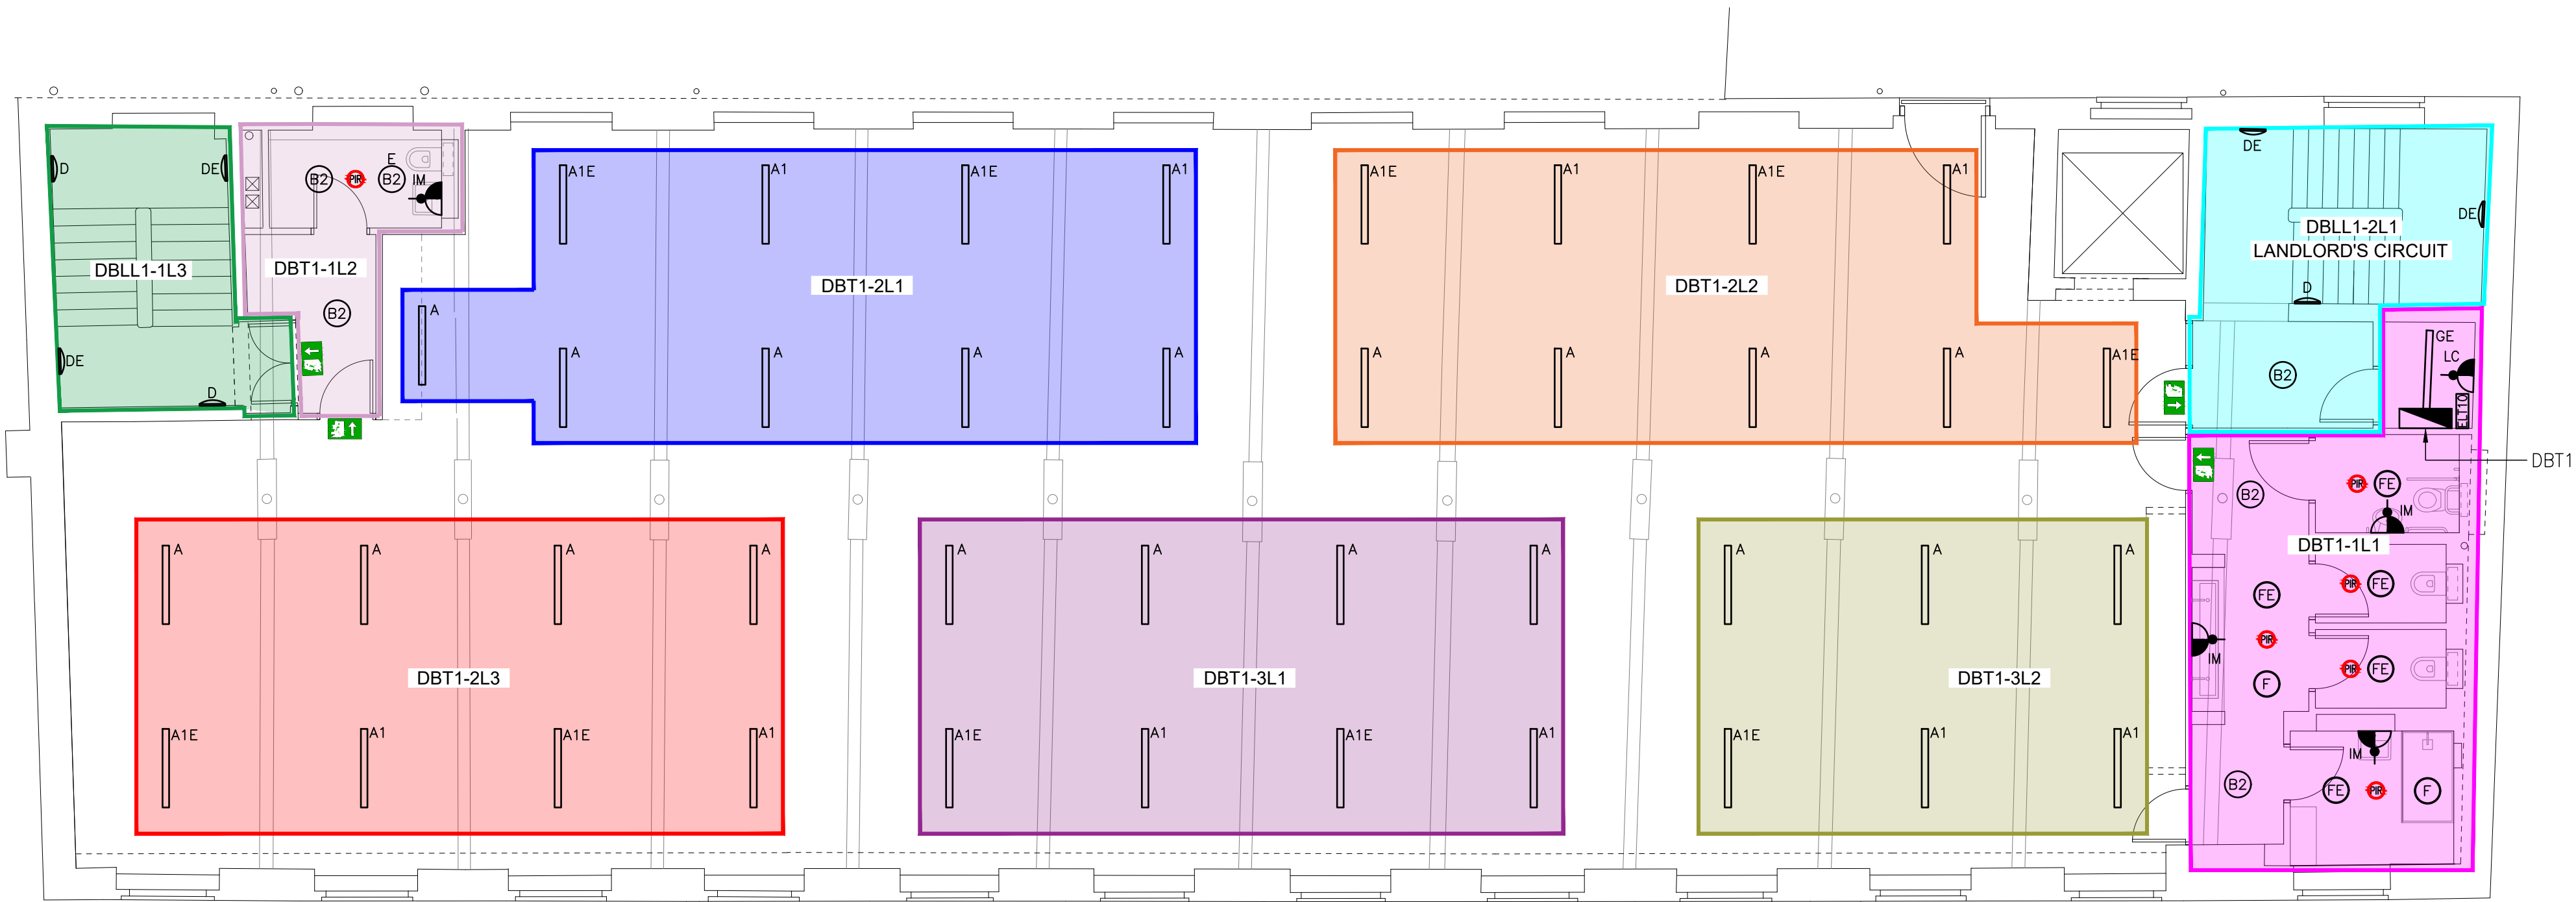

NOTES – LIGHTING

1. ALL PERIMETER SUSPENDED LUMINAIRES WITHIN OPEN PLAN FLOOR PLATES WILL BE CONFIGURED FOR DAYLIGHT HARVESTING VIA LOCAL PIR'S.
2. ALL GENERAL LIGHTING WILL BE CONTROLLED VIA LOCAL PIR'S.
3. ALL GENERAL LIGHTING WILL BE 230VOLT SWITCHING WITH NO DIMMING CAPABILITY.
4. ALL ELECTRICAL CIRCUITRY WILL BE INSTALLED IN ACCORDANCE WITH BS7671, 18th EDITION REGULATIONS.
5. STAIRCASES AND LOBBIES CLASSED AS LANDLORDS AREAS AND INSTALLED VIA LANDLORDS DB ON GROUND FLOOR.
6. ALL EMERGENCY LIGHTING WILL BE SUPPLIED VIA LOCAL LIGHTING CIRCUITRY IN ACCORDANCE WITH BS5839.
7. SINGLE POINT EMERGENCY TEST SWITCH LOCATED ADJACENT TENANT DB FOR FLOOR PLATE EMERGENCY LIGHTING TESTING.
8. LIGHTING CIRCUITRY DETAILS/ZONING TO BE ADDED FOLLOWING AGREEMENT AND COORDINATION.
9. DELIVERED GENERAL LIGHTING AND EMERGENCY LIGHTING LUX LEVELS TO BE ADDED TO AS FITTED DRAWINGS (DETAILED WITHIN LIGHTING CALCULATIONS).

LEGEND – LIGHTING

- A** P&A PROJECTS – SUBSPACE 70. SUSPENDED LED LUMINAIRE, 4000K, DIRECT/INDIRECT, NON–DIMMABLE, UGR19, BLACK FINISH (E DENOTES INTEGRAL EMERGENCY)
- A1** P&A PROJECTS – SUBSPACE 70. SUSPENDED LED LUMINAIRE, 4000K, DIRECT/INDIRECT, DIMMABLE, UGR19, BLACK FINISH, INTEGRAL DAYLIGHT PIR (E DENOTES INTEGRAL EMERGENCY)
- B** P&A PROJECTS – PAS–TL 125. SUSPENDED LED CAN LUMINAIRE, 4000K, NON–DIMMABLE, BLACK FINISH (E DENOTES INTEGRAL EMERGENCY)
- B1** P&A PROJECTS – PAS–TL 175. SUSPENDED LED CAN LUMINAIRE, 4000K, NON–DIMMABLE, BLACK FINISH (E DENOTES INTEGRAL EMERGENCY)
- B2** P&A PROJECTS – PAS–TL 90. SUSPENDED LED CAN LUMINAIRE, 4000K, NON–DIMMABLE, BLACK FINISH (E DENOTES INTEGRAL EMERGENCY)
- D** P&A PROJECTS – DECORATIVE CIRCULAR LED WALL LIGHT. BACK LIT, 4000K, NON–DIMMABLE, BLACK FINISH, INTEGRAL PIR'S (E DENOTES INTEGRAL EMERGENCY)
- D1** ANSELL – RECESSED LED DOWNLIGHT. WHITE BEZEL, 4000K, NON–DIMMABLE, (E DENOTES INTEGRAL EMERGENCY)
- D2** ROBUS – RECESSED LED DOWNLIGHT. IP65 RATED, 4000K, NON–DIMMABLE
- D3** ANSELL – TORNADO. 1500mm SUSPENDED LED BATTEN LUMINAIRE, 4000K, NON–DIMMABLE, IP RATED, INTEGRAL PIR (E DENOTES INTEGRAL EMERGENCY)
- H** ANSELL – GAMMA. LED WALL LIGHT, BLACK BEZEL, 4000K, NON–DIMMABLE (E DENOTES INTEGRAL EMERGENCY)
- K** FEATURE UP/DOWN LED WALL LIGHT – SUPPLIER TBC, SAMPLE TO BE APPROVED BY CLIENT
- L1** P&A PROJECTS – SUBSPACE 70. SURFACE MOUNTED OR SUSPENDED LED LINEAR LUMINAIRE, 4000K, DIMMABLE, BLACK FINISH (E DENOTES INTEGRAL EMERGENCY)
- N** FEATURE PENDANT OVER CAFE SERVERY – SPEC TBC
- D500** DIRECTIONAL LED TRACK SPOT LUMINAIRE (CAFE), BLACK SUSPENDED LIGHTING TRACK, 4000K, NON–DIMMABLE
- TB TS** SUSPENDED LIGHTING/MAGNETIC TRACK SYSTEM – CLIENT SIGN OFF REQUIRED FOLLOWING SAMPLE REVIEW
- E11** ANSELL – EAGLE. SUSPENDED/SURFACE MOUNTED LED EMERGENCY EXIT SIGN, 3HR MAINTAINED
- E12** ANSELL – IP65 BULKHEAD. 3HR NON–MAINTAINED EMERGENCY BULKHEAD OVER FINAL EXIT
- E10** RECESSED LED 3HR NON–MAINTAINED EMERGENCY LUMINAIRE
- E20** TRACK MOUNTED LED 3HR NON–MAINTAINED TRACK MOUNTED EMERGENCY LUMINAIRE

LEGEND – LIGHTING CONTROLS

- LS** LIGHT SWITCH
- CP** CP ELECTRONICS – RECESSED/SURFACE MOUNTED PRESENCE DETECTOR
- MD** CP ELECTRONICS – MICROWAVE DETECTOR
- ETSW** EMERGENCY LIGHTING TEST SWITCH
- WSP** WALL MOUNTED SCENE PLATE FOR MEETING ROOM LIGHTING CONTROLS

D	UPDATED TO CLIENT COMMENTS	11.12.23
Revision	Description	Date



Drawing Status
PROPOSED



Client
WORKSPACE DESIGN & BUILD

Project
NEPTUNE MILL

Title
FIRST FLOOR
LIGHTING & EMERGENCY
LIGHTING LAYOUT

Drawn LY Date 11.12.23

Sheet A1

Scale 1:75

Drawing Number
H&O–J369–L01–D



LEGEND – LIGHTING

- A** P&A PROJECTS – SUBSPACE 70. SUSPENDED LED LUMINAIRE, 4000K, DIRECT/INDIRECT, NON–DIMMABLE, UGR19, BLACK FINISH (E DENOTES INTEGRAL EMERGENCY)
- A1** P&A PROJECTS – SUBSPACE 70. SUSPENDED LED LUMINAIRE, 4000K, DIRECT/INDIRECT, DIMMABLE, UGR19, BLACK FINISH, INTEGRAL DAYLIGHT PIR (E DENOTES INTEGRAL EMERGENCY)
- Ⓢ** P&A PROJECTS – PAS–TL 125. SUSPENDED LED CAN LUMINAIRE, 4000K, NON–DIMMABLE, BLACK FINISH (E DENOTES INTEGRAL EMERGENCY)
- Ⓢ** P&A PROJECTS – PAS–TL 175. SUSPENDED LED CAN LUMINAIRE, 4000K, NON–DIMMABLE, BLACK FINISH (E DENOTES INTEGRAL EMERGENCY)
- Ⓢ** P&A PROJECTS – PAS–TL 90. SUSPENDED LED CAN LUMINAIRE, 4000K, NON–DIMMABLE, BLACK FINISH (E DENOTES INTEGRAL EMERGENCY)
- Ⓢ/P** P&A PROJECTS – DECORATIVE CIRCULAR LED WALL LIGHT. BACK LIT, 4000K, NON–DIMMABLE, BLACK FINISH, INTEGRAL PIR'S (E DENOTES INTEGRAL EMERGENCY)
- Ⓢ** ANSELL – RECESSED LED DOWNLIGHT. WHITE BEZEL, 4000K, NON–DIMMABLE, (E DENOTES INTEGRAL EMERGENCY)
- Ⓢ** ROBUS – RECESSED LED DOWNLIGHT. IP65 RATED, 4000K, NON–DIMMABLE
- Ⓢ** ANSELL – TORNADO. 1500mm SUSPENDED LED BATTEN LUMINAIRE, 4000K, NON–DIMMABLE, IP RATED, INTEGRAL PIR (E DENOTES INTEGRAL EMERGENCY)
- Ⓢ** ANSELL – GAMMA. LED WALL LIGHT, BLACK BEZEL, 4000K, NON–DIMMABLE (E DENOTES INTEGRAL EMERGENCY)
- K** FEATURE UP/DOWN LED WALL LIGHT – SUPPLIER TBC, SAMPLE TO BE APPROVED BY CLIENT
- L** P&A PROJECTS – SUBSPACE 70. SURFACE MOUNTED OR SUSPENDED LED LINEAR LUMINAIRE, 4000K, DIMMABLE, BLACK FINISH (E DENOTES INTEGRAL EMERGENCY)
- Ⓢ** FEATURE PENDANT OVER CAFE SERVERY – SPEC TBC
- Ⓢ** DIRECTIONAL LED TRACK SPOT LUMINAIRE (CAFE), BLACK SUSPENDED LIGHTING TRACK, 4000K, NON–DIMMABLE
- Ⓢ** SUSPENDED LIGHTING/MAGNETIC TRACK SYSTEM – CLIENT SIGN OFF REQUIRED FOLLOWING SAMPLE REVIEW
- Ⓢ** ANSELL – EAGLE. SUSPENDED/SURFACE MOUNTED LED EMERGENCY EXIT SIGN, 3HR MAINTAINED
- Ⓢ** ANSELL – IP65 BULKHEAD. 3HR NON–MAINTAINED EMERGENCY BULKHEAD OVER FINAL EXIT
- E1** RECESSED LED 3HR NON–MAINTAINED EMERGENCY LUMINAIRE
- E2** TRACK MOUNTED LED 3HR NON–MAINTAINED TRACK MOUNTED EMERGENCY LUMINAIRE

LEGEND – LIGHTING CONTROLS

- Ⓢ** LIGHT SWITCH
- Ⓢ** CP ELECTRONICS – RECESSED/SURFACE MOUNTED PRESENCE DETECTOR
- Ⓢ** CP ELECTRONICS – MICROWAVE DETECTOR
- Ⓢ** EMERGENCY LIGHTING TEST SWITCH
- Ⓢ** WALL MOUNTED SCENE PLATE FOR MEETING ROOM LIGHTING CONTROLS

NOTES – LIGHTING

- ALL PERIMETER SUSPENDED LUMINAIRES WITHIN OPEN PLAN FLOOR PLATES WILL BE CONFIGURED FOR DAYLIGHT HARVESTING VIA LOCAL PIR'S.
- ALL GENERAL LIGHTING WILL BE CONTROLLED VIA LOCAL PIR'S.
- ALL GENERAL LIGHTING WILL BE 230VOLT SWITCHING WITH NO DIMMING CAPABILITY.
- ALL ELECTRICAL CIRCUITRY WILL BE INSTALLED IN ACCORDANCE WITH BS7671, 18th EDITION REGULATIONS.
- STAIRCASES AND LOBBIES CLASSED AS LANDLORDS AREAS AND INSTALLED VIA LANDLORDS DB ON GROUND FLOOR.
- ALL EMERGENCY LIGHTING WILL BE SUPPLIED VIA LOCAL LIGHTING CIRCUITRY IN ACCORDANCE WITH BS5839.
- SINGLE POINT EMERGENCY TEST SWITCH LOCATED ADJACENT TENANT DB FOR FLOOR PLATE EMERGENCY LIGHTING TESTING.
- LIGHTING CIRCUITRY DETAILS/ZONING TO BE ADDED FOLLOWING AGREEMENT AND COORDINATION.
- DELIVERED GENERAL LIGHTING AND EMERGENCY LIGHTING LUX LEVELS TO BE ADDED TO AS FITTED DRAWINGS (DETAILED WITHIN LIGHTING CALCULATIONS).

D	UPDATED TO CLIENT COMMENTS	11.12.23
Revision	Description	Date



Drawing Status	PROPOSED
----------------	----------



Client	WORKSPACE DESIGN & BUILD
--------	--------------------------

Project	NEPTUNE MILL
---------	--------------

Title	SECOND FLOOR LIGHTING & EMERGENCY LIGHTING LAYOUT
-------	---

Drawn	LY	Date	11.12.23
-------	----	------	----------

Sheet	A1
-------	----

Scale	1:75
-------	------

Drawing Number	H&O–J369–L02–D
----------------	----------------



NOTES – LIGHTING

1. ALL PERIMETER SUSPENDED LUMINAIRES WITHIN OPEN PLAN FLOOR PLATES WILL BE CONFIGURED FOR DAYLIGHT HARVESTING VIA LOCAL PIR'S.
2. ALL GENERAL LIGHTING WILL BE CONTROLLED VIA LOCAL PIR'S.
3. ALL GENERAL LIGHTING WILL BE 230VOLT SWITCHING WITH NO DIMMING CAPABILITY.
4. ALL ELECTRICAL CIRCUITRY WILL BE INSTALLED IN ACCORDANCE WITH BS7671, 18th EDITION REGULATIONS.
5. STAIRCASES AND LOBBIES CLASSED AS LANDLORDS AREAS AND INSTALLED VIA LANDLORDS DB ON GROUND FLOOR.
6. ALL EMERGENCY LIGHTING WILL BE SUPPLIED VIA LOCAL LIGHTING CIRCUITRY IN ACCORDANCE WITH BS5839.
7. SINGLE POINT EMERGENCY TEST SWITCH LOCATED ADJACENT TENANT DB FOR FLOOR PLATE EMERGENCY LIGHTING TESTING.
8. LIGHTING CIRCUITRY DETAILS/ZONING TO BE ADDED FOLLOWING AGREEMENT AND COORDINATION.
9. DELIVERED GENERAL LIGHTING AND EMERGENCY LIGHTING LUX LEVELS TO BE ADDED TO AS FITTED DRAWINGS (DETAILED WITHIN LIGHTING CALCULATIONS).

LEGEND – LIGHTING

P&A PROJECTS - SUBSPACE 70. SUSPENDED
LED LUMINAIRE, 4000K, DIRECT/INDIRECT,
NON-DIMMABLE, UGR19, BLACK FINISH (E
DENOTES INTEGRAL EMERGENCY)

A1  P&A PROJECTS – SUBSPACE 70. SUSPENDED
LED LUMINAIRE, 4000K, DIRECT/INDIRECT,
DIMMABLE, UGR19, BLACK FINISH, INTEGRAL
DAYLIGHT PIR (E DENOTES INTEGRAL
EMERGENCY)

⑤ P&A PROJECTS - PAS-TL 125. SUSPENDED LED CAN LUMINAIRE, 4000K, NON-DIMMABLE, BLACK FINISH (E DENOTES INTEGRAL EMERGENCY)

⑧1 P&A PROJECTS - PAS-TL 175. SUSPENDED
LED CAN LUMINAIRE, 4000K, NON-DIMMABLE,
BLACK FINISH (E DENOTES INTEGRAL
EMERGENCY)

(B2) P&A PROJECTS - PAS-TL 90. SUSPENDED LED CAN LUMINAIRE, 4000K, NON-DIMMABLE, BLACK FINISH (E DENOTES INTEGRAL EMERGENCY)

 P&A PROJECTS – DECORATIVE CIRCULAR LED WALL LIGHT. BACK LIT, 4000K, NON-DIMMABLE. BLACK FINISH, INTEGRAL PIR'S (E DENOTES INTEGRAL EMERGENCY)

(F) ANSELL - RECESSED LED DOWNLIGHT. WHITE BEZEL, 4000K, NON-DIMMABLE, (E DENOTES INTEGRAL EMERGENCY)

Ⓡ ROBUS – RECESSED LED DOWNLIGHT. IP65 RATED, 4000K, NON-DIMMABLE

G ANSELL - TORNADO. 1500mm SUSPENDED
LED BATTEN LUMINAIRE, 4000K, NON-
DIMMABLE, IP RATED, INTEGRAL PIR (E
DENOTES INTEGRAL EMERGENCY)

(H) ANSELL - GAMMA. LED WALL LIGHT, BLACK BEZEL, 4000K, NON-DIMMABLE (E DENOTES INTEGRAL EMERGENCY)

K FEATURE UP/DOWN LED WALL LIGHT –
SUPPLIER TBC, SAMPLE TO BE APPROVED BY
CLIENT

L1 P&A PROJECTS – SUBSPACE 70. SURFACE MOUNTED OR SUSPENDED LED LINEAR LUMINAIRE, 4000K, DIMMABLE, BLACK FINISH (DENOTES INTEGRAL EMERGENCY)

(N) FEATURE PENDANT OVER CAFE SERVERY – SPEC TBC

D50 DIRECTIONAL LED TRACK SPOT LUMINAIRE (CAFE), BLACK SUSPENDED LIGHTING TRACK, 4000K, NON-DIMMABLE

TB TS SUSPENDED LIGHTING/MAGNETIC TRACK SYSTEM
- CLIENT SIGN OFF REQUIRED FOLLOWING
SAMPLE REVIEW

 ANSELL – EAGLE. SUSPENDED/SURFACE MOUNTED LED EMERGENCY EXIT SIGN, 3HR MAINTAINED

 ANSELL - IP65 BULKHEAD. 3HR NON-MAINTAINED EMERGENCY BULKHEAD OVER FINAL EXIT

E10 RECESSED LED 3HR NON-MAINTAINED
EMERGENCY LUMINAIRE

E20	TRACK MOUNTED LED 3HR NON-MAINTAINED TRACK MOUNTED EMERGENCY LUMINAIRE
-----	---

LEGEND – LIGHTING CONTROLS

 LIGHT SWITCH

CP ELECTRONICS – RECESSED/SURFACE MOUNTED PRESENCE DETECTOR

CP ELECTRONICS – MICROWAVE DETECTOR

EMERGENCY LIGHTING TEST SWITCH

WALL MOUNTED SCENE PLATE FOR MEETING ROOM LIGHTING CONTROLS

D	UPDATED TO CLIENT COMMENTS	11.12.2023
Revision	Description	Date



Drawing Status PROPOSED



Client **WORKSPACE DESIGN & BUILD**

Project NEPTUNE MILL


Title THIRD FLOOR
LIGHTING & EMERGENCY
LIGHTING LAYOUT

Drawn LY Date 11.12.23

Sheet A1

Scale 1:75

Drawing Number
H&O-J369-L03-D

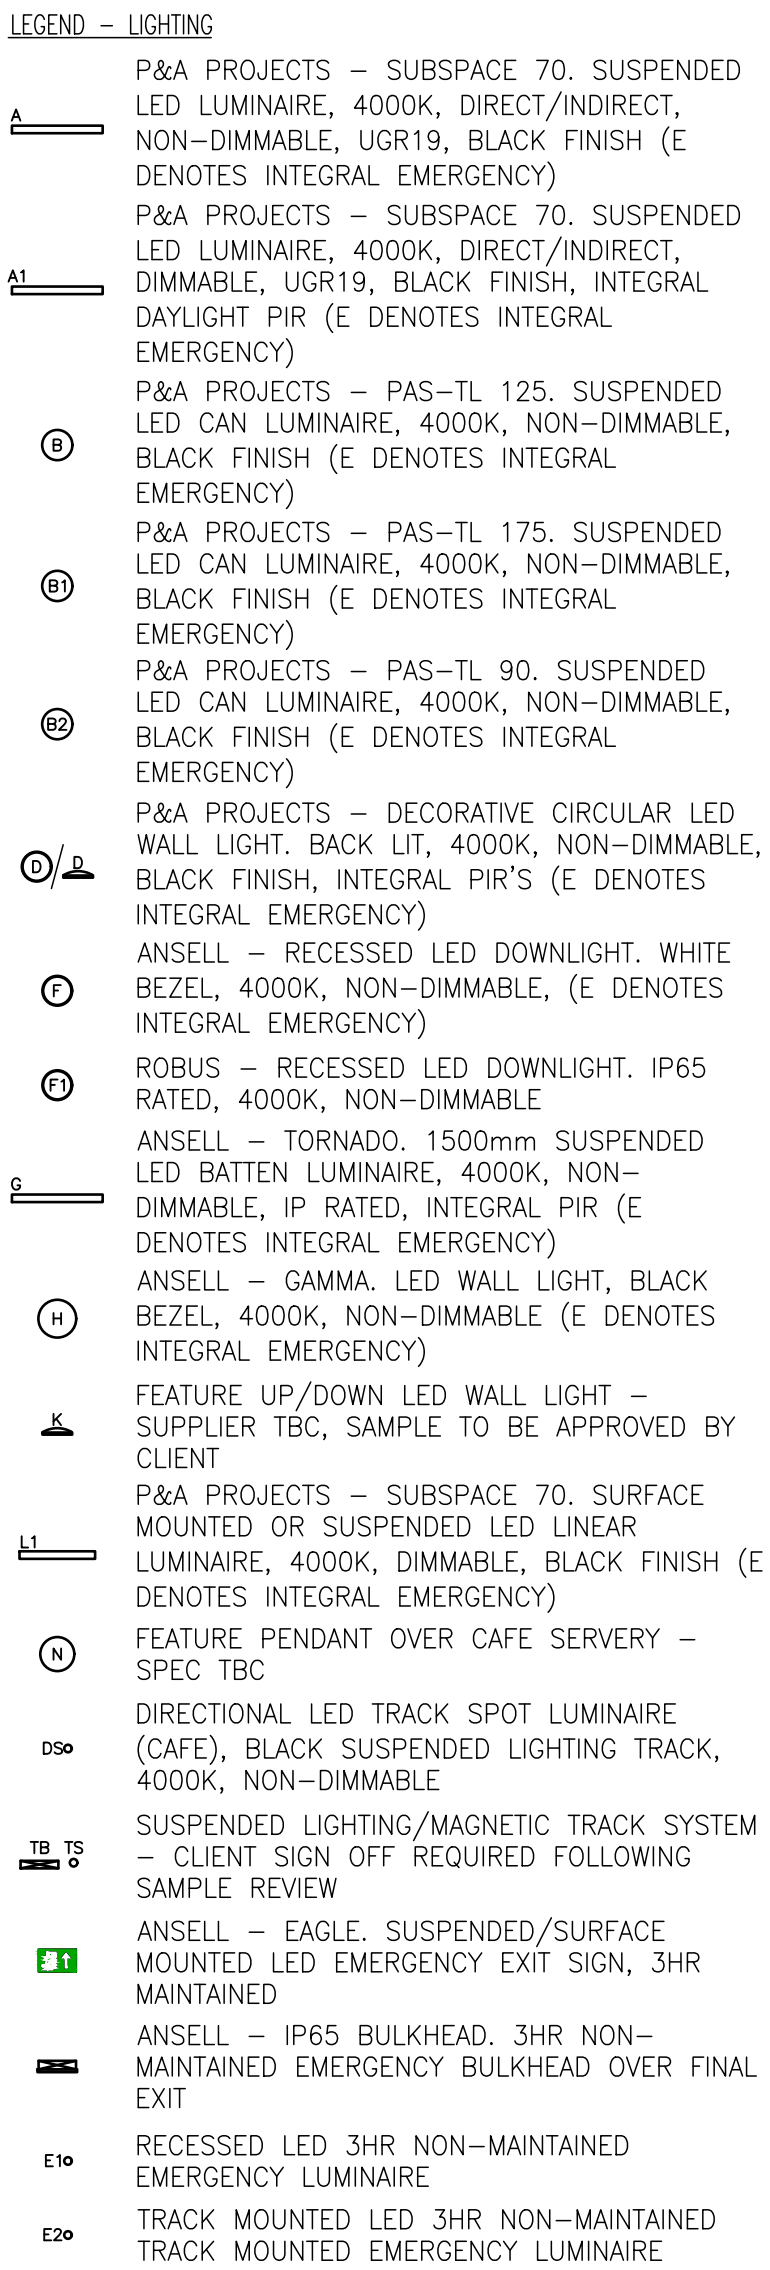

- LIGHT SWITCH
- CP ELECTRONICS – RECESSED/SURFACE MOUNTED PRESENCE DETECTOR
- CP ELECTRONICS – MICROWAVE DETECTOR
- EMERGENCY LIGHTING TEST SWITCH
- WALL MOUNTED SCENE PLATE FOR MEETING ROOM LIGHTING CONTROLS




Project NEPTUNE MILL

Drawn LY Date 11.12.23
Sheet A1

Scale 1:75

Drawing Number
H&O-J369-L04-C

1. ALL PERIMETER SUSPENDED LUMINAIRES WITHIN OPEN PLAN FLOOR PLATES WILL BE CONFIGURED FOR DAYLIGHT HARVESTING VIA LOCAL PIR'S.
2. ALL GENERAL LIGHTING WILL BE CONTROLLED VIA LOCAL PIR'S.
3. ALL GENERAL LIGHTING WILL BE 230VOLT SWITCHING WITH NO DIMMING CAPABILITY.
4. ALL ELECTRICAL CIRCUITRY WILL BE INSTALLED IN ACCORDANCE WITH BS7671, 18th EDITION REGULATIONS.
5. STAIRCASES AND LOBBIES CLASSED AS LANDLORDS AREAS AND INSTALLED VIA LANDLORDS DB ON GROUND FLOOR.
6. ALL EMERGENCY LIGHTING WILL BE SUPPLIED VIA LOCAL LIGHTING CIRCUITRY IN ACCORDANCE WITH BS5839.
7. SINGLE POINT EMERGENCY TEST SWITCH LOCATED ADJACENT TENANT DB FOR FLOOR PLATE EMERGENCY LIGHTING TESTING.
8. LIGHTING CIRCUITRY DETAILS/ZONING TO BE ADDED FOLLOWING AGREEMENT AND COORDINATION.
9. DELIVERED GENERAL LIGHTING AND EMERGENCY LIGHTING LUX LEVELS TO BE ADDED TO AS FITTED DRAWINGS (DETAILED WITHIN LIGHTING CALCULATIONS).

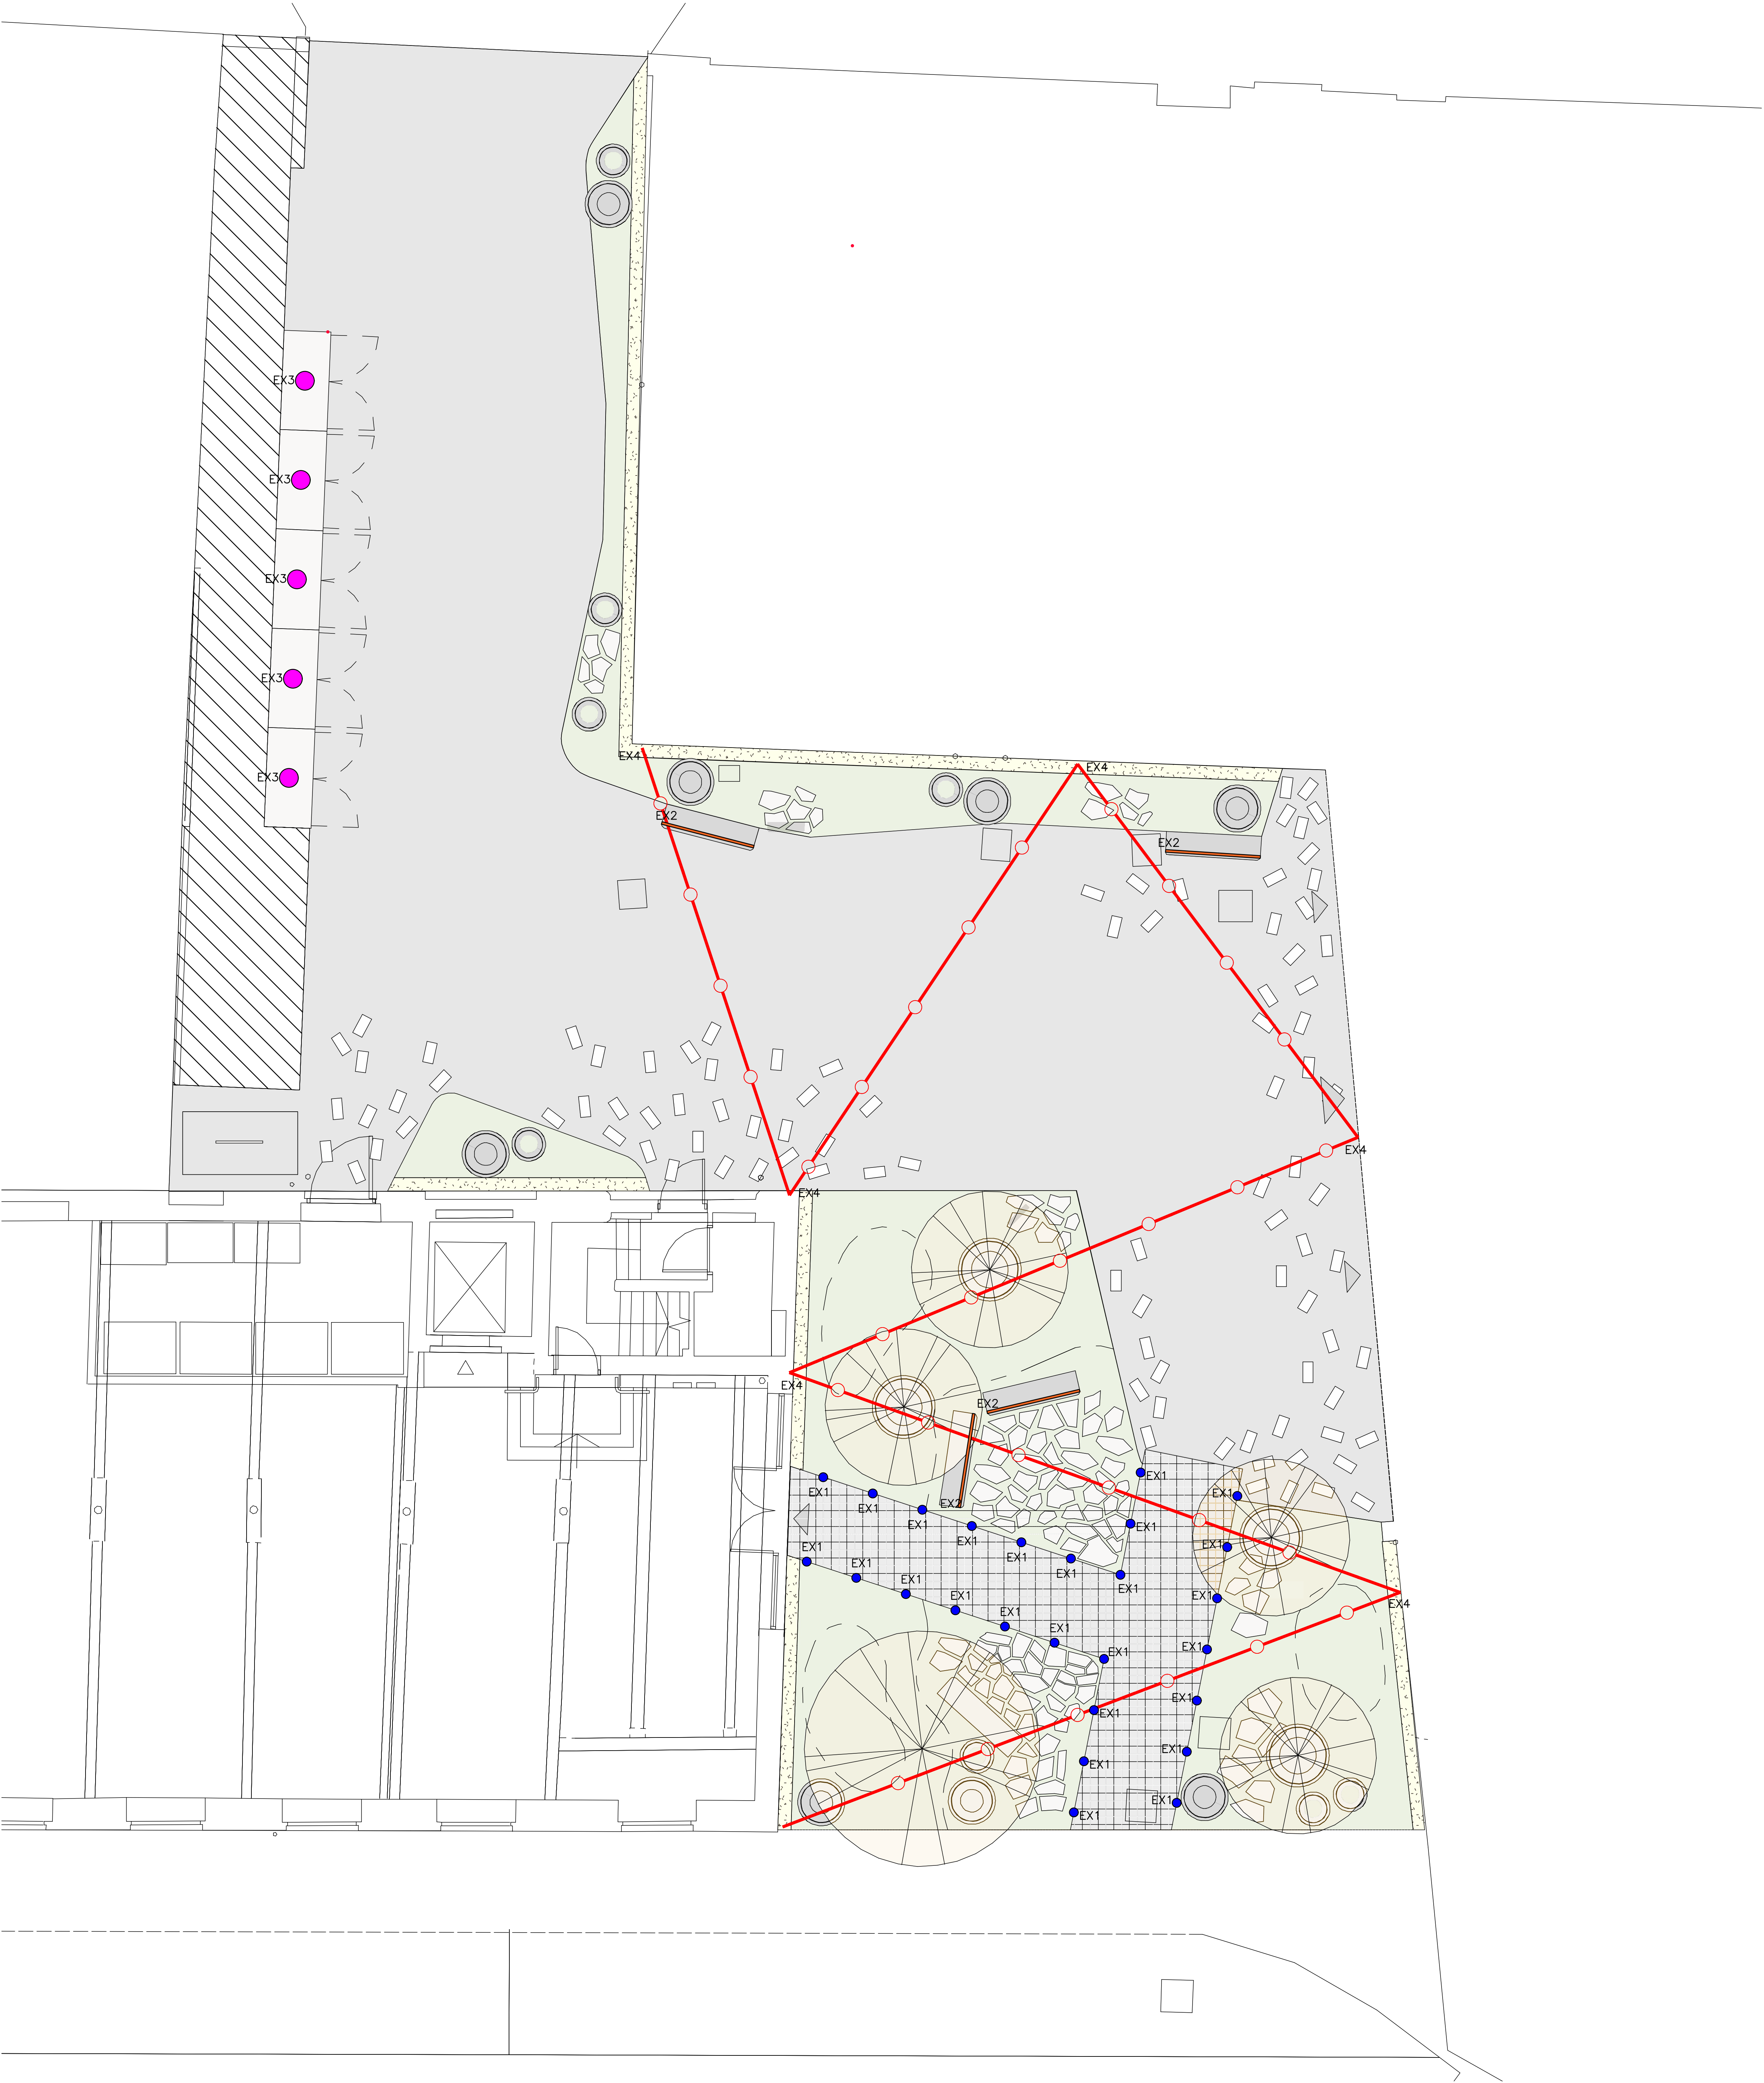


- LEGEND – EXTERIOR LIGHTING
- EX1 BEGA LIGHTING, 24085 – 3000K
 - EX2 BEGA LIGHTING, 22261 – 3000K
 - EX3 SLV LIGHTING, DASAR 1200 – 3000K
 - EX4 COLLINGWOOD LIGHTING, LEDLINE 400 WW 45
 - EX5 TAGRA LIGHTING, IP RATED LED STRIP LIGHTING – 3000K
- LEGEND – SMALL POWER
- SWITCHED FUSE CONNECTION UNIT
- LEGEND – EXTERNAL LIGHTING
- EX1 COLLINGWOOD – GLO19
 - EX2 TAGRA LIGHTING – IP RATED LED STRIP LIGHTING
 - EX3 SLV LIGHTING – OUTSIDE BULKHEAD 360
 - EX4 TAGRA LIGHTING – PRO CONNECTABLE FESTOON (VARYING LENGTHS)


A	PRELIMINARY ISSUED FOR COMMENT	01.12.23
Revision	Description	Date
		
Drawing Status	PROPOSED	
		
Client	WORKSPACE DESIGN & BUILD	
Project	NEPTUNE MILL	
Title	EXTERNAL LIGHTING LAYOUT	
Drawn	LY	Date 01.12.23
Sheet	A0	
Scale	1:50	
Drawing Number	H&O–J369–LEX2–A	




SOUTH ELEVATION

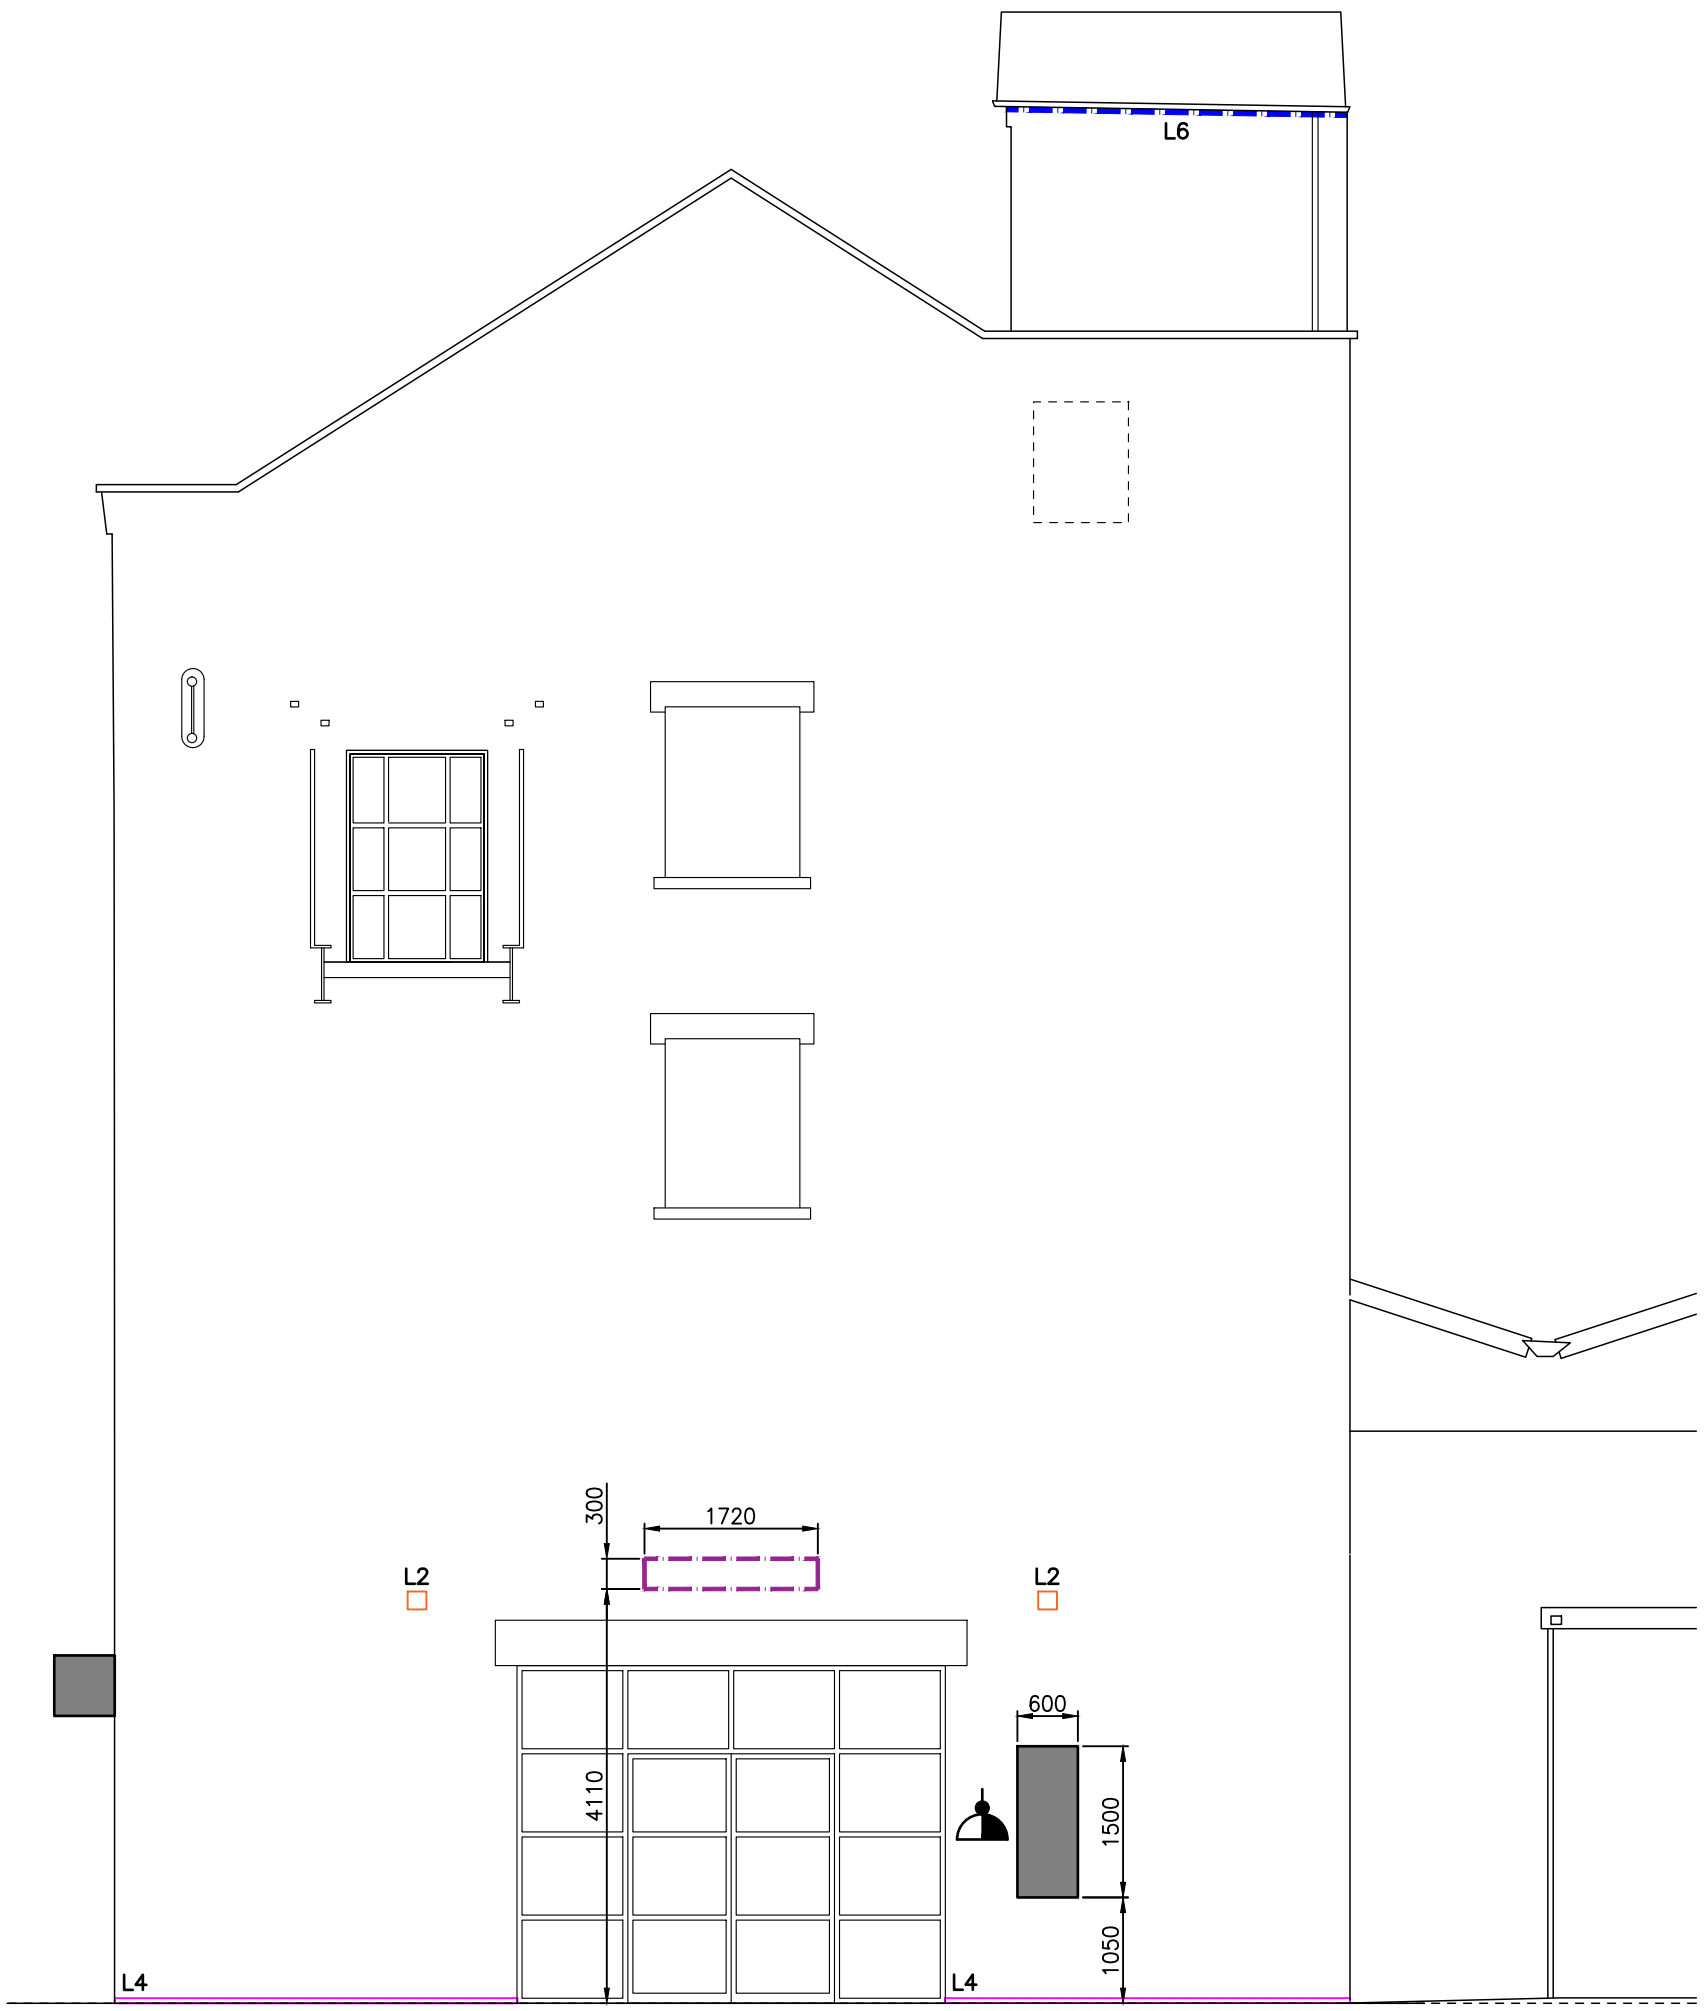

EAST ELEVATION

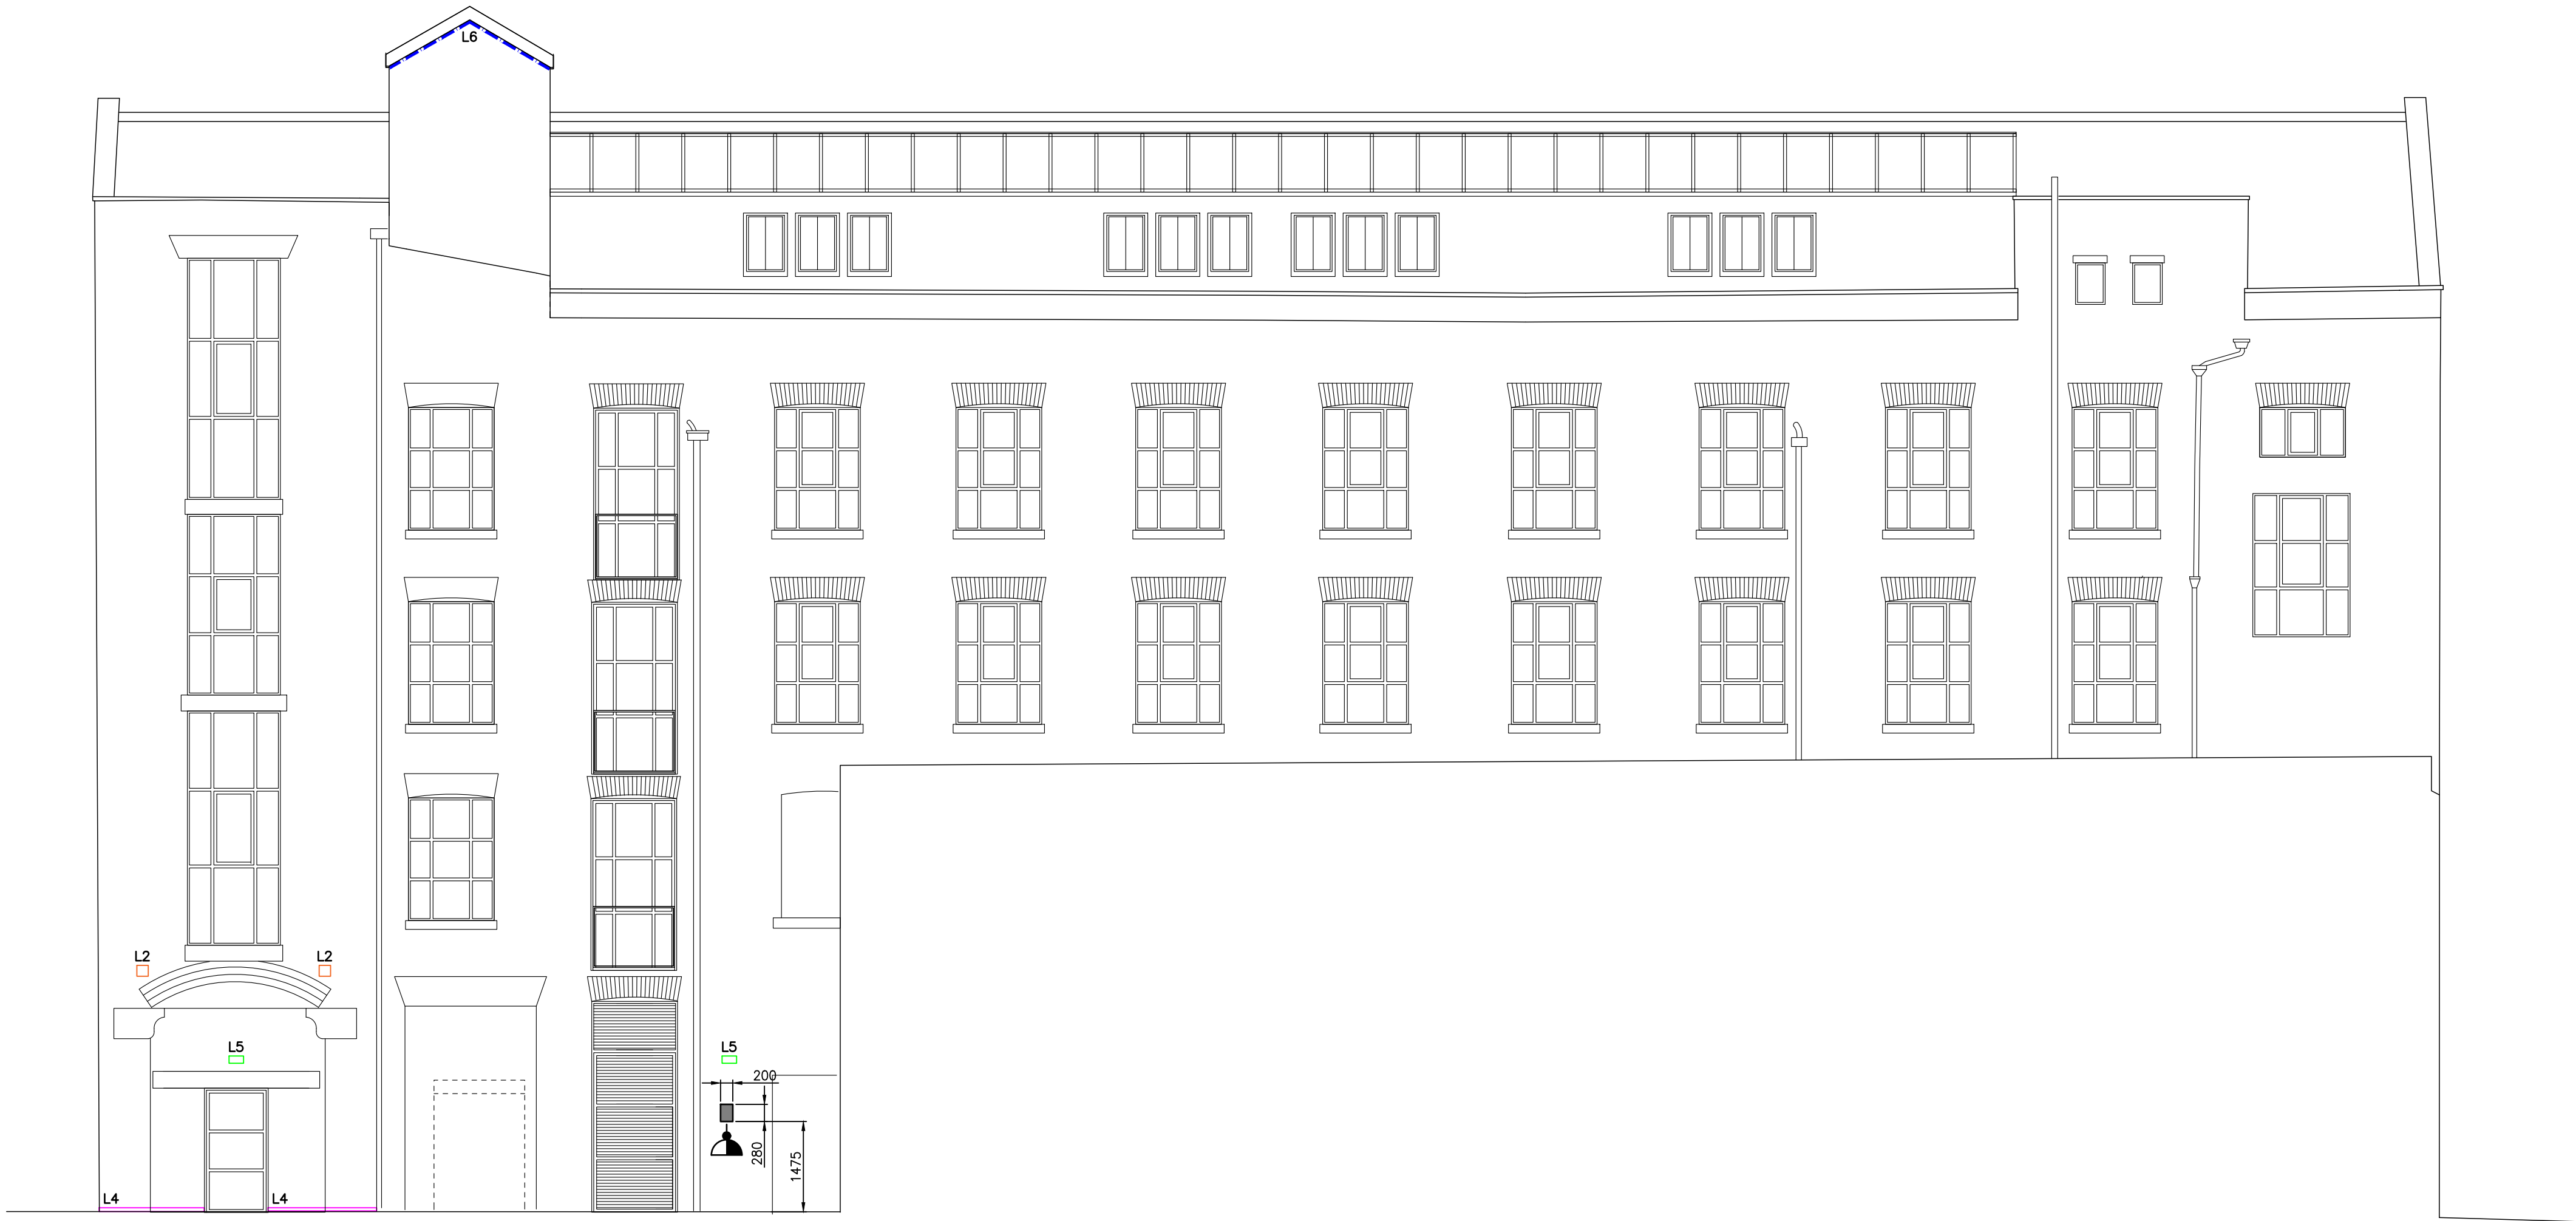

NORTH ELEVATION

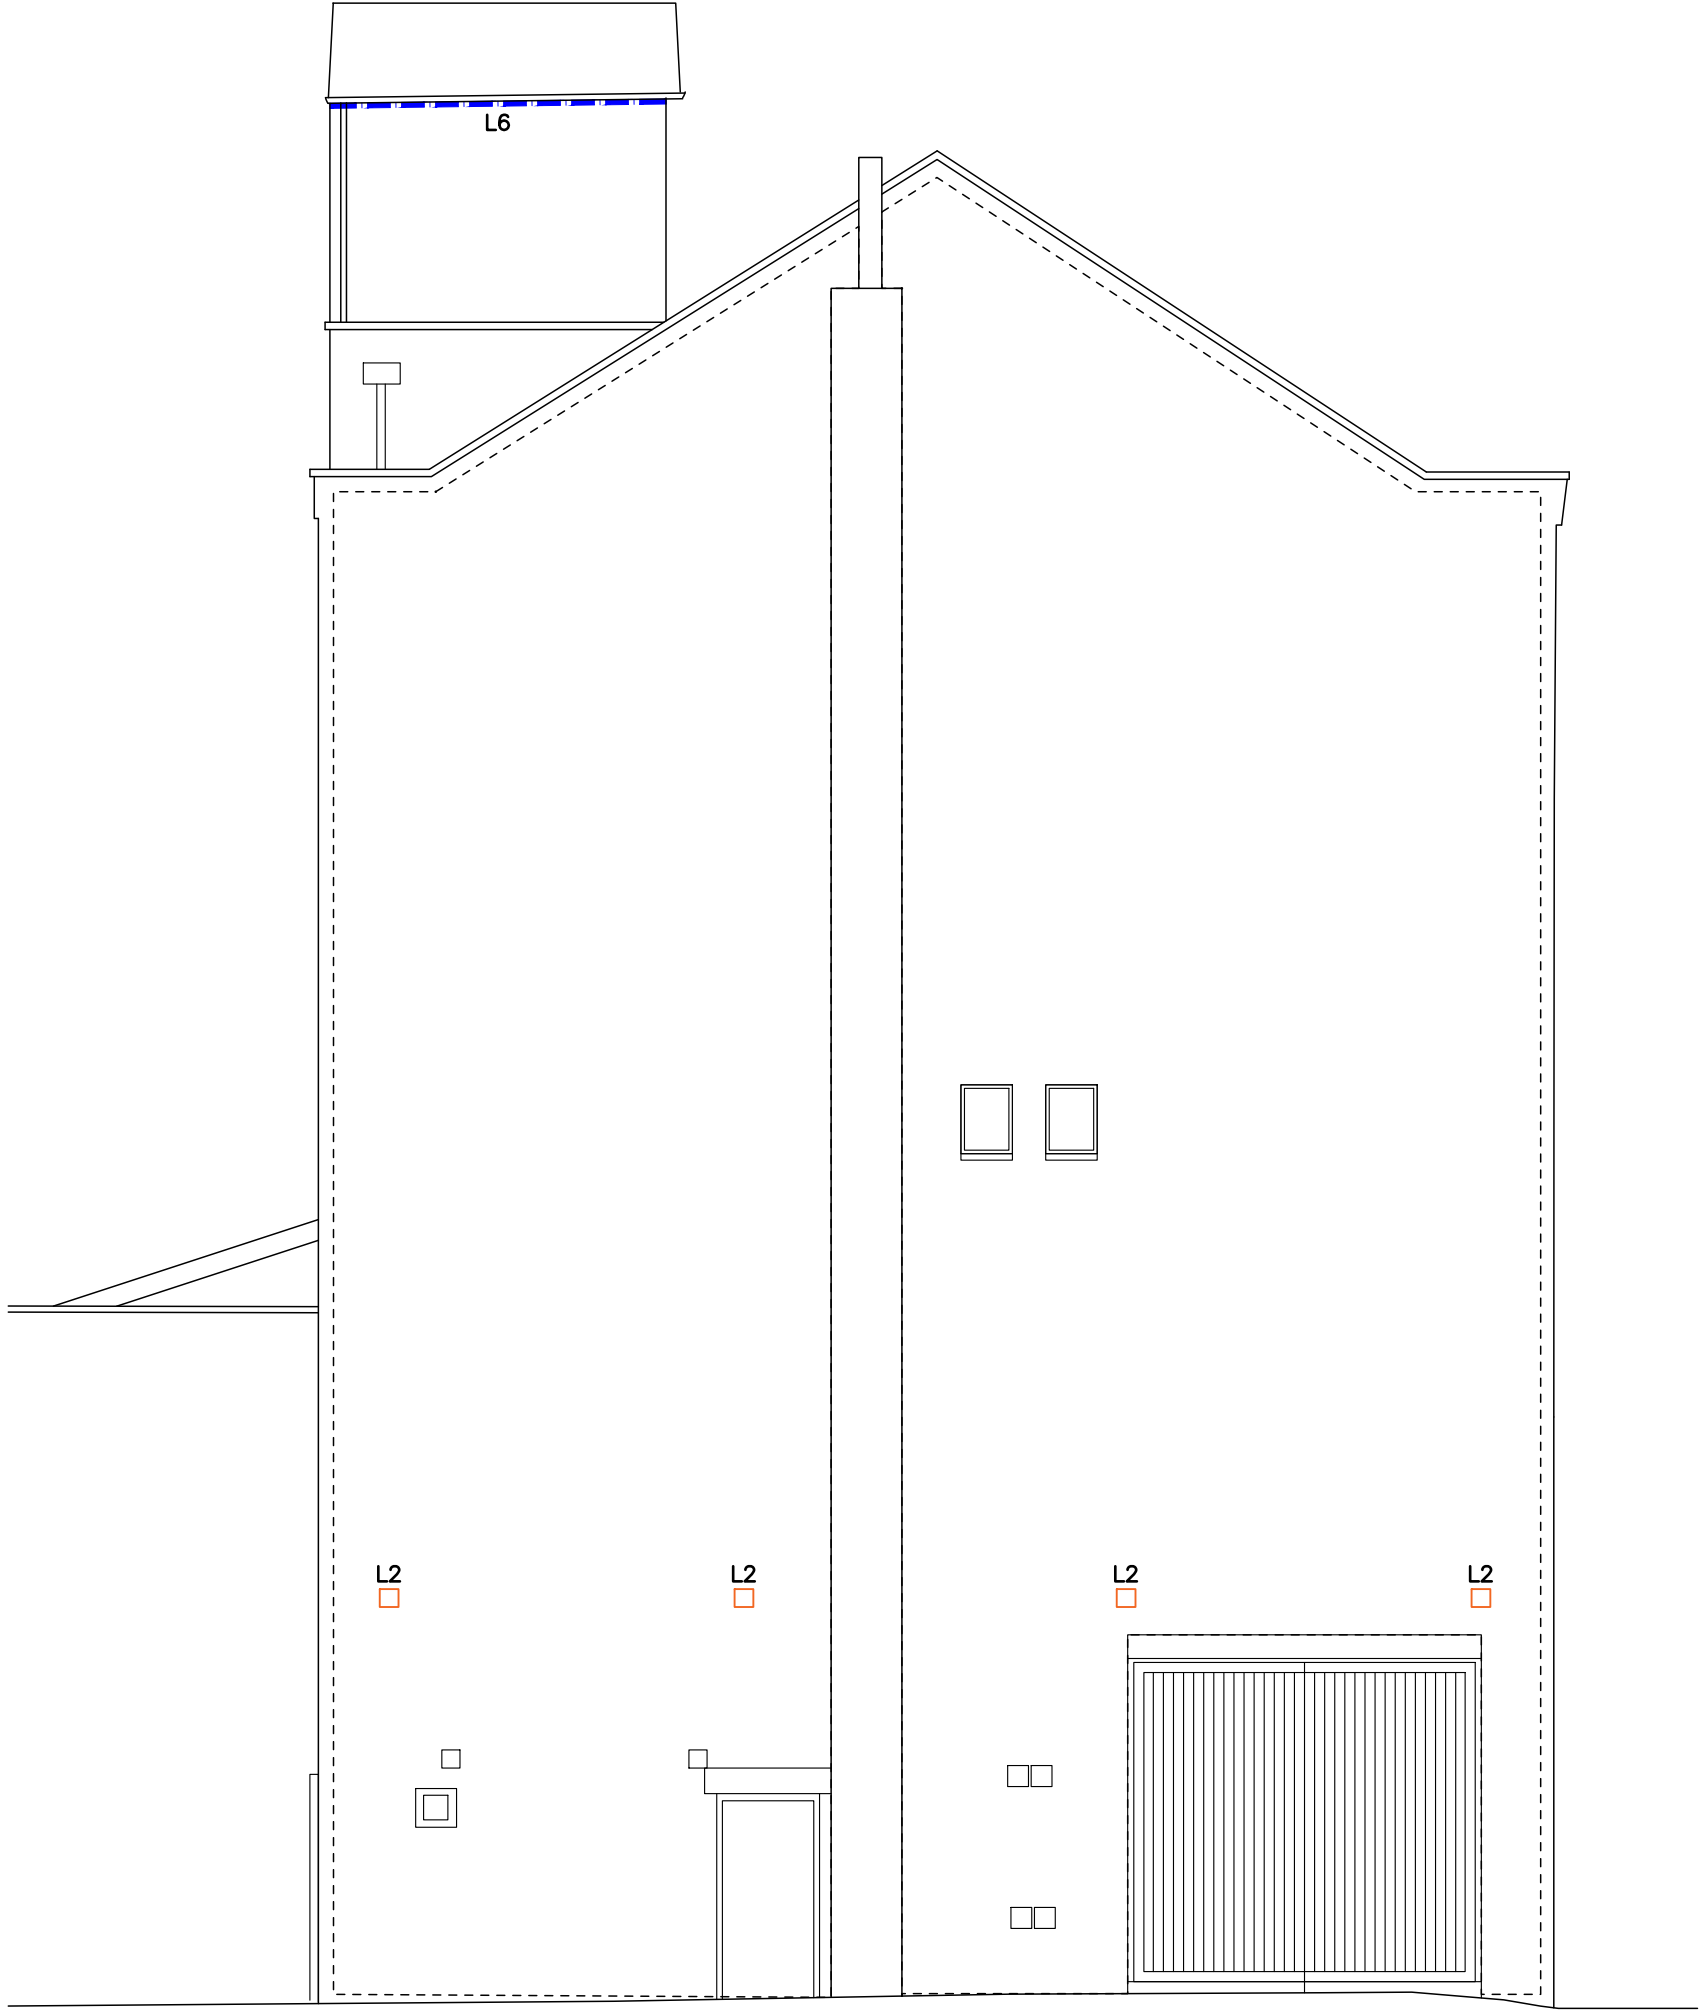


WEST ELEVATION

- LEGEND – EXTERIOR LIGHTING
- L1 BEGA LIGHTING, 24085 – 3000K
 - L2 BEGA LIGHTING, 22261 – 3000K
 - L3 SLV LIGHTING, DASAR 1200 – 3000K
 - L4 COLLINGWOOD LIGHTING, LEDLINE 400 WW 45
 - L5 TAGRA LIGHTING, IP RATED LED STRIP LIGHTING – 3000K
- LEGEND – SMALL POWER
- SWITCHED FUSE CONNECTION UNIT
- LEGEND – EXTERNAL LIGHTING
- COLLINGWOOD – GLO19
 - TAGRA LIGHTING – IP RATED LED STRIP LIGHTING
 - SLV LIGHTING – OUTSIDE BULKHEAD 360
 - TAGRA LIGHTING – PRO CONNECTABLE FESTOON (VARYING LENGTHS)

A	PRELIMINARY ISSUED FOR COMMENT	01.12.23
Revision	Description	Date
		
Drawing Status	PROPOSED	
		
Client	WORKSPACE DESIGN & BUILD	
Project	NEPTUNE MILL	
Title	EXTERIOR LIGHTING LAYOUT	
Drawn	LY	Date 01.12.23
Sheet	A0	
Scale	1:75	
Drawing Number	H&O–J369–LEX–A	

NOTES — LIGHTING

1. ALL PERIMETER SUSPENDED LUMINAIRES WITHIN OPEN PLAN FLOOR PLATES WILL BE CONFIGURED FOR DAYLIGHT HARVESTING VIA LOCAL PIR'S.
2. ALL GENERAL LIGHTING WILL BE CONTROLLED VIA LOCAL PIR'S.
3. ALL GENERAL LIGHTING WILL BE 230VOLT SWITCHING WITH NO DIMMING CAPABILITY.
4. ALL ELECTRICAL CIRCUITRY WILL BE INSTALLED IN ACCORDANCE WITH BS7671, 18th EDITION REGULATIONS.
5. STAIRCASES AND LOBBIES CLASSSED AS LANDLORDS AREAS AND INSTALLED VIA LANDLORDS DB ON GROUND FLOOR.
6. ALL EMERGENCY LIGHTING WILL BE SUPPLIED VIA LOCAL LIGHTING CIRCUITRY IN ACCORDANCE WITH BS5839.
7. SINGLE POINT EMERGENCY TEST SWITCH LOCATED ADJACENT TENANT DB FOR FLOOR PLATE EMERGENCY LIGHTING TESTING.
8. LIGHTING CIRCUITRY DETAILS/ZONING TO BE ADDED FOLLOWING AGREEMENT AND COORDINATION.
9. DELIVERED GENERAL LIGHTING AND EMERGENCY LIGHTING LUX LEVELS TO BE ADDED TO AS FITTED DRAWINGS (DETAILED WITHIN LIGHTING CALCULATIONS).

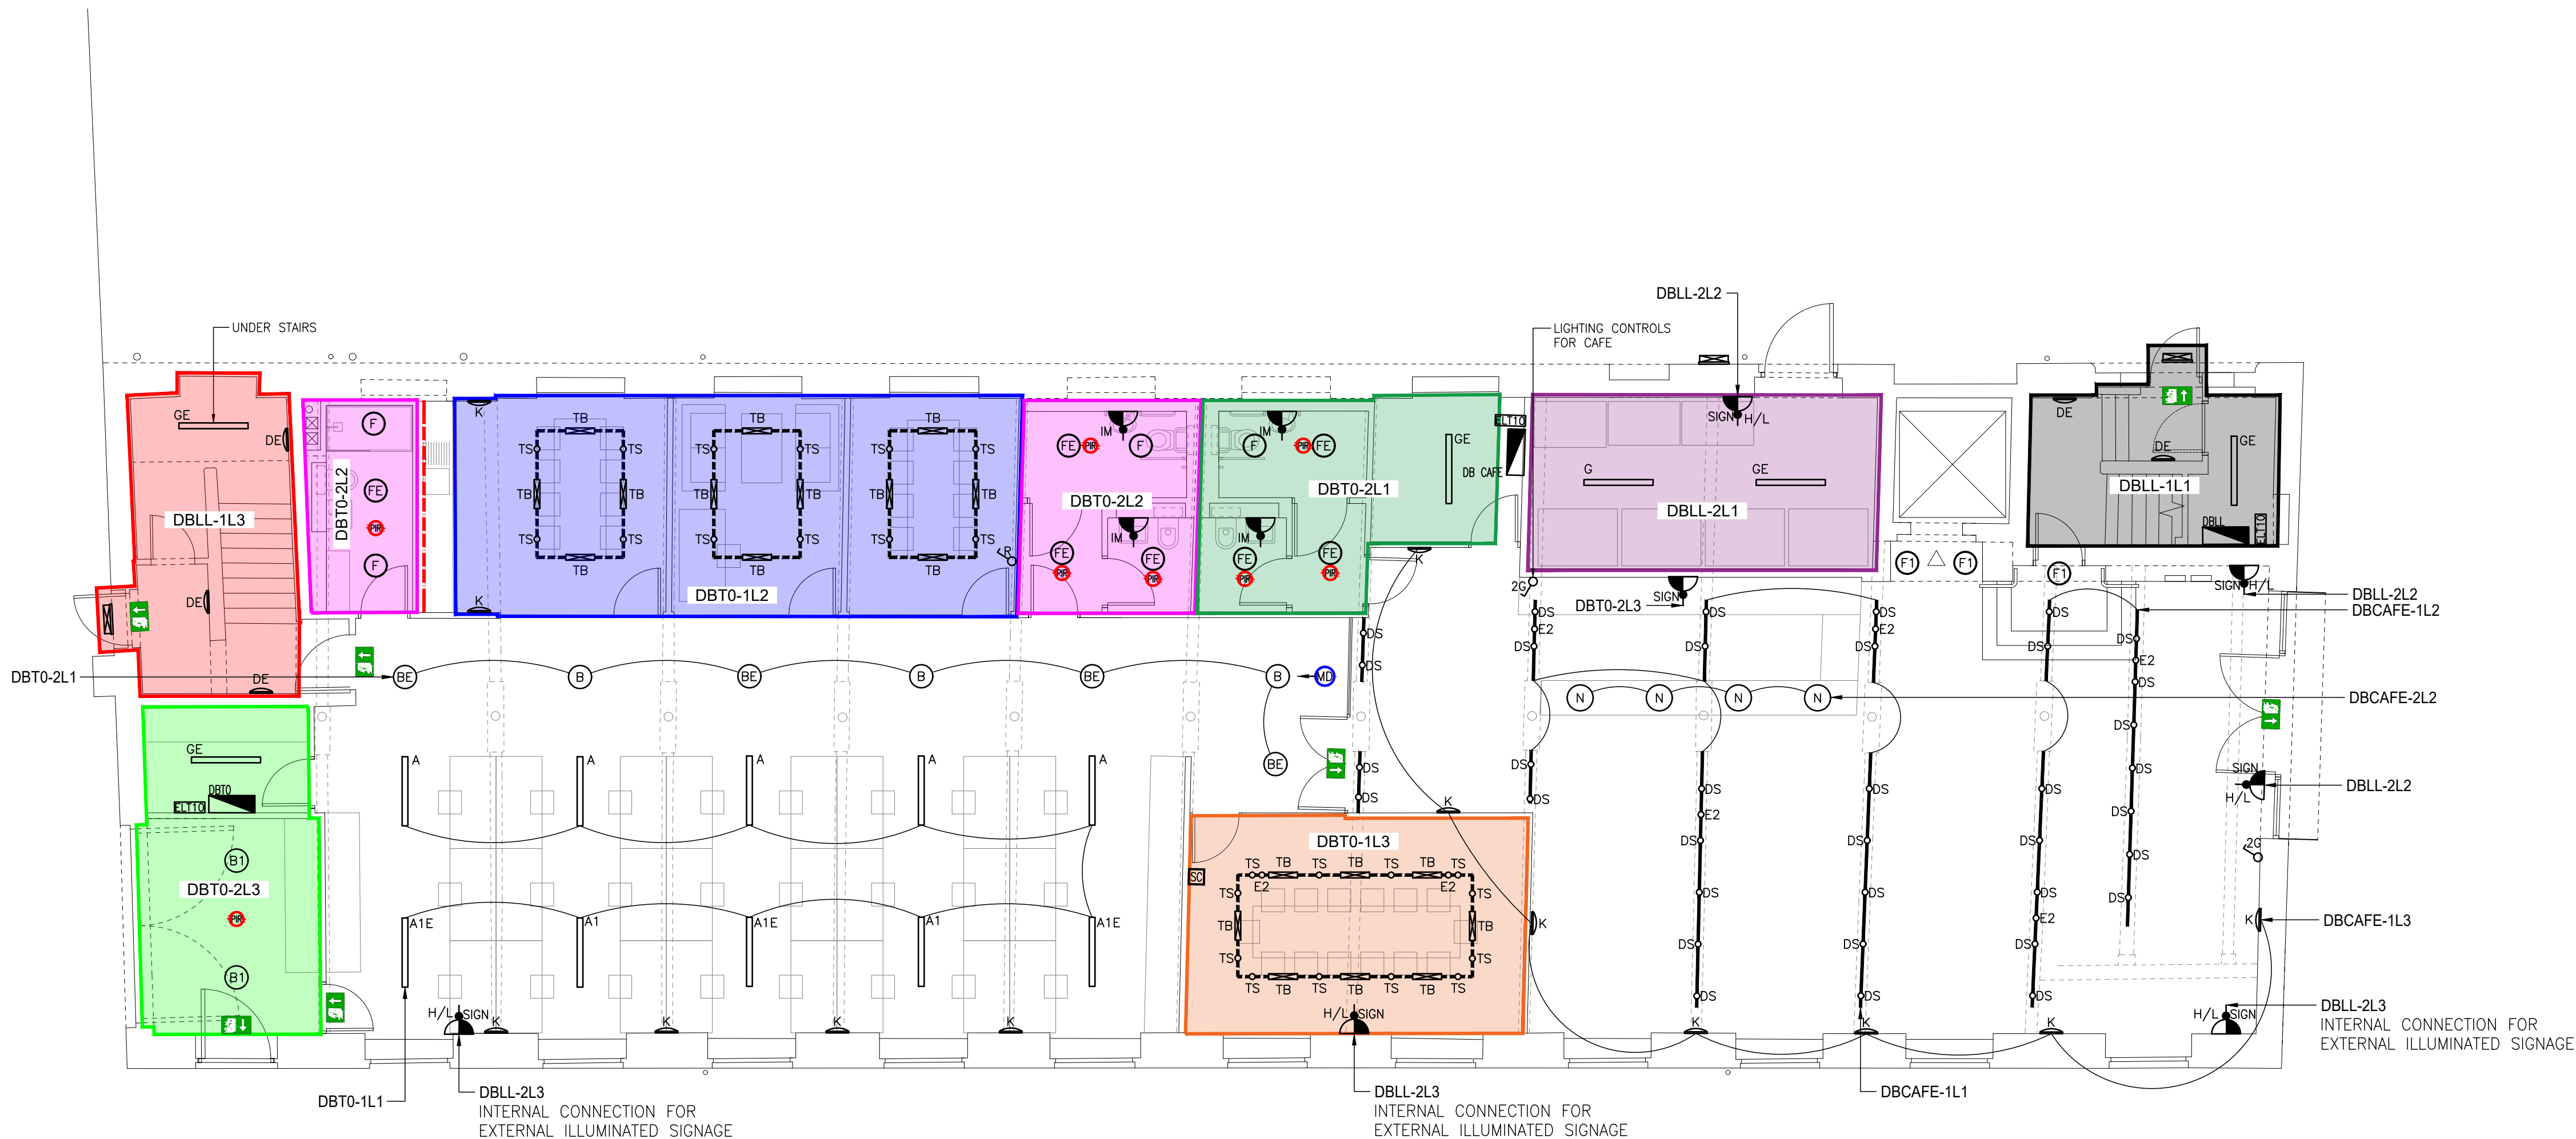

LEGEND — LIGHTING

- P&A PROJECTS — SUBSPACE 70. SUSPENDED LED LUMINAIRE, 4000K, DIRECT/INDIRECT, NON-DIMMABLE, UGR19, BLACK FINISH (E DENOTES INTEGRAL EMERGENCY)
- P&A PROJECTS — SUBSPACE 70. SUSPENDED LED LUMINAIRE, 4000K, DIRECT/INDIRECT, DIMMABLE, UGR19, BLACK FINISH, INTEGRAL DAYLIGHT PIR (E DENOTES INTEGRAL EMERGENCY)
- P&A PROJECTS — PAS-TL 125. SUSPENDED LED CAN LUMINAIRE, 4000K, NON-DIMMABLE, BLACK FINISH (E DENOTES INTEGRAL EMERGENCY)
- P&A PROJECTS — PAS-TL 175. SUSPENDED LED CAN LUMINAIRE, 4000K, NON-DIMMABLE, BLACK FINISH (E DENOTES INTEGRAL EMERGENCY)
- P&A PROJECTS — PAS-TL 90. SUSPENDED LED CAN LUMINAIRE, 4000K, NON-DIMMABLE, BLACK FINISH (E DENOTES INTEGRAL EMERGENCY)
- P&A PROJECTS — DECORATIVE CIRCULAR LED WALL LIGHT. BACK LIT, 4000K, NON-DIMMABLE, BLACK FINISH, INTEGRAL PIR'S (E DENOTES INTEGRAL EMERGENCY)
- ANSELL — RECESSED LED DOWNLIGHT. WHITE BEZEL, 4000K, NON-DIMMABLE, (E DENOTES INTEGRAL EMERGENCY)
- ROBUS — RECESSED LED DOWNLIGHT. IP65 RATED, 4000K, NON-DIMMABLE
- ANSELL — TORNADO. 1500mm SUSPENDED LED BATTEN LUMINAIRE, 4000K, NON-DIMMABLE, IP RATED, INTEGRAL PIR (E DENOTES INTEGRAL EMERGENCY)
- ANSELL — GAMMA. LED WALL LIGHT, BLACK BEZEL, 4000K, NON-DIMMABLE (E DENOTES INTEGRAL EMERGENCY)
- FEATURE UP/DOWN LED WALL LIGHT — SUPPLIER TBC, SAMPLE TO BE APPROVED BY CLIENT
- P&A PROJECTS — SUBSPACE 70. SURFACE MOUNTED OR SUSPENDED LED LINEAR LUMINAIRE, 4000K, DIMMABLE, BLACK FINISH (E DENOTES INTEGRAL EMERGENCY)
- FEATURE PENDANT OVER CAFE SERVERY — SPEC TBC
- DIRECTIONAL LED TRACK SPOT LUMINAIRE (CAFE), BLACK SUSPENDED LIGHTING TRACK, 4000K, NON-DIMMABLE
- SUSPENDED LIGHTING/MAGNETIC TRACK SYSTEM — CLIENT SIGN OFF REQUIRED FOLLOWING SAMPLE REVIEW
- ANSELL — EAGLE. SUSPENDED/SURFACE MOUNTED LED EMERGENCY EXIT SIGN, 3HR MAINTAINED
- ANSELL — IP65 BULKHEAD. 3HR NON-MAINTAINED EMERGENCY BULKHEAD OVER FINAL EXIT
- RECESSED LED 3HR NON-MAINTAINED EMERGENCY LUMINAIRE
- TRACK MOUNTED LED 3HR NON-MAINTAINED TRACK MOUNTED EMERGENCY LUMINAIRE

LEGEND — LIGHTING CONTROLS

- ♂ LIGHT SWITCH
- CP ELECTRONICS — RECESSED/SURFACE MOUNTED PRESENCE DETECTOR
- CP ELECTRONICS — MICROWAVE DETECTOR
- EMERGENCY LIGHTING TEST SWITCH
- WALL MOUNTED SCENE PLATE FOR MEETING ROOM LIGHTING CONTROLS

C	UPDATED TO CLIENT COMMENTS	11.12.23
Revision	Description	Date



Drawing Status
PROPOSED

H&O
ELECTRICAL

Client
WORKSPACE DESIGN & BUILD

Project
NEPTUNE MILL

Title
GROUND FLOOR
LIGHTING & EMERGENCY
LIGHTING LAYOUT

Drawn LY Date 11.12.23

Sheet A1

Scale 1:75

Drawing Number
H&O-J369-L00-C