



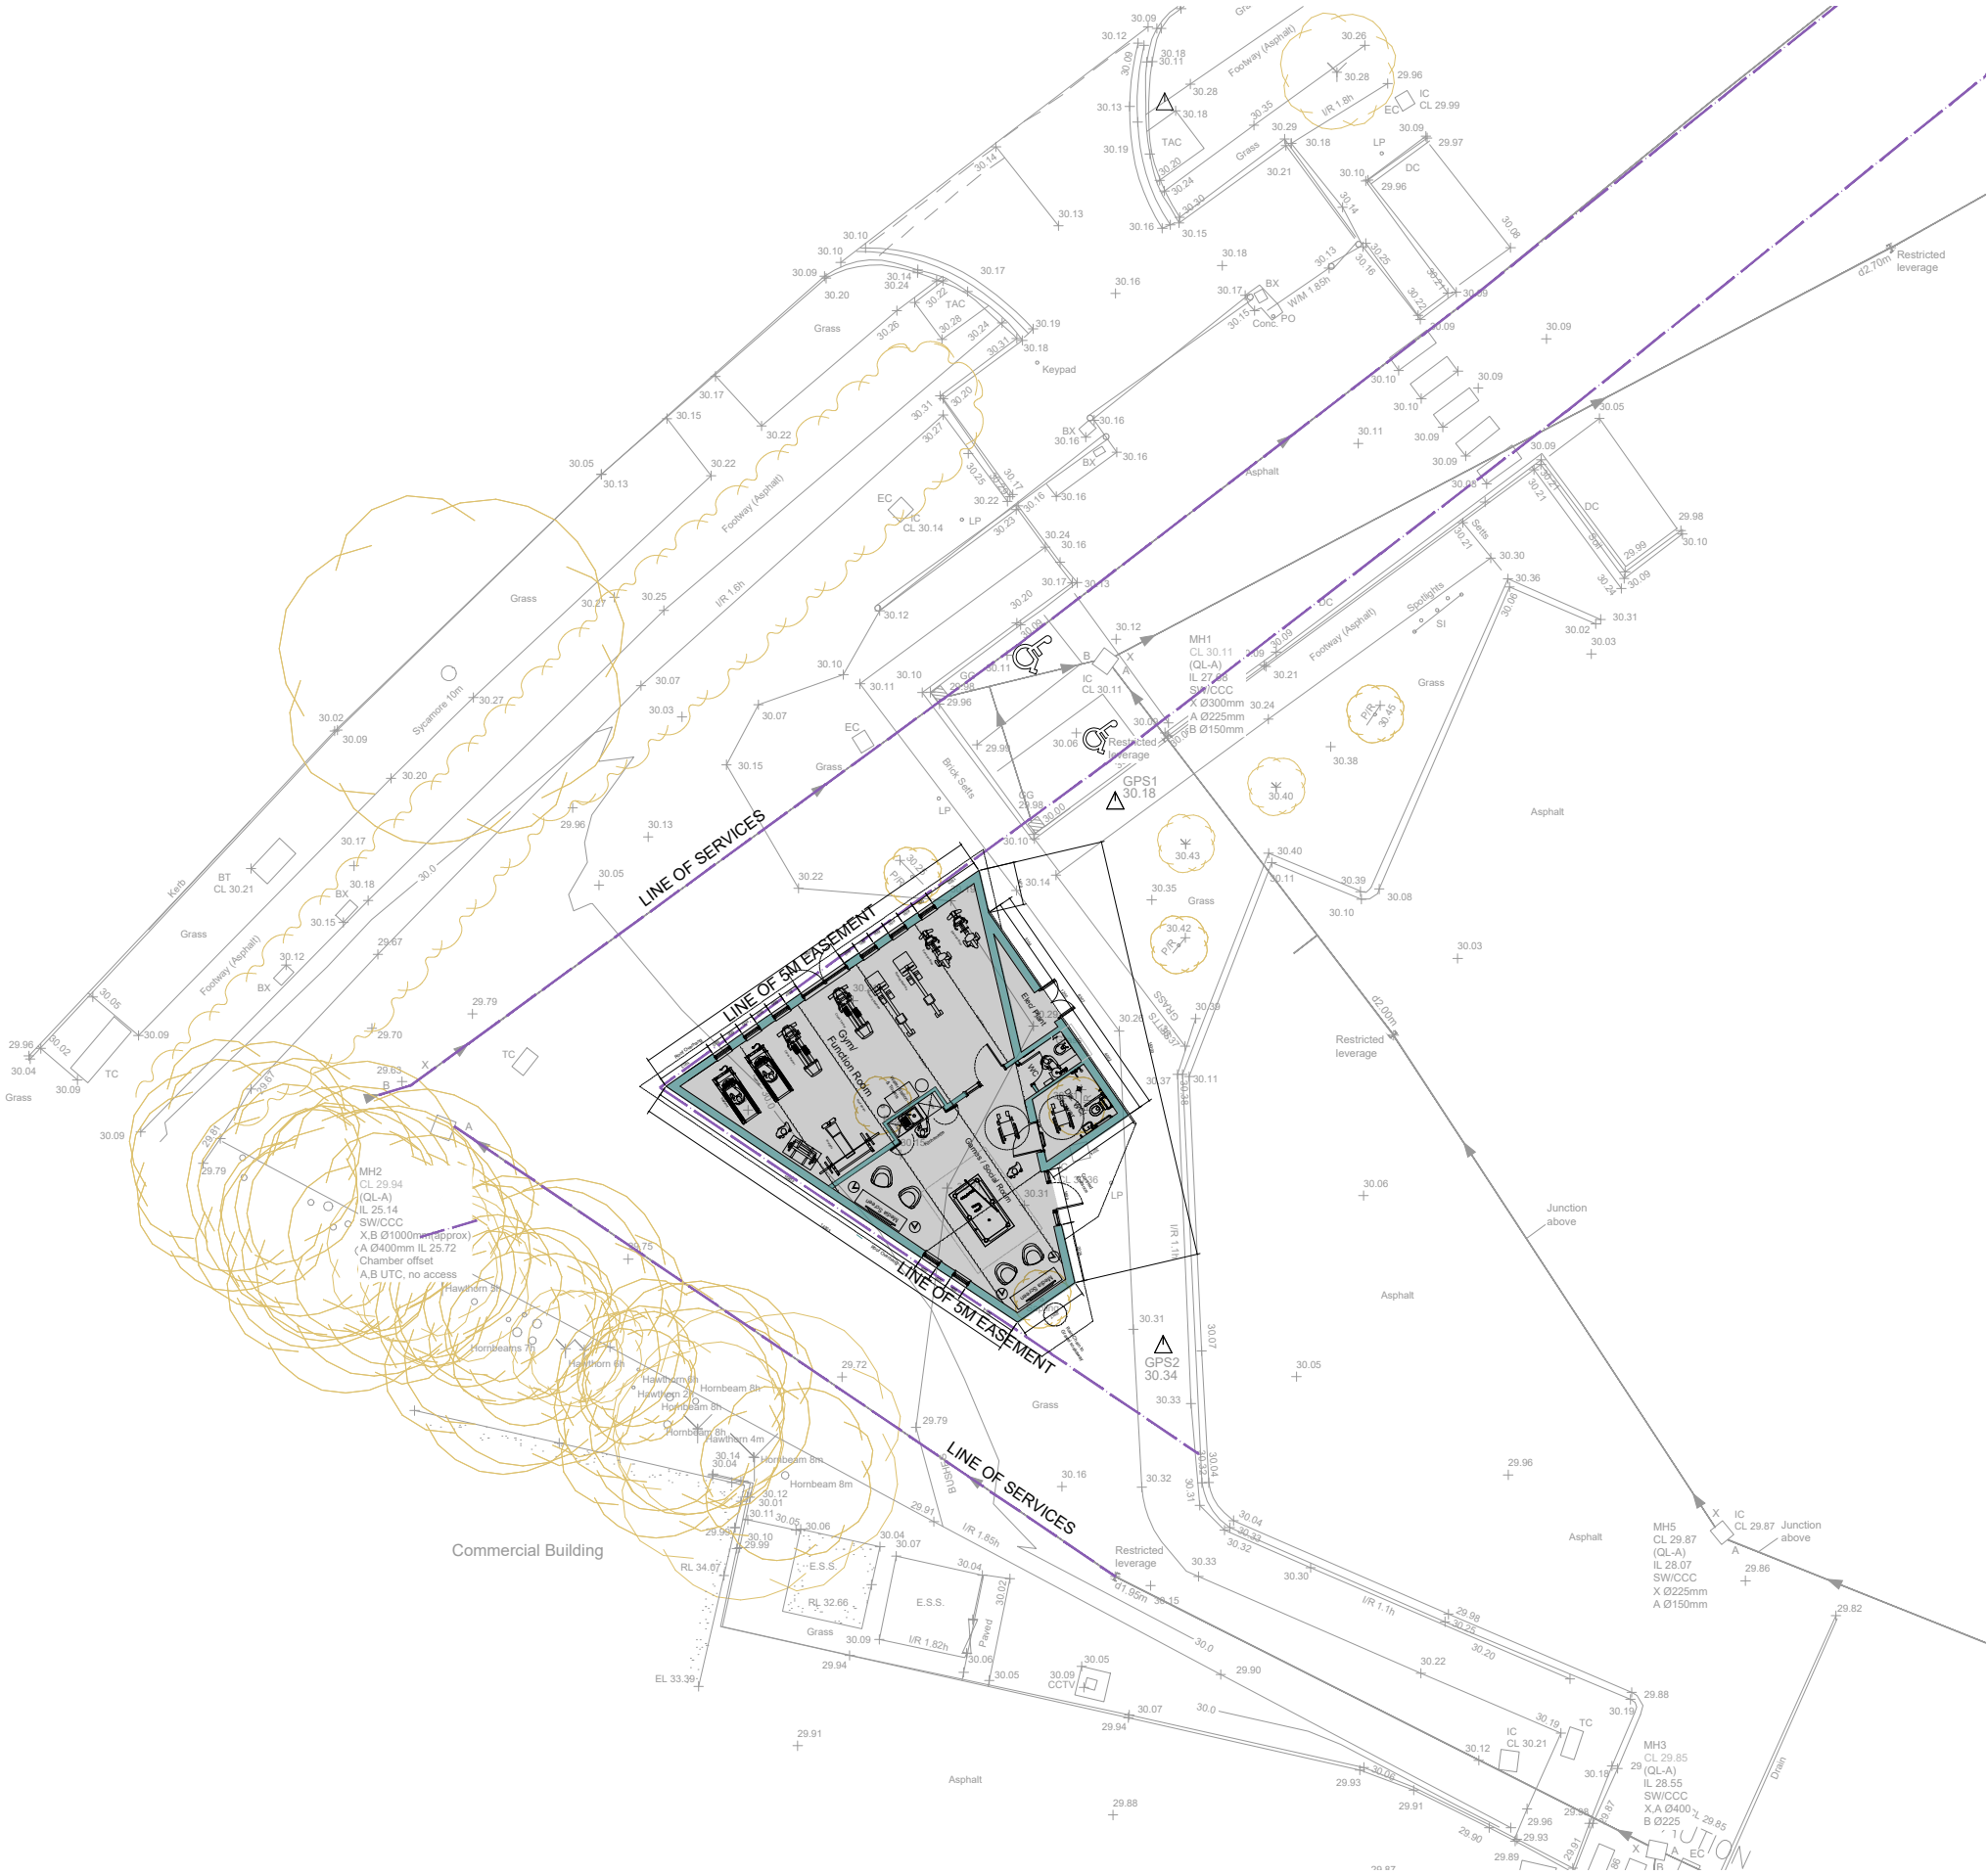

Site plan and position of UU sewers
based upon survey undertaken by
Survey Solutions.
on 24th May 2023
Refer to drawing 48956MCUG-01a

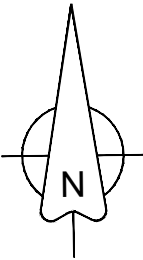

Scale 1:250



Rev	Description	By	Chk	Date
Project No:	2305	Scale @ A3	1:250	Date: 22/06/2023
Drawn:	TC	Status:	PLANNING	
Drawing No:	2305(08)07	Revision:		