


DESIGNERS RISK ASSESSMENT
REFER TO APPENDIX 1 OF M&E SPECIFICATION FOR DESIGNERS RISK ASSESSMENT SCHEDULE

DRAWING BACKGROUND(S):		
COMPANY	DRAWING NUMBER	REV
BLACKSHEEP	TBR001_A211	B

LEGEND	
SYMBOL	DESCRIPTION
	INSTALLED BY LANDLORD
	INSTALLED BY TENANT

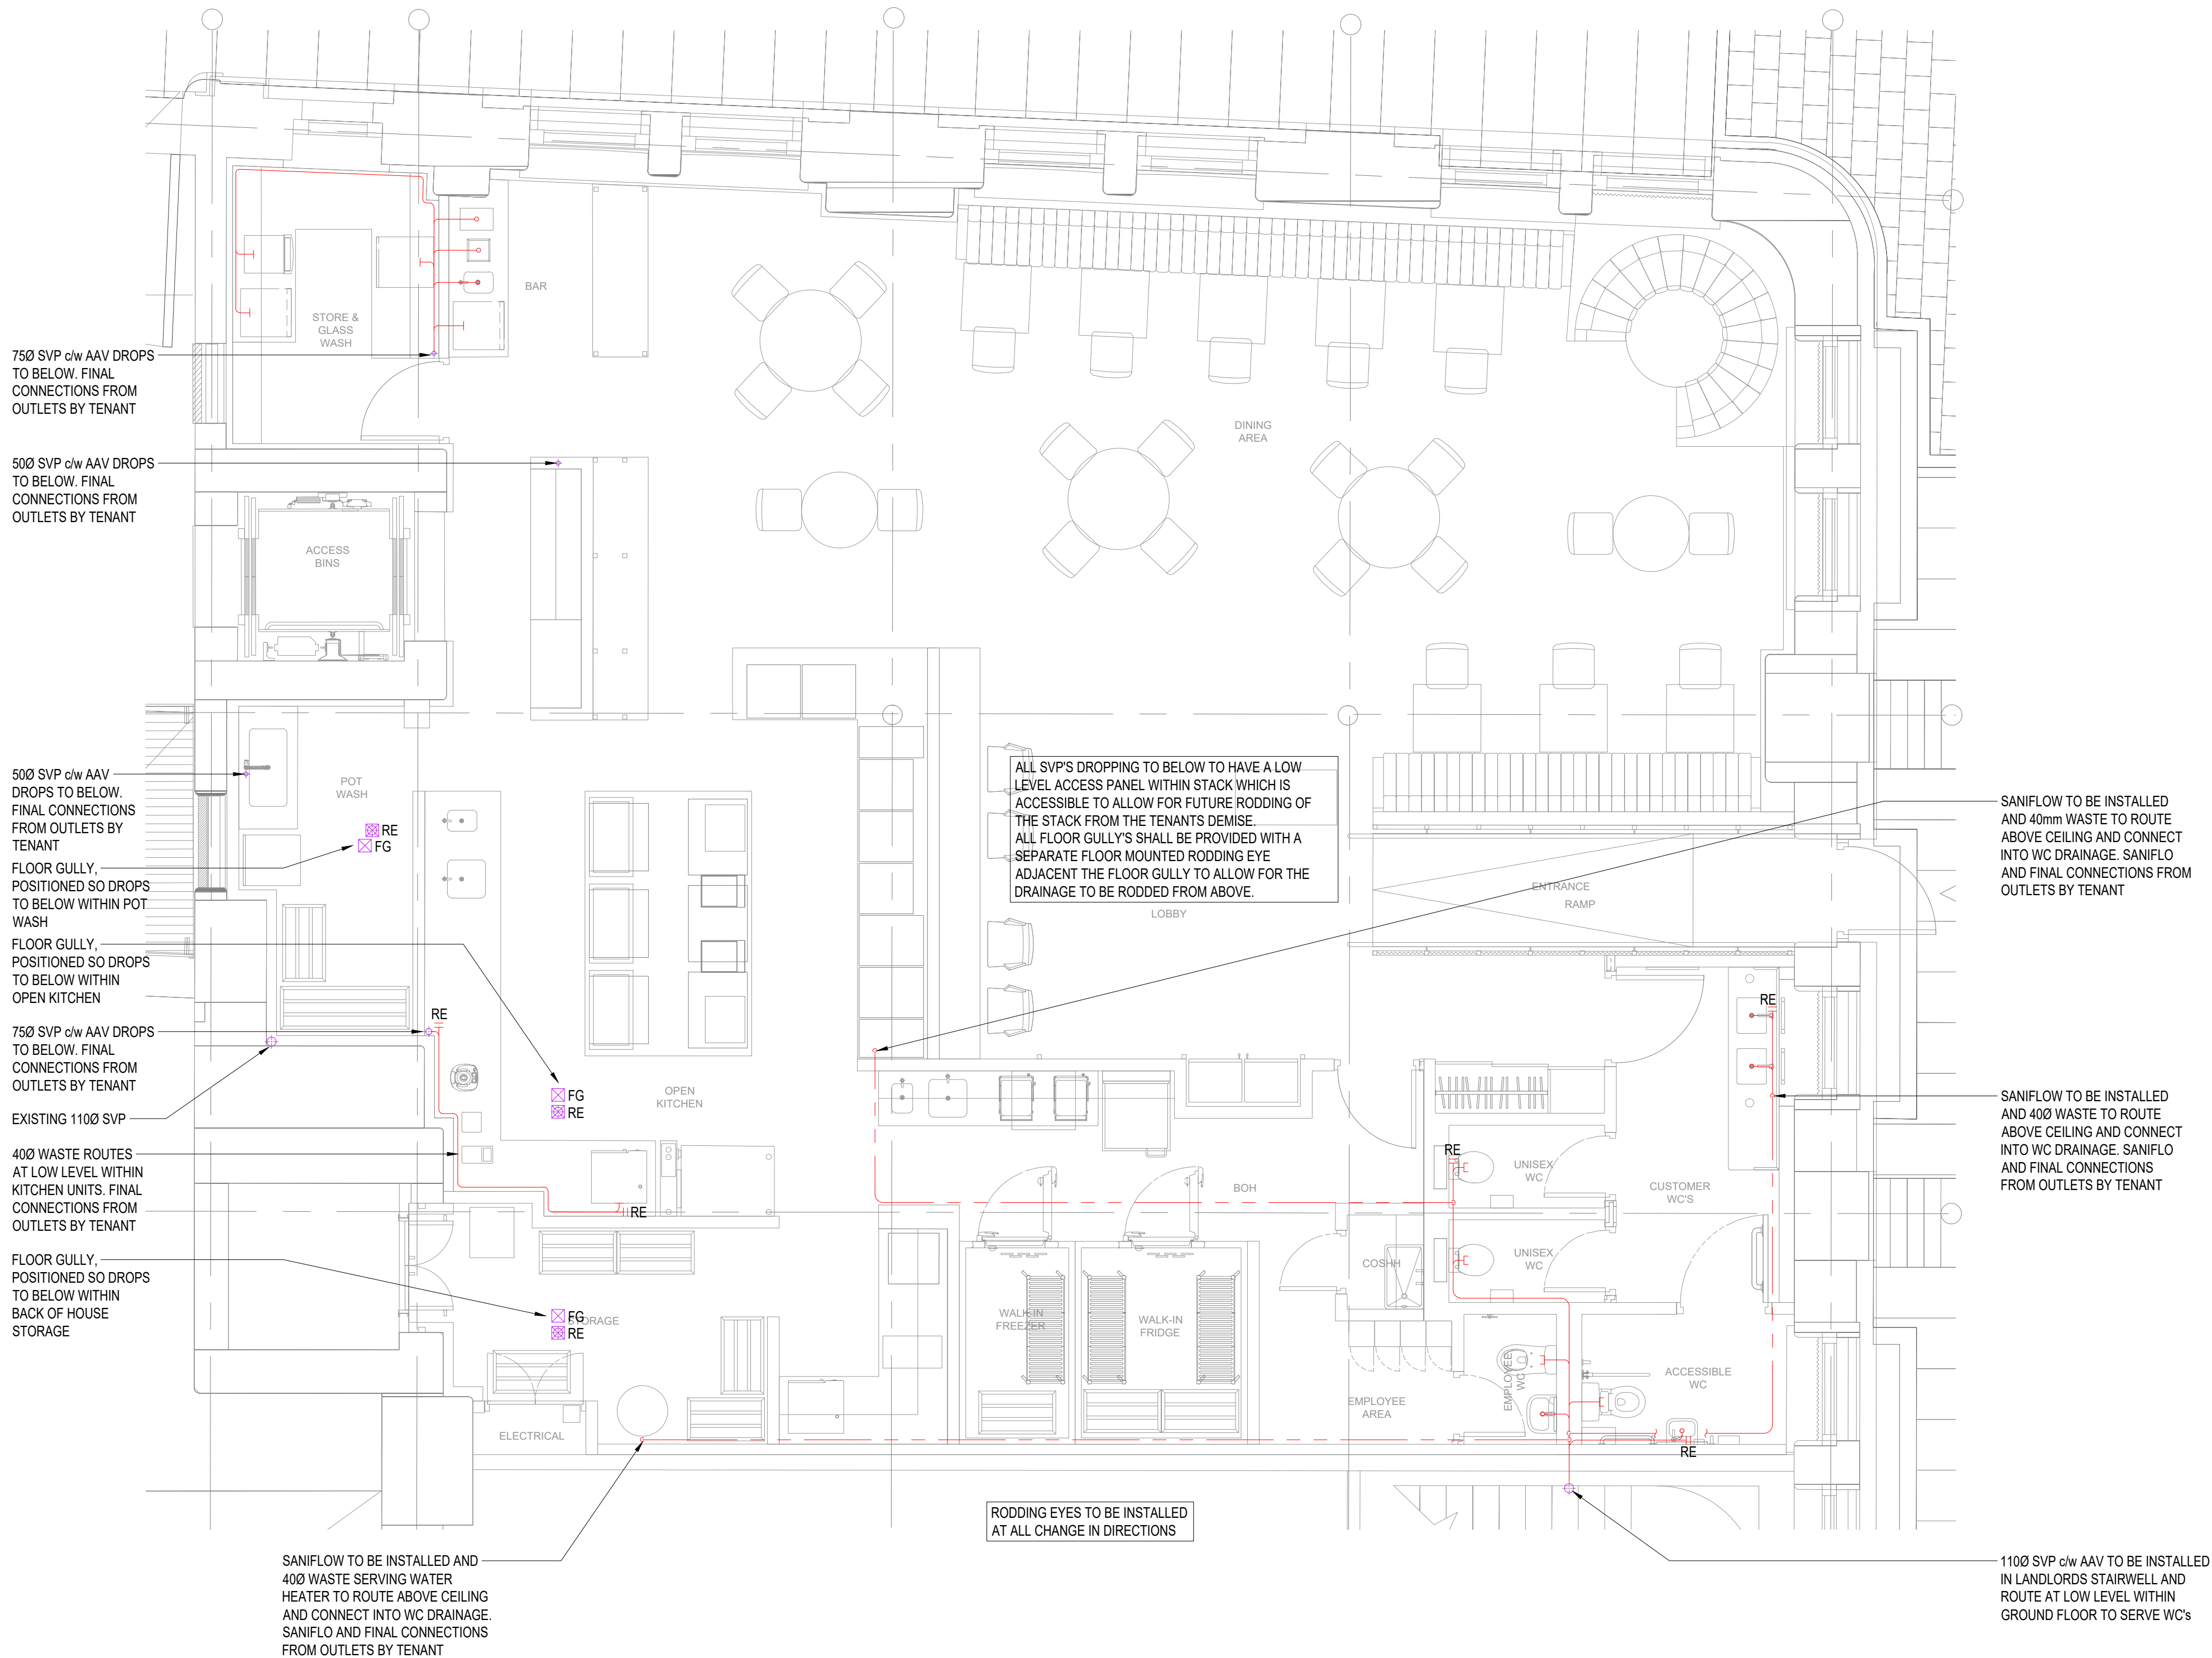

Rev	Date	Description	Eng	Chk
P04	01.11.23	PRELIMINARY ISSUE	RB	BH
P03	27.10.23	PRELIMINARY ISSUE	RB	BH
P02	24.10.23	PRELIMINARY ISSUE	RB	BH
P01	27.09.23	PRELIMINARY ISSUE	BH	BH

CWC
crookes walker
consulting

Suite 9a, Bloc. 17 Marble Street
Manchester M2 3AW
Tel: 0161 834 9999
The Plaza, Old Hall Street,
Liverpool L3 9QJ
Tel: 0151 600 5409
Cornwall Building, 45 Newhall Street,
Birmingham B3 3QR
Tel: 0121 262 4046
E-mail: admin@cwcon.co.uk
Website: www.cwcon.co.uk

Client

NOMA LTD

Project

**HANOVER - NOMA
UNIT 3
MANCHESTER**

Drawing Title

**GROUND FLOOR
DRAINAGE LAYOUT**

Status		
PRELIMINARY		
Project No.	Drawn	Scale / Paper Size
2996	SJW	1:50 @ A1
Drawing No.	Rev	
2996-CWC-XX-00-DR-M-5201	P04	