
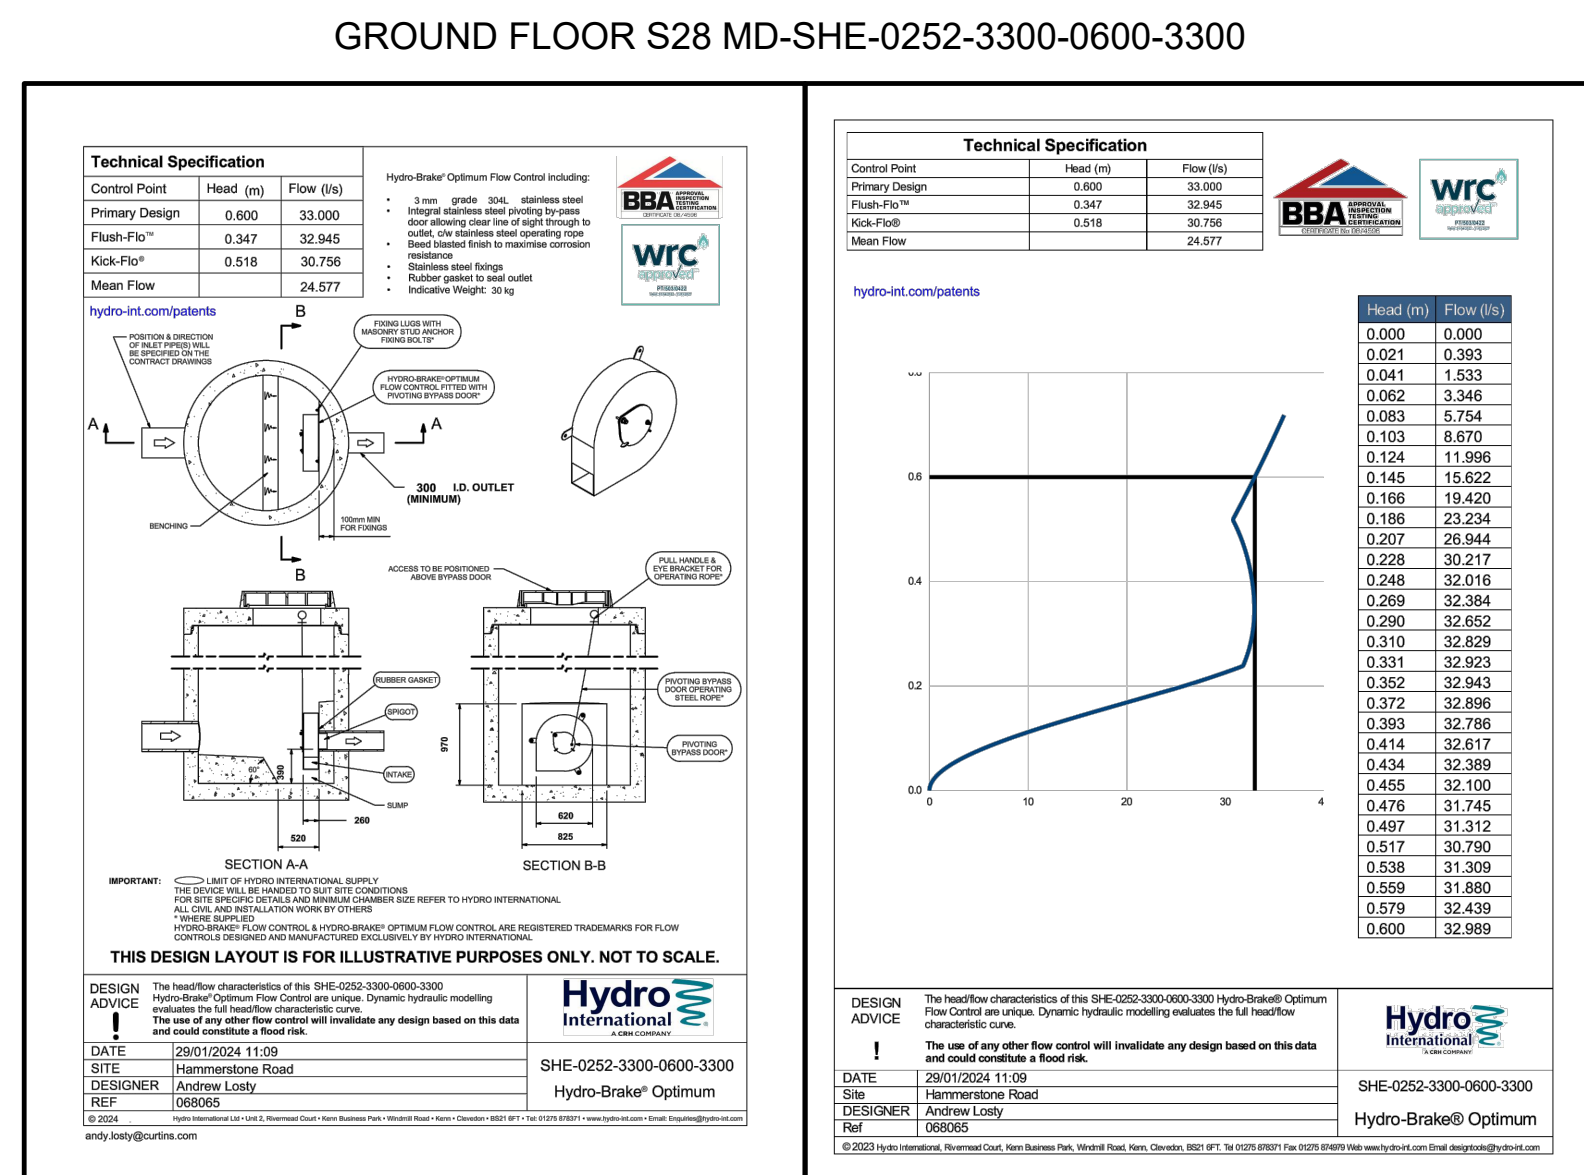
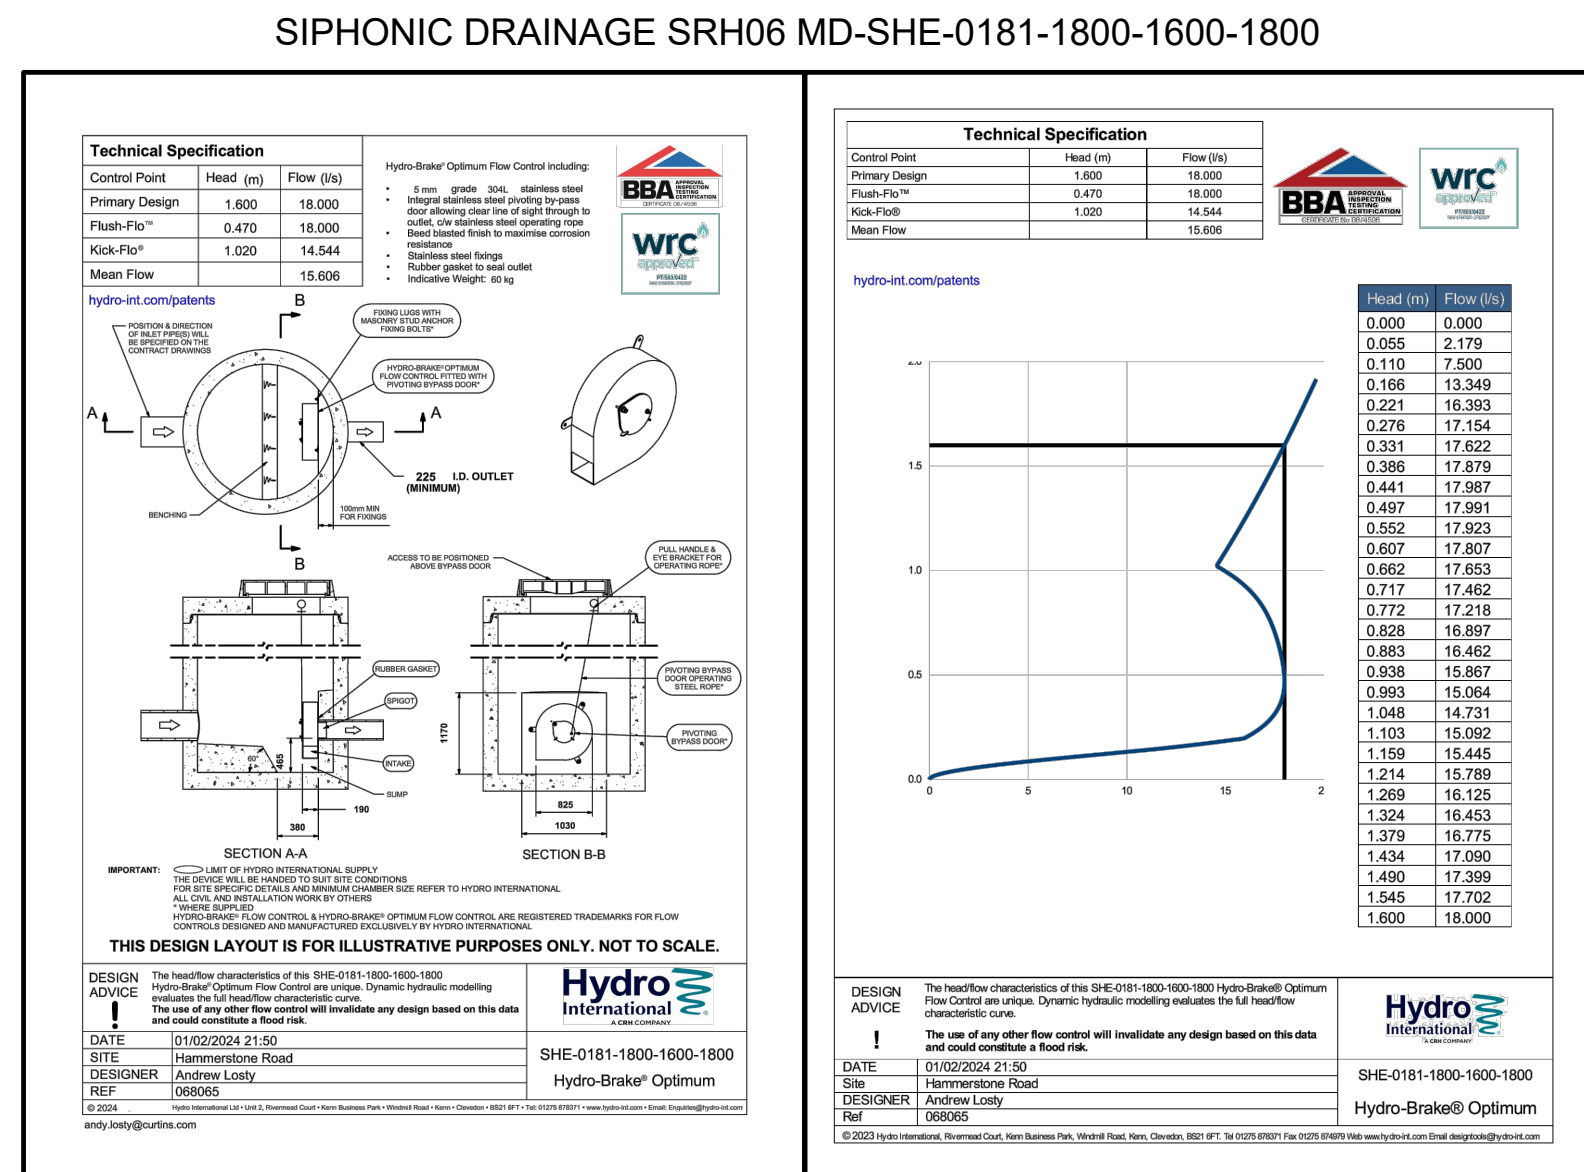
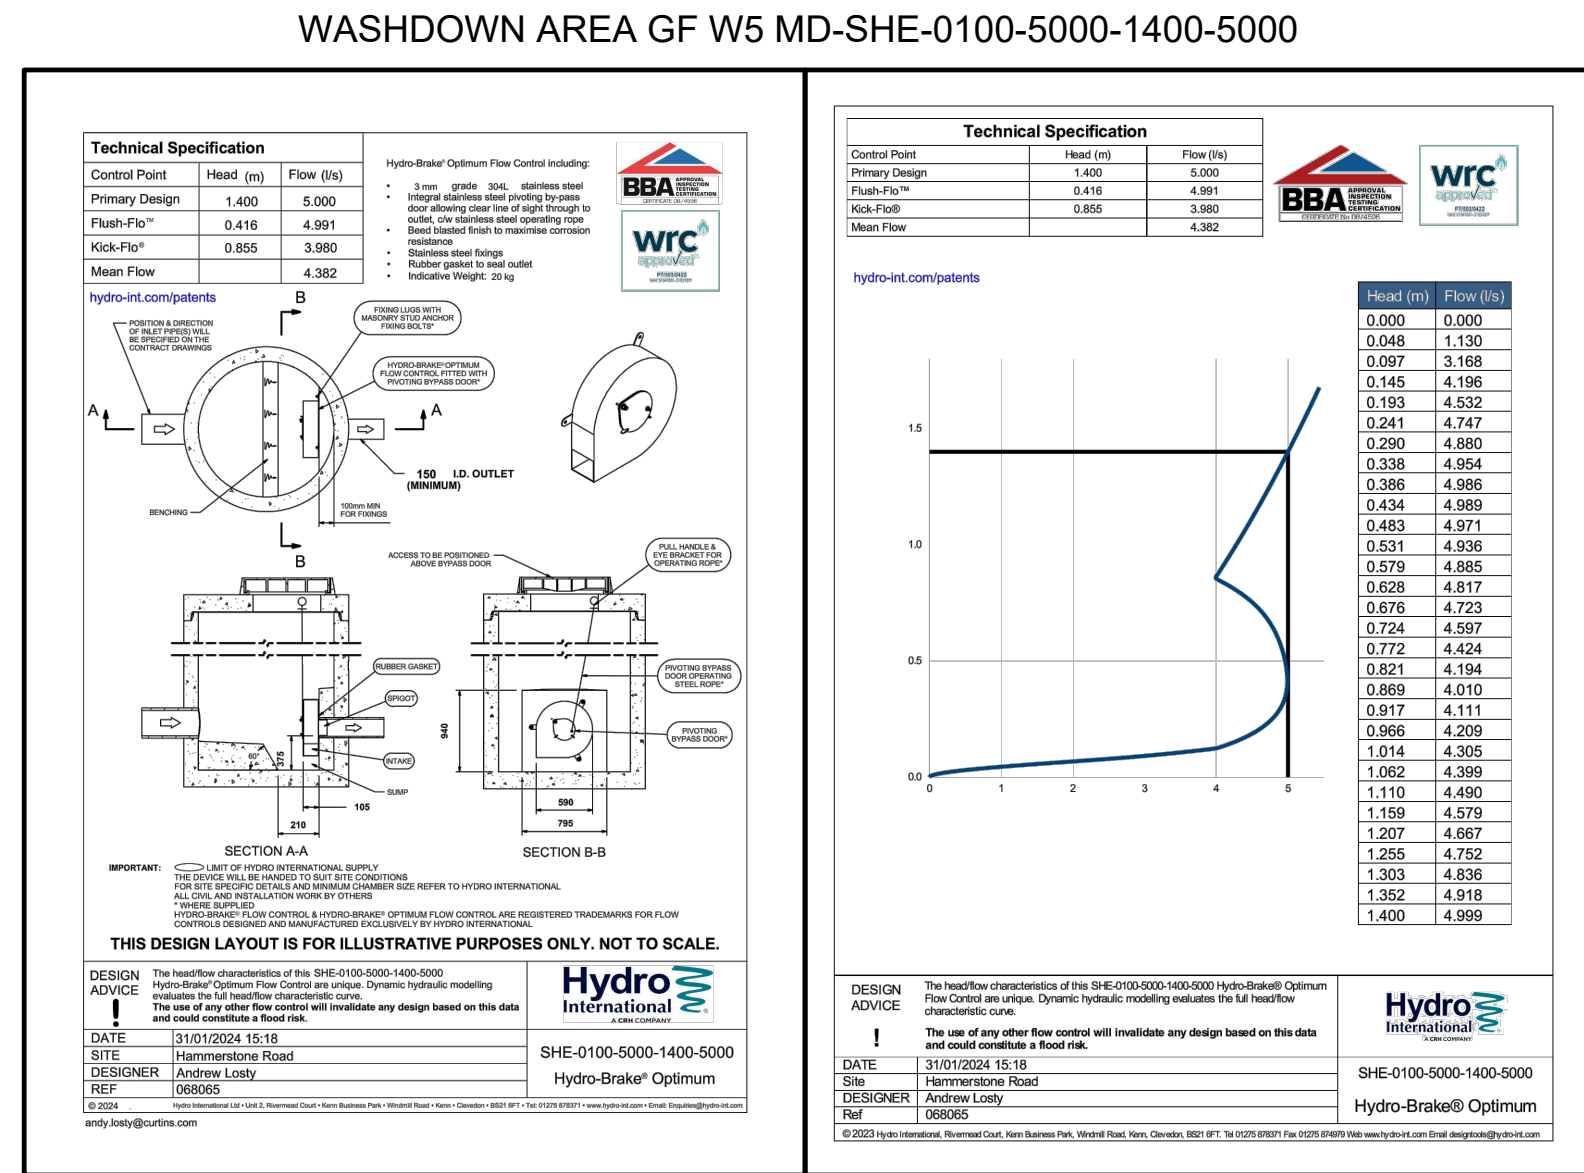
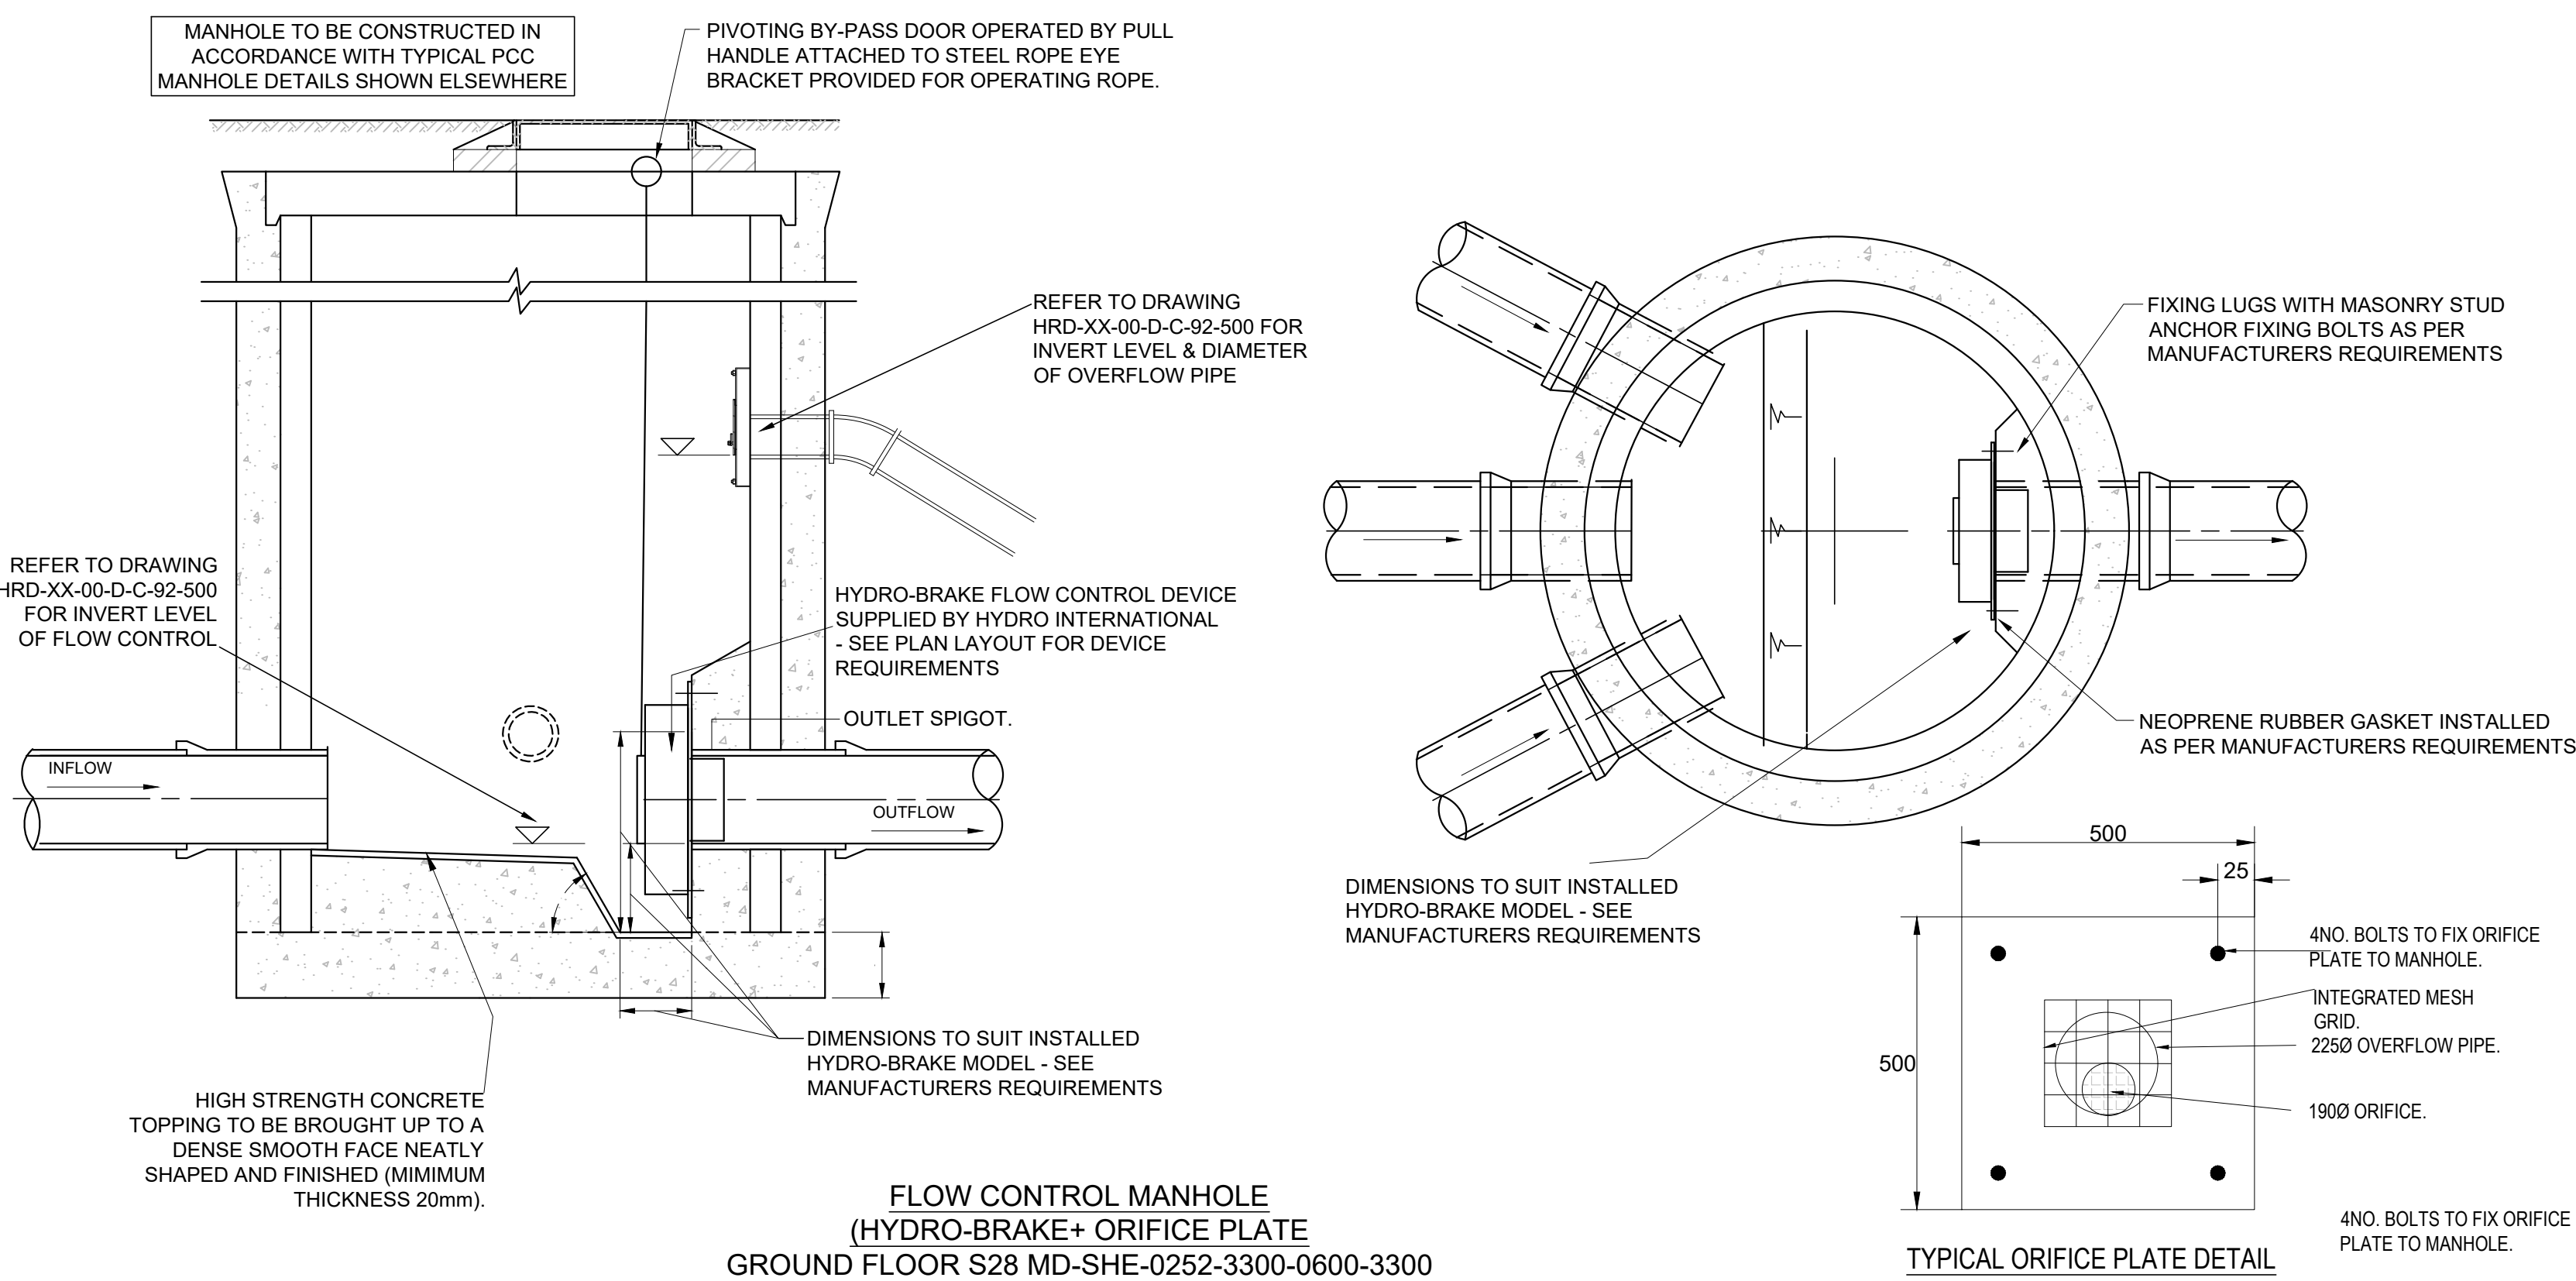
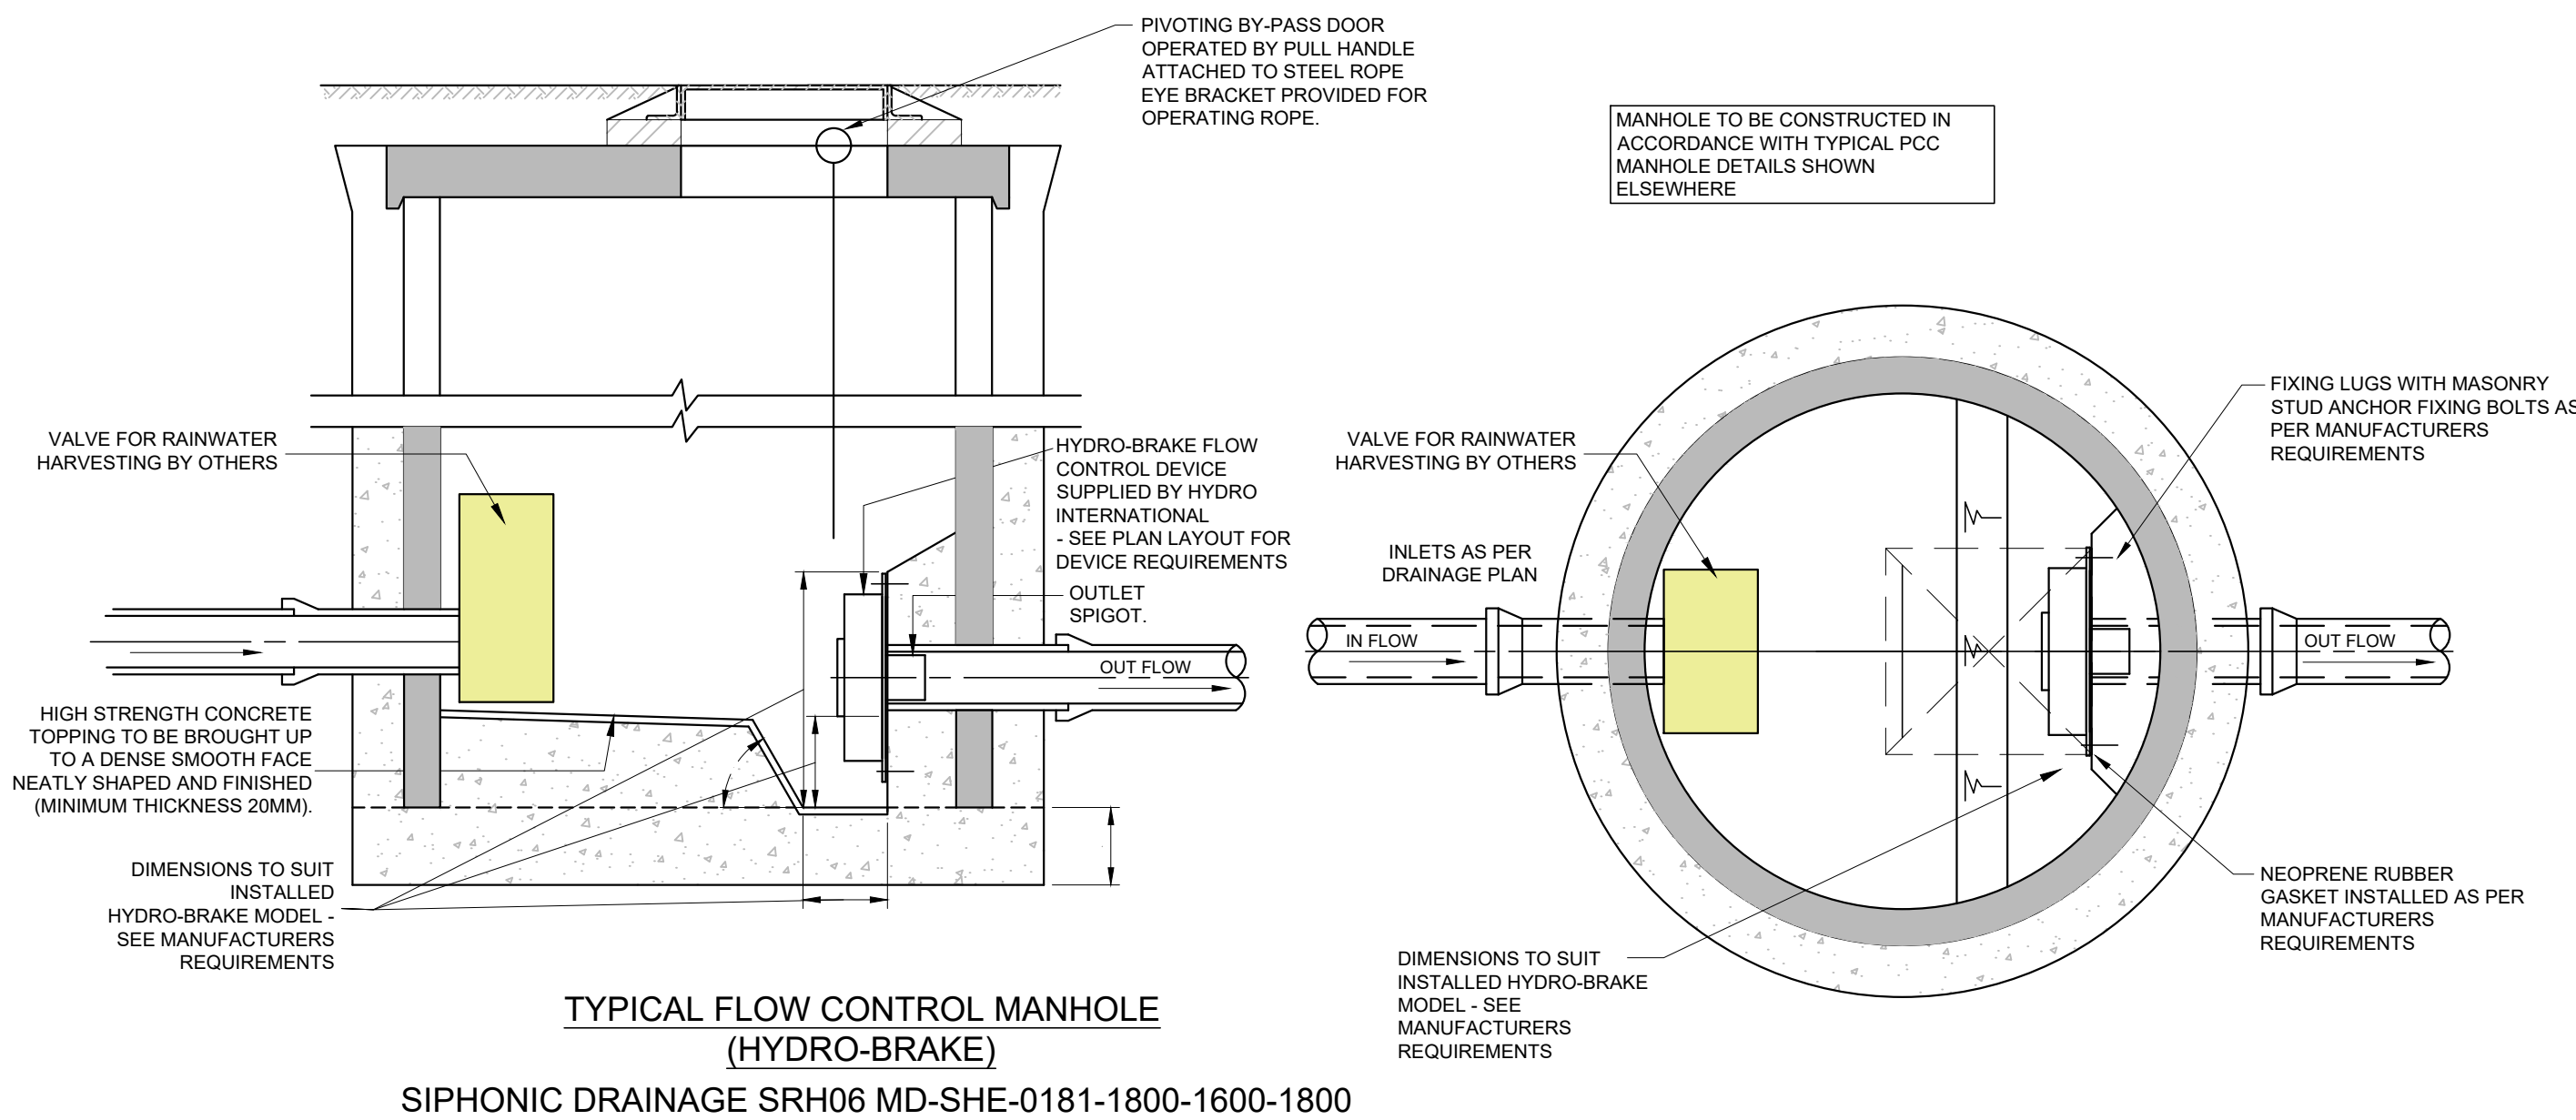


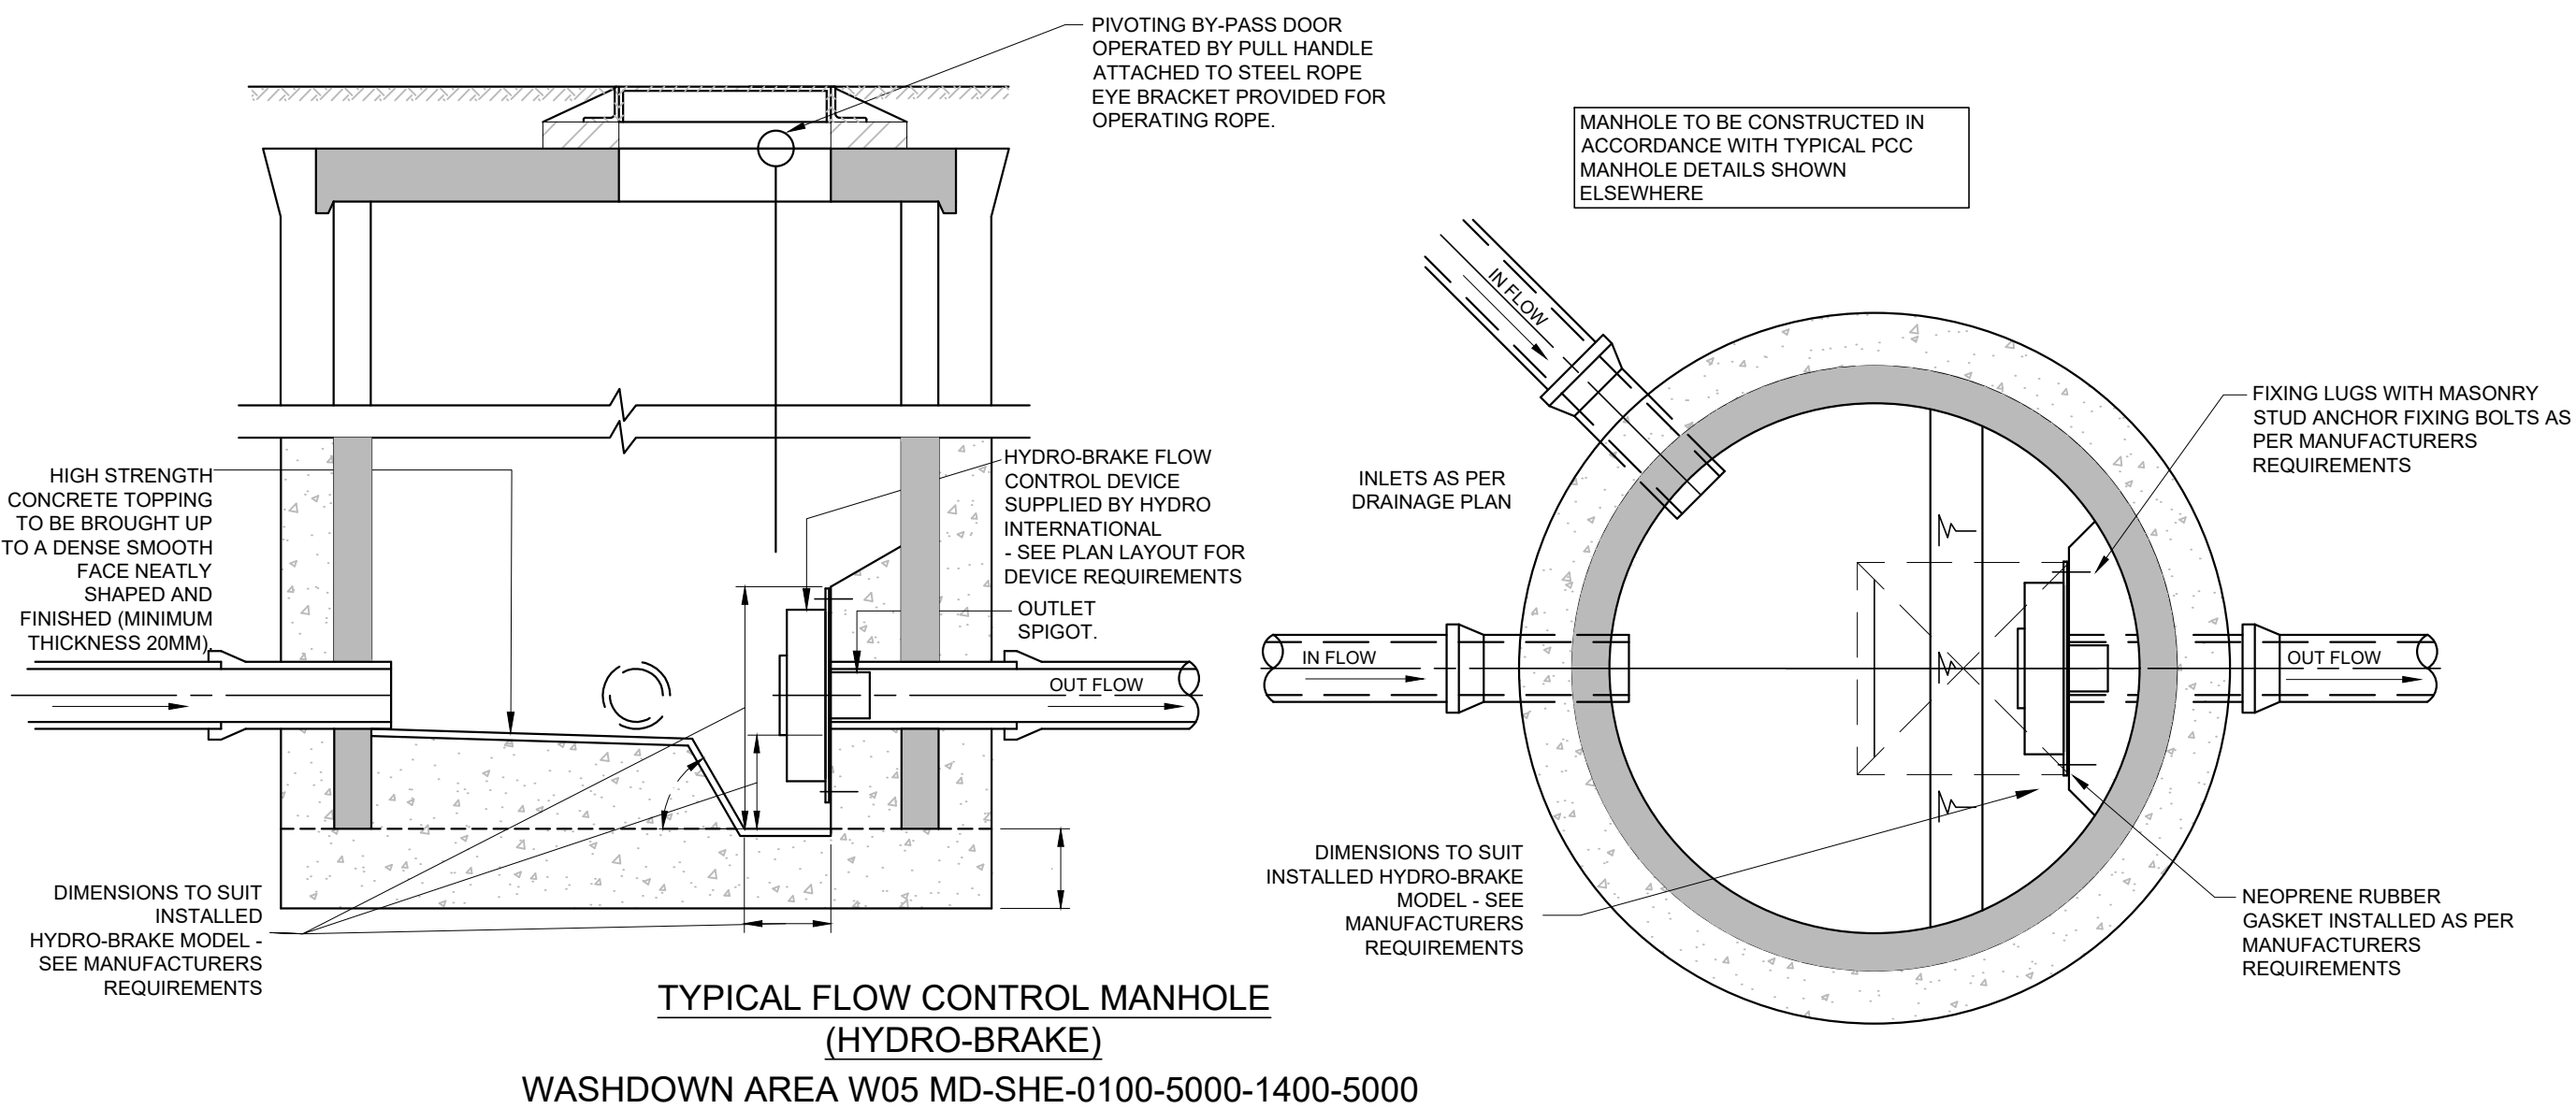

- GENERAL NOTES:
- THIS DRAWING IS TO BE READ IN CONJUNCTION WITH ALL RELEVANT ARCHITECTS AND ENGINEERS DRAWINGS AND SPECIFICATIONS.
 - DO NOT SCALE THIS DRAWING. ANY AMBIGUITIES, OMISSIONS AND ERRORS ON DRAWINGS SHALL BE BROUGHT TO THE ENGINEERS ATTENTION IMMEDIATELY. ALL DIMENSIONS MUST BE CHECKED / VERIFIED ON SITE.
 - ALL DIMENSIONS ARE IN MILLIMETRES UNLESS NOTED OTHERWISE.
 - REFER TO DRAINAGE LAYOUT HRD-CUR-XX-00-DR-C-92-500 FOR THE LOCATION OF THE ATTENUATION TANK.
 - FLOW CONTROL TO BE INSTALLED IN STRICT ACCORDANCE WITH THE MANUFACTURERS REQUIREMENTS, INSTRUCTIONS AND RECOMMENDATIONS.
 - WHERE ALTERNATIVE FLOW CONTROL DEVICE IS PREFERRED, IT WILL BE SUBJECT TO REDESIGN TO CONFIRM WHETHER THE SYSTEM HAS CAPACITY.
 - SURFACE WATER DRAINAGE CONNECTION SUBJECT LAND DRAIN CONSENT
 - FOR FULL DRAINAGE NOTES REFER TO DWG HRD-CUR-XX-ZZ-DR-C-92-502

P06	UPDATED FOR NEW TENDER	02/02/24	ATL	MW
C02	FLOW CONTROL MH SW08 AMENDED	25/11/22	ATL	MW
C01	CONSTRUCTION ISSUE	23/09/22	MW	MW
P05	UPDATED HYDROBRAKE CHARACTERISTICS	20/07/22	TH	MW
P04	STAGE 4 ISSUE- HYDROBRAKE UPDATED LGSW02	05/08/21	MW	MW
P03	STAGE 4 ISSUE	09/04/21	MW	MW
P02	STAGE 3 ISSUE	03/12/20	MW	MW
P01	STAGE 3 ISSUE	18/11/20	MW	MW
Rev:	Description:	Date:	By:	Chkd:

curtins

Merchant Exchange, 17-19 Whitworth Street West, Manchester, M1 5WG
0161 235 2394
manchester@curtins.com
www.curtins.com

Chris & Structures • Transport Planning • Environmental • Infrastructure • Geotechnical • Conservation & Heritage • Principal Designer
Birmingham • Bristol • Cambridge • Cardiff • Douglas • Dublin • Edinburgh • Glasgow • Kentish • Leeds • Liverpool • London • Manchester • Nottingham

Status: **STAGE 5**

Project: **HAMMERSTONE ROAD DEPOT**

Dwg Title: **DRAINAGE DETAILS SHEET 4**

Project No:	Size:	Date:	Drawn By:	Designed By:	Checked By:
068065	A1	18/11/20	MW	MW	MW
Scale: 1:20					
Project Code:	Originator:	Zone:	Level:	Type:	Discipline/Category/Number:
HRD	- CUR	- XX	- ZZ	- DR	- C - 92523 -P06