



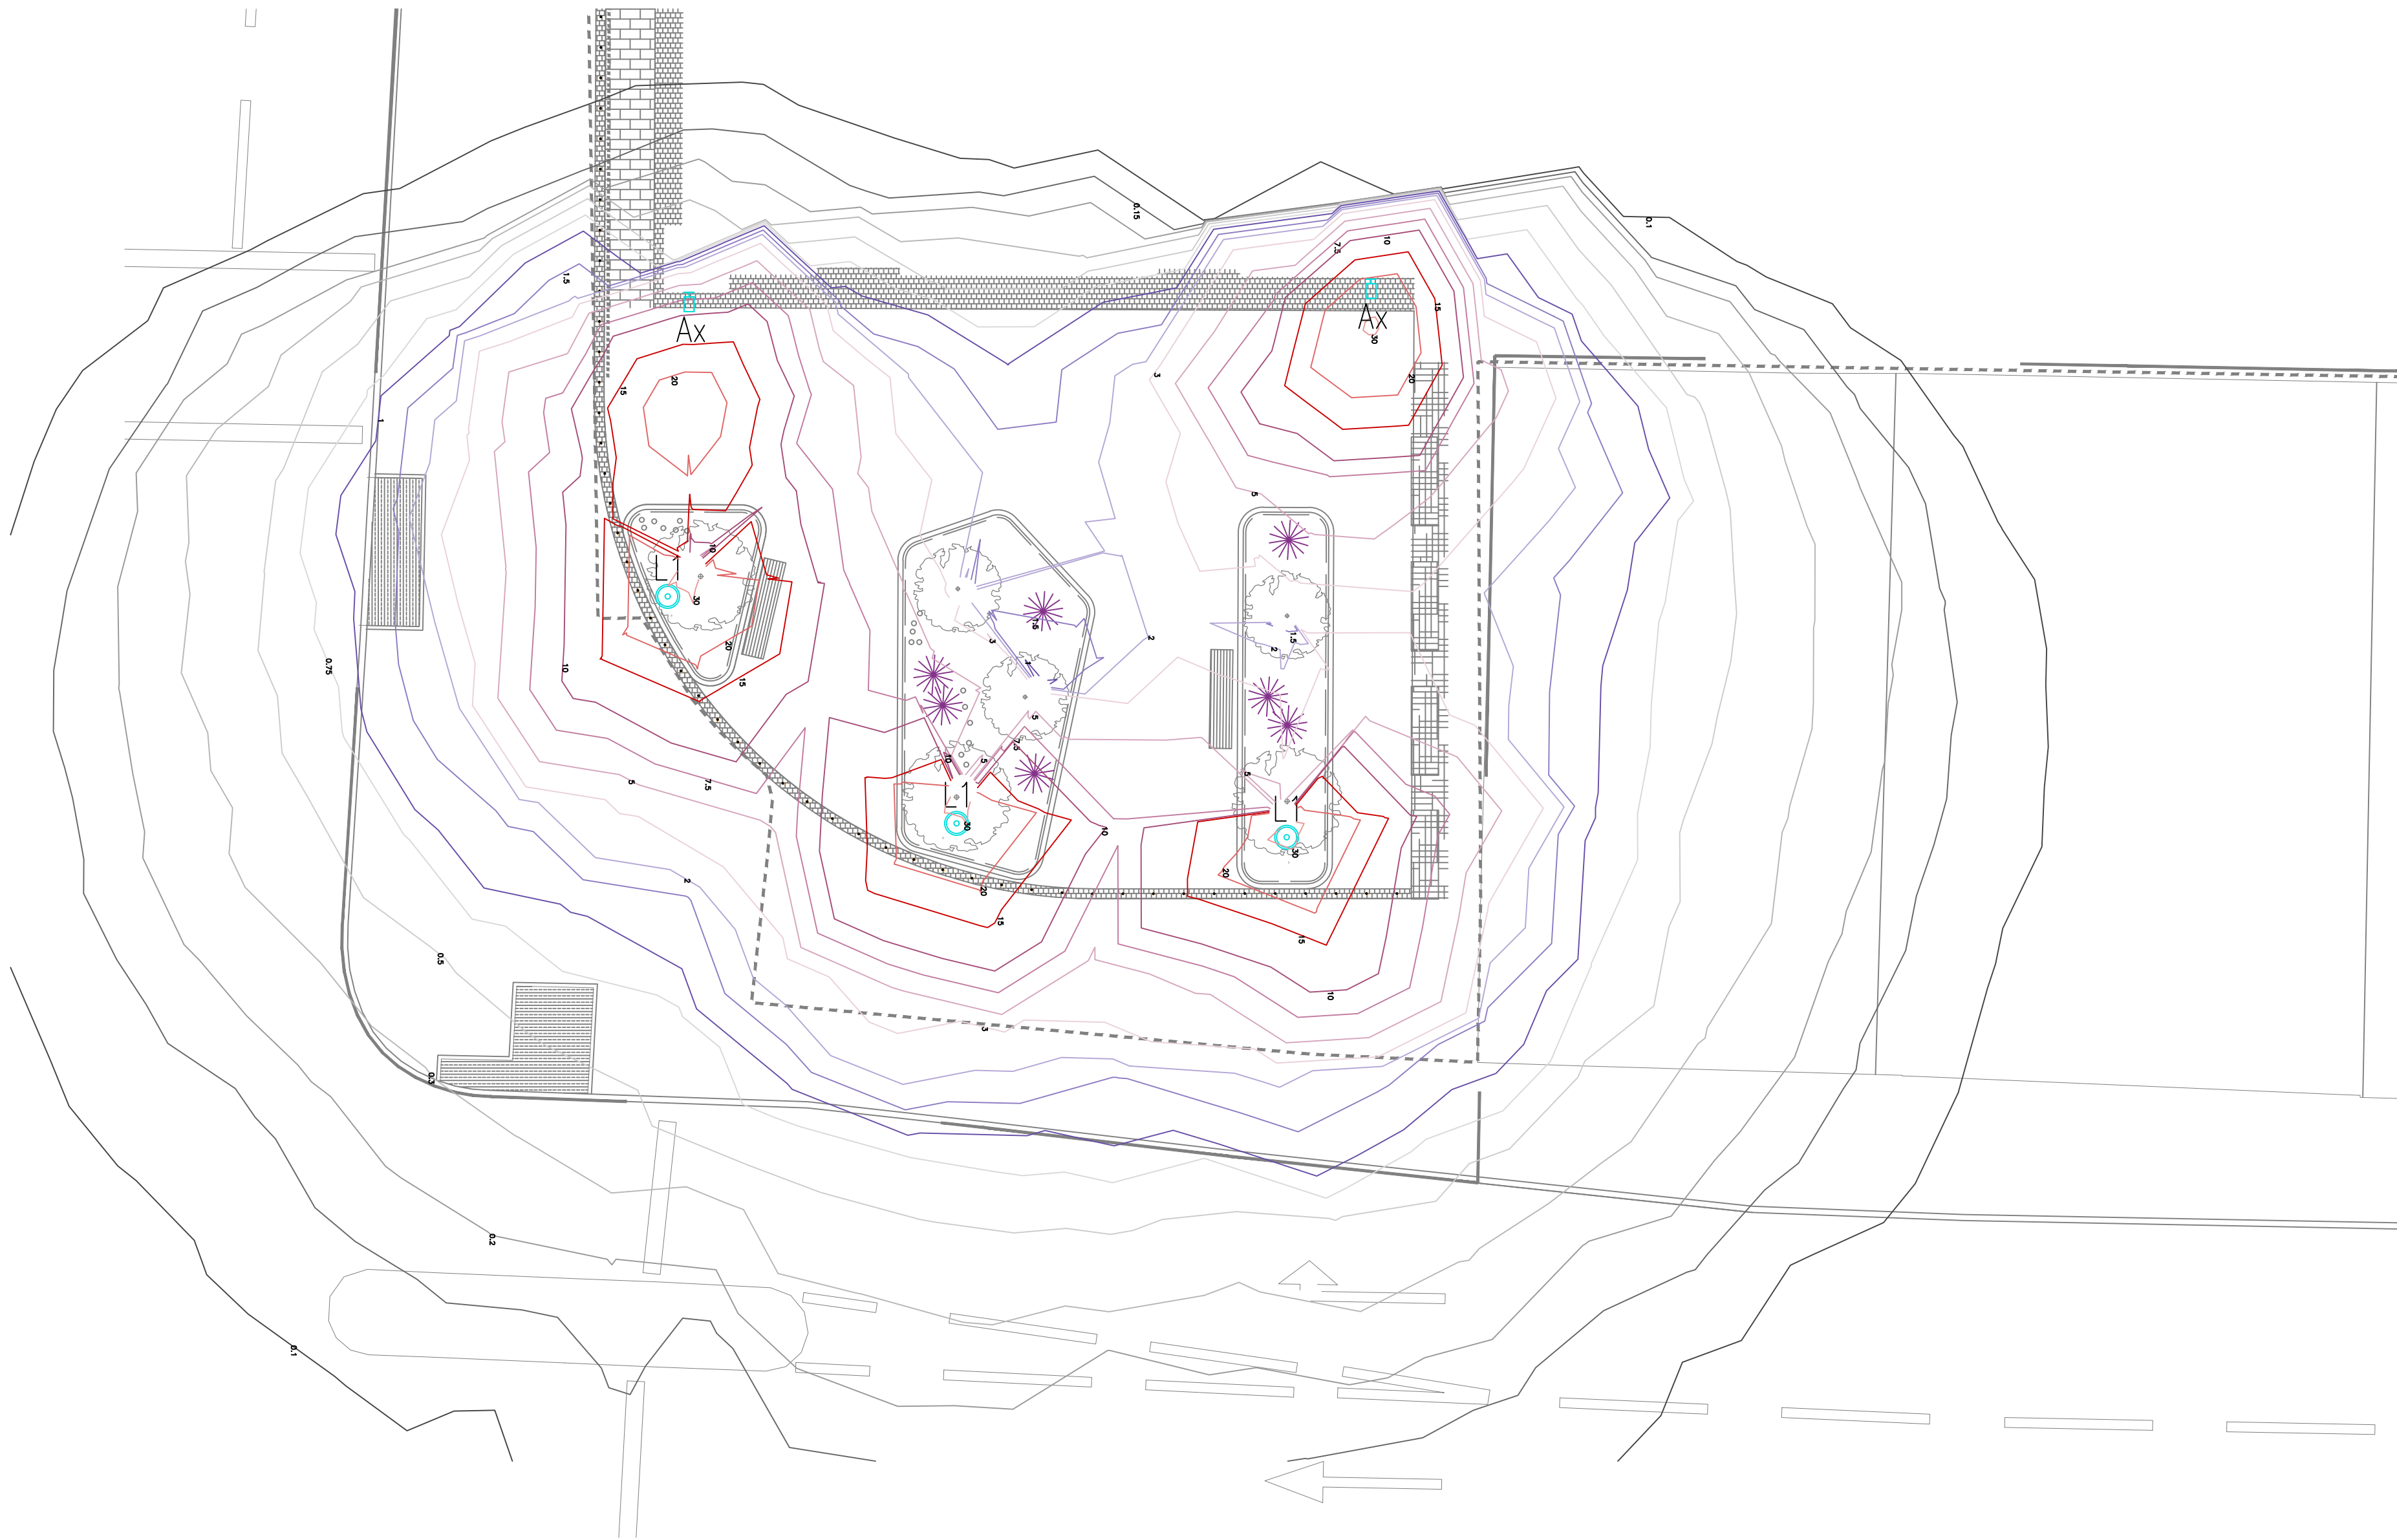

SITE PLAN @ 1:100

1.5sqmm LSF/LSF cables in trunking/conduit.

230v supply from local distribution board.

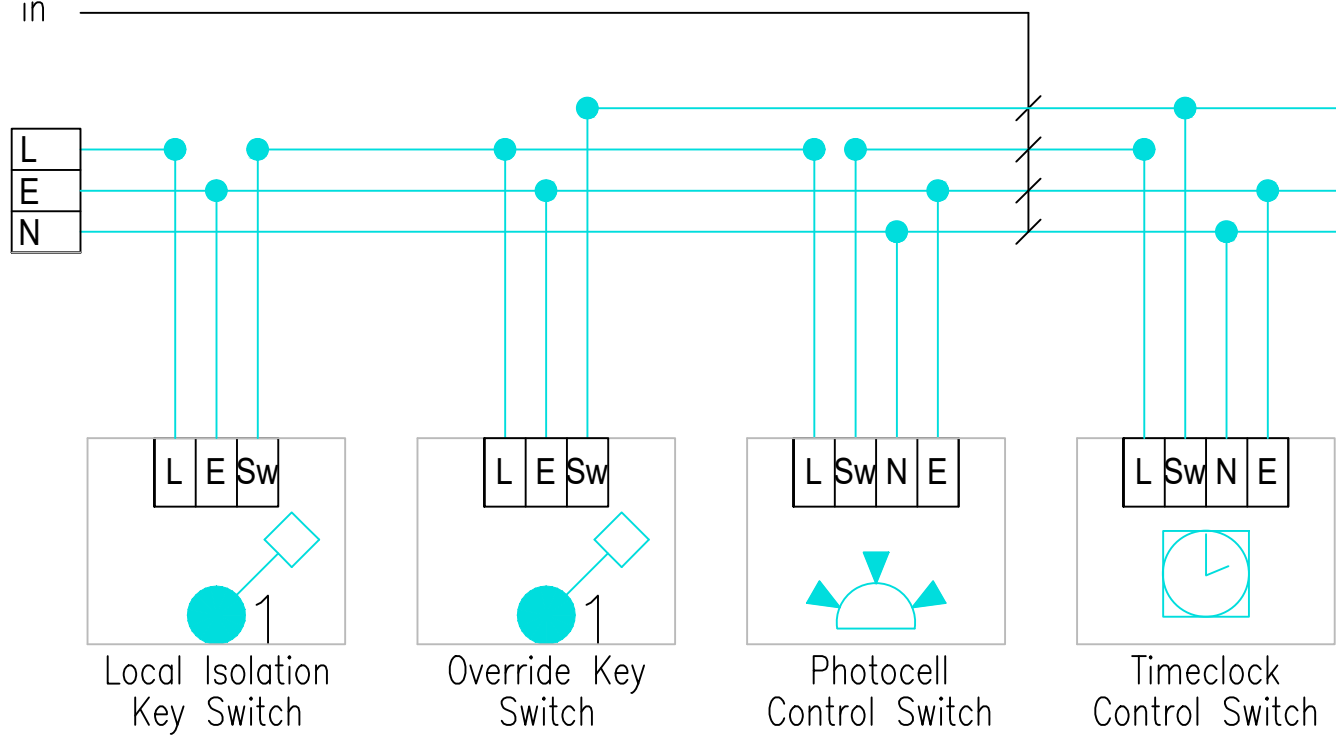

Control wiring to coil of 20Amp DP contactors controlling each outgoing external lighting circuit.

LEGEND

SYMBOL	MANUFACTURER	DESCRIPTION
L1	ANSELL	LAZOR PROJECTOR 2 UPLIGHTER
Ax	ASD	HORIZON ROUND

EXTERNAL LIGHTING

Automatic lighting control with Timeclock & Photocell Sensor

GENERAL NOTES

- THIS DRAWING IS COPYRIGHT AND SHALL NOT BE REPRODUCED WITHOUT PERMISSION
- THIS DRAWING IS TO BE READ IN CONJUNCTION WITH ALL OTHER DISCIPLINES, DRAWINGS, SCHEDULES AND SPECIFICATIONS, LEGENDS AND STANDARD DETAILS
- DIMENSIONS GOVERN ON ALL DRAWINGS AND DETAILS. SHOULD ANY DISCREPANCIES BE FOUND ON THIS DRAWING AND ANY ASSOCIATED DRAWINGS OR SPECIFICATIONS, THIS SHOULD BE BROUGHT TO THE ATTENTION OF BRENTWOOD DESIGN IMMEDIATELY
- CONTRACTORS MUST CHECK AND VERIFY ALL INFORMATION / DIMENSIONS / LEVELS IN CONJUNCTION WITH ALL RELEVANT DRAWINGS AND ACTUAL SITE CONDITIONS BEFORE COMPLETING ANY MANUFACTURING / INSTALLATION DRAWINGS OR COMMENCING SITE INSTALLATION WORK
- DO NOT SCALE FROM THIS DRAWING

NOTES

- THIS DRAWING INDICATES THE HORIZONTAL ILLUMINANCE ON THE SURFACE. THE LUMINAIRES CONSIST OF TREE UPLIGHTERS WHICH THEREFORE PRODUCE NO SPILL VERTICALLY TO THE SURROUNDING AREAS.
- THE LUMINAIRES WILL BE CONTROLLED VIA A PHOTOCELL AND TIMECLOCK WHICH WILL SWITCH ALL LUMINAIRES ON/OFF TOGETHER. THERE SHALL BE AN OVERRIDE SWITCH TO TURN THE LUMINAIRES ON/OFF AS REQUIRED.

Rev	Date	Description	SA	JO
			Dwn	Onk

BRENTWOOD
CONSULTING ENGINEERS

First Floor, 21 Hornbeam Square South, Harrogate, HG2 8BN
T: 01423 878892 W: www.brentwoodgroup.co.uk
Jacton House, 11000 Street, Manchester, M4 6AW
T: 0161 553 4630

CLIENT:

RG GROUP

PROJECT:
SWAN ST HOUSE, MANCHESTER

DRAWING TITLE:
EXTERNAL LIGHTING LUX LEVEL PLOTS

DRAWING STATUS:

PLANNING

DRAWN BY:	CHK BY:	DATE:	SCALE:
SA	JO	11/12/23	1:100 @A1
DRAWING No:	REVISION:		
5527-E-401-LL	A		