



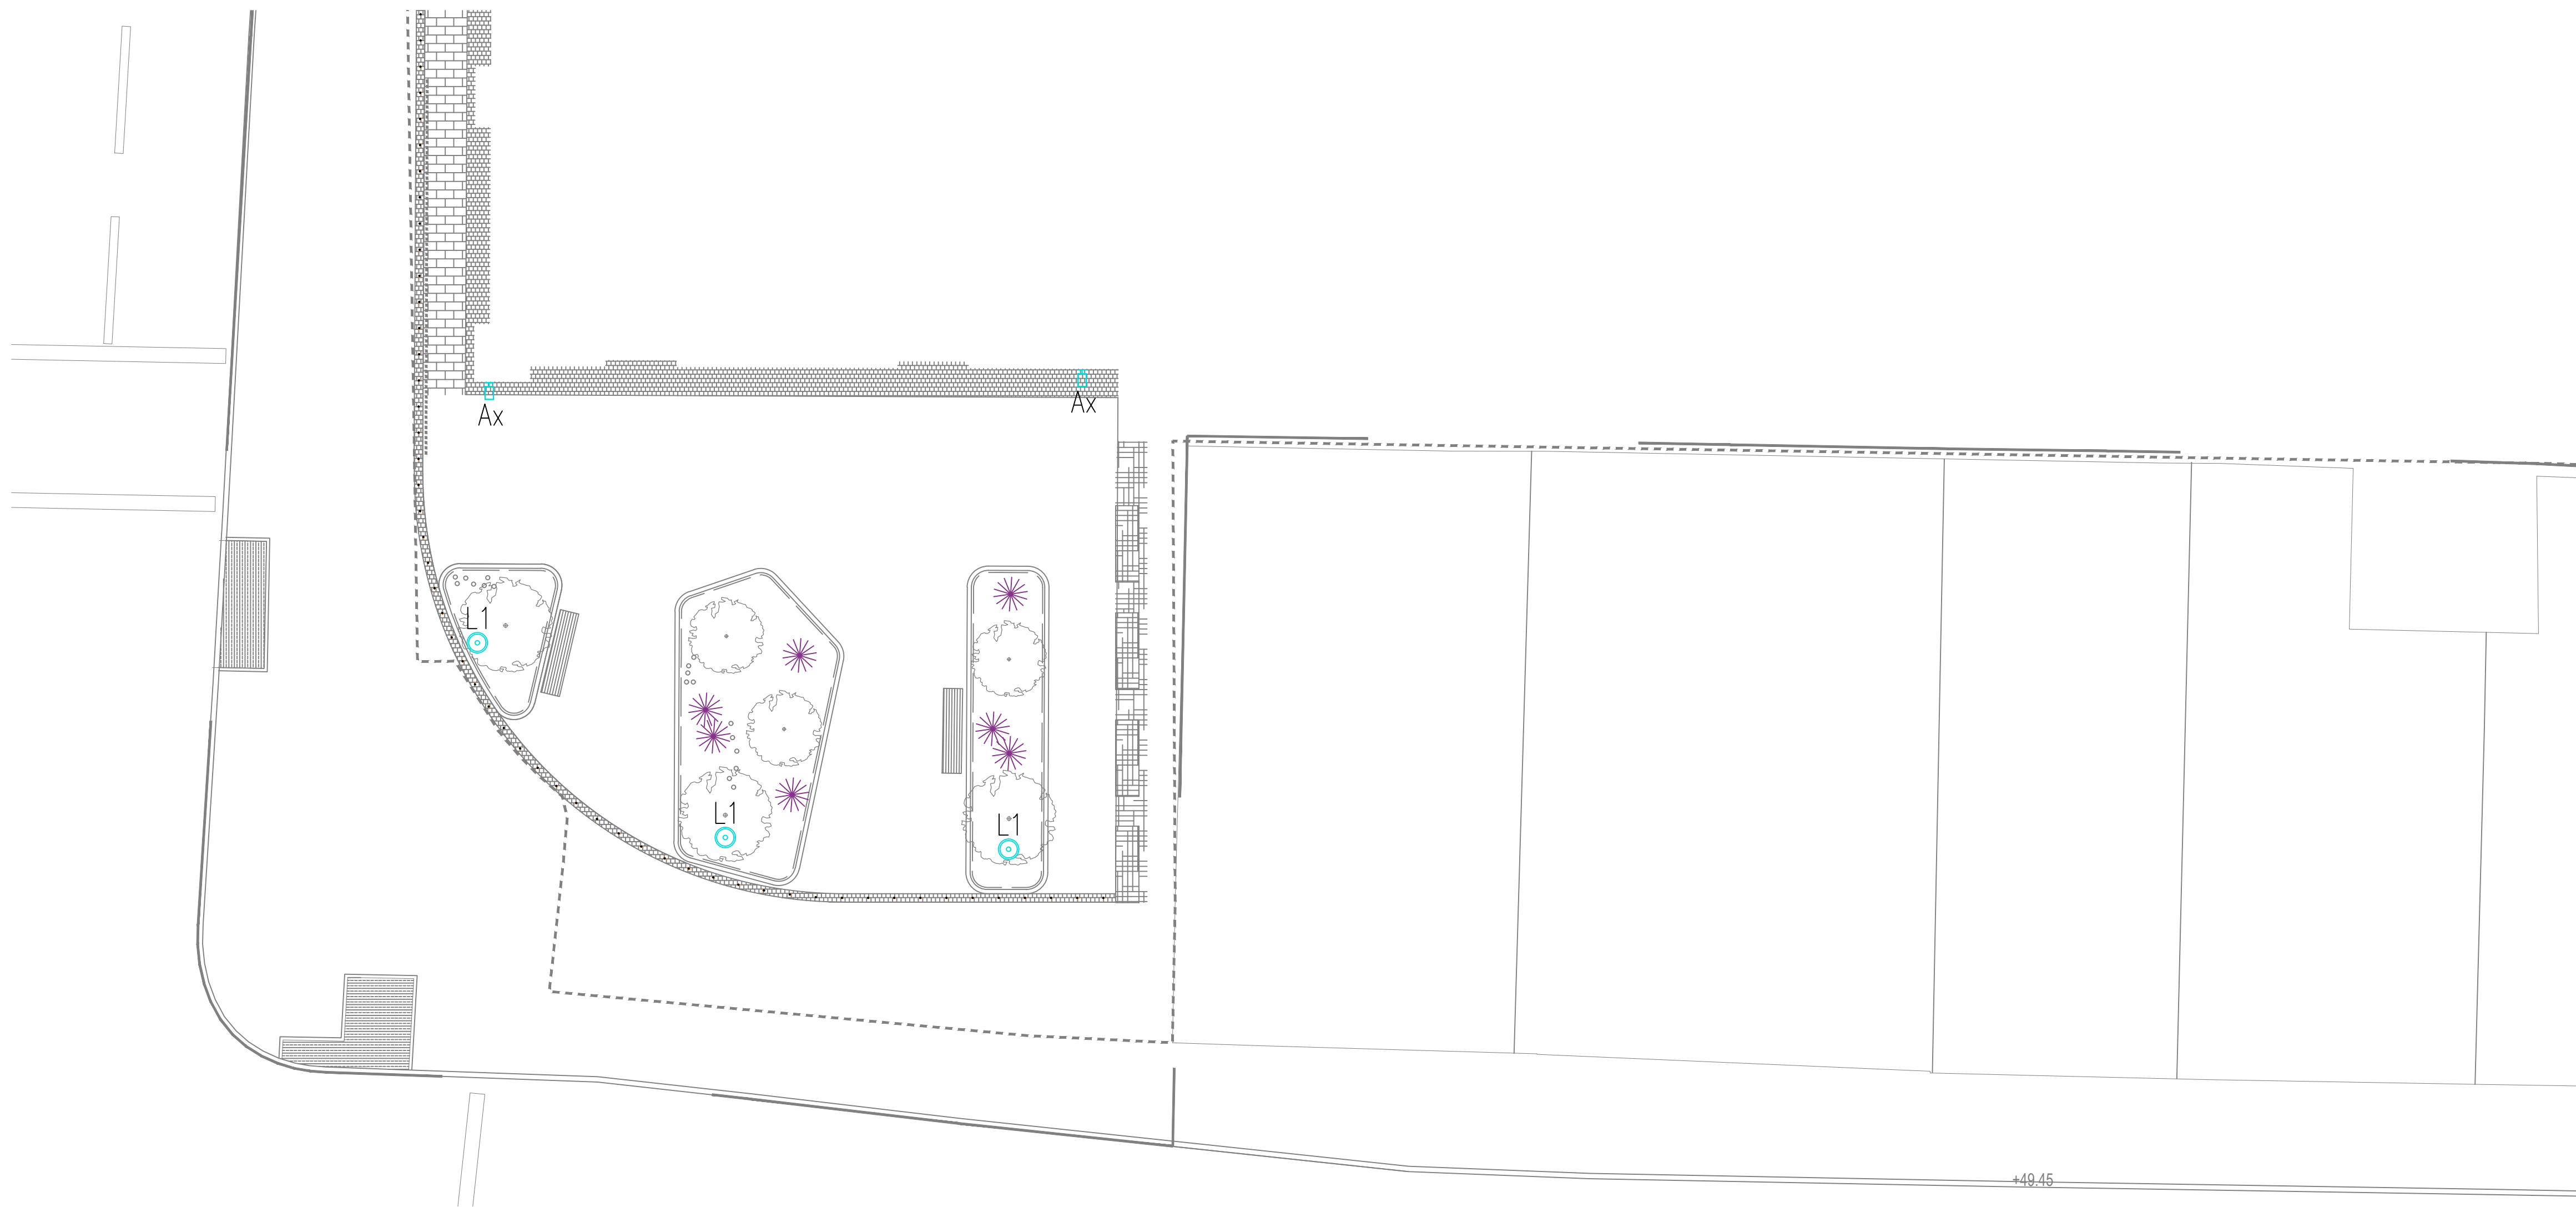

SITE PLAN @ 1:100

1.5sqmm LSF/LSF cables in trunking/conduit.

230v supply from local distribution board.

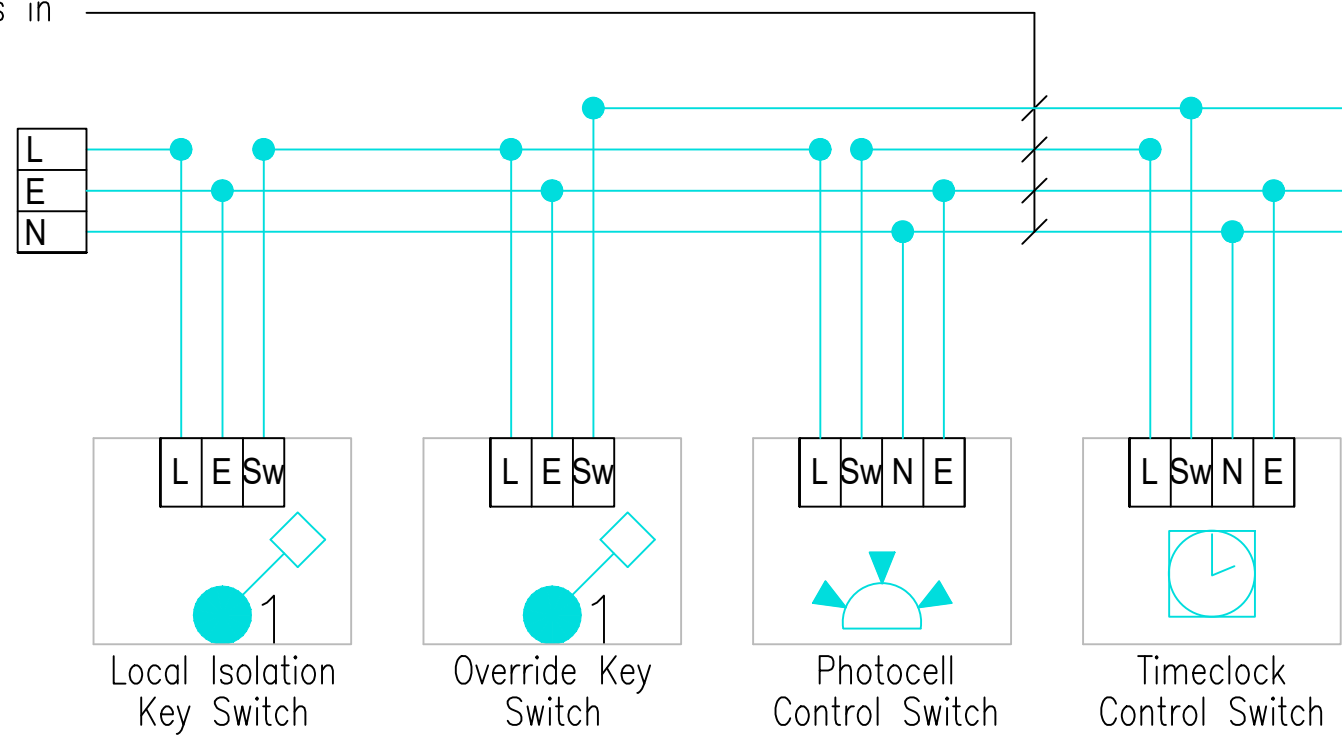

Control wiring to coil of 20Amp DP contactors controlling each outgoing external lighting circuit.

LEGEND

SYMBOL	MANUFACTURER	DESCRIPTION
L1	ANSELL	LAZOR PROJECTOR 2 UPLIGHTER
Ax	ASD	HORIZON ROUND

EXTERNAL LIGHTING

Automatic lighting control with Timeclock & Photocell Sensor

- GENERAL NOTES
- THIS DRAWING IS COPYRIGHT AND SHALL NOT BE REPRODUCED WITHOUT PERMISSION
 - THIS DRAWING IS TO BE READ IN CONJUNCTION WITH ALL OTHER DISCIPLINES, DRAWINGS, SCHEDULES AND SPECIFICATIONS, LEGENDS AND STANDARD DETAILS
 - DIMENSIONS GOVERN ON ALL DRAWINGS AND DETAILS. SHOULD ANY DISCREPANCIES BE FOUND ON THIS DRAWING AND ANY ASSOCIATED DRAWINGS OR SPECIFICATIONS, THIS SHOULD BE BROUGHT TO THE ATTENTION OF BRENTWOOD DESIGN IMMEDIATELY
 - CONTRACTORS MUST CHECK AND VERIFY ALL INFORMATION / DIMENSIONS / LEVELS IN CONJUNCTION WITH ALL RELEVANT DRAWINGS AND ACTUAL SITE CONDITIONS BEFORE COMPLETING ANY MANUFACTURING / INSTALLATION DRAWINGS OR COMMENCING SITE INSTALLATION WORK
 - DO NOT SCALE FROM THIS DRAWING
- NOTES

A	11/12/23	PLANNING ISSUE	SA	JO
Rev	Date	Description	Dwn	Ok
BRENTWOOD CONSULTING ENGINEERS				
First Floor, 21 Hornbeam Square South, Harrogate, HG2 8BN T: 01423 878892 W: www.brentwoodgroup.co.uk Jacton House, 10 Good Street, Manchester, M4 6AW T: 0161 553 4639				
CLIENT: RG GROUP				
PROJECT: SWAN ST HOUSE, MANCHESTER				
DRAWING TITLE: EXTERNAL LIGHTING LAYOUT				
DRAWING STATUS: PLANNING				
DRAWN BY: SA	CHK BY: JO	DATE: 11/12/23	SCALE: 1:100 @A1	REVISION: A
DRAWING No: 5527-E-401-LA				