


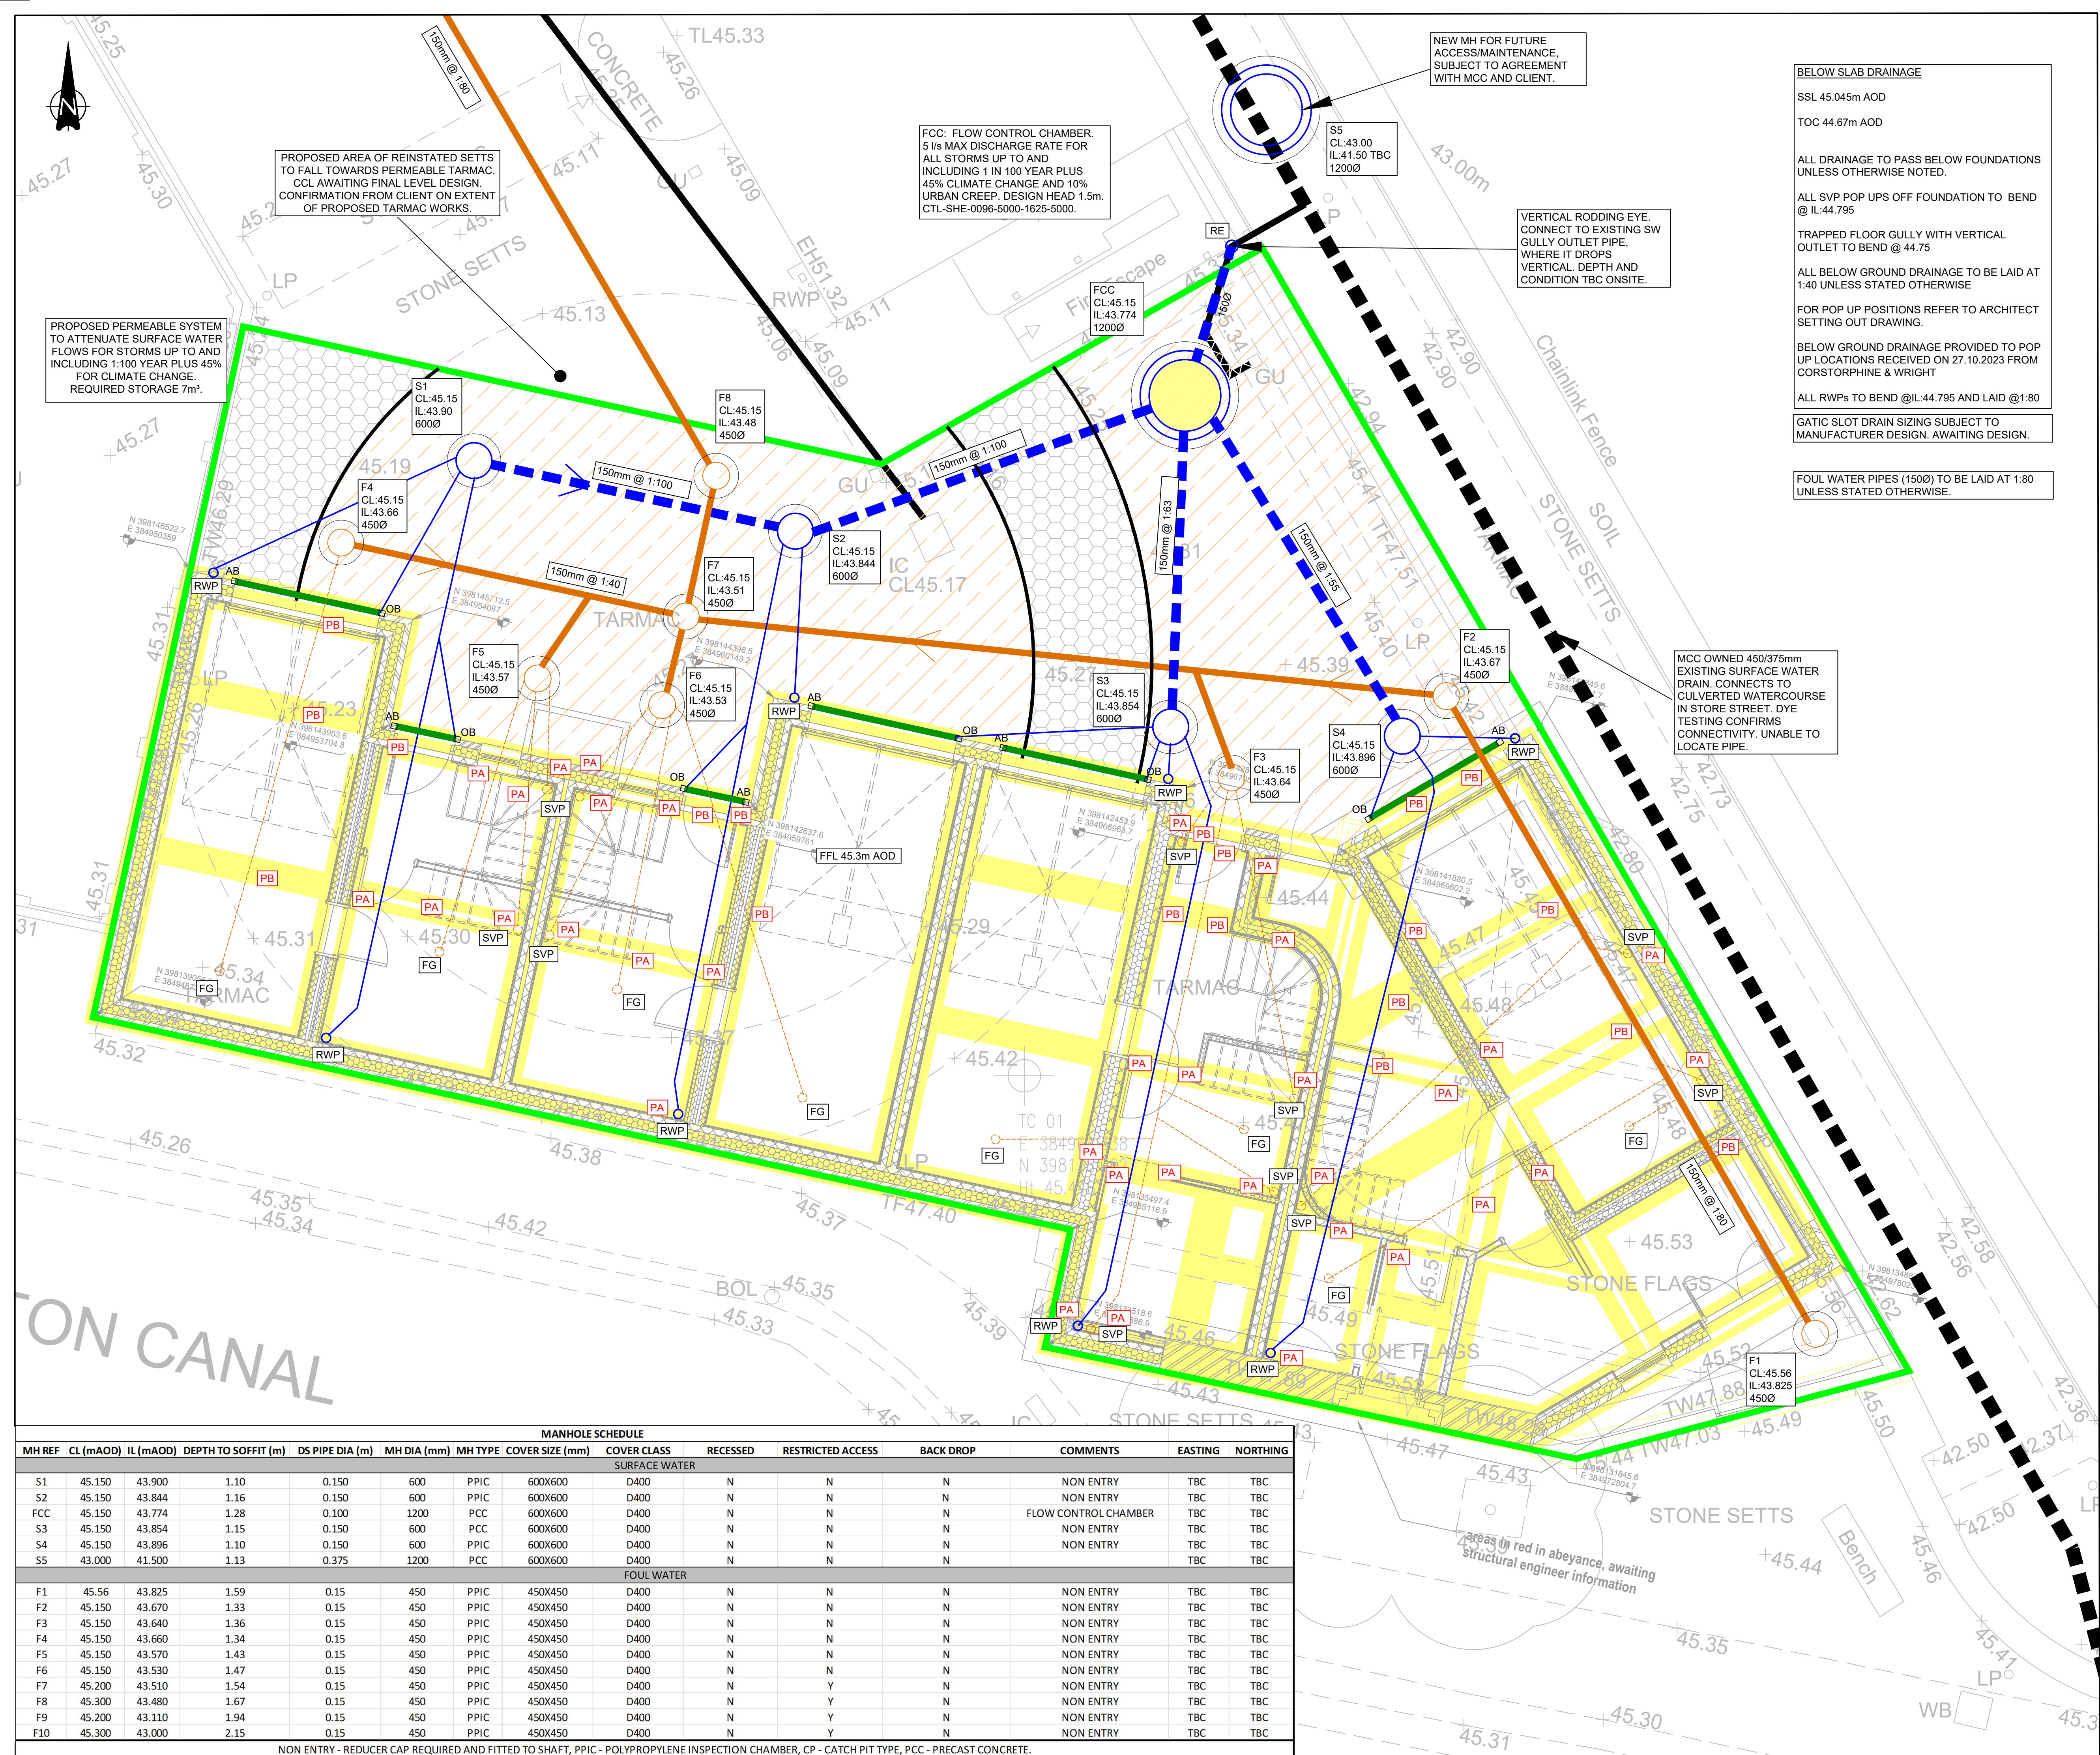

KEY:

SITE BOUNDARY TBC

EXISTING COMBINED UU SEWER

EXISTING CULVERTED WATERCOURSE

EXISTING PRIVATE COMBINED DRAIN

EXISTING SURFACE WATER DRAIN (MCC OWNED)

PROPOSED SURFACE PERFORATED PIPE (150mmØ) AND CHAMBER

PROPOSED FOUL WATER PIPE (150mmØ) AND CHAMBER

PROPOSED FLOW CONTROL HYDRO-BRAKE OR SIMILAR APPROVED.

P01- PROPOSED PERMEABLE TARMAC

P02- PROPOSED SETT REINSTATEMENT

PROPOSED RAIN WATER PIPE AND 100mm CONNECTION

PROPOSED SOIL VENT PIPE AND 100mm CONNECTION

PROPOSED TRAPPED FLOOR GULLY WITH VERTICAL OUTLET AND 100mm CONNECTION

ACO CHANNEL DRAIN WITH OUTLET AND ACCESS BOXES

PB = PASS BELOW FOUNDATION

PA = PASS ABOVE FOUNDATION

FOUNDATIONS

- DRAWINGS BASED ON THE FOLLOWING INFORMATION**
- ARCHITECT LAYOUT - 27.10.23 (20005-CWA-BC-00-DR-A-2001-02_GROUND FLOOR PLAN)
 - POP UP LOCATIONS - 27.10.23 (20005-CWA-BC-00-DR-A-2201-02_ABOVE GROUND DRAINAGE)
 - FOUNDATION DESIGN - 27.07.23 (1-21074-CCL-ZZ-00-DR-S-002_P1)

SEE DRAWING 21074-CCL-XX-XX-DR-C-92503 FOR DRAINAGE LOCATION PLAN, CONSTRUCTION SPECIFICATION DETAILS AND DRAWING NOTES

P03 08.12.23	STAGE 4	AA	CD	CD
P02 28.04.23	STAGE 3	CD	JAP	JAP
P01 17.12.21	FOR INFORMATION	CD	PM	PM
Rev	Date	Description	By	Check App.

COPYRIGHT: THE COPYRIGHT OF THIS DRAWING IS VESTED IN CLANCY CONSULTING. IT SHALL NOT BE USED WITHOUT PERMISSION BY ANYONE FOR ANY PURPOSE. DO NOT SCALE THIS DRAWING ELECTRONICALLY OR MANUALLY. WORK TO FIGURED DIMENSIONS ONLY. ALL DIMENSIONS ARE IN MILLIMETRES UNLESS STATED OTHERWISE. DO NOT TURN ON LAYERS THAT HAVE BEEN TURNED OFF. DO NOT TURN LAYERS THAT HAVE BEEN FROZEN.

Client	VICTOR (M1) LTD
Project	PARADISE MEWS
Office	MANCHESTER
Discipline	CIVILS
Title	DRAINAGE LAYOUT

Scale @ A1	1:50	Status	STAGE 4
------------	------	--------	---------



www.clancy.co.uk

Originator	Job Number	Discipline	Building/Zone
CCL	1-21074	C	XX
Type	Level	Drawing No.	Revision
DR	XX	92500	P03

MANHOLE SCHEDULE											
MH REF	CL (mAOD)	IL (mAOD)	DEPTH TO SOFFIT (m)	DS PIPE DIA (m)	MH DIA (mm)	MH TYPE	COVER SIZE (mm)	COVER CLASS	RECESSED	RESTRICTED ACCESS	BACK DROP
SURFACE WATER											
S1	45.150	43.900	1.10	0.150	600	PPIC	600X600	D400	N	N	N
S2	45.150	43.844	1.16	0.150	600	PPIC	600X600	D400	N	N	N
FCC	45.150	43.774	1.28	0.100	1200	PCC	600X600	D400	N	N	N
S3	45.150	43.854	1.15	0.150	600	PCC	600X600	D400	N	N	N
S4	45.150	43.896	1.10	0.150	600	PPIC	600X600	D400	N	N	N
S5	43.000	41.500	1.13	0.375	1200	PCC	600X600	D400	N	N	N
FOUL WATER											
F1	45.56	43.825	1.59	0.15	450	PPIC	450X450	D400	N	N	N
F2	45.150	43.670	1.33	0.15	450	PPIC	450X450	D400	N	N	N
F3	45.150	43.640	1.36	0.15	450	PPIC	450X450	D400	N	N	N
F4	45.150	43.660	1.34	0.15	450	PPIC	450X450	D400	N	N	N
F5	45.150	43.570	1.43	0.15	450	PPIC	450X450	D400	N	N	N
F6	45.150	43.530	1.47	0.15	450	PPIC	450X450	D400	N	N	N
F7	45.200	43.510	1.54	0.15	450	PPIC	450X450	D400	N	Y	N
F8	45.300	43.480	1.67	0.15	450	PPIC	450X450	D400	N	Y	N
F9	45.200	43.110	1.94	0.15	450	PPIC	450X450	D400	N	Y	N
F10	45.300	43.000	2.15	0.15	450	PPIC	450X450	D400	N	Y	N

NON ENTRY - REDUCER CAP REQUIRED AND FITTED TO SHAFT, PPIC - POLYPROPYLENE INSPECTION CHAMBER, CP - CATCH PIT TYPE, PCC - PRECAST CONCRETE.