


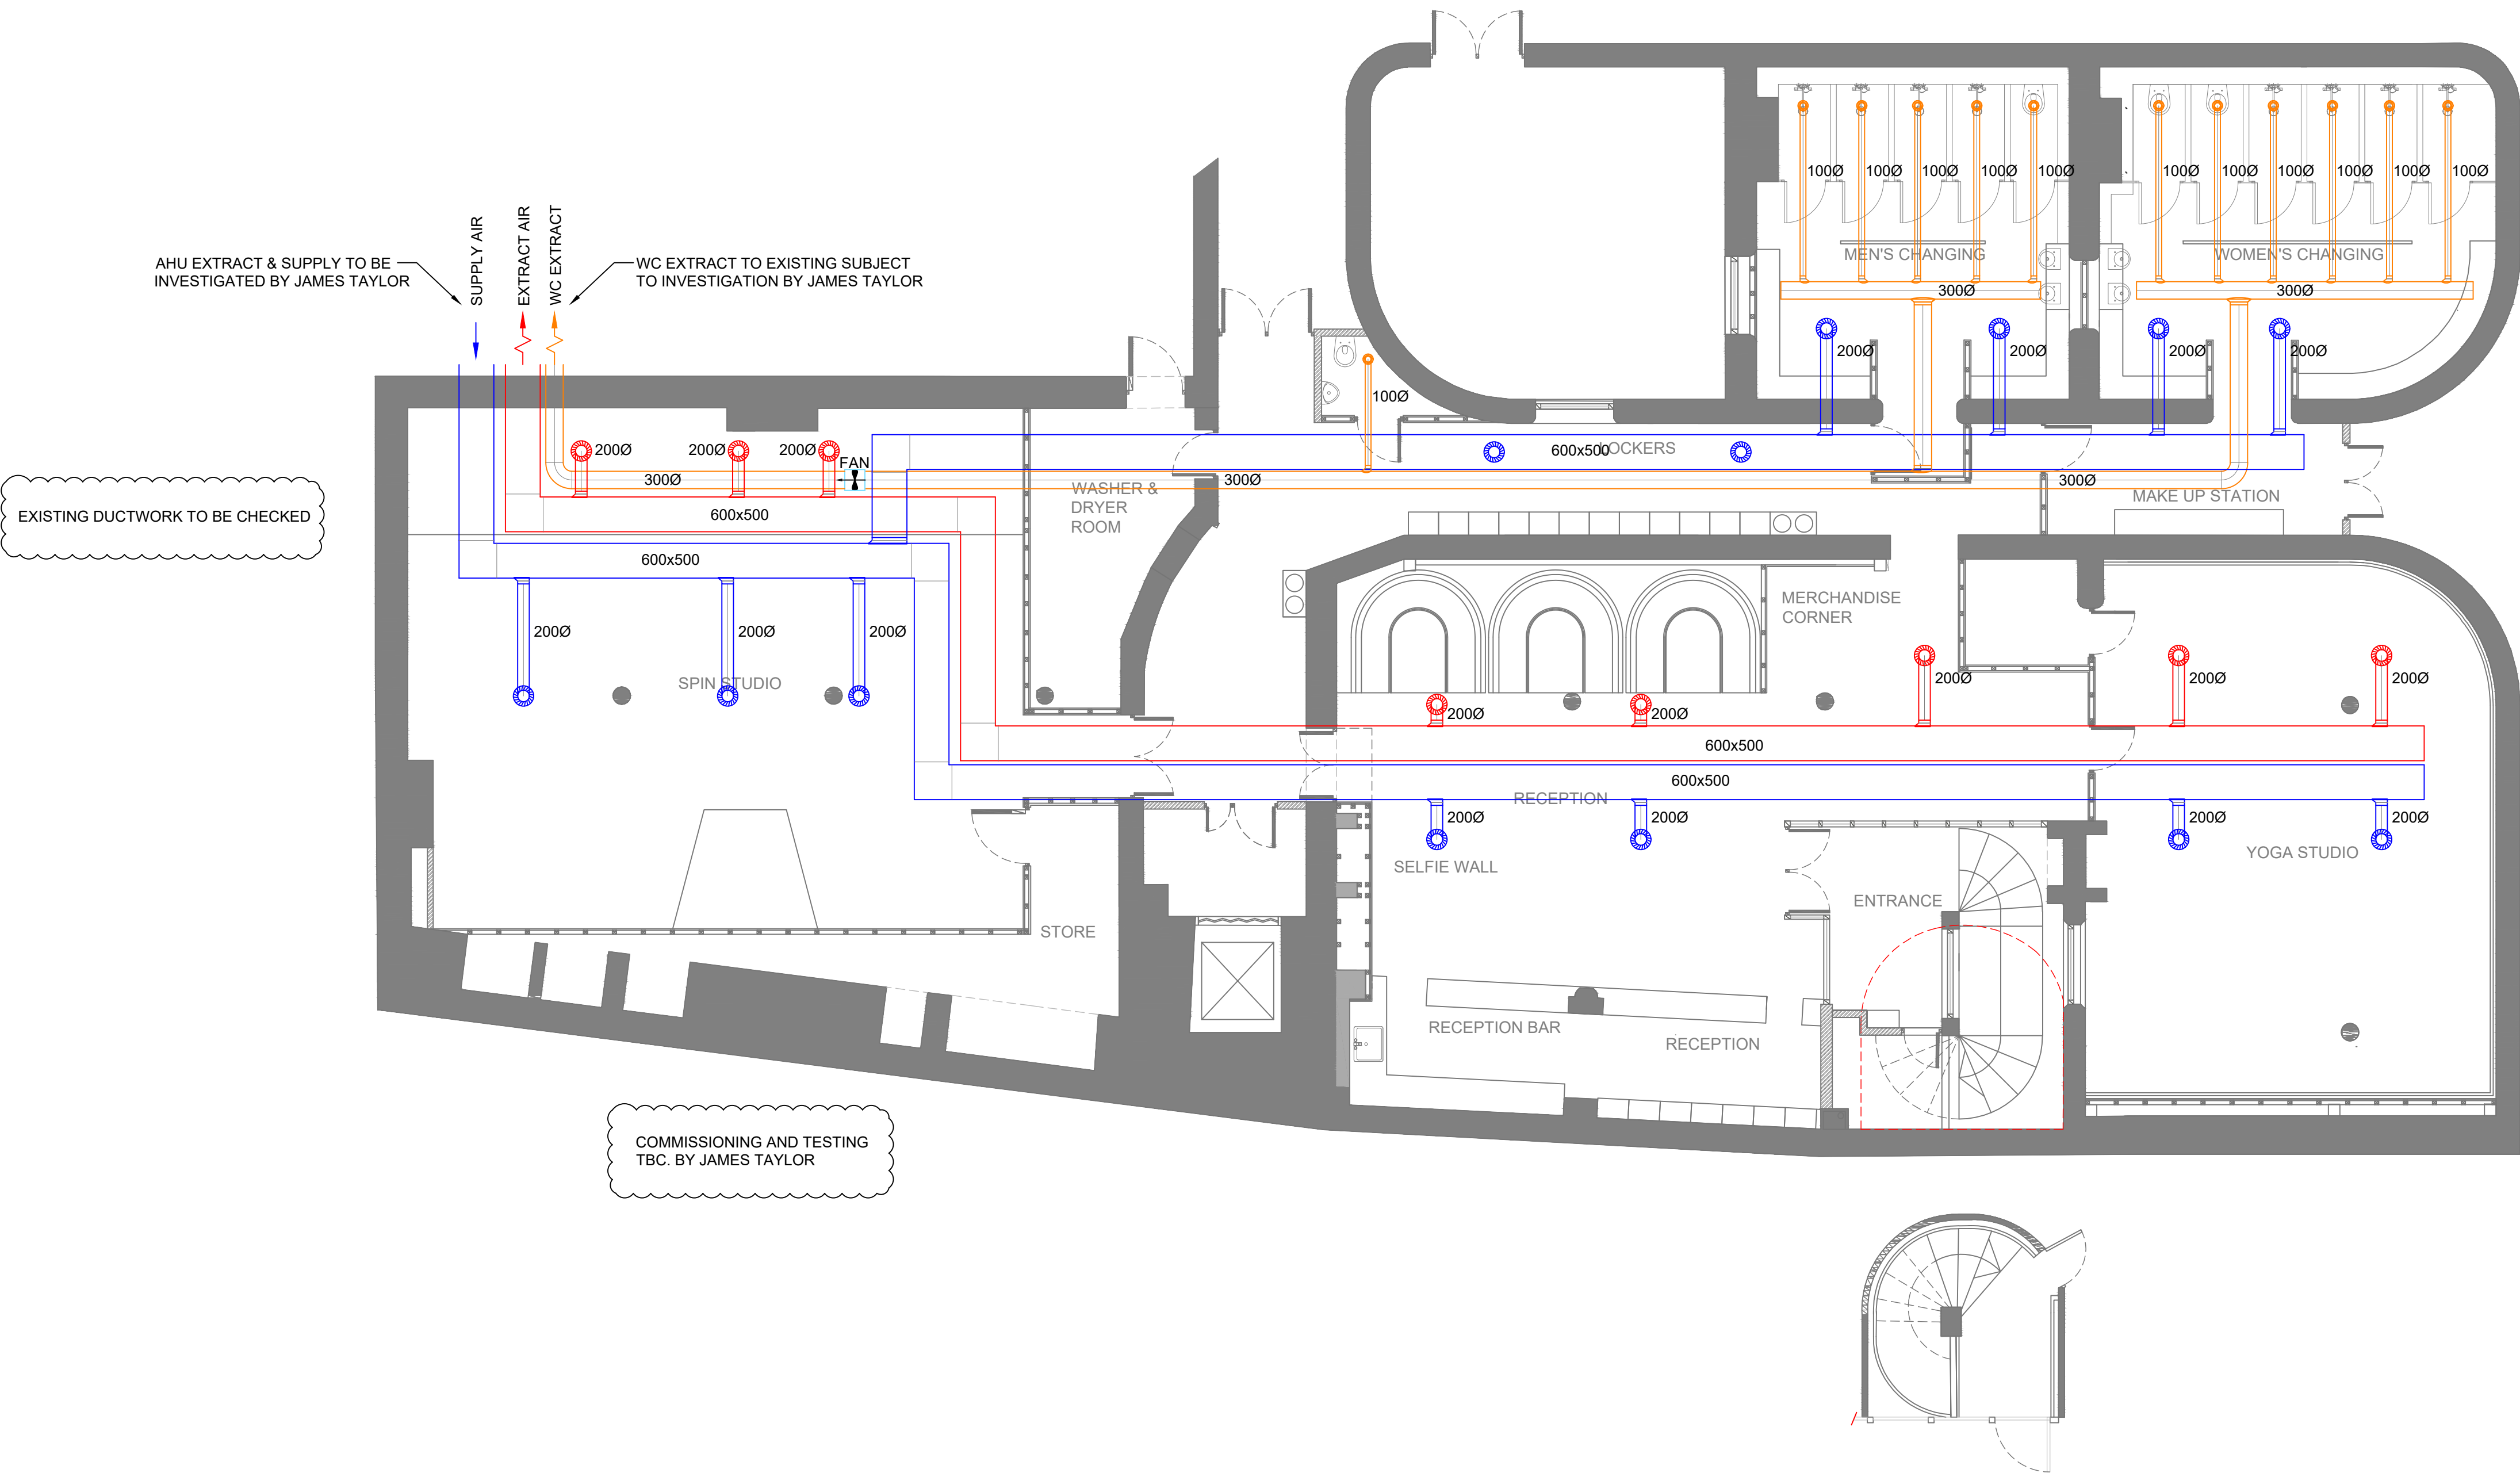

P1	PRELIMINARY	06.09.23
Rev	Description	Date
<div>AP Electrical Services</div> <p>5 FOUNDRY GATE WOMBWELL BARNESLEY SOUTH YORKSHIRE, S73 0LF Tel : 07702596381 Enquiriesapelectricalservices@gmail.com</p> <p>Client: RYDE STUDIO</p> <p>Project: BARTON ARCADE</p> <p>Drawing Title: MECHANICAL SERVICES VENTILATION LAYOUT</p>		
CAD: MEP	CHK: AP	Date: 06/09/23
Drawing Status: PRELIMINARY		Scale @ A1 1:75
Drawing N°: M02		Revision: P1