
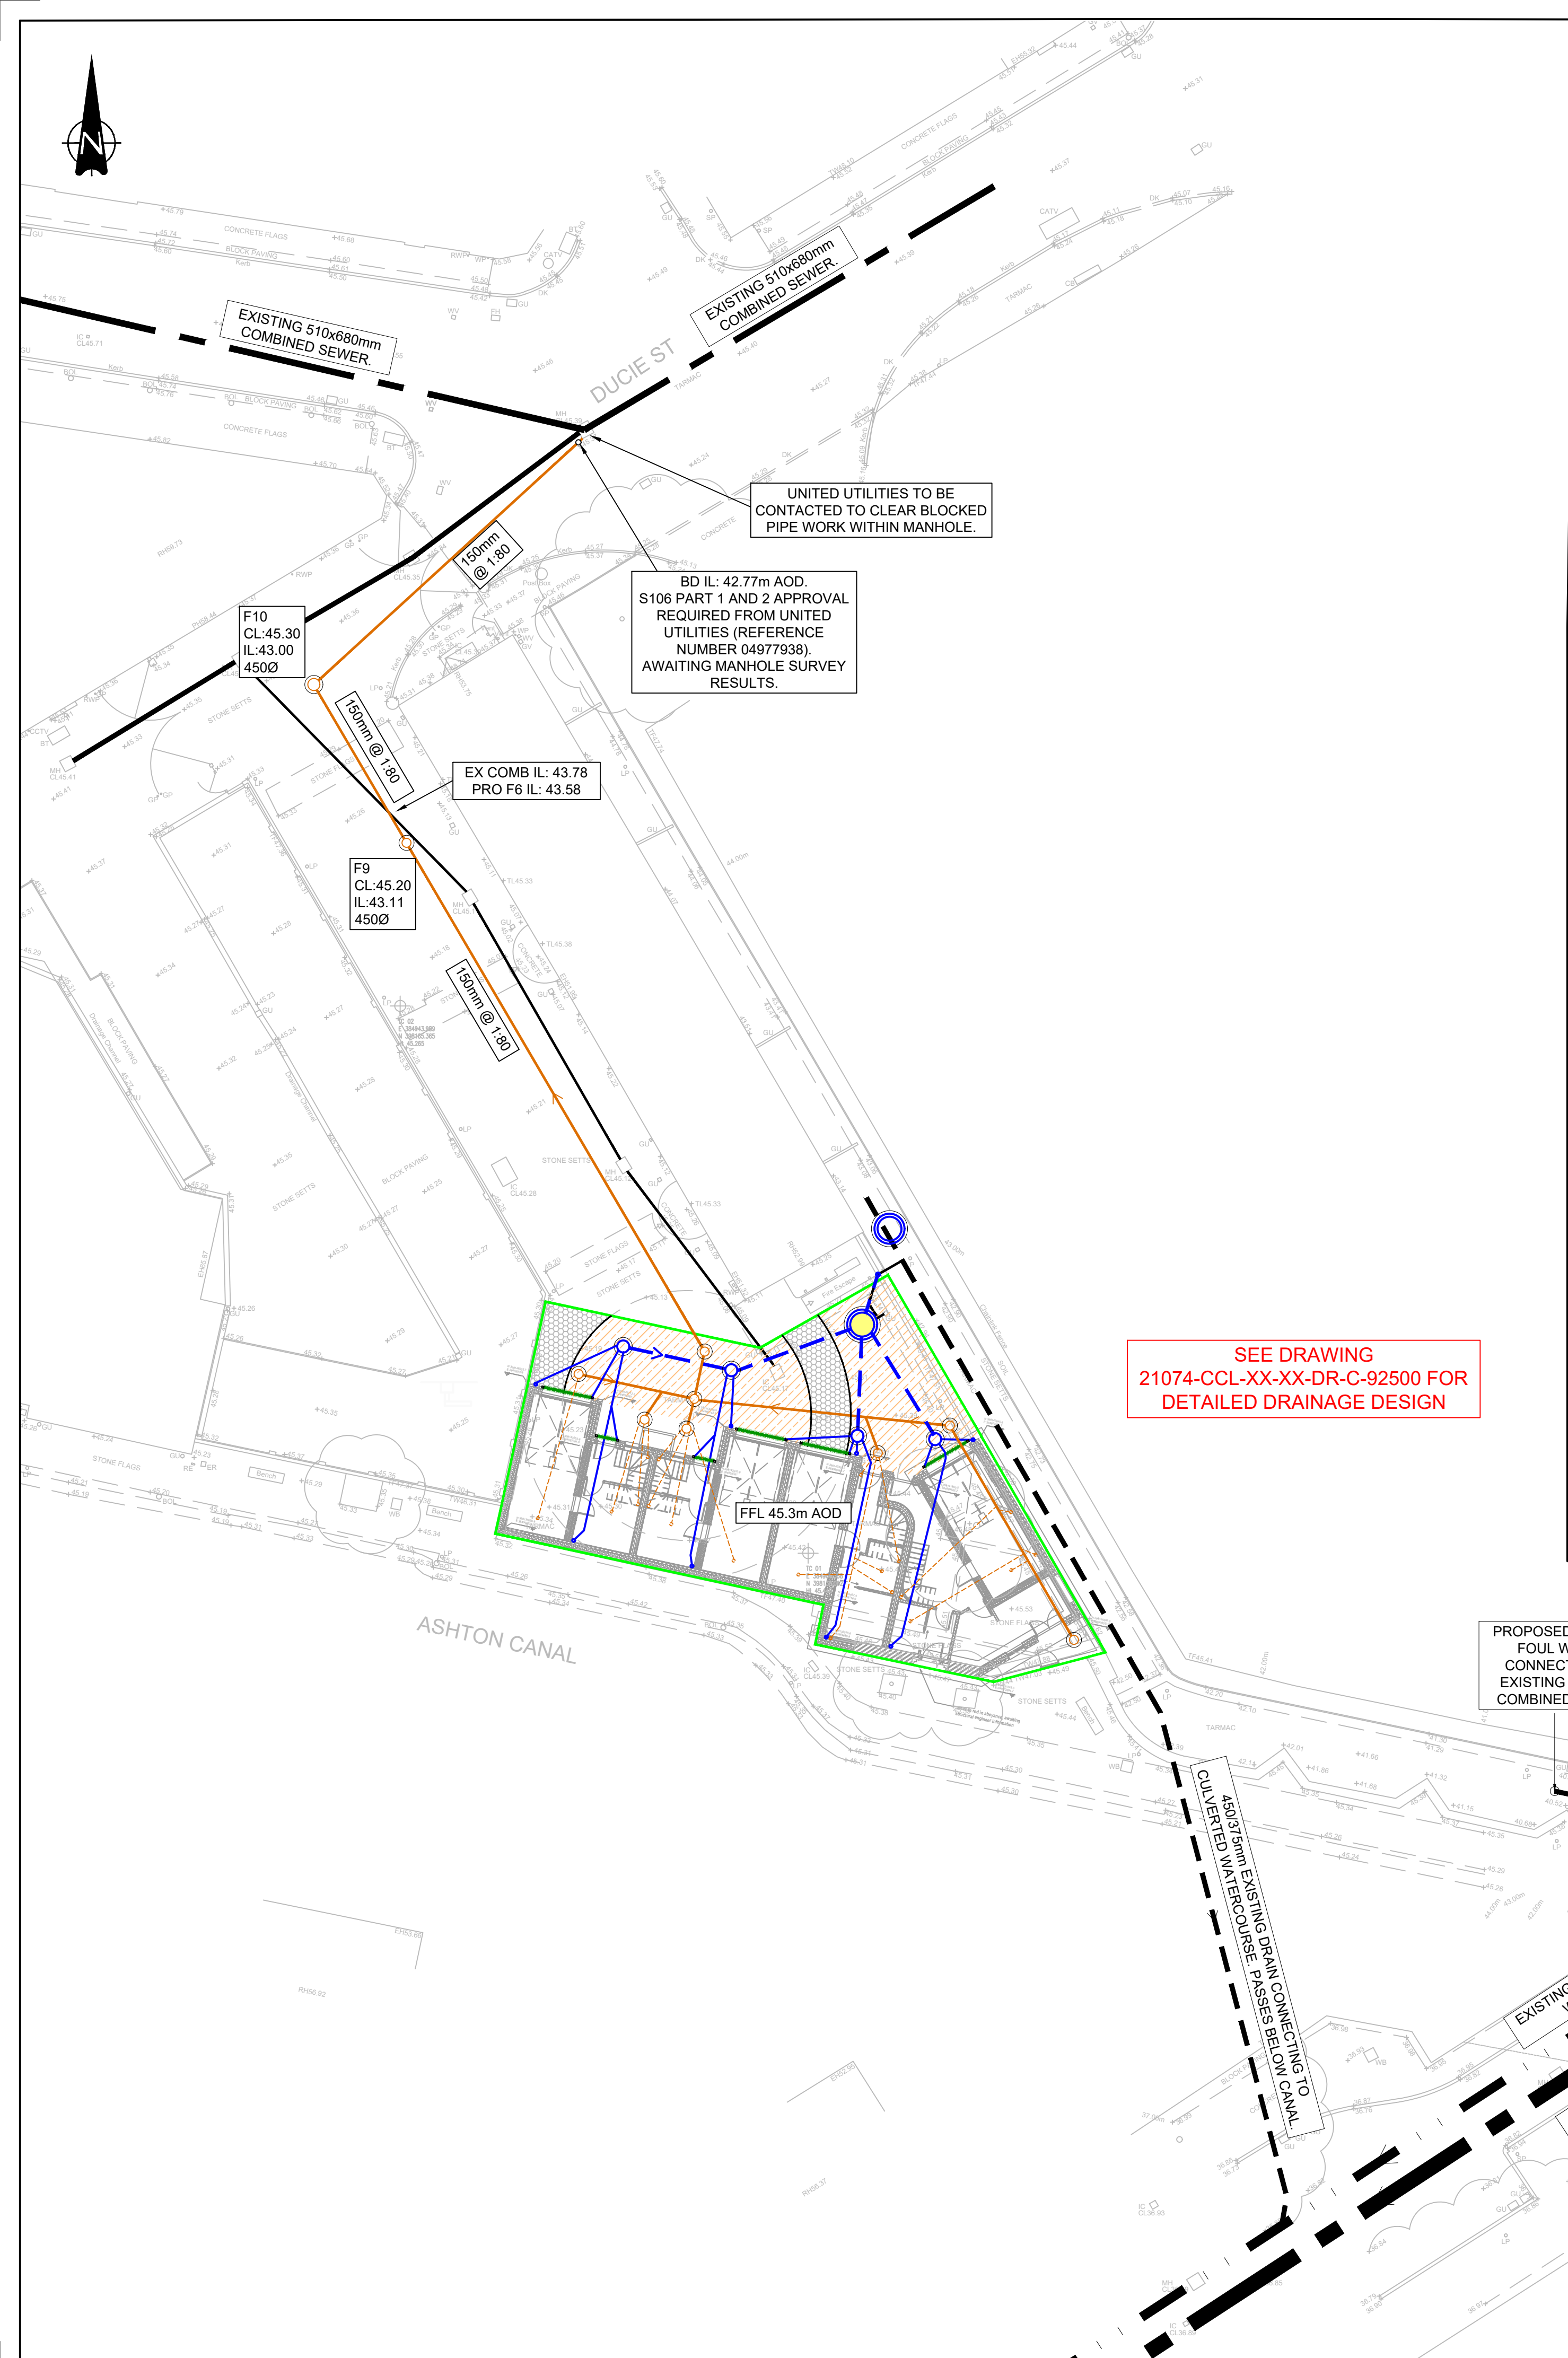


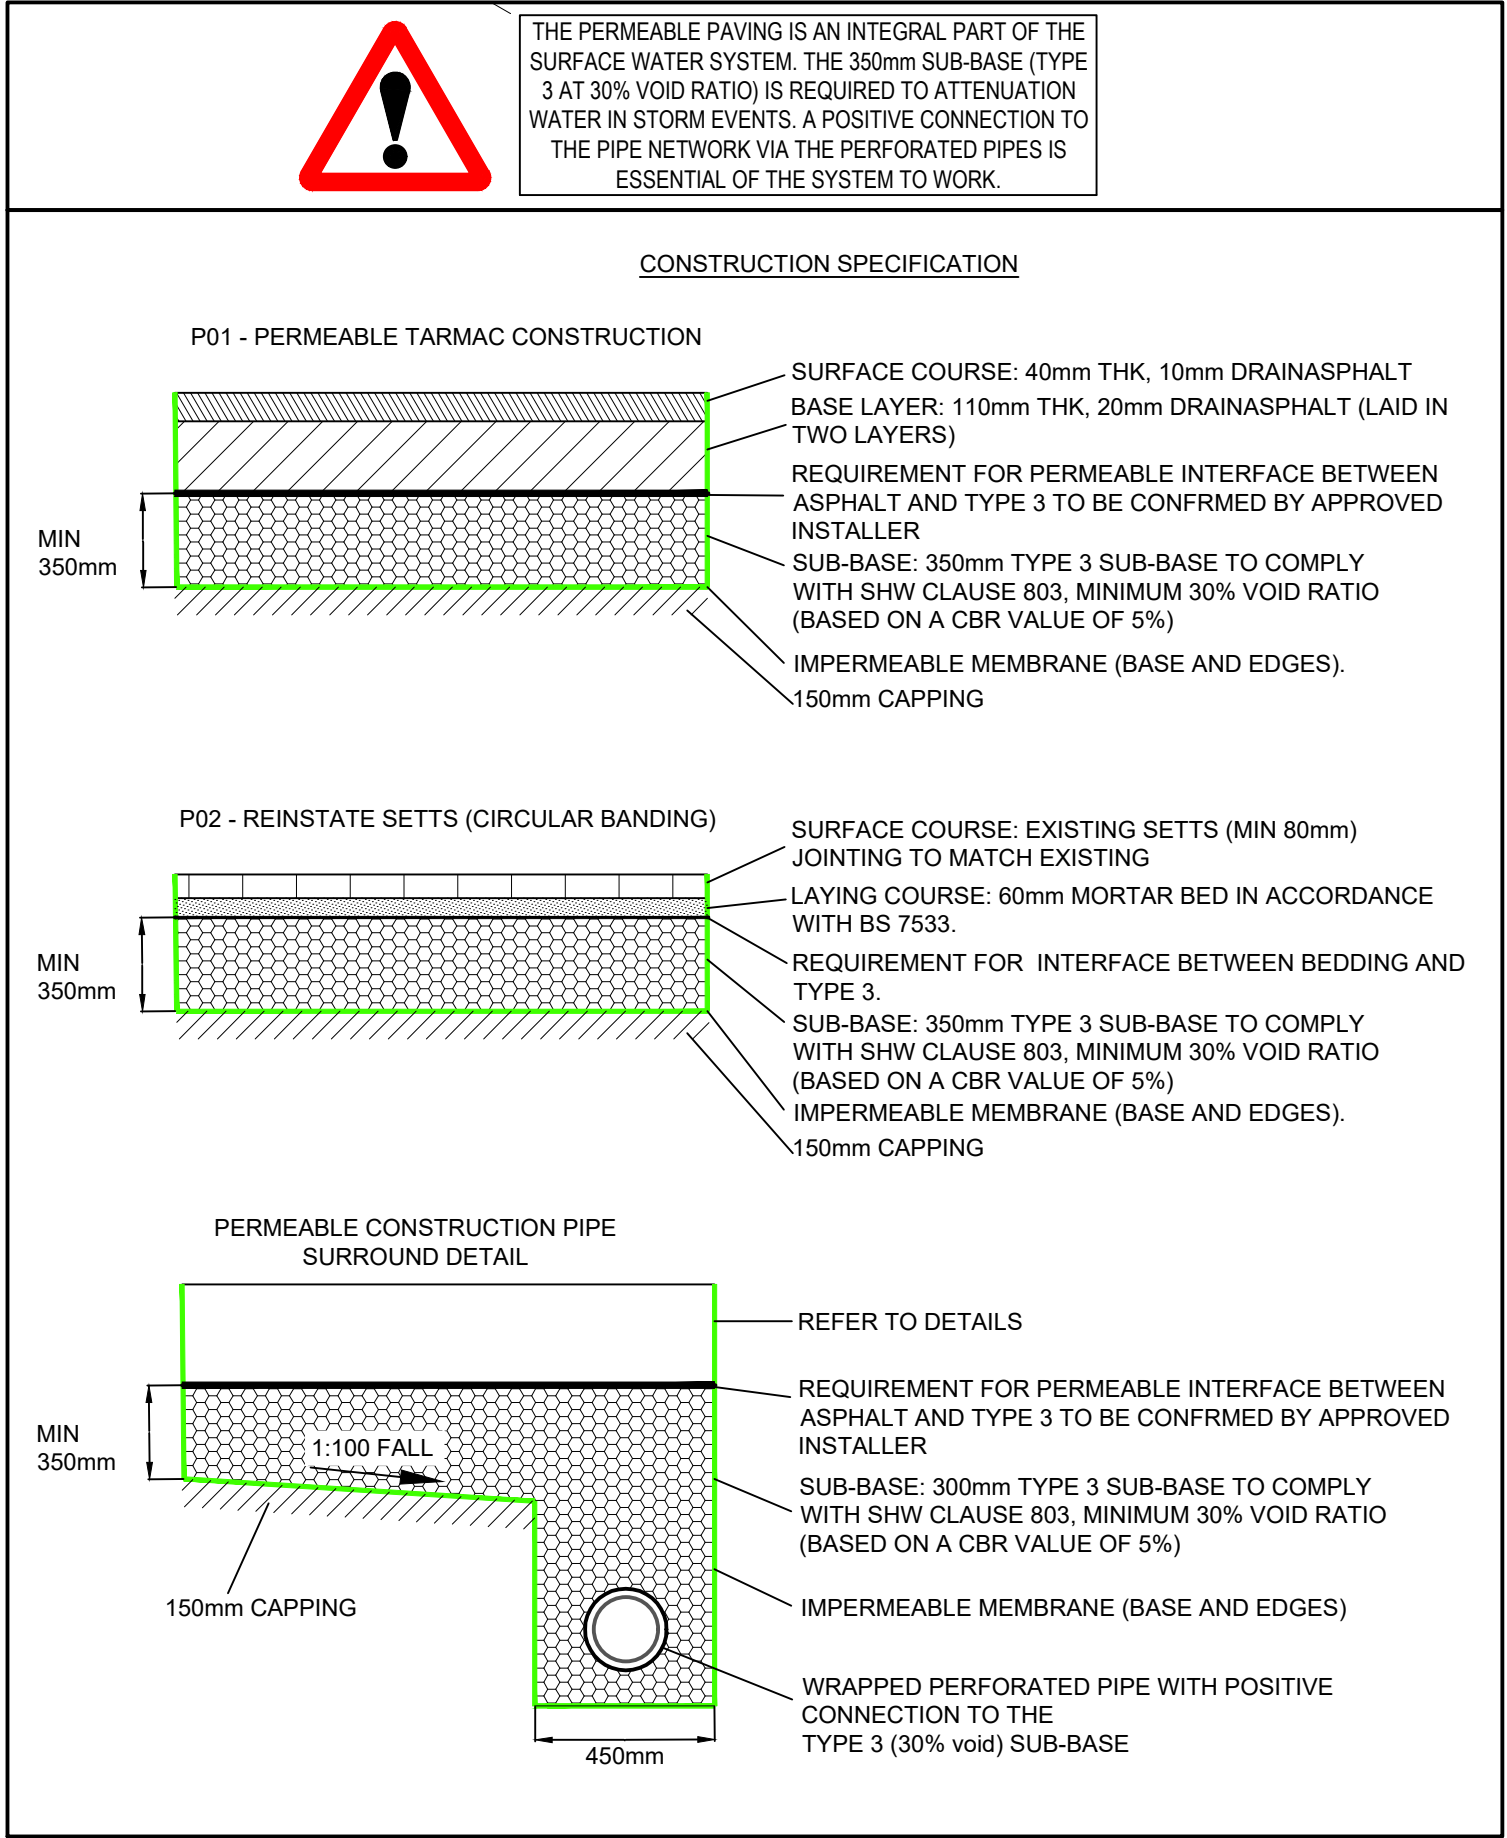

- GENERAL NOTES:**
- THIS DRAWING IS TO BE READ IN CONJUNCTION WITH ALL RELEVANT ARCHITECTS AND ENGINEERS DRAWINGS AND SPECIFICATIONS.
 - ALL ADAPTABLE DRAINAGE WORKS INCLUDING WORKS TO EXISTING PUBLIC SEWERS TO BE UNDERTAKEN IN ACCORDANCE WITH 'SEWERS FOR ADOPTION 7th EDITION' AND 'CIVIL ENGINEERING SPECIFICATION FOR THE WATER INDUSTRY 7th EDITION' AND CONSTRUCTED TO THE RELEVANT STATUTORY UNDERTAKERS DETAILS.
 - ALL PRIVATE DRAINAGE WORKS TO BE IN ACCORDANCE WITH 'CIVIL ENGINEERING SPECIFICATION FOR THE WATER INDUSTRY 7th EDITION', BS EN 752 2017 DRAIN AND SEWER SYSTEMS OUTSIDE BUILDINGS AND THE BUILDING REGULATIONS APPROVED DOCUMENT H.
 - DO NOT SCALE THIS DRAWING. ANY AMBIGUITIES, OMISSIONS AND ERRORS ON DRAWINGS SHALL BE BROUGHT TO THE ENGINEERS ATTENTION IMMEDIATELY. ALL DIMENSIONS MUST BE CHECKED / VERIFIED ON SITE.
 - DESIGN BASED ON TOPOGRAPHICAL SURVEY AND INFORMATION AVAILABLE AT THE TIME OF THE DESIGN.
 - OUTFALL CONNECTION(S) SUBJECT TO AGREEMENT WITH THE APPROVING AUTHORITY.
 - ALL DIMENSIONS ARE IN METRES AND LEVELS IN METRES ABOVE ORDNANCE DATUM UNLESS OTHERWISE NOTED.
 - COVER LEVELS, GULLY POSITIONS, AND BUILDINGS LOCATION ARE APPROXIMATE AND SHALL BE CONFIRMED BY ARCHITECT/ LANDSCAPE ARCHITECT. CONTRACTOR TO ALLOW FOR ADJUSTMENT TO SUIT AGREED POSITIONS AND FINISHED LEVELS, AND CONFIRM ALL COVER LEVELS ON SITE.
 - ALL BELOW SLAB DRAINAGE CONNECTIONS SHOWN TO THE PENETRATION POSITIONS ARE INDICATIVE ONLY. REFER TO DIMENSIONED LOCATIONS AND DIAMETERS ON ARCHITECT'S GROUND FLOOR SETTING-OUT PLANS.
 - ALL UNDERGROUND FOUL DRAINAGE SHOULD BE SUITABLY VENTED AT OR NEAR TO THE HEAD OF RUNS.
 - ALL ACCESS FITTINGS, STACKS, RIMPS AND GULLIES TO BE RODDABLE. ALL TO HAVE LOW LEVEL RODDING ACCESS PLATES UNLESS AN ALTERNATIVE MEANS OF ACCESS IS AGREED. ACCESS POINT TO BE ABOVE ANY GROUND FLOOR CONNECTED APPLIANCE SPILL LEVEL.
 - LARGE ACCESS FITTING REQUIRED ABOVE GROUND WHERE GREATER THAN 12M UP TO 22M TO A JUNCTION. SMALL ACCESS FITTING REQUIRED UP TO 12M TO A JUNCTION.
 - ALL GULLY AND CHANNEL DRAIN OUTLETS AND TERMINATION POINTS TO BE TRAPPED AND RODDABLE. INTERNAL GULLIES AND CHANNEL DRAINS TO BE SPECIFIED BY OTHERS.
 - WHERE NO WC'S ARE CONNECTED UPSTREAM, UNDERSLAB FW DRAINAGE TO BE LAID AT 1:40 MIN. AFTER THE CONNECTION OF AT LEAST 1 NO WC, A MIN. FALL OF 1:80 APPLIES.
 - ALL CONNECTIONS FROM POP-UPS TO BE LAID AT A CONSTANT GRADIENT TO JUNCTION/ INSPECTION CHAMBER/ MANHOLE UNLESS NOTED OTHERWISE. ANY ISSUES RELATING TO CLASHES WITH FOUNDATIONS ARE TO BE FORWARDED TO THE ENGINEER, ALLOWING SUFFICIENT TIME FOR AN ALTERNATIVE SOLUTION TO BE PROPOSED.
 - INVERT LEVELS AT MANHOLES/ INSPECTION CHAMBERS TO BE USED TO SET OUT PIPEWORK. PIPE GRADIENTS ARE SHOWN INDICATIVELY ONLY.
 - ALL PIPE DIAMETERS GIVEN ARE NOMINAL INTERNAL PIPE DIAMETERS.
 - THIS DRAWING IS TO BE READ IN CONJUNCTION WITH ALL RELEVANT ARCHITECTS AND ENGINEERS DRAWINGS AND SPECIFICATIONS.
 - ALL SEWERS, UNLESS AGREED OTHERWISE STATED, SHALL BE:
 - 100mm to 300mm DIA TO BE VITRIFIED CLAY.
 - 375mm DIA AND GREATER TO BE CLASS 120 CONCRETE PIPES.
 - AS AN ALTERNATIVE THE CONTRACTOR MAY USE AN APPROVED UNPLASTICISED POLYVINYL CHLORIDE (PVCU) WITH APPROVAL FROM THE ENGINEER.
 - SEWER PIPES TO BE LAID IN MAXIMUM 3 METRE LENGTHS UNLESS THERE IS A SPECIFIC OPERATIONAL NEED TO LAY LONGER LENGTHS.
 - THE FIRST PIPE OUT OF MANHOLES TO BE AS SHORT AS PRACTICABLE SO AS TO PROVIDE A FLEXIBLE JOINT AS CLOSE AS POSSIBLE TO THE OUTSIDE FACE OF THE CONCRETE SURROUND AND CONNECTED TO A LENGTH OF ROCKER PIPE.
 - ALL NEW CONNECTIONS INTO EXISTING MANHOLES (OR INTO EXISTING SEWERS) TO BE 'SOFFITS LEVEL' UNLESS OTHERWISE NOTED.
 - ALL ADAPTABLE DRAINAGE PIPES WILL REQUIRE A MINIMUM OF 1200mm COVER, IN ACCORDANCE WITH SEWERAGE UNDERTAKERS REQUIREMENTS. WHERE THIS IS NOT ACHIEVED, IT WILL BE NECESSARY TO AGREE THE BED AND SURROUND DETAIL.
 - ALL PRIVATE DRAINAGE PIPES WITH A COVER OF LESS THAN 600mm IN NON-TRAFFICKED AREAS AND LESS THAN 1200mm IN TRAFFICKED AREAS TO BE BEDDED AND SURROUNDED IN CONCRETE (CLASS Z), COMPRESSIBLE MATERIAL SHALL BE PROVIDED AT EVERY PIPE JOINT. WHERE COVER EXCEEDS THIS DEPTH, PIPES ARE TYPICALLY BEDDED AND SURROUNDED IN CLASS S. REFER TO PIPE EMBEDMENT DETAILS DRAWING FOR SPECIFIC TYPES.
 - WHERE DRAINAGE PIPES ARE LESS THAN 300mm BELOW THE UNDERSIDE OF THE GROUND FLOOR SLAB, CONCRETE ENCASEMENT IS REQUIRED (CLASS Z). COMPRESSIBLE JOINTS ARE TO BE PROVIDED AT EVERY PIPE JOINT WITHIN THE CONCRETE.
 - WHERE PIPES ARE MORE THAN 300mm BELOW THE UNDERSIDE OF THE SLAB, CLASS S BEDDING IS ACCEPTABLE.
 - SULPHATE RESISTANT CEMENT (C20-DC2) AND PRECAST CONCRETE PRODUCTS MUST BE USED OR A LABORATORY REPORT PROVIDED TO PROVE THAT SUCH PRECAUTIONS ARE NOT REQUIRED.
 - WHERE FOUL SEWERS RUN ABOVE SURFACE SEWERS, CONCRETE PROTECTION MAY BE REQUIRED AT CROSSOVERS TO PREVENT ANY POTENTIAL CONTAMINATION.
 - ALL CONNECTIONS PASSING THROUGH BASES OR EDGE BEAMS TO BE IN SEALED SLEEVES. ALTERNATIVELY CONNECTIONS MAY BE CAST-IN WITH FLEXIBLE JOINTS NOT GREATER THAN 150MM FROM FACE OF CONCRETE.
 - THE CHAMBER SIZE OF MANHOLES WITH MORE THAN ONE CONNECTION MAY NEED TO BE INCREASED TO ACCOMMODATE THE CONNECTIONS AND BENDS.
 - ALL MANHOLE COVERS IN BLOCK/SLAB AND EXTERNAL PAVING AREAS TO HAVE RECESSED COVERS OF THE APPROPRIATE GRADE TO ACCEPT ARCHITECT'S PAVING PROPOSAL.
 - UNLESS NOTED OTHERWISE IN THE MANHOLE SCHEDULE, ALL MANHOLE, GULLY AND CHANNEL COVERS (IRONWORK) SHOULD BE THE FOLLOWING SPECIFICATION:
 - B125 LOAD CLASS IN PEDESTRIAN AREAS
 - D400 LOAD CLASS IN VEHICULAR AREAS.
 - ALL PROPRIETARY PRODUCTS TO BE INSTALLED IN STRICT ACCORDANCE WITH THE MANUFACTURERS REQUIREMENTS, INSTRUCTIONS AND RECOMMENDATIONS.
 - ALL PROPOSED PIPEWORK TO BE 150mm DIAMETER UNLESS NOTED OTHERWISE.

SEE DRAWING
21074-CCL-XX-XX-DR-C-92500 FOR
DETAILED DRAINAGE DESIGN

KEY:

SITE BOUNDARY TBC

EXISTING COMBINED UU SEWER

EXISTING CULVERTED WATERCOURSE

EXISTING PRIVATE COMBINED DRAIN

EXISTING SURFACE WATER DRAIN (MCC OWNED)

PROPOSED SURFACE PERFORATED PIPE (150mmØ) AND CHAMBER

PROPOSED FOUL WATER PIPE (150mmØ) AND CHAMBER

PROPOSED FLOW CONTROL, HYDRO-BRAKE OR SIMILAR APPROVED.

P01- PROPOSED PERMEABLE TARMAC

P02- PROPOSED SETT REINSTATEMENT

PROPOSED RAIN WATER PIPE AND 100mm CONNECTION

PROPOSED SOIL VENT PIPE AND 100mm CONNECTION

PROPOSED TRAPPED FLOOR GULLY WITH VERTICAL OUTLET AND 100mm CONNECTION

ACO CHANNEL DRAIN WITH OUTLET AND ACCESS BOXES

Rev	Date	Description	By	Check	App.
P01	08.12.23	STAGE 4	AA	CD	CD

COPYRIGHT: THE COPYRIGHT OF THIS DRAWING IS VESTED IN CLANCY CONSULTING. IT SHALL NOT BE USED WITHOUT PERMISSION BY ANYONE FOR ANY PURPOSE. DO NOT SCALE THIS DRAWING ELECTRONICALLY OR MANUALLY. WORK TO FIGURED DIMENSIONS ONLY. ALL DIMENSIONS ARE IN MILLIMETRES UNLESS STATED OTHERWISE. DO NOT TURN ON LAYERS THAT HAVE BEEN TURNED OFF. DO NOT TRIM LAYERS THAT HAVE BEEN FROZEN.

Client	VICTOR (M1) LTD
Project	PARADISE MEWS
Office	MANCHESTER
Discipline	CIVILS
Title	DRAINAGE LAYOUT LOCATION PLAN AND DETAILS
Scale @ A1	1:200
Status	STAGE 4



Originator	Job Number	Discipline	Building/Zone
CCL	1-21074	C	XX
Type	Level	Drawing No.	Revision
DR	XX	92503	P01