


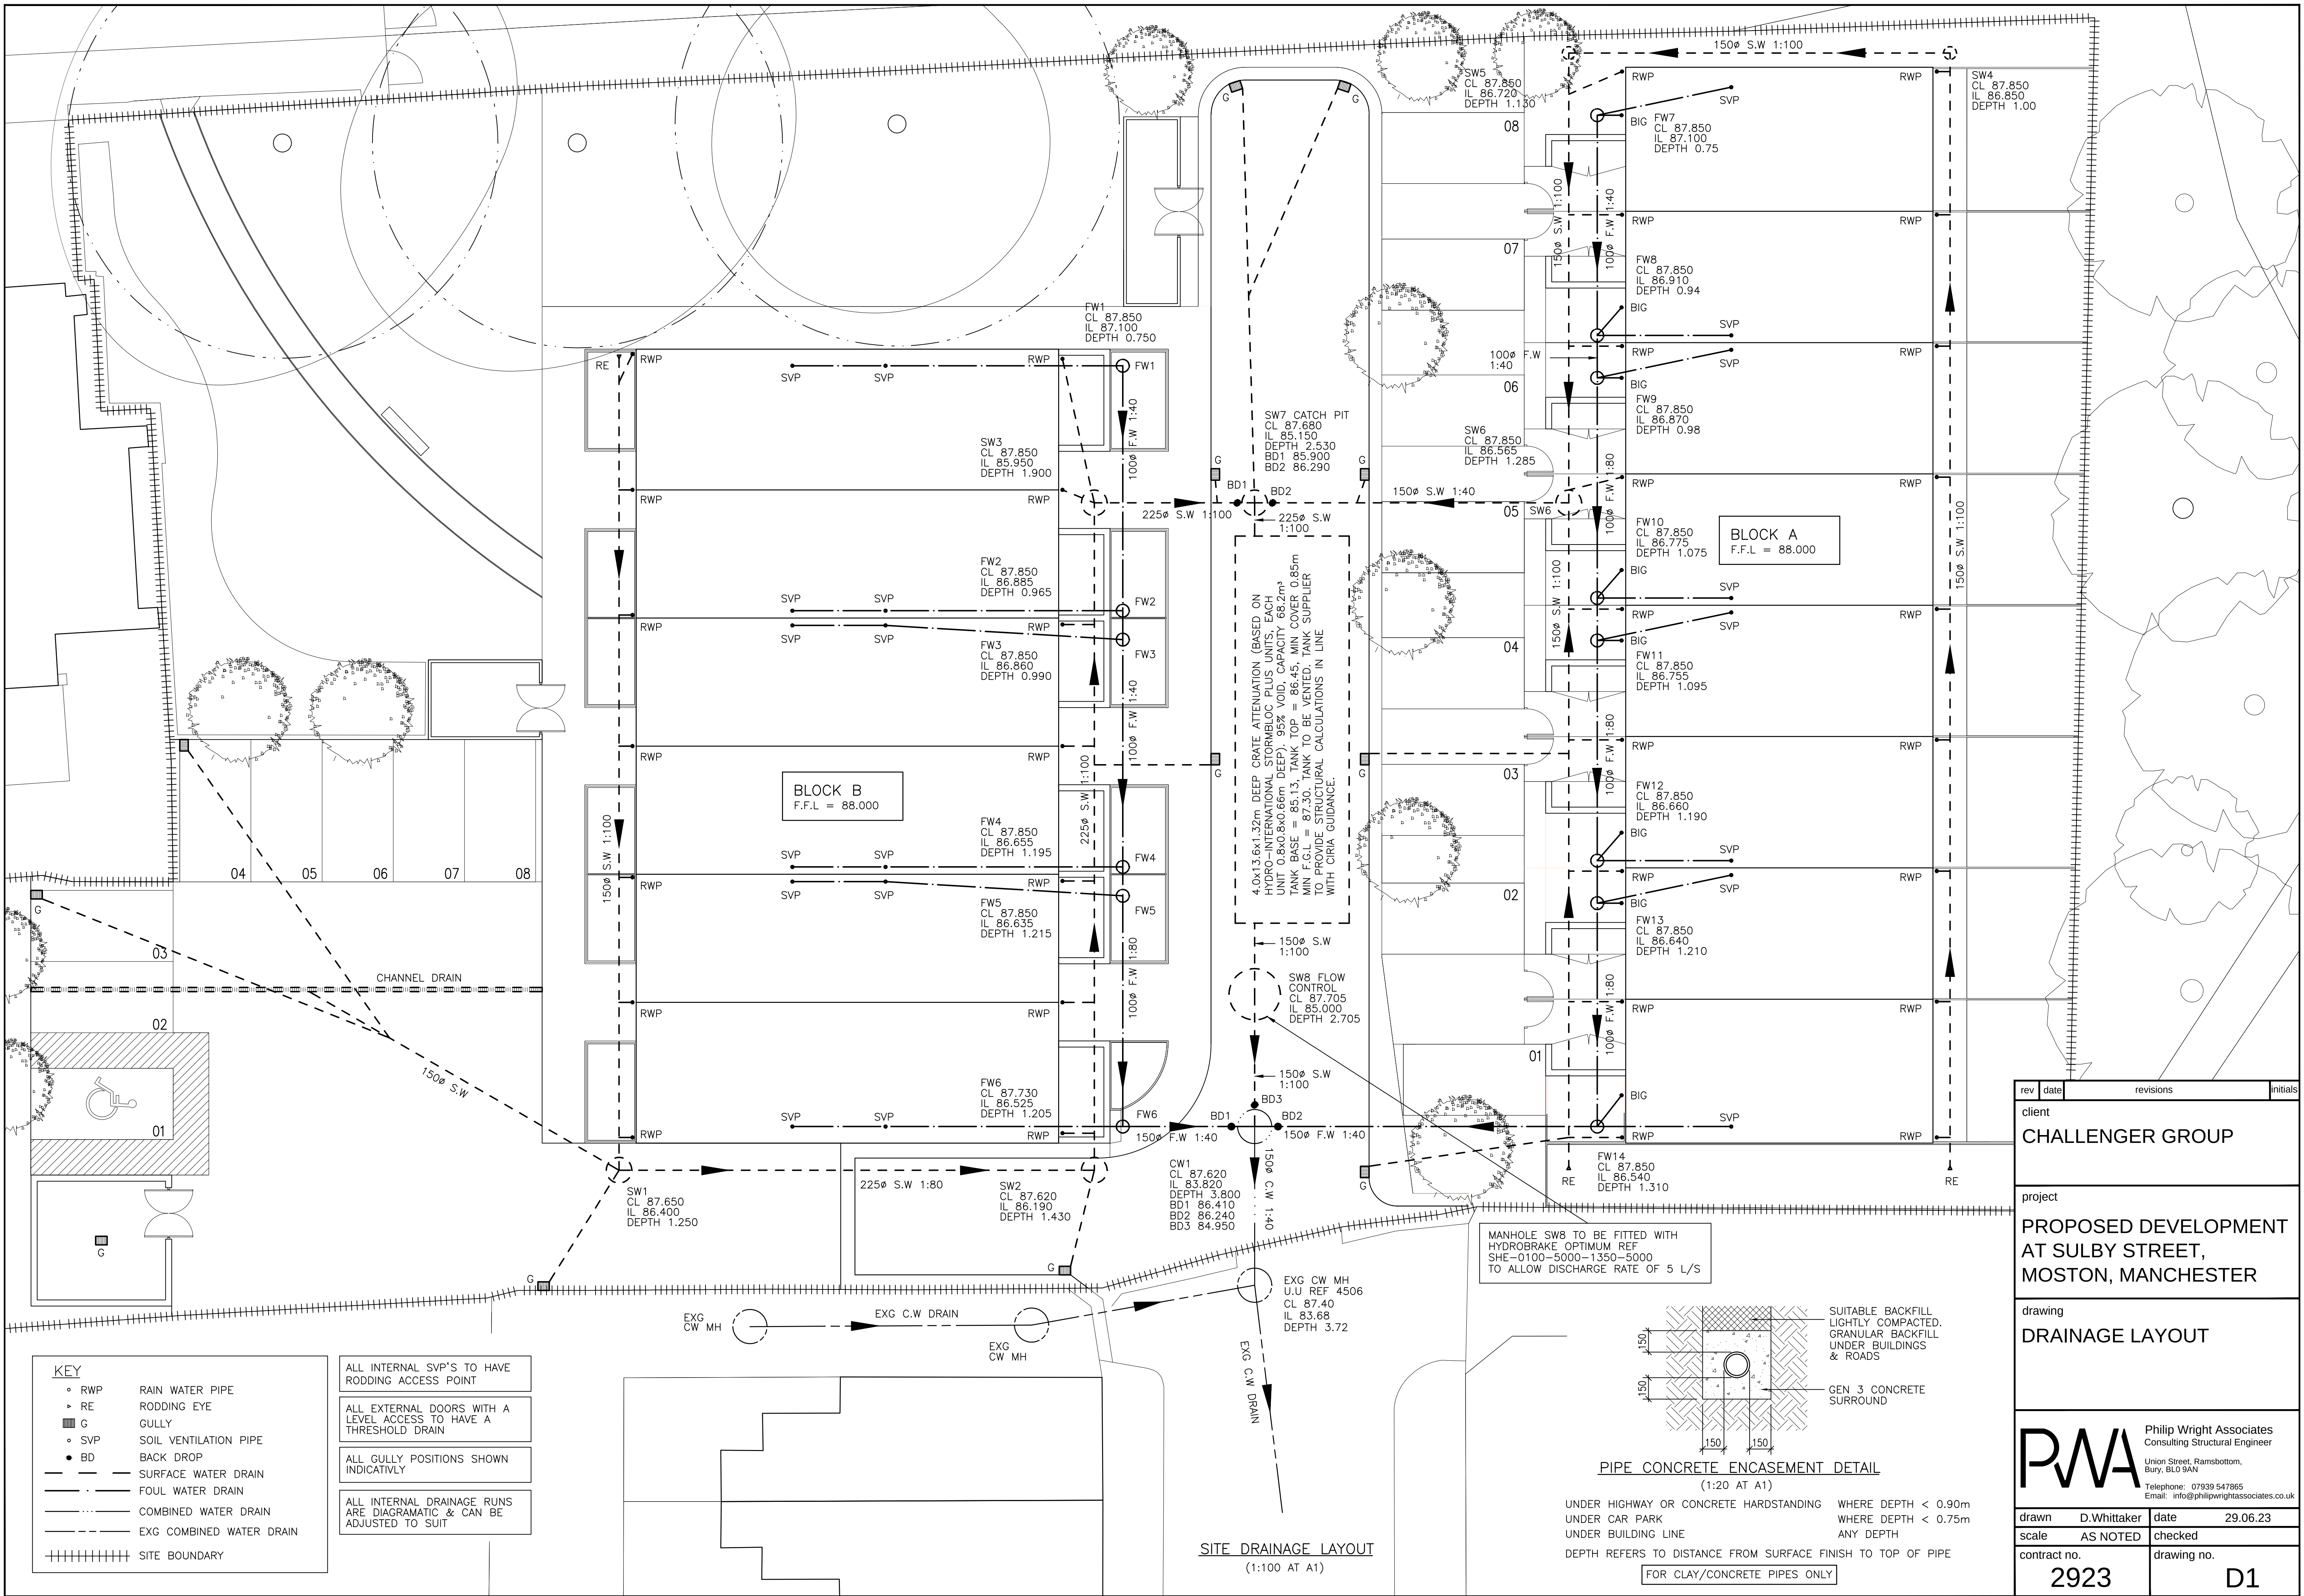

rev	date	revisions	initials
client			
CHALLENGER GROUP			
project			
PROPOSED DEVELOPMENT AT SULBY STREET, MOSTON, MANCHESTER			
drawing			
DRAINAGE LAYOUT			
drawing			
Philip Wright Associates Consulting Structural Engineer Union Street, Ramsbottom, Bury, BLO 9AN Telephone: 07939 547865 Email: info@philipwrightassociates.co.uk			
drawn	D.Whittaker	date	29.06.23
scale	AS NOTED	checked	
contract no.	2923	drawing no.	D1