

NOTES:
All dimensions must be checked on site and not scaled from this drawing.

Ref.	Date	Revisions	By
P01	22.04.22	PRELIMINARY ISSUE	B.W.
C01	08.07.22	CONSTRUCTION ISSUE	B.W.
C02	05.10.22	LAYOUT AMENDED AS CLOUDED	C.P.

NOTES:

- ALL DIMENSIONS IN MILLIMETRES UNLESS OTHERWISE STATED.
- THIS DRAWING IS TO BE READ IN CONJUNCTION WITH THE DISTRIBUTION BOARD SCHEDULES AND LIGHTING TECHNICAL SUBMITTALS.
- UPPER FLOOR CIRCULATION LIGHTING TO BE WIRED ON SPLIT CIRCUITS. 50% OF LUMINAIRES TO BE PERMANENTLY ON AND WIRED THROUGH KEY SWITCH WITHIN RISER. 50% TO BE SWITCHED VIA PIR. REFER TO TYPICAL WIRING DETAIL.
- EMERGENCY LIGHTING KEYSWITCH TO BE PROVIDED ADJACENT LOCAL DB FOR TESTING.
- PRINCIPLE CONTRACTOR TO ENSURE ALL EMERGENCY EXIT SIGNAGE POSITIONS/ DIRECTION ARROWS ARE AGREED WITH BUILDING CONTROL PRIOR TO CONSTRUCTION.

LIGHTING LEGEND:


L1	SPECULAR DOWNLIGHTER - SPEC/7W/580/120D/3K
L2	ANTILES - ANT/CAN/1775/OPAL/3
D	LD8 CIRCULAR BULKHEAD - LDB/2690/4/C
G1	HENRY DOWNLIGHTER - HEN/1500/4
H1	LOUIS LED PANEL - LOU/66/3000/4/TPA
J1	LD8 CIRCULAR BULKHEAD - LDB/1900/4/C
J2	BUILDING MOUNTED LUMINAIRE - DETAILS TBC
RE	RAVELLO DOWNLIGHTER - RAV/2460/4
K1	WPZ LINEAR - WPZ/5/4510/4
L3	RECESSED LED TAPE
X1	TALAS - IP67 IN GROUND UPLIGHT
EM	EMERGENCY BULKHEAD
EC	EMERGENCY DOWNLIGHT FOR CORRIDOR - EMD/NM/CO
EO	EMERGENCY DOWNLIGHT FOR OPEN AREA - EMSD/NM/OA
'E'	DENOTES EMERGENCY FITTING

EMERGENCY SIGNAGE LIGHTING LEGEND:

E1	LED EXIT SIGN WALL MOUNTED ARROW UP
E2	LED EXIT SIGN CEILING MOUNTED ARROW UP
E3	LED EXIT SIGN CEILING MOUNTED ARROW DOWN
E4	LED EXIT SIGN CEILING MOUNTED DOUBLE SIDED
E5	LED EXIT SIGN CEILING MOUNTED ARROW RIGHT
E6	LED EXIT SIGN CEILING MOUNTED ARROW LEFT
E7	LED EXIT SIGN CEILING MOUNTED ARROW LEFT (DIAGONAL DOWN)




LIGHTING CONTROL LEGEND:

P1	FLUSH 360 INFRARED PRESENCE DETECTOR
P2	SURFACE 360 INFRARED PRESENCE DETECTOR
MW1	FLUSH LONG RANGE MICROWAVE SENSOR
MW2	SURFACE LONG RANGE MICROWAVE SENSOR
X	RETRACTIVE SWITCH - 'X' DENOTES NO OF GANGS
•	TWO-WAY RETRACTIVE SWITCH
•	INTERMEDIATE RETRACTIVE SWITCH
•	EMERGENCY KEY SWITCH
—	CIRCUIT LINE
→	SWITCH LEADER

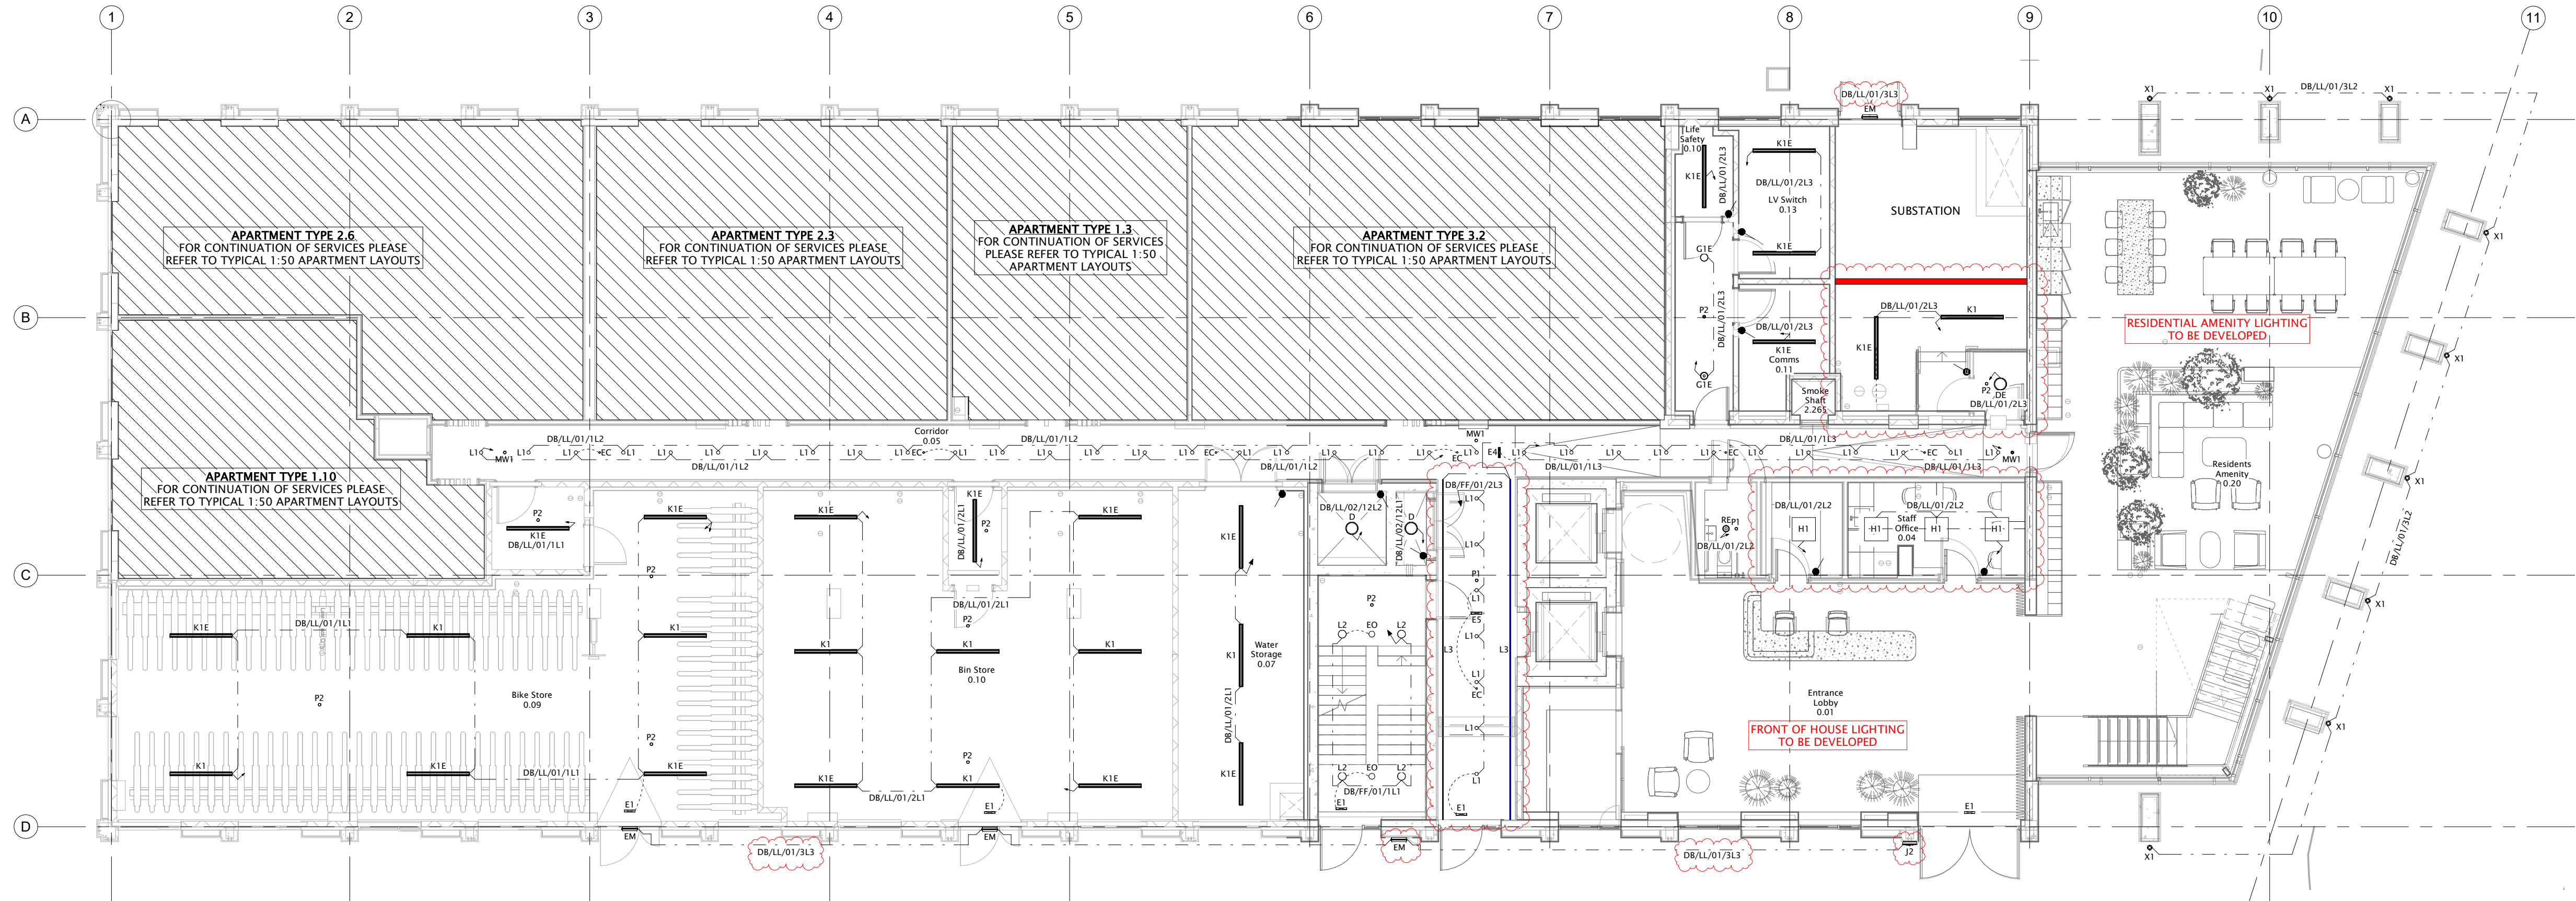

Level 00 - Lighting Layout

1 : 100

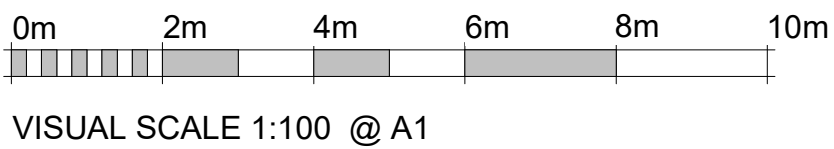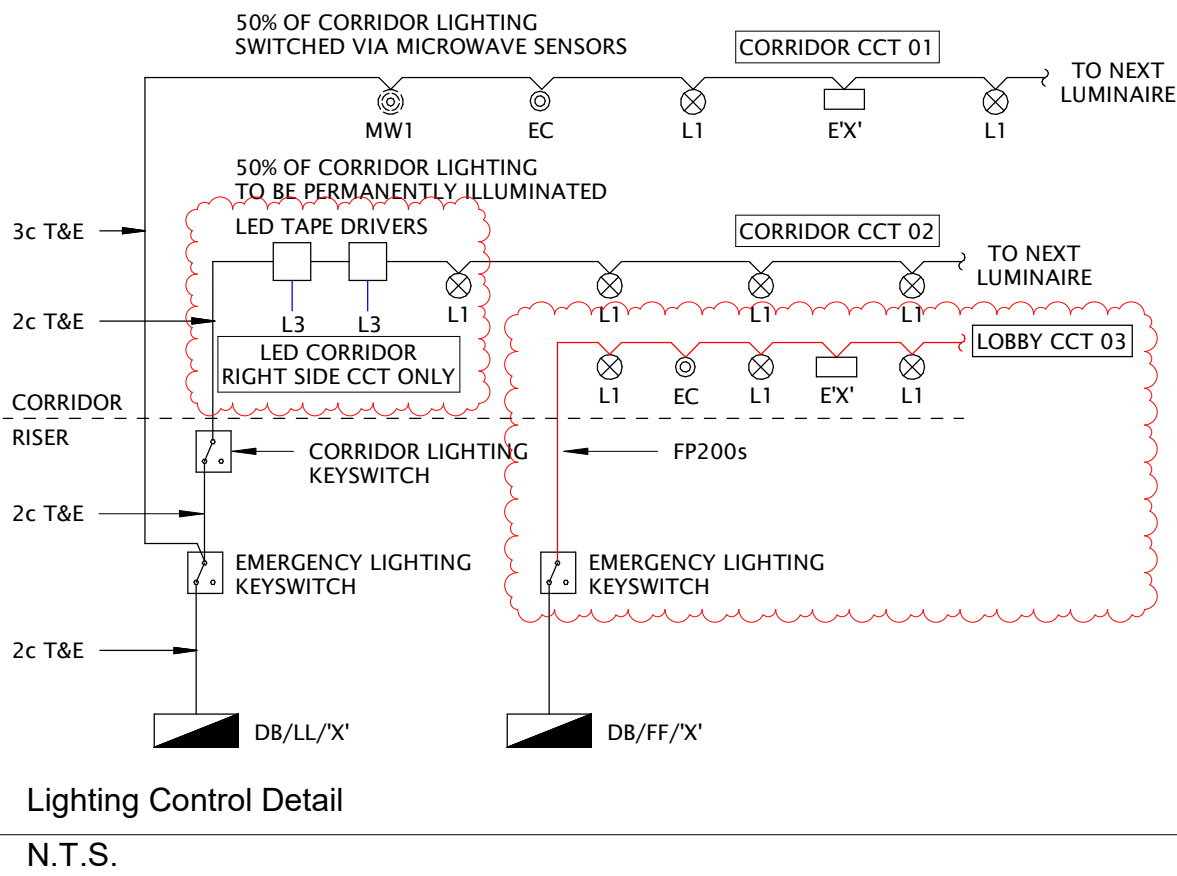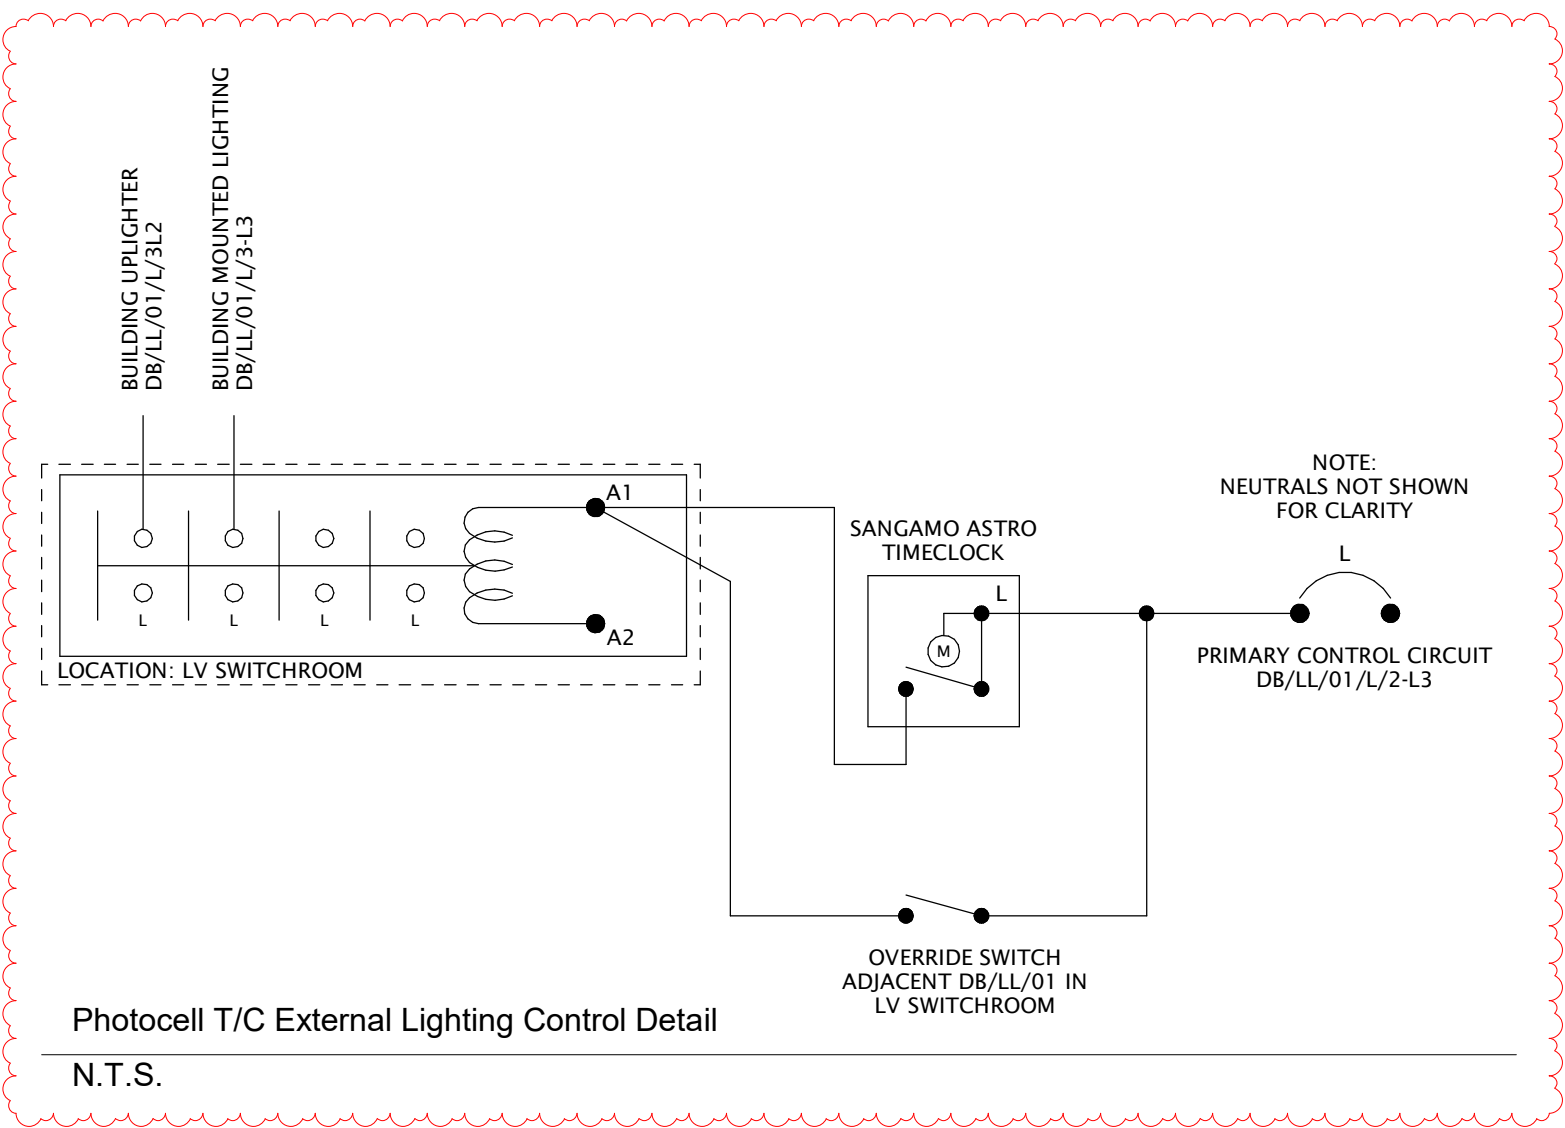

Client	Job Title	Drawing Title	Date April 22	Drawn by B.W.	Check by B.C.
	New Cross, Bendix Street	Level 00 - Lighting Layout	Scale @ A1 As indicated	Status CONSTRUCTION	
			Drawing Number D480-AME-ZZ-00-DR-E-6301		Revision C02

ameon
Building Services Engineering
Unit 9-10 Olympic Court, Boardmans Way,
Whitehills Business Park, Blackpool, FY4 5GU
Tel: 01253 760160
E-mail: info@ameon.co.uk