




- NOTES
1. THIS DRAWING IS TO BE READ IN CONJUNCTION WITH ALL RELEVANT ARCHITECTURAL & STRUCTURAL DRAWINGS.
 2. THIS DRAWING IS TO BE READ IN CONJUNCTION WITH ALL RELEVANT BUILDING SERVICES DRAWINGS & THE RELEVANT SECTIONS OF THE SPECIFICATIONS & SCHEDULES.
 3. THIS DRAWING IS NOT TO BE SCALED.
 4. ALL DIMENSIONS ARE IN mm UNLESS OTHERWISE STATED.
 5. THE INFORMATION ON THIS DRAWING IS INDICATIVE ONLY OF THE DESIGN INTENT. THE CONTRACTOR SHOULD USE THIS AS A BASIS ONLY FOR THEIR DESIGN DEVELOPMENT AND THE PRODUCTION OF WORKING DRAWINGS FOR SITE USE. DESIGN DRAWINGS MUST NOT BE USED ON SITE FOR INSTALLATION PURPOSES.
 6. ANY DISCREPANCIES, ERRORS OR OMISSIONS ARE TO BE CLARIFIED WITH THE RELEVANT ENGINEER AT THE EARLIEST OPPORTUNITY.
 7. ALL WORKS ARE TO BE IN ACCORDANCE WITH THE CURRENT RELEVANT STATUTORY REGULATIONS, BUILDING REGULATIONS, BRITISH STANDARDS, ACCEPTED CODES OF PRACTICE AND TRADE ASSOCIATION REQUIREMENTS.
 8. IT IS THE CONTRACTORS RESPONSIBILITY TO LIAISE WITH THE MAIN CONTRACTOR AND ALL OTHER TRADES TO ENSURE THE CORRECT CO-ORDINATION OF WORKS TO SUIT PROGRAMME RESTRAINTS, AND TO AVOID CLASHES.

LIGHTING LEGEND	
SYMBOL	DESCRIPTION
W1	WALL MOUNTED STEP LIGHT LED LUMINAIRE
W2E	WALL MOUNTED LED LUMINAIRE WITH 3HR EMERGENCY BATTERY
PL	POLE LIGHT FOR DRIVEWAY
BL	BOLLARD LIGHT FOR PASSWAY
13A	13A SWITCHED FUSED SPUR FOR LOGO SIGN
DS	DAYLIGHT SENSOR
TC	TIME CLOCK (SETTING TO BE AGREED WITH CLIENT)

P01	20.11.23	ISSUED FOR STAGE 3	CC	SL
REV	DATE	DESCRIPTION	BY	CHK

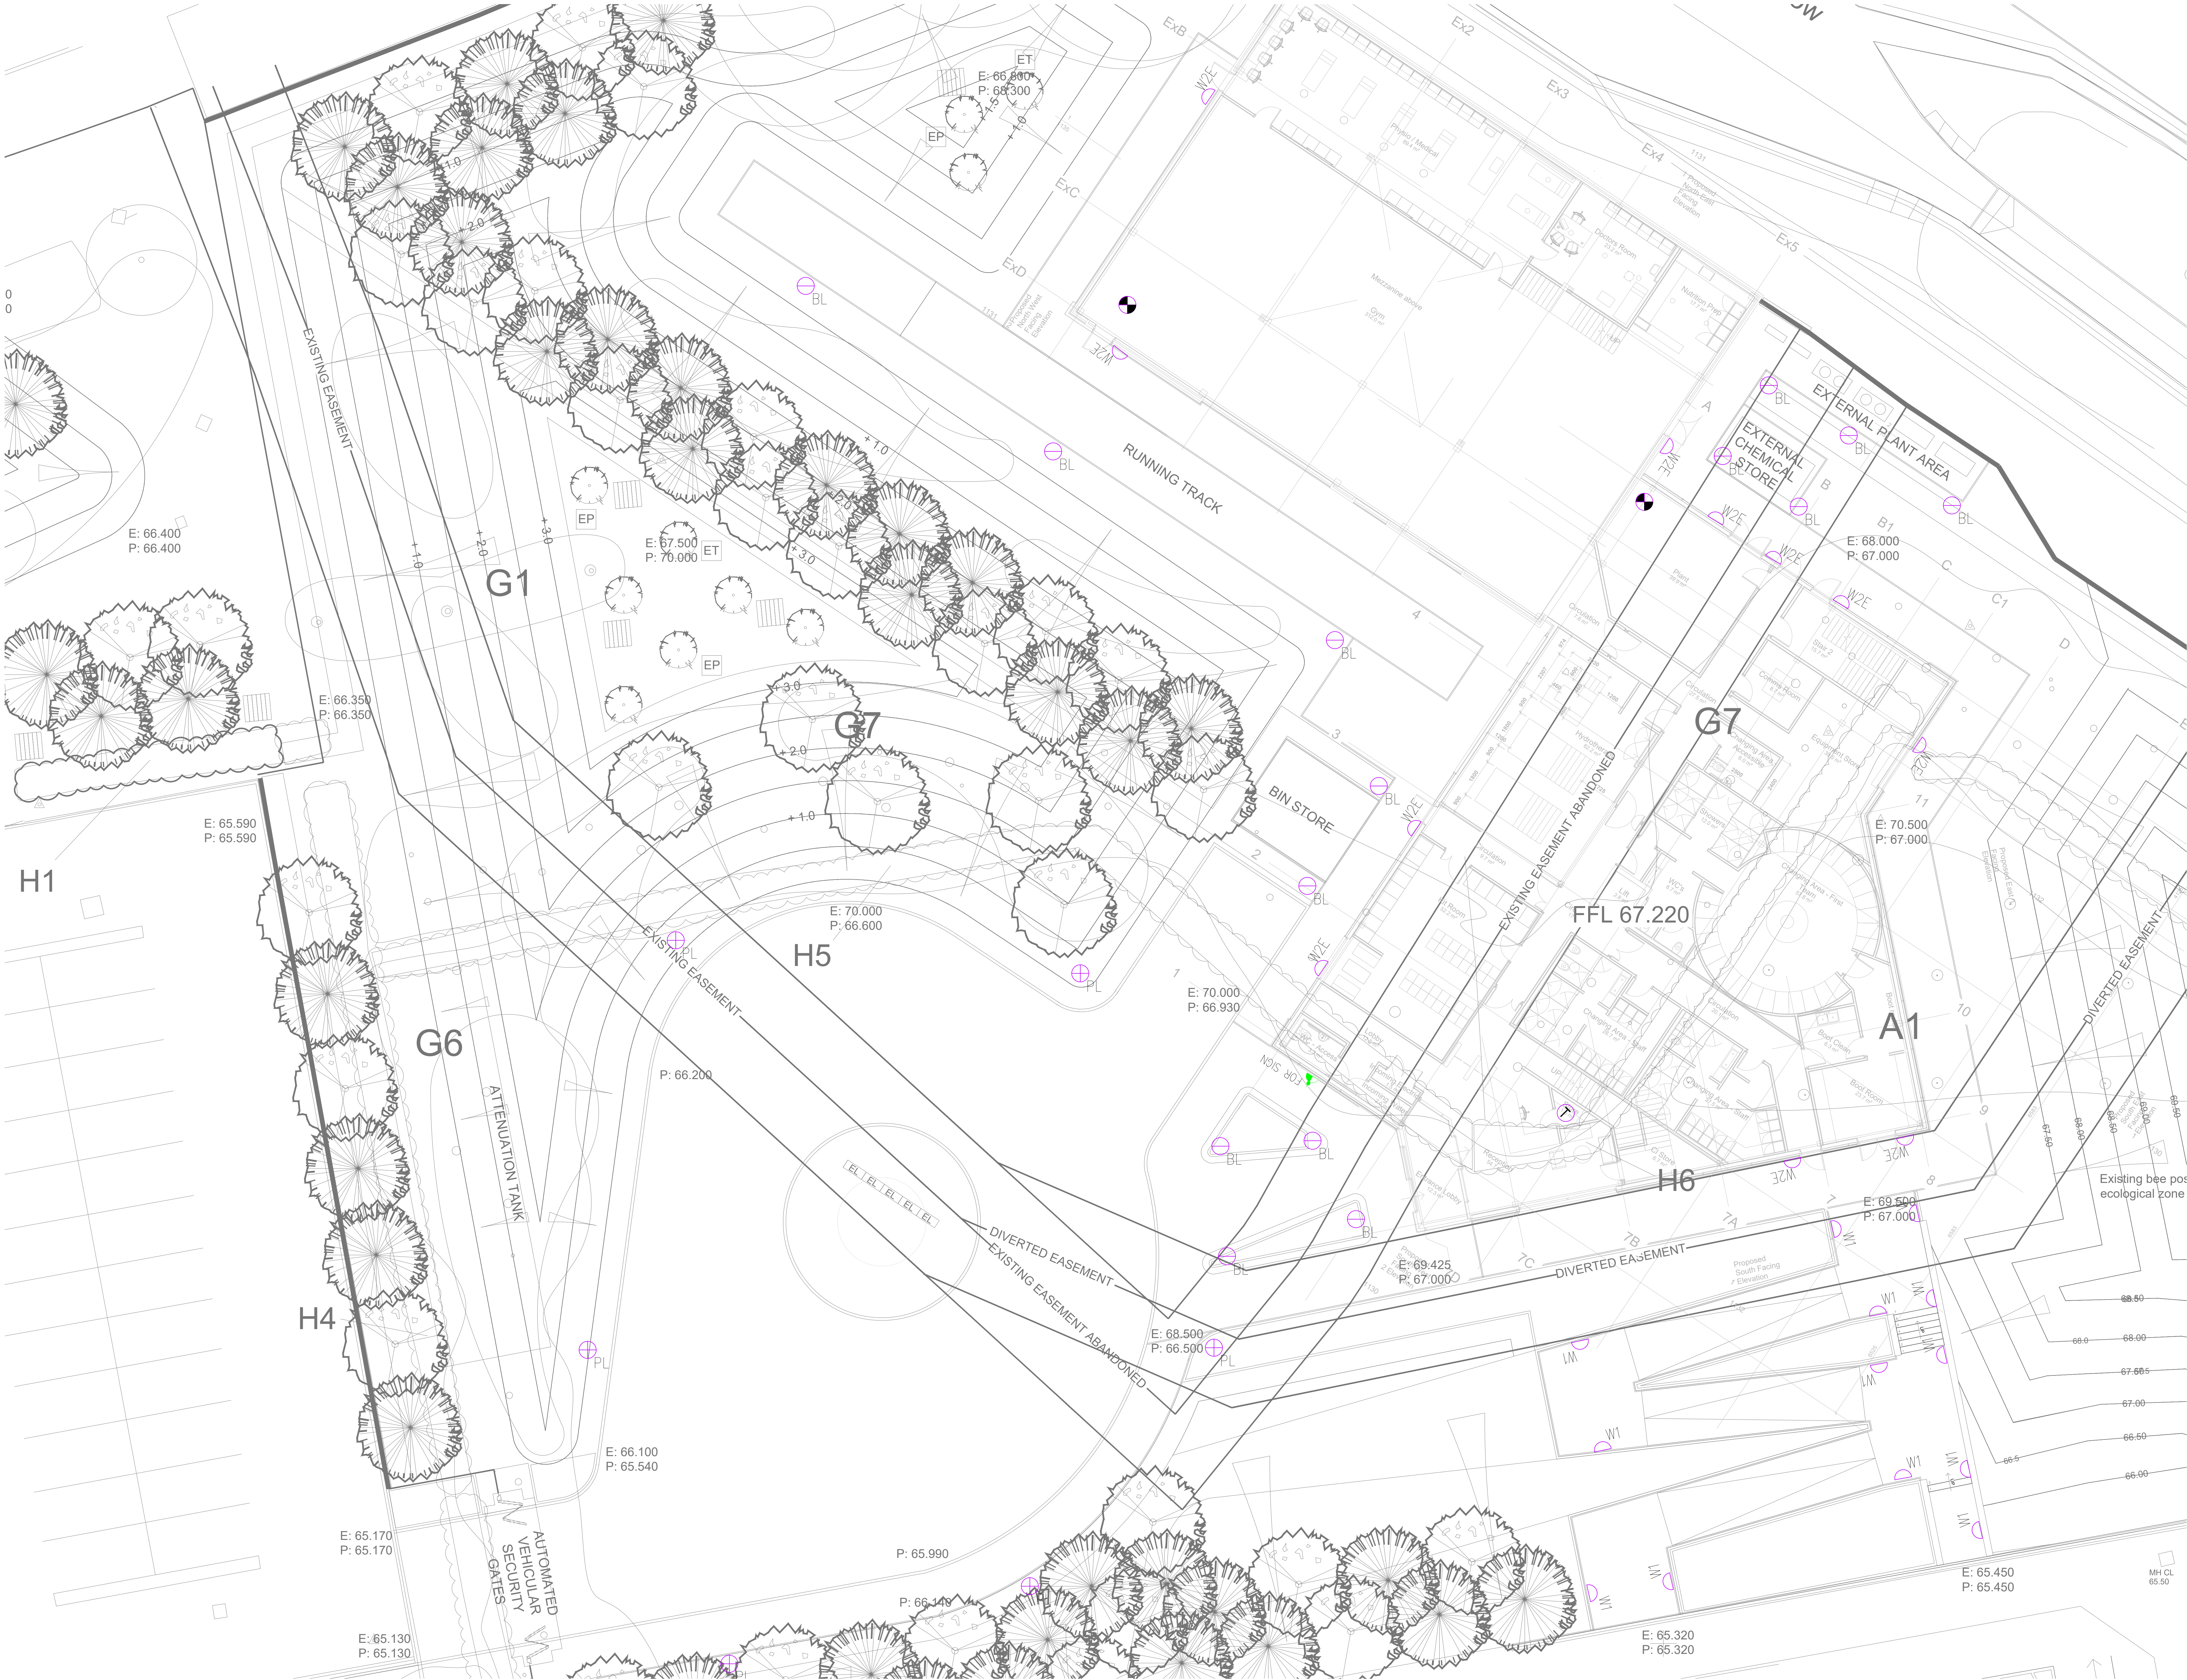

SVM BUILDING SERVICES DESIGN
Email: info@SVM-bsd.co.uk Website: www.SVM.co.uk
Offices at: Birmingham, Berkhamsted, Manchester, London



Client:
BOWKER SADLER

Project:
MCWFC

Title:
**ELECTRICAL SERVICES
SITE PLAN
EXTERNAL LIGHTING LAYOUT**

Scale at A0:	Suitability:	Designed:	Drawn:	Design:	CC
1:100	S2	CC	CJO	CAD CK:	CO
Drawing No:	230565-SVM-ZZ-ZZ-DR-E-2202	Rev:	P01		

PRELIMINARY