


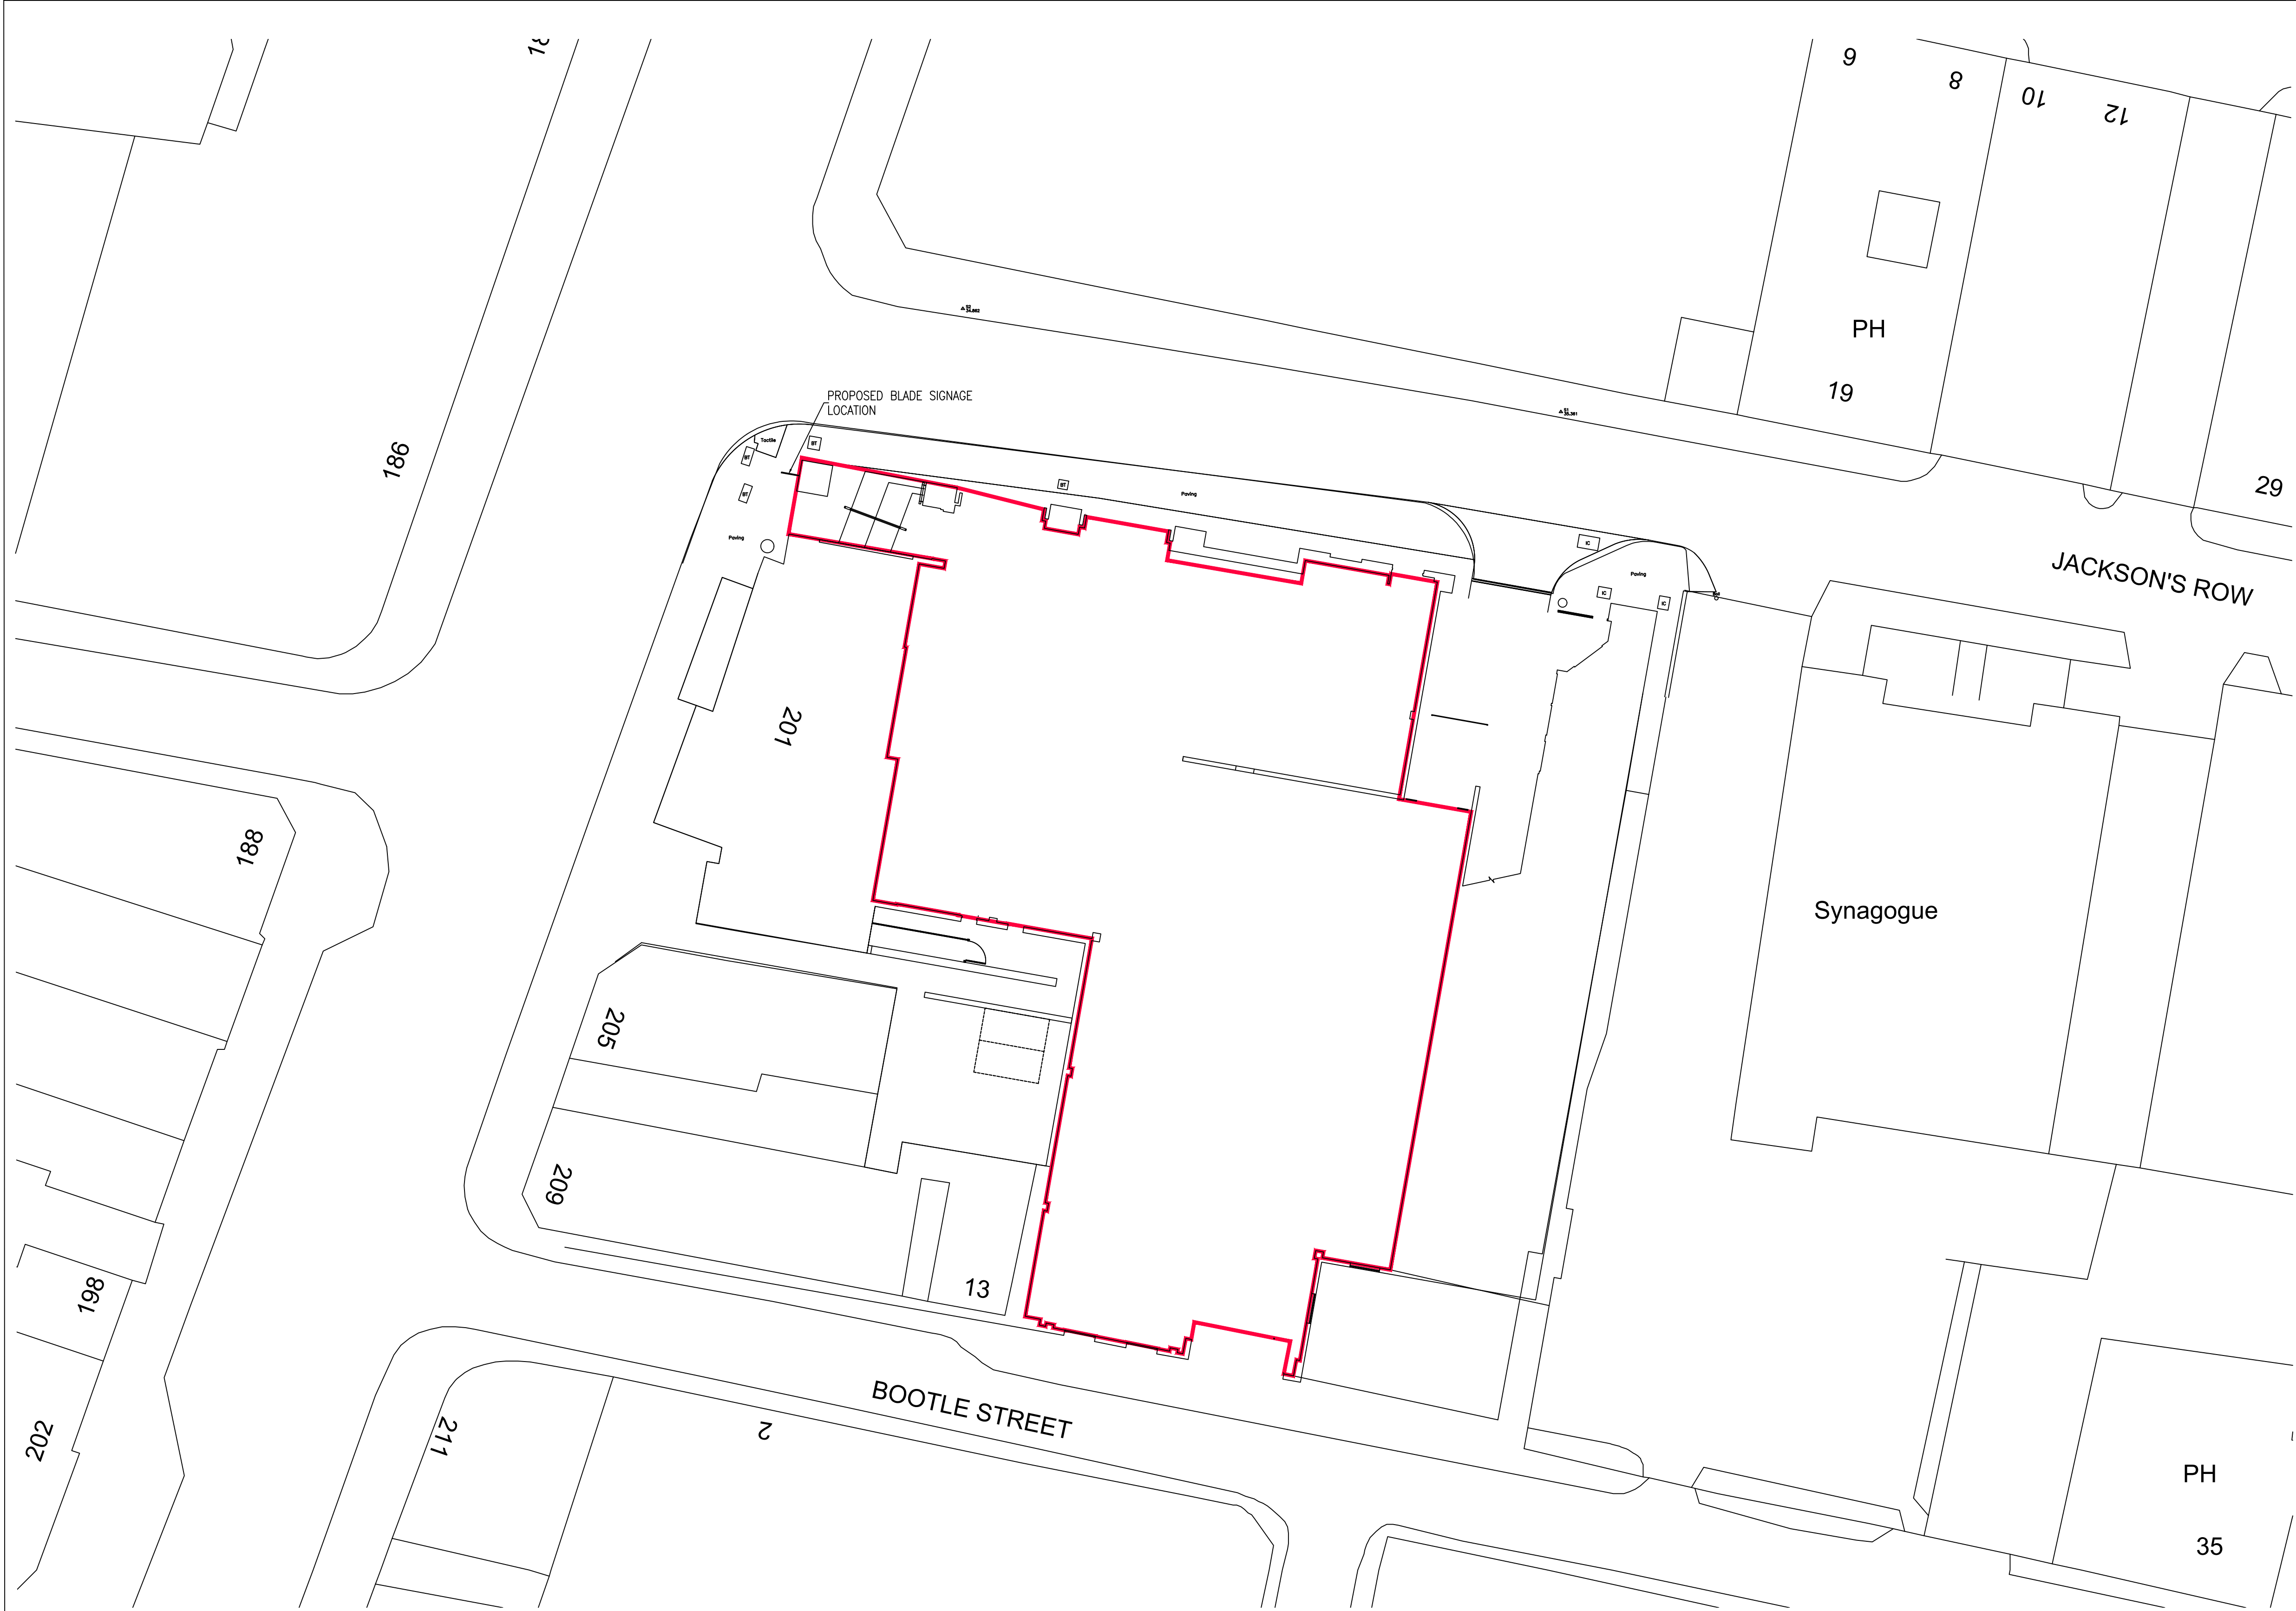

NOTE
This drawing is to read in conjunction with all other Architects drawings and all Structural Engineers drawings details and calculations.
It is the contractors responsibility to check all dimensions prior to fabrication or construction, any discrepancies to be reported to the Architect.

- Revisions:
REV A: Co-ordinated with RE Design Intent issue 13.07.23
REV B: Amendments to plan 24.07.23
REV C: Co-ordinated with RE Design Intent issue 2 17.08.23
REV D: Blade signage application (Planning) 20.10.23
REV E: Amended site demise line 26.10.23

EXTENT OF RED ENGINE DEMISE



K I R K M A N
A R C H I T E C T S

PO Box 929
ALTRINCHAM, CHESHIRE
WA15 5QL
TEL: 07974 254060
WWW.KIRKMANARCHITECTS.CO.UK

Project
PROPOSED ELECTRIC SHUFFLE
201 DEANS GATE, MANCHESTER,
M3 3NW

Drawing
PROPOSED SITE PLAN

Date MARCH 2023 Drawn By CM Scale 1:200 © A1

Drawing Status PLANNING	Drawing No. 1643-04	Rev No. E
----------------------------	------------------------	--------------

Proposed Site Plan

Scale 1:200