


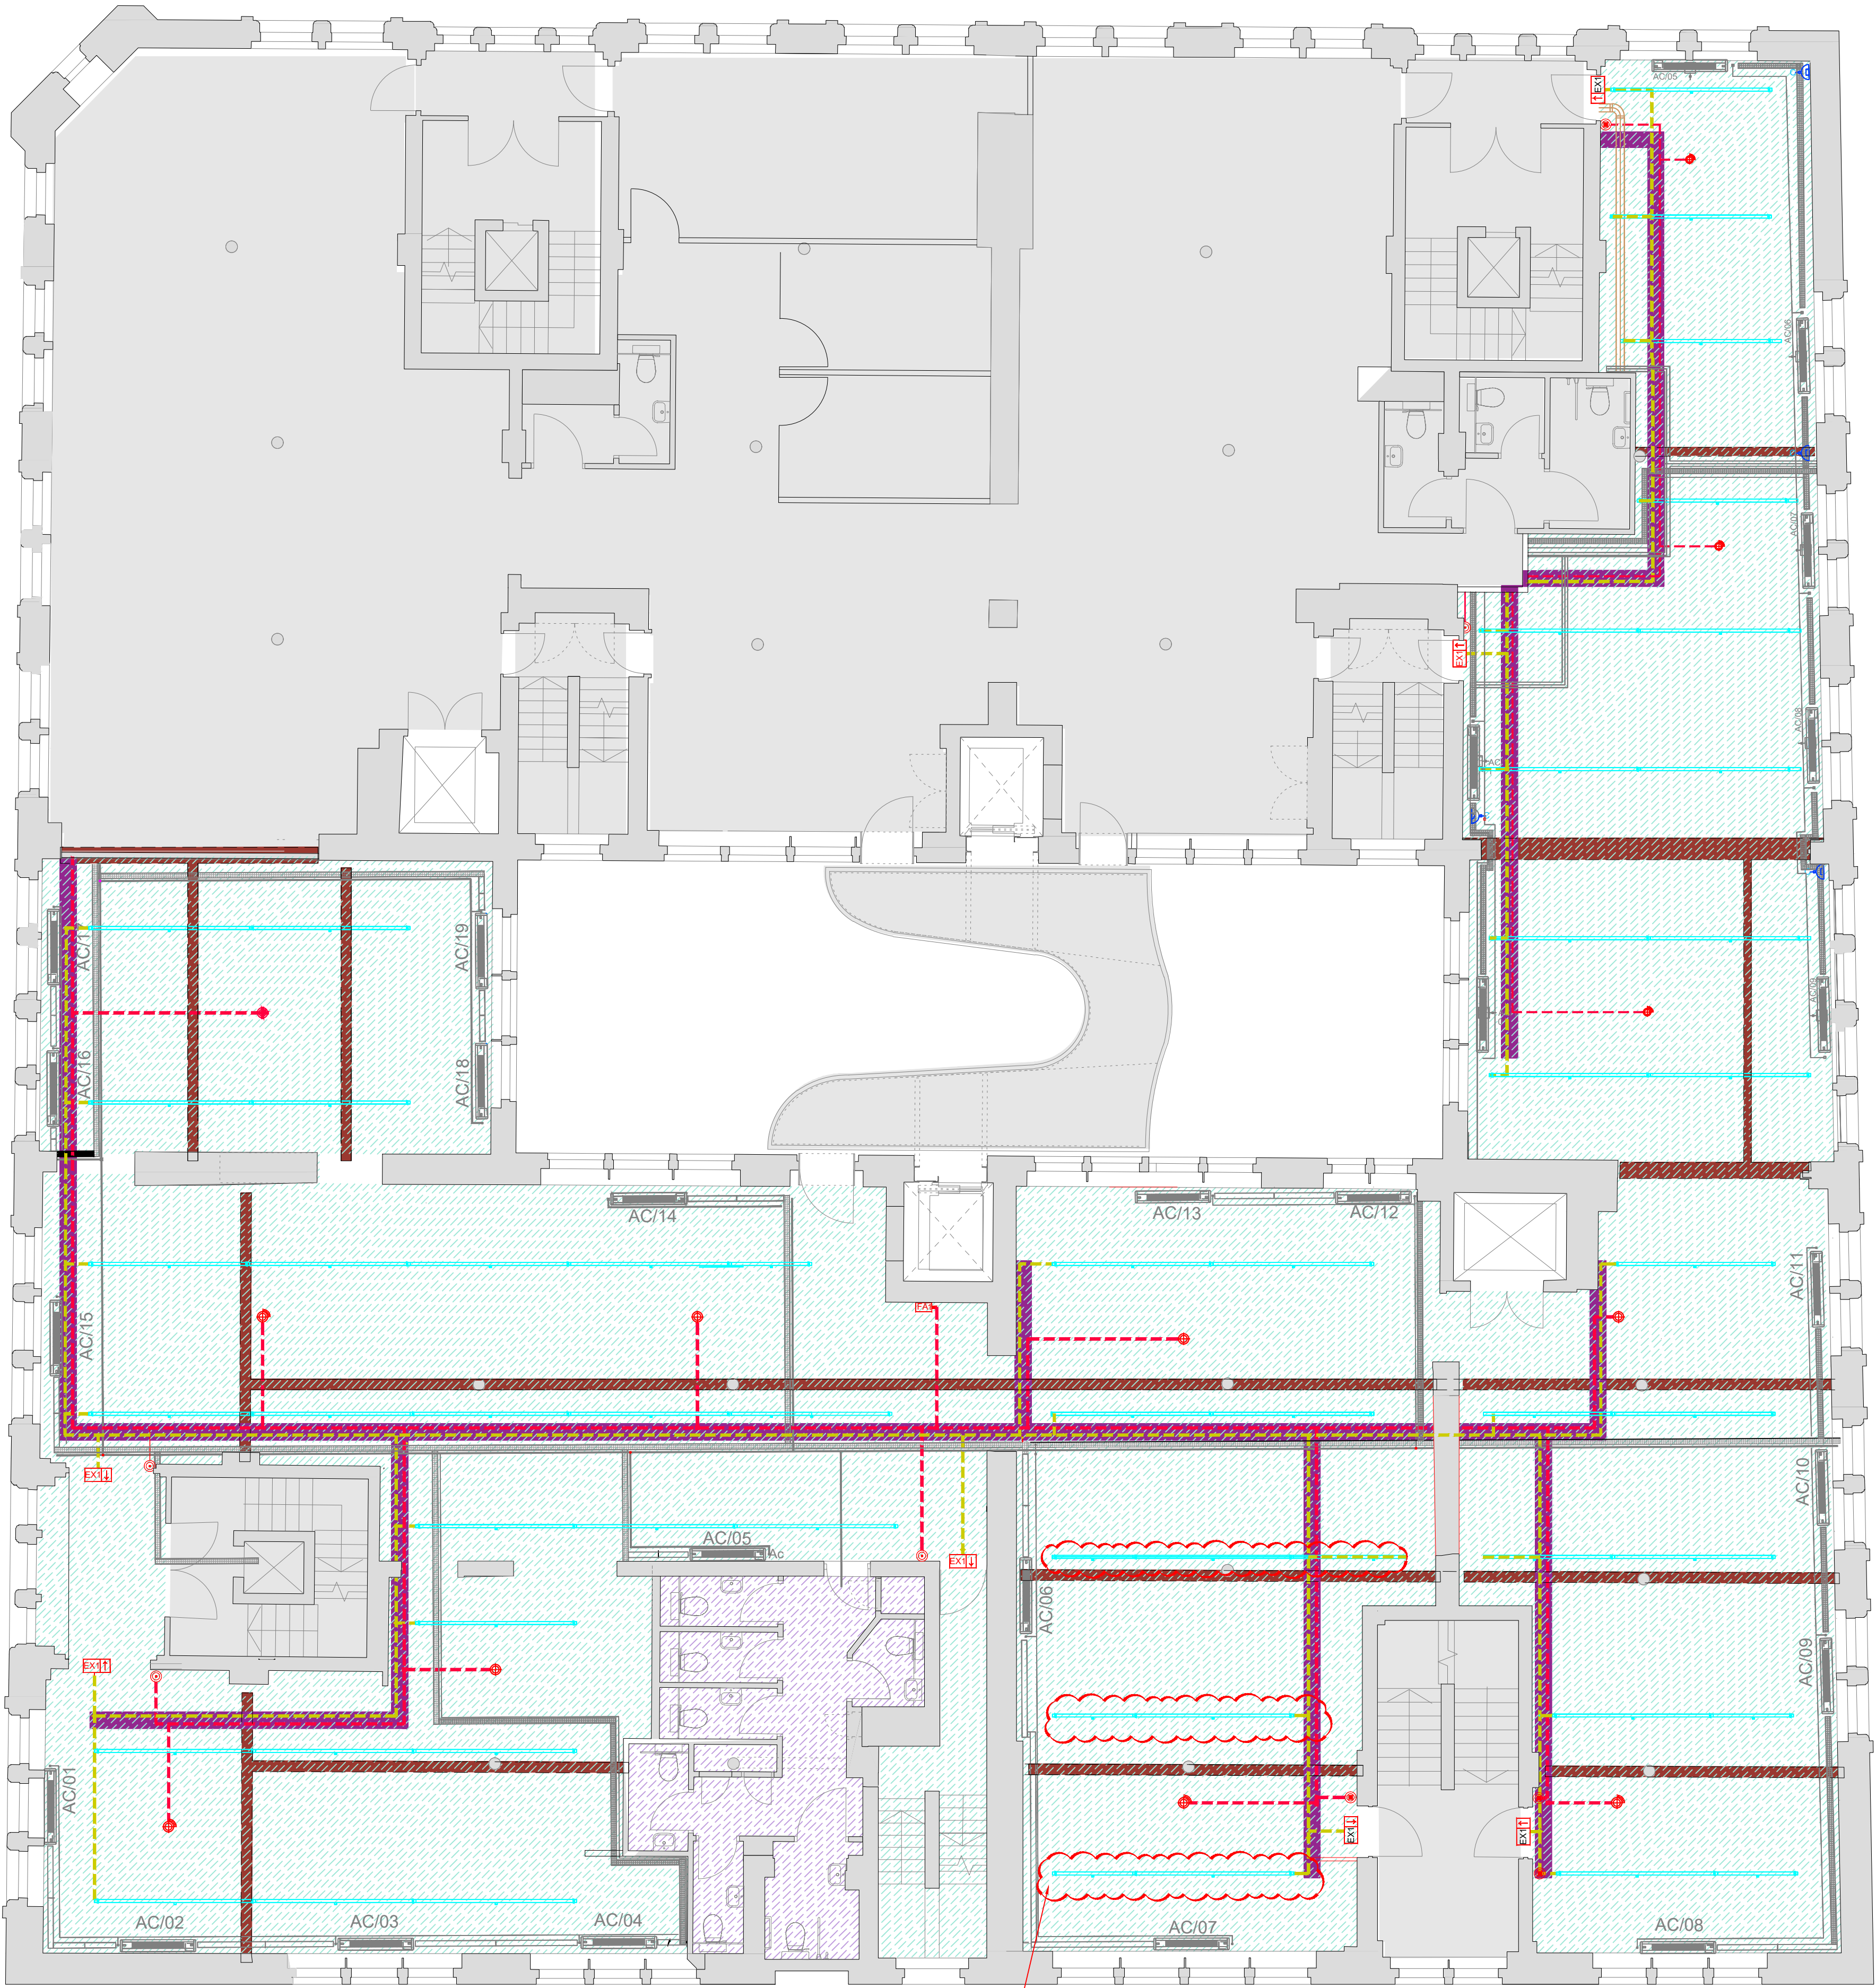

LIGHTING REMOVED AND
SET ASIDE FOR RE-USE
IN PROPOSED SCHEME

EXISTING CEILING PLAN

REFLECTED CEILINGS KEY

- EXISTING PLASTERED CEILING
- EXISTING PLASTERED SUSPENDED CEILING
- ORIGINAL TIMBER TRUSSES EXPOSED
- AREA NOT SUBJECT OF THIS APPLICATION

LEGEND:

- A1 Thorlux 30W LED 1500mm Hi-Bar suspended continuous luminaire smart scan (Black) - Existing
- A1E Thorlux 30W LED 1500mm Hi-Bar suspended continuous luminaire smart scan Emergency (Black) - Existing
- A2 Thorlux 60W LED 3000mm Hi-Bar suspended continuous luminaire smart scan (Black) - Existing
- A2E Thorlux 60W LED 3000mm Hi-Bar suspended continuous luminaire smart scan Emergency (Black) - Existing
- EX1 Thorlux ceiling mounted "LEX" maintained LED scanlight c/w directional arrow
- Primary Containment
- Secondary Containment

NOTE: ALL DIMENSIONS TO BE CHECKED ON SITE
NO DIMENSIONS TO BE SCALED UNLESS
OTHERWISE STATED

DRAWING STATUS

LISTED BUILDING CONSENT

REV	DESCRIPTION	DATE/INITIAL
A	AMENDED IN LINE WITH COMMENTS RECEIVED 24.10.23	31.10.23/SR

adit workplace
THE WORKSPACE (22 BRICK COURT) COVENTRY ROAD MANCHESTER M14 6LN
T: 0161 655 0290 www.aditworkplace.com

DEVELOPMENT	PHIL SHEPHERD
PROJECT MANAGER	
DESIGN	DRAWN BY STACEY NOLAN
SCALE@A1	1/75
DATE	27.09.23
PROJECT	XLB 2nd FLOOR FOURWAYS HOUSE MANCHESTER
DRAWING NO.	E2678_02_LBC_002
REVISION	A
DRAWING TITLE	EXISTING SECOND FLOOR REFLECTED CEILING PLAN