

A1

A

B

C

D

E

F

G

H

I

J

K

L

M

N

1

2

3

4

5

6


7

8

9

10

11

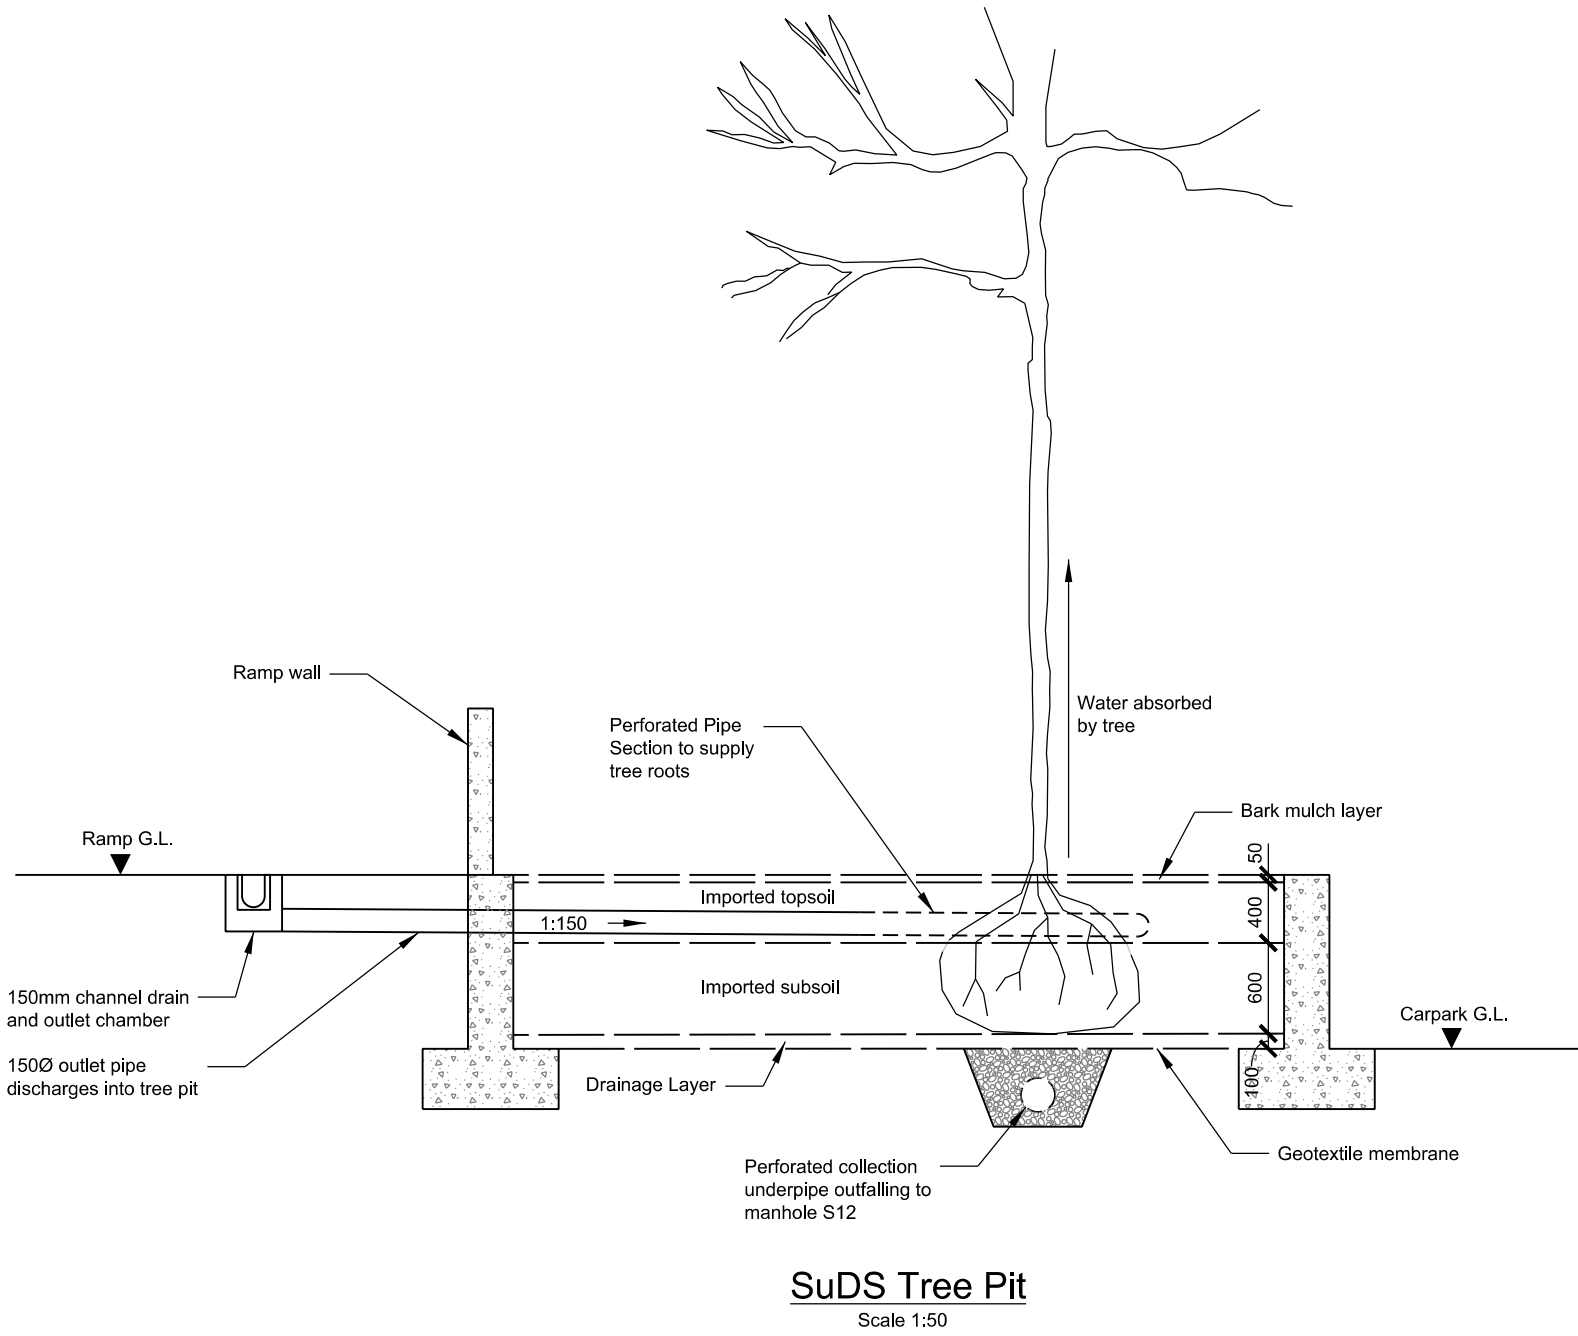

Notes

1. Do not scale from this drawing (printed or electronic version).
2. This drawing is copyright and for use on this site only.
3. This drawing should be read in conjunction with all relevant Engineer's and Architect's drawings, reports and specification.
4. Responsibility for the reproduction of this drawing in paper form, or if issued in electronic format, lies with the recipient to check that all information has been replicated in full and is correct when compared to the original.
5. All works to be carried out in accordance with the latest British Standards/Codes of Practice unless specifically directed otherwise.

P1	16/07/19	AS	AJ	SL
Workstage 3 Issue				
Rev	Date	By	Chkd	Appd

ARUP

Three Piccadilly Place, Manchester, M1 3BN
Tel+44(0)161 228 2331 Fax+44(0)161 228 6879

Client
Muse Developments Ltd

Project Title
New Victoria

Drawing Title
Proposed Drainage Layout
Typical Details
Sheet 6 of 6

Scale at A1
1:50

Role
Civils

Suitability
S2 - Issued for Information

Arup Job No 255644-00	Rev P1
Name VIC-ARUP-ZZ-EX-DR-CD-7011	