


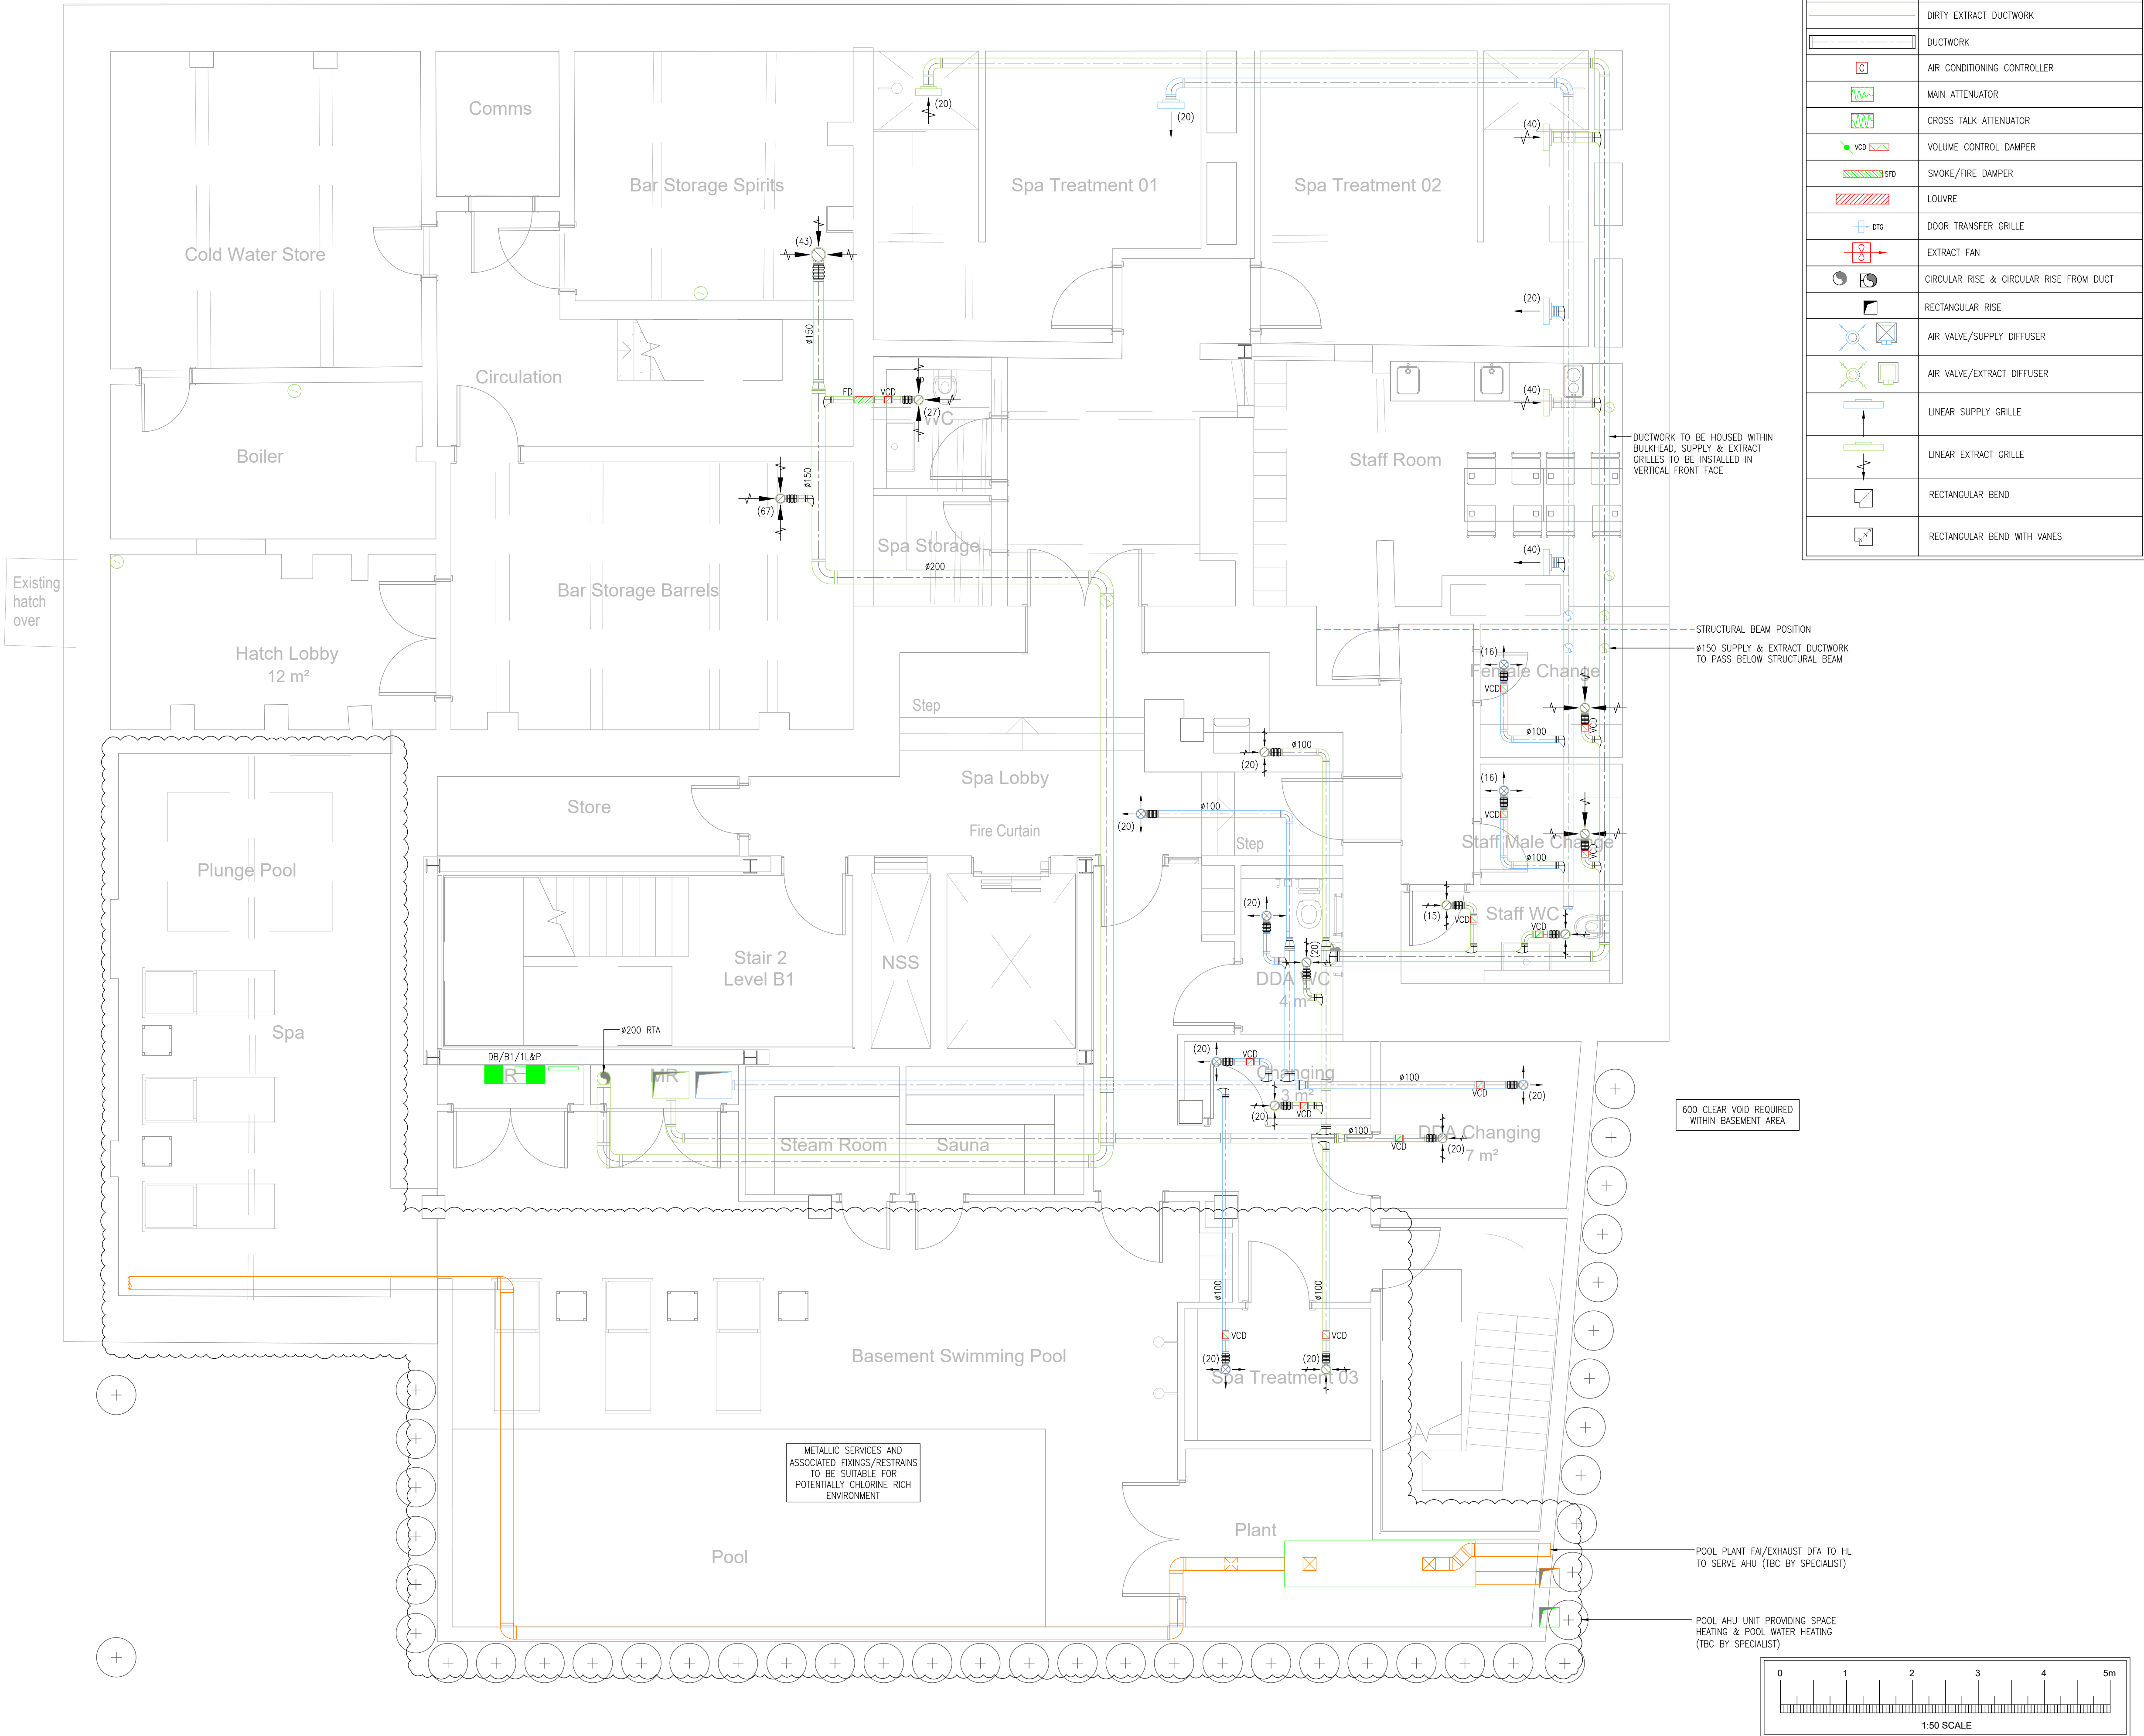

PROTECTED BY UK COPYRIGHT LAW
DO NOT SCALE OFF THIS DRAWING

DESIGNERS RISK ASSESSMENT

Under section 11, 18 - Construction (Design and Management) Regulations 2015

SAFETY, HEALTH & ENVIRONMENTAL INFORMATION

There are no significant, unusual or location specific risks which are not obvious to a competent contractor or likely to be difficult to manage

NOTES

1. ALL DIMENSIONS IN mm UNLESS OTHERWISE STATED

2. THIS DRAWING SHALL BE READ IN CONJUNCTION WITH ALL MECHANICAL, ELECTRICAL, STRUCTURAL AND ARCHITECTURAL DRAWINGS

3. THE INSTALLATION SHALL COMPLY WITH THE BUILDING REGULATIONS, BRITISH STANDARDS, STATUTORY REGULATIONS, CIBSE GUIDES, CIBSE COMMISSIONING CODES, HVCA CODES AND GUIDES AND ALL OTHER RELEVANT REGULATIONS.

4. THE DUCTWORK INSTALLATION SHALL BE CONSTRUCTED AND INSTALLED IN ACCORDANCE WITH DW/144

5. THE AIR INTAKE DUCTWORK BETWEEN THE VENTILATION HEAT RECOVERY UNITS AND INTAKE LOUVRES SHALL BE THERMALLY INSULATED IN ACCORDANCE WITH BS5422:2001, WITH ALL DUCTWORK VAPOUR SEALED

6. DUCTWORK SHALL BE INSTALLED (WHERE PRACTICAL) WITH GRADIENTS TOWARDS THE VENTILATION HEAT RECOVERY UNIT TO ENSURE THAT CONDENSATE DRAINS TOWARDS THE UNIT

7. ALL EXTRACT VALVES SHALL BE ADJUSTABLE FOR VOLUME CONTROL, NOISE REDUCTION AND DRAUGHT AVOIDANCE PURPOSES

8. ACCESS PANELS SHALL BE PROVIDED WITHIN THE DUCTWORK SYSTEM INLINE WITH B&ES TR17 AND GENERALLY AT 3m INTERVALS ON STRAIGHT DUCTS. IN ADDITION EASILY REMOVABLE END CAPS SHALL BE INCLUDED ON ALL STRAIGHT DUCT LENGTHS FOR CLEANING PURPOSES

9. ALL FIRE DAMPERS SHALL BE PROVIDED WITH ADJACENT ACCESS PANELS (WHERE NECESSARY) TO ENABLE INSPECTION AND TESTING

10. ALL SERVICE ROUTES AND POSITIONS ARE INDICATIVE AND SHOULD BE VERIFIED ON SITE FOLLOWING AN EXISTING SITE SERVICES SURVEY AND SHALL BE FULLY COORDINATED WITH THE ARCHITECT.

11. NO FLEXIBLE CONNECTIONS TO GRILLES AND DIFFUSERS TO EXCEED 250mm IN LENGTH.

12. ALL FANS & AC UNITS SHALL BE PROVIDED WITH ANTI-VIBRATION MOUNTS.

13. THE CONTRACTOR SHALL ALLOW FOR ALL CO-ORDINATION WITH M, E & PH INSTALLATIONS & FABRIC/STRUCTURE.

14. THE CONTRACTOR SHALL ALLOW FOR ALL BUILDERS WORK IN CONNECTION WITH THE SERVICE INSTALLATION.

15. ALL DUCTWORK BRANCHES INTO STUDIOS TO BE 150mmØ & TRANSFORM TO 204x60mm UNLESS STATED OTHERWISE.

16. SMOKE/FIRE DAMPERS TO BE INSTALLED TO EACH STUDIO.

3

Spatial Coordination

-	P01	PRELIMINARY ISSUE	CF	BD	13.01.23
STA	REV	DESCRIPTION	DES	CHD	DATE

PURPOSE OF ISSUE

PRELIMINARY ISSUE

NOVO

Integration Ltd

7 Feast Field, Horsforth, Leeds,
West Yorkshire, LS18 4TJ
t: +44(0)113 2577300 e: novocad@novo.eu.com

CLIENT

DOMIS

PROJECT

LIVERPOOL ROAD
MANCHESTER

TITLE

MECHANICAL SERVICES
BASEMENT LEVEL
VENTILATION LAYOUT

SCALE	ORIGINAL SIZE	DATE
1:50	A1	JAN '23
DRAWN	DESIGNED	CHECKED
CF	CF	BD

PROJECT | ORIGINATOR | ZONE | LEVEL | TYPE | ROLE | CLASS | NUMBER

P1824-NOV-XX-B1-DR-M-5701

REVISION

P01

VENTILATION