


THIS DRAWING IS AN INDICATIVE LAYOUT ONLY DEMONSTRATING THE CONCEPTUAL REQUIREMENTS CORRELATING WITH THE AGREED SCHEMATIC SOLUTIONS. THE PURPOSE OF THIS DRAWING IS TO DEMONSTRATE DESIGN INTENT FOR FURTHER DEVELOPMENT BY THE RELEVANT SERVICES DESIGNER ONLY.

THIS DRAWING SHALL BE PRINTED IN COLOUR TO FULLY UNDERSTAND CONCEPTUAL REQUIREMENTS SHOWN WITHIN

GENERAL POWER	
SYMBOL	DESCRIPTION
	EXISTING DUCTWORK
	EXISTING AC UNIT
	RECTANGULAR SUSPENDED LUMINAIRE
	ROUND SURFACE LUMINAIRE
	EMERGENCY DOWNLIGHTER
	SMOKE DETECTOR
	LIGHT TRACK
	PR PRESENCE ABSENCE DETECTOR



EXISTING 2x CONDENSER UNITS TO BE STRIPPED OUT ALONG WITH ASSOCIATED PIPINGWORK

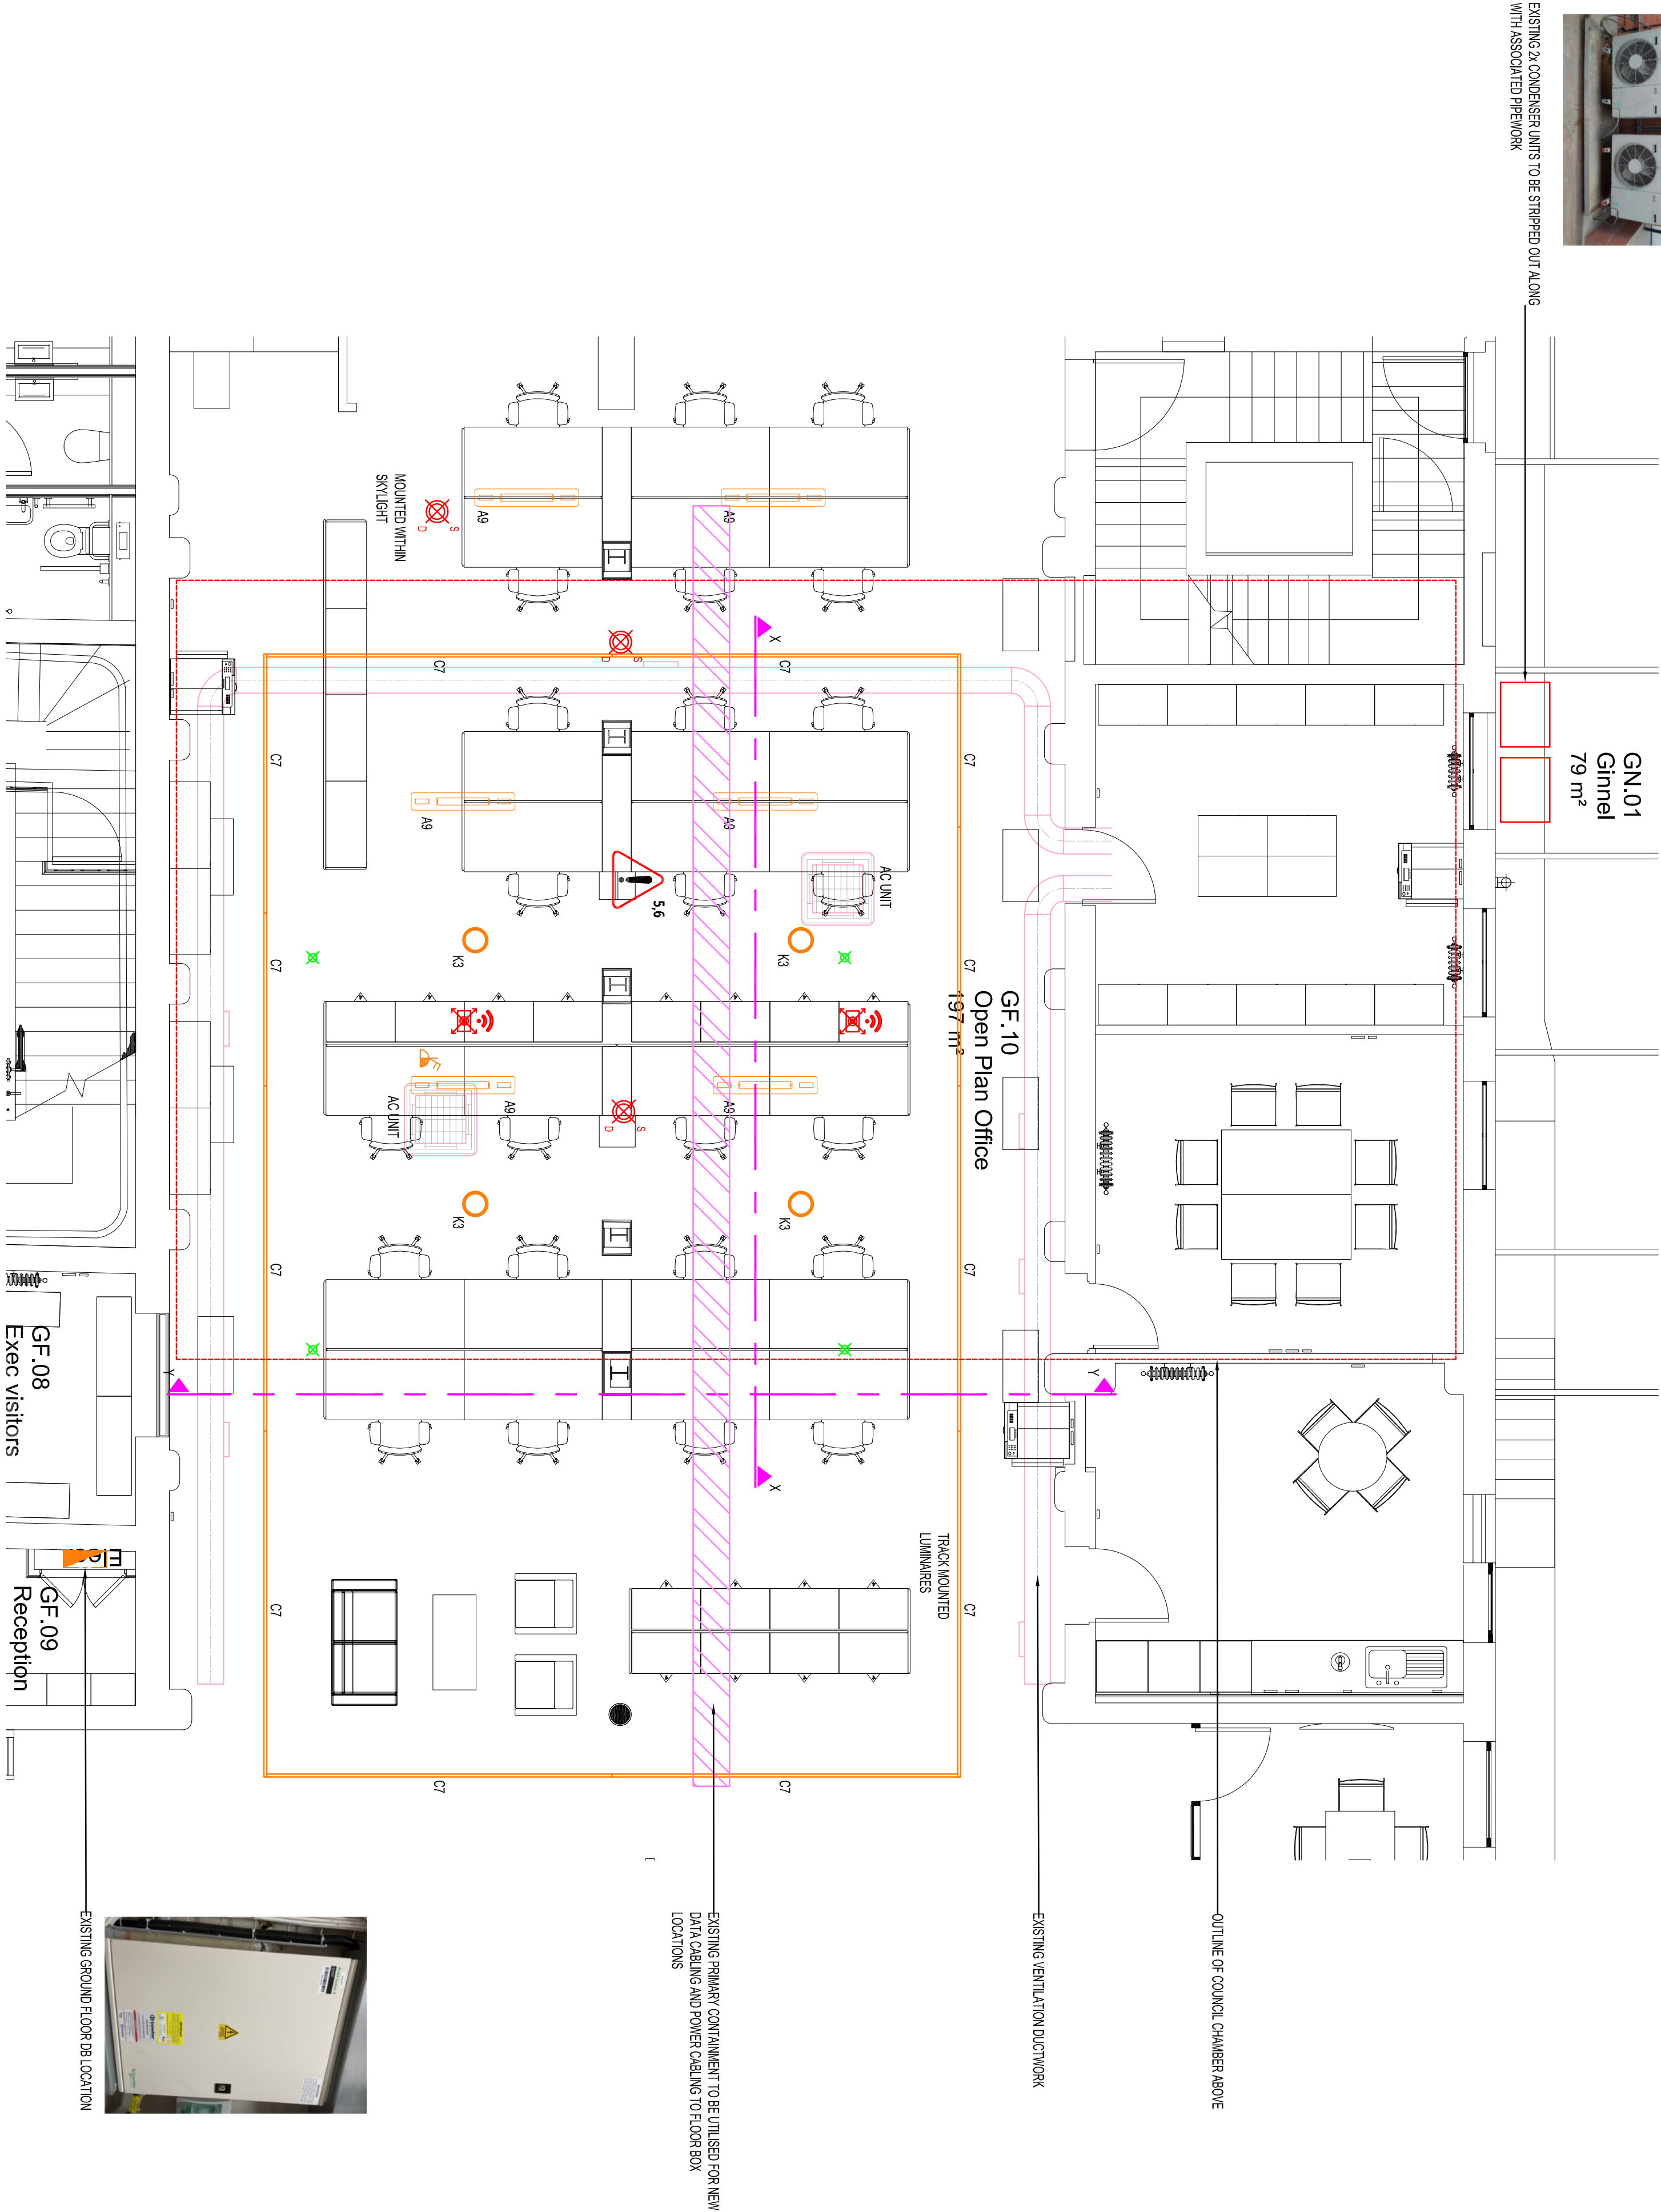

EXISTING GROUND FLOOR DB LOCATION

HEALTH AND SAFETY INFORMATION

Standard hazards and risks may not necessarily be identified on this drawing. The caution symbols that are identified, but not limited to, related to specific hazards and risks associated with the type of project.

Reference should be made to the DPA for further details.

Drawn	Description
No.	
5	Working in a live building.
6	Exposure to live electrical parts.

It is assumed that all works shall be undertaken by a competent contractor working, where appropriate, to an approved method statement.

NOTES

- AS FITTED DRAWINGS DO NOT APPEAR TO REFLECT THE INSTALLED LAYOUT ALLOW TO REPOSITION THREE FIRE ALARM DETECTORS.
- ALL EQUIPMENT/DEVICES THAT ARE REMOVED ARE TO BE SIMILAR, PROTECTED AND STORED SAFELY READY FOR RE-INSTALLATION ONCE DUCT WORK INSTALLATION COMPLETE.
- AS FITTED DRAWINGS ARE NOT ACCURATE. UNDERPAGE ARE THEBES SUBJECT TO BEING REVISITING SERVICES TO BE REPOSITIONING REFINISHED. TO BE UNDERPAGES IN ACCORDANCE WITH THE DRAWING AND THE REVISIONS.
- EXISTING SMOKE DETECTORS TO BE RELOCATED TO BE PROTECTED FROM CONTAMINATION DURING WORKS. INCURRING THE ALARM CONTRACTOR TO UNDERPAGES THE MODIFICATION WORKS IN ACCORDANCE WITH THE NEW FIRE STRATEGY.

FOR SECTION X-X AND SECTION Y-Y REFER
DRG NO: 230543-CPW-ZZ-00-DR-N-301004

TEL	01753 600000	3000000000	8	21
RE	DATE	30/09/2024	8	21

Address:
6th Floor, Arnhem House
1st Floor, Arnhem House
1st Floor, Arnhem House

Phone:
+44(0) 116 257 7397
Info@cpw.com

www.cpw.com

STAGE 4

Status

TENDER

Client



ONMOND BUILDING COUNCIL CHAMBER

GROUND FLOOR
EXISTING REFLECTED CEILING PLAN
LAYOUT

Scale (A1)	Date	By	Ve
1:50	OCT '23	JB	JH

Rev	Change	Scale	Date	By	Ve
202404	CPW	ZZ	00	PR	N

230543-CPW-ZZ-00-DR-N-301004 50 101

CPW Project No. 2305

Linked Files