


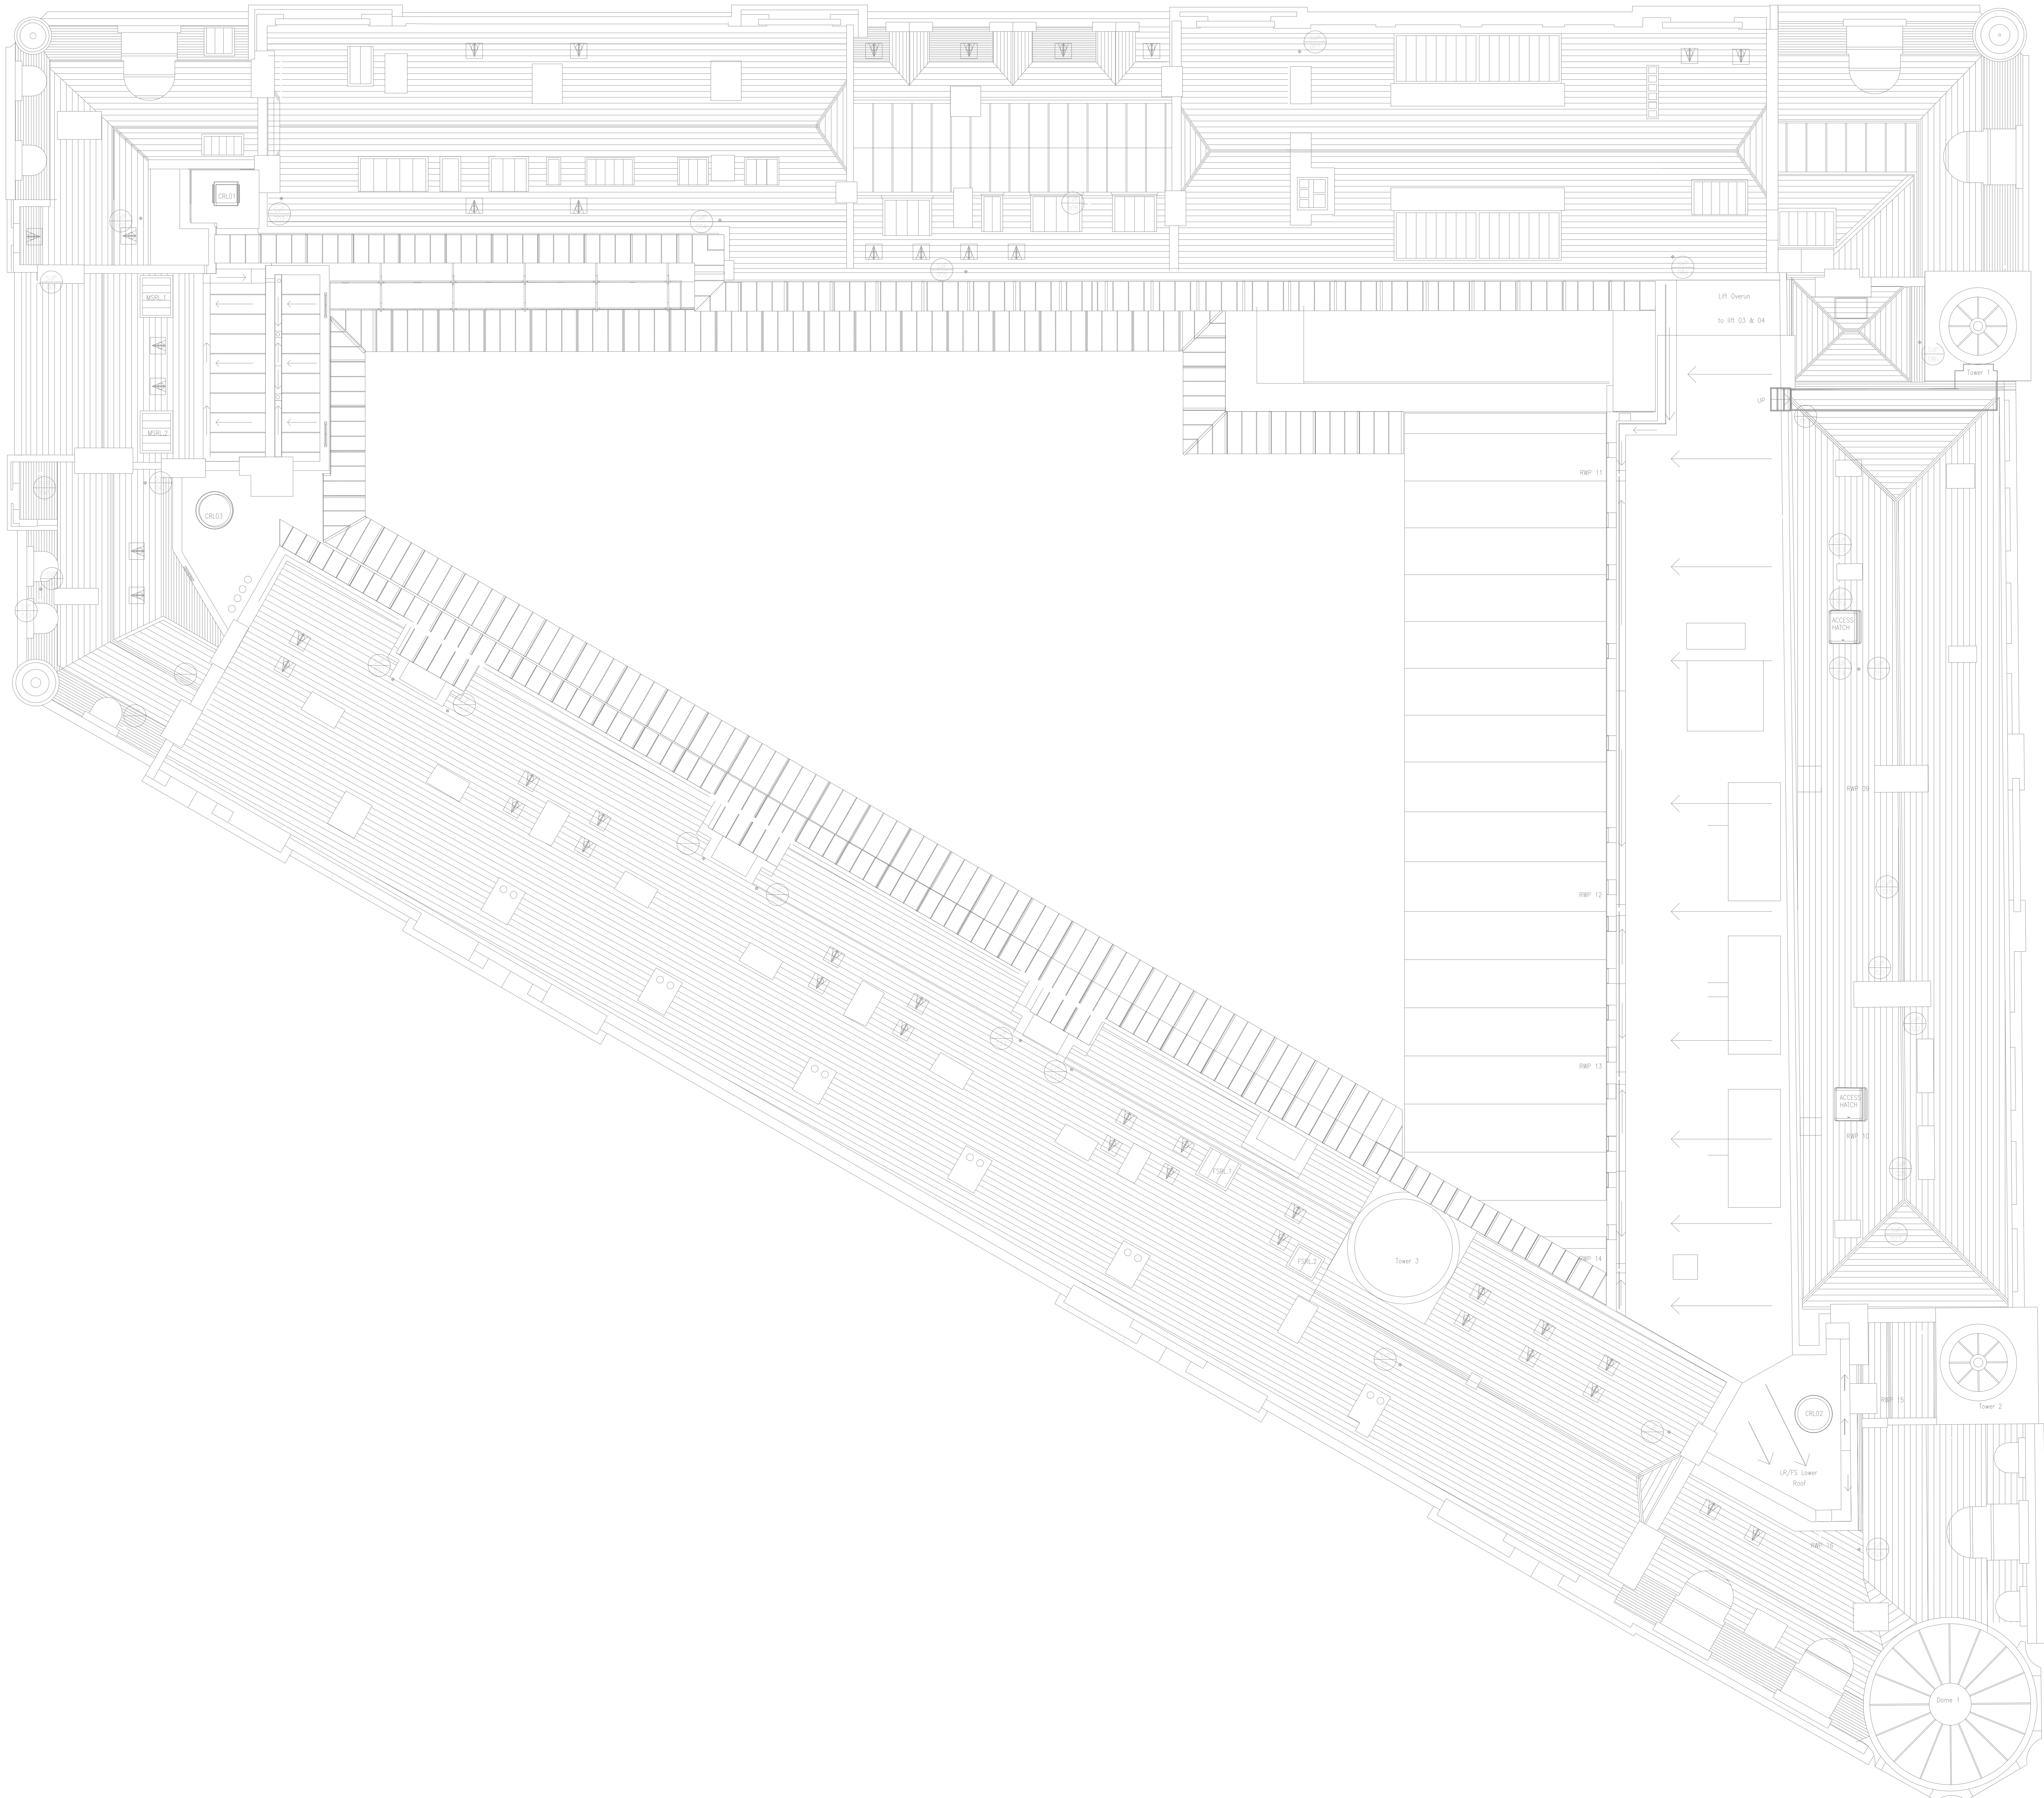

- NOTES
1. DO NOT SCALE FROM THIS DRAWING
 2. ALL DIMENSIONS TO BE CHECKED ON SITE BY THE CONTRACTOR PRIOR TO PREPARATION OF SHOP DRAWINGS, FABRICATION OF PARTS, ORDERING MATERIALS OR COMMENCING WORKS
 3. THIS DRAWING IS TO BE READ IN CONJUNCTION WITH ALL OTHER CONSULTANTS DRAWINGS, SPECIFICATIONS AND SCHEDULES
 4. ANY PENETRATION THROUGH FLOOR, SEEK STRUCTURAL ENGINEERS APPROVAL BEFORE COMMENCEMENT
 5. ALL PLANT AND EQUIPMENT SHALL BE INSTALLED FULLY IN ACCORDANCE WITH MANUFACTURER'S RECOMMENDATIONS

- LEGEND
- CCTV CAMERA
 - WEATHER PROOF CCTV CAMERA IP65
 - ACCESS CONTROLLED DOOR COMPRISED OF:
MAGLOCK/PSU
GREEN BREAK GLASS
PUSH TO EXIT BUTTON
(MANUFACTURER - SAIJO BLUENET - WIRELESS & WI-FI BASED SYSTEM)
 - ACCESS CONTROL FOR LIFT
(FINAL DETAILS TO BE CONFIRMED WITH LIFT SPECIALIST/MANUFACTURER)
 - DOOR INTERCOM PHONE SYSTEM
 - CARD READER (HOTEL ROOM)
TYPICALLY OFF-LINE. FINAL DETAILS TBC BY THE ACCESS CONTROL SPECIALIST
(MANUFACTURER - AITO SAIJO - RFID, WIRELESS & BLUETOOTH SMART)
 - DOOR HOLD OPEN DEVICES

NOTE:
ALL DOOR HOLD OPEN DEVICES,
ACCESS CONTROLLED DOORS & LIFTS
TO BE INTERFACED WITH THE FIRE
ALARM SYSTEM

FOR COMMENT
NOT FOR SITE USE

13.04.22	TENDER ISSUE	T4	AL	SEJ
07.02.22	TENDER ISSUE	T3	AL	ES
02.04.21	INCORPORATED INTERIOR DESIGNER COMMENTS	T2	PR	SEJ
21.05.21	TENDER ISSUE	T1	PR	SEJ
26.03.21	INTERIM ISSUE FOR CLIENT COMMENTS	P1	PR	FR
26.02.21	PRELIMINARY ISSUE	P1	RW	FR
Date	Description	Rev	Drawn	Check
Revision Description				

CONSOLUX
CONSOLUX M&E CONSULTING LTD.
MECHANICAL & ELECTRICAL CONSULTING ENGINEERS

London Office: 35 Piccadilly, London W1J 0DW
Tel: +44 (0)207 734 3030
Fax: +44 (0)207 617 7385
Email: mail@consolux.co.uk

Liverpool Office: The Cavern Exchange, Liverpool L3 9RF
Tel: +44 (0)151 708 9669
Fax: +44 (0)151 709 7196
Website: www.consolux.co.uk

Project:
**LONDON ROAD FIRE STATION
FIRE STATION, LONDON ROAD
MANCHESTER, M1**

Drawing Title:
**ELECTRICAL INSTALLATION SERVICES
ROOF LEVEL
SECURITY LAYOUT**

Date:	Design By:	Drawn By:	Scale:
24.02.21	FR	RW	1:100

Issue Number:
TENDER

Drawing Number:
647-E-(64)-RL-01

Rev:
T4