
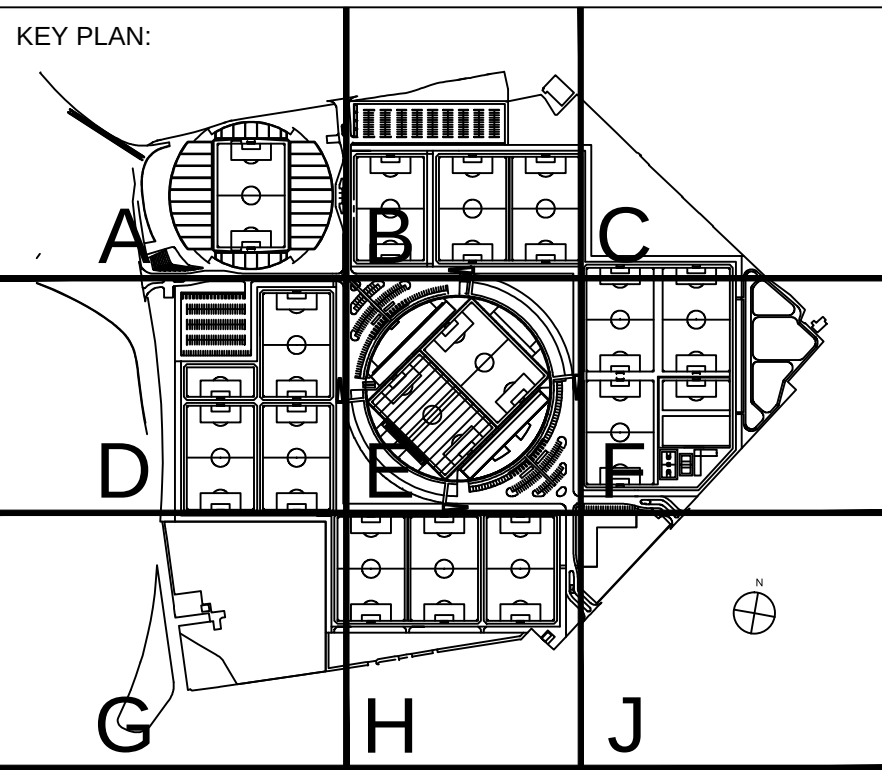


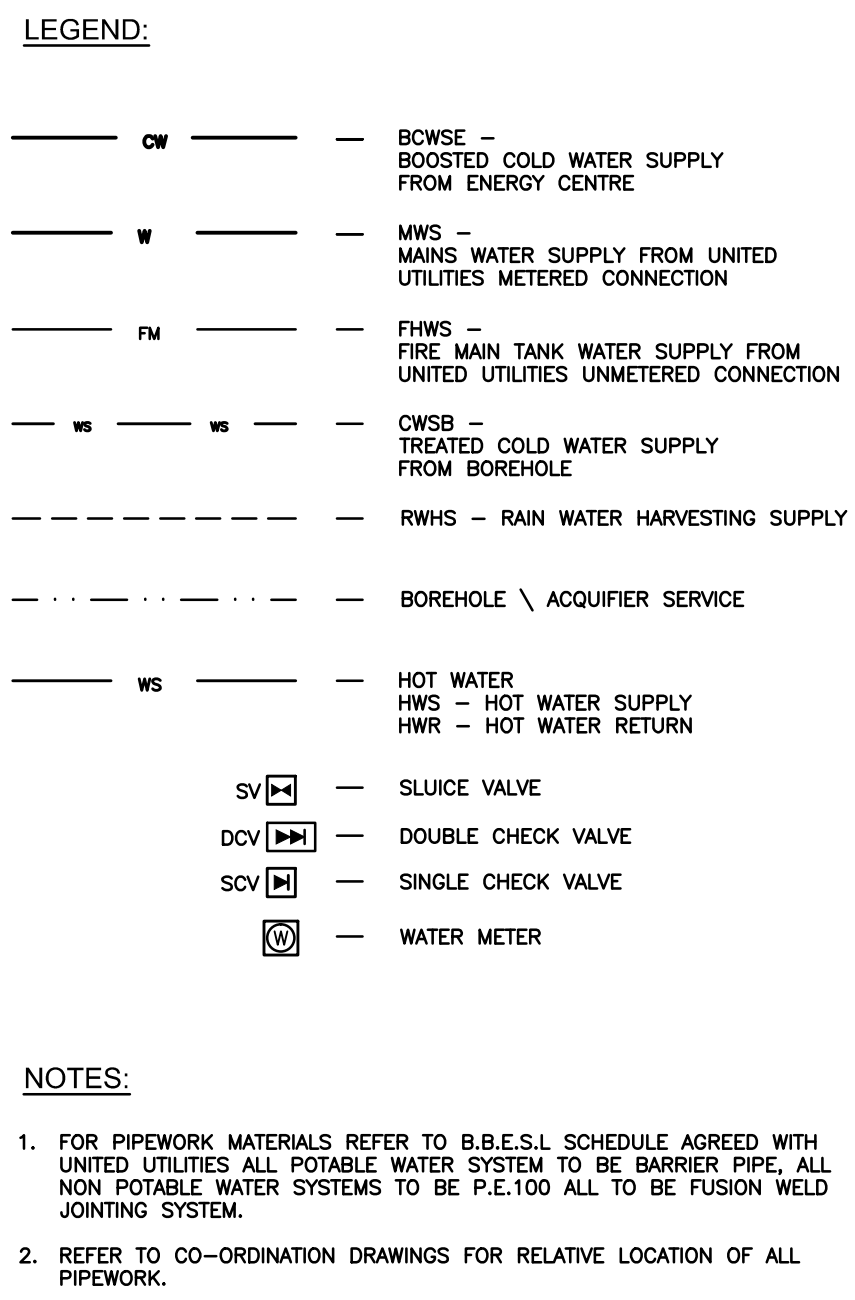

The Designer operates a Quality Management System certified to ISO 9001.
 SERVICE INFORMATION ONLY TO BE TAKEN FROM THIS DRAWING.
 Use figure dimensions - DO NOT SCALE FROM THIS DRAWING.
 Where Architects details are shown on this drawing, these are indicative and
 reference should be made to the appropriate Architect's drawing.

PROJECT NAME AND LOCATION:
MANCHESTER CITY FOOTBALL ACADEMY
 MANCHESTER, M11 3FF
 TEL: N/A

OWNER:
MANCHESTER CITY FOOTBALL CLUB LTD
ETIHAD STADIUM,
MANCHESTER, M11 3FF
TEL: +44 161 438 7768

PROJECT MANAGER / CDM CO-ORDINATOR:
CHRISTAL MANAGEMENT LTD
BASS WAREHOUSE, 4 CASTLE STREET
MANCHESTER, M3 4LZ
TEL: +44 161 819 2822

DESIGN AND BUILD CONTRACTOR:
BAM CONSTRUCTION LTD
NEW COURT, REGENTS PLACE REGENTS ROAD
SALFORD, MANCHESTER, M5 4HB
T: +44 161 877 9274

ARCHITECT OF RECORD:
RAFAEL VIÑOLY ARCHITECTS PC
11 - 29 FASHION STREET
LONDON, E1 6PX
TEL: +44 20 8206 6200

STRUCTURAL ENGINEER:
ARUP
8TH FLOOR, ST JAMES'S BUILDINGS, OXFORD STREET,
MANCHESTER, M1 6EL
TEL: +44 161 228 2331

ENVIRONMENTAL ENGINEER:
BALFOUR BEATTY PLC
5000 LAKESIDE, CHEADLE ROYAL BUSINESS PARK
CHEADLE, STOCKPORT. SK8 3AX
TEL: +44 161 741 6100

LANDSCAPE ARCHITECT:
PLANIT
2 BACK GRAFTON, ALTRINCHAM
CHESHIRE, WA14 1DY
TEL: +44 161 928 9281

AF	AS BUILT	DEC. 2014	CD	AL/SC
REV	DESCRIPTION	DATE	DRWN	APRV

DRAWING ORIGINATOR:

Balfour Beatty
Engineering Services

DRAWING TITLE:

INFRASTRUCTURE SERVICES SITE PLAN
SITE WATER SERVICES EXTERNAL MAINS
BOREHOLE & BOOSTED WATER INSTALLATION

DATE: NOV. 2012	SCALE: 1:750	SIZE: A0
DRAWING NUMBER / FILE NAME:		

DRAWING NUMBER / FILE NAME:
G1518/P(96)002

STAGE: STAGE F1 REV: AF

DISCLAIMER:

THE ARCHITECT SHALL HAVE NO RESPONSIBILITY FOR ANY LIABILITY, LOSS, COST, DAMAGE OR EXPENSE ARISING FROM OR RELATING TO ANY USE OF THIS DOCUMENT FOR ANY PURPOSE OTHER THAN ITS INTENDED PURPOSE ON THIS PROJECT. THIS DOCUMENT IS PROTECTED BY COPYRIGHT.

THIS DOCUMENT IS TO BE CONSIDERED IN CONJUNCTION WITH ALL RELATED DOCUMENTATION.

ANY DISCREPANCIES IDENTIFIED IN THIS DOCUMENT MUST BE REPORTED IMMEDIATELY TO THE ARCHITECT OF RECORD BEFORE PROCEEDING.

CONTRACTORS MUST VERIFY ALL DIMENSIONS PRIOR TO PROCEEDING WITH ANY WORK. ONLY FIGURED DIMENSIONS ARE TO BE USED FOR VERIFICATION.

DOCUMENT STATUS: **AS FITTED**



This document had been declared:

RESTRICTED

To be viewed by MCFC employees
or external named persons only.