


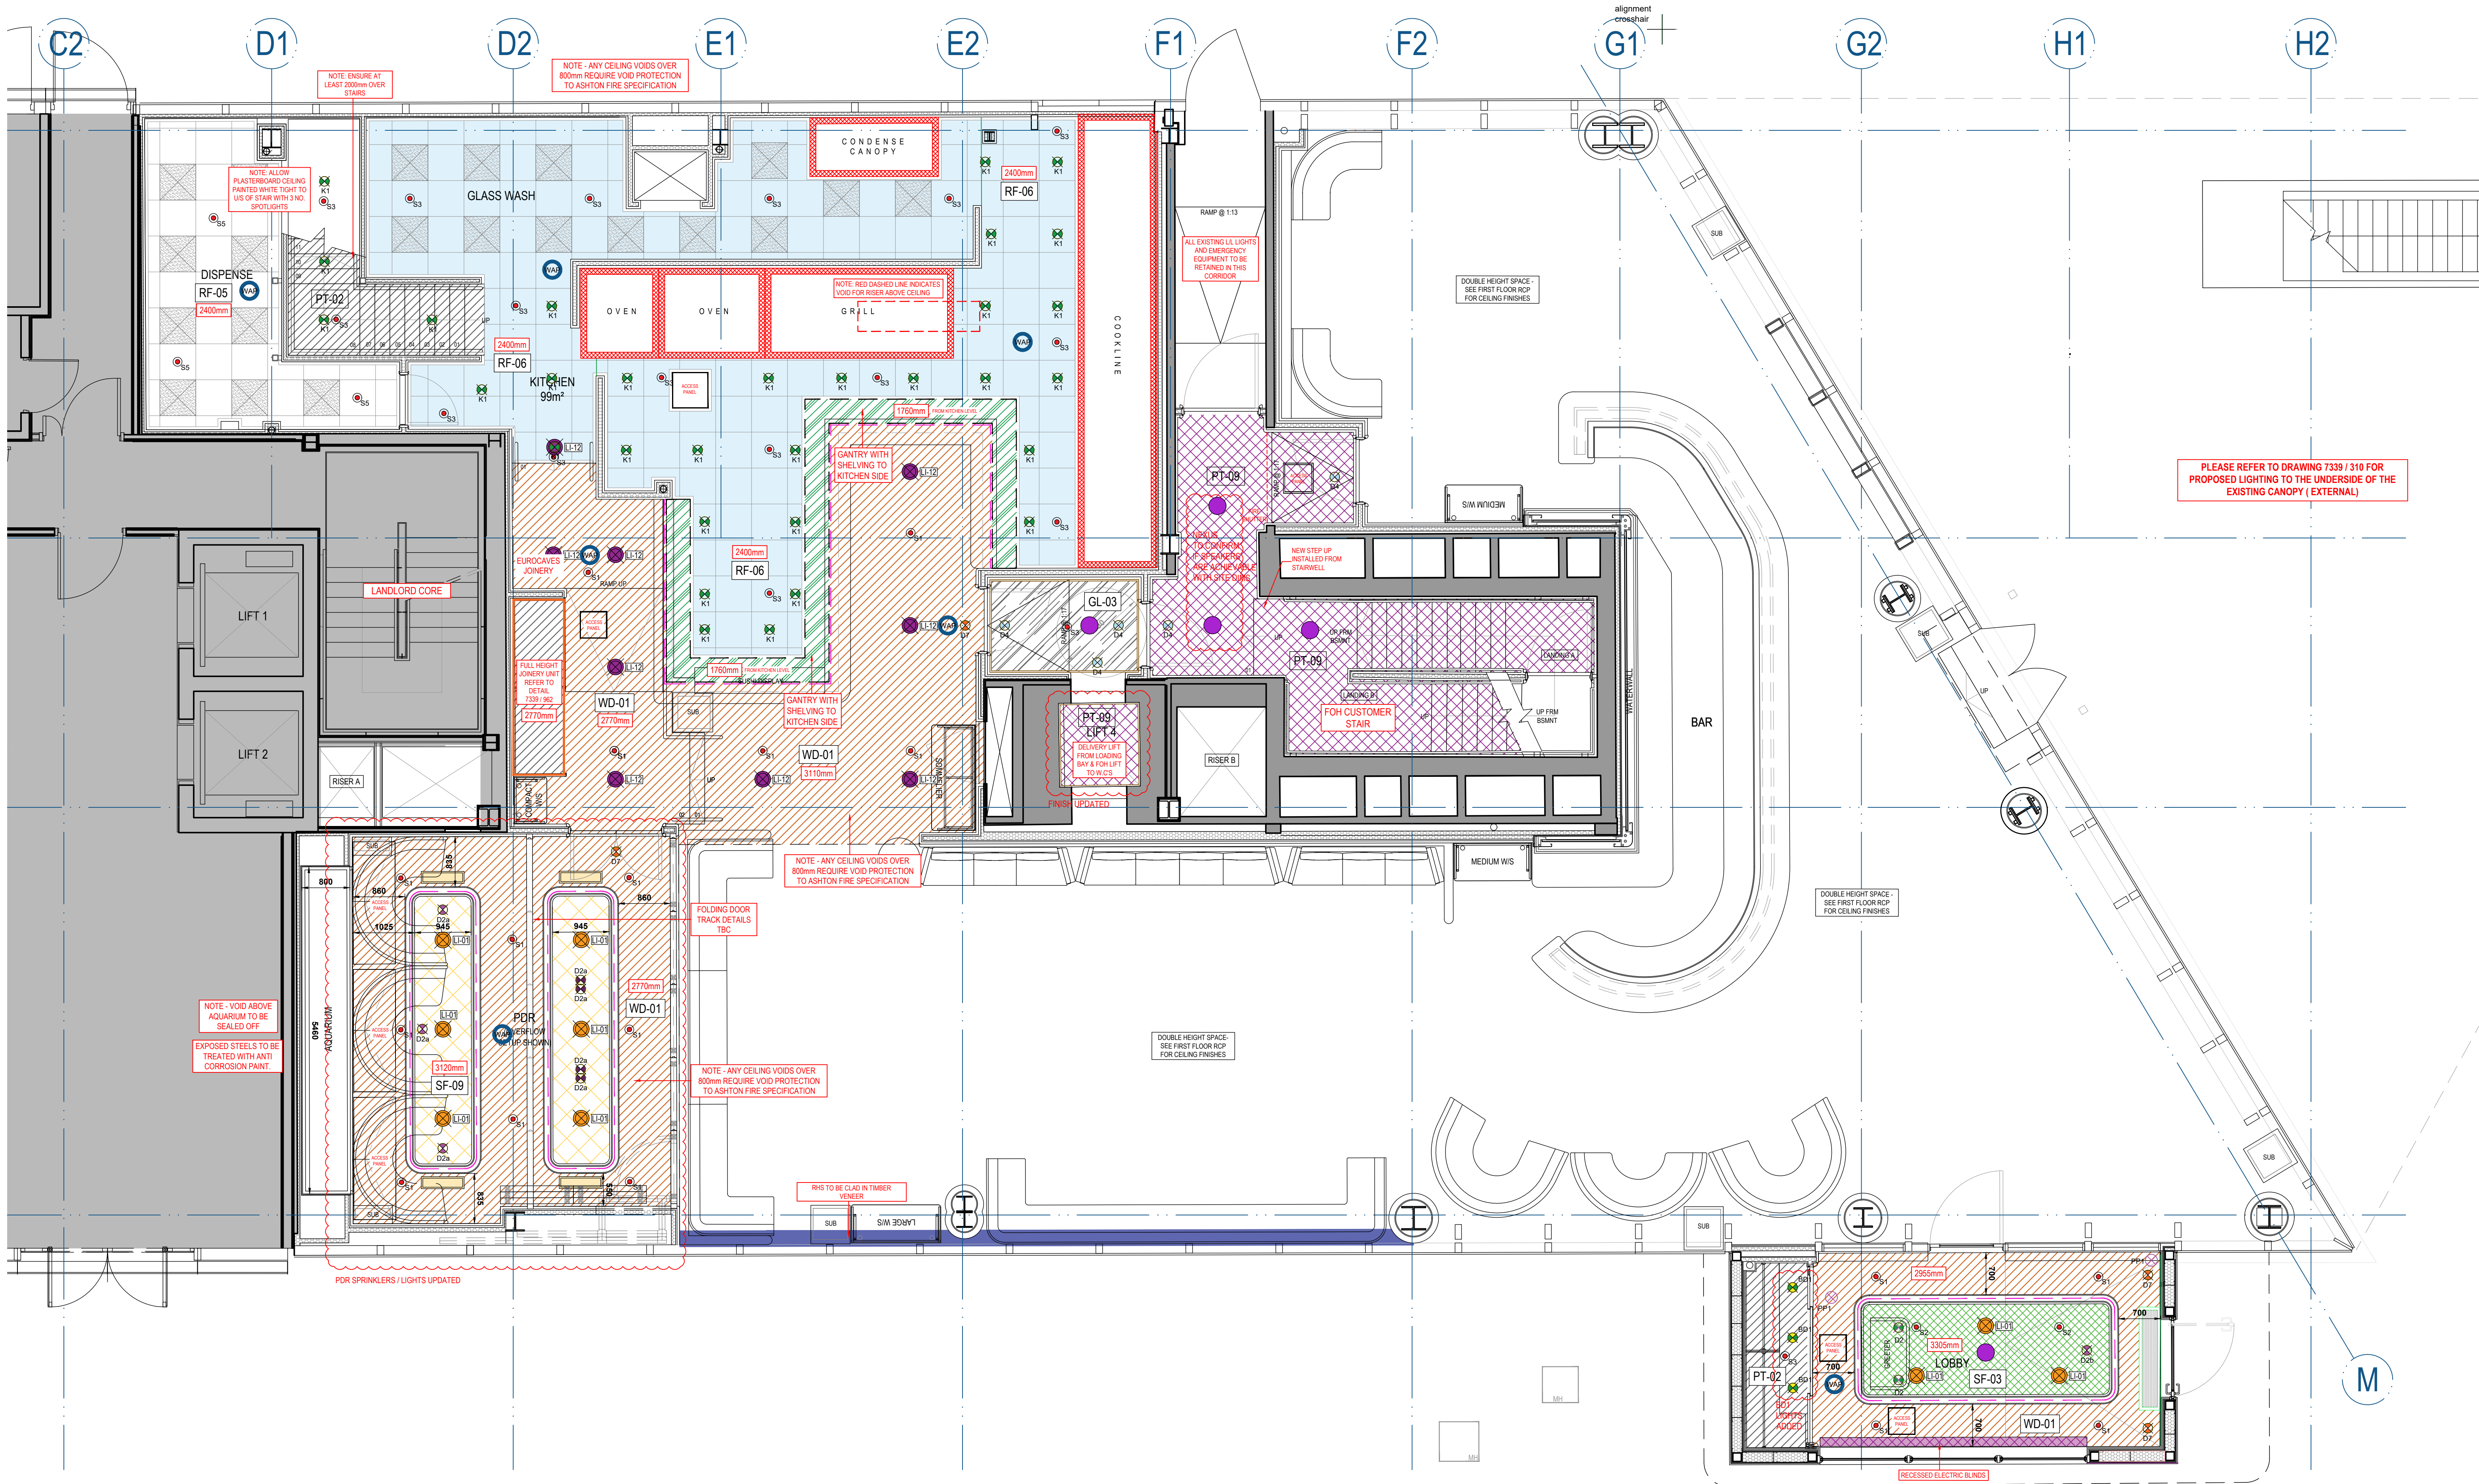

SPRINKLER LEGEND

SYMBOL SPECIFICATION

	SPRINKLER WITHIN TIMBER FINISH & ARTWORK COFFER - RAL (K7) 8025
	SPRINKLER WITHIN PDR AND LOBBY COFFER- RAL (K7) 1036
	SPRINKLER WITHIN MIRROR CEILING, MENS W.C.S, DWC & OPEN KITCHEN - RAL (K7) 9011
	SPRINKLER WITHIN PAINTED FEMALE WC - RAL (K7) 1035
	SPRINKLER WITHIN GRID TILES - STANDARD WHITE

LIGHTING LEGEND

SYMBOL SPECIFICATION

	POLISHED NICKEL ALRESFORD UPLIGHTER WITH BRASS INTERIOR SHADE
	HIGH OUTPUT SIDE BEND ENCAPSULATED LED
	HIGH OUTPUT LED TAPE IN PROFILE
	LINEAR SWIMMING-POOL RATED LED LIGHT FITTING
	DARK BRONZE SPOT DIFFUSER
	PINHOLE DOWNLIGHT 12DEG
	PINHOLE DOWNLIGHT 12DEG
	PINHOLE DOWNLIGHT
	SMALL PINHOLE DOWNLIGHT 24DEG
	SMALL PINHOLE DOWNLIGHT 15DEG
	PINHOLE DOWNLIGHT
	PINHOLE DOWNLIGHT MEDIUM BEAM
	PINHOLE DOWNLIGHT
	PINHOLE DOWNLIGHT MEDIUM BEAM
	PINHOLE DOWNLIGHT NARROW BEAM
	IP RATED ADJUSTABLE DOWNLIGHT
	PINHOLE DOWNLIGHT 24DEG - GOLD LEAF
	MINIATURE FIXED DOWNLIGHT
	SMALL PINHOLE DOWNLIGHT - 15DWG
	SMALL SPOTLIGHT WITH NARROW BEAM
	TRACK MOUNTED SPOTLIGHT
	TRACK MOUNTED SPOTLIGHT
	SPOTLIGHT
	PROVISION FOR POWER
	BOH FLUSH MOUNT LIGHT FITTING
	SUSPENDED CEILING TILE LIGHT
	ROGUE R2X
	DIABLO LIGHTING
	LED WITHIN PERIMETER COFFER
	INDICATIVE OF CEILING SPEAKER
	FWP GRILLE
	WIFI ACCESS POINT WITHIN CEILING VOID - ACCESS REQUIRED

CEILING LEGEND - HEIGHTS IN RED

ALL NEW GRILLES, SPEAKERS, CAMERAS, EMERGENCY LIGHTS & EMERGENCY DETECTION TO BE IN LINE WITH LIGHTING LAYOUT

SYMBOL	SPECIFICATION	
	TIMBER FINISH HEIGHT - SEE PLAN	WD-01
	DECORATIVE FABRIC TO CEILING COFFER HEIGHT - SEE PLAN	SF-01
	REAL GOLD LEAF TO PDR COFFER AND ALSO TO BE USED FOR LOW LEVEL COFFER DETAILS HEIGHT - SEE PLAN	SF-09
	MIRROR TILES WITHIN BRASS FRAME HEIGHT - VARIES	GL-03
	PROPOSED MF CEILING - GREY PAINT FINISH HEIGHT - SEE PLAN	PT-02
	FEMALE WC CEILING - PAINTED	PT-08
	FEMALE LOBBY - ARCHITRAVE / LINING MARBLE - ROSA PORTAGALLO HEIGHT - SEE PLAN	ST-07
	SUSPENDED CEILING TILES ON GRID - WHITE HEIGHT - SEE PLAN	RF-05
	SUSPENDED CEILING TILES ON GRID - BLACK HEIGHT - SEE PLAN	RF-06
	PROPOSED MF CEILING, PAINTED DULUX WHITE - RAL TBC HEIGHT - SEE PLAN	
	WHITE ROC CLADDING SHEETS HEIGHT - SEE PLAN	
	BACK LIT ALABASTER PANEL HEIGHT - SEE PLAN	ST-08
	ALLOWANCE FOR TIMBER FINISH TO RHS REFER TO DETAIL	WD-01
	PROPOSED RECESSED ELECTRIC BLINDS	
	PROPOSED BULKHEAD TO TOP OF WATERWALL - FOR INTEGRATED LIGHTING - 7720MM FROM FFL - REFER TO DETAIL	
	PAINTED FINISH TO STAIRCORE, MALE W.C, DDA	PT-09
	HARDWEARING MATTE VINYL TO LIFT	SF-12
	GOLD LEAF EFFECT WALLPAPER HEIGHT - SEE PLAN	SF-03
	TIMBER GANTRY OVER KITCHEN PASS - REFER TO DETAIL - HEIGHT - SEE PLAN	

PROPOSED GROUND FLOOR PLAN

AREA - 602m² / 6477ft²


RESTAURANT - GROUND	138 NO.
BAR	18 NO.
TOTAL	156 NO.

DINING SETUP (SUNDAY - WEDNESDAY)

FOR CEILING CAVITY BARRIERS REFER TO DRAWING 7339-312 FOR SETTING OUT

NOTE
DO NOT SCALE FROM THIS DRAWING. ALL DIMENSIONS ARE TO BE CHECKED ON SITE PRIOR TO MANUFACTURE/CONSTRUCTION. ANY DISCREPANCIES ARE TO BE REPORTED TO PUMPHOUSE DESIGNS

NOTE
SHOP DRAWINGS TO BE PROVIDED FOR SIGN OFF BEFORE MANUFACTURE

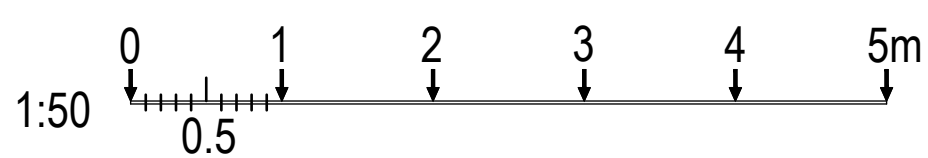

GENERAL NOTES

ALL DIMENSIONS TO BE CHECKED ON SITE PRIOR TO COMMENCEMENT OF WORKS - PLEASE REPORT ERRORS OR OMISSIONS TO THE ARCHITECT


THIS DRAWING HAS BEEN PRODUCED FOR THE PURPOSES OF PLANNING AND BUILDING REGULATING APPROVALS ONLY AND IS NOT INTENDED TO BE A FULL WORKING DRAWING

THIS DRAWING IS TO BE READ IN CONJUNCTION WITH ANY WRITTEN SPECIFICATIONS, SCHEDULES OF WORK AND STRUCTURAL ENGINEERS DETAILS AS APPROPRIATE

THIS DRAWING IS THE COPYRIGHT OF PUMPHOUSE DESIGNS AND ANY FURTHER REPRODUCTION OF THE PLAN IS NOT PERMITTED WITHOUT OBTAINING PRIOR CONSENT.

© CROWN COPYRIGHT - LICENCE NO. 100032227

NOTE
ALL LIGHTING TO BE REVIEWED BY SPECIALIST

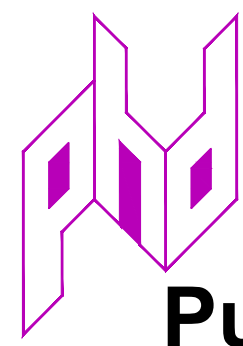

Pump House Yard
The Green
Sedlescombe
East Sussex
TN33 0QA
info@pumphousedesigns.co.uk
www.pumphousedesigns.co.uk

T: 01424 871120

V	KITCHEN UPDATES TO TIERIFY LAYOUTS	AG	21.07.23
U	PDR UPDATES - LIGHTS ADDED TO CEILINGWALL	PR	19.07.23
Y	SPEAKERS ADDED	AT	14.07.23
S	PDR AREA UPDATED	PR	11.07.23
R	SPRINKLERS UPDATED	AT	06.07.23
Q	SEATING LAYOUT AMENDED	AT	30.06.23
P	KITCHEN CEILING AMENDED	AT	29.06.23
O	SPRINKLER COVERS AMENDED	AT	13.06.23
N	RE ISSUED WITH UPDATED LAYOUT	AG	12.06.23
M	UPDATES TO LATEST LAYOUT	PR	10.06.23
L	UPDATES TO LATEST LAYOUT	PR	12.06.23
K	PDR UPDATES - FINISH IN LOBBY AMENDED	PR	31.05.23
J	AMENDMENTS TO LOBBY ROOMS & LOBBY AND BAR	AT	08.05.23
I	COFFER OMITTED A MINOR AMENDMENTS	AT	06.05.23
H	LOBBY AREA UPDATES TO LATEST LAYOUT	PR	29.11.22
G	AMENDMENTS MADE TO MATCH NEW LAYOUT	CM	07.11.22
F	GA AMENDMENTS	OT	14.09.22
E	AQUARIUM ACCESS PANELS AMENDED	CM	23.08.22
D	UPDATES FOLLOWING MANQUEE INFO	OT	16.08.22
C	GA AMENDMENTS	OT	01.08.22
B	MINOR AMENDMENTS	AT	14.07.22
A	MINOR AMENDMENTS	AT	01.07.22

SEXY FISH - MANCHESTER
2 SPINNINGFIELDS SQUARE
MANCHESTER
M3 3AE

PROPOSED REFLECTIVE CEILING PLAN - GROUND FLOOR

DRAWN BY - A TIDMARSH
DATE - MARCH 2022
SCALE - 1:50 @ A0

DRAWING No: 7339 / 302 / V