 
 



THIS DRAWING IS AN INDICATIVE LAYOUT ONLY, DEMONSTRATING THE CONCEPTUAL REQUIREMENTS CORRELATING WITH THE AGREED SCHEMATIC SOLUTIONS. THE PURPOSE OF THIS DRAWING IS TO DEMONSTRATE DESIGN INTENT, FOR FURTHER DEVELOPMENT BY THE RELEVANT SERVICES DESIGNER ONLY.

THIS DRAWING SHALL BE PRINTED IN COLOUR TO FULLY UNDEFSIAND CONCEPTUAL REQUIREMENTS SHOWN WITHIN

GENERAL POWER	
SYMBOL	DESCRIPTION
	EXISTING DUCTWORK
	EXISTING AC UNIT
	REPOSITIONED AC UNIT
	RECTANGULAR SUSPENDED LUMINAIRE
	A9 ROUND SURFACE LUMINAIRE
	K3 EMERGENCY DOWNLIGHTER
	SMOKE DETECTOR
	LIGHT TRACK
	EXISTING PR PRESENCE ABSENCE DETECTOR
	REPOSITIONED PR PRESENCE ABSENCE DETECTOR



EXISTING 2x CONDENSEN UNITS TO BE STRIPPED OUT ALONG WITH ASSOCIATED PPEWORK

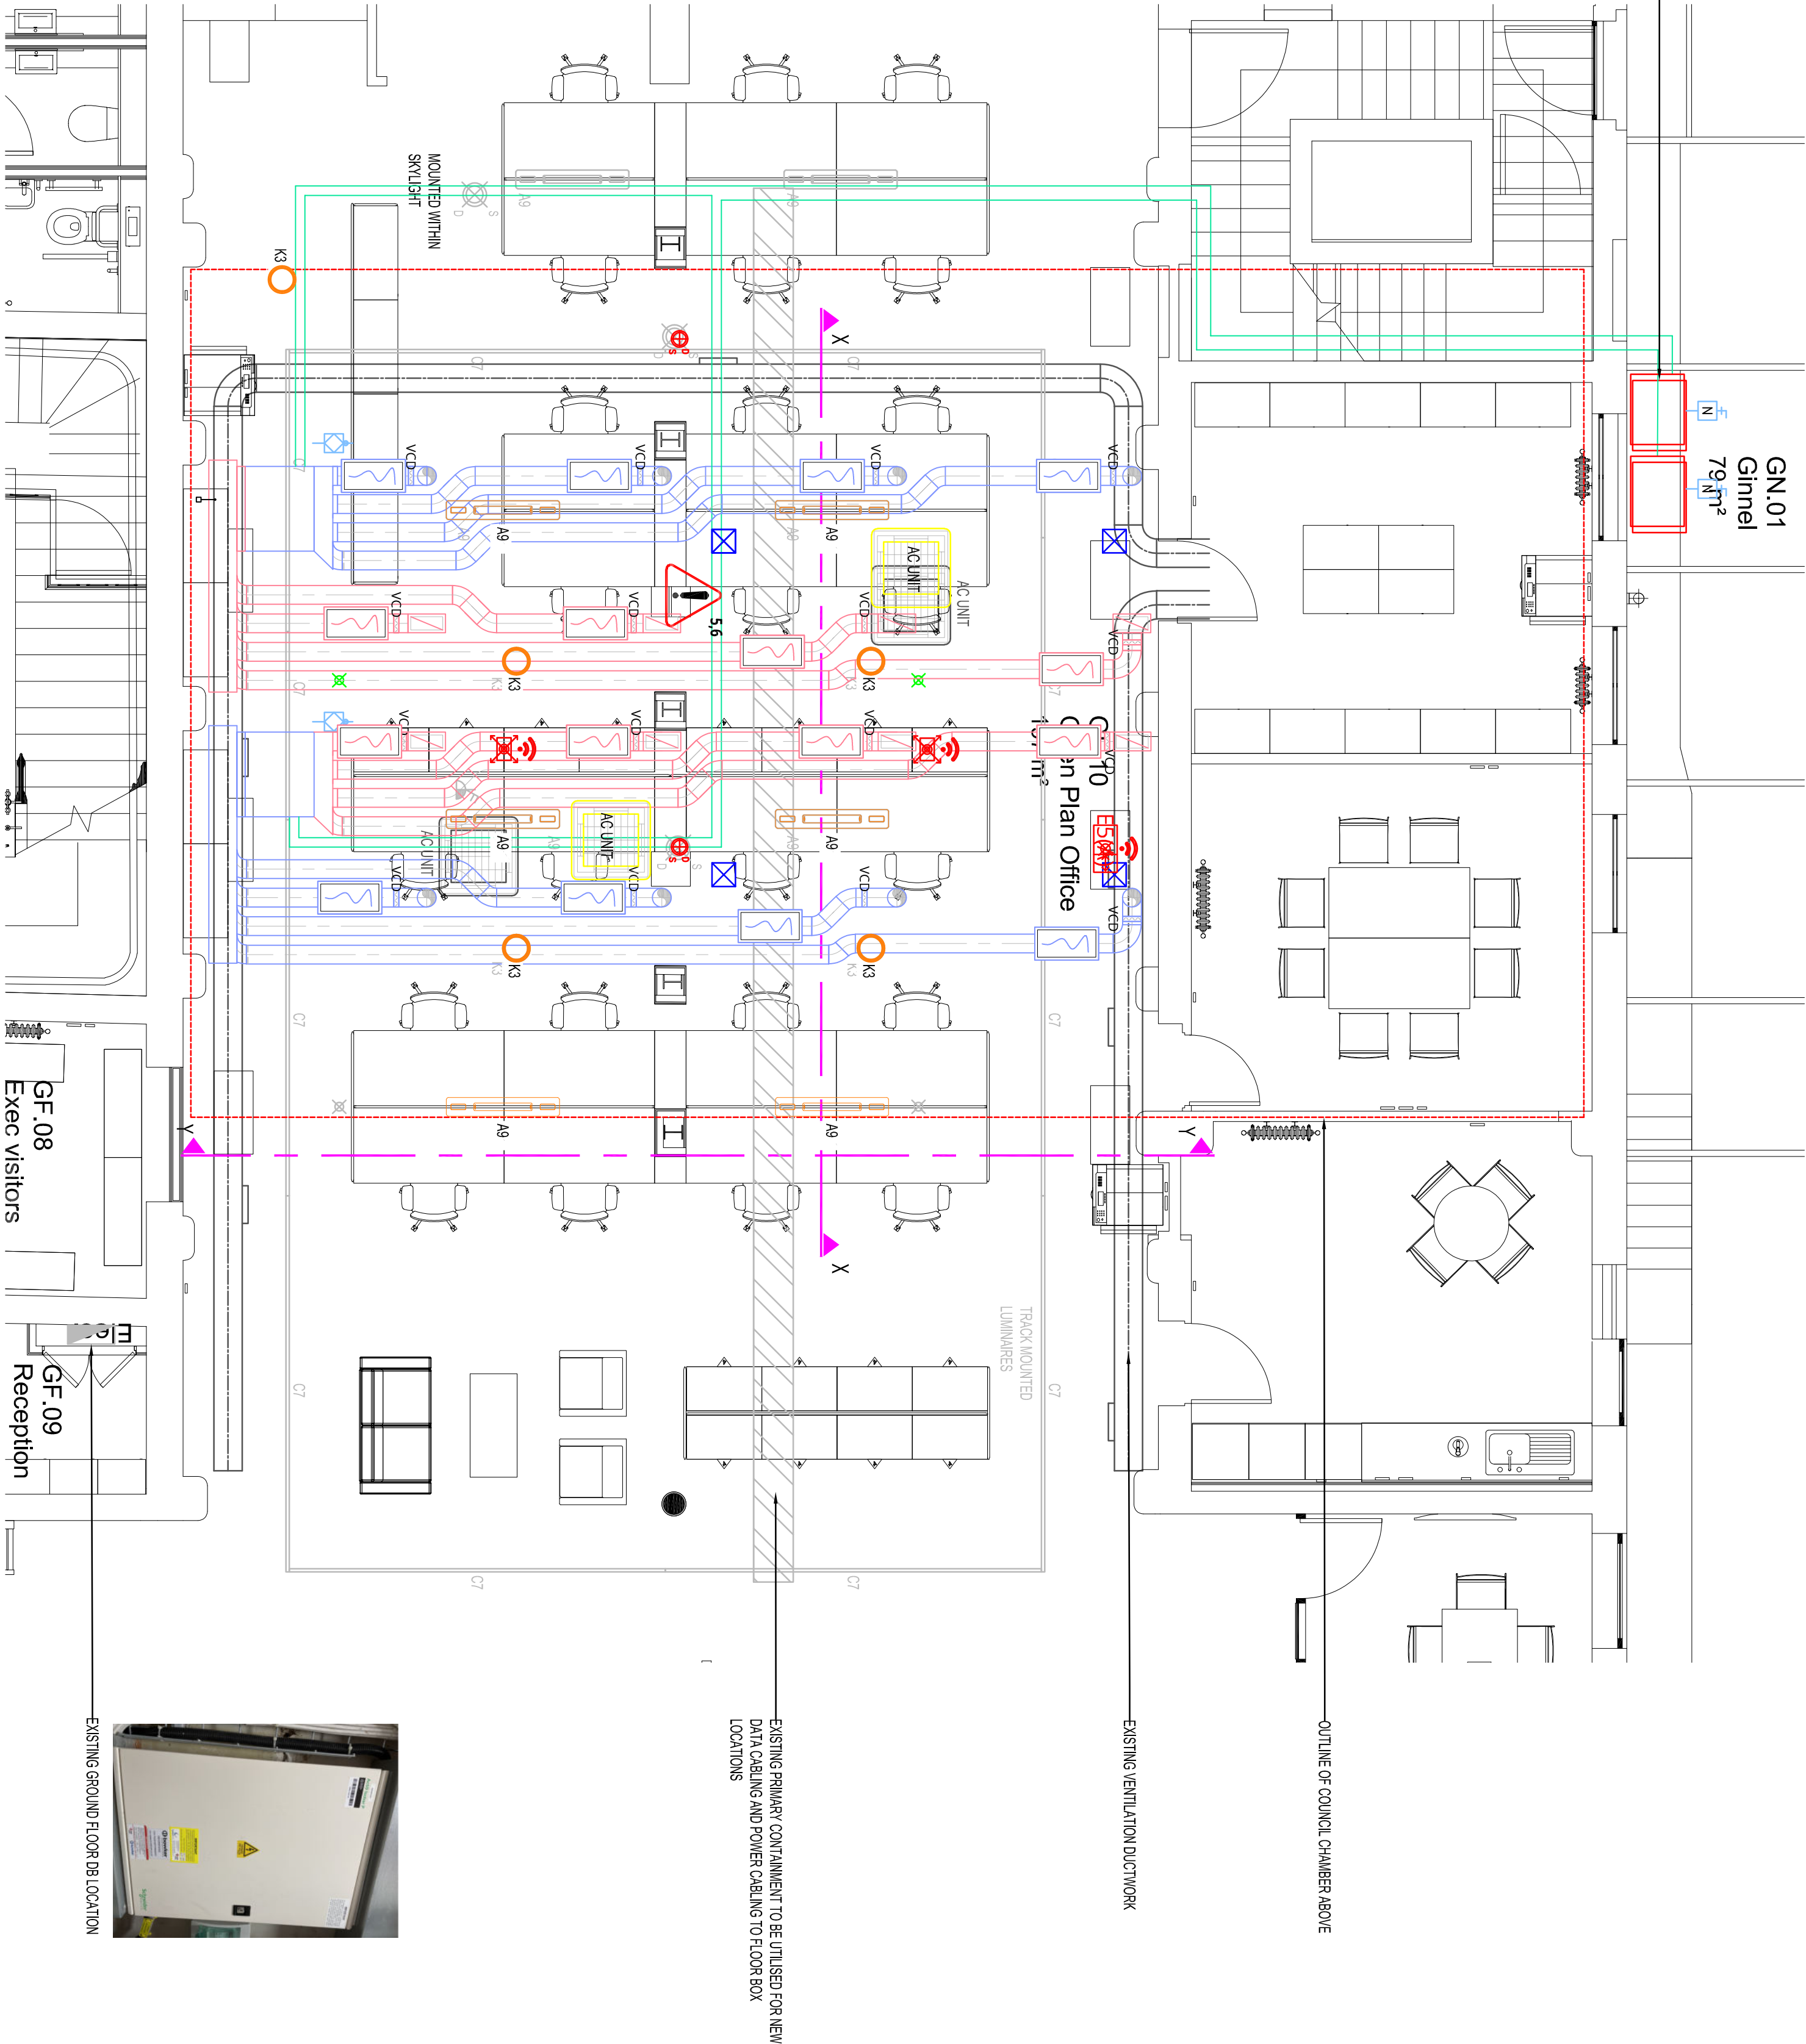

EXISTING GROUND FLOOR DB LOCATION

HEALTH AND SAFETY INFORMATION

Standard hazards and risks may not necessarily be identified on this drawing. The caution symbols that are identified, but not limited to, related to specific hazards and risks associated with this type of project.

Reference should be made to the project details.

DBA Ref No.	Description
5	Working in a live building.
6	Exposure to live electrical parts.

It is assumed that all works shall be undertaken by a competent contractor working, where appropriate, to an approved method statement.

NOTES

- AS FITTED DRAWINGS DO NOT APPEAR TO REFLECT THE INSTALLED LAYOUT ALLOW TO REPOSITION THREE FIRE ALARM DETECTORS.
- ALL EQUIPMENT/ DEVICES THAT ARE REVISED ARE TO BE SUPPLY PROTECTED AND STORED READY READY FOR RE-INSTALLATION ONCE DUCT WORK INSTALLATION COMPLETE.
- AS FITTED DRAWINGS ARE NOT ACCURATE. UNDERLINE A DETAILLED SURVEY TO IDENTIFY EXISTING SERVICES TO BE REPOSITIONED/RE-INSTALLED.
- FIRE ALARM SPECIALIST TO ADVISE LOCATION OF REPOSITIONED DEVICES. TO BE UNDERSTANDEN IN ACCORDANCE WITH HMD STANDARDS AND HMD FIRE STANDARDS.
- EXISTING SMOKE DETECTORS TO BE RELOCATED TO BE PROTECTED FROM CONTAMINATION DURING WORKS. INCLUDE THE ALARM CONTRACTOR TO UNDERSTAND THE MODIFICATION WORKS IN ACCORDANCE WITH THE HMD FIRE STANDARDS.
- EXISTING EXISTING AC UNIT LOCATION. RELOCATE THE NEW RELOCATED POSITION OF THE AC UNIT TO ALLOW THE INSTALLATION OF THE PROPOSED DUCTWORK.

FOR SECTION X-X AND SECTION Y-Y REFER DRG.NO: 230543-CPW-XX-00-DR-N-301006



CPW
6th Floor, Ardenway House
Warrington, Cheshire
LE1 6LR

www.cpw.com

01440 116 255 7397
leicester@cpw.com

STAGE 4

TENDER

Rev: 0.00

Status

Client



Project
ORMROD BUILDING COUNCIL CHAMBER

Drawing Title
GROUND FLOOR
PROPOSED REFLECTED CEILING PLAN
INCLUDING EXISTING SERVICES LAYOUT

Scale (A3)	Date	By	Vo
1:50	OCT 23	JB	JH

230543-CPW-ZZ-00-DR-N-301005 SO 101

CPW Project No. 2305

United Files