


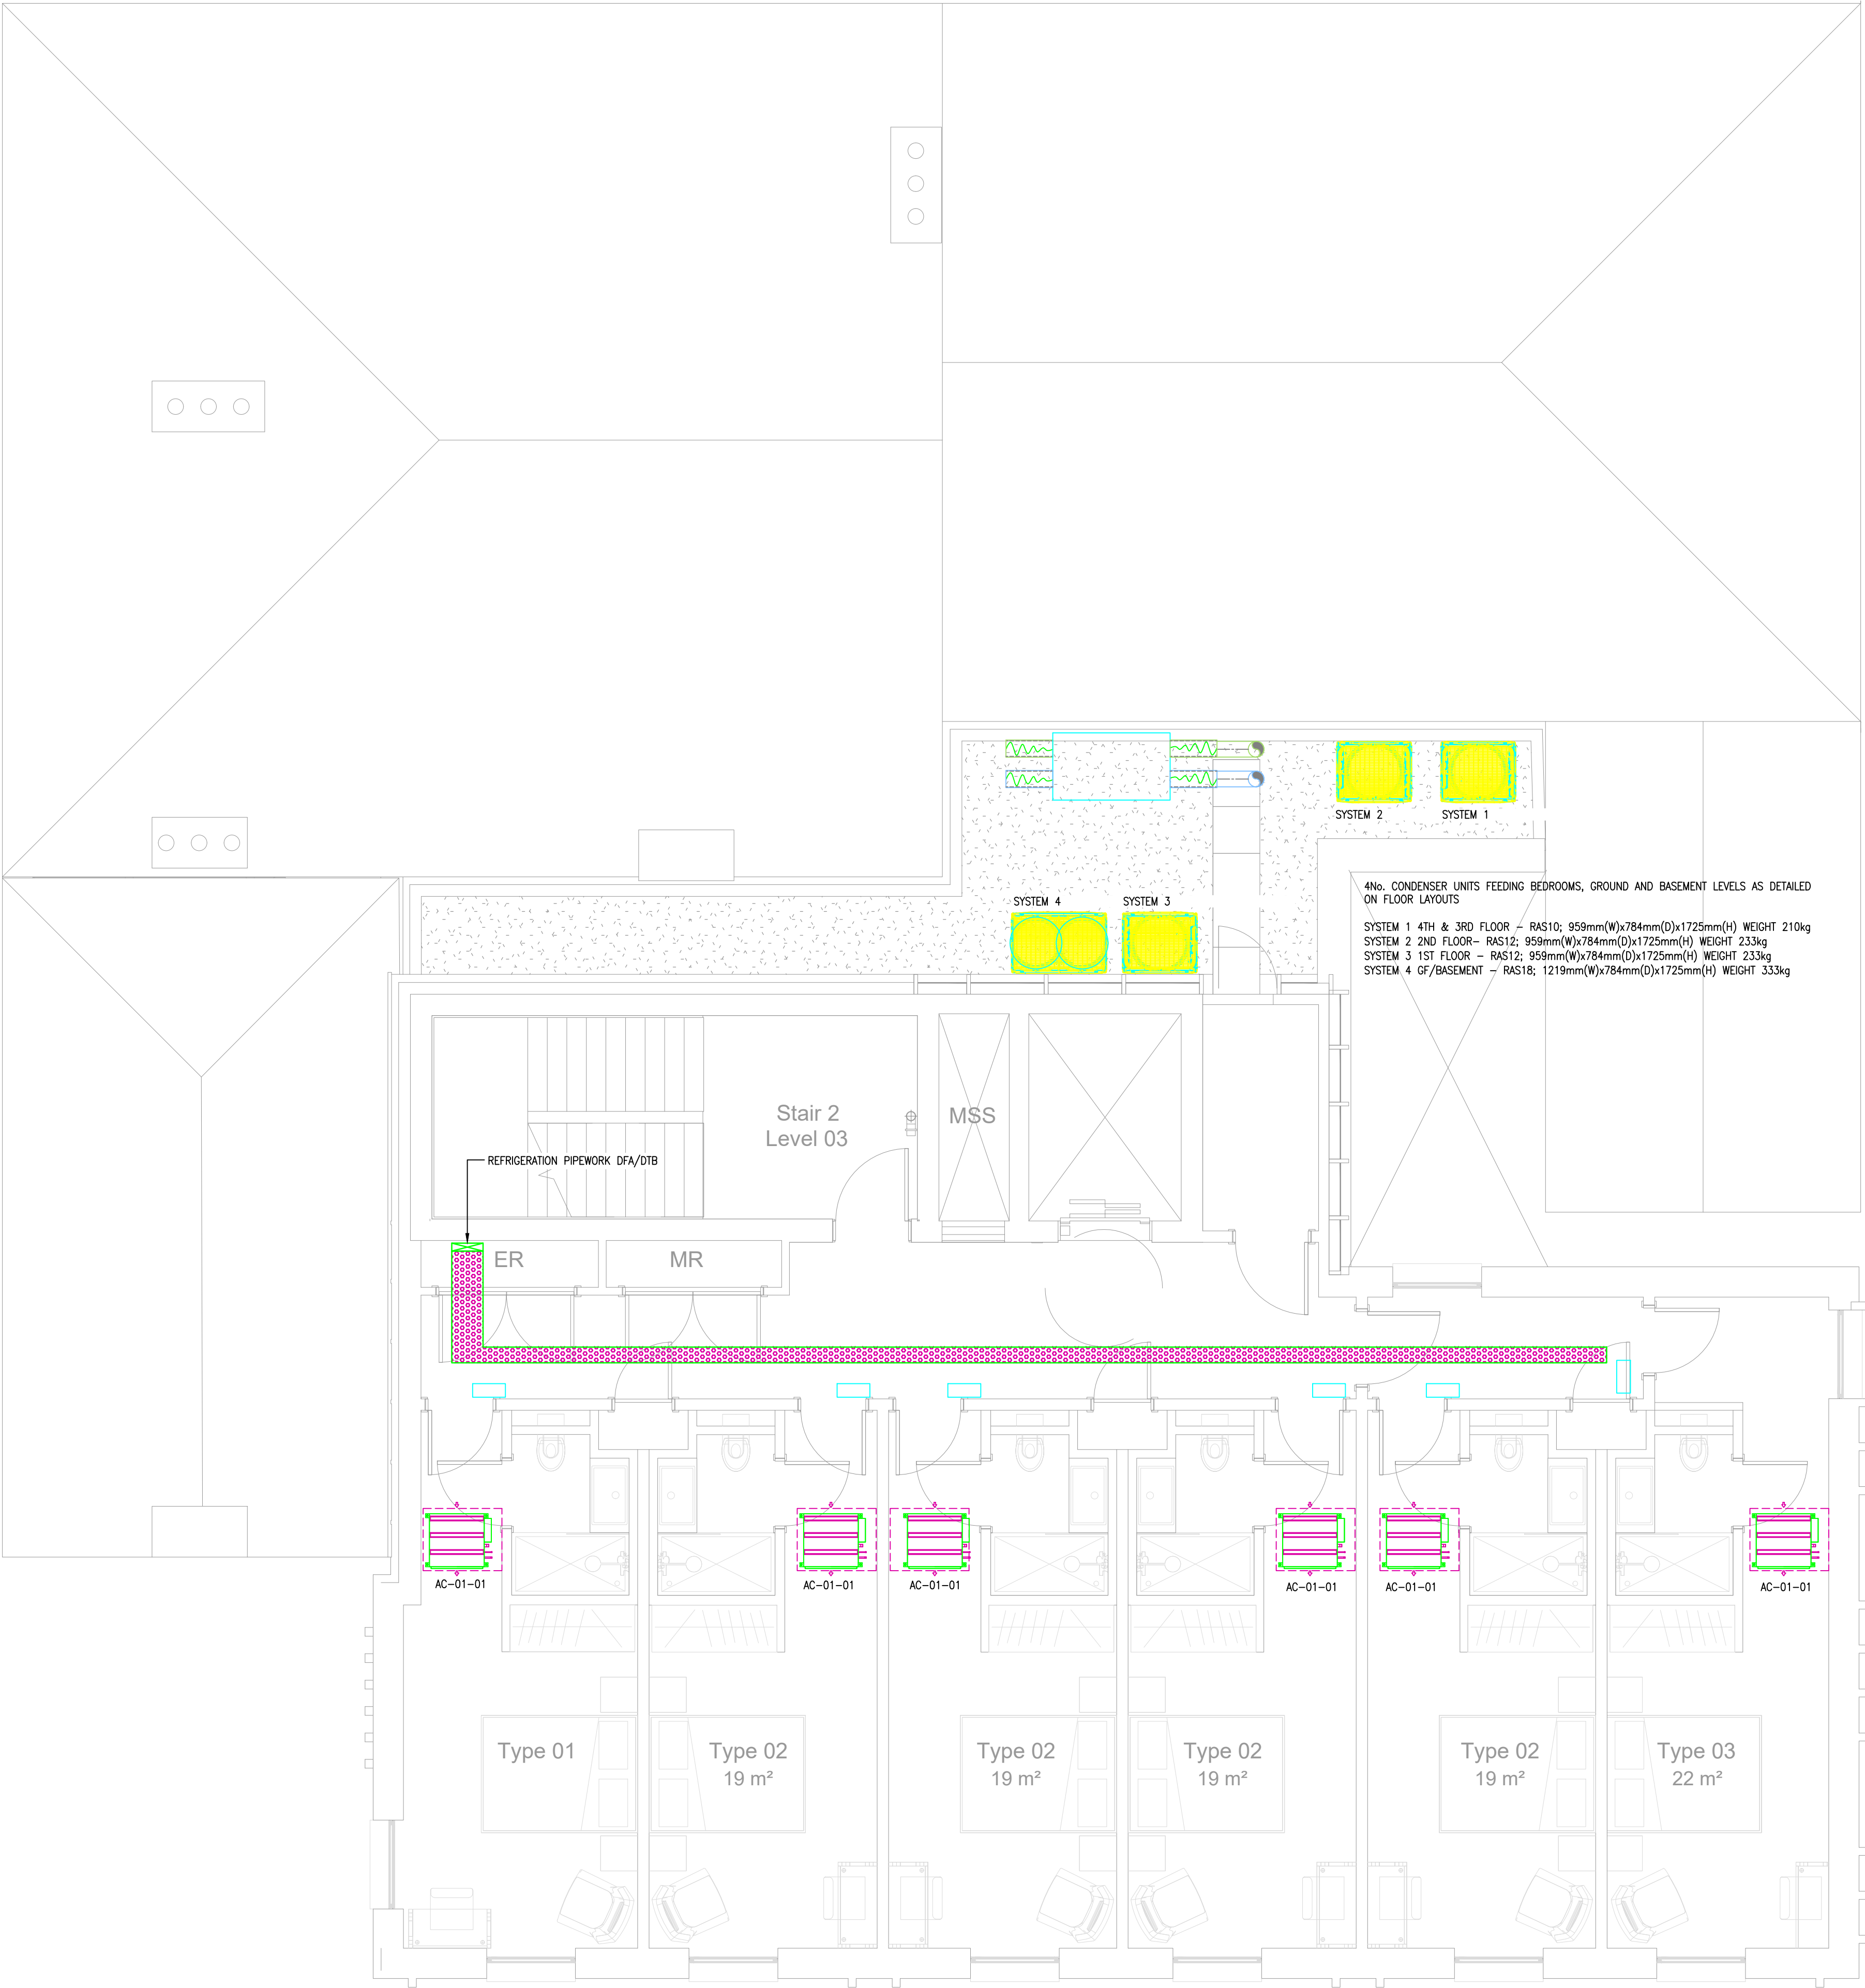

Ⓢ PROTECTED BY UK COPYRIGHT LAW
DO NOT SCALE OFF THIS DRAWING

DESIGNERS RISK ASSESSMENT
Under section 11, 18 - Construction (Design and Management) Regulations 2015

SAFETY, HEALTH & ENVIRONMENTAL INFORMATION
There are no significant, unusual or location specific risks which are not obvious to a competent contractor or likely to be difficult to manage

- NOTES
- ALL PIPEWORK SHALL BE IDENTIFIED WITH THE APPROPRIATE LABELS IN ACCORDANCE WITH BS1710 AND BS4800.
 - AUTOMATIC AIR VENTS SHALL BE PROVIDED AT ALL HIGH POINTS OF THE SYSTEM.
 - DRAIN COCKS SHALL BE PROVIDED AT ALL LOW POINTS OF THE SYSTEM.
 - PIPEWORK SHALL BE INSULATED TO BS5422:2001 TO PLANTROOMS, SERVICE VOIDS AND SEMI-EXPOSED PIPEWORK AT HIGH LEVEL.
 - HEATING PIPEWORK SHALL BE FLUSHED THROUGH ON COMPLETION IN ACCORDANCE WITH BSRIA AG1/2001 AND TREATED WITH CORROSION INHIBITOR.
 - UNDERFLOOR HEATING MANIFOLDS TO BE CONFIRMED BY MANUFACTURER.
 - ALL VALVES TO BE POSITIONED TO ENSURE ACCESS FOR MAINTENANCE WHEN REQUIRED.

HEATING & COOLING SERVICES LEGEND	
SYMBOL	REFERENCE
	REFRIGERATION TRAY
	FLOW SELECTOR BOX
	600x600 4 WAY CASSETTE
	SLIM DUCTED AC UNIT
AC-01-01	RPI 0.8 FSN



-	P02	PRELIMINARY ISSUE	CF	BD	04.05.23
-	P01	PRELIMINARY ISSUE	CF	BD	13.01.23
STA	REV	DESCRIPTION	DES	CHD	DATE

PURPOSE OF ISSUE

PRELIMINARY ISSUE

7 Feast Field, Horsforth, Leeds,
West Yorkshire, LS18 4TJ
t: +44(0)113 2577300 e: novocad@novo.eu.com

CLIENT

PROJECT

LIVERPOOL ROAD
MANCHESTER

TITLE

MECHANICAL SERVICES
THIRD FLOOR
HEATING LAYOUT

SCALE	ORIGINAL SIZE	DATE
1:50	A1	JAN '23
DRAWN	DESIGNED	CHECKED
CF	CF	BD

REVISION

P02