


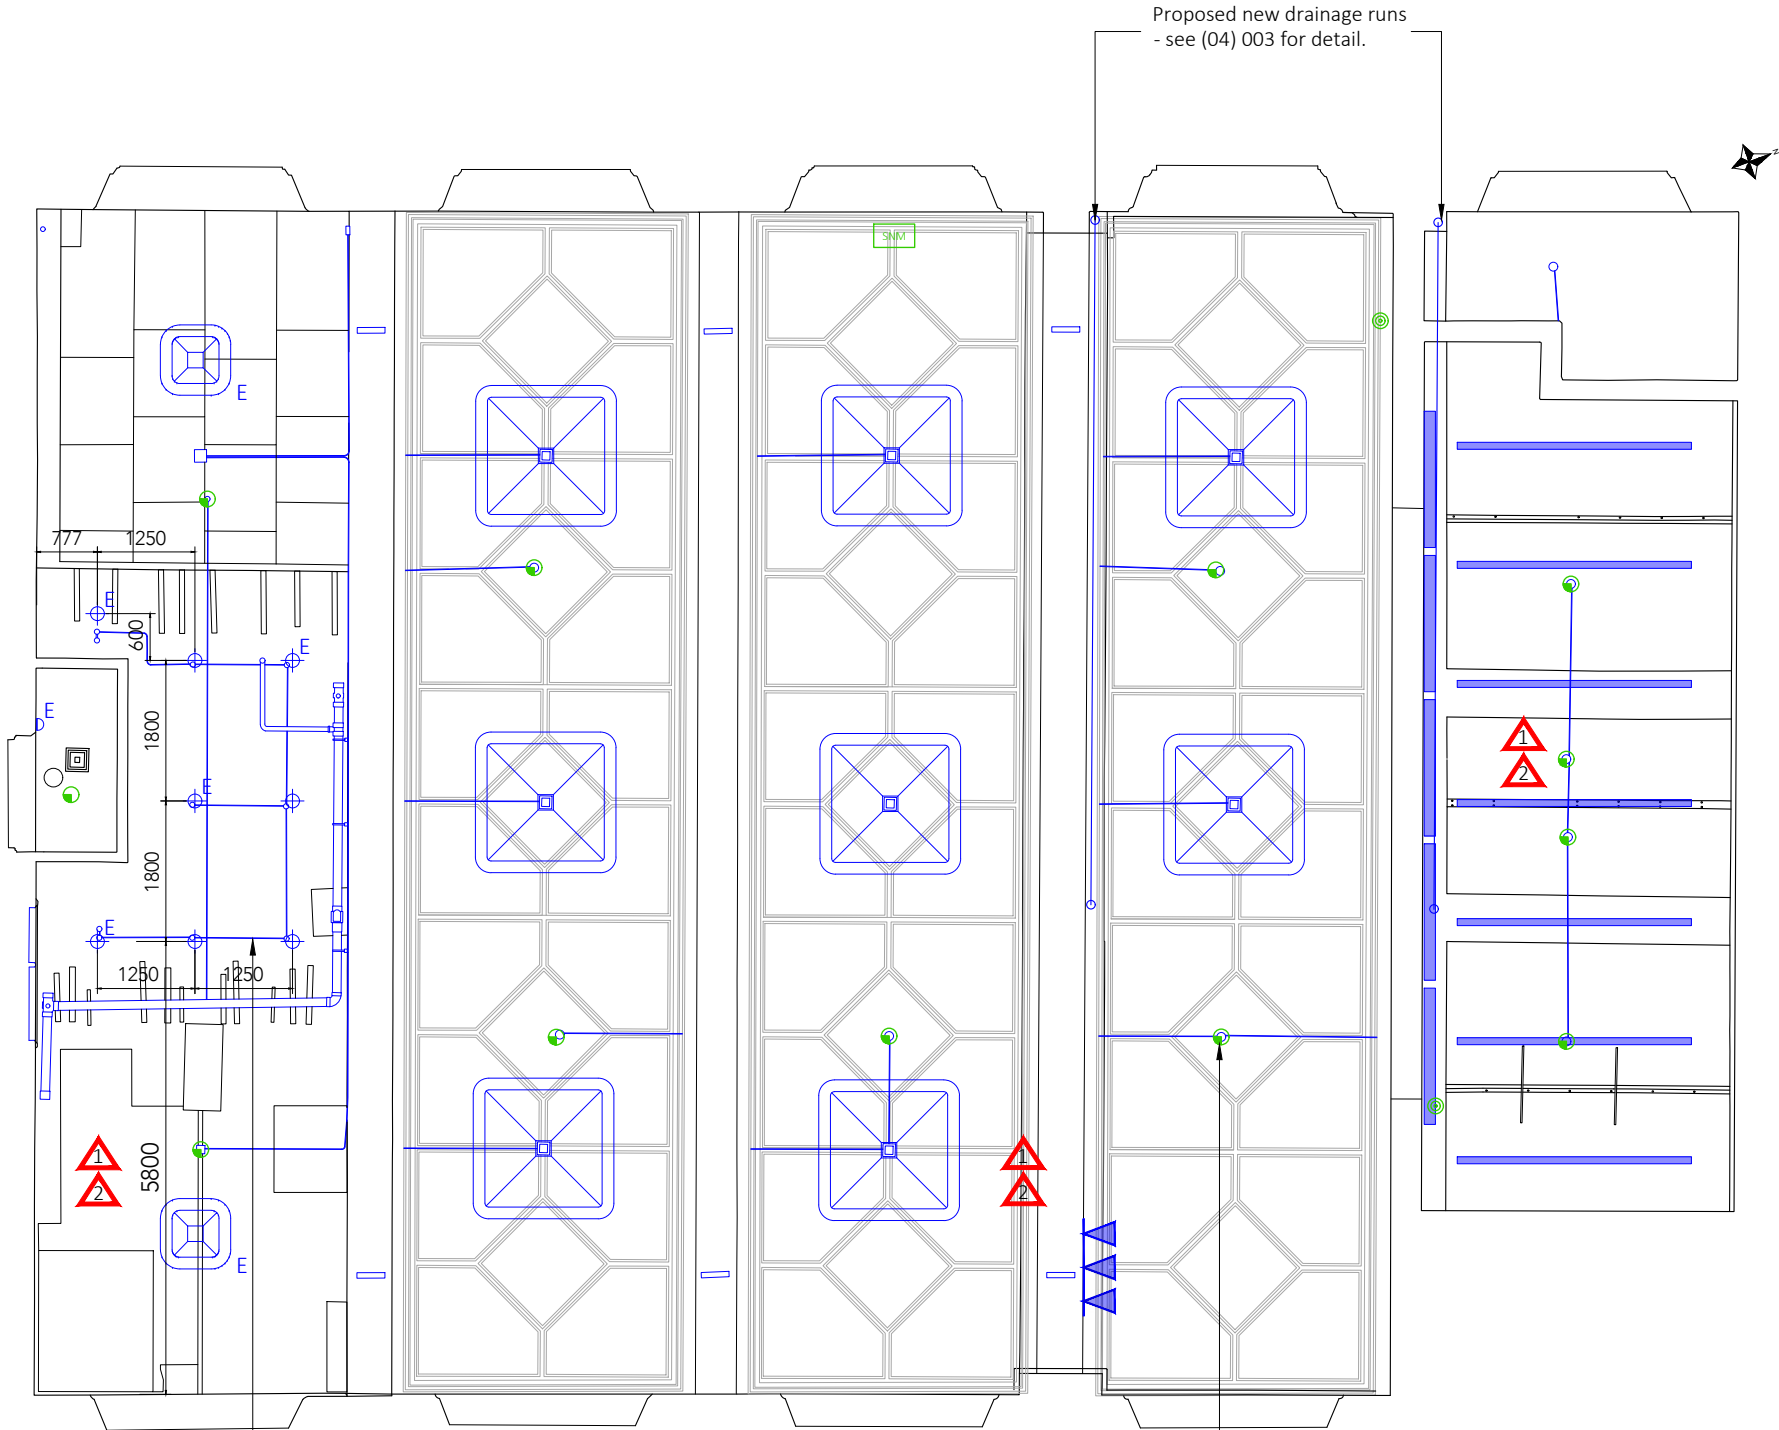


Allow to remove existing damaged wiring and replace with new wiring in former positions to m+e engineer's details. Install new lighting in former positions.

Allow for new fire protection system including new smoke detectors, alarms and call points. See specification for detail. To m+e engineer's detail and specification in liaison with a fire consultant.

Proposed Reflected Ceiling Plan - Proposed Lighting Layout

Proposed lighting units shown in former positions. In the panelled ceilings existing and former fixings to re-used requiring no additional fixings into the ceiling.

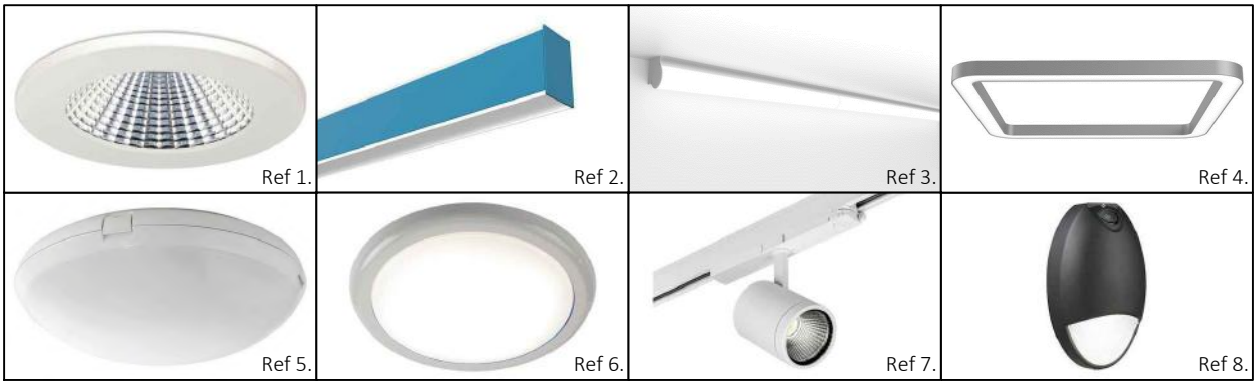

CDM Notes:

- 1 Asbestos - Asbestos fabric known to be above stage area - ensure all fabric removed in controlled conditions by specialist prior to work. Contractor to consult asbestos register and all existing services information prior to planning works on ceilings.
- 2 Working at height - Contractor to consider if some tasks can be conducted at low level. Contractor to ensure safe scaffolding is provided by a specialist and regularly checked and maintained. All contractors to be provided with correct PPE for high level work.

Key - Fire Symbols:

- Call Point
- Heat detector
- SNM Sound notification module

Positions shown indicatively based on existing information. Confirm positions on site.

Note:
Do not scale from this drawing.
Dimensions are to be checked on site.
If in doubt please ask.

KEY - As per received information.	
	Ref 1.
	Ref 2.
	Ref 3.
	Ref 4.
	Ref 5.
	Ref 6.
	Ref 7.
	Ref 8.

All work subject to M+E engineer's detail and specification.

Rev --/-- --

Rev Date/Intls Details

© The moral rights of the author are hereby asserted.
This drawing and design is the sole property of Buttress Ltd and must not be reproduced without permission.
Buttress Ltd is Registered in England and Wales: 5363573

Buttress

41 Bengal St
Manchester
M4 6AF

T 0161 236 3303
E contact@buttress.net
W www.buttress.net

Project Title CSM - Whiteley Hall
Client Chetham's School of Music
Location Manchester

Drawing Title Whiteley Hall Lower Level
High Level Lighting - Reflected Ceiling Plan

Date 18/08/22 Scale 1:100
Checked EK Orig Paper Size A3

Status **PLANNING**

Project: Origin: Zone: Level: Type: Disc: Number: Rev:

9357-BA - B1 - XX - DR - A -(63)002 -