

NOTES:
All dimensions must be checked on site and not scaled from this drawing.

Ref.	Date	Revisions	By
P01	22.04.22	PRELIMINARY ISSUE	B.W.

NOTES:

- ALL DIMENSIONS IN MILLIMETRES UNLESS OTHERWISE STATED.
- THIS DRAWING IS TO BE READ IN CONJUNCTION WITH THE DISTRIBUTION BOARD SCHEDULES AND LIGHTING TECHNICAL SUBMITTALS.
- UPPER FLOOR CIRCULATION LIGHTING TO BE WIRED ON SPLIT CIRCUITS. 50% OF LUMINAIRES TO BE PERMANENTLY ON AND WIRED THROUGH KEY SWITCH WITHIN RISER. 50% TO BE SWITCHED VIA PIR. REFER TO TYPICAL WIRING DETAIL.
- EMERGENCY LIGHTING KEYSWITCH TO BE PROVIDED ADJACENT LOCAL DB FOR TESTING.
- PRINCIPLE CONTRACTOR TO ENSURE ALL EMERGENCY EXIT SIGNAGE POSITIONS/ DIRECTION ARROWS ARE AGREED WITH BUILDING CONTROL PRIOR TO CONSTRUCTION.

LIGHTING LEGEND


- L1 ○ SPECULAR DOWNLIGHTER - SPEC/7W/580/120D/3K
- L2 ○ ANTILLES - ANT/CAN/1775/OPAL/3
- D ○ LDB CIRCULAR BULKHEAD - LDB/2690/4/C
- C1 ○ HENRY DOWNLIGHTER - HEN/1500/4
- H1 □ LOUIS LED PANEL - LOU/66/3000/4/TPA
- J1 — LDB CIRCULAR BULKHEAD - LDB/1900/4/C
- RE ⊙ RAVELLO DOWNLIGHTER - RAV/2460/4
- K1 — WPZ LINEAR - WPZ/5/4510/4
- L3 — RECESSED LED TAPE
- X1 ⊙ DIANNE - IP67 IN GROUND UPLIGHT
- EM ⊙ EMERGENCY BULKHEAD
- EC ⊙ EMERGENCY DOWNLIGHT FOR CORRIDOR - EMD/NM/CO
- EO ○ EMERGENCY DOWNLIGHT FOR OPEN AREA - EMSD/NM/OA
- E' ⊙ DENOTES EMERGENCY FITTING

EMERGENCY SIGNAGE LIGHTING LEGEND:


- E1 — LED EXIT SIGN WALL MOUNTED ARROW UP
- E2 — LED EXIT SIGN CEILING MOUNTED ARROW UP
- E3 — LED EXIT SIGN CEILING MOUNTED ARROW DOWN
- E4 — LED EXIT SIGN CEILING MOUNTED DOUBLE SIDED
- E5 — LED EXIT SIGN CEILING MOUNTED ARROW RIGHT
- E6 — LED EXIT SIGN CEILING MOUNTED ARROW LEFT
- E7 — LED EXIT SIGN CEILING MOUNTED ARROW LEFT (DIAGONAL DOWN)

LIGHTING CONTROL LEGEND:

- P1 ⊕ FLUSH 360 INFRARED PRESENCE DETECTOR
- P2 ⊕ SURFACE 360 INFRARED PRESENCE DETECTOR
- MW1 ⊕ FLUSH LONG RANGE MICROWAVE SENSOR
- MW2 ⊕ SURFACE LONG RANGE MICROWAVE SENSOR
- X' ⊕ RETRACTIVE SWITCH - 'X' DENOTES NO OF GANGS
- ⊕ TWO-WAY RETRACTIVE SWITCH
- ⊕ INTERMEDIATE RETRACTIVE SWITCH
- ⊕ EMERGENCY KEY SWITCH
- — — CIRCUIT LINE
- ➔ SWITCH LEADER

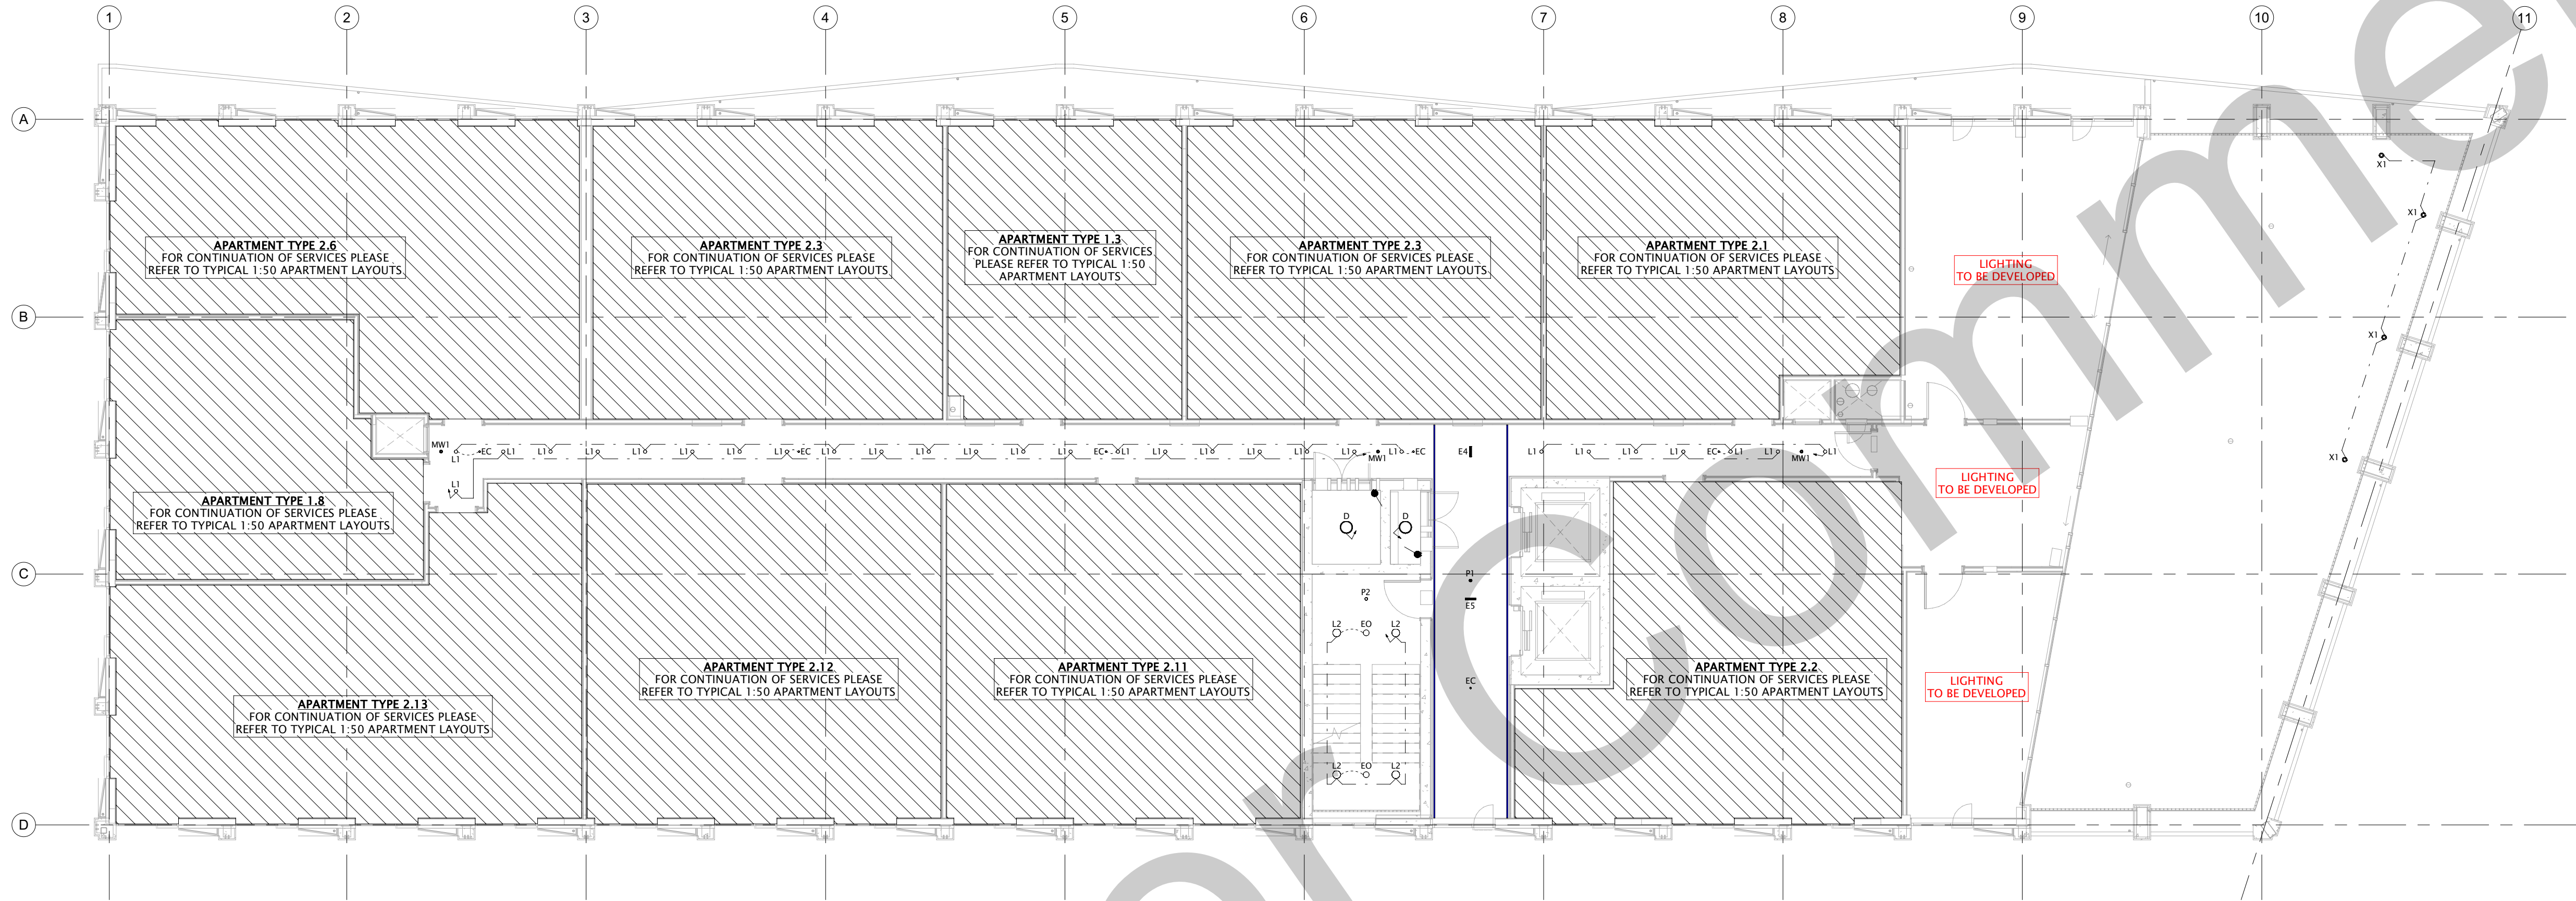


Level 11 - Lighting Layout
1 : 100

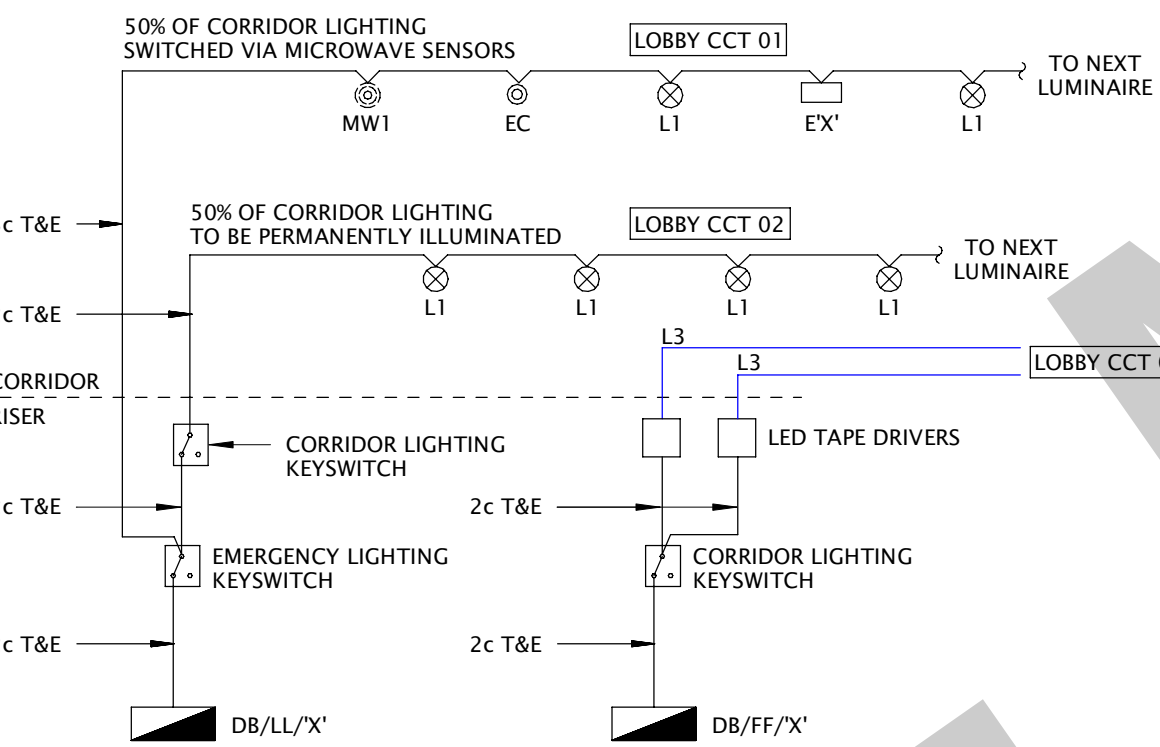

Lighting Control Detail
N.T.S.

COMMENTS SAME AS GROUND FLOOR. SEE MARK UP ON DRAWING D480-AME-ZZ-00-DR-E-63 01

- LED LIGHT REDUCES TO LIFT LOBBY ONLY.
- LIGHTS TO BE EVENLY DISTRIBUTED FROM CENTRE LINE OF LIBY LOBBY
- LIGHT LEVEL TO BE MADE MINIMUM THAT STILL COMPLY WITH LIGHTING REQUIREMENTS TO CREATE LOW LIT AESTHETIC

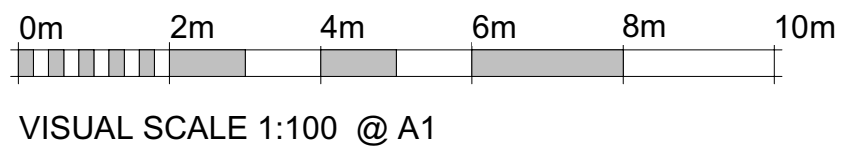

VISUAL SCALE 1:100 @ A1

Client	Job Title	Drawing Title	Date	Drawn by	Check by
GMI Construction Group PLC	New Cross, Bendix Street	Level 11 - Lighting Layout	April 22	B.W.	B.C.
			Scale @ A1 As Indicated	Status PRELIMINARY	Revision
			Drawing Number D480-AME-ZZ-11-DR-E-6305		P01

ameon
Building Services Engineering
Unit 9-10 Olympic Court, Boardmans Way,
Whitehills Business Park, Blackpool, FY4 5GU
Tel: 01253 760160
E-mail: info@ameon.co.uk