



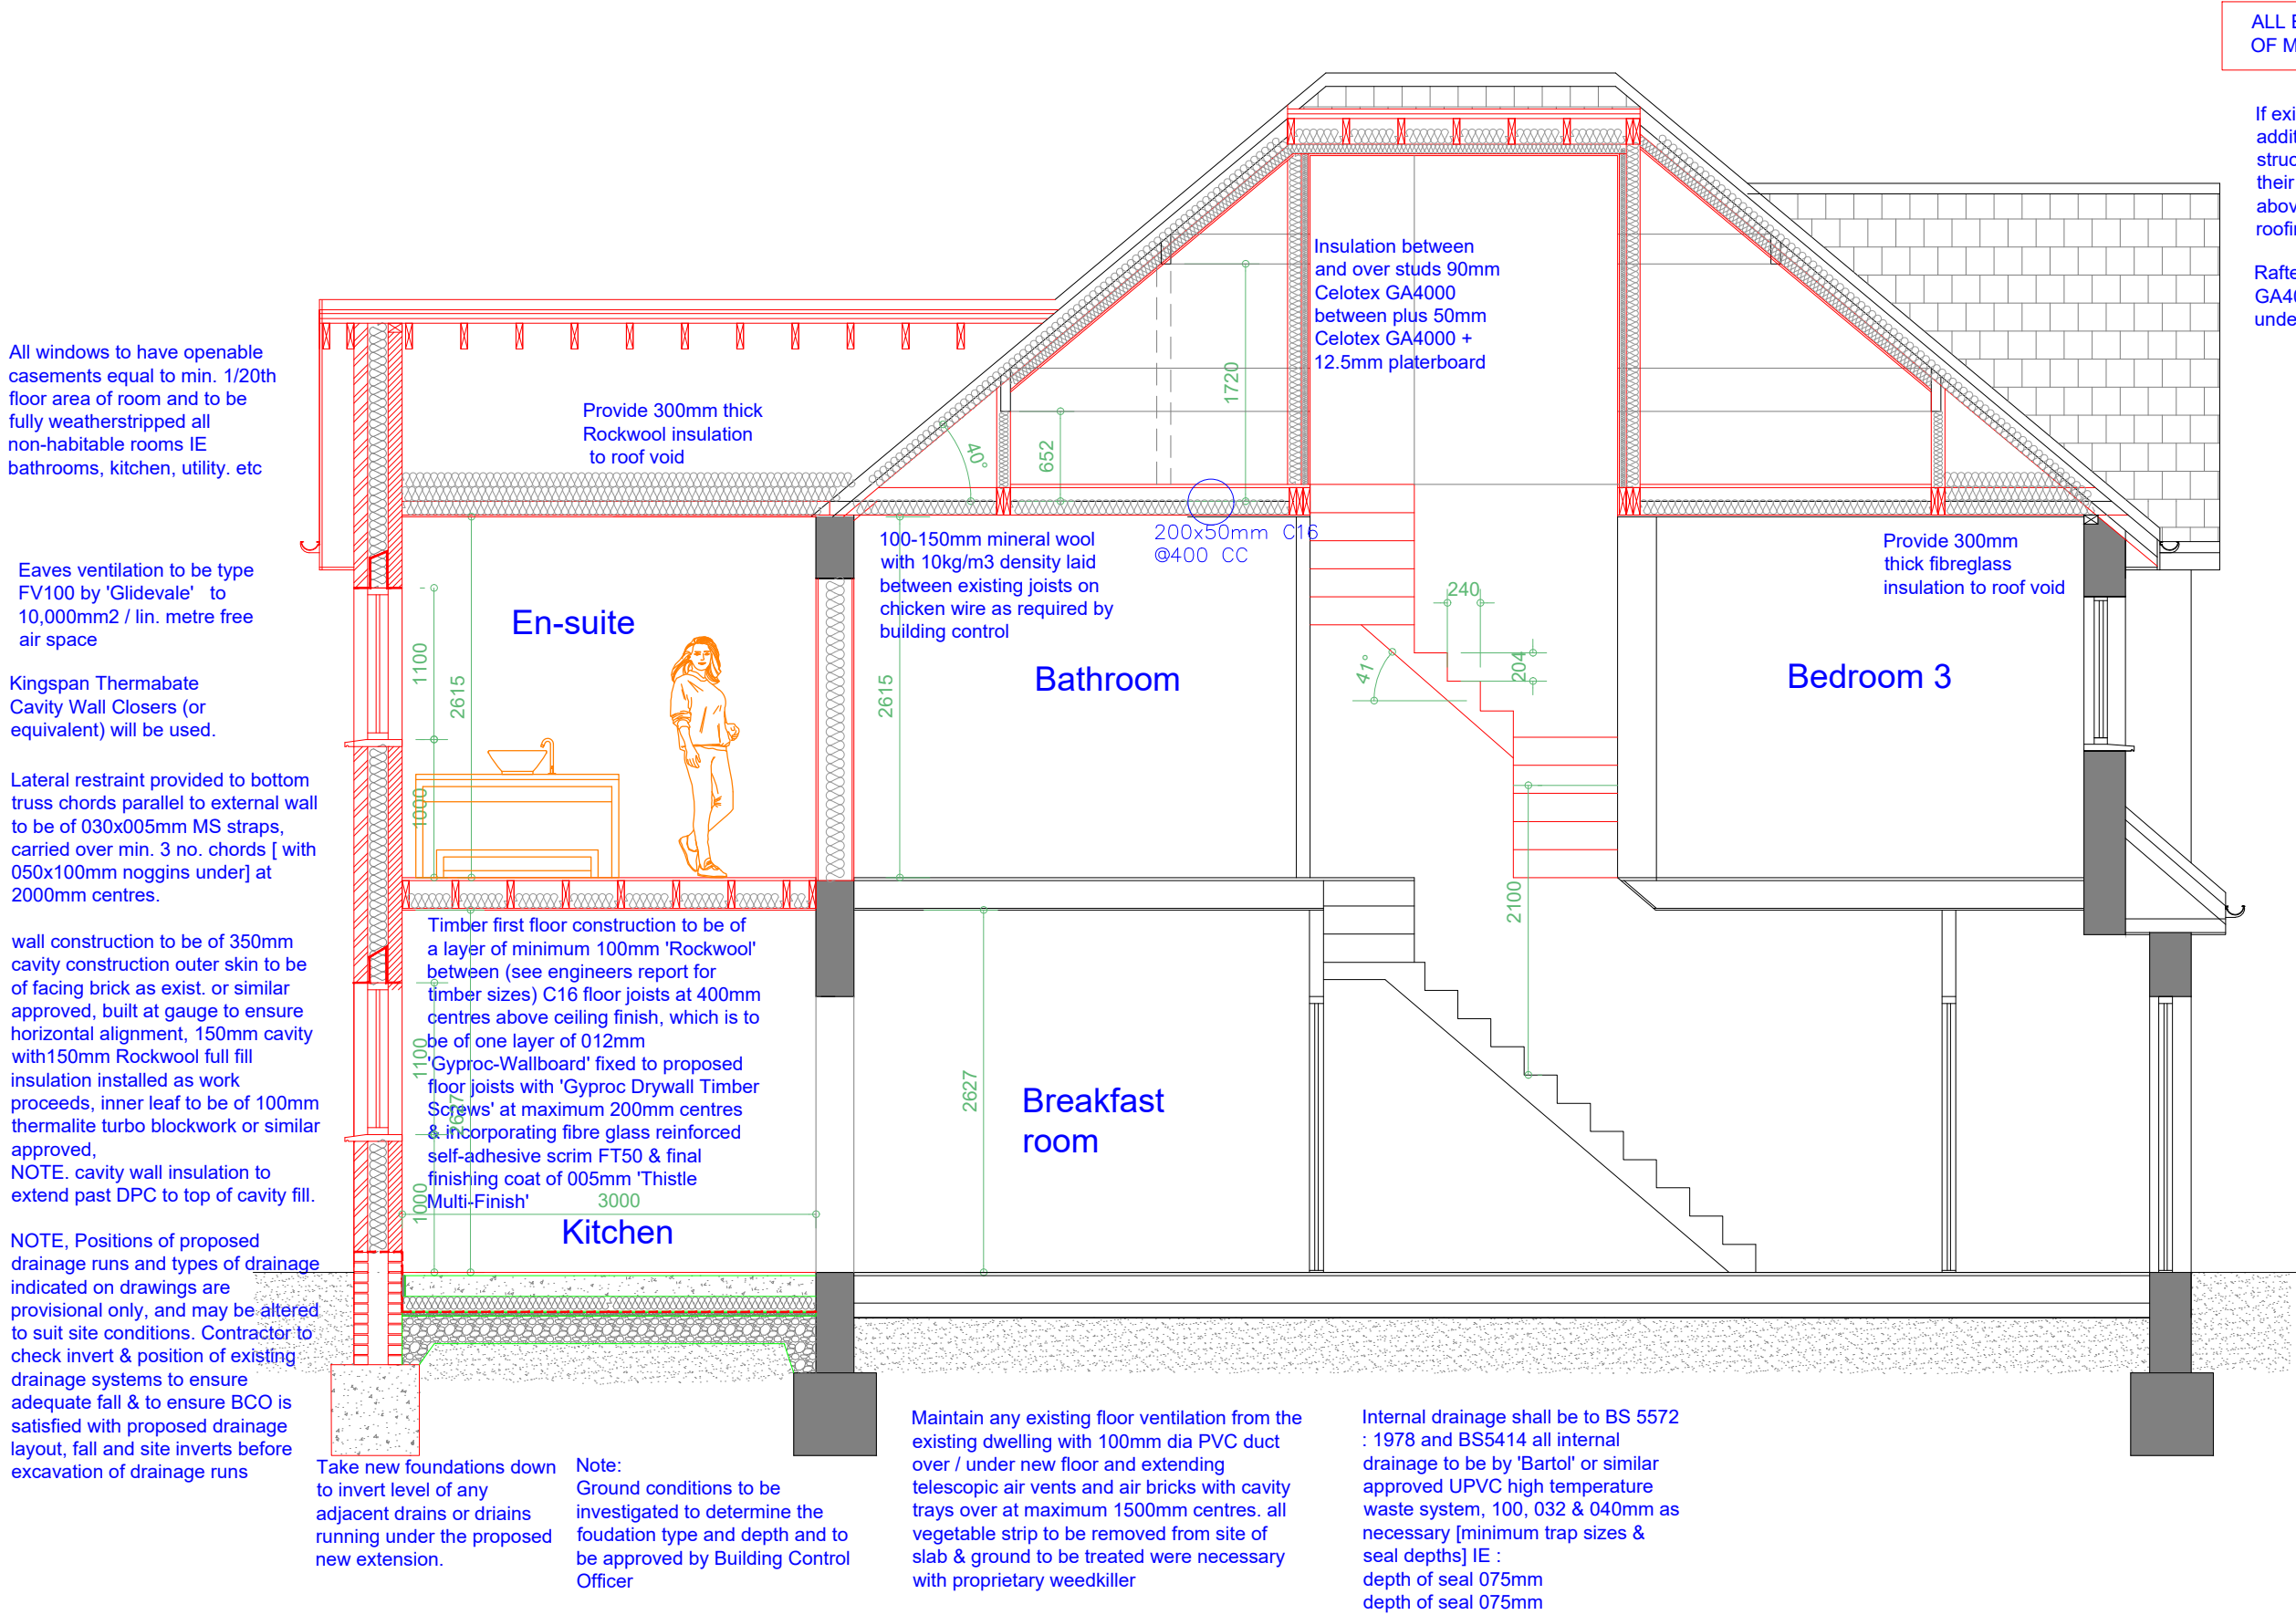

Proposed Section A-A
Scale 1:50

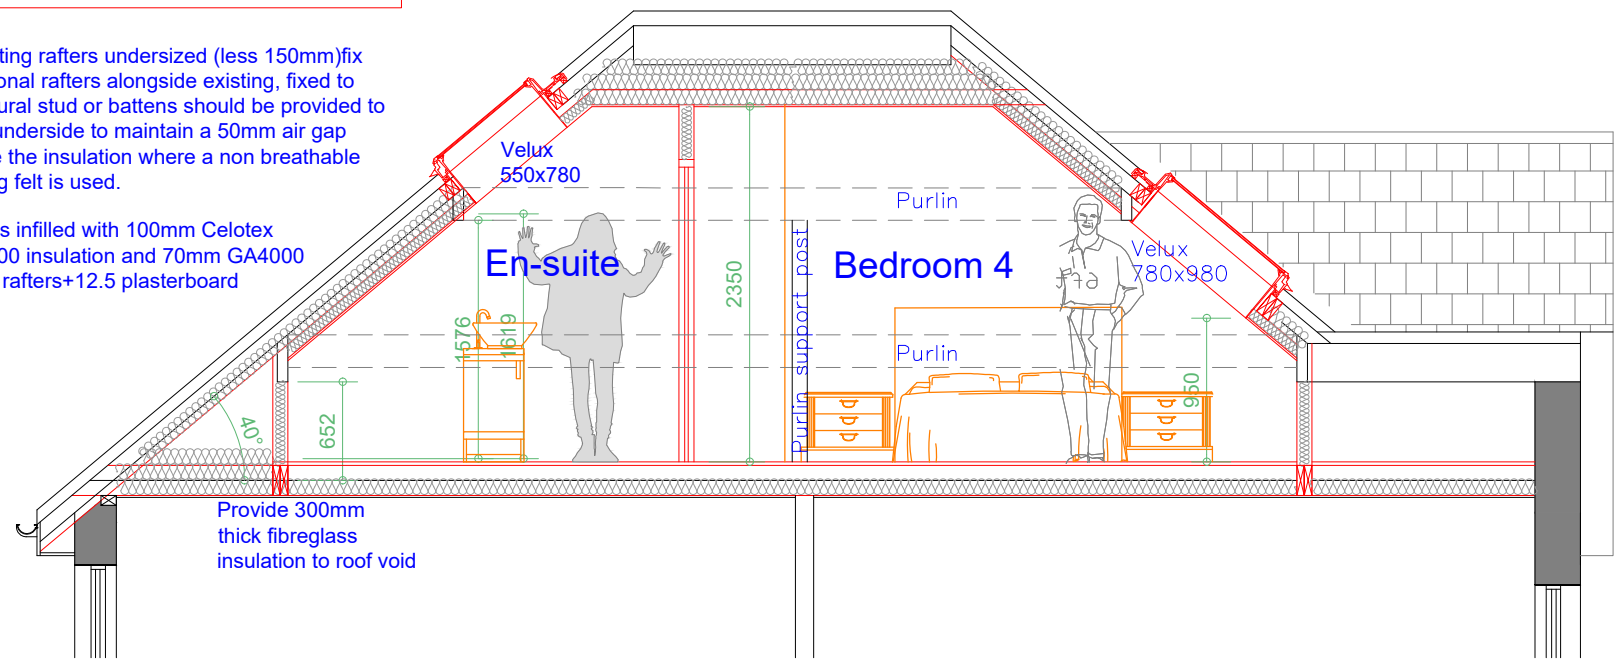

GAS service into existing buildings., care must be taken when any excavation is taking place near these positions. Confirm position of gas supply pipe with Transco 01204 - 546900, before commencing on site, position of service pipe to be marked on site, and also on copy of plans, once position of pipe has been established. IN AN EMERGENCY CALL 0800 111999 IMMEDIATELY

NOTE, Positions of proposed drainage runs and types of drainage indicated on drawings are provisional only, and may be altered to suit site conditions. Contractor to check invert & position of existing drainage systems to ensure adequate fall & to ensure BCO is satisfied with proposed drainage layout, fall and site inverts before excavation of drainage runs

ELECTRICITY service into existing buildings., care must be taken when any excavation is taking place near these positions. Confirm position of electricity cables with UK Power Networks (plans@ukpowernetworks.co.uk) before commencing on site, position of service cable to be marked on site, and also on copy of plans.

WATER supply to be located & isolated prior to removal of any pipework, water supply pipe to be adequately protected froaccidental / wilful damage at all times, contact United Utilities 0845 746 2200

Proposed Section B-B
Scale 1:50

Rev	Date	Description
Issued For : INFORMATION PURPOSES ONLY		

Client
Mr. Eugen Lindner

Project
33 Burnage Lane, Manchester M19 2HZ
Proposed two storey rear extension and loft conversion with side dormer.

Scheme - Drawing Title
Proposed Sections A-A and B-B.

05	Date	06.10.23
Drawing No.	Revision	Scale 1:50 @A2

