

Information Note

Any drawing format is to be read in conjunction with and at the scale of accompanying documents.

Where colours other than black or grey are used the drawing must be plotted in colour.

All dimensions are to be checked on site by the Contractor, scaling is for Local Authority purposes only.

Unless otherwise indicated, all dimensions are in millimeters.

All information on this drawing is to be read in conjunction with the relevant Donald Insall Associates (Insall) specification and trade contractors' drawings and information by specialists.


In the event of any discrepancy, please contact Insall immediately.

This drawing may contain survey information by others and is to be used solely for the purposes for which it was issued.


These are uncontrolled documents issued for information purposes only. If you have any queries regarding the drawings, contact Insall immediately.

Insall cannot be held responsible for any errors arising from changes made to an uncontrolled file.

Drawings by Donald Insall Associates to be read in conjunction with full 'Next Chapter' drawing sets. Including those by Structural Engineer, MEP Engineer, Exhibition Designer, Fire Consultant and Acoustic Consultant.

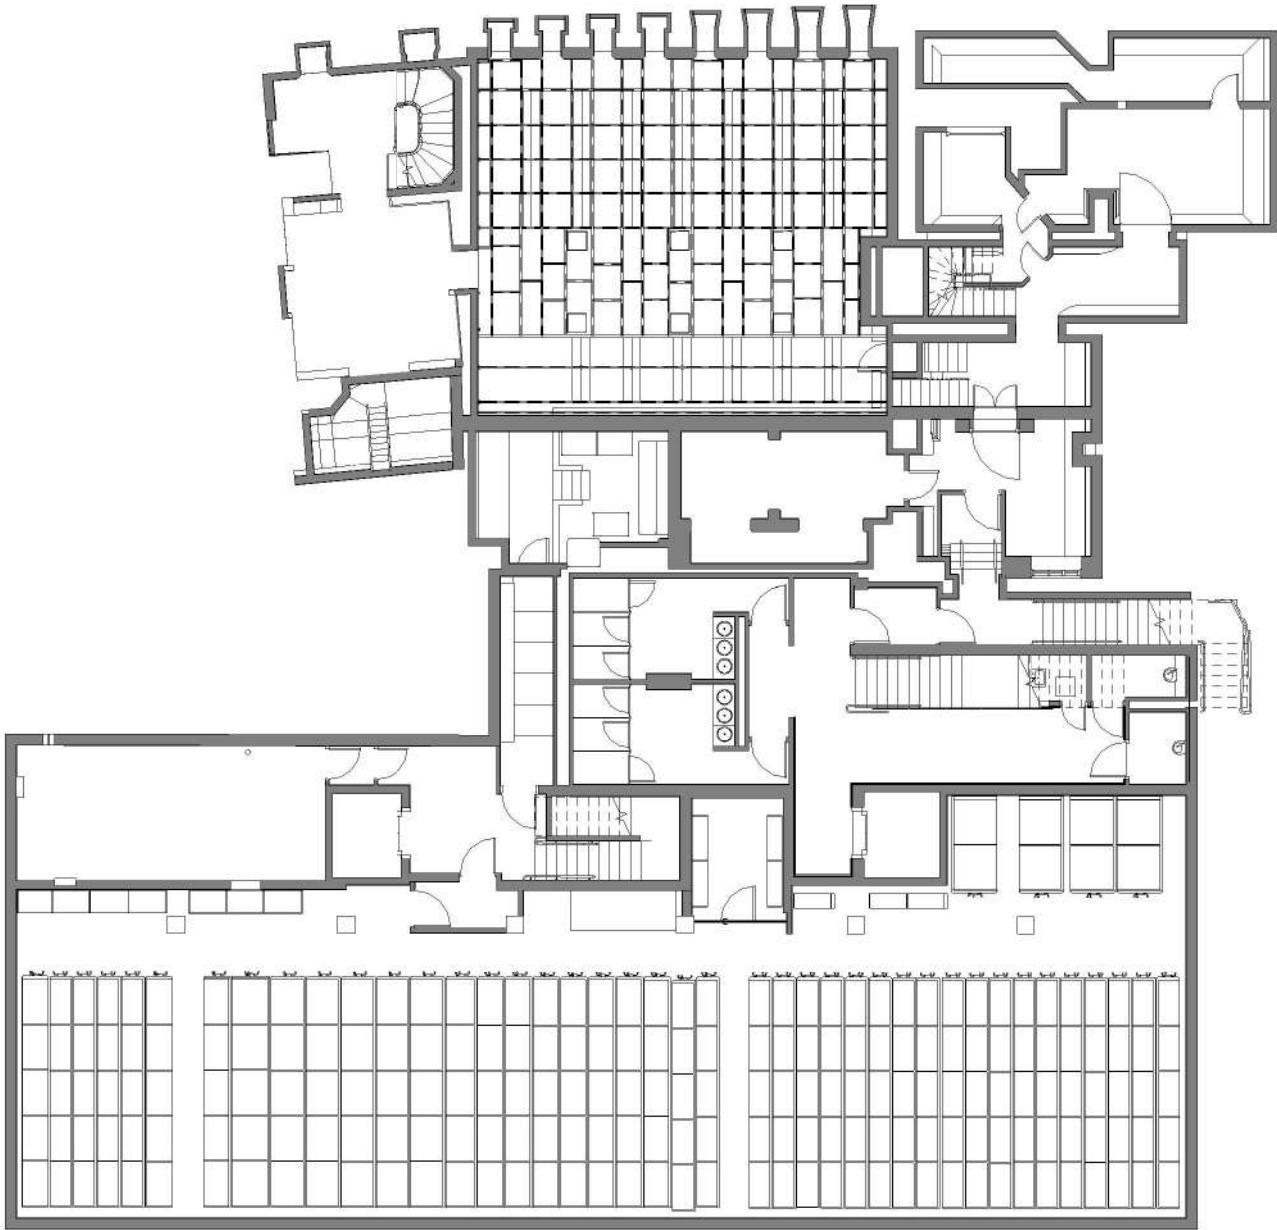


Basement Plan - Stripping Out
Scale 1 : 100

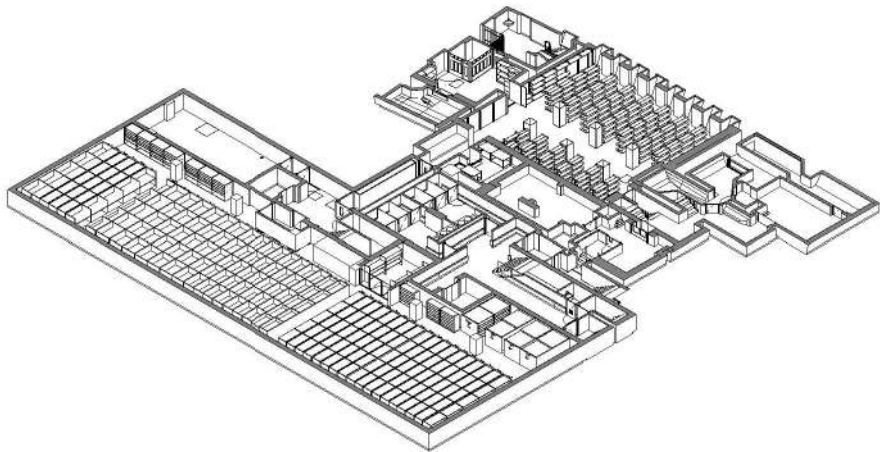


Axonometric - Basement Plan - Stripping Out

P1	27.06.23	JXW	RXC	Planning Permission and LBC Application		
Rev.	Date	Dim.	Auth.	Description		
Purpose of Issue						
Planning Permission and LBC Application						
Project Information						
The John Rylands						
Research Institute and Library						
Manchester, 'Next Chapter' Project						
Drawing Title						
Basement Plan - Stripping Out - General Arrangement						
Drawing Number						
Project ID	Originator	Functional Breakdown	Spatial Breakdown	Form	Discipline	Number
JRL	- DIA	- ZZ	- 00A	- D60-	ACL	- 2150
Project Number		Scale at A1		Status	Revision	
MAN_JRL_03		As indicated		S3	P1	
Donald Insall Associates						
Chartered Architects and Historic Building Consultants						
Ducie House, 37 Ducie Street, Manchester M1 2JW						
(+44) 0161 359 4326						
Manchester@insall-architects.co.uk						
© 2023 DONALD INSALL ASSOCIATES LTD						



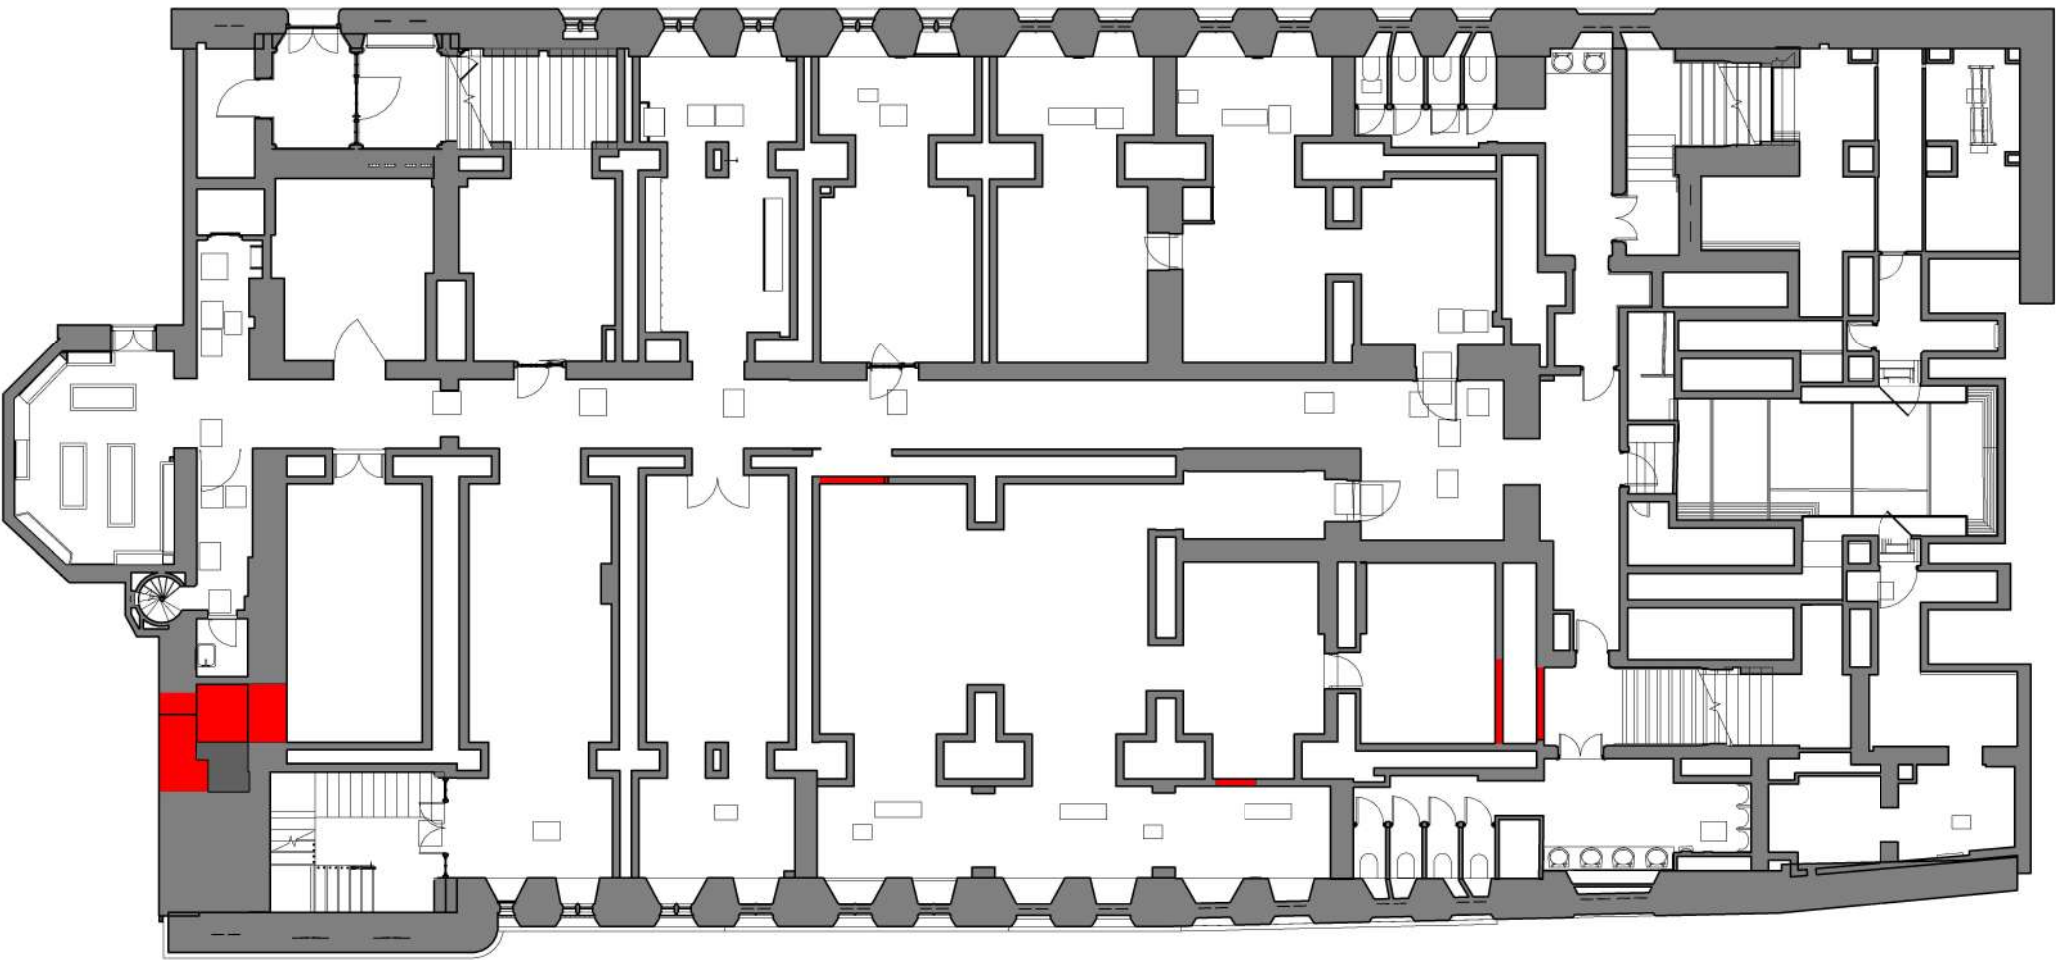

Cellar Floor Plan - Stripping Out
Scale 1 : 100

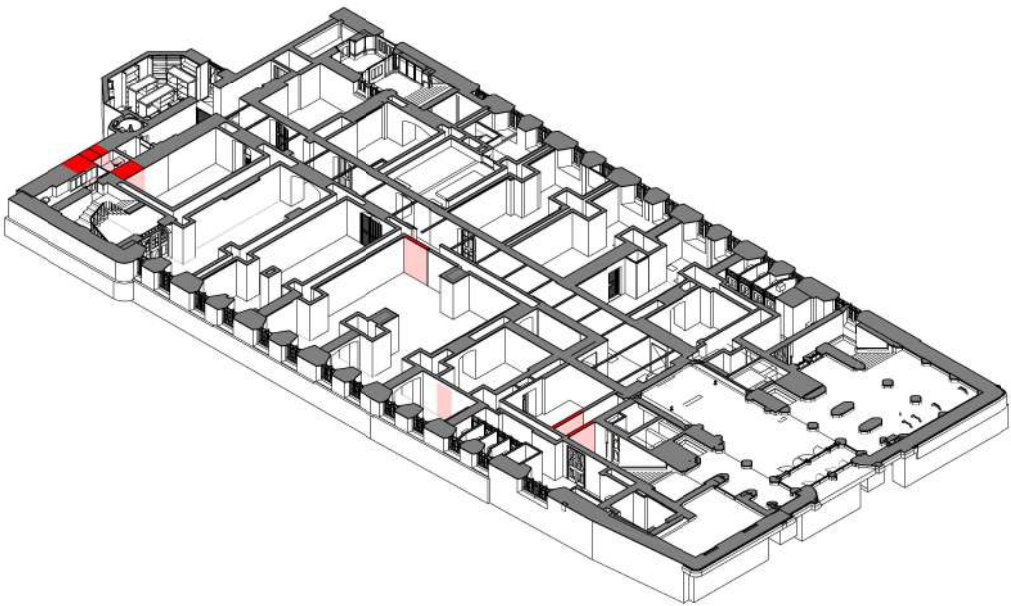

Axonometric - Cellar Plan - Stripping Out
Scale

Information Note

Any drawing format is to be read in conjunction with and at the scale of accompanying documents.

Where colours other than black or grey are used the drawing must be plotted in colour.

All dimensions are to be checked on site by the Contractor, scaling is for Local Authority purposes only.

Unless otherwise indicated, all dimensions are in millimeters.

All information on this drawing is to be read in conjunction with the relevant Donald Insall Associates (Insall) specification and trade contractors' drawings and information by specialists.

In the event of any discrepancy, please contact Insall immediately.

This drawing may contain survey information by others and is to be used solely for the purposes for which it was issued.

These are uncontrolled documents issued for information purposes only. If you have any queries regarding the drawings, contact Insall immediately.

Insall cannot be held responsible for any errors arising from changes made to an uncontrolled file.

Drawings by Donald Insall Associates to be read in conjunction with full 'Next Chapter' drawing sets, including those by Structural Engineer, MEP Engineer, Exhibition Designer, Fire Consultant and Acoustic Consultant.

P1	27.06.23	JXW	RXC	Planning Permission and LBC Application		
Rev.	Date	Dim.	Auth.	Description		
Purpose of Issue						
Planning Permission and LBC Application						
Project Information						
The John Rylands						
Research Institute and Library						
Manchester, 'Next Chapter' Project						
Drawing Title						
Cellar Floor Plan - Stripping Out - General Arrangement						
Drawing Number						
Project ID	Originator	Functional Breakdown	Spatial Breakdown	Form	Discipline	Number
JRL	- DIA	- ZZ	- 01B	- D60-	ACL	- 2100
Project Number		Scale at A1		Status	Revision	
MAN.JRL.03		As indicated		S3	P1	


Donald Insall Associates

Chartered Architects and Historic Building Consultants


Ducie House, 37 Ducie Street, Manchester M1 2JW
(+44) 0161 359 4326
Manchester@insall-architects.co.uk

© 2023 DONALD INSALL ASSOCIATES LTD



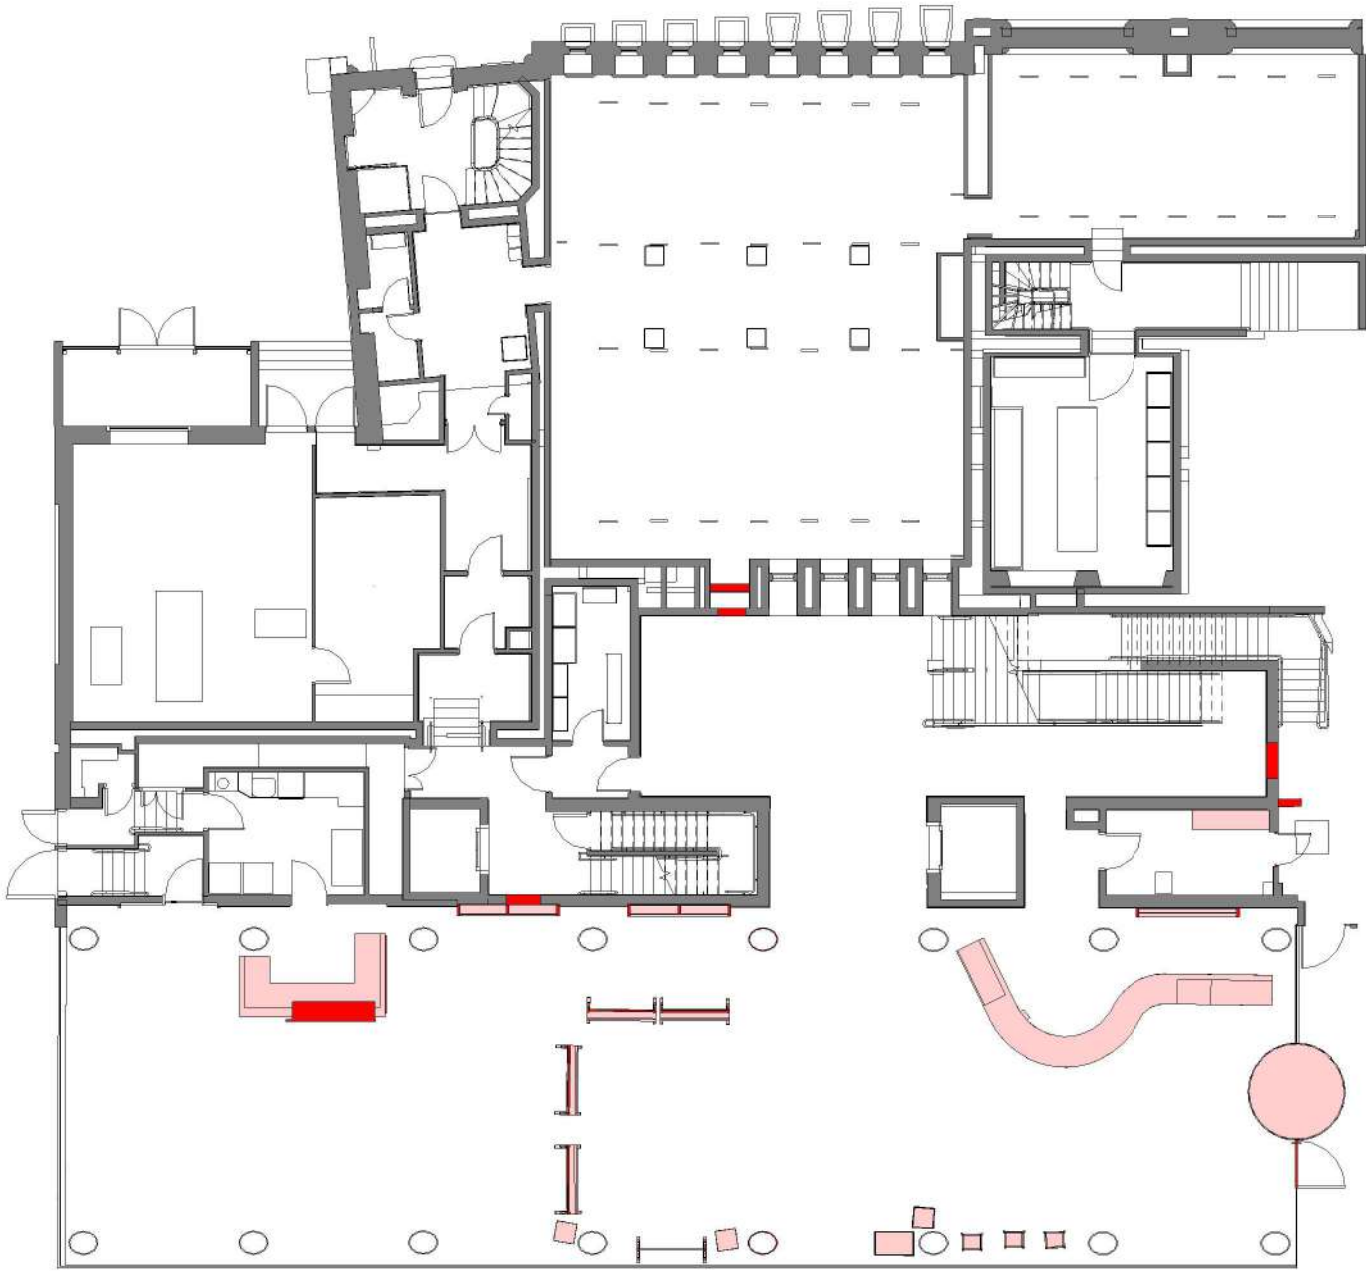

Ground Floor Plan - Stripping Out
Scale 1 : 100

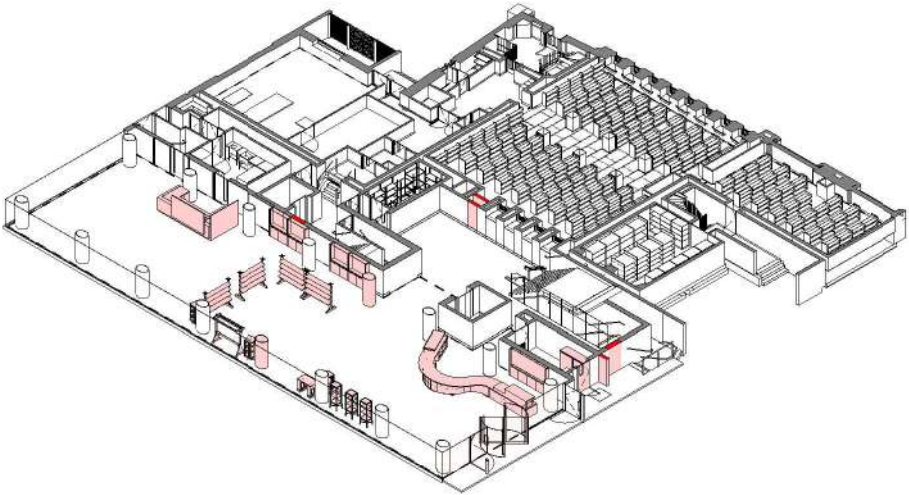

Axonometric - Ground Floor Plan - Stripping Out

Information Note

Any drawing format is to be read in conjunction with and at the scale of accompanying documents.

Where colours other than black or grey are used the drawing must be plotted in colour.

All dimensions are to be checked on site by the Contractor, scaling is for Local Authority purposes only.

Unless otherwise indicated, all dimensions are in millimeters.

All information on this drawing is to be read in conjunction with the relevant Donald Insall Associates (Insall) specification and trade contractors' drawings and information by specialists.

In the event of any discrepancy, please contact Insall immediately.


This drawing may contain survey information by others and is to be used solely for the purposes for which it was issued.

These are uncontrolled documents issued for information purposes only. If you have any queries regarding the drawings, contact Insall immediately.


Insall cannot be held responsible for any errors arising from changes made to an uncontrolled file.

Drawings by Donald Insall Associates to be read in conjunction with full 'Next Chapter' drawing sets. Including those by Structural Engineer, MEP Engineer, Exhibition Designer, Fire Consultant and Acoustic Consultant.

27.06.23	JXW	RXC	Planning Permission and LBC Application		
Rev.	Date	Dim.	Auth.	Description	
Purpose of Issue					
Planning Permission and LBC Application					
Project Information					
The John Rylands					
Research Institute and Library					
Manchester, 'Next Chapter' Project					
Drawing Title					
Ground Floor Plan - Stripping Out - General Arrangement					
Drawing Number					
Project ID	Originator	Functional Breakdown	Spatial Breakdown	Form	Discipline Number
JRL	- DIA	- ZZ	- 10A	- D60-	ACL - 2151
Project Number		Scale at A1		Status	Revision
MAN_JRL_03		As indicated		S3	P1
Donald Insall Associates					
Chartered Architects and Historic Building Consultants					
Ducie House, 37 Ducie Street, Manchester M1 2JW					
(+44) 0161 359 4326					
Manchester@insall-architects.co.uk					
© 2023 DONALD INSALL ASSOCIATES LTD					

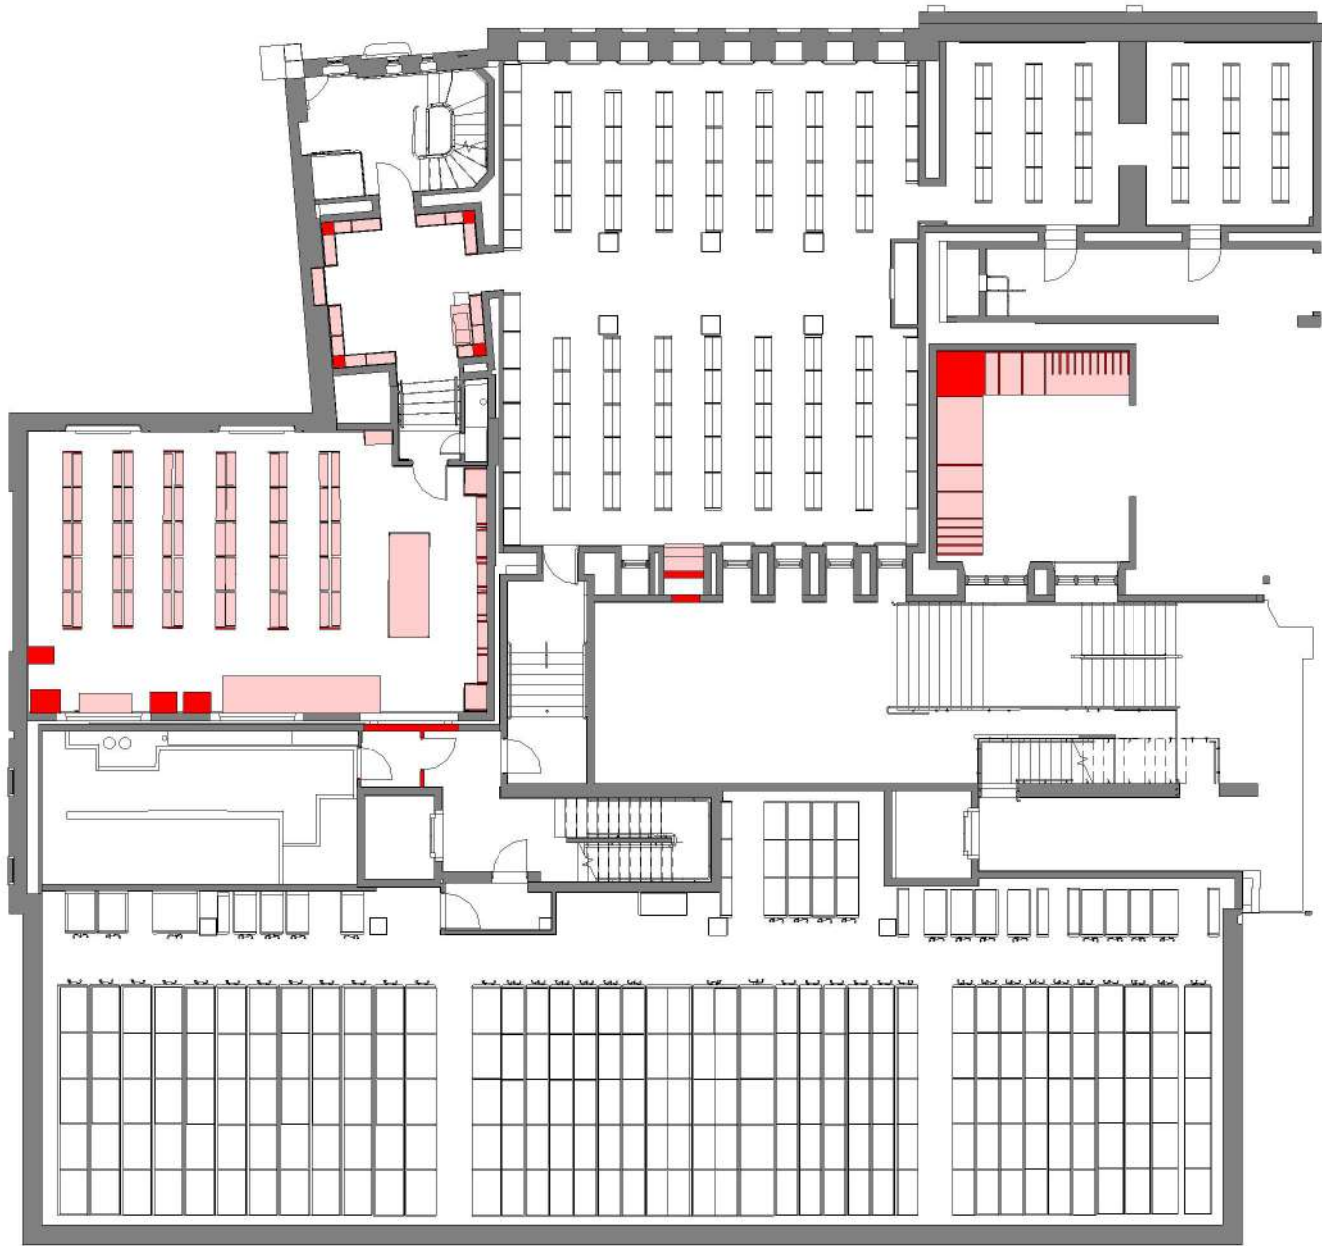

First Floor Plan - Stripping Out
Scale 1 : 100

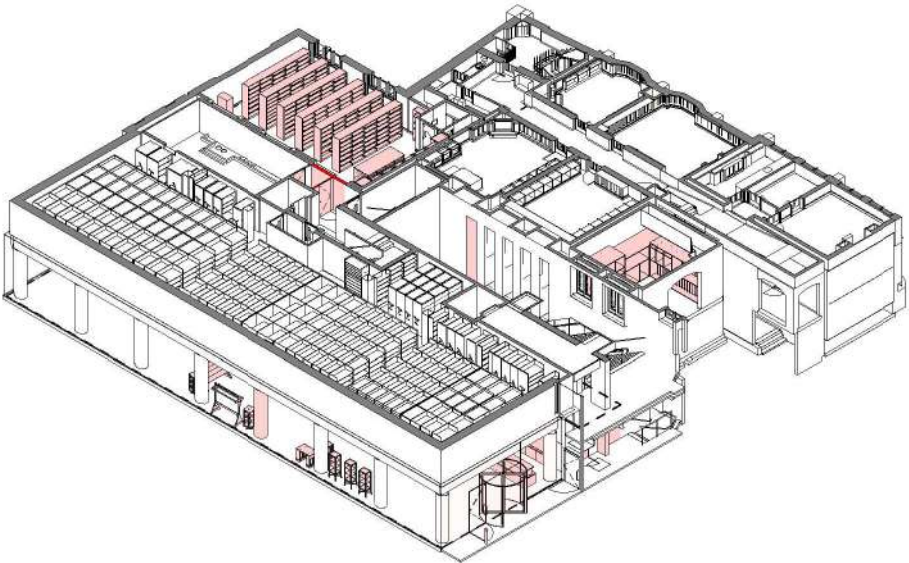

Axonometric - First Floor Plan - Stripping Out

Information Note

Any drawing format is to be read in conjunction with and at the scale of accompanying documents.

Where colours other than black or grey are used the drawing must be plotted in colour.

All dimensions are to be checked on site by the Contractor, scaling is for Local Authority purposes only.

Unless otherwise indicated, all dimensions are in millimeters.

All information on this drawing is to be read in conjunction with the relevant Donald Insall Associates (Insall) specification and trade contractors' drawings and information by specialists.

In the event of any discrepancy, please contact Insall immediately.

This drawing may contain survey information by others and is to be used solely for the purposes for which it was issued.

These are uncontrolled documents issued for information purposes only. If you have any queries regarding the drawings, contact Insall immediately.

Insall cannot be held responsible for any errors arising from changes made to an uncontrolled file.

Drawings by Donald Insall Associates to be read in conjunction with full 'Next Chapter' drawing sets. Including those by Structural Engineer, MEP Engineer, Exhibition Designer, Fire Consultant and Acoustic Consultant.

P1	27.06.23	JXW	RXC	Planning Permission and LBC Application		
Rev.	Date	Dim.	Auth.	Description		
Purpose of Issue						
Planning Permission and LBC Application						
Project Information						
The John Rylands						
Research Institute and Library						
Manchester, 'Next Chapter' Project						
Drawing Title						
First Floor Plan - Stripping Out - General Arrangement						
Drawing Number						
Project ID	Originator	Functional Breakdown	Spatial Breakdown	Form	Discipline	Number
JRL	- DIA	- ZZ	- 20A	- D60-	ACL	- 2152
Project Number		Scale at A1		Status	Revision	
MAN_JRL_03		As indicated		S3	P1	

Donald Insall Associates

Chartered Architects and Historic Building Consultants

Ducie House, 37 Ducie Street, Manchester M1 2JW
(+44) 0161 359 4326
Manchester@insall-architects.co.uk

© 2023 DONALD INSALL ASSOCIATES LTD


Any drawing format is to be read in conjunction with and at the scale of accompanying documents.

All dimensions are to be checked on site by the Contractor, scaling is for Local Authority purposes only.


All information on this drawing is to be read in conjunction with the relevant Donald Insall Associates (Insall) specification and trade contractors' drawings and information by specialists.

This drawing may contain survey information by others and is to be used solely for the purposes for which it was issued.

Insall cannot be held responsible for any errors arising from changes made to an uncontrolled file.

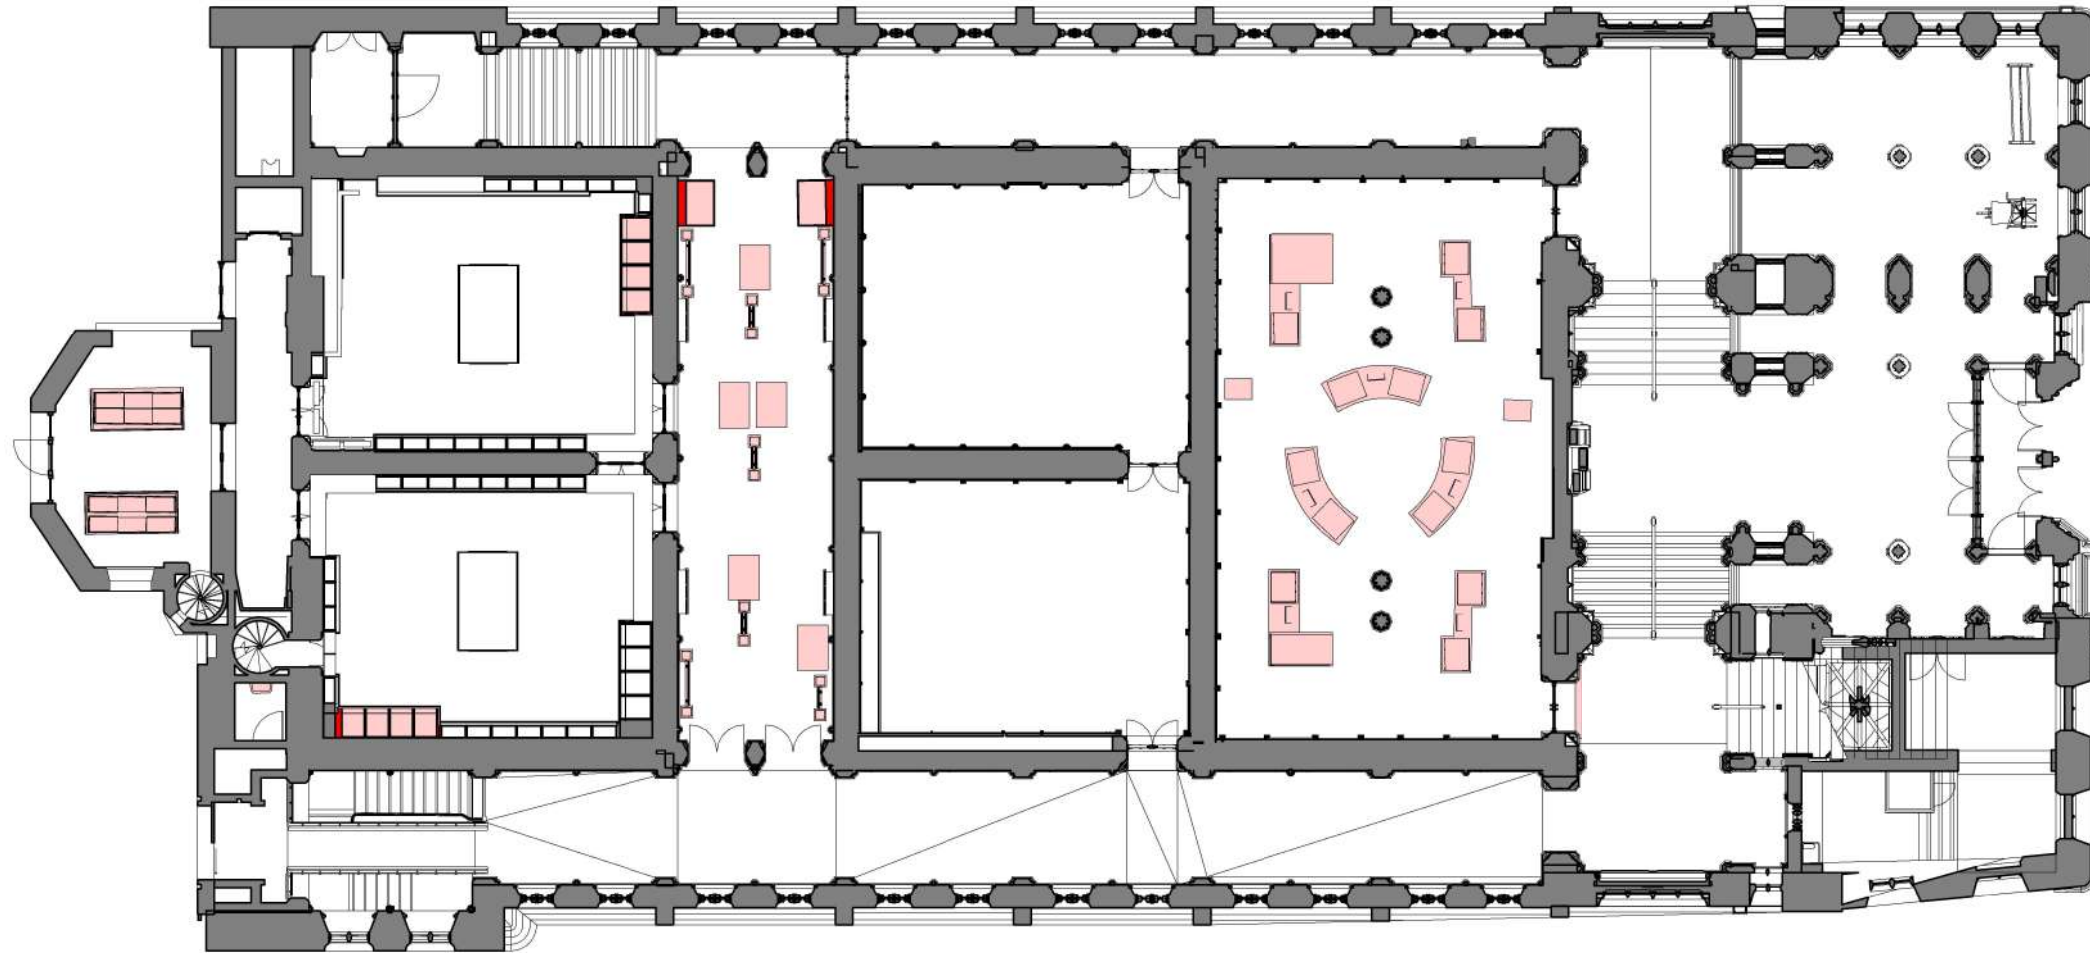

Scale 1 : 100

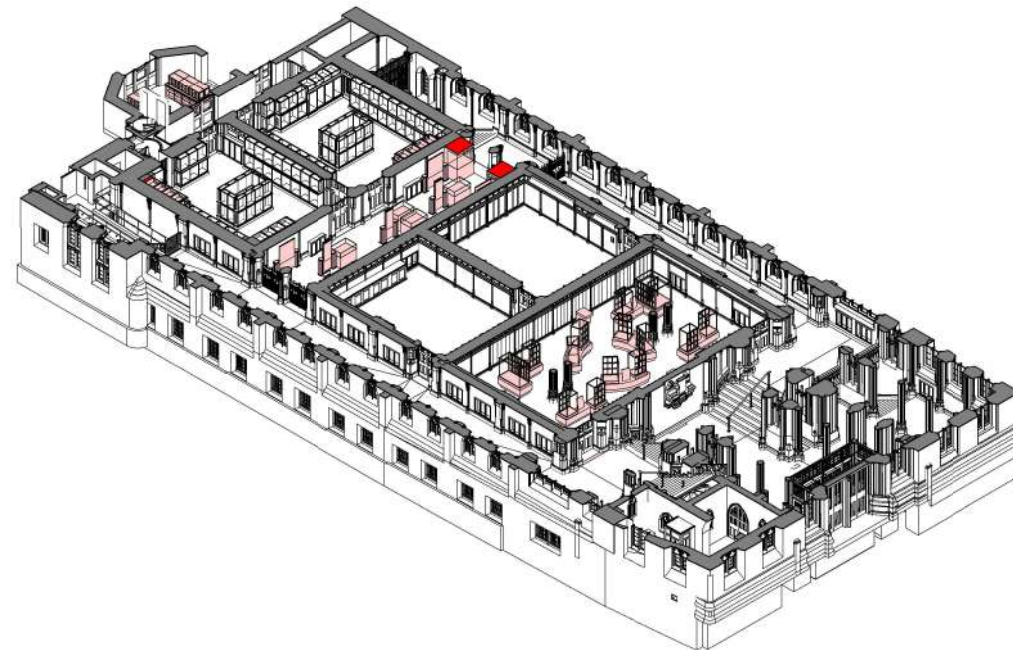

Axonometric - Historic Entrance and First Floor - Stripping Out

P1	27.08.23	JWW	RXC	Planning Permission and LBC Application		
Rev.	Date	Dm.	Auth.	Description		
Purpose of Issue						
Planning Permission and LBC Application						
Project Information						
The John Rylands						
Research Institute and Library						
Manchester, 'Next Chapter' Project						
Drawing Title						
Historic Entrance and First Floor - Stripping Out - General Arrangement						
Drawing Number						
Project ID	Originator	Functional Breakdown	Spatial Breakdown	Form	Discipline	Number
JRL	- DIA	- ZZ	- 20B	- D60-	ACL	- 2101
Project Number		Scale at A1		Status	Revision	
MAN.JRL.03		As indicated		S3	P1	
Donald Insall Associates Chartered Architects and Historic Building Consultants						
Ducie House, 37 Ducie Street, Manchester M1 2JW (+44) 0161 359 4326 Manchester@insall-architects.co.uk						
© 2023 DONALD INSALL ASSOCIATES LTD						

Any drawing format is to be read in conjunction with and at the scale of accompanying documents.

Where colours other than black or grey are used the drawing must be plotted in colour.

All dimensions are to be checked on site by the Contractor, scaling is for Local Authority purposes only.

Unless otherwise indicated, all dimensions are in millimeters.

All information on this drawing is to be read in conjunction with the relevant Donald Insall Associates (Insall) specification and trade contractors' drawings and information by specialists.

In the event of any discrepancy, please contact Insall immediately.

This drawing may contain survey information by others and is to be used solely for the purposes for which it was issued.

These are uncontrolled documents issued for information purposes only. For queries regarding the drawings, contact Insall immediately.

Insall cannot be held responsible for any errors arising from changes made to an uncontrolled file.

Drawings by Donald Insall Associates to be read in conjunction with full 'Next Chapter' drawing sets, including those by Structural Engineer, MEP Engineer, Exhibition Designer, Fire Consultant and Acoustic Consultant.



Donald Insall Associates
Chartered Architects and Historic Building Consultants

Ducie House, 37 Ducie Street, Manchester M1 2JW
(+44) 0161 359 4326
Manchester@insall-architects.co.uk

© 2023 DONALD INSALL ASSOCIATES LTD



Any drawing format is to be read in conjunction with and at the scale of accompanying documents.

All dimensions are to be checked on site by the Contractor, scaling is for Local Authority purposes only.

Unless otherwise indicated, all dimensions are in millimeters.

All information on this drawing is to be read in conjunction with the relevant Donald Insall Associates (Insall) specification and trade contractors' drawings and information by specialists.

 
In the event of any discrepancy, please contact Insall immediately.

This drawing may contain survey information by others and is to be used solely for the purposes for which it was issued.

These are uncontrolled documents issued for information purposes only. If you have any queries regarding the drawings, contact Insall immediately.

Insall cannot be held responsible for any errors arising from changes made to an uncontrolled file.


Drawings by Donald Insall Associates to be read in conjunction with full 'Next Chapter' drawing sets. Including those by Structural Engineer, MEP Engineer, Exhibition Designer, Fire Consultant and Acoustic Consultant.




Donald Insall Associates
Chartered Architects and Historic Building Consultants

Ducie House, 37 Ducie Street, Manchester M1 2JW
(+44) 0161 359 4326
Manchester@insall-architects.co.uk

© 2023 DONALD INSALL ASSOCIATES LTD

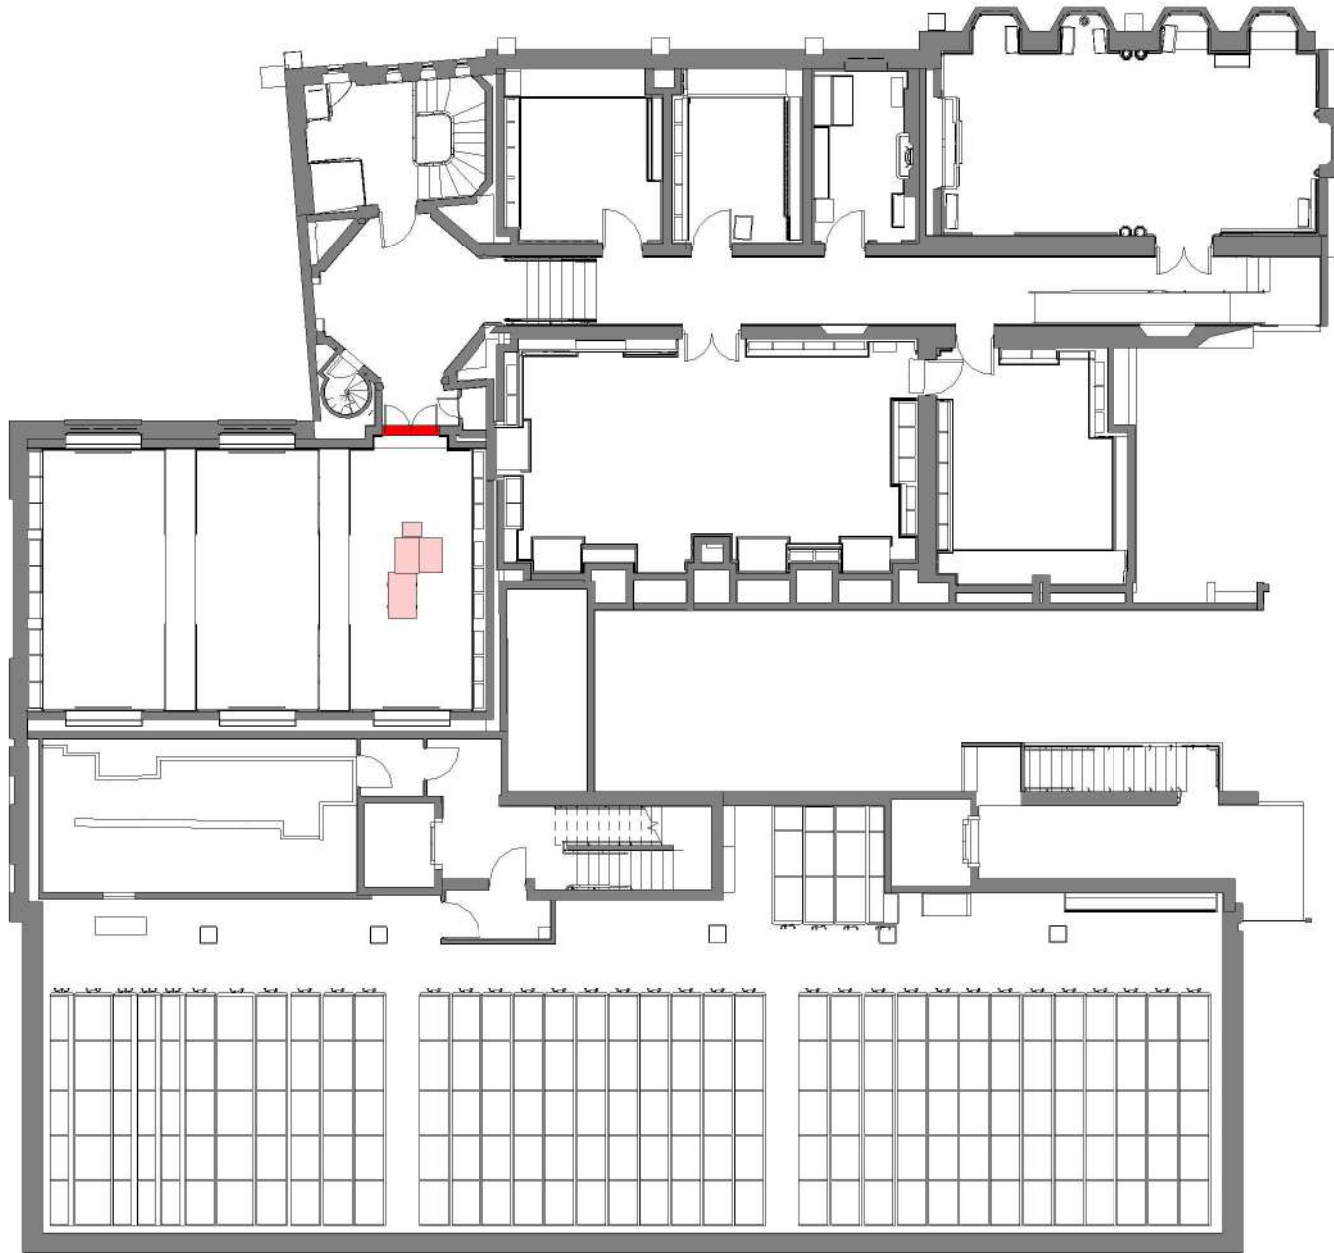

Axonometric - Third Floor Plan - Stripping Out
Scale 1 : 100

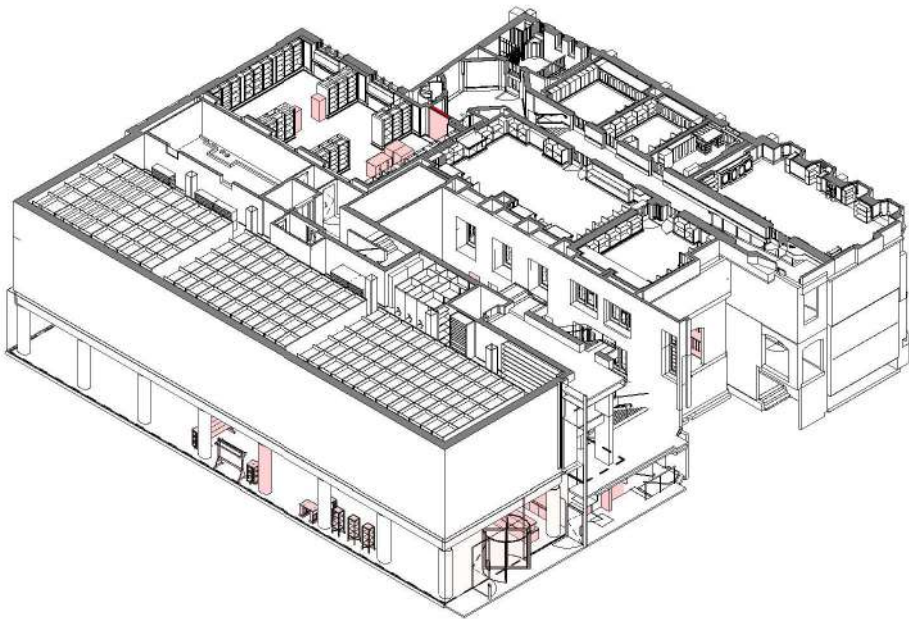

Axonometric - Third Floor Plan - Stripping Out

Information Note

Any drawing format is to be read in conjunction with and at the scale of accompanying documents.

Where colours other than black or grey are used the drawing must be plotted in colour.

All dimensions are to be checked on site by the Contractor, scaling is for Local Authority purposes only.

Unless otherwise indicated, all dimensions are in millimeters.

All information on this drawing is to be read in conjunction with the relevant Donald Insall Associates (Insall) specification and trade contractors' drawings and information by specialists.

In the event of any discrepancy, please contact Insall immediately.


This drawing may contain survey information by others and is to be used solely for the purposes for which it was issued.

These are uncontrolled documents issued for information purposes only. If you have any queries regarding the drawings, contact Insall immediately.


Insall cannot be held responsible for any errors arising from changes made to an uncontrolled file.

Drawings by Donald Insall Associates to be read in conjunction with full 'Next Chapter' drawing sets. Including those by Structural Engineer, MEP Engineer, Exhibition Designer, Fire Consultant and Acoustic Consultant.

P1	27.06.23	JXW	RXC	Planning Permission and LBC Application		
Rev.	Date	Dim.	Auth.	Description		
Purpose of Issue						
Planning Permission and LBC Application						
Project Information						
The John Rylands Research Institute and Library Manchester, 'Next Chapter' Project						
Drawing Title						
Third Floor Plan - Stripping Out - General Arrangement						
Drawing Number						
Project ID	Originator	Functional Breakdown	Spatial Breakdown	Form	Discipline	Number
JRL	- DIA	- ZZ	- 40A	- D60-	ACL	- 2154
Project Number		Scale at A1		Status	Revision	
MAN_JRL_03		As indicated		S3	P1	
Donald Insall Associates						
Chartered Architects and Historic Building Consultants						
Ducie House, 37 Ducie Street, Manchester M1 2JW (+44) 0161 359 4326 Manchester@insall-architects.co.uk						
© 2023 DONALD INSALL ASSOCIATES LTD						

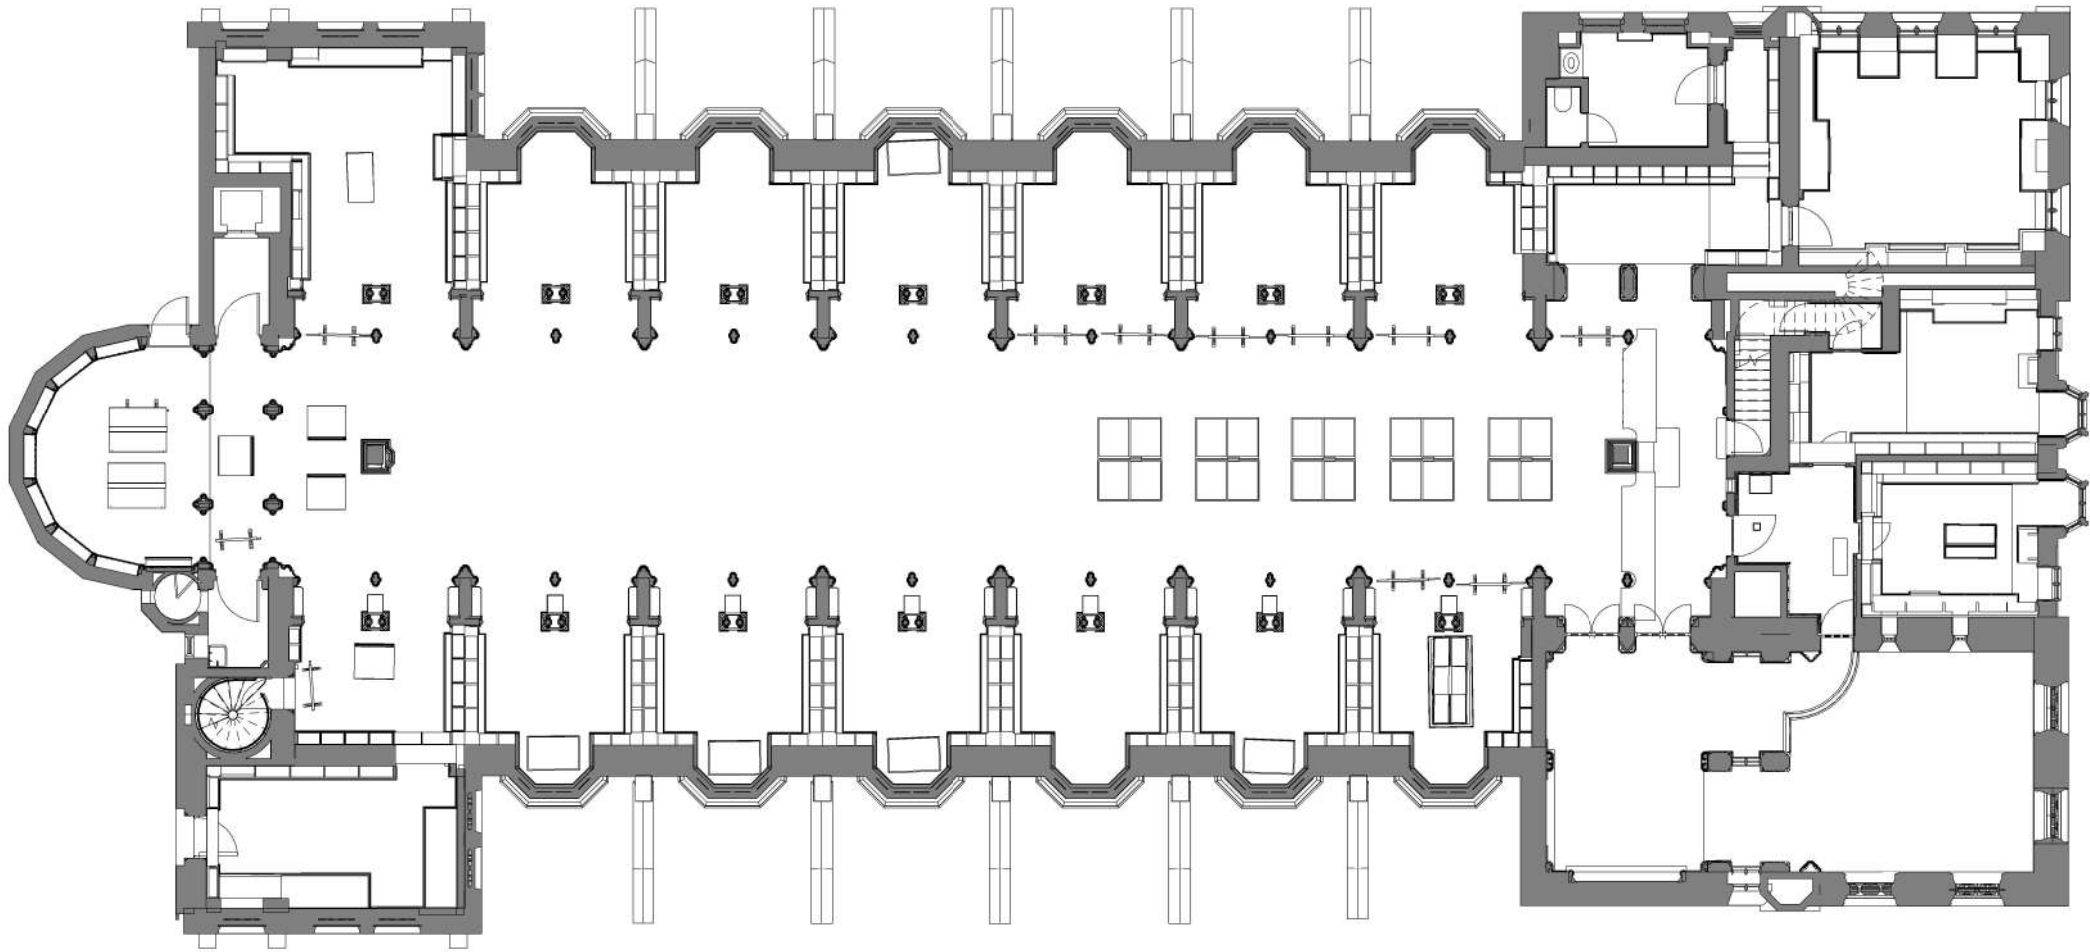

Reading Room - Stripping Out
SCALE : 100

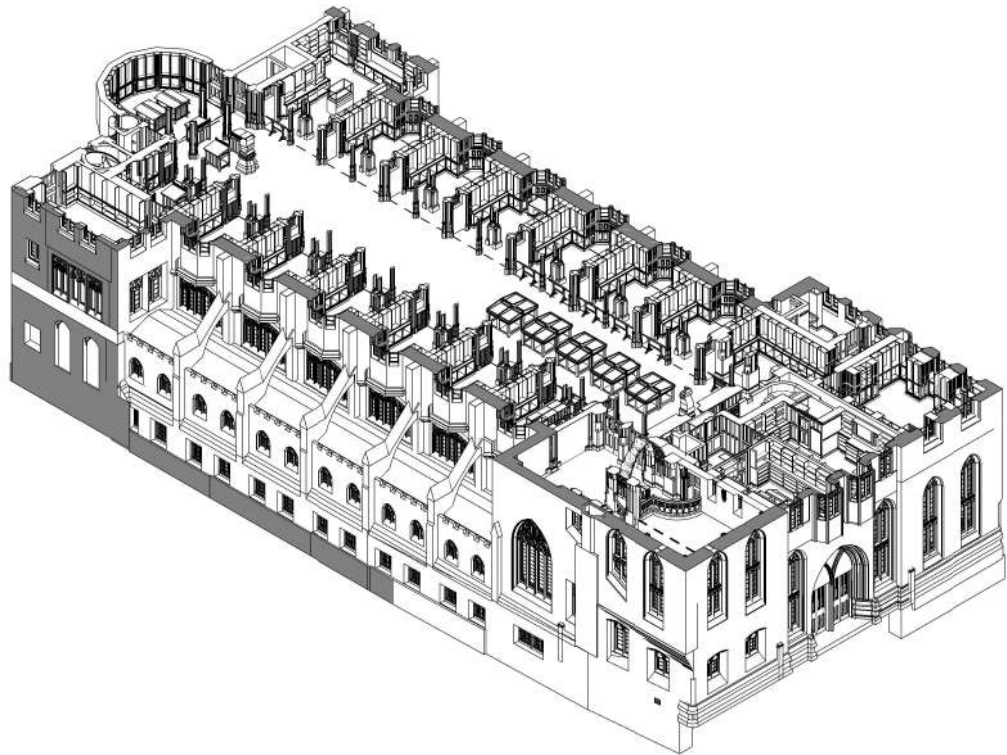

Axonometric - Reading Room - Stripping Out
SCALE



Information Note

Any drawing format is to be read in conjunction with and at the scale of accompanying documents.

Where colours other than black or grey are used the drawing must be plotted in colour.

All dimensions are to be checked on site by the Contractor, scaling is for Local Authority purposes only.

Unless otherwise indicated, all dimensions are in millimeters.

All information on this drawing is to be read in conjunction with the relevant Donald Insall Associates (Insall) specification and trade contractors' drawings and information by specialists.

In the event of any discrepancy, please contact Insall immediately.

This drawing may contain survey information by others and is to be used solely for the purposes for which it was issued.

These are uncontrolled documents issued for information purposes only. If you have any queries regarding the drawings, contact Insall immediately.

Insall cannot be held responsible for any errors arising from changes made to an uncontrolled file.

Drawings by Donald Insall Associates to be read in conjunction with full 'Next Chapter' drawing sets. Including those by Structural Engineer, MEP Engineer, Exhibition Designer, Fire Consultant and Acoustic Consultant.


P2	27.06.2023	JXW	RXC	Planning Permission and LBC Application	
P1	16.03.23	JXW	ELE	Initial Issue	
Rev.	Date	Dim.	Auth.	Description	
Purpose of Issue					
Planning Permission and LBC Application					
Project Information					
The John Rylands					
Research Institute and Library					
Manchester, 'Next Chapter' Project					
Drawing Title					
Reading Room - Stripping Out - General Arrangement					
Drawing Number					
Project ID	Originator	Functional Breakdown	Spatial Breakdown	Form Discipline	Number
JRL	- DIA	- ZZ	- 40B - D60-	ACL	- 2103
Project Number		Scale at A1		Status	Revision
MAN.JRL.03		As indicated		S3	P2

Donald Insall Associates


Chartered Architects and Historic Building Consultants

Ducie House, 37 Ducie Street, Manchester M1 2JW
(+44) 0161 359 4326
Manchester@insall-architects.co.uk

© 2023 DONALD INSALL ASSOCIATES LTD

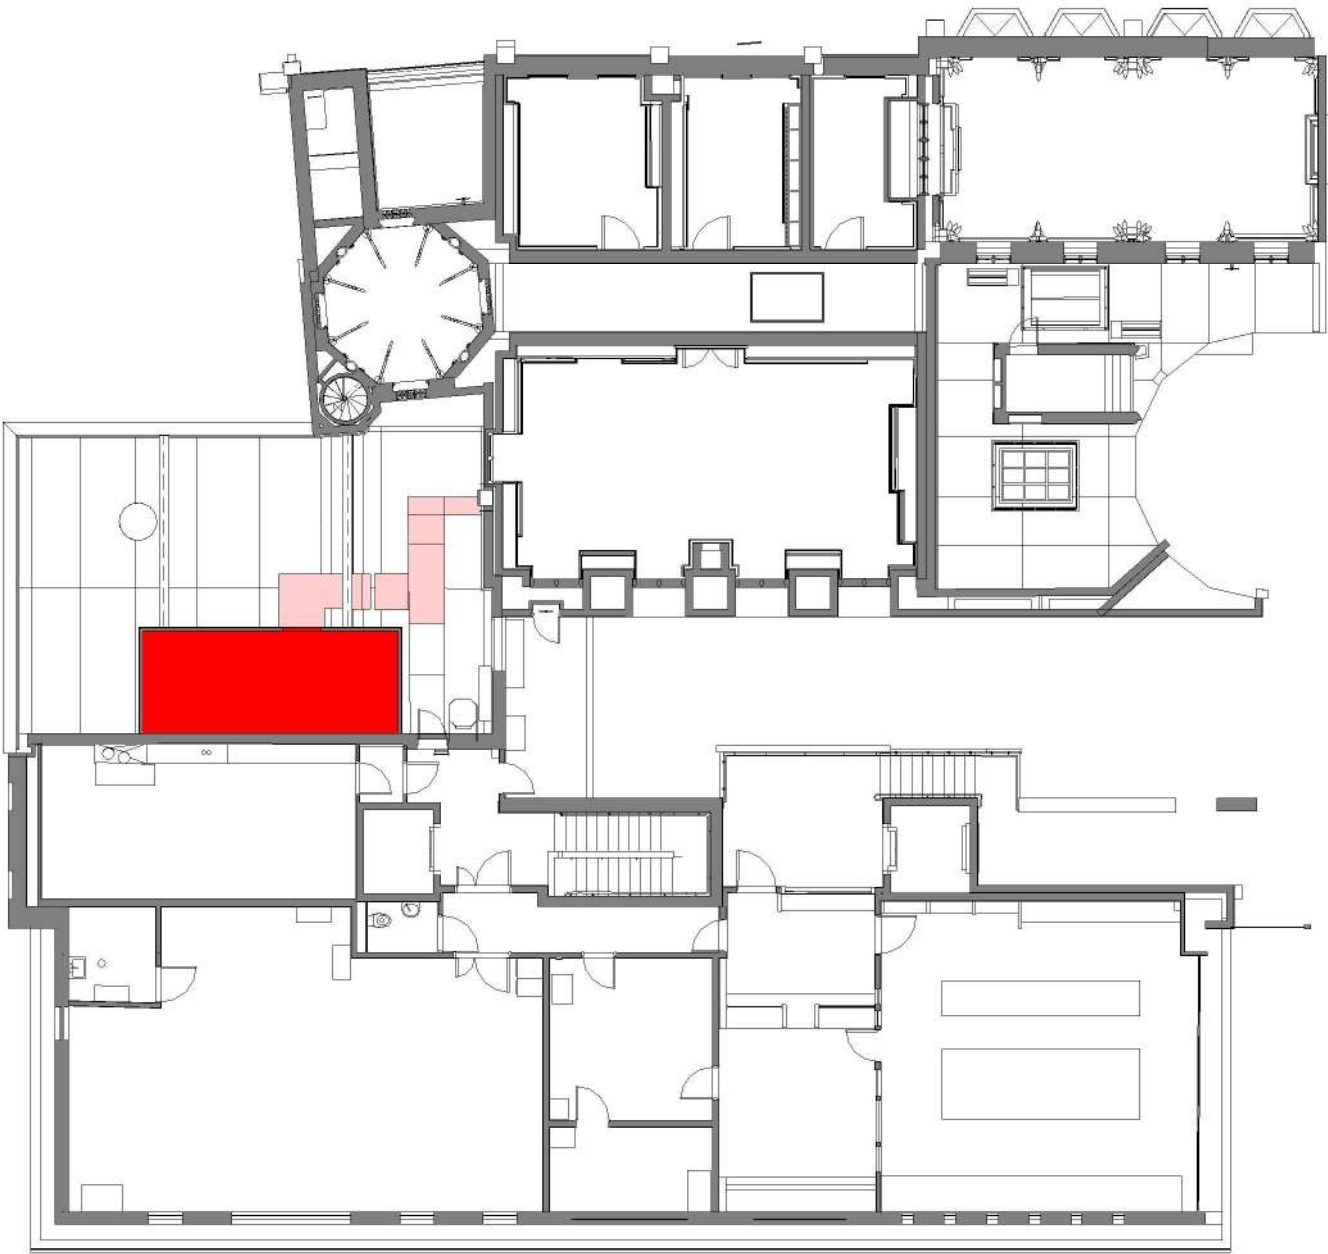

Fourth Floor - Stripping Out
Scale 1 : 100

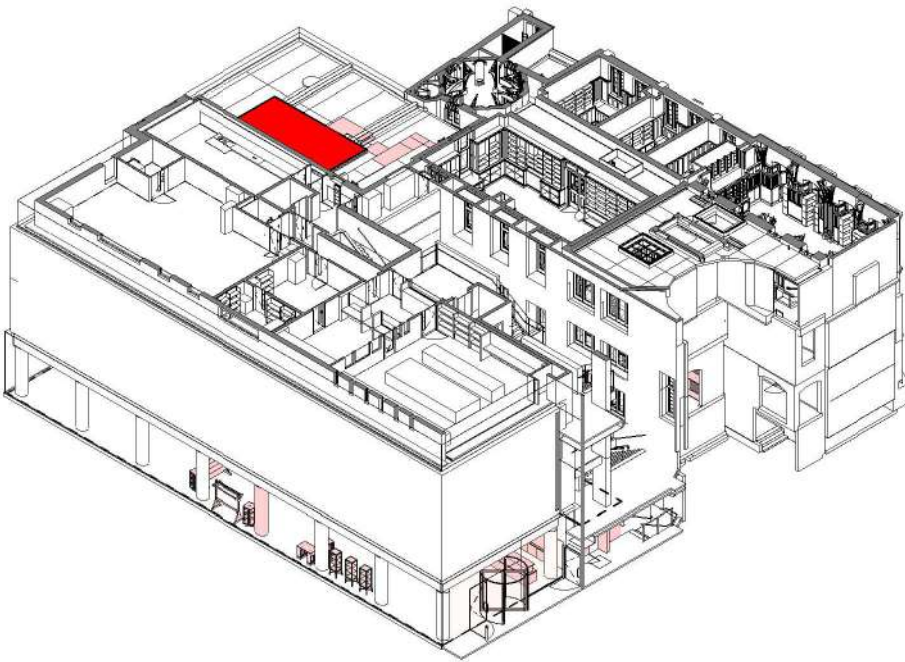

Axonometric - Fourth Floor - Stripping Out

Information Note

Any drawing format is to be read in conjunction with and at the scale of accompanying documents.

Where colours other than black or grey are used the drawing must be plotted in colour.

All dimensions are to be checked on site by the Contractor, scaling is for Local Authority purposes only.

Unless otherwise indicated, all dimensions are in millimeters.

All information on this drawing is to be read in conjunction with the relevant Donald Insall Associates (Insall) specification and trade contractors' drawings and information by specialists.

In the event of any discrepancy, please contact Insall immediately.

This drawing may contain survey information by others and is to be used solely for the purposes for which it was issued.

These are uncontrolled documents issued for information purposes only. If you have any queries regarding the drawings, contact Insall immediately.

Insall cannot be held responsible for any errors arising from changes made to an uncontrolled file.

Drawings by Donald Insall Associates to be read in conjunction with full 'Next Chapter' drawing sets. Including those by Structural Engineer, MEP Engineer, Exhibition Designer, Fire Consultant and Acoustic Consultant.


Rev.	27.06.23	JXW	RXC	Planning Permission and LBC Application		
Date		Dim.	Auth.	Description		
Purpose of Issue						
Planning Permission and LBC Application						
Project Information						
The John Rylands						
Research Institute and Library						
Manchester, 'Next Chapter' Project						
Drawing Title						
Fourth Floor Plan - Stripping Out - General Arrangement						
Drawing Number						
Project ID	Originator	Functional Breakdown	Spatial Breakdown	Form	Discipline	Number
JRL	- DIA	- ZZ	- 50A - D60-	ACL	-	2155
Project Number		Scale at A1		Status	Revision	
MAN_JRL_03		As indicated		S3	P1	

Donald Insall Associates


Chartered Architects and Historic Building Consultants

Ducie House, 37 Ducie Street, Manchester M1 2JW
(+44) 0161 359 4326
Manchester@insall-architects.co.uk

© 2023 DONALD INSALL ASSOCIATES LTD

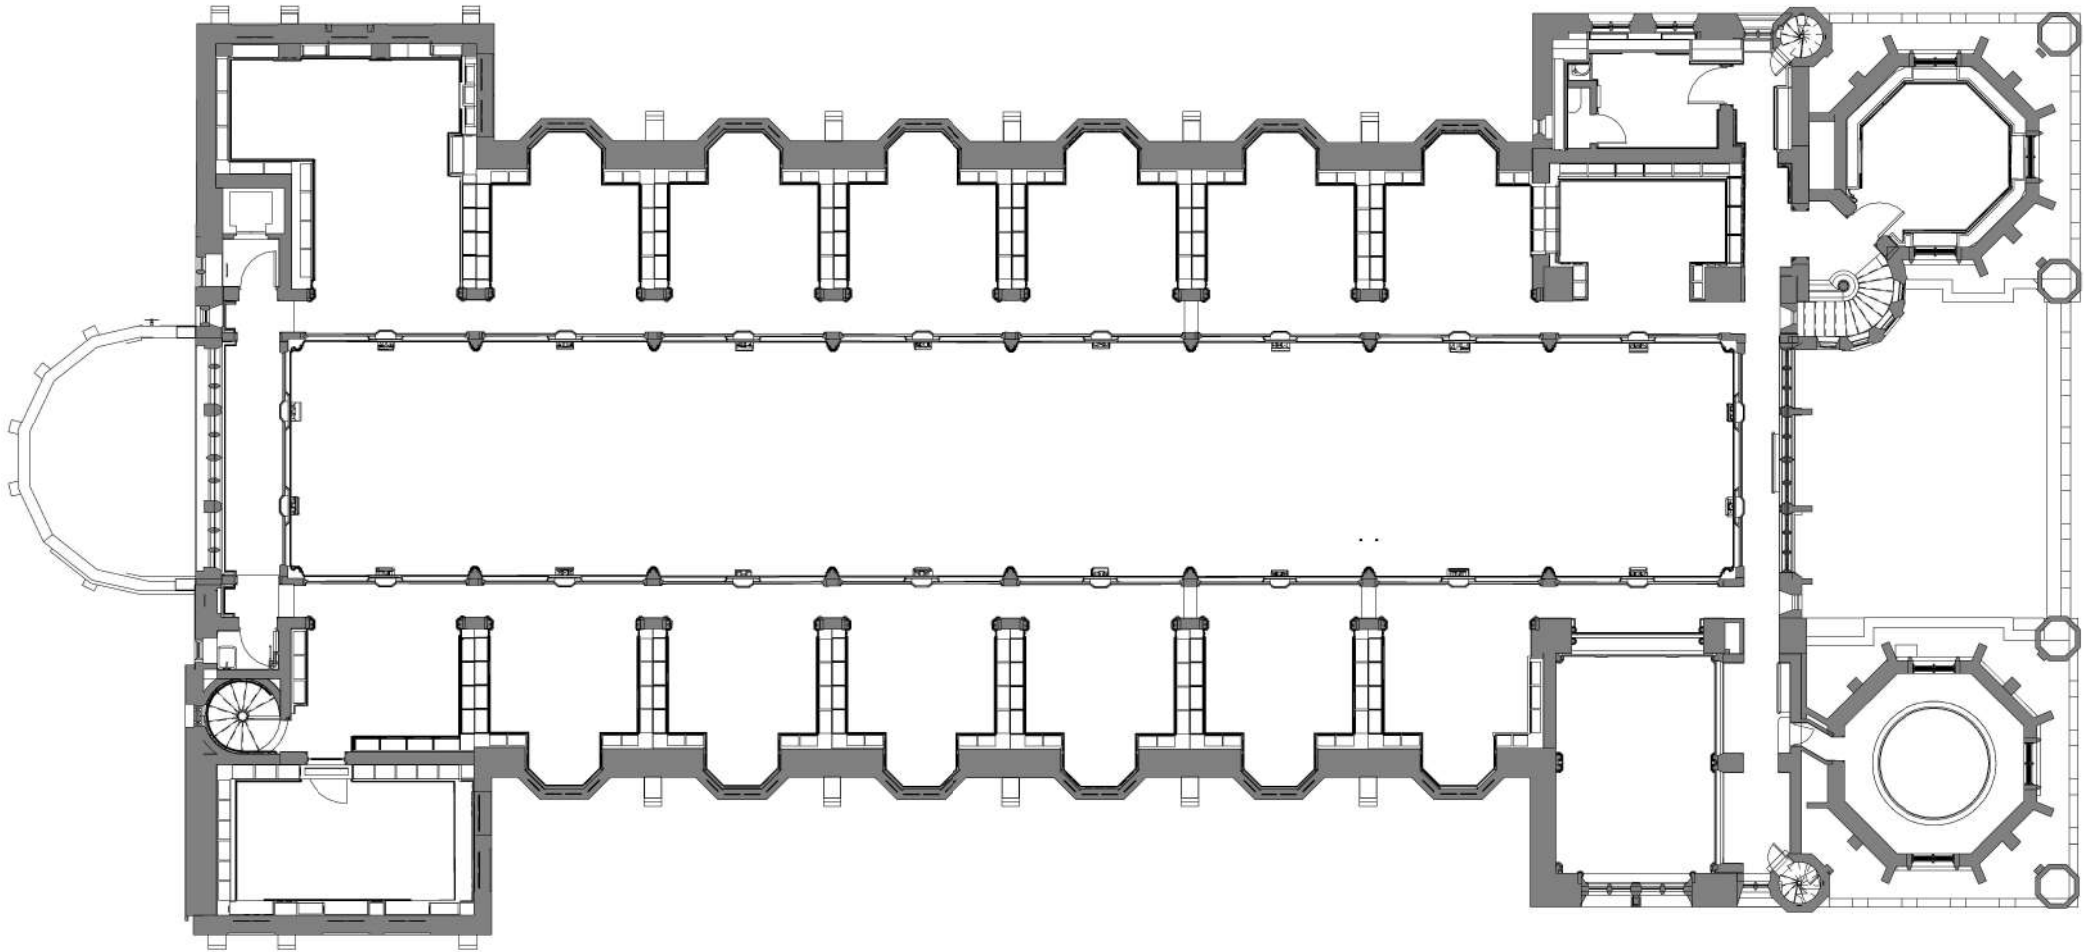

Reading Room Mezzanine - Stripping Out
SCALB : 100

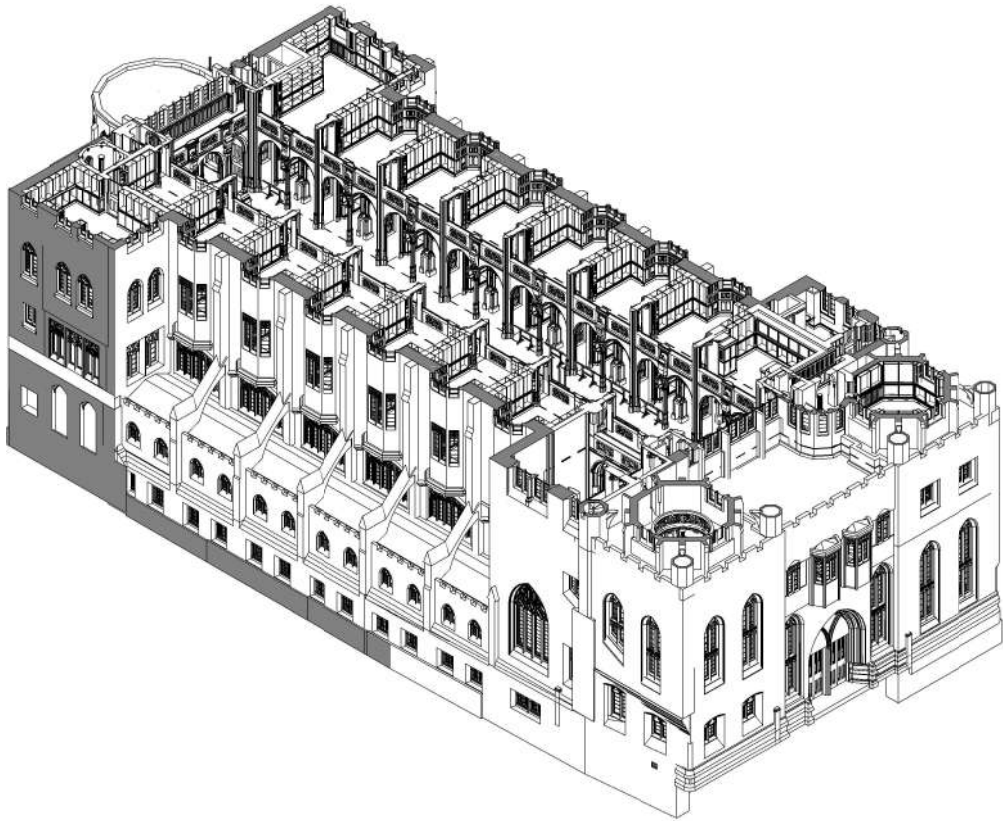

Axonometric - Reading Room Mezzanine as Proposed



Information Note

Any drawing format is to be read in conjunction with and at the scale of accompanying documents.

Where colours other than black or grey are used the drawing must be plotted in colour.

All dimensions are to be checked on site by the Contractor, scaling is for Local Authority purposes only.

Unless otherwise indicated, all dimensions are in millimeters.

All information on this drawing is to be read in conjunction with the relevant Donald Insall Associates (Insall) specification and trade contractors' drawings and information by specialists.

In the event of any discrepancy, please contact Insall immediately.

This drawing may contain survey information by others and is to be used solely for the purposes for which it was issued.

These are uncontrolled documents issued for information purposes only. If you have any queries regarding the drawings, contact Insall immediately.

Insall cannot be held responsible for any errors arising from changes made to an uncontrolled file.

Drawings by Donald Insall Associates to be read in conjunction with full 'Next Chapter' drawing sets, including those by Structural Engineer, MEP Engineer, Exhibition Designer, Fire Consultant and Acoustic Consultant.

P2	27.06.2023	JXW	RXC	Planning Permission and LBC Application		
P1	16.03.23	JXW	ELE	Initial Issue		
Rev.	Date	Dim.	Auth.	Description		
Purpose of Issue						
Planning Permission and LBC Application						
Project Information						
The John Rylands Research Institute and Library Manchester, 'Next Chapter' Project						
Drawing Title						
Reading Room Mezzanine - Stripping Out - General Arrangement						
Drawing Number						
Project ID	Originator	Functional Breakdown	Spatial Breakdown	Form	Discipline	Number
JRL	- DIA	- ZZ	- 50B	- D60-	ACL	- 2104
Project Number		Scale at A1		Status	Revision	
MAN.JRL.03		As indicated		S3	P2	

Donald Insall Associates

Chartered Architects and Historic Building Consultants

Ducie House, 37 Ducie Street, Manchester M1 2JW

(+44) 0161 359 4326

Manchester@insall-architects.co.uk

© 2023 DONALD INSALL ASSOCIATES LTD