



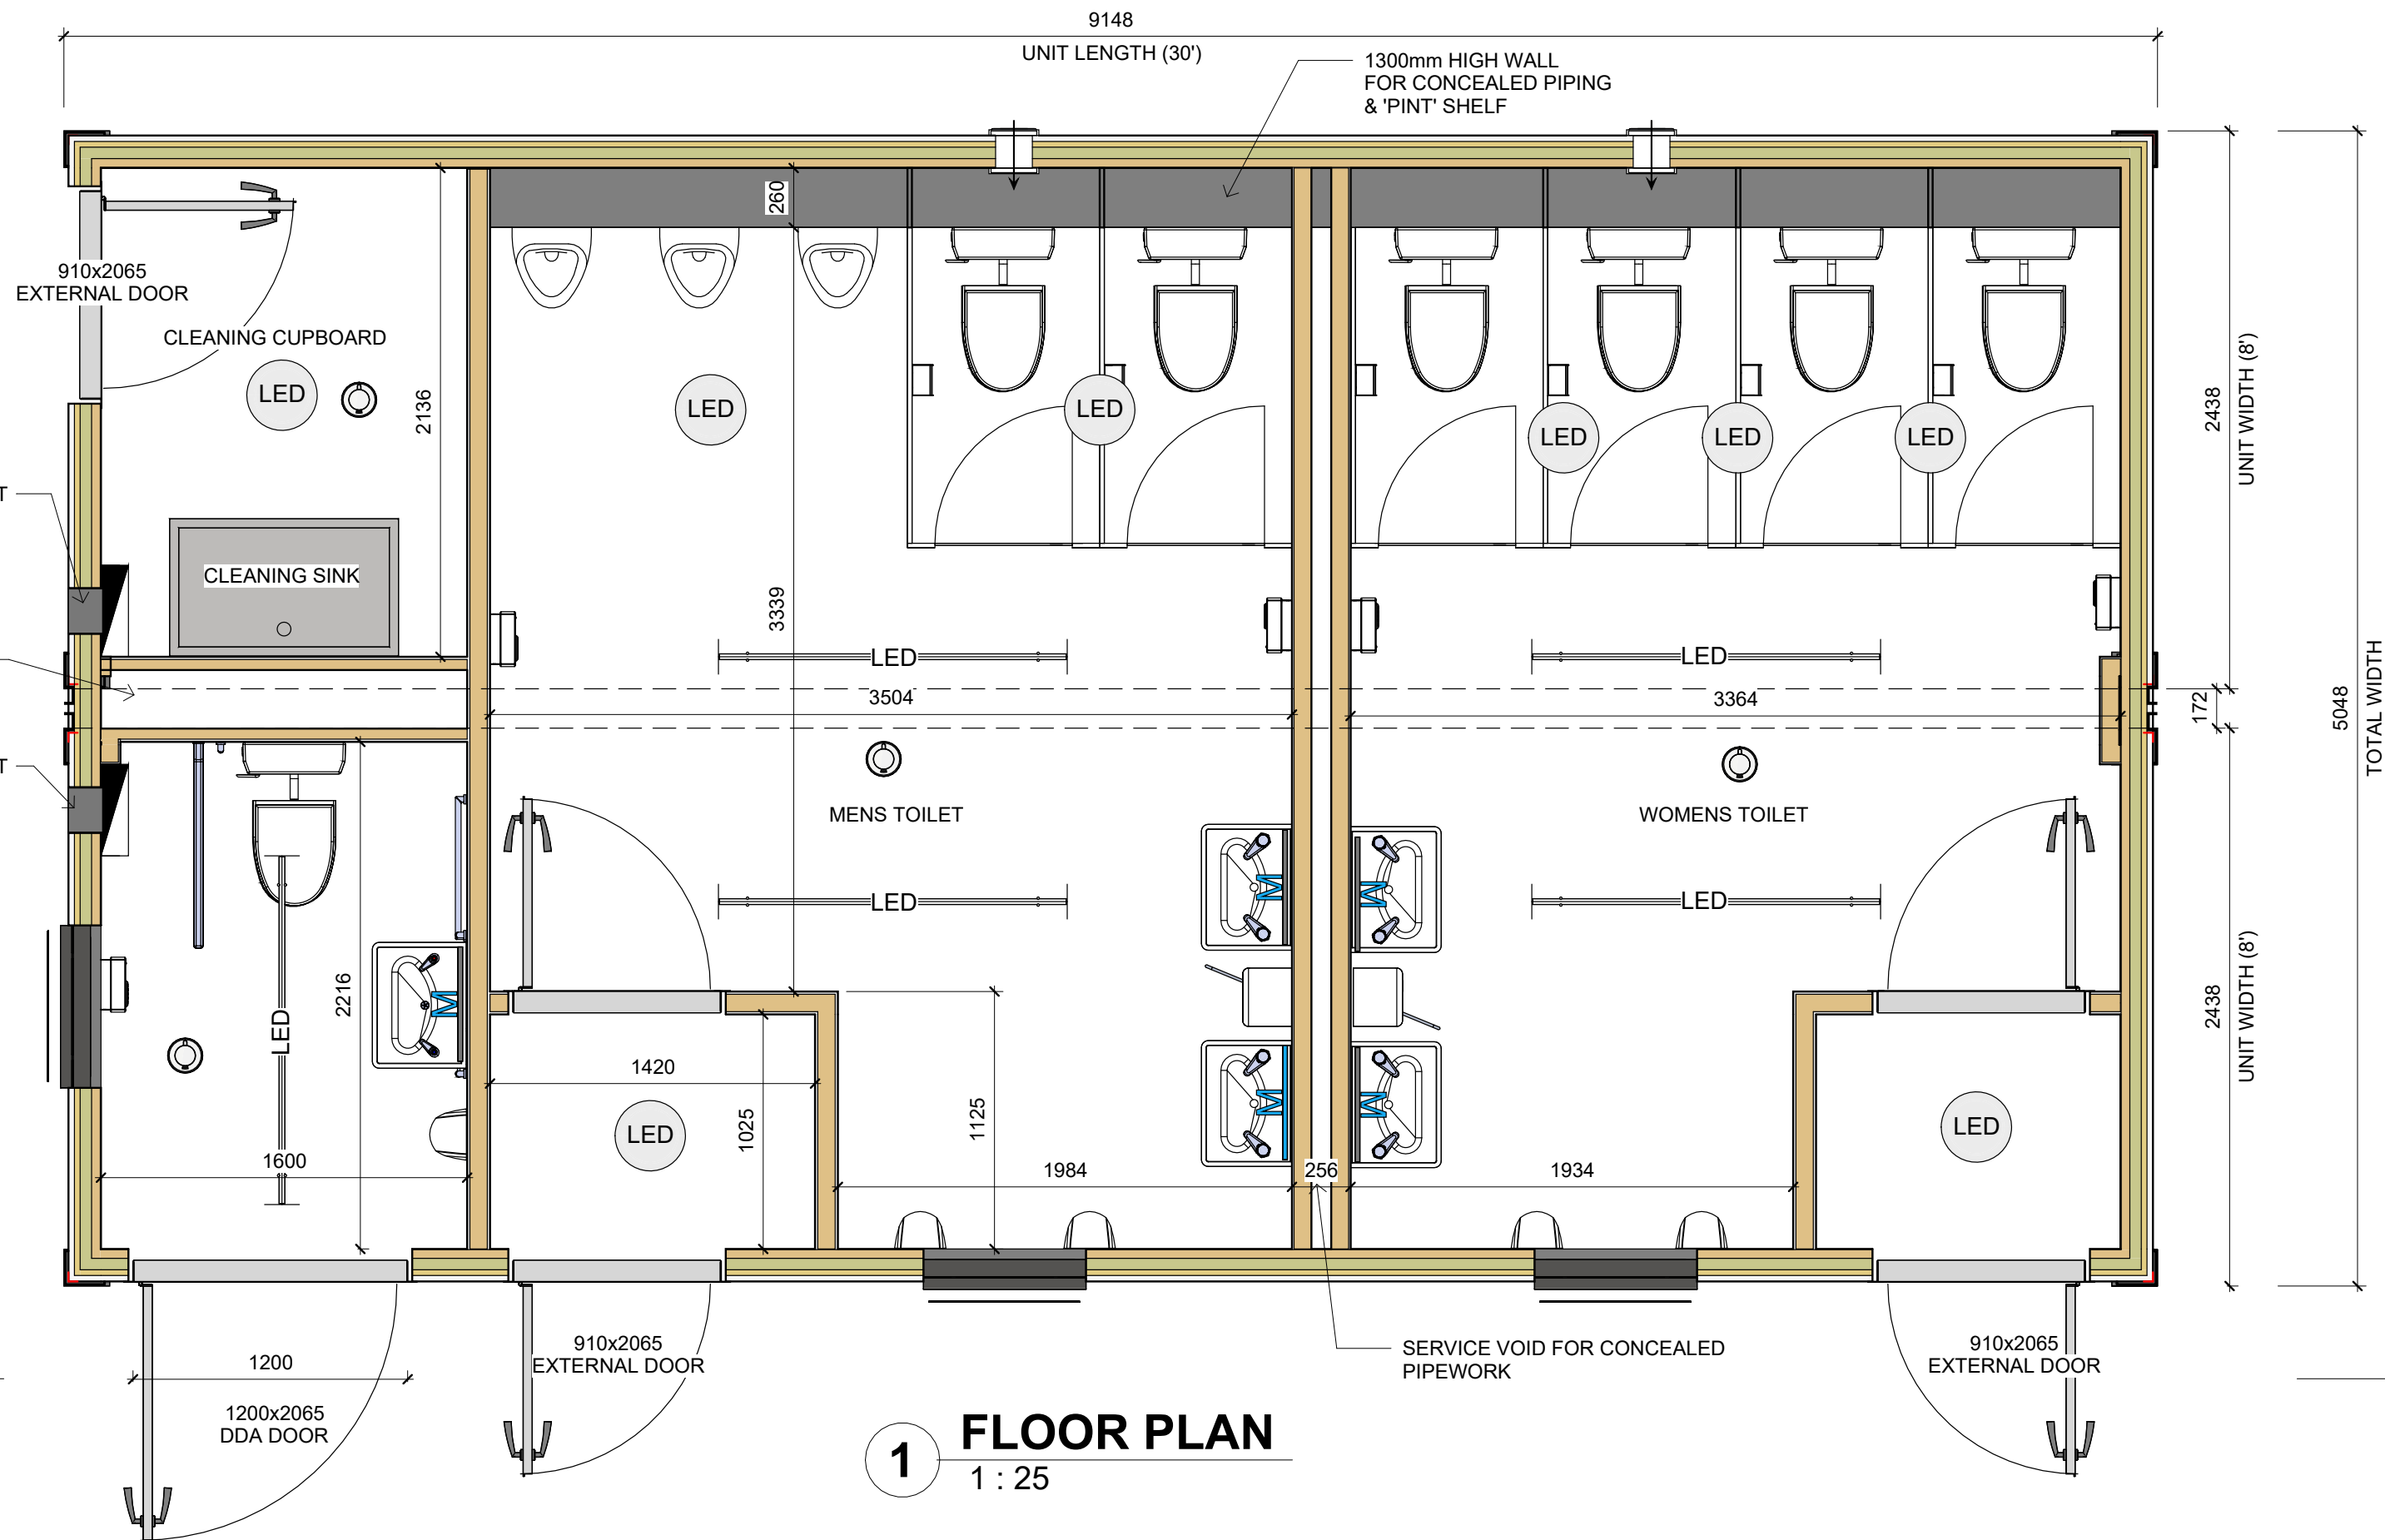


1 FLOOR PLAN
1 : 25

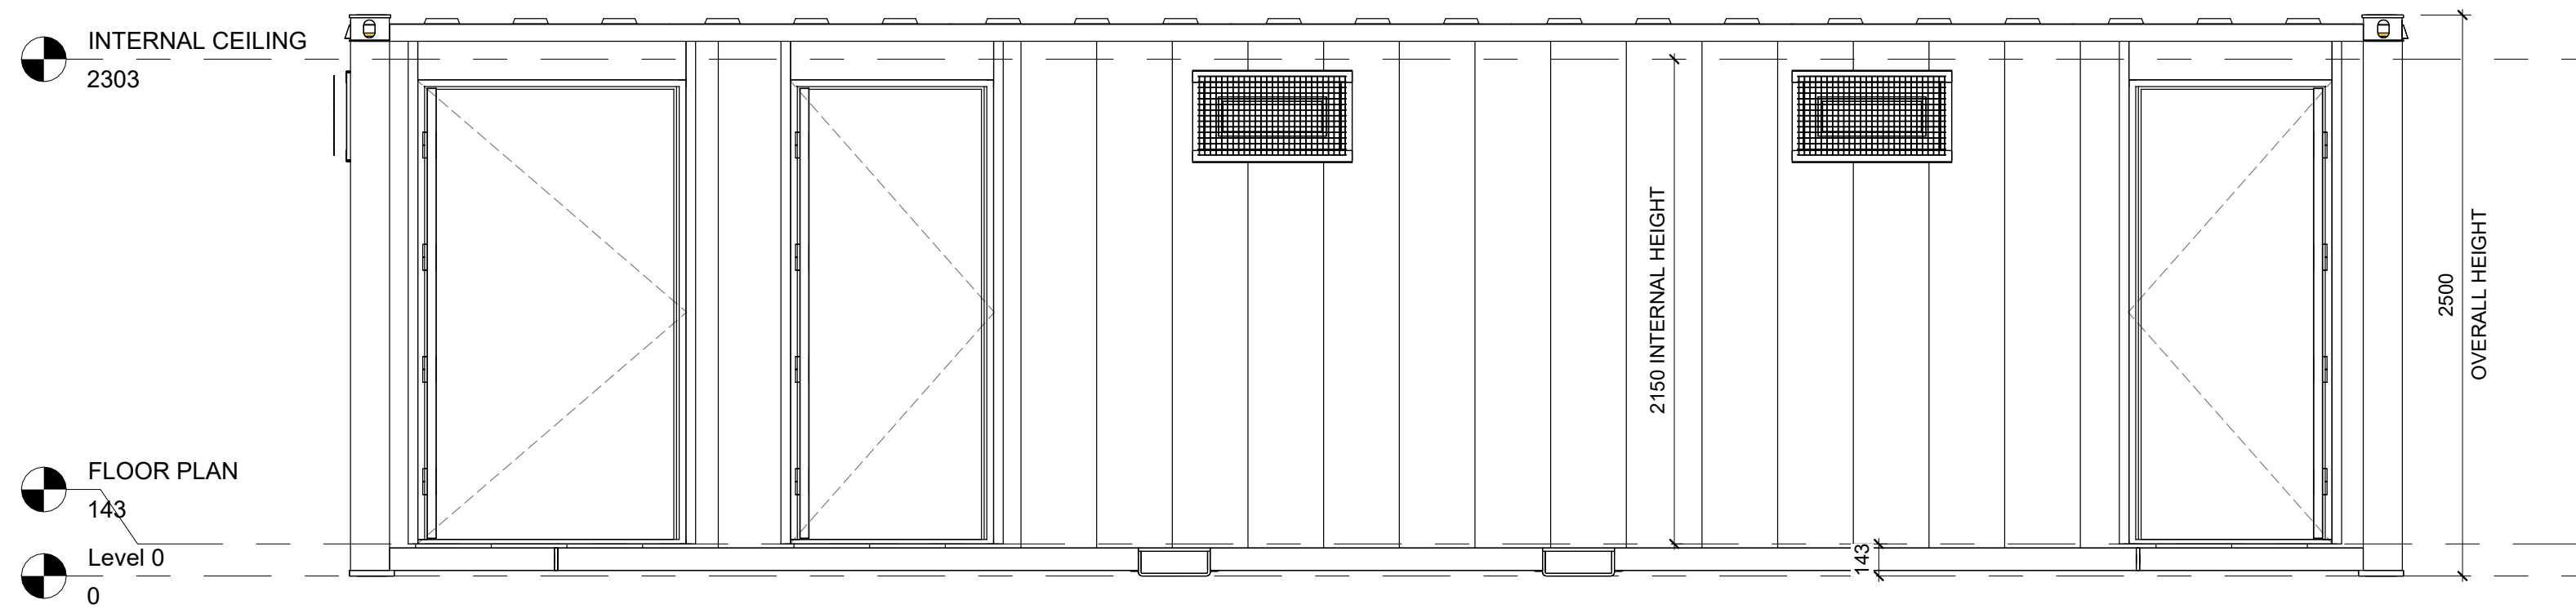

2 FRONT ELEVATION
1 : 25

SCHEDULE	
Count	COMPONENT
5	1Kw D/F Heater
2	6" EXTRACTOR FAN
1	2L Oversink Handwash
2	5L Undersink Handwash
5	Hand Dryer
5	Drilled Mirror
5	Vapour Proof LED Lights
8	Round Bulkhead Light With Sensor
Grand total: 33	
2x 30'x8' UNIT FLAT SIDED CONSTRUCTION	
CAPPING CHANNEL IN BETWEEN UNITS FOR DRAINAGE	
BOTTOM RAIL SIZE: 100x50x10.42Kg/m P.F.C TOP RAIL SIZE: 76x38x6.7Kg/m P.F.C FLAT FACES OF TOP RAILS OUTWARD. BEARER SIZE: 100x50x3mm R.H.S. @ 405mm CTRS. ROOF RIBS: 3 Off 40x40x3mm S.H.S	
WHITE UPVC FRAMED, DOUBLE GLAZED, HIGH LEVEL, FOV WINDOWS c/w OBSCURE GLASS & STEEL, MESH GUARDS.	
LINING DETAILS:	
WALLS 9MM WHITE MELAMINE BOARD & 50MM INSULATION	
CEILING 9MM WHITE MELAMINE BOARD & 25MM SPRAY FOAM + 50MM INSULATION.	
TRIMS WHITE PLASTIC	
FLOOR VINYL FLOORING OVER 15MM P5 TIMBER. NON-SLIP VINYL AND CAP N COVE EDGES THROUGHOUT	
CLIENT: MANCHESTER CITY FOOTBALL	
DRAWING NAME: PLAN VIEW	
DRAWING NUMBER: 01	
REV: 1	REV DATE: 05/07/23
DRAWN BY: MB	CHECKED BY: NT
DRAWING STATUS: FOR INFORMATION	
SCALE:	1 : 25

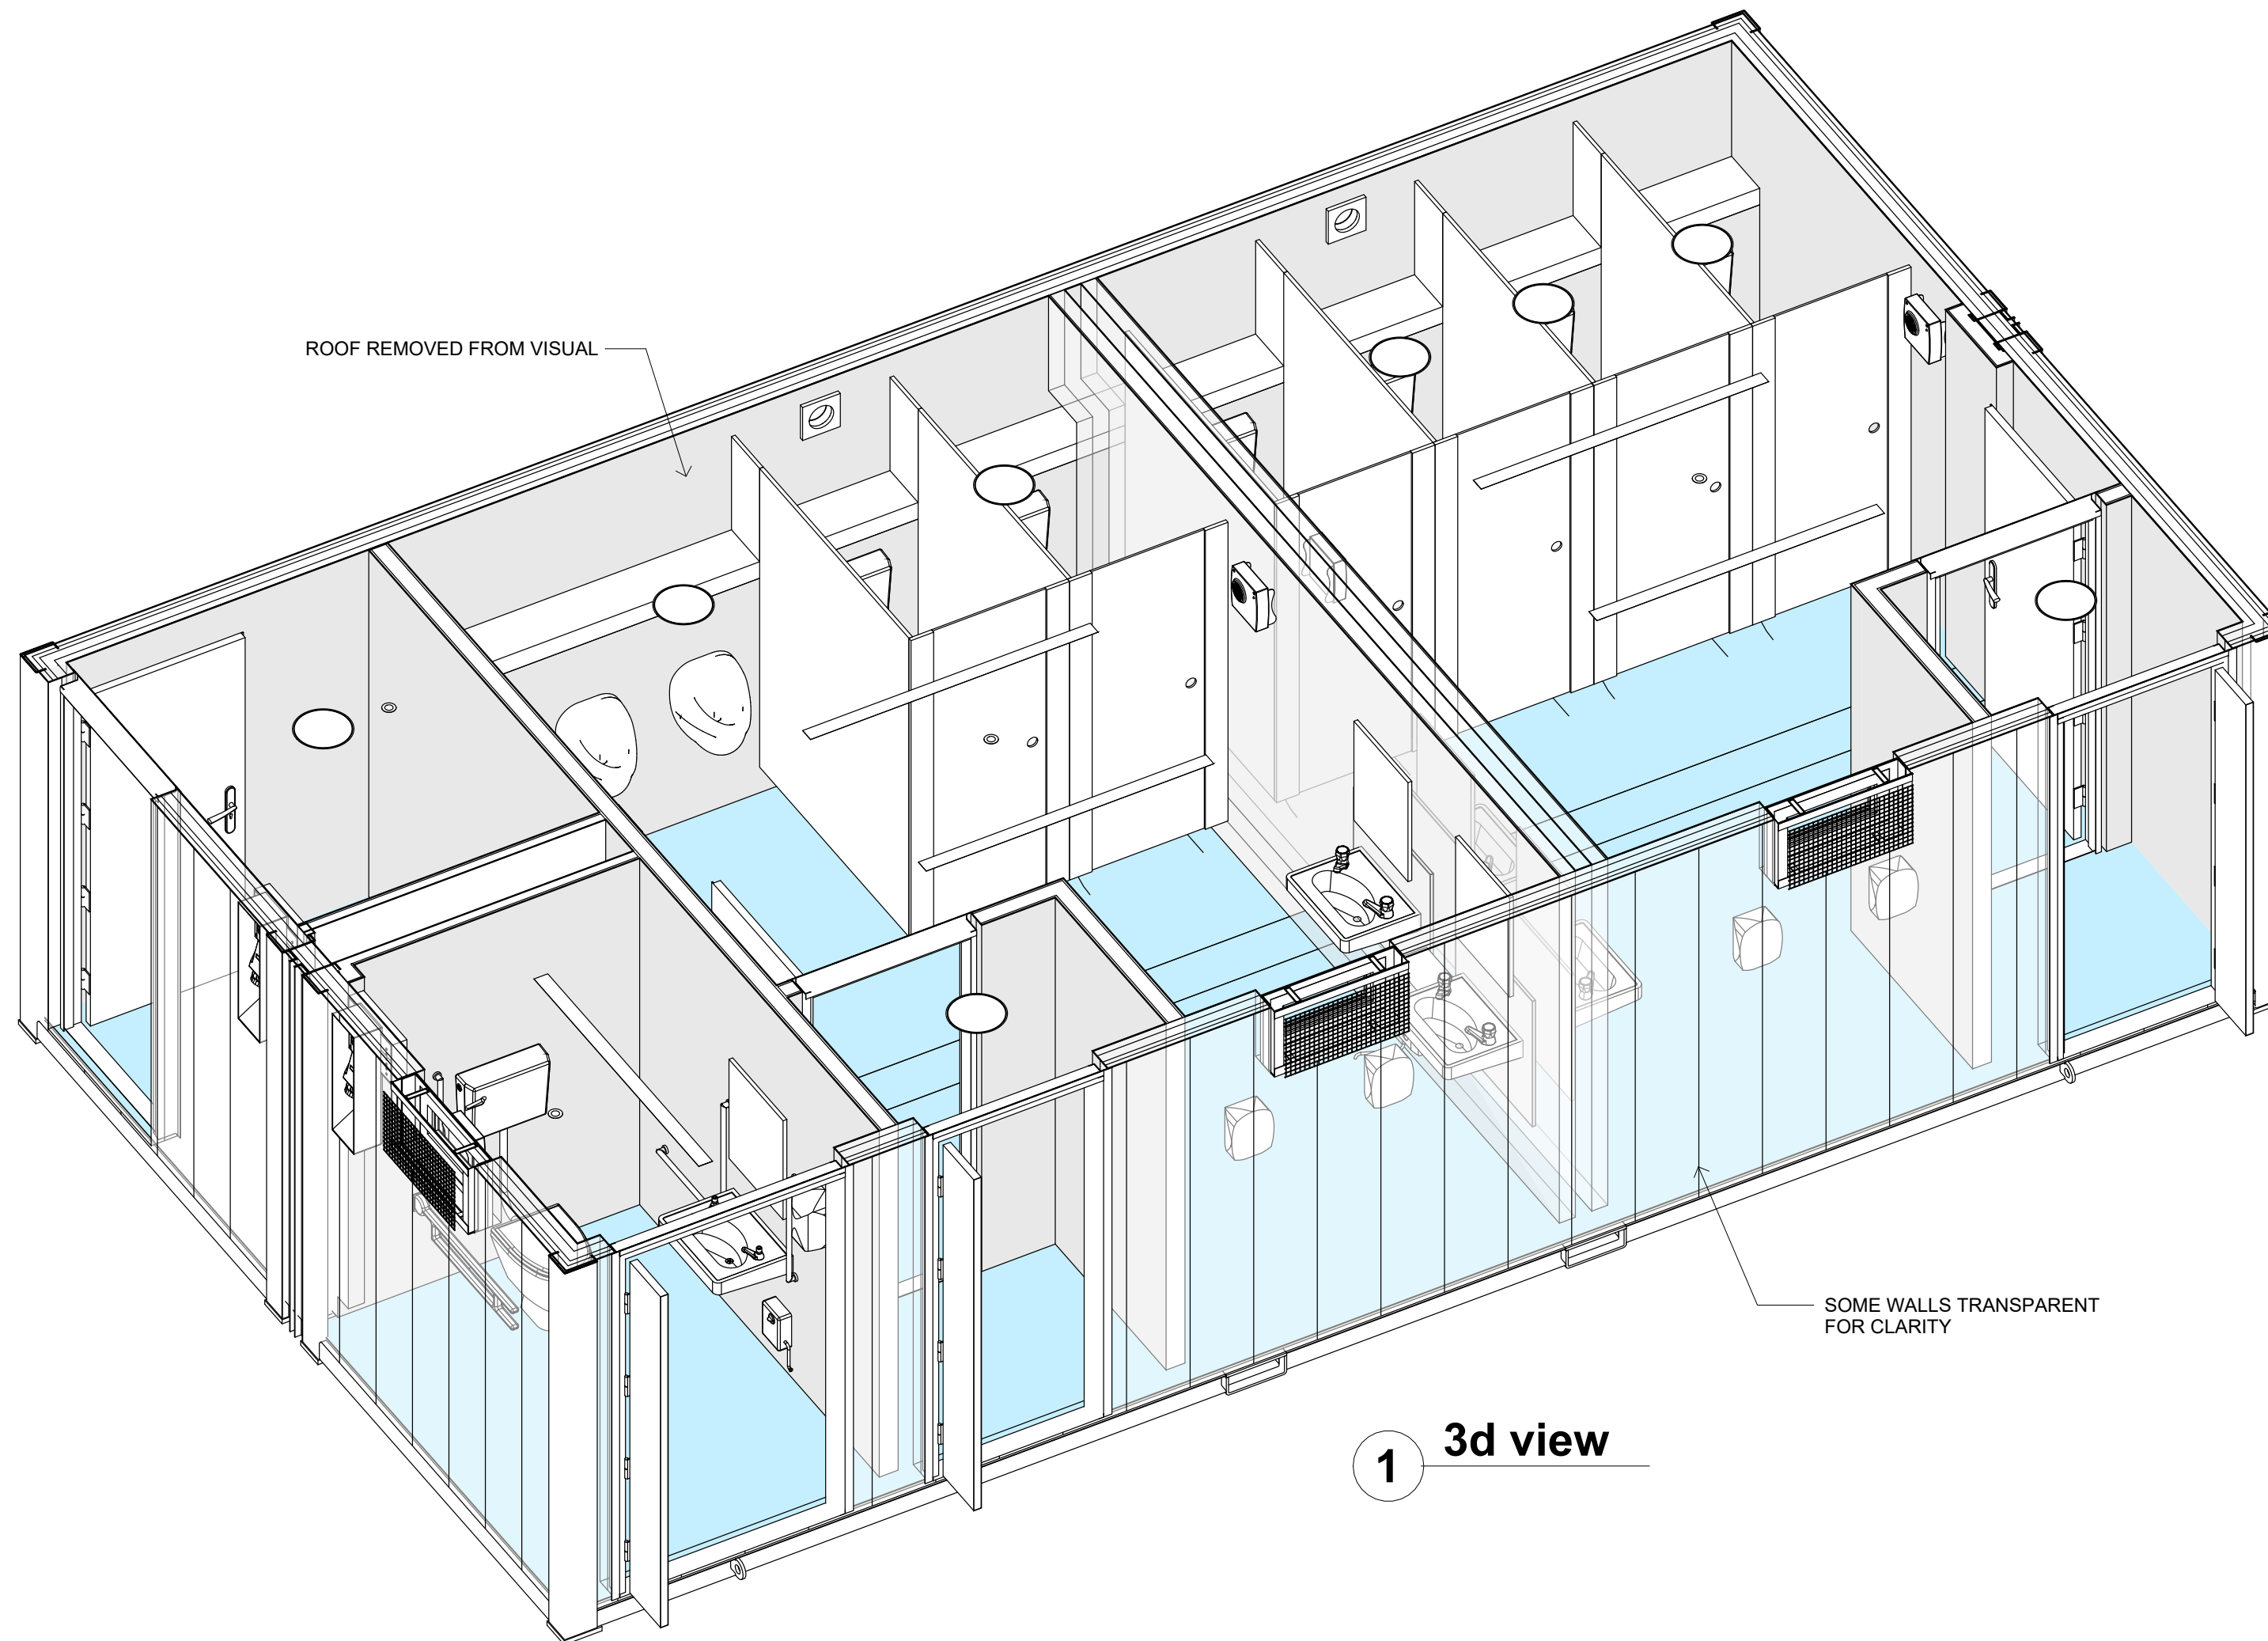

1 3d view



CLIENT:
MANCHESTER CITY FOOTBALL

DRAWING NAME:
3D View

DRAWING NUMBER:
02

REV: 1 REV DATE: 05/07/23

DRAWN BY: MB CHECKED BY: NT

DRAWING STATUS:
FOR INFORMATION

SCALE: