



Main Star Lighting

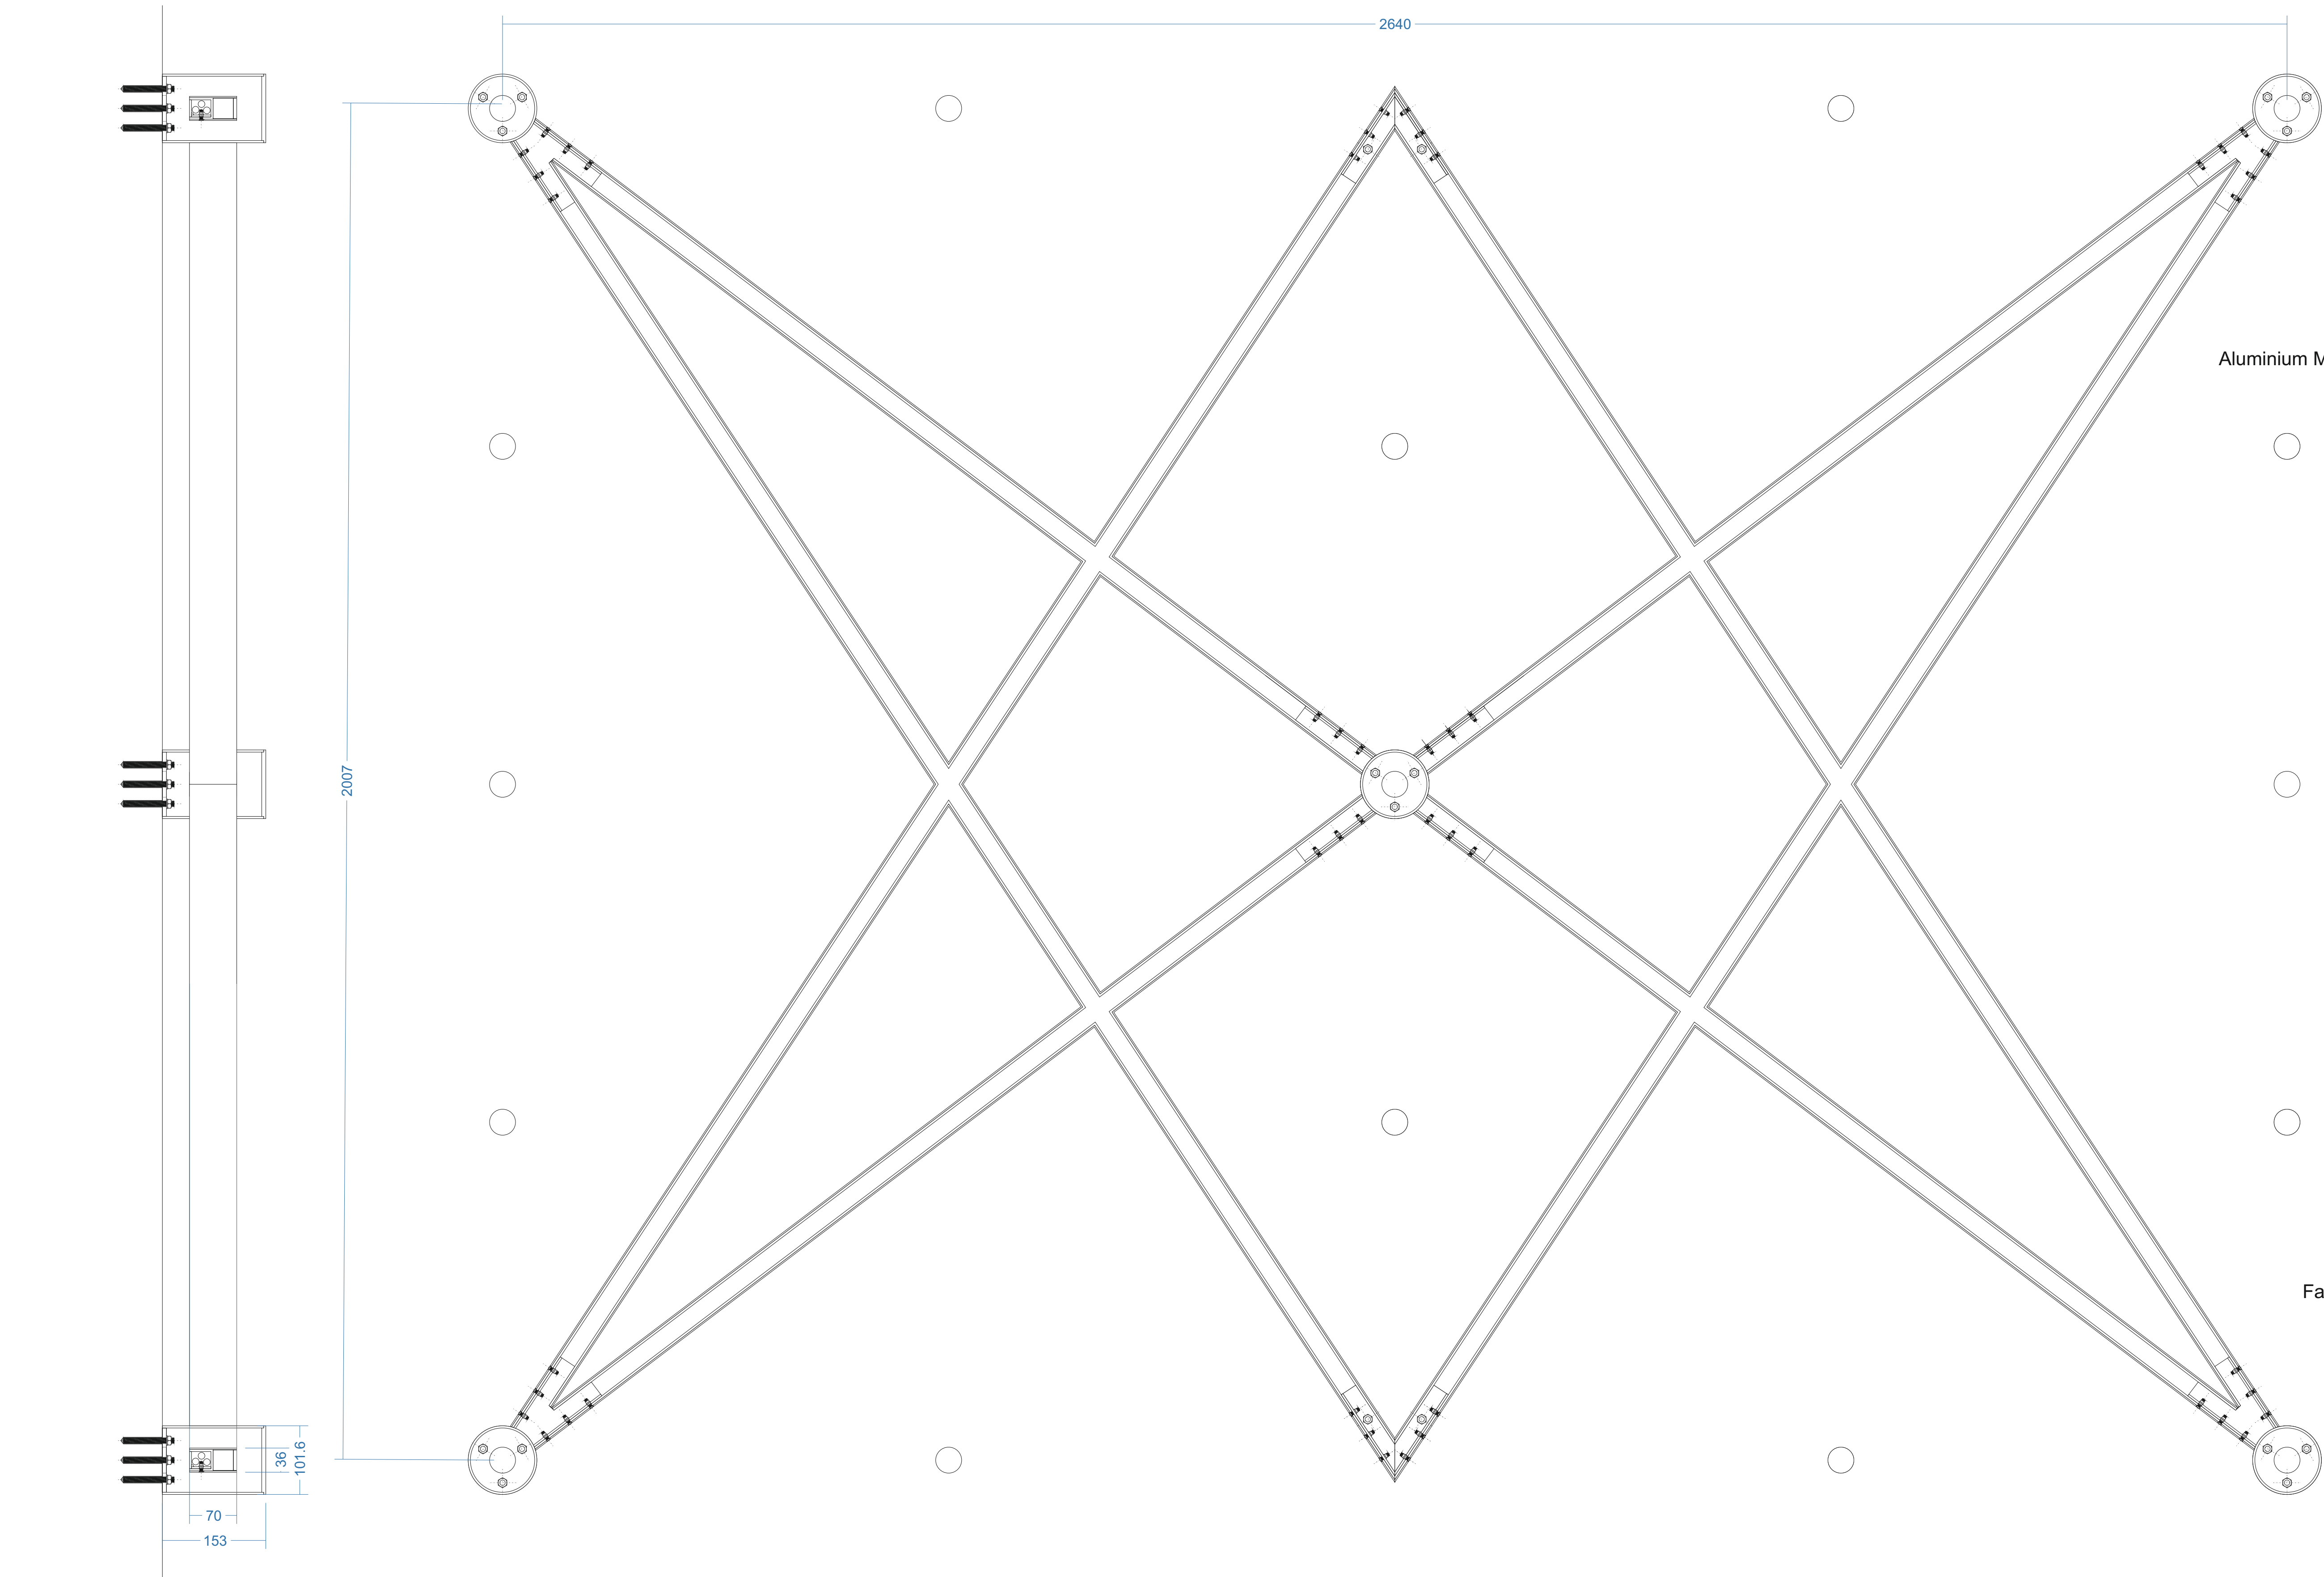


Typical Section
Scale 1:5 @ A0

Front Elevation
Scale 1:5 @ A0

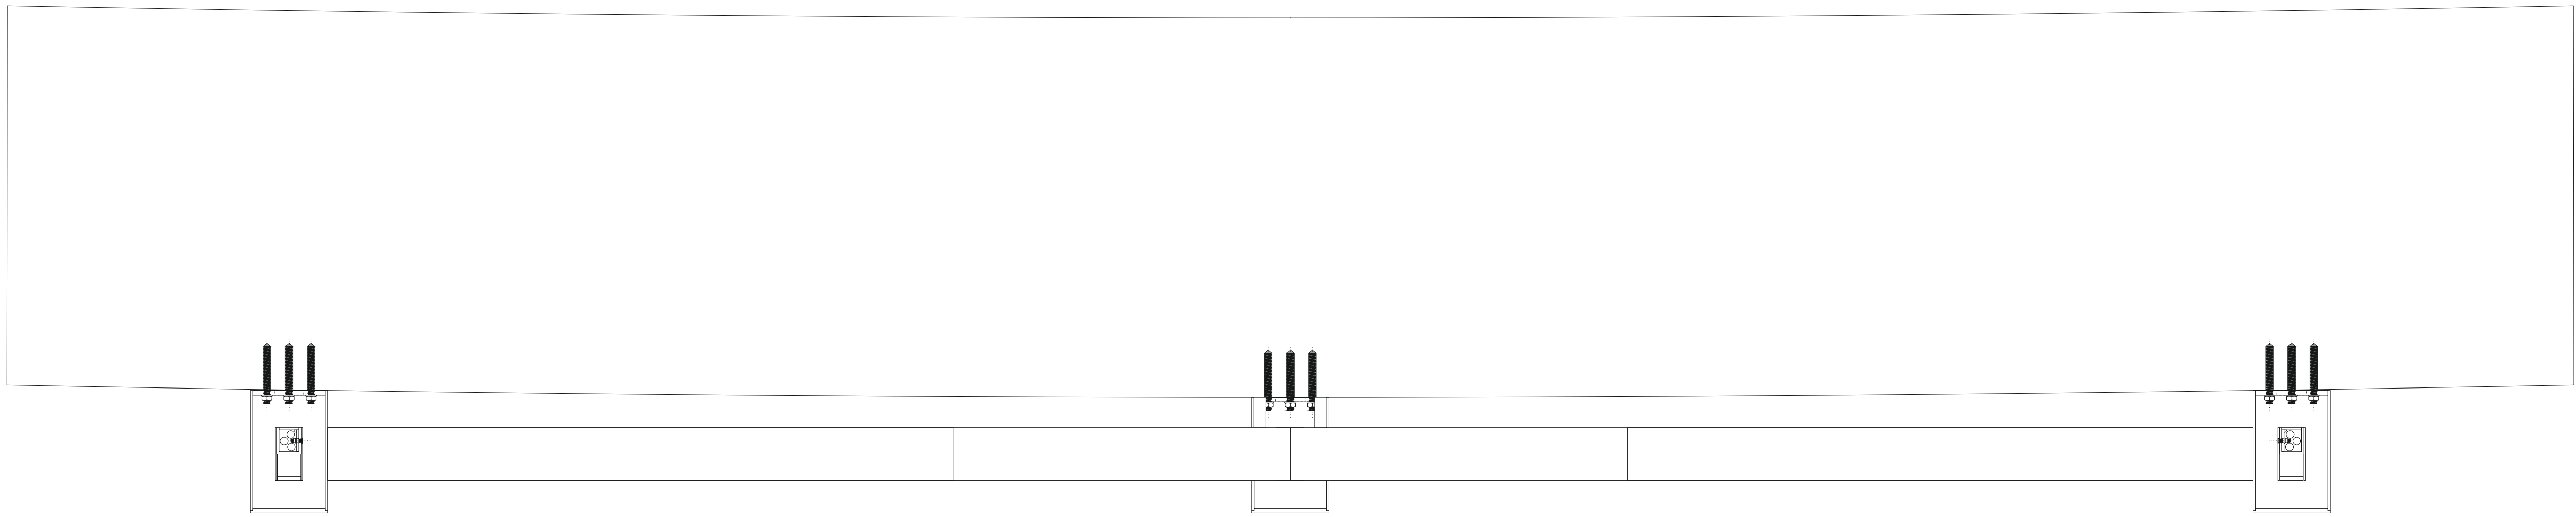

Plan View
Scale 1:10 @ A0

- 101.6 x 3.0mm Aluminium Knuckle Tube Finished Satin Black
- Welded 6.0mm Mounting Plate
- 6.0mm Rebated Black-White Secret Sign Acrylic Lense
- M8 Resin Anchors
- RGBW LED Strip Mounted Internally
- Extruded Aluminium Main Frame Finished Satin Black
- Bonded Aluminium Side Cheeks Finished Satin Black
- Aluminium Mounting Bracket Fully Welded To Knuckle Tube Finished Satin Black
- CNC Cut Sectional 30.0mm Thick Lumescense Light Source
- 5.0mm Thick Secret Sign Acrylic Face

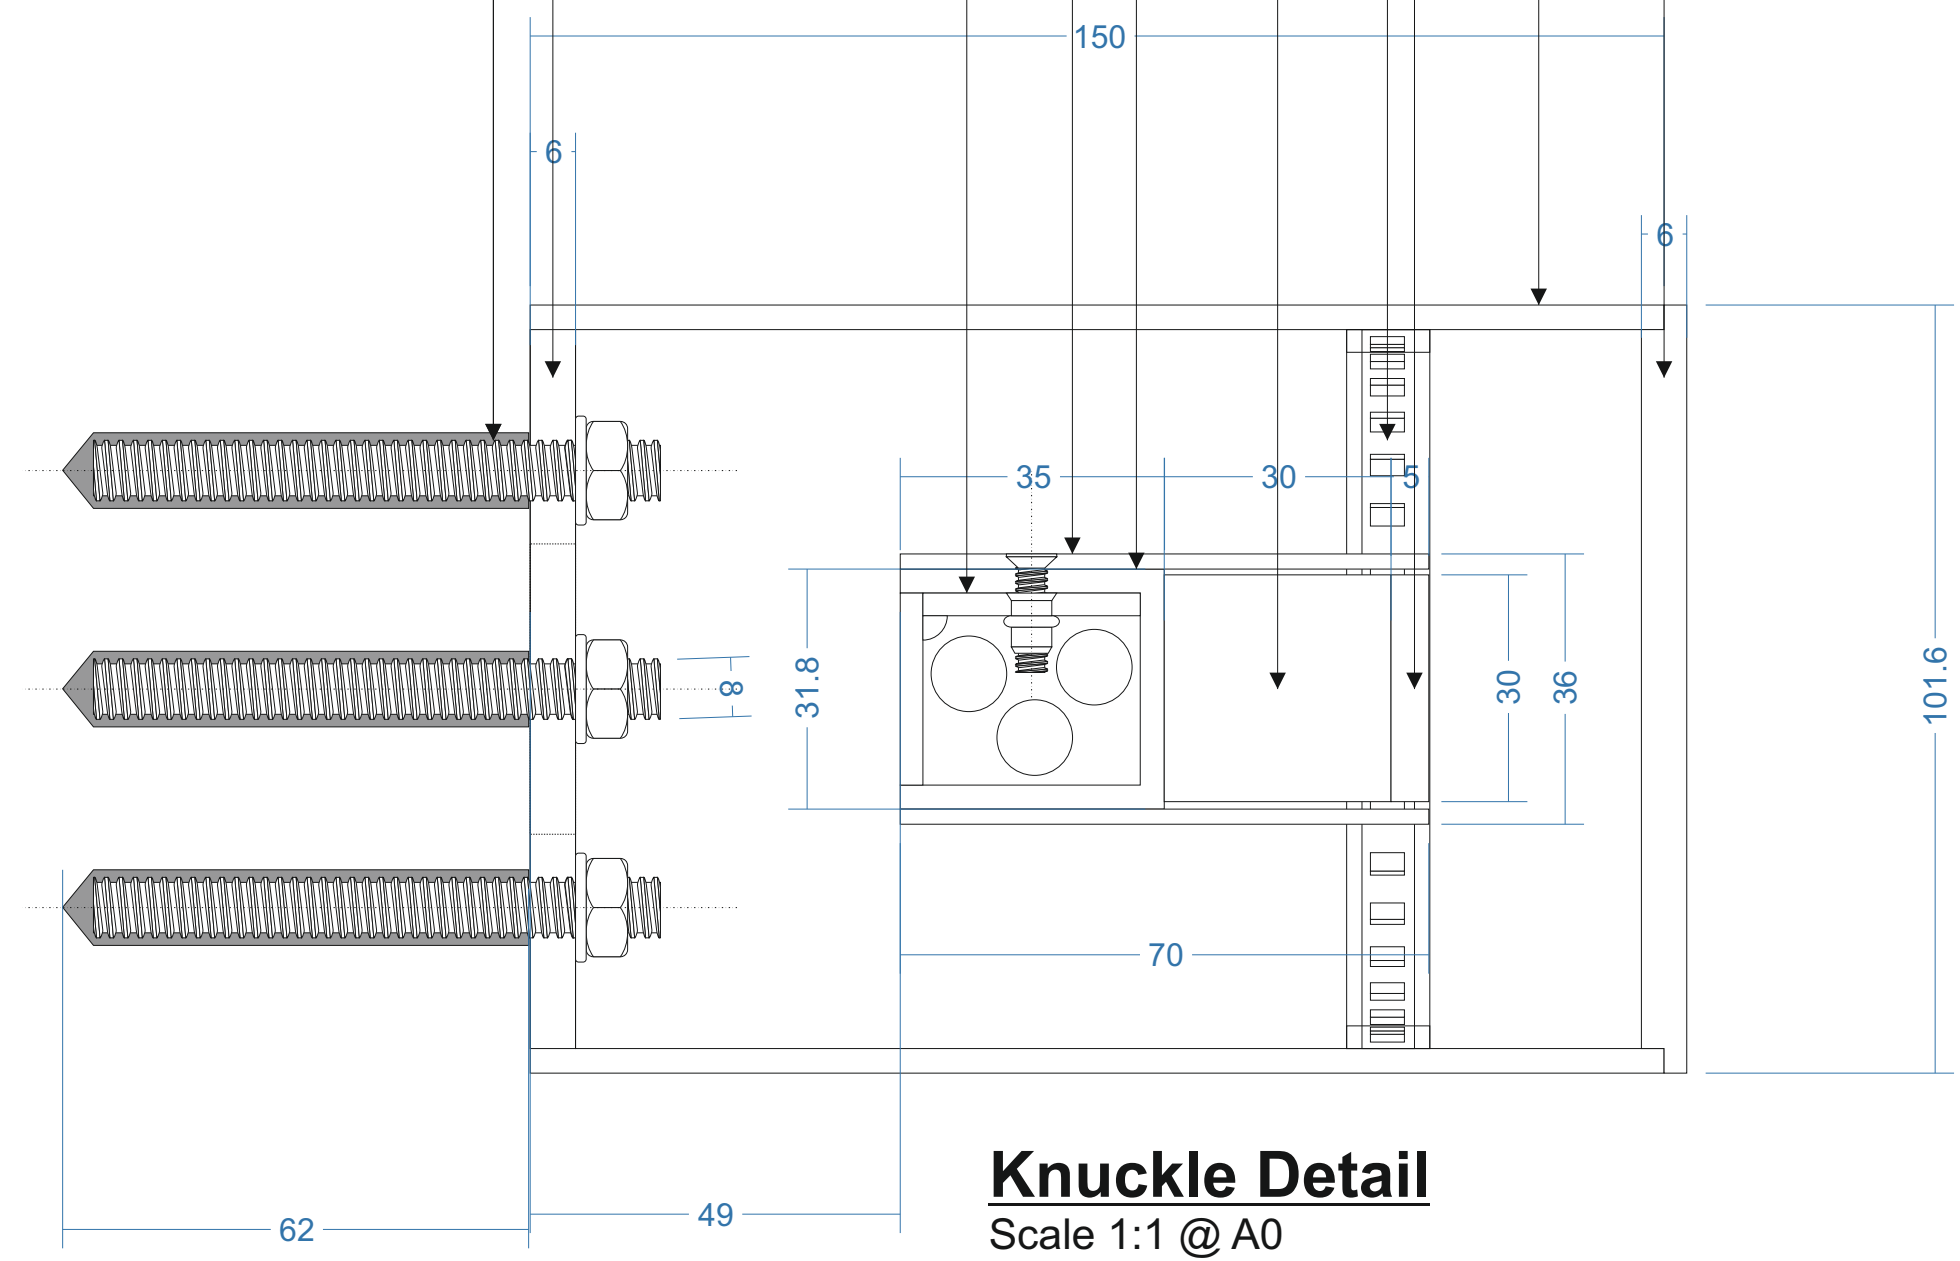

- 101.6 x 3.0mm Aluminium Knuckle Tube Finished Satin Black
- Welded 6.0mm Mounting Plate
- M8 Resin Anchors
- RGBW LED Strip Mounted Internally
- Fabricated Aluminium Mounting Bracket Fully Welded To Knuckle Tube

