


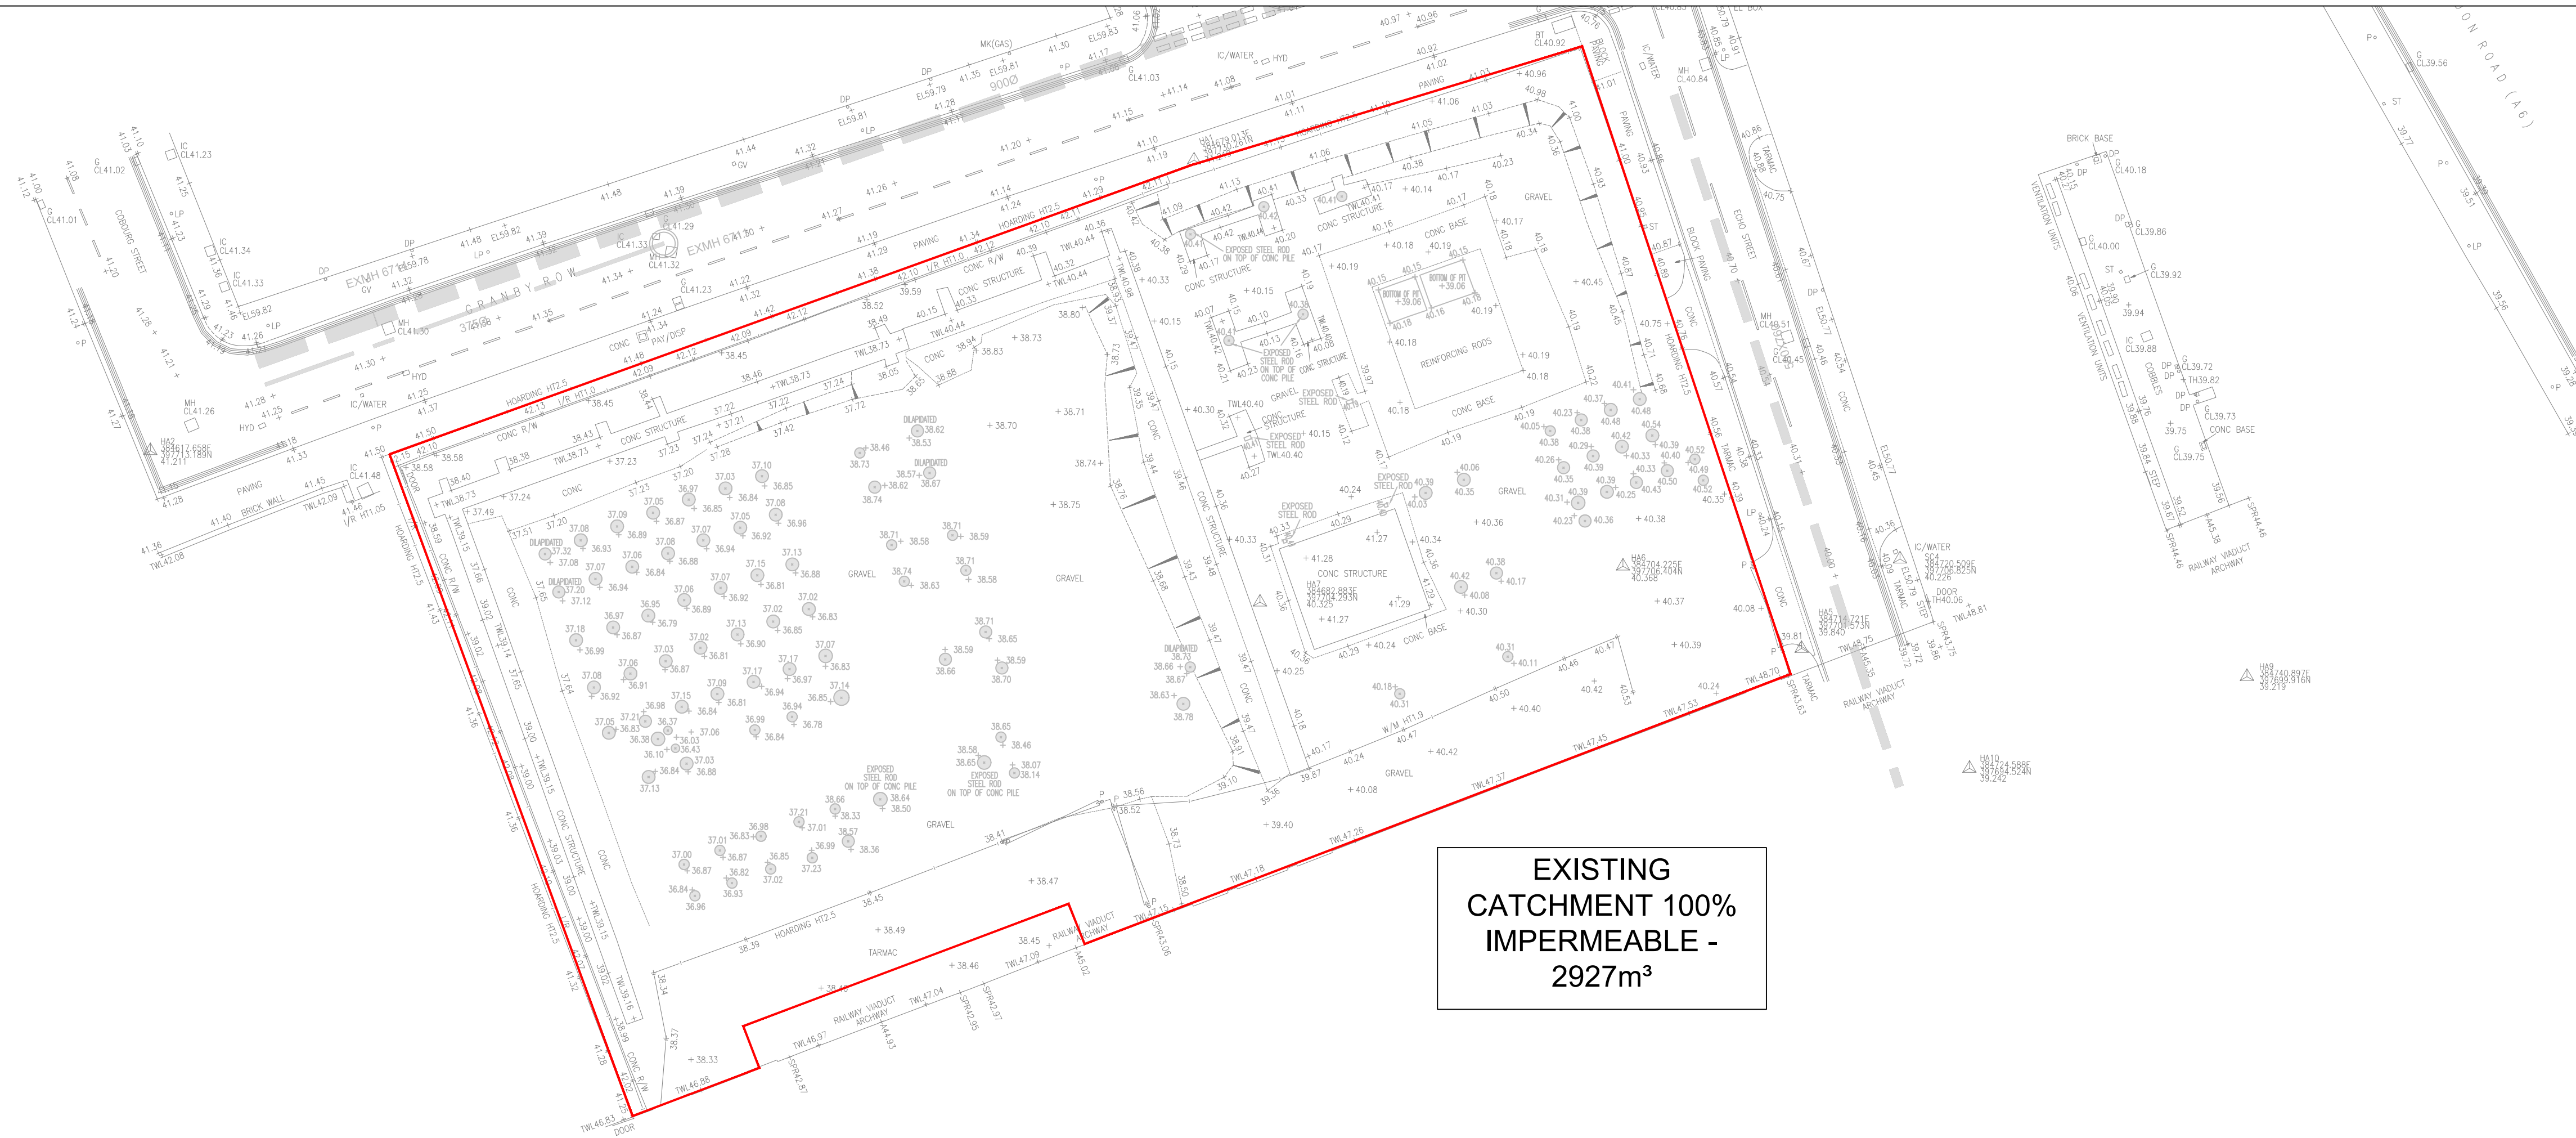


EXISTING
CATCHMENT 100%
IMPERMEABLE -
2927m³

- STANDARD NOTES
1. THIS DRAWING IS TO BE READ IN CONJUNCTION WITH ALL RELEVANT ARCHITECT'S AND ENGINEER'S DRAWINGS AND THE SPECIFICATIONS.
 2. THIS DRAWING SHOULD NOT BE SCALED.
 3. ALL DIMENSIONS ARE TO BE VERIFIED BY THE CONTRACTOR ON SITE.
 4. ALL DISCREPANCIES SHOULD BE REPORTED TO C.A./E.A. PRIOR TO THE COMMENCEMENT OF WORKS.

- © CIVIC ENGINEERS LIMITED
- KEY
- RED LINE BOUNDARY
 - RWP RAIN WATER PIPE
 - YG YARD GULLY
 - PROPOSED SURFACE WATER PIPE, 150mmØ UNLESS STATED OTHERWISE
 - PROPOSED SURFACE WATER BRANCH PIPE, 100mmØ UNLESS STATED OTHERWISE
 - PROPOSED SURFACE WATER INSPECTION CHAMBER
 - EXISTING COMBINED DRAINAGE TO BE RETAINED
 - ACO OUTLET SUMP UNIT
 - CHANNEL DRAIN
 - PERMEABLE PAVING WITH TYPE 3 SUB BASE PROVIDING ATTENUATION
 - SD SURFACE WATER BACKDROP
 - RAINWATER HARVESTING TANK
 - ACO MULTIDRAIN PPD - M100PPD 0.0J - WITH 1% SLOPE
 - THRESHOLD DRAINS
 - THRESHOLD OUTLET SUMP UNIT

FILE LOCATION PATH: P:\PROJECTS\HOT\2925-CIV-XX-XX-D-C-30002 - DRAINAGE LAYOUT CATCHMENT PLAN.DWG

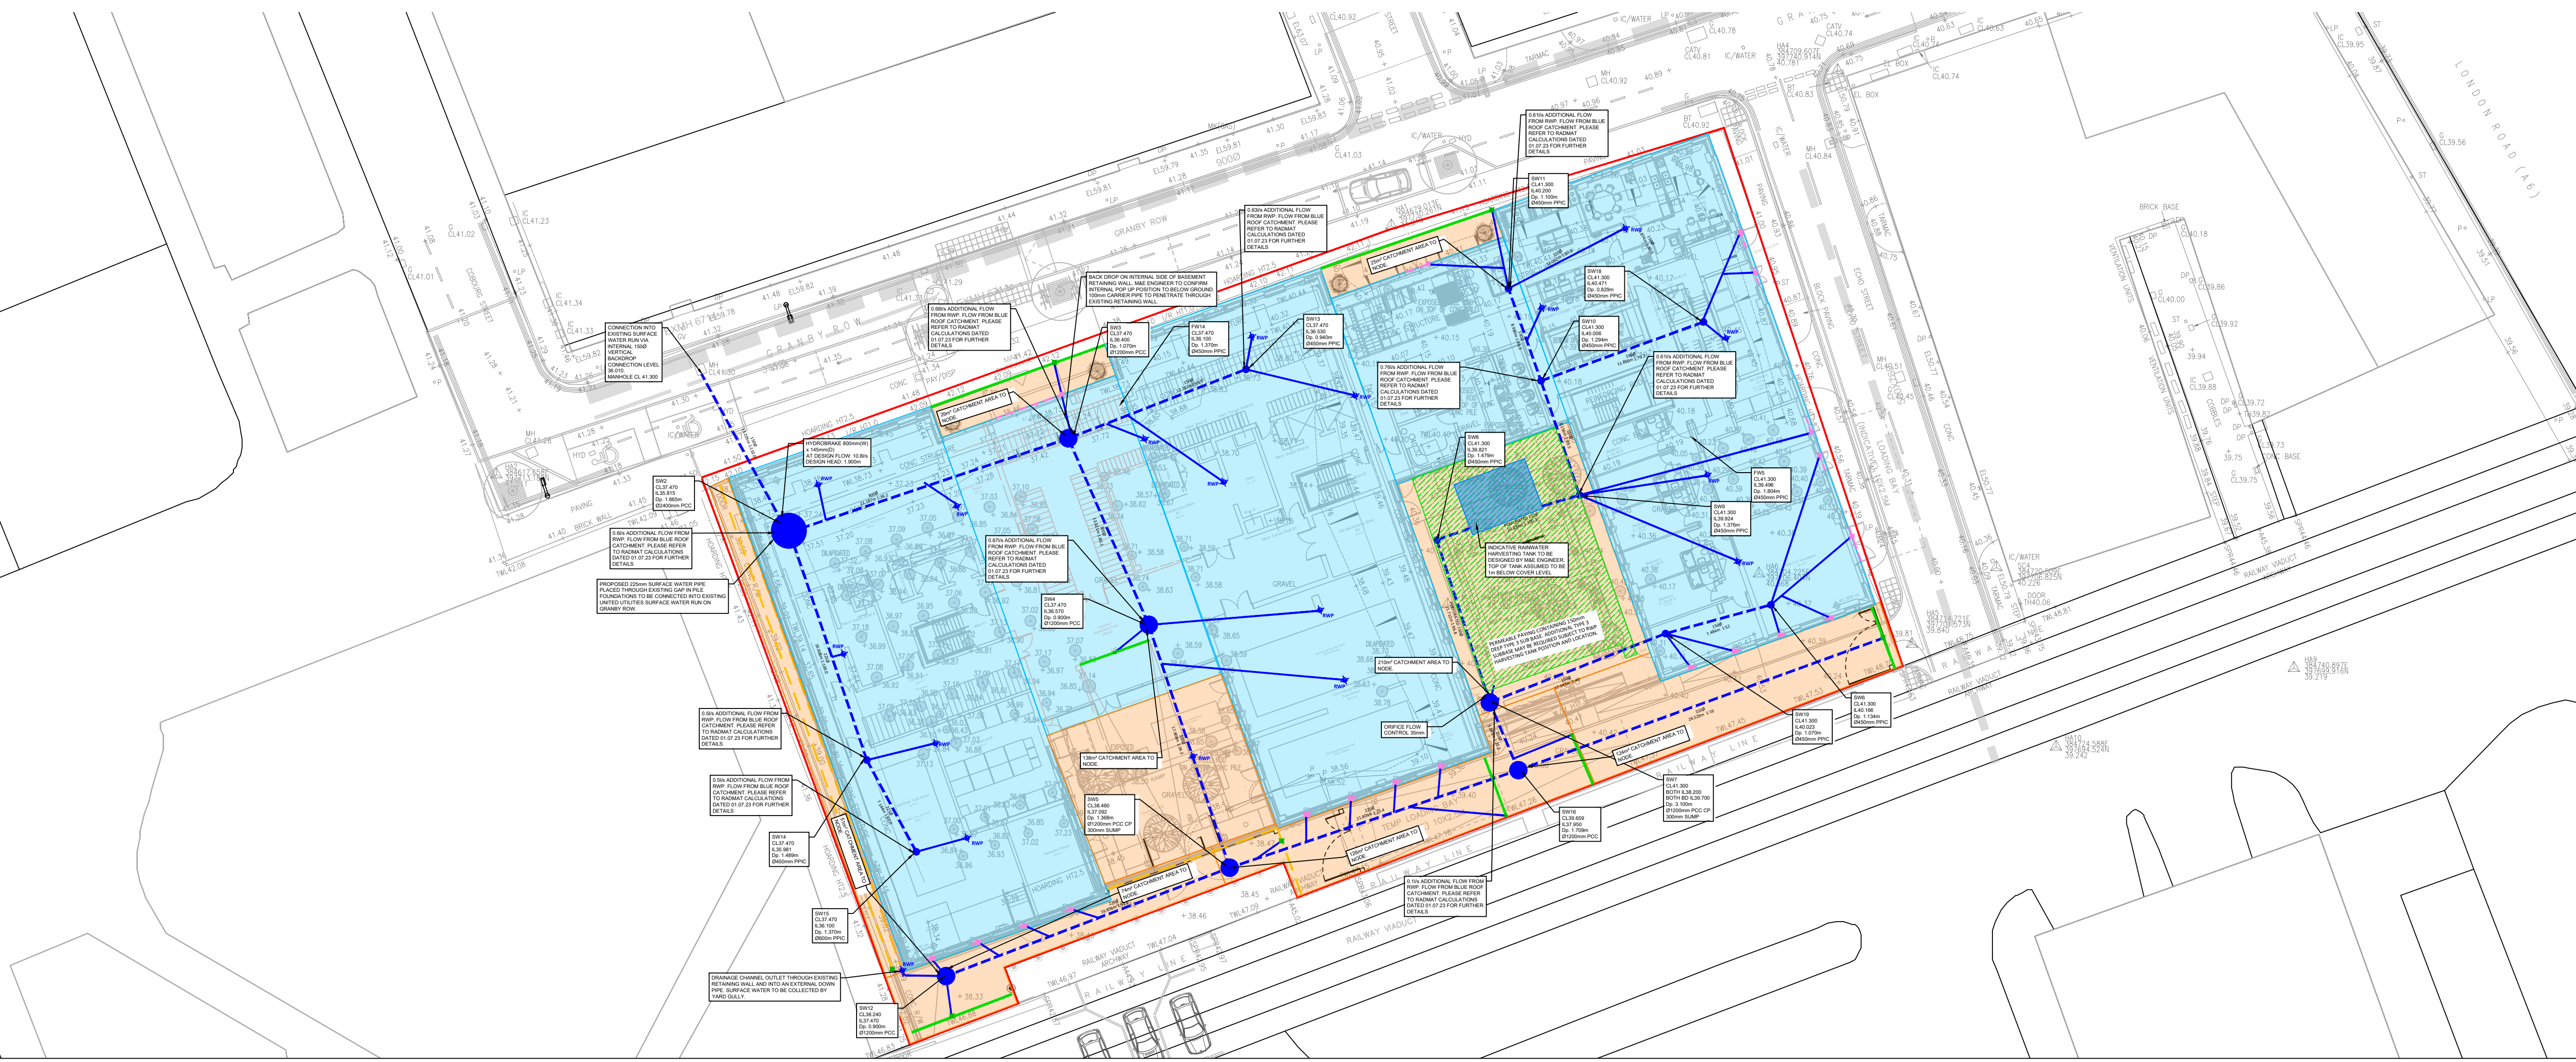

25.09.23	P01	ISSUED FOR INFORMATION	TC	CK
DATE	REV	DESCRIPTION	DRAWN	CHKD
<div><div><div></div></div><div>Civic Engineers</div></div> <div><div>MANCHESTER</div><div>LONDON</div><div>LEEDS</div><div>GLASGOW</div></div> <div><div>Civic's Warehouse, 77 Dale Street, Manchester, M1 2HG. Tel: 0161 228 6703</div><div>Reeds Wharf, 33 Mill Street, London SE1 2AA. Tel: 020 7233 2977</div><div>1 Saw Mill Street, Winter Lane, Leeds, LS11 5WE. Tel: 0113 2025 130</div><div>25 Virginia Street, Glasgow, G2 7TH. Tel: 0143 370 1809</div></div> <div>www.civicingineers.com</div>				
PROJECT				
ECHO STREET				
TITLE				
EX & PROPOSED SW CATCHMENT GA				
DRAWING STATUS				STATUS CODE
INFORMATION				-
CE PROJECT No.	SCALE @ A1	DATE CREATED	DRAWN	CHECKED
2925	1:200	AUG'23	BW	CK
DRAWING No.				REV
2925-CIV-XX-XX-D-C-30002				P01