



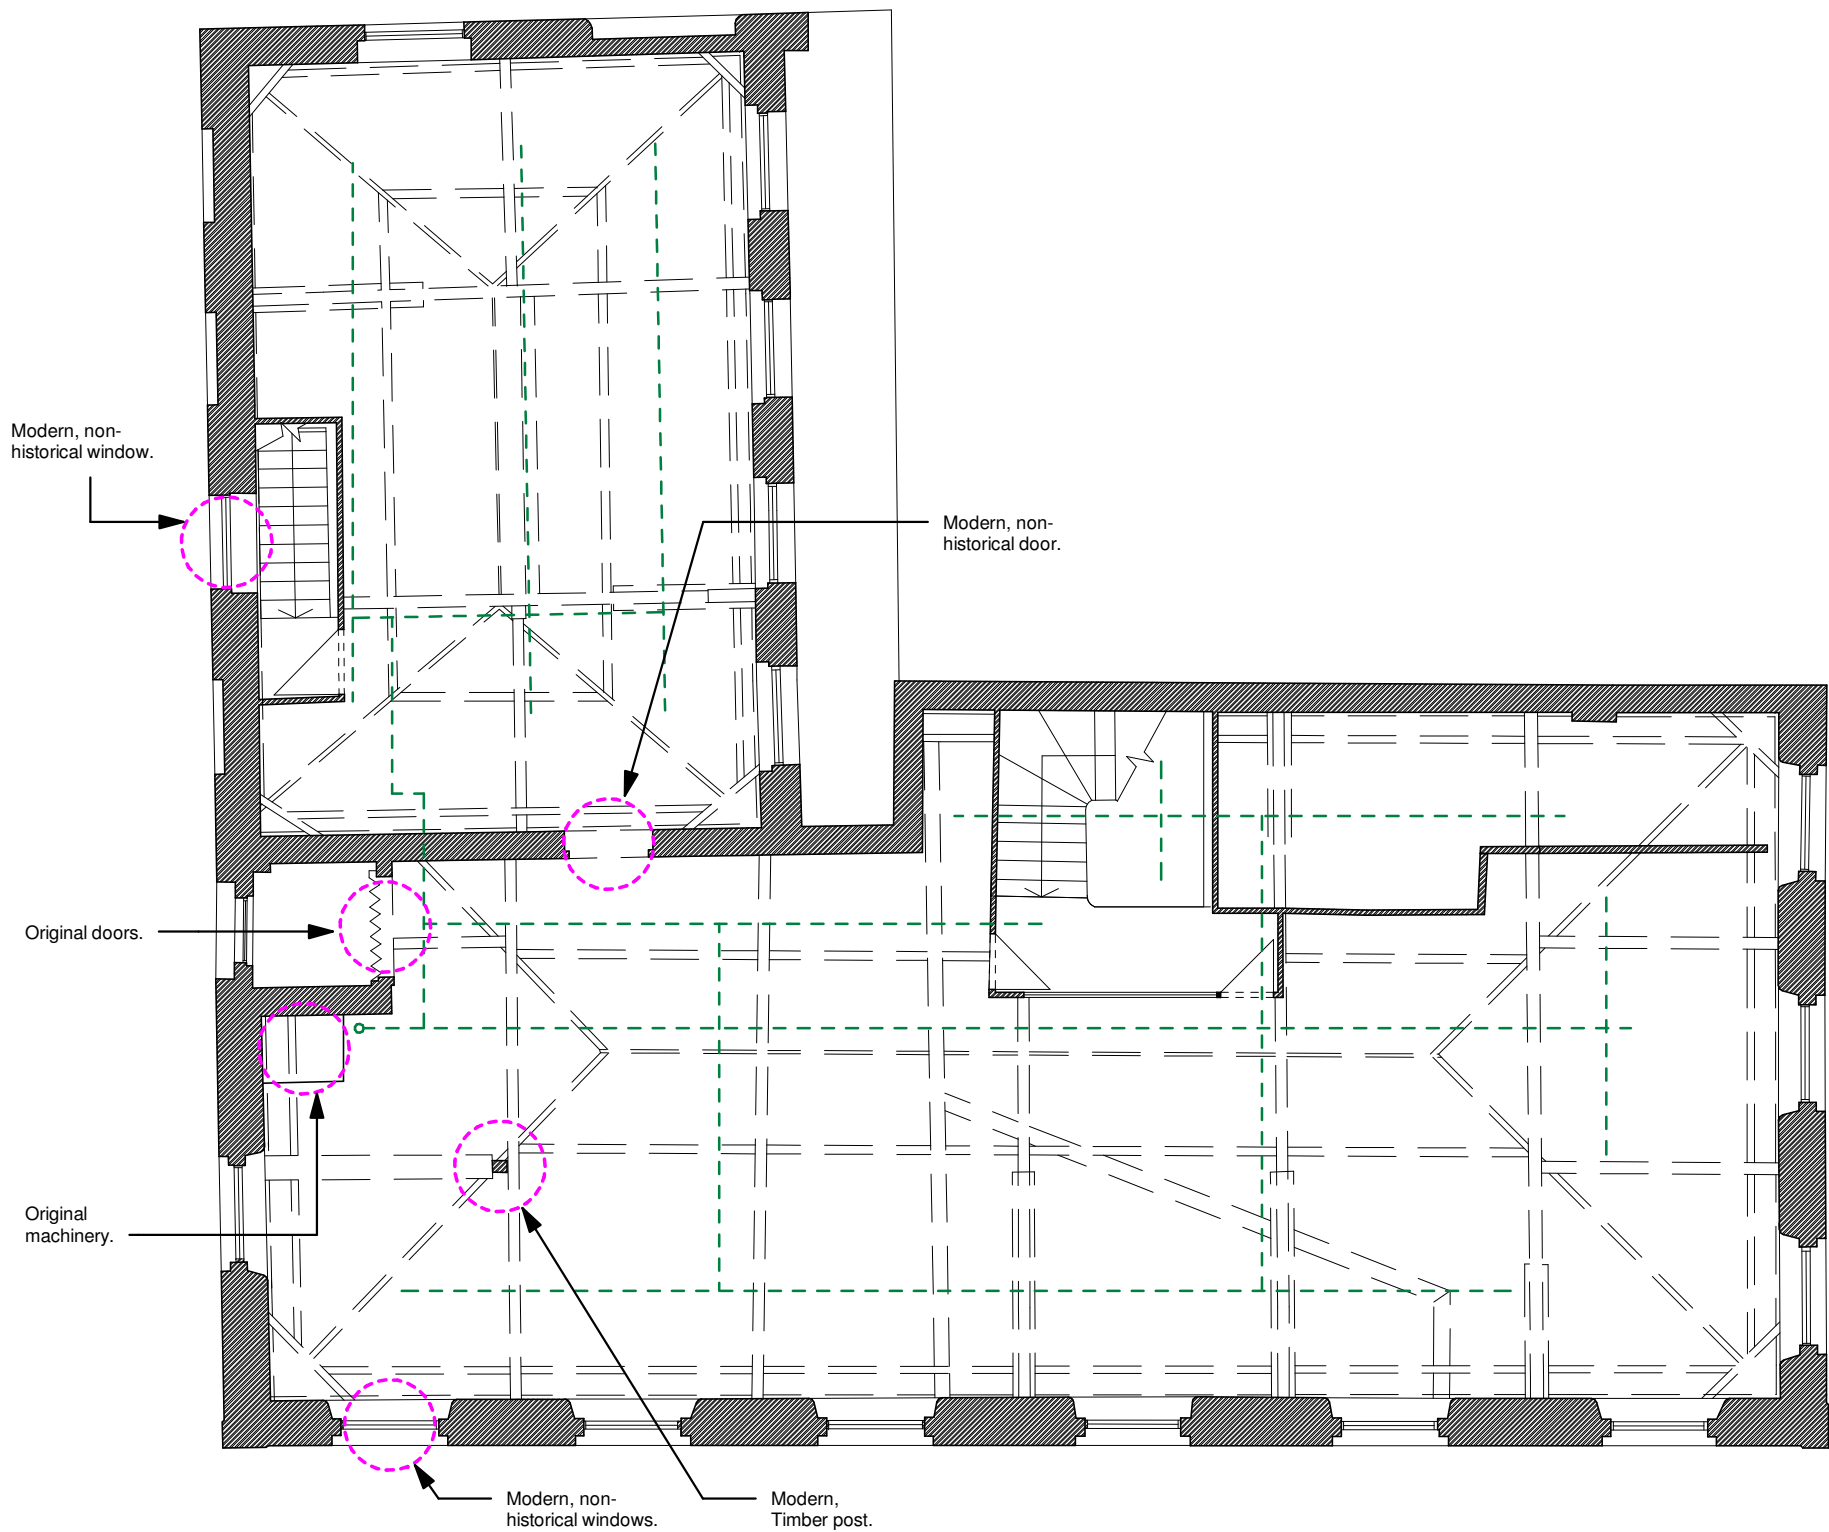

Existing 4th Floor Plan

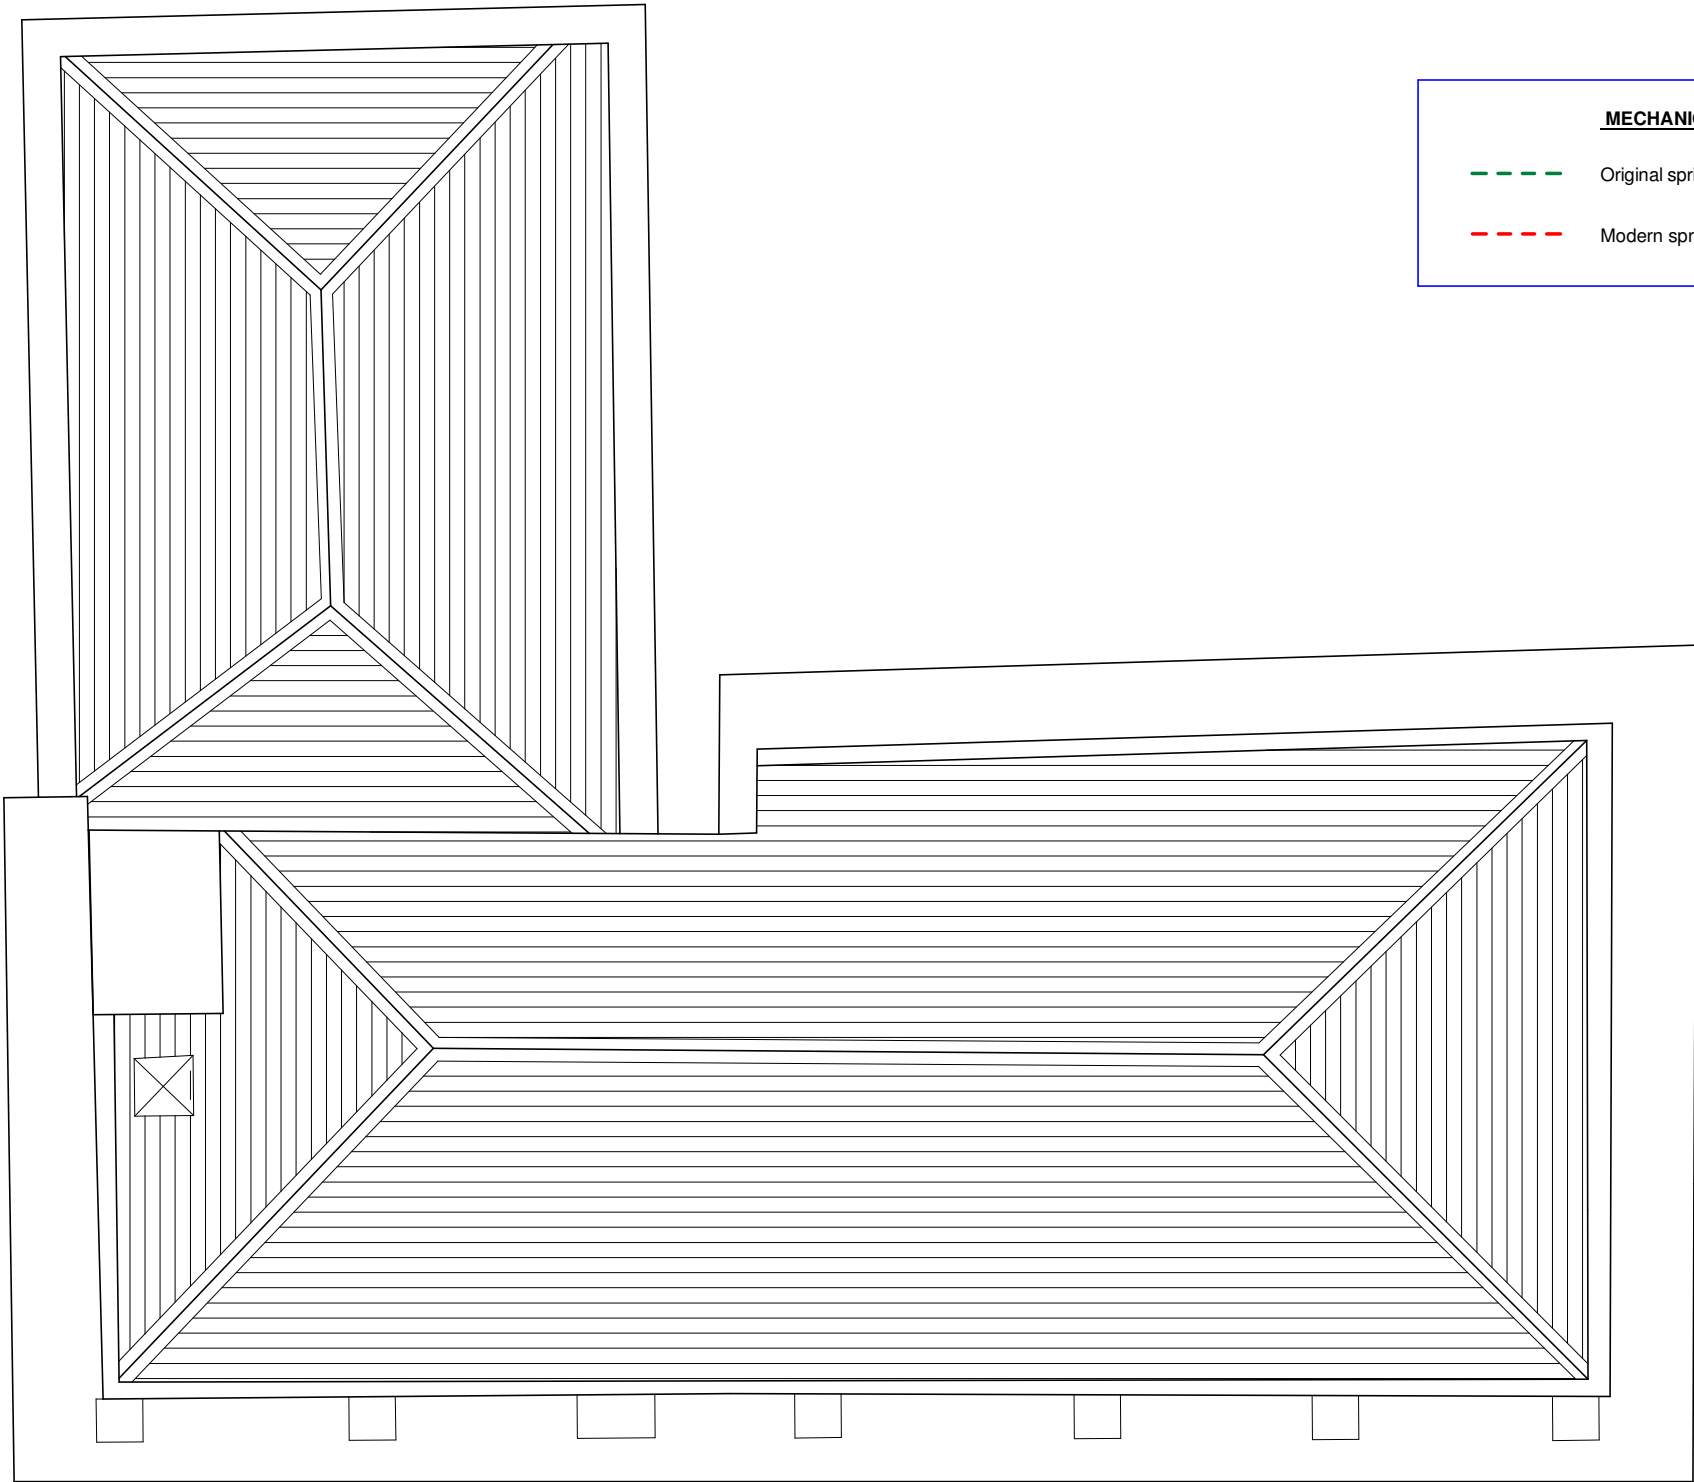

MECHANICAL KEY

--- Original sprinkler system mains.

--- Modern sprinkler system mains.

Existing Roof Plan

PARKdesigned
architects

Leeds: The Loft,13 Carlton Mills, Armley, LS12 2QG		Tel: 0113 819 8057
London: Hamilton House, Mabledon Place, Bloomsbury, WC1H 9BB		E-mail: info@parkdesigned.com
Client:	Date:	Scale:
T&M Investment	March 2022	As indicated A1
Project Name:	Drawn:	Reviewed:
34 Charlotte Street	JAH	JAH
Drawing Title:	Drawing No:	Revision:
Existing Plans - Sheet 3	022	B
Drawing Status:	Project No:	
Preliminary	2022.04	