





Section A-A (Existing View)
Scale - 1:100

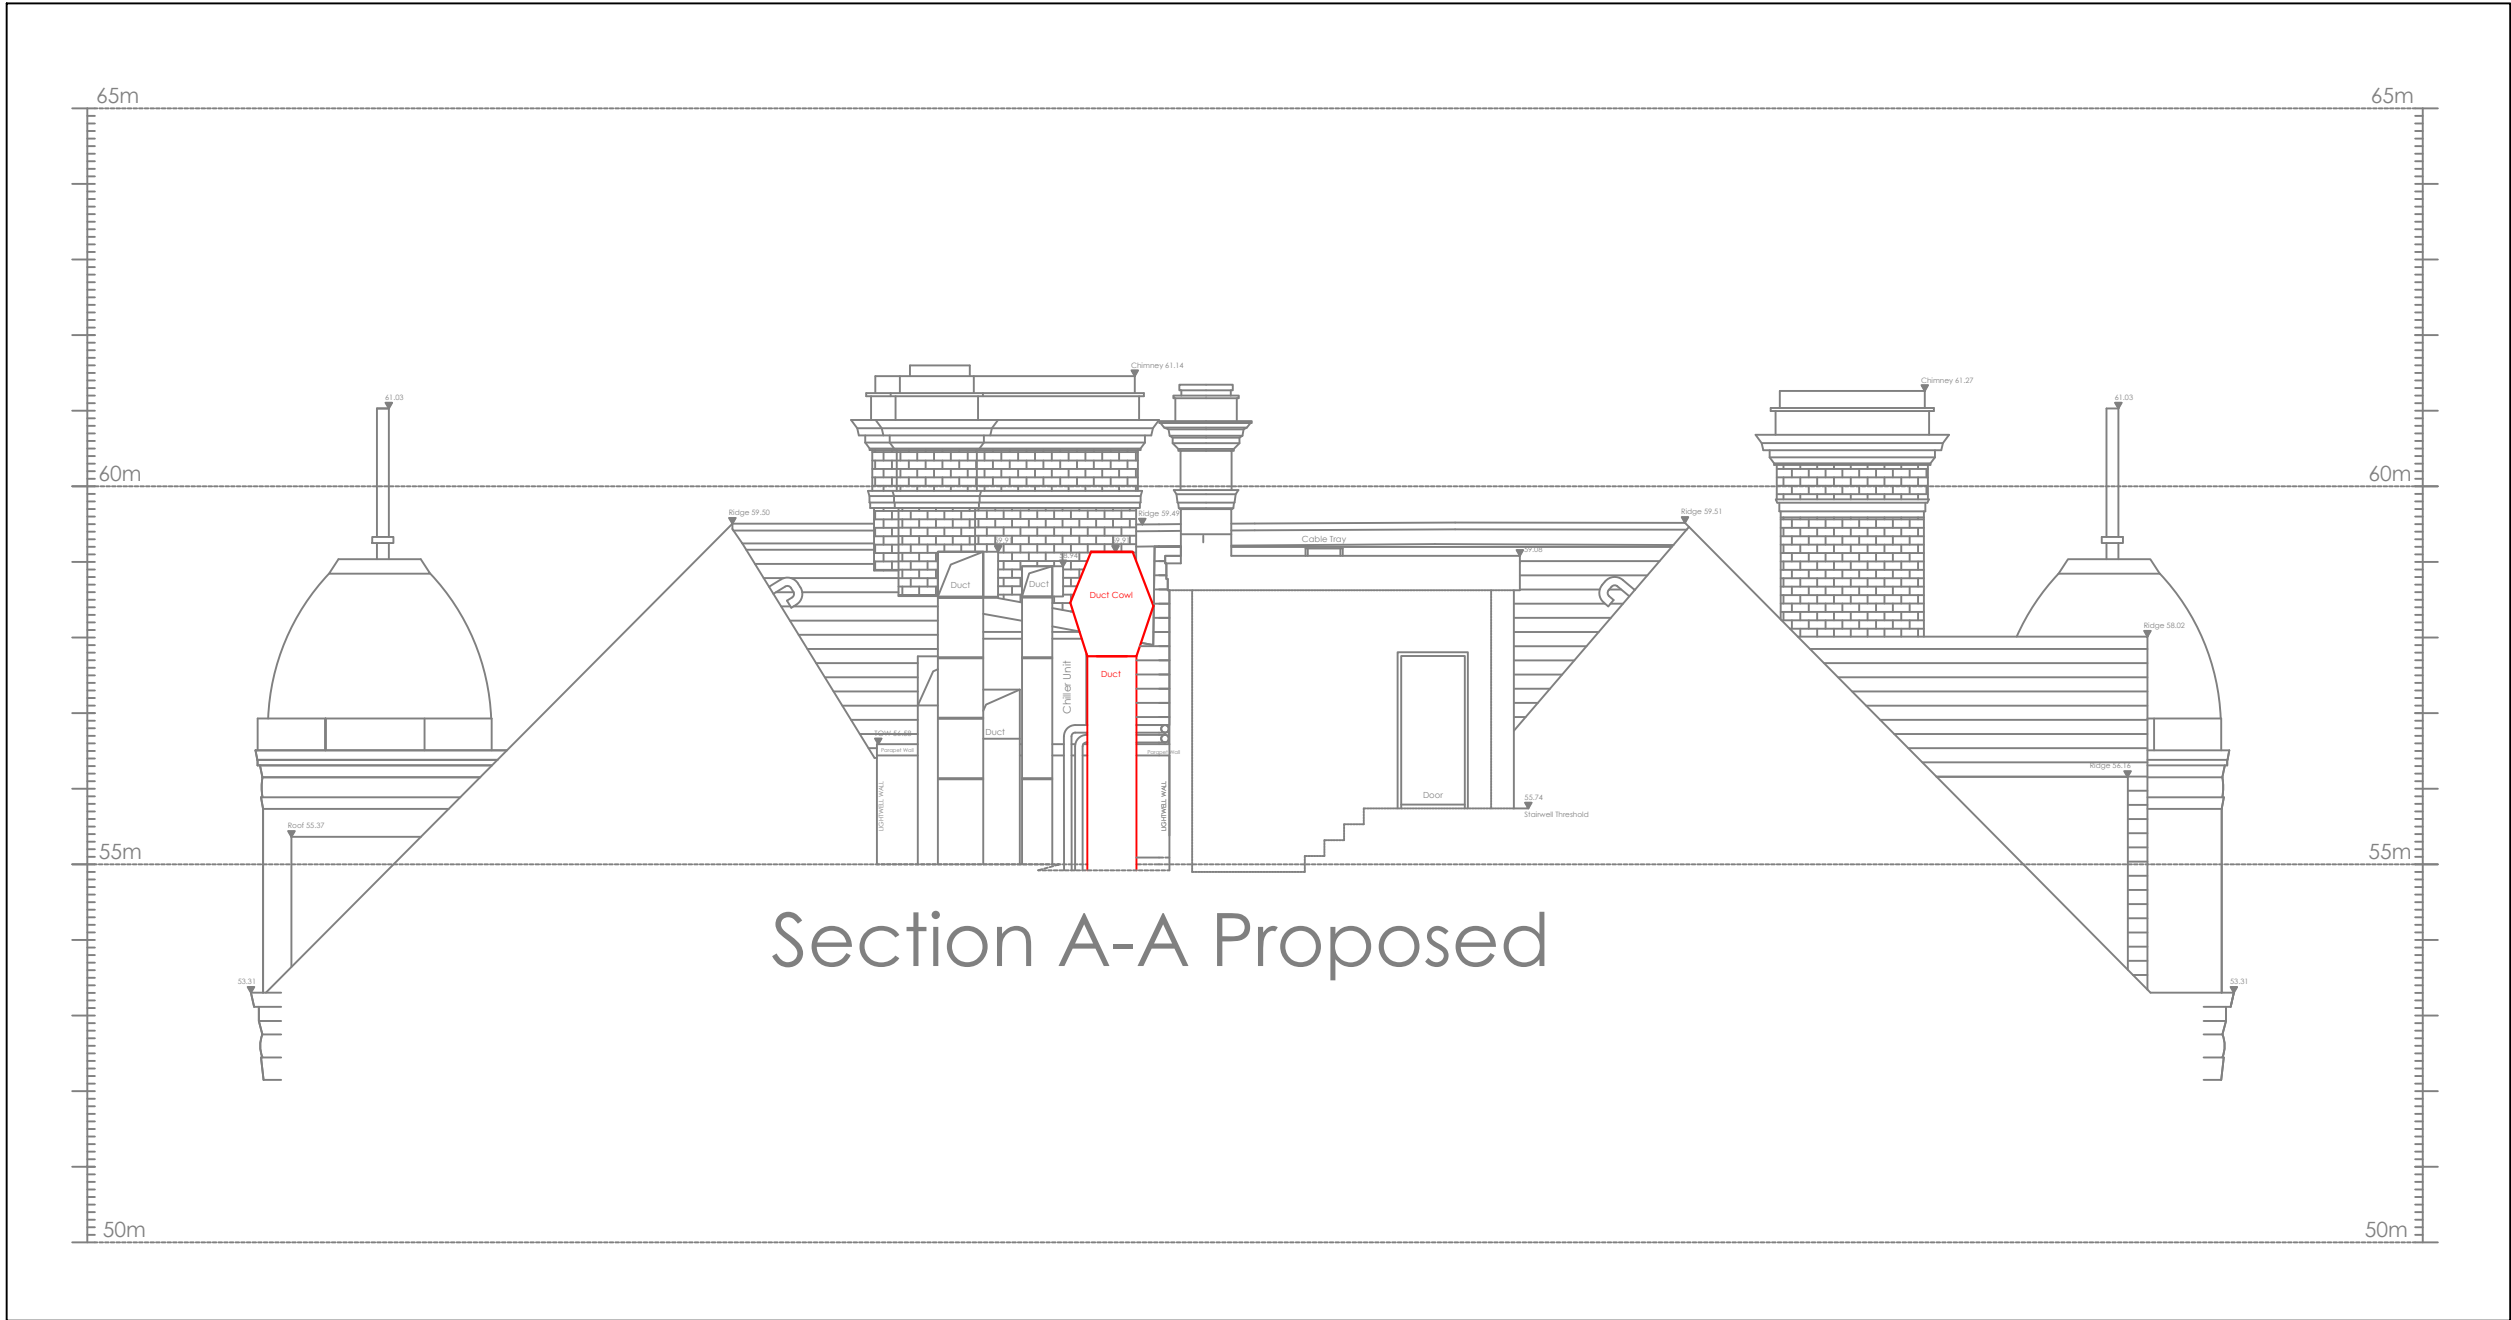

Section A-A (Proposed View)
Scale - 1:100

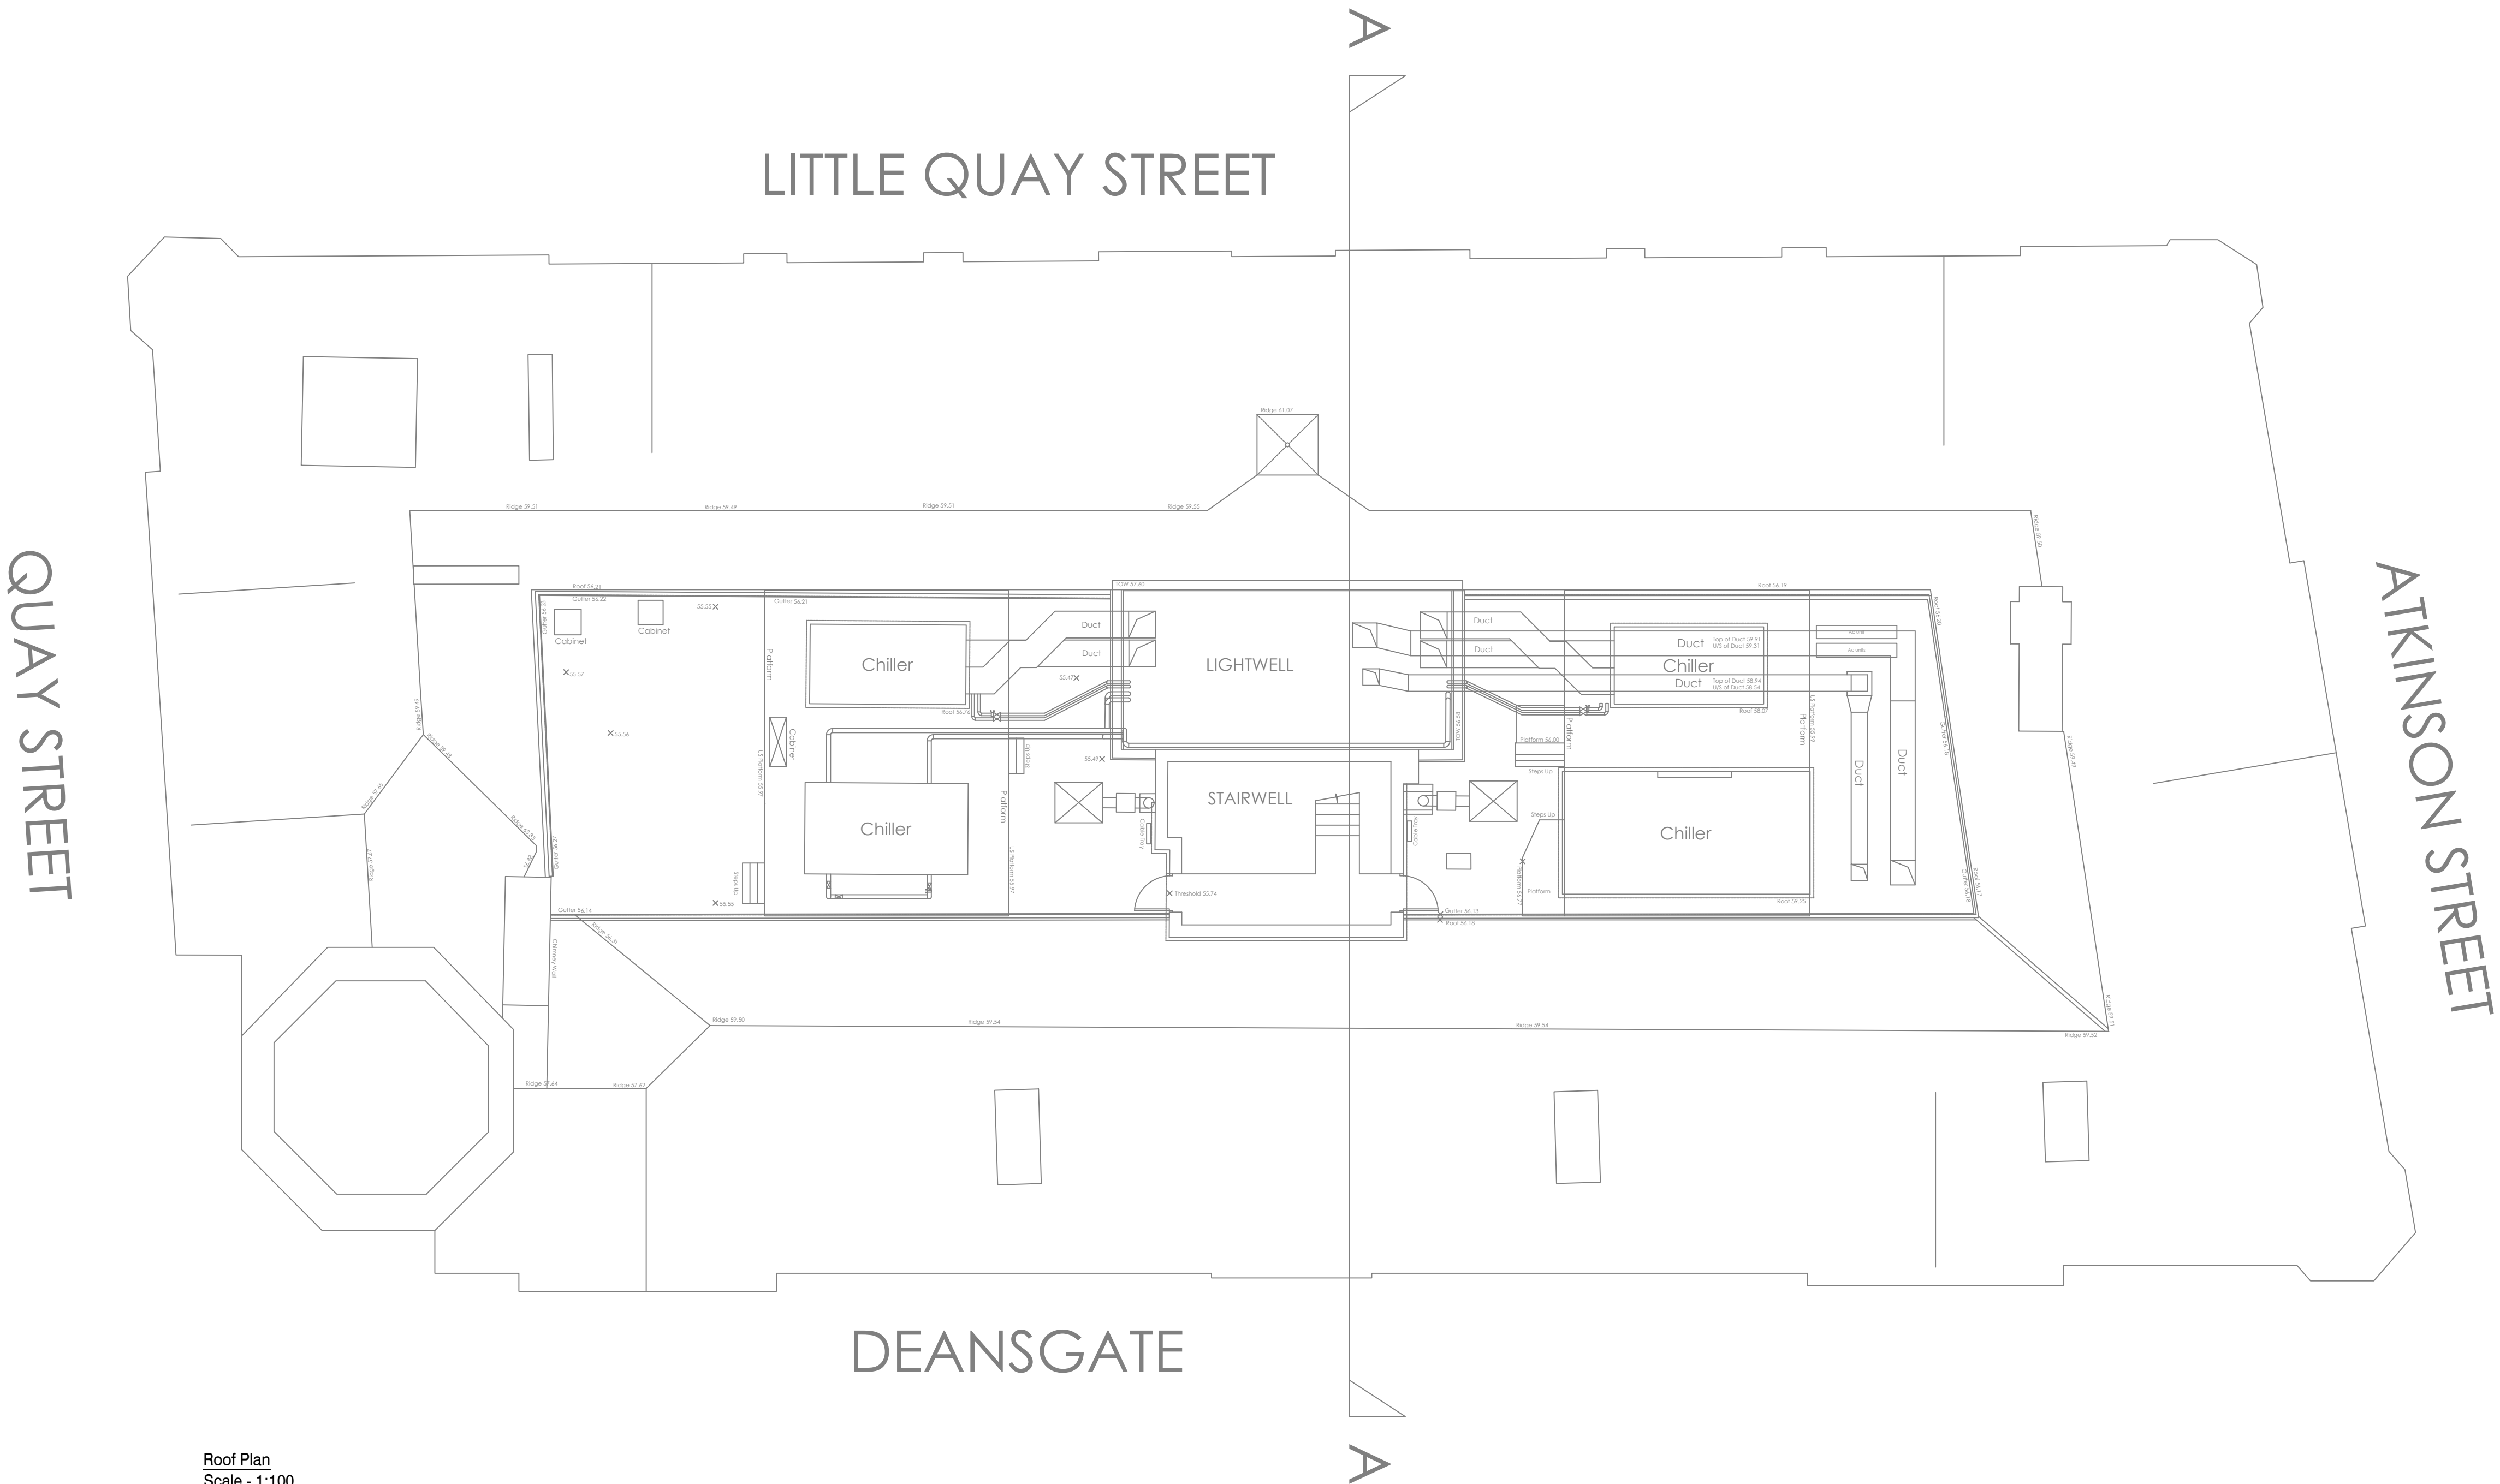

Roof Plan
Scale - 1:100

© This drawing and its contents
are strictly the copyright of GLD



Certificate Number 16602-Q15-001
ISO 9001

GENERAL NOTES

1. Drawings are to be read in conjunction with all relevant specifications, engineers, architects & services drawings, including approved builders work drawings. Contractor to notify engineer of discrepancies between structural drawings & specifications or other drawings.
2. All dimensions are in millimeters unless noted otherwise.
3. Do not scale from the drawings or the computer digital data, only figured dimensions are to be used.

LEGEND

— New Extract Air Duct

P1	07.08.23	Preliminary Issue	IR/JW	GD
Rev:	Date:	Amendment:	Drawn:	Check:
Drwn:	IR	Date:	07.08.2023	Scale: 1:100 @ A1
Chkd:	GD	Date:	27.03.2023	XRef: ROOF-01 & 02 PG

Client:
CEG
Number One, Great Exhibition Way,
Kirkstall Forge,
LS5 3BF

Project Title:
200-204 Deansgate Building
200 Deansgate, Manchester M3 3NN

Drawing Title:
Flat Iron
Kitchen Extract Ventilation System
Proposed new Kitchen Extract Roof Layout

Status:
FOR INFORMATION



Domhouse, Astley Hall Drive
Astley, Manchester, M29 7TX
W: www.gldtechnicalconsulting.co.uk
T: 01942889535 / 01616417097

Drawing No:
J304-GLD-00-DR-EM-5700-004

Rev:
P1