


FLIE ALA M		E N T I N	
FLA	FLIE ALA M ANEL		
○	ANAL E T I AL M KE ETE T		
⊗	M KE ETE T	N E	
⊗	M KE ETE T	N E	EA N
⊗	HEAT ETE T		
⊗	HEAT ETE T	N E	
⊗	HEAT ETE T	N E	EA N
○	MAN AL AL INT		
□	A E A LE IN LE HANNEEL DELAY		
⋮	N E	EA N	
⊗	EEFL E ALA M ANEL		

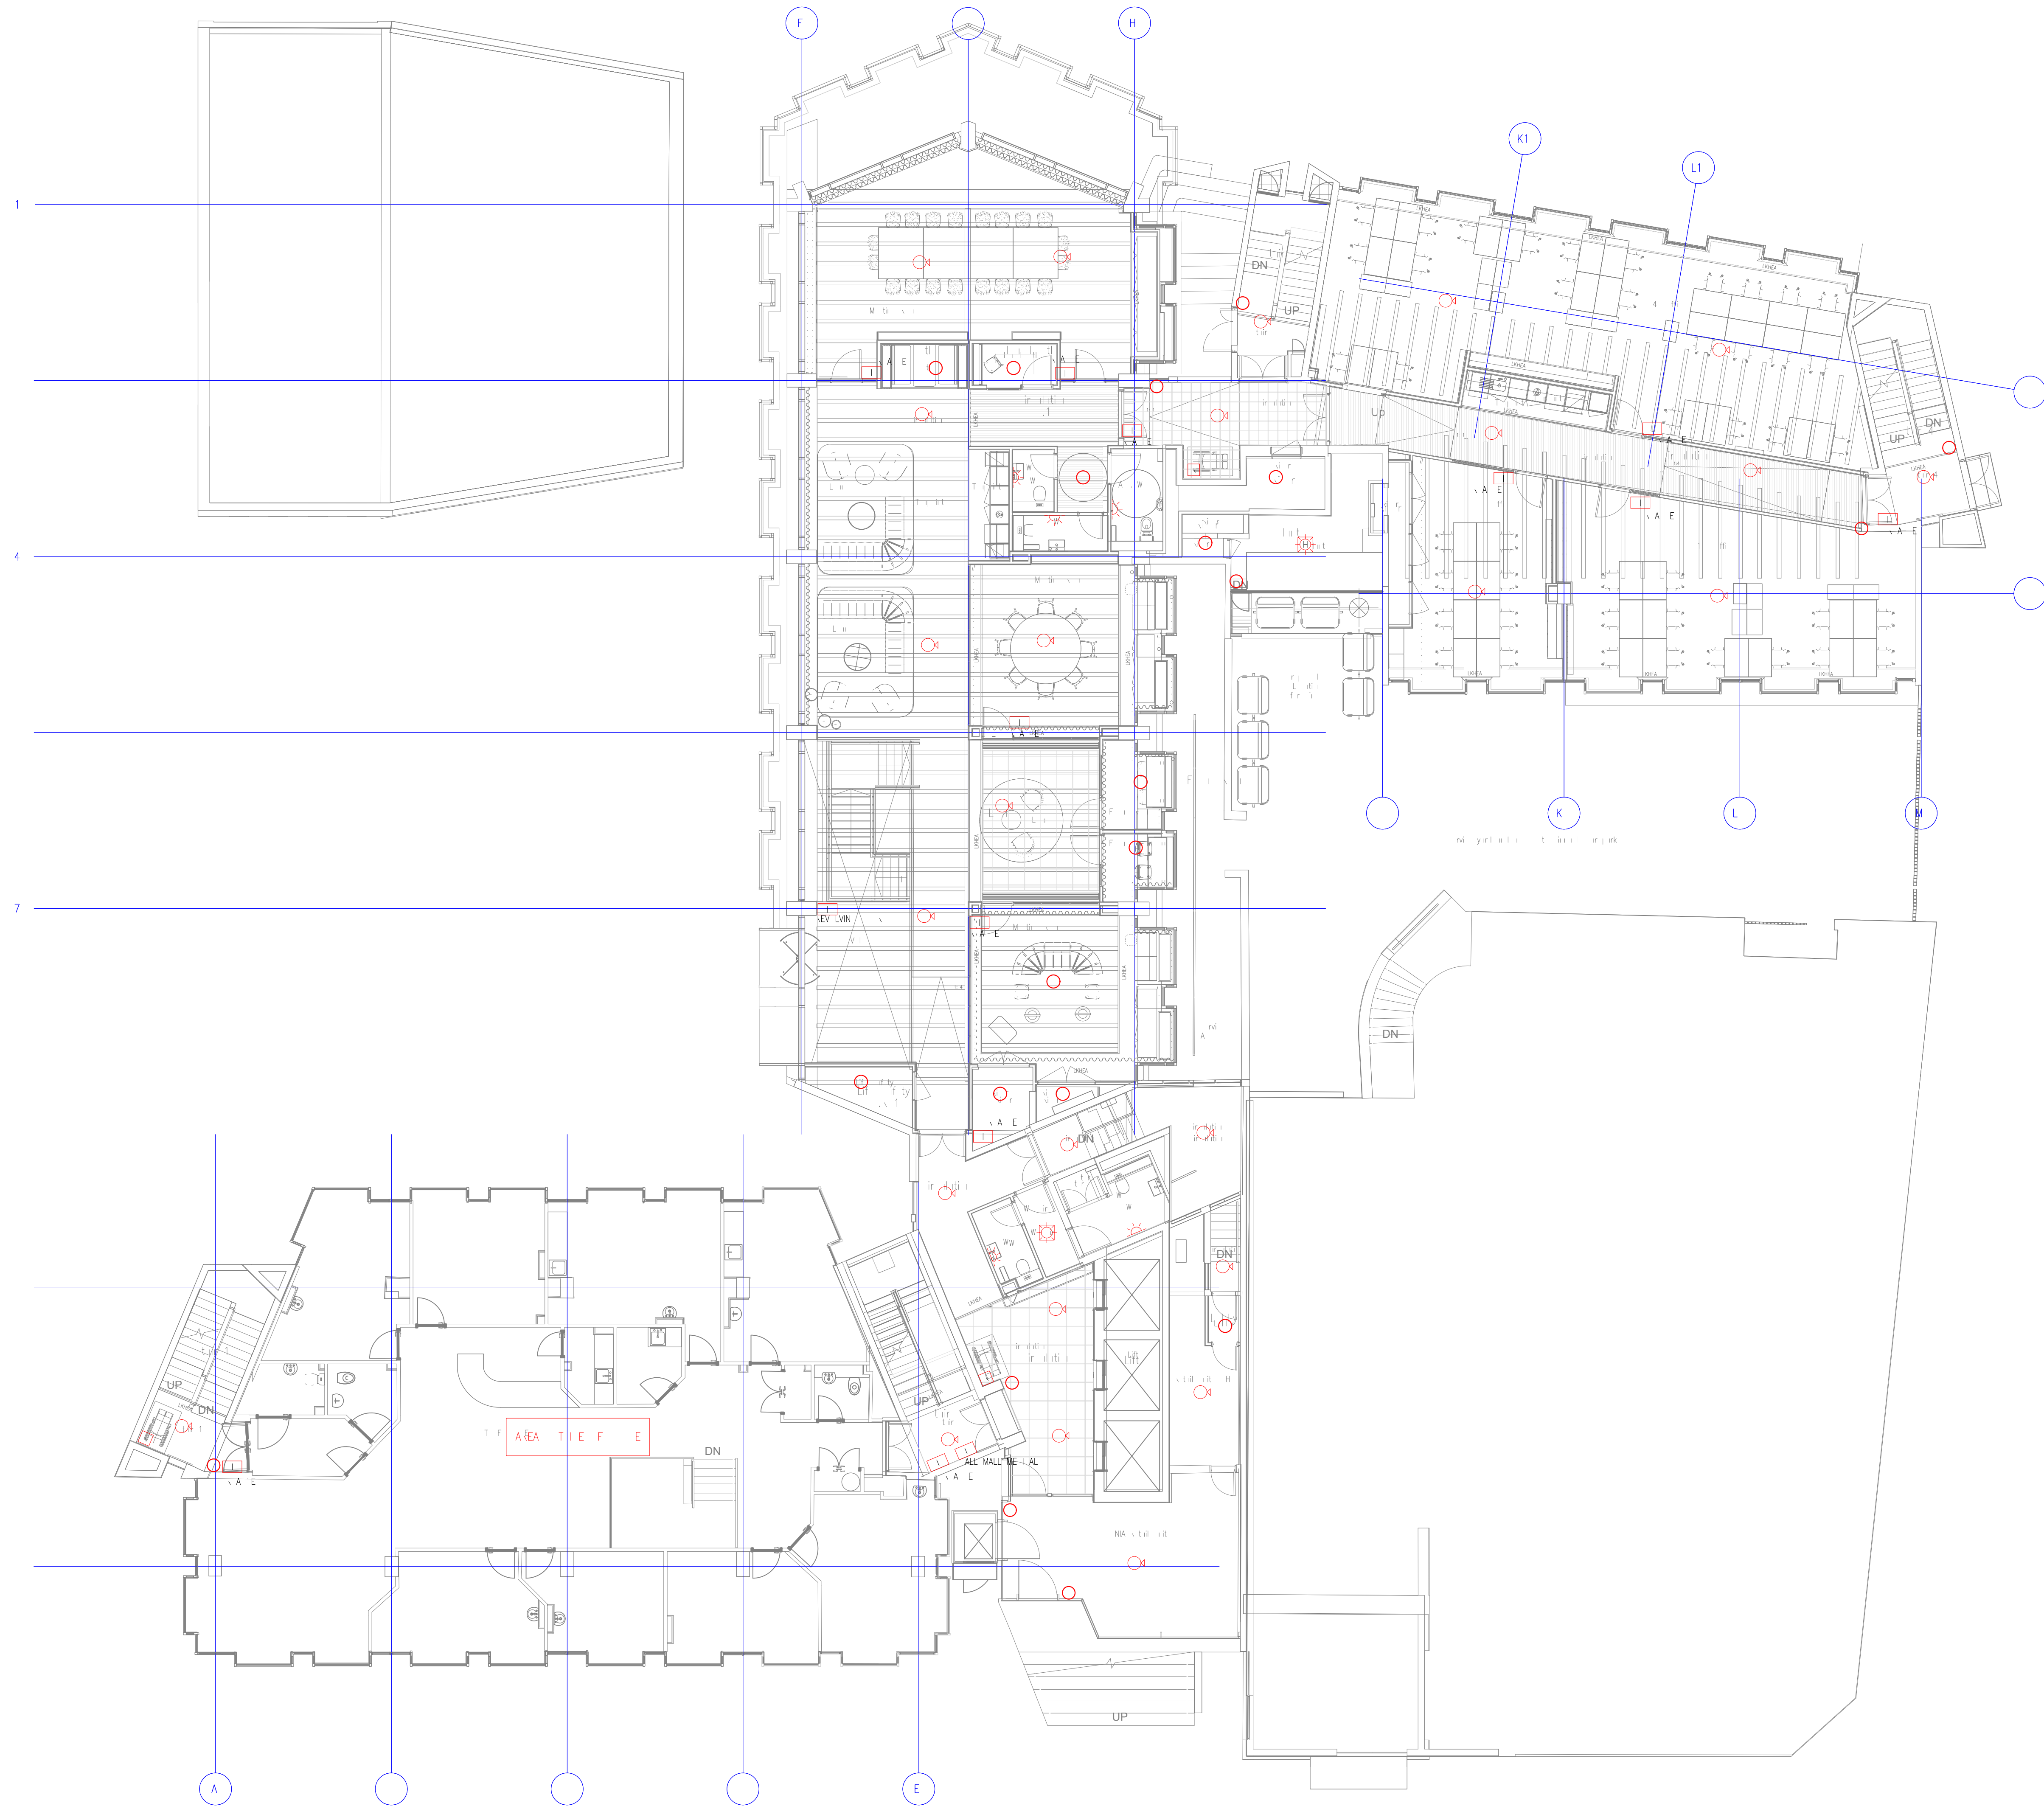

	EXPLANATION	K	A	M
1	FLUTE			
2	FLUTE			

Drawing Status: PRELIMINARY



Unit 6, North Staffs Business Park,
Innovation Way, Staffs ST64BF.
Email : info@carterelectrical.co.uk
Telephone: 01782 822250
www.carterelectrical.co.uk



Project:

PALL MALL
MANCHESTER

Table
GROUND FLOOR
FIRE DETECTION & ALARM
CONTINUED

Architect	SHEPPARD ROBSON
Construction	RAMBOLL


Designer, PG	Project Manager, CB	CAD, PG	Checked, MD
Date, 06.02.2023	Project Number, CES561		Scale, 1:100

Drawing No. 6911-CES-XX-00-DR-E-6702 Rev. 


Copyright, Carter Electrical Services LTD
 Customers are to check all Greenlines on site and order any

Contractors are to check all dimensions on site and refer any discrepancies to Carter Electrical immediately.

FIVE ALA:M	
YM L	E ɹl TI N
	FIVE ALA:M ANEL
	ANAL E ʔI AL M KE ETE T ɹ
	M KE ETE T ɹ ɹ ɹ N E ɹ
	M KE ETE T ɹ ɹ ɹ N E ɹ EA N
	HEAT ETE T ɹ
	HEAT ETE T ɹ ɹ N E ɹ
	HEAT ETE T ɹ ɹ N E ɹ EA N
	MAN AL ALL INT
	A ɹ E AL E IN LE HANDEL ɹLAY
	N E ɹ EA N
	ɹE F ALA:M ANEL

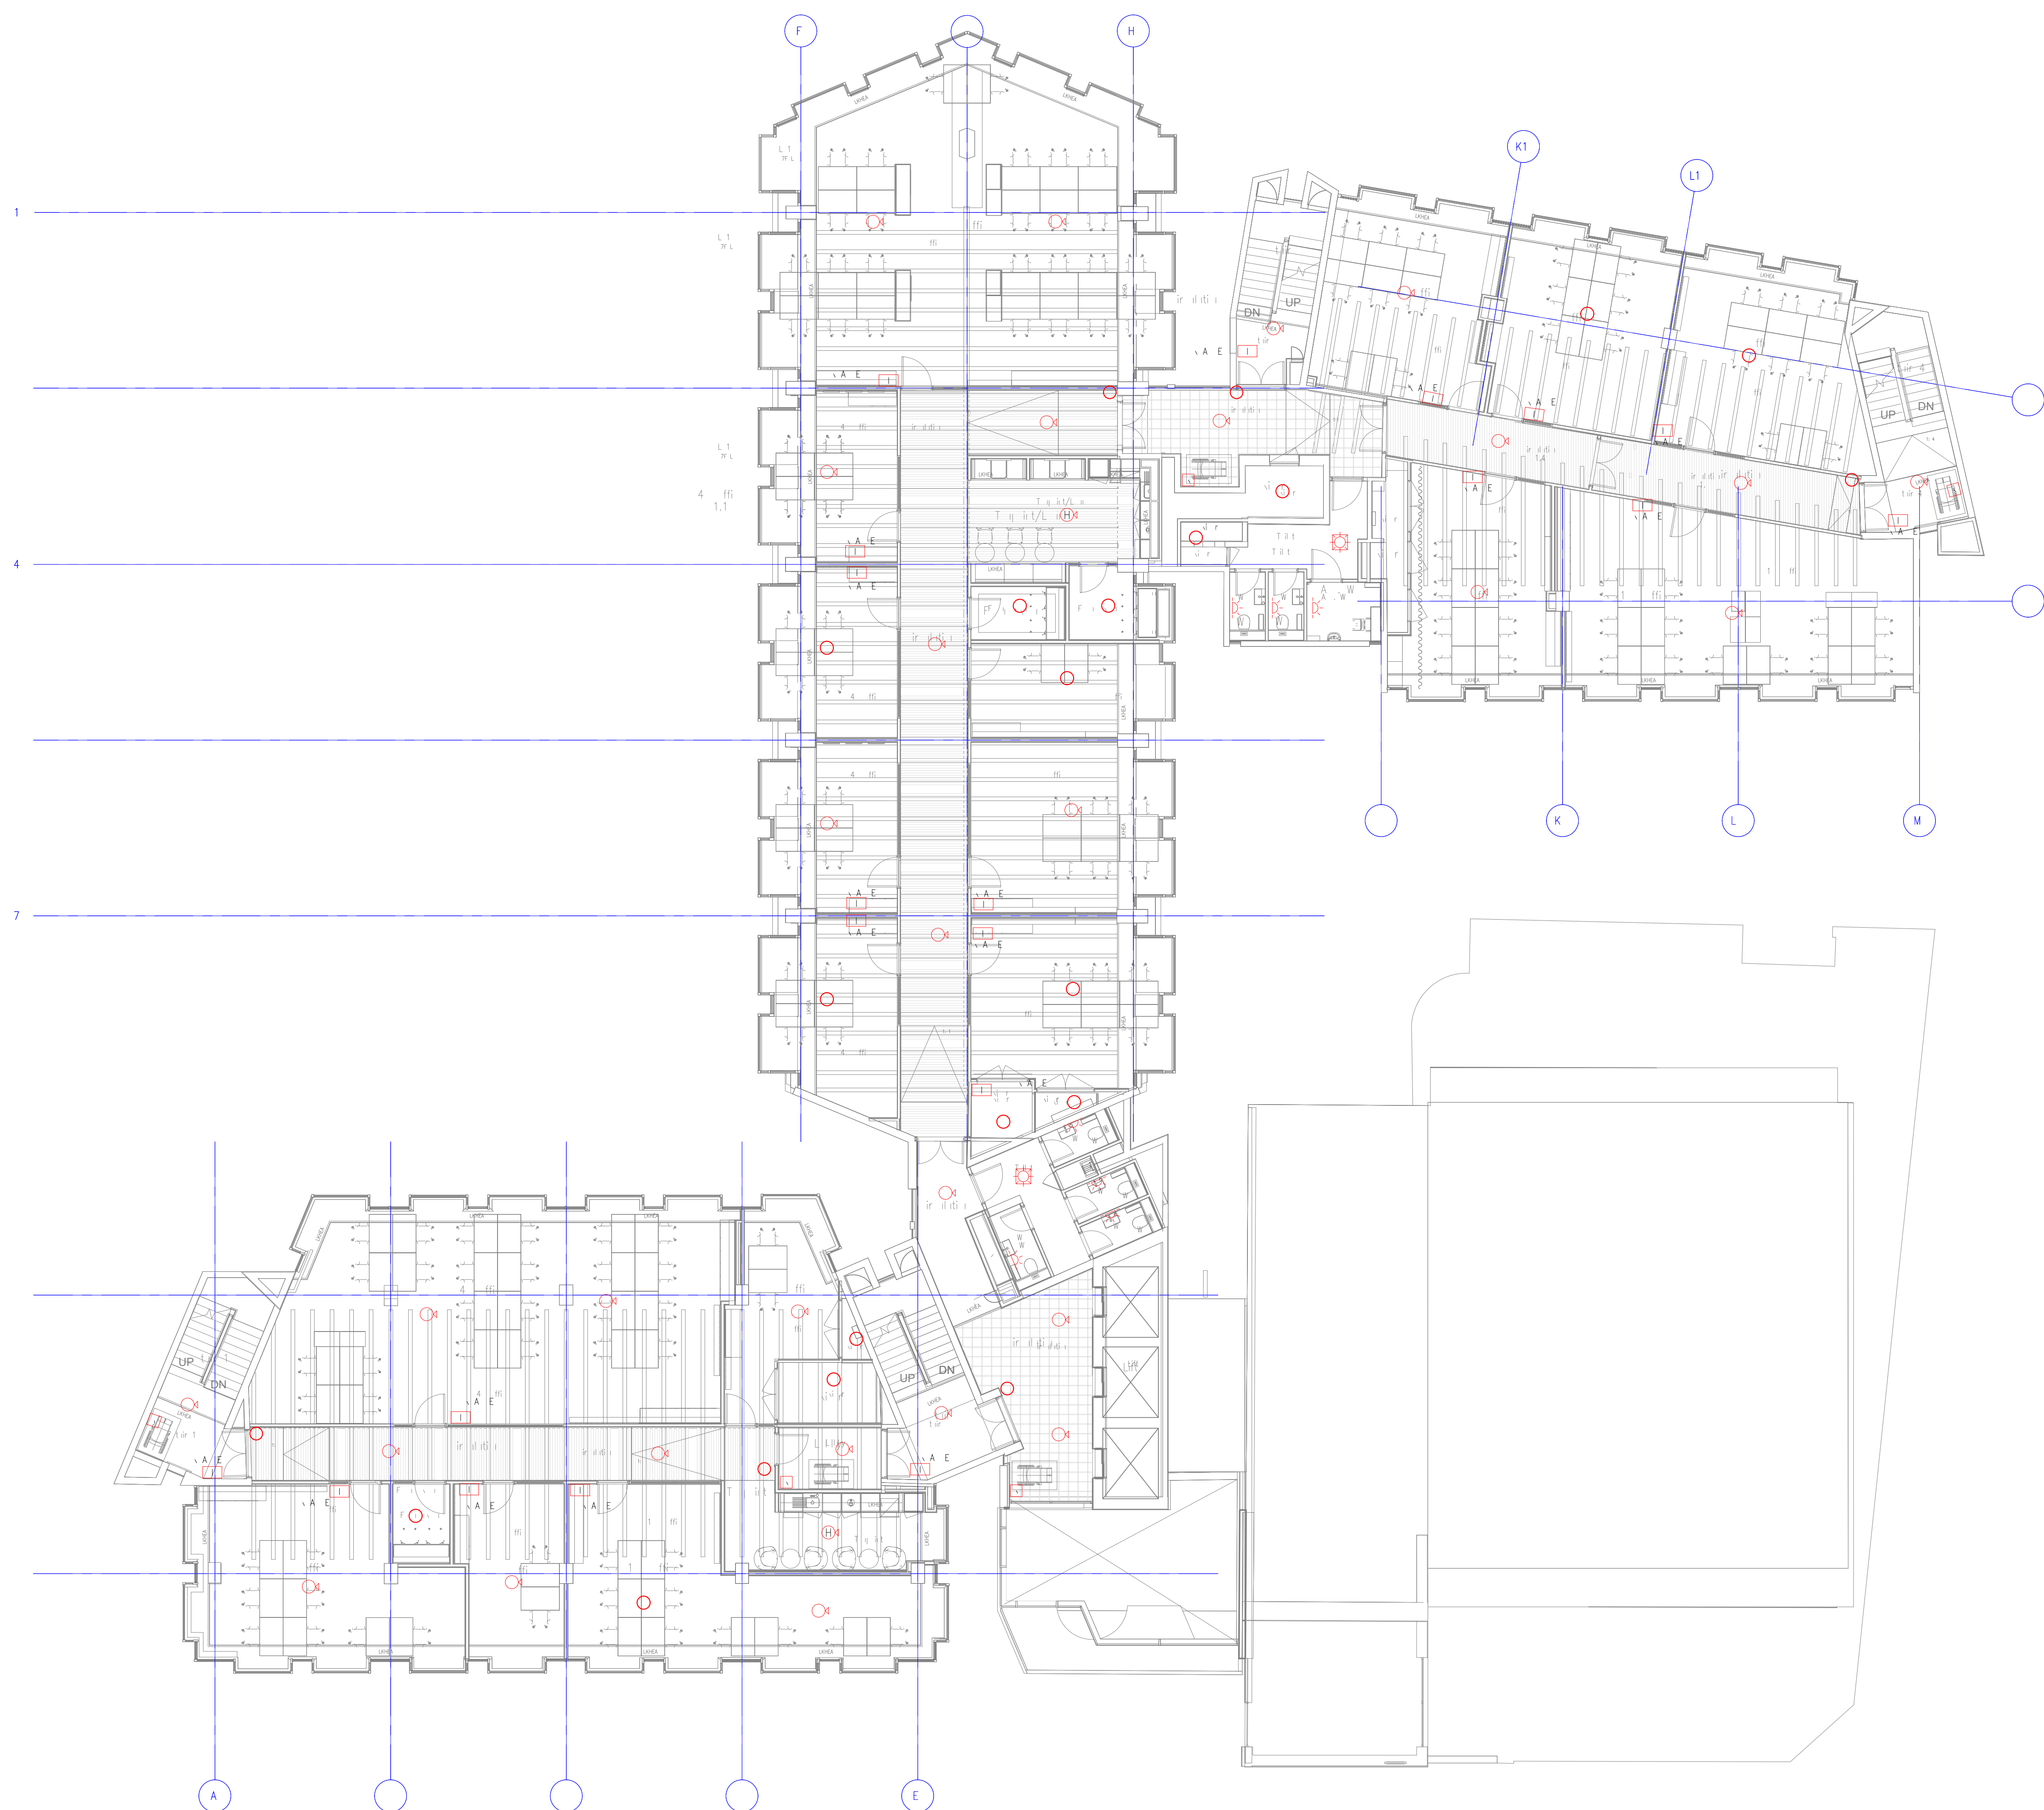

FIXE ALA M	
YM L	E N I T I N
	FIXE ALA M ANEL
	ANAL E T I A L M KE ETE T .
	M KE ETE T . w N E .
	M KE ETE T . w N E / EA N
	HEAT ETE T .
	HEAT ETE T . w N E .
	HEAT ETE T . w N E / EA N
	MAN AL ALL INT
	A . E A LE IN LE HANNEL -ELAY
	N E . EA N
	-EF E ALA M ANEL

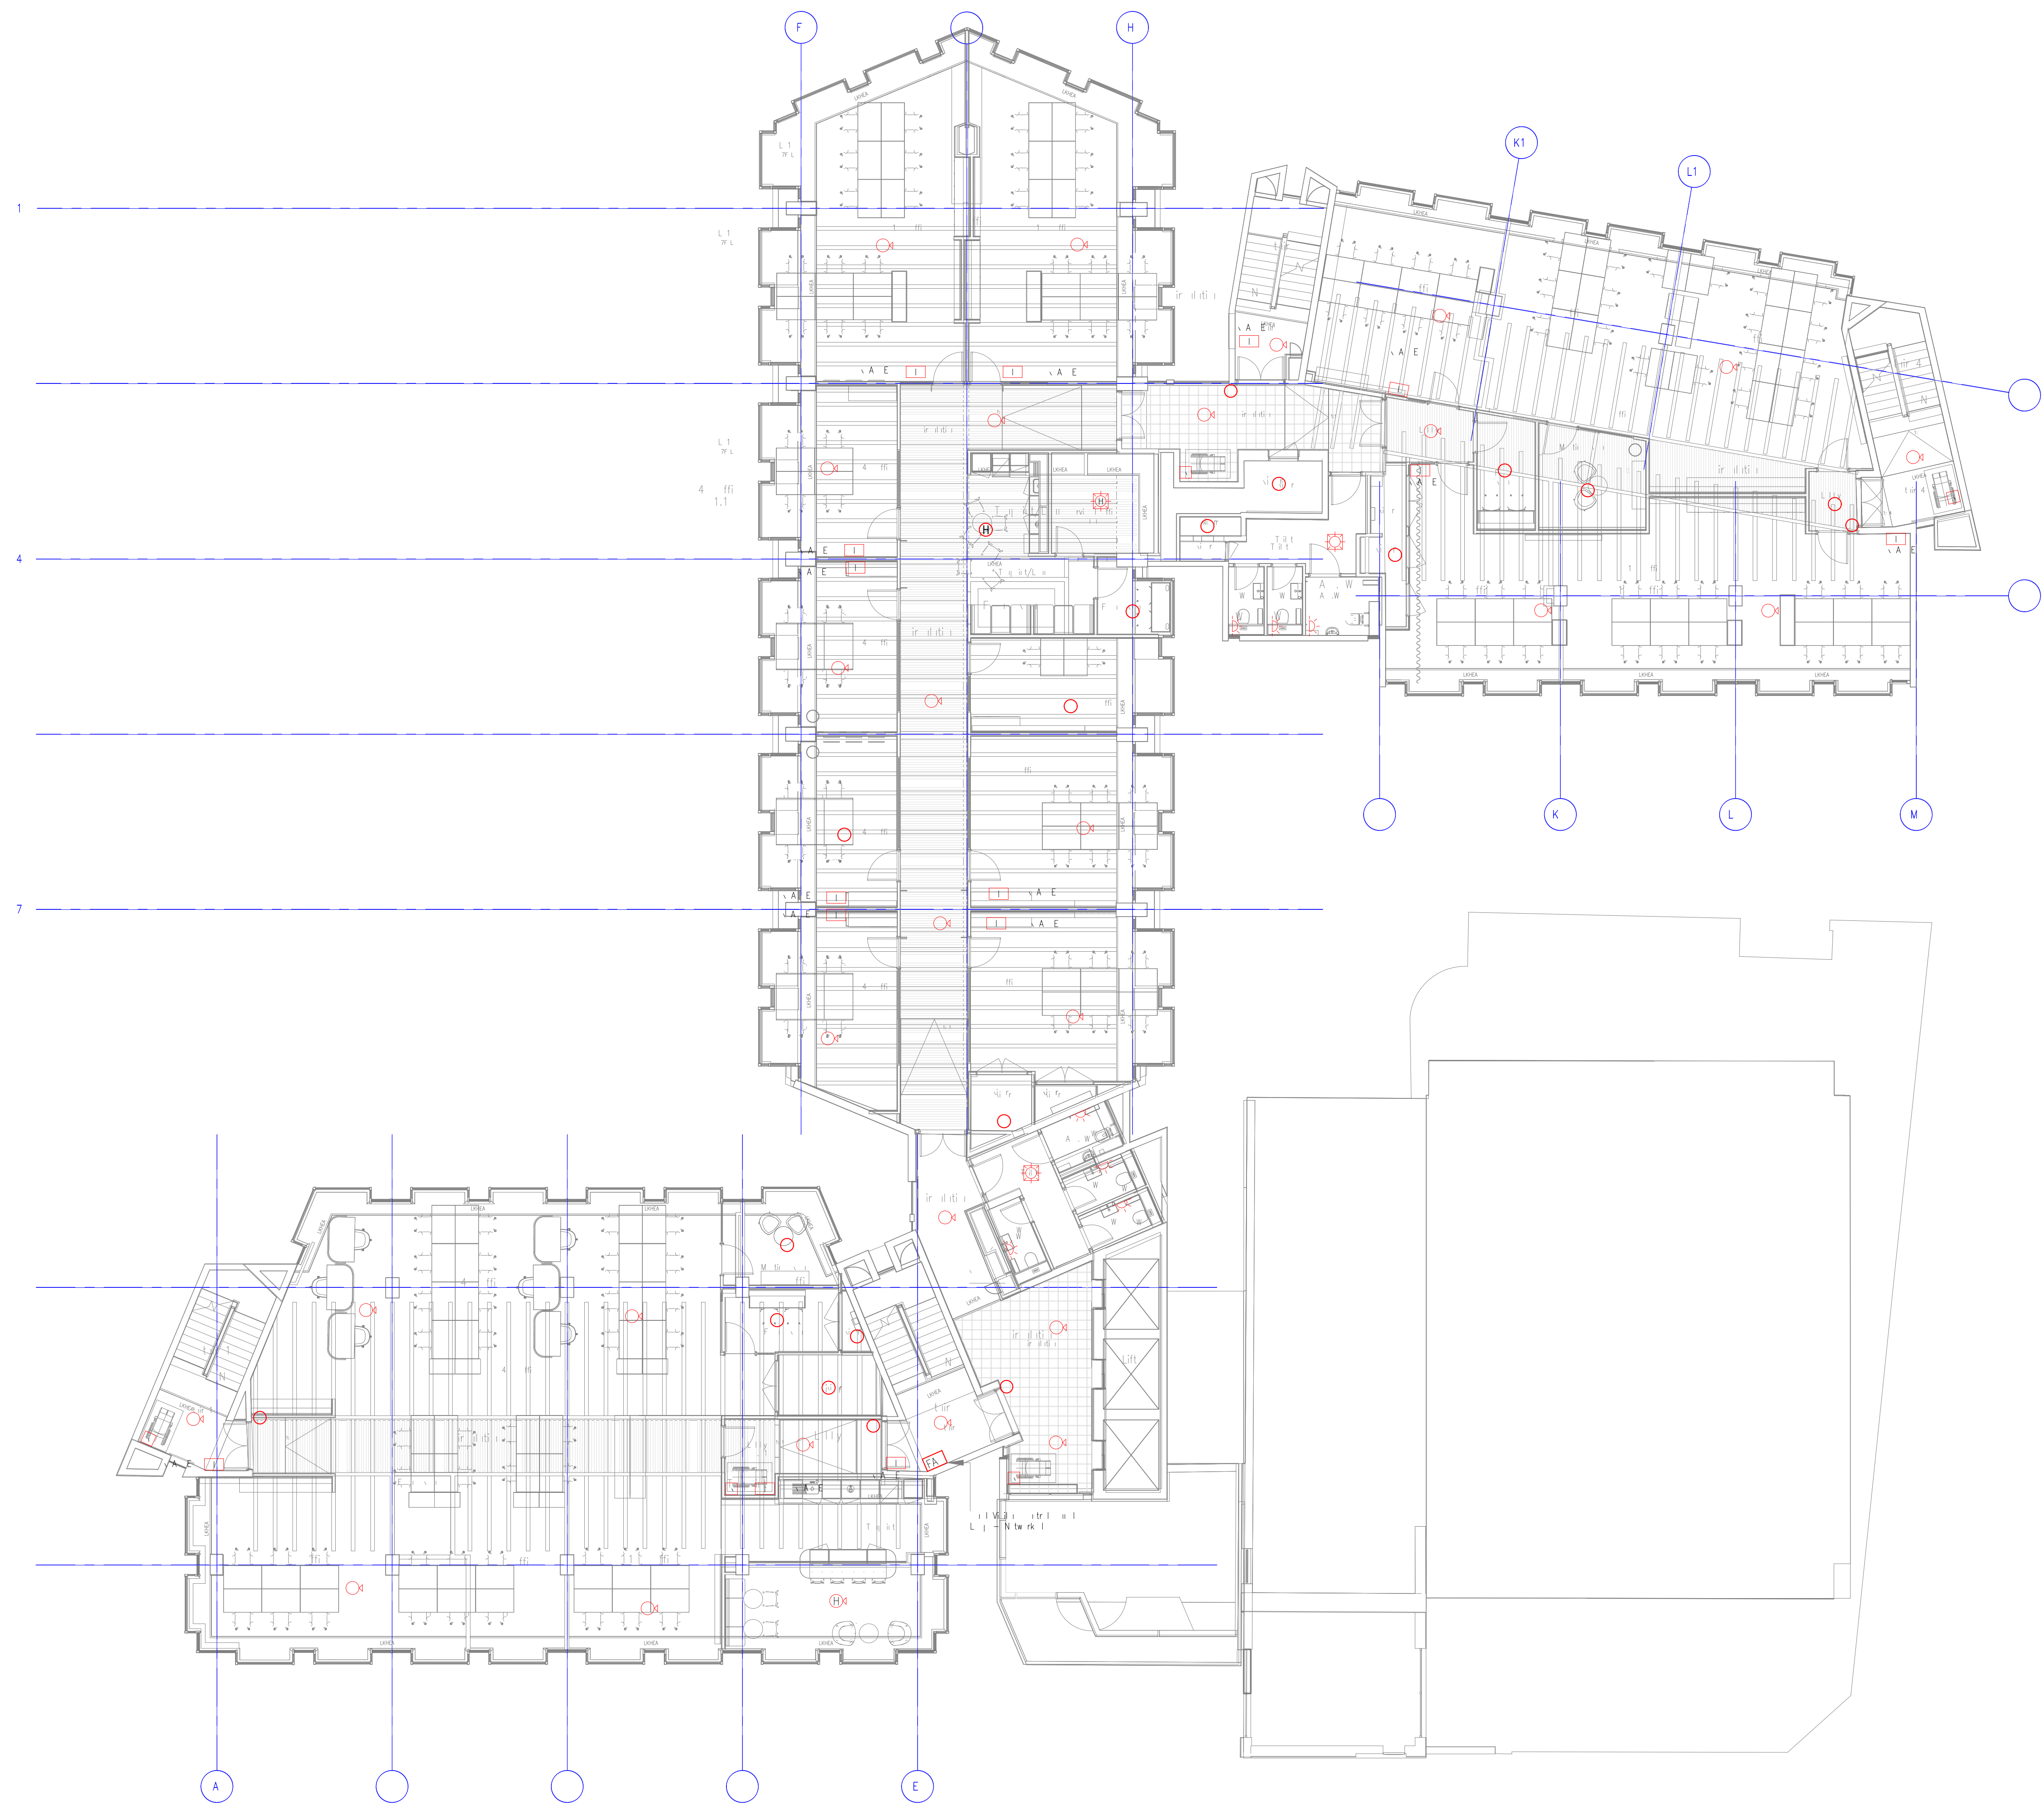

		S E V I T N - P L S A M W NT \ L ANEL A E	K	A	-
		S E V I E A E N JAM LL MMMENT -- K	K	A	T-6
1	F I T I E		/	/	
(K)	(代客)		能	>	M

BASED ON: 35202 Level 02 Ceiling Plan XREF CLEANED - P10.dwg

PRELIMINARY



Unit 6, North Staffs Business Park
Innovation Way, Staffs ST64BF.
Email : info@carterelectrical.co.uk
Telephone: 01782 822250



Project.

PALL MALL
MANCHESTER

THE SECOND FLOOD

Architect: SHEPPARD ROBSON

Consultant	RAMBOLL
------------	---------

Designer, PG	Project Manager, CB	CNO, PG
--------------	---------------------	---------

Date: 06.02.2023	Project Number: CES561	Scale: 1:100	AO
------------------	------------------------	--------------	----

Drawing No. 6011-CES-VV-02-DR-E-6704 Rev. 	
--	--


0911 CLJ-AA-02 DR-L-0704	P03
--------------------------	-----

Contractors are to check all dimensions on site and refer any

discrepancies to Carter Electrical immediately

1. I want that this is a A brown .
 . N e r g i l i t y u n i e t l i n e r r f
 m f r o t l i n w l y t l r . A l l
 r r r t l l l l t u k f r f r f r l
 l i n i n u l l k l i t .

FIXE ALA-M	
YM L	E ɹɪ TI N
	FI-E ALA-M ANEL
	ANAL E TI AL M KE ETE T ɹ
	M KE ETE T ɹ ɹ N E ɹ
	M KE ETE T ɹ ɹ N E ɹ/ EA N
	HEAT ETE T ɹ
	HEAT ETE T ɹ ɹ N E ɹ
	HEAT ETE T ɹ ɹ N E ɹ/ EA N
	MAN AL ALL INT
	A ɹ E AL E IN LE HANDEL ɹ ELAY
	N E ɹ EA N
	ɹ E ALA-M ANEL

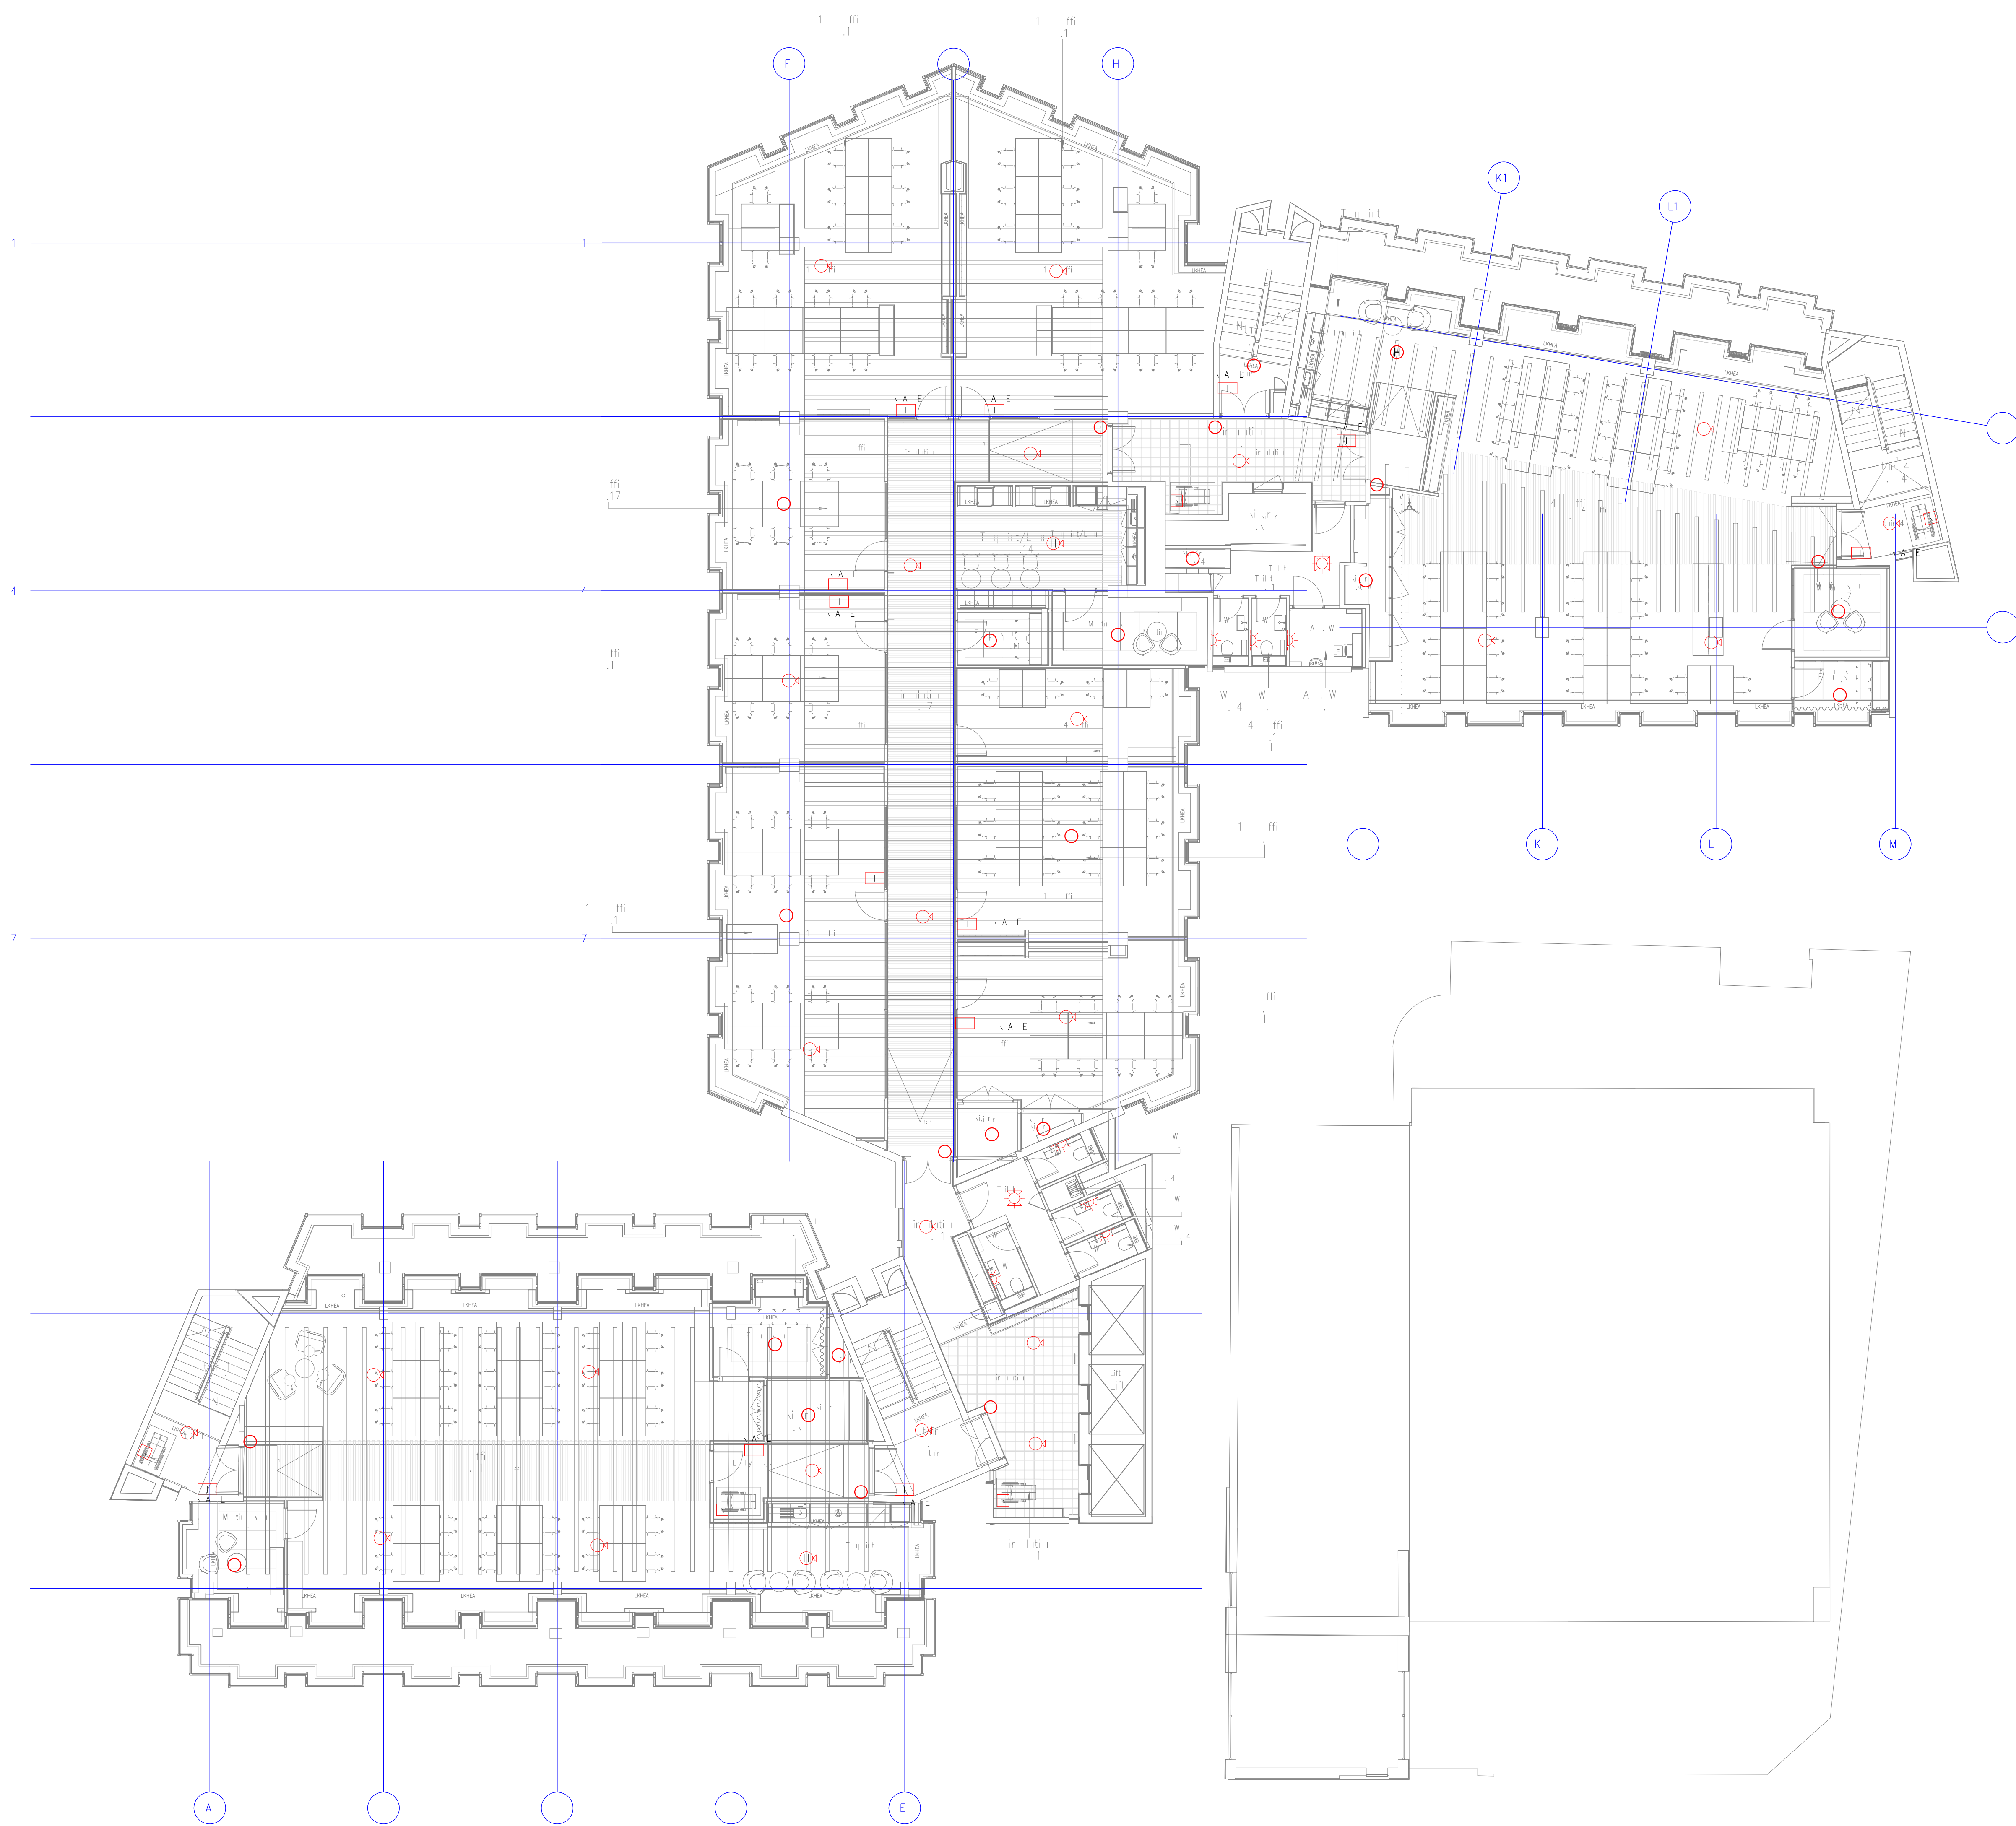

	E	V	I	N	A	E	N	J	A	M	L	M	E	N	T	-	K		A		N	A
1	F	I	T	I	E													K		A		N

BASED ON: 35203 Level 03 Ceiling Panel WRE CLEANED - P10-dwg
 Drawing Status:

PRELIMINARY



Unit 6, North Star's Business Park,
 Invercreevy Way, Sully 31348
 Email - info@cornersteel.co.uk
 or 0182 822230
www.cornersteel.co.uk






Project

PALL MALL MANCHESTER

The

THIRD FLOOR

FIRE DETECTION & ALARM
 LAYOUT

SHEPPARD ROBSON

As/Author: _____


Consultant: **RAMBOLL**

Designer: PG	Project Manager:	CB	AO	PG	Discussed: MD
Date: 06.02.2023	Project Number:	CES561			Scale: 1:100 AO

Drawing No: **8911-CES-XX-03-DR-E-6705** the 

Copyright, Central Electrical Services Ltd
 Contractors are to check all dimensions on site and refer any
 discrepancies to Central Electrical immediately

FIXE ALAM	
YM L	E N T I N
	FIXE ALAM ANEL
	ANAL E TIAL M KE ETE T
	M KE ETE T * W N E
	M KE ETE T * W N E / EA N
	HEAT ETE T
	HEAT ETE T * W N E
	HEAT ETE T * W N E / EA N
	MANAL ALL INT
	A A LE IN LE HANDEL ELAY
	N E / EA N
	LET ALAM ANEL

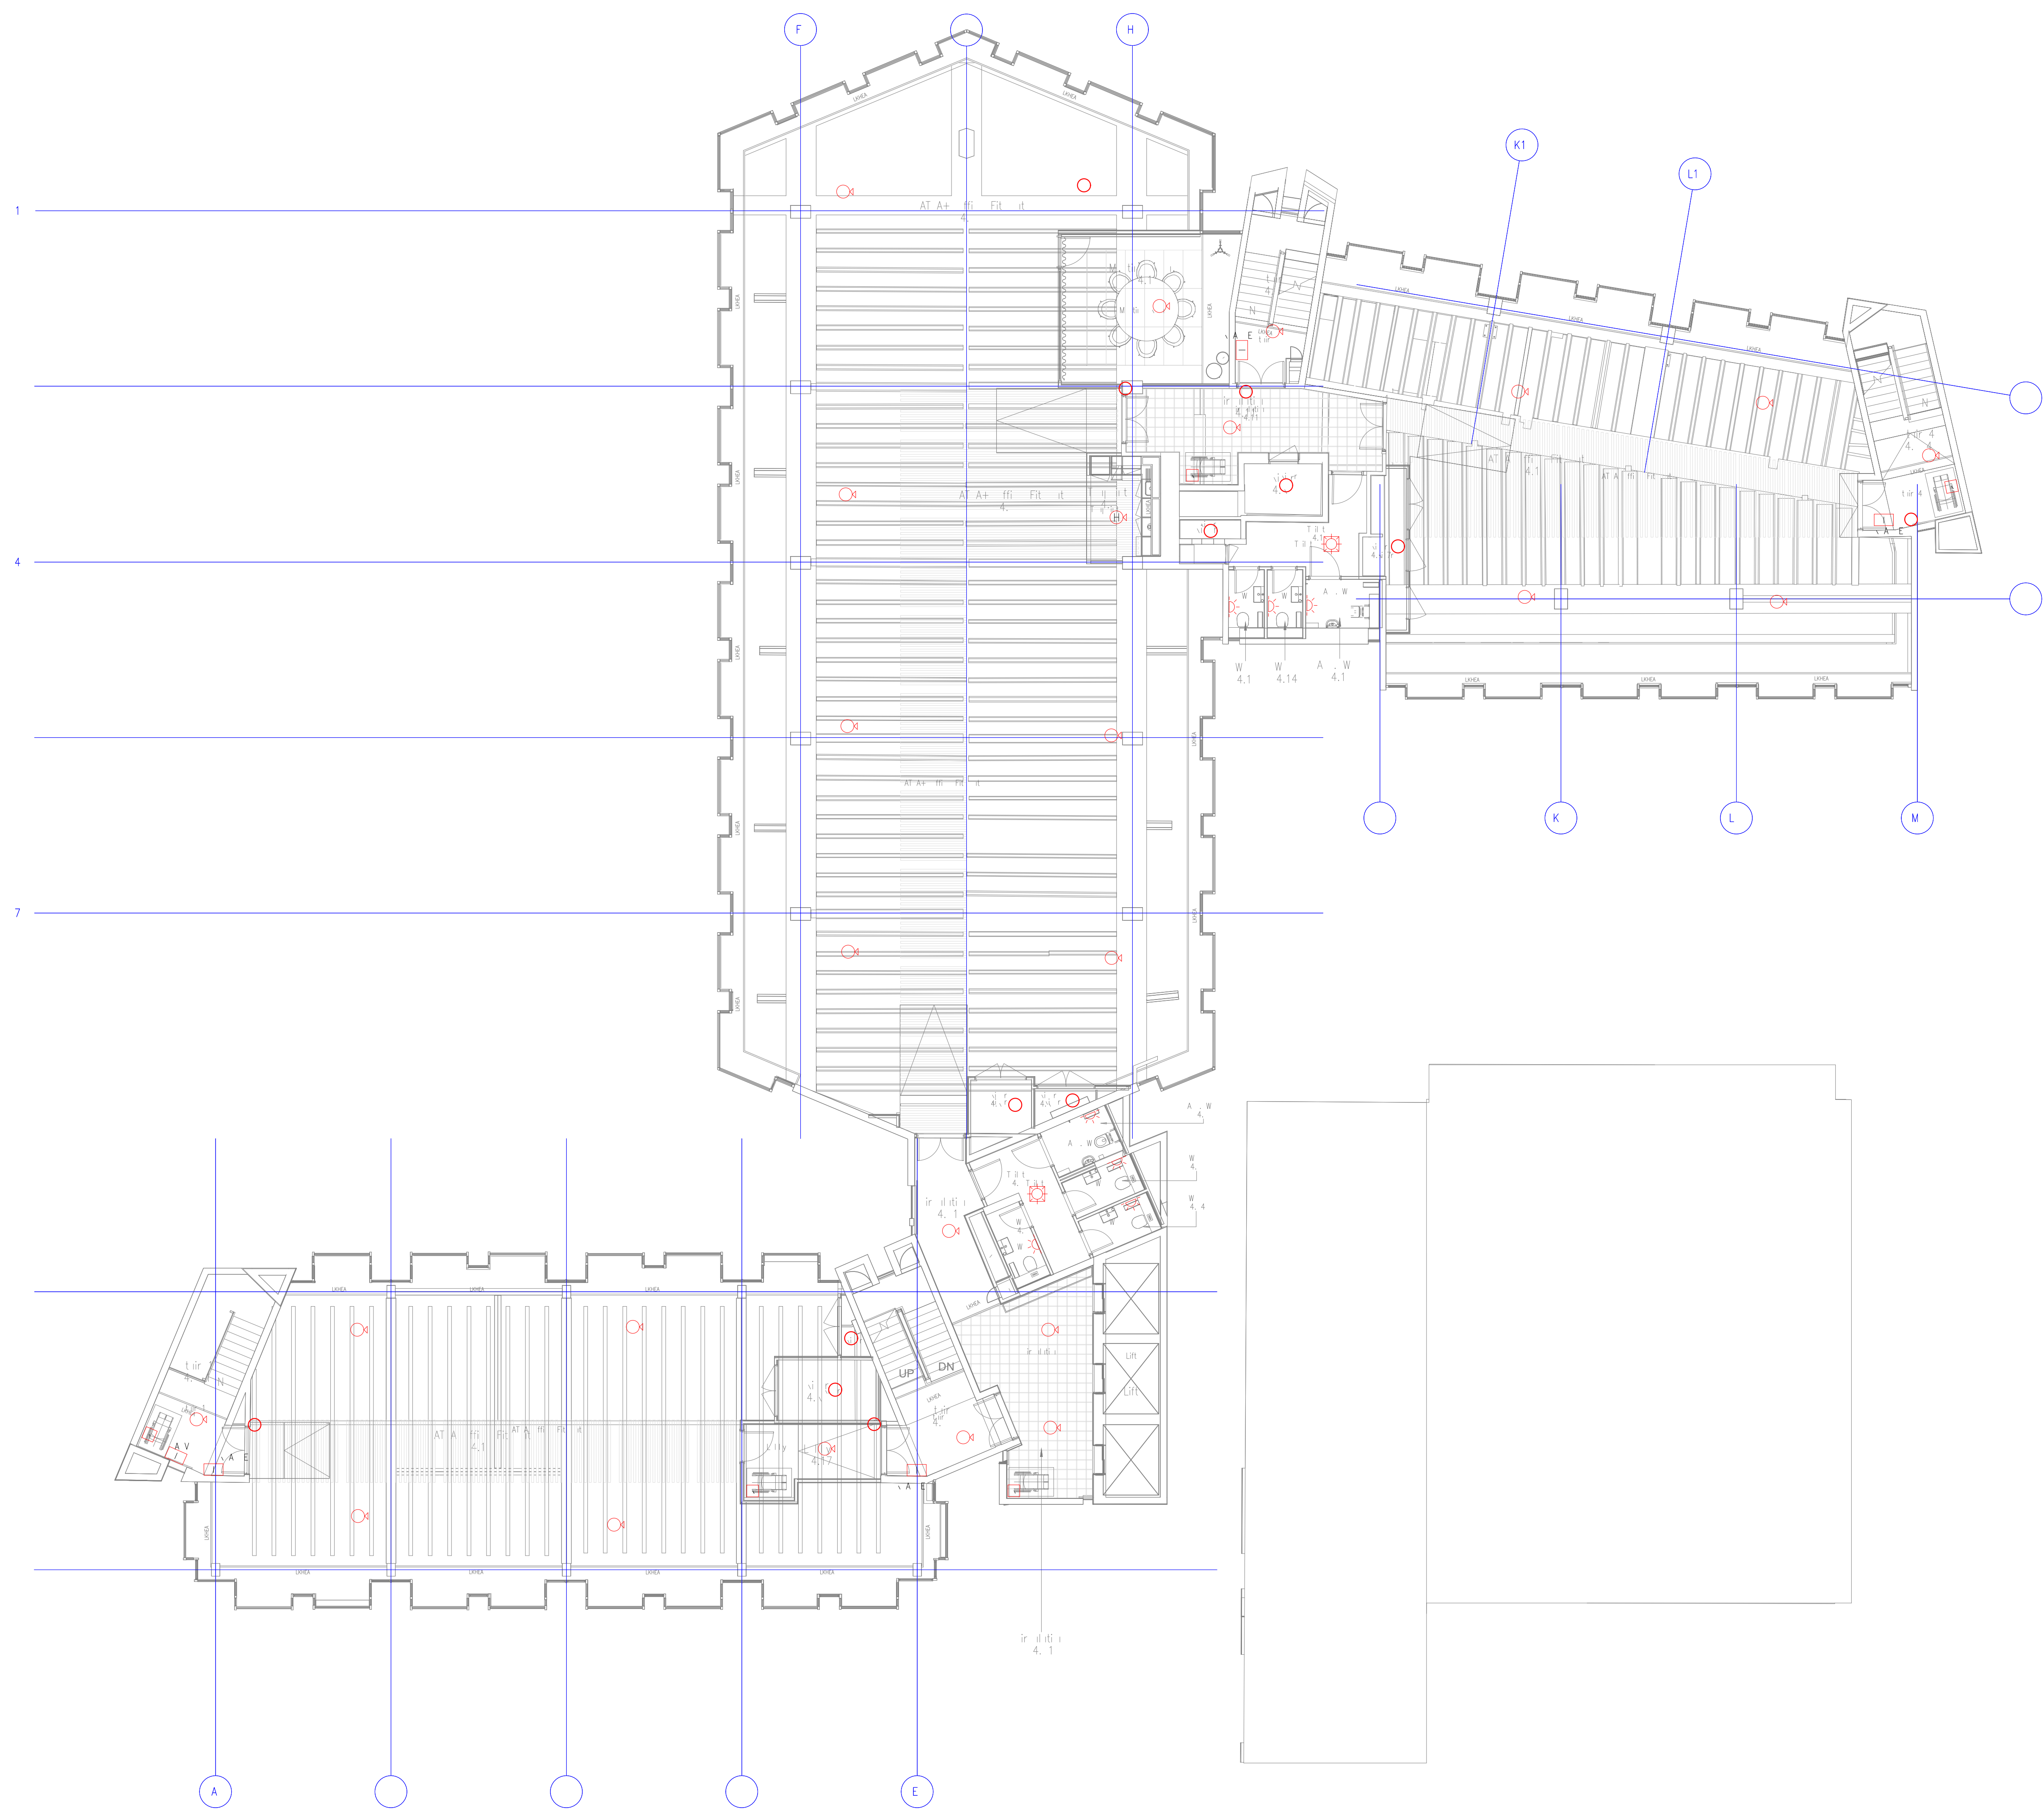

	I	V	I	N	A	E	N	J	M	L	M	E	N	T	-	K	A	S	H	A
1	F	I	L	I	E															

BASED ON: 35004 Level 4 College Place HREF CLEANED - P10.dwg
Drawing Status:

PRELIMINARY



Unit 4, North Scotts Business Park,
Invercreevy Way, Salford M13 4AH
Email : info@cornersteel.co.uk
Telephone: 01762 822230
www.cornersteelfabric.co.uk






Project

PALL MALL MANCHESTER

The


FOURTH FLOOR

FIRE DETECTION & ALARM LAYOUT

SHEPPARD ROBSON


Consultant **RAMBOLL**

Drawing PC	Project Manager	CB	AO	PG	Discard Date
Date: 06.02.2023	Project Number: CES561				Scale: 1:100 AO

 Drawing No: 8911-CES-XX-04-DR-E-6706 the 

Copyright, Carter Electrical Services Ltd
Constructors are to check all dimensions on site and refer any discrepancies to Carter Electrical immediately

FIVE ALA-M	
Y M L	E ∩ T I N
	FIVE ALA-M ANGEL
	ANGEL E T I A L M K I E E T E T ∩
	M K I E E T E T ∩ ∩ N E ∩
	M K I E E T E T ∩ ∩ N E ∩ / E A N
	HEAT E T E T ∩
	HEAT E T E T ∩ ∩ N E ∩
	HEAT E T E T ∩ ∩ N E ∩ / E A N
	MAN AL AL INT
	A ∩ E A L E IN L E H A N N E L E L A Y
	N E ∩ E A N
	∩ E F E A L A M ANGEL

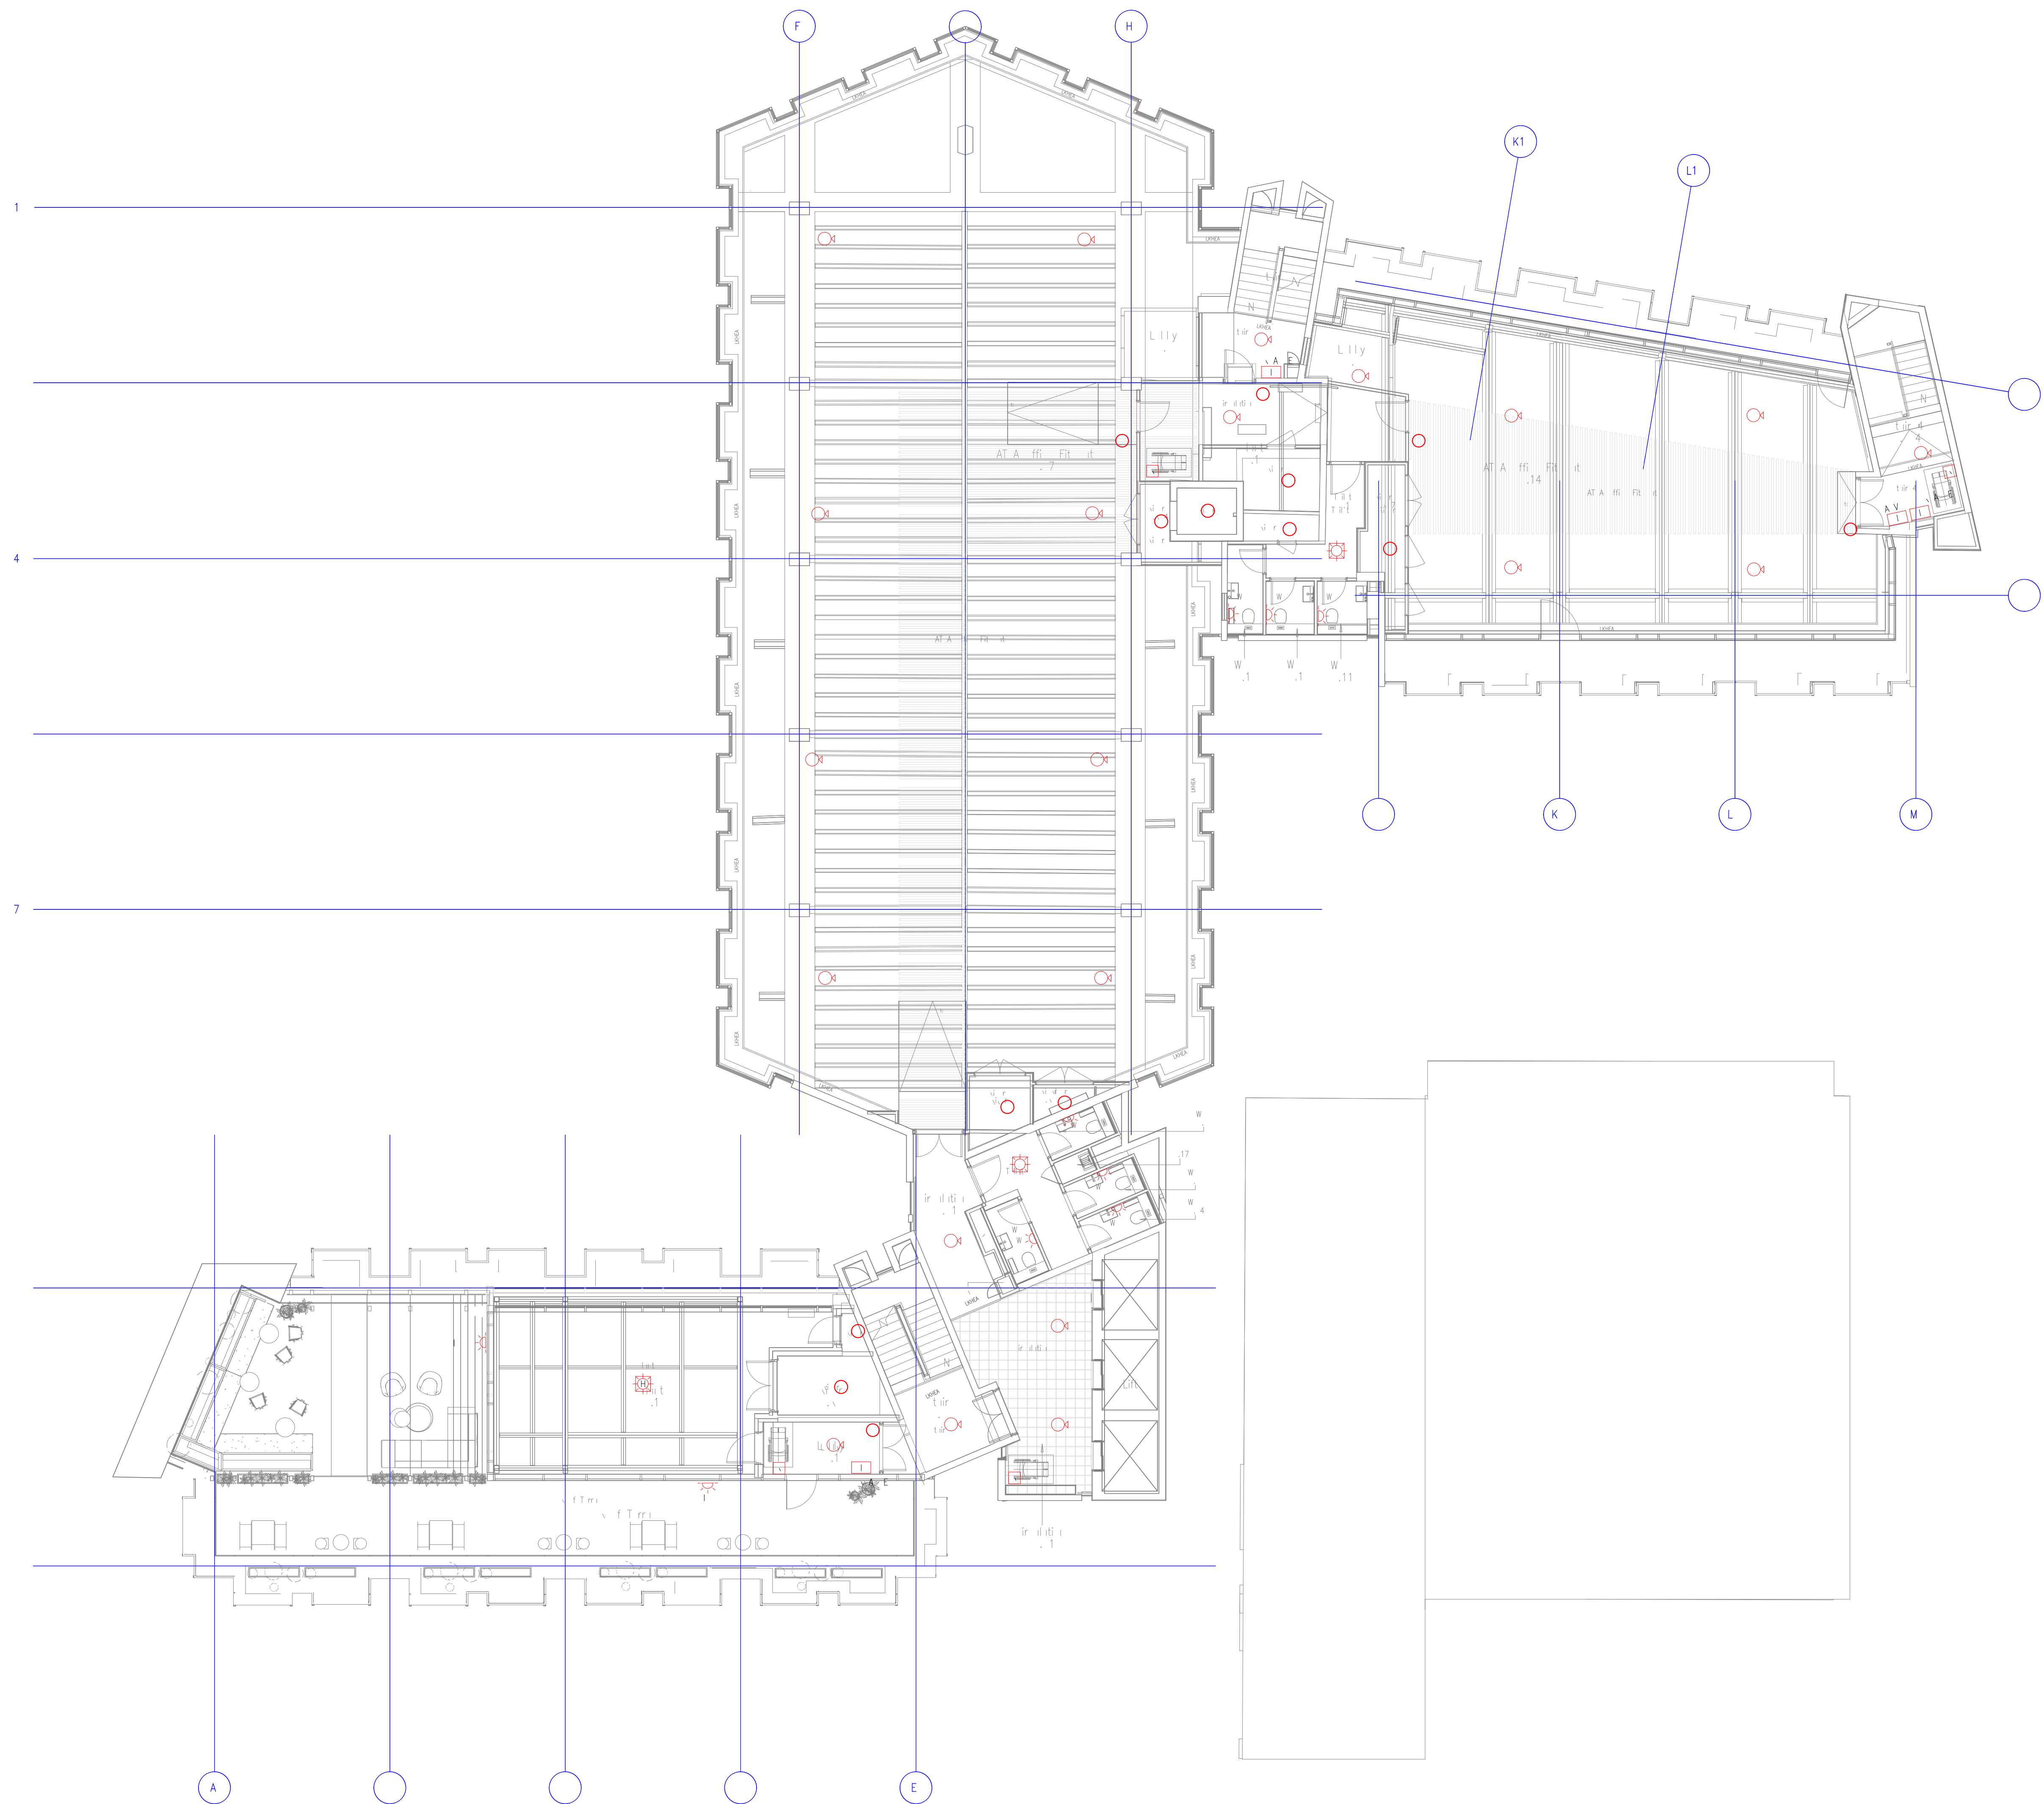

	EVILIN - FLENTL ANEL SEMVE	K	A	
	EVILIN A E N AM LL MMENT - K	K	A	nt 4
1	FILIT E			
1	EVILIN A E N AM LL MMENT - K	K	A	nt 4

Drawing Status: PRELIMINARY

--	--

Unit 6, North Staffs Business Park
Innovation Way, Staffs ST64BF
Email : info@carterelectrical.co.uk
Telephone: 01782 822250
www.carterelectrical.co.uk



Project:
PALL MALL
MANCHESTER

FIFTH FLOOR
FIRE DETECTION & ALARM
LAYOUT

Architect: SHEPPARD ROBSON


Consultant: RAMBOLL		
Designer: PG	Project: CB	Rev: PG

Date: 06.02.2023	Project Number: CES561
------------------	------------------------

Drawing No. 6911-CES-XX-05-DR-E-670

Copyright, Carter Electrical Services LTD
Contractors are to check all dimensions on site and report any discrepancies to Carter Electrical immediately

FIVE ALAM M	
YM L	E U T I N
	FIVE ALAM ANEL
	ANAL E T I A L M K E E T E T
	M K E E T E T \ w N E \
	M K E E T E T \ w N E \ / EA N
	HEAT E T E T
	HEAT E T E T \ w N E \
	HEAT E T E T \ w N E \ / EA N
	M A N A L A N T I N T
	A \ E A L E I N L E H A N N E L \ E L A Y
	N E \ EA N
	\ E T E A L A M A N E L

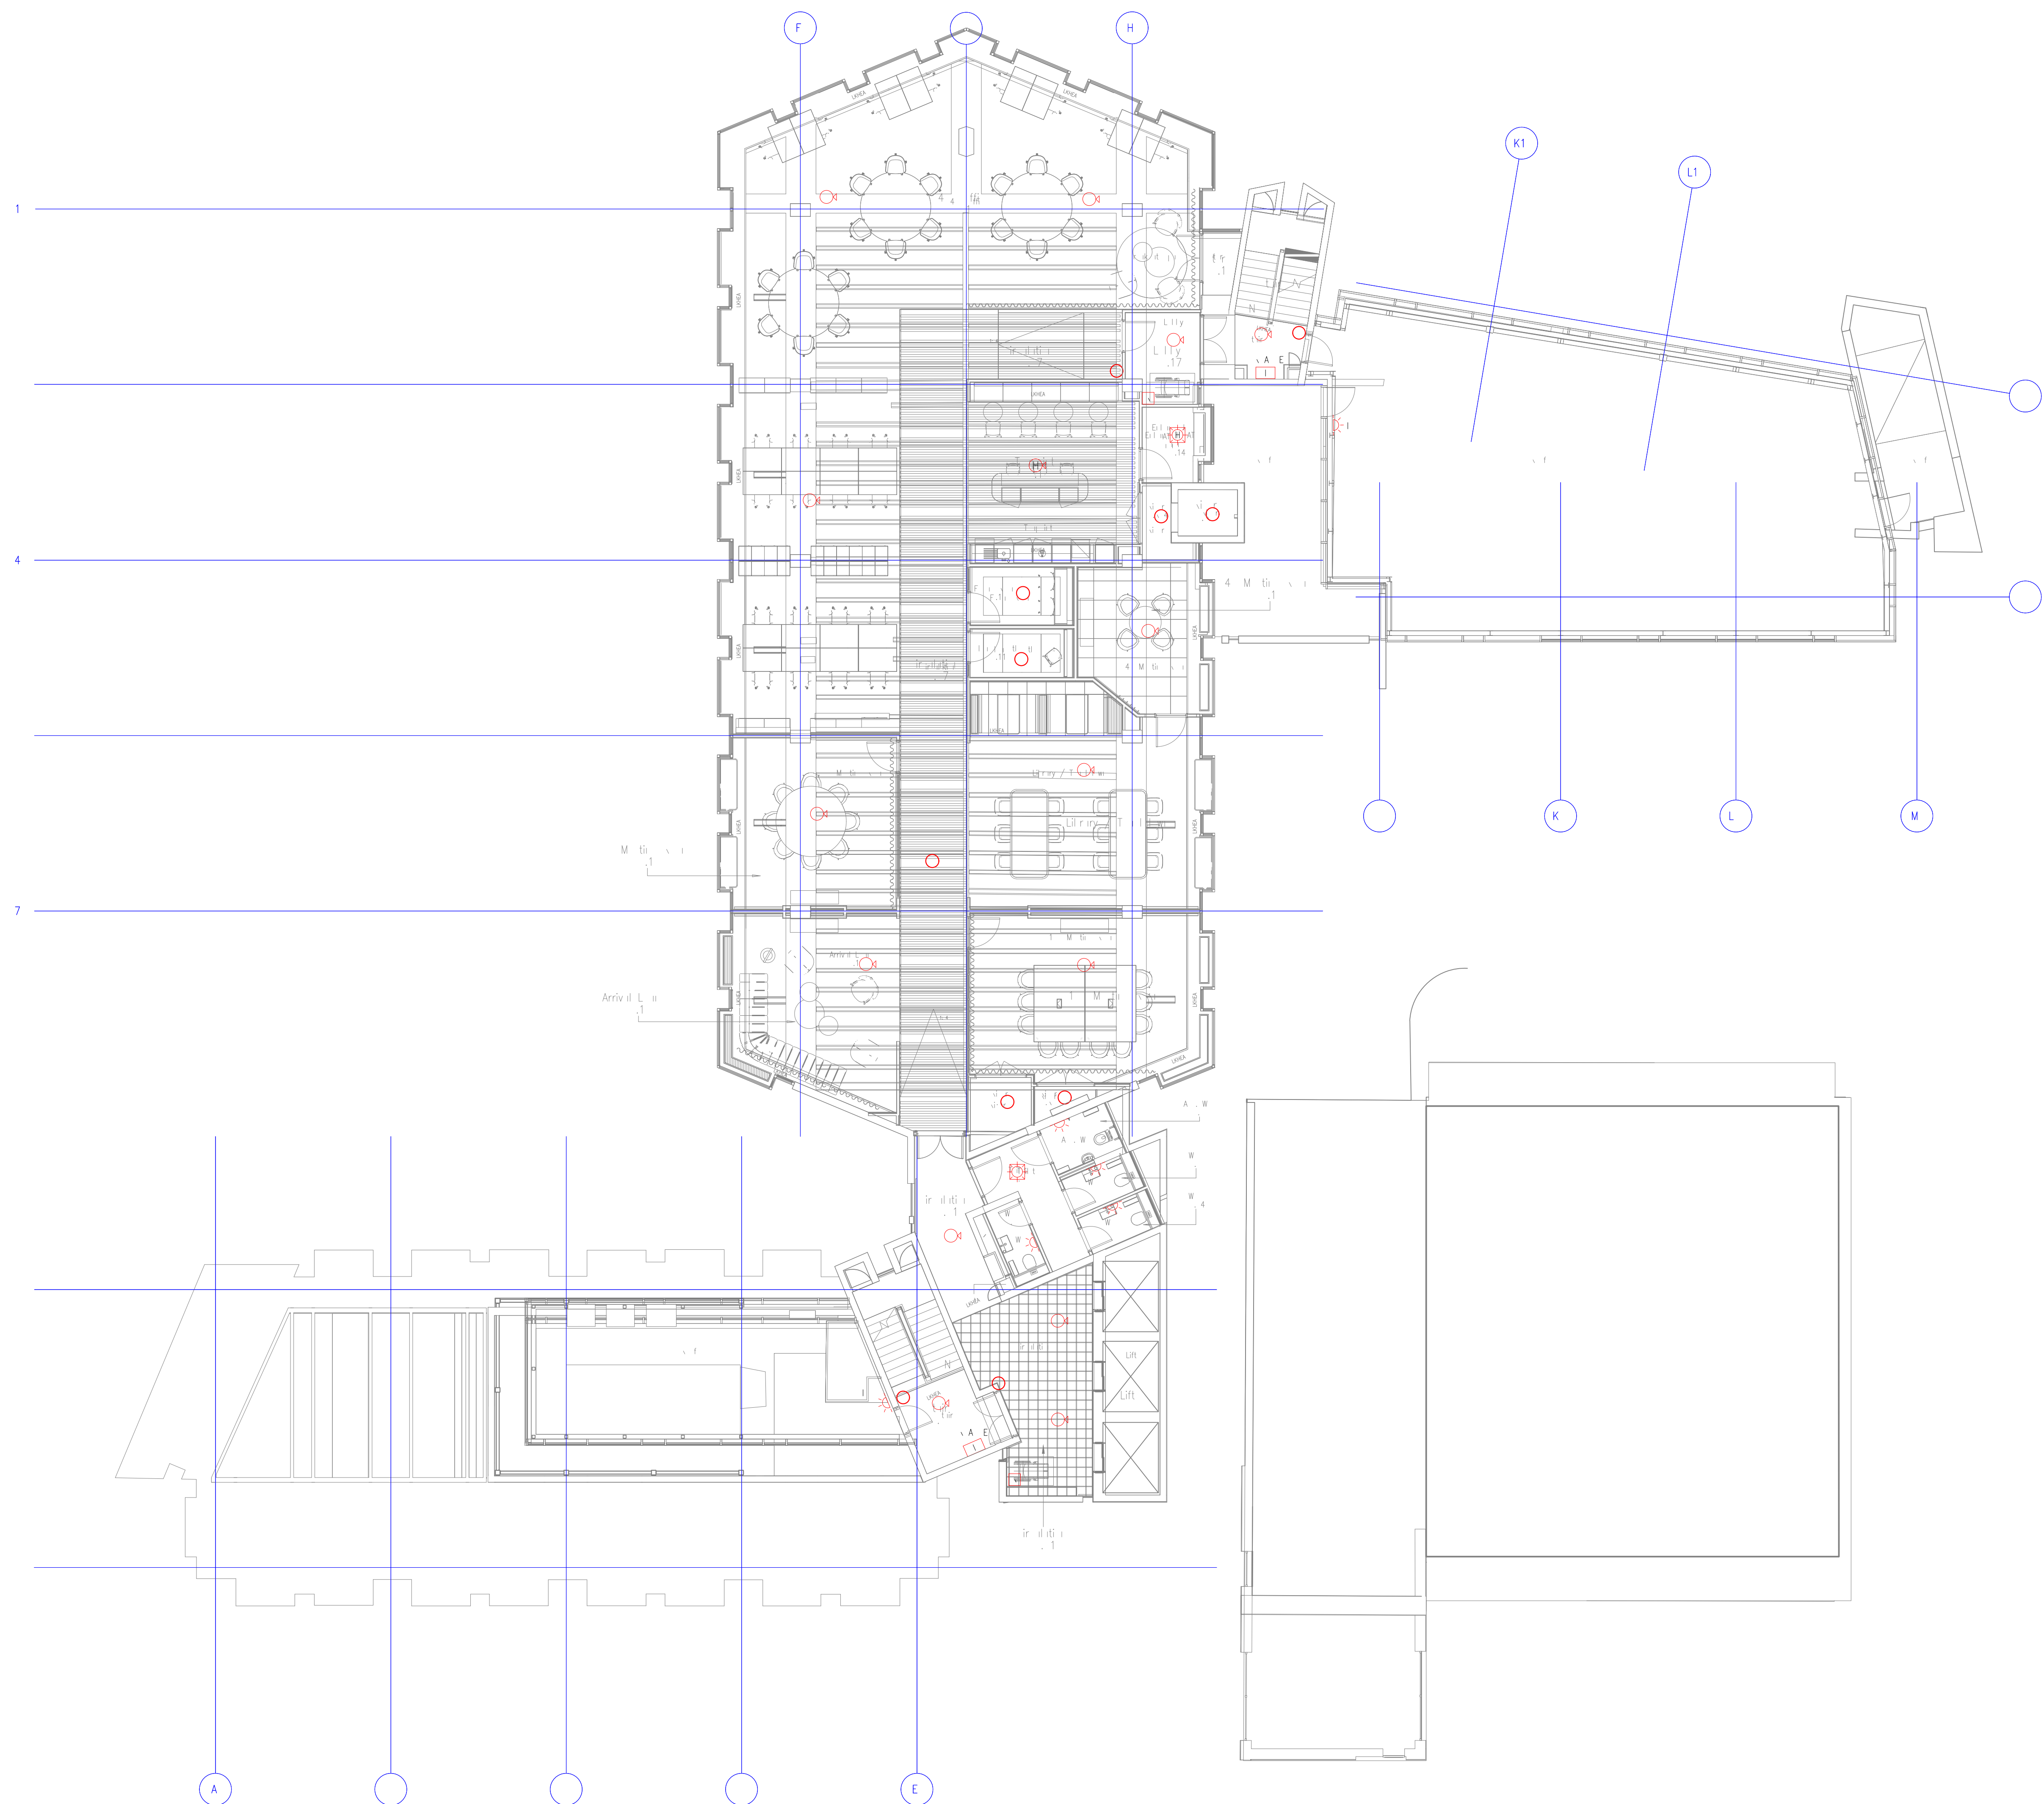

	EVIN A E N AM LL MMENT -K	K	A	Me
1	FI T I E			

BASED ON: 35206 Level 06 Ceiling Plan XREF CLEANED - P10

PRELIMINARY



Unit 6, North Staffs Business Park,
Innovation Way, Staffs ST64BF.
Email : info@carterelectrical.co.uk
Telephone: 01782 822250



Project

Project:
PALL MALL
MANCHESTER

SIXTH FLOOR
FIRE DETECTION & ALARM
LAYOUT

Architect: SHEPPARD ROBSON

Consultant:	RAMBOLL
-------------	---------

Designer, PG	Project Manager, CB	CO, PG
--------------	---------------------	--------

Date: 06.02.2023	Project Number: CES561	Scale: 1:100	AO
------------------	------------------------	--------------	----

Drawing No. 6911-CES-XX-06-DR-E-6708 Rev. 


Copyright, Carter Electrical Services LTD

Contractors are to check all dimensions on site and refer any discrepancies to Carter Electrical immediately

ENE VAL N TE

1. I want that this is a A. I want.
N. I want that this is a A. I want.
I want that this is a A. I want.
I want that this is a A. I want.

YM L	E J I T I N
	FIVE ALAM ANEL
	ANAL E T I AL M K E E T E T V
	M K E E T E T V * N E V
	M K E E T E T V * N E V/ EA N
	HEAT E T E T V
	HEAT E T E T V * N E V
	HEAT E T E T V * N E V/ EA N
	MAN AL ALL INT
	A E A L E N L E HANNEL E LAY
	N E V EA N
	DEF E ALAM ANEL

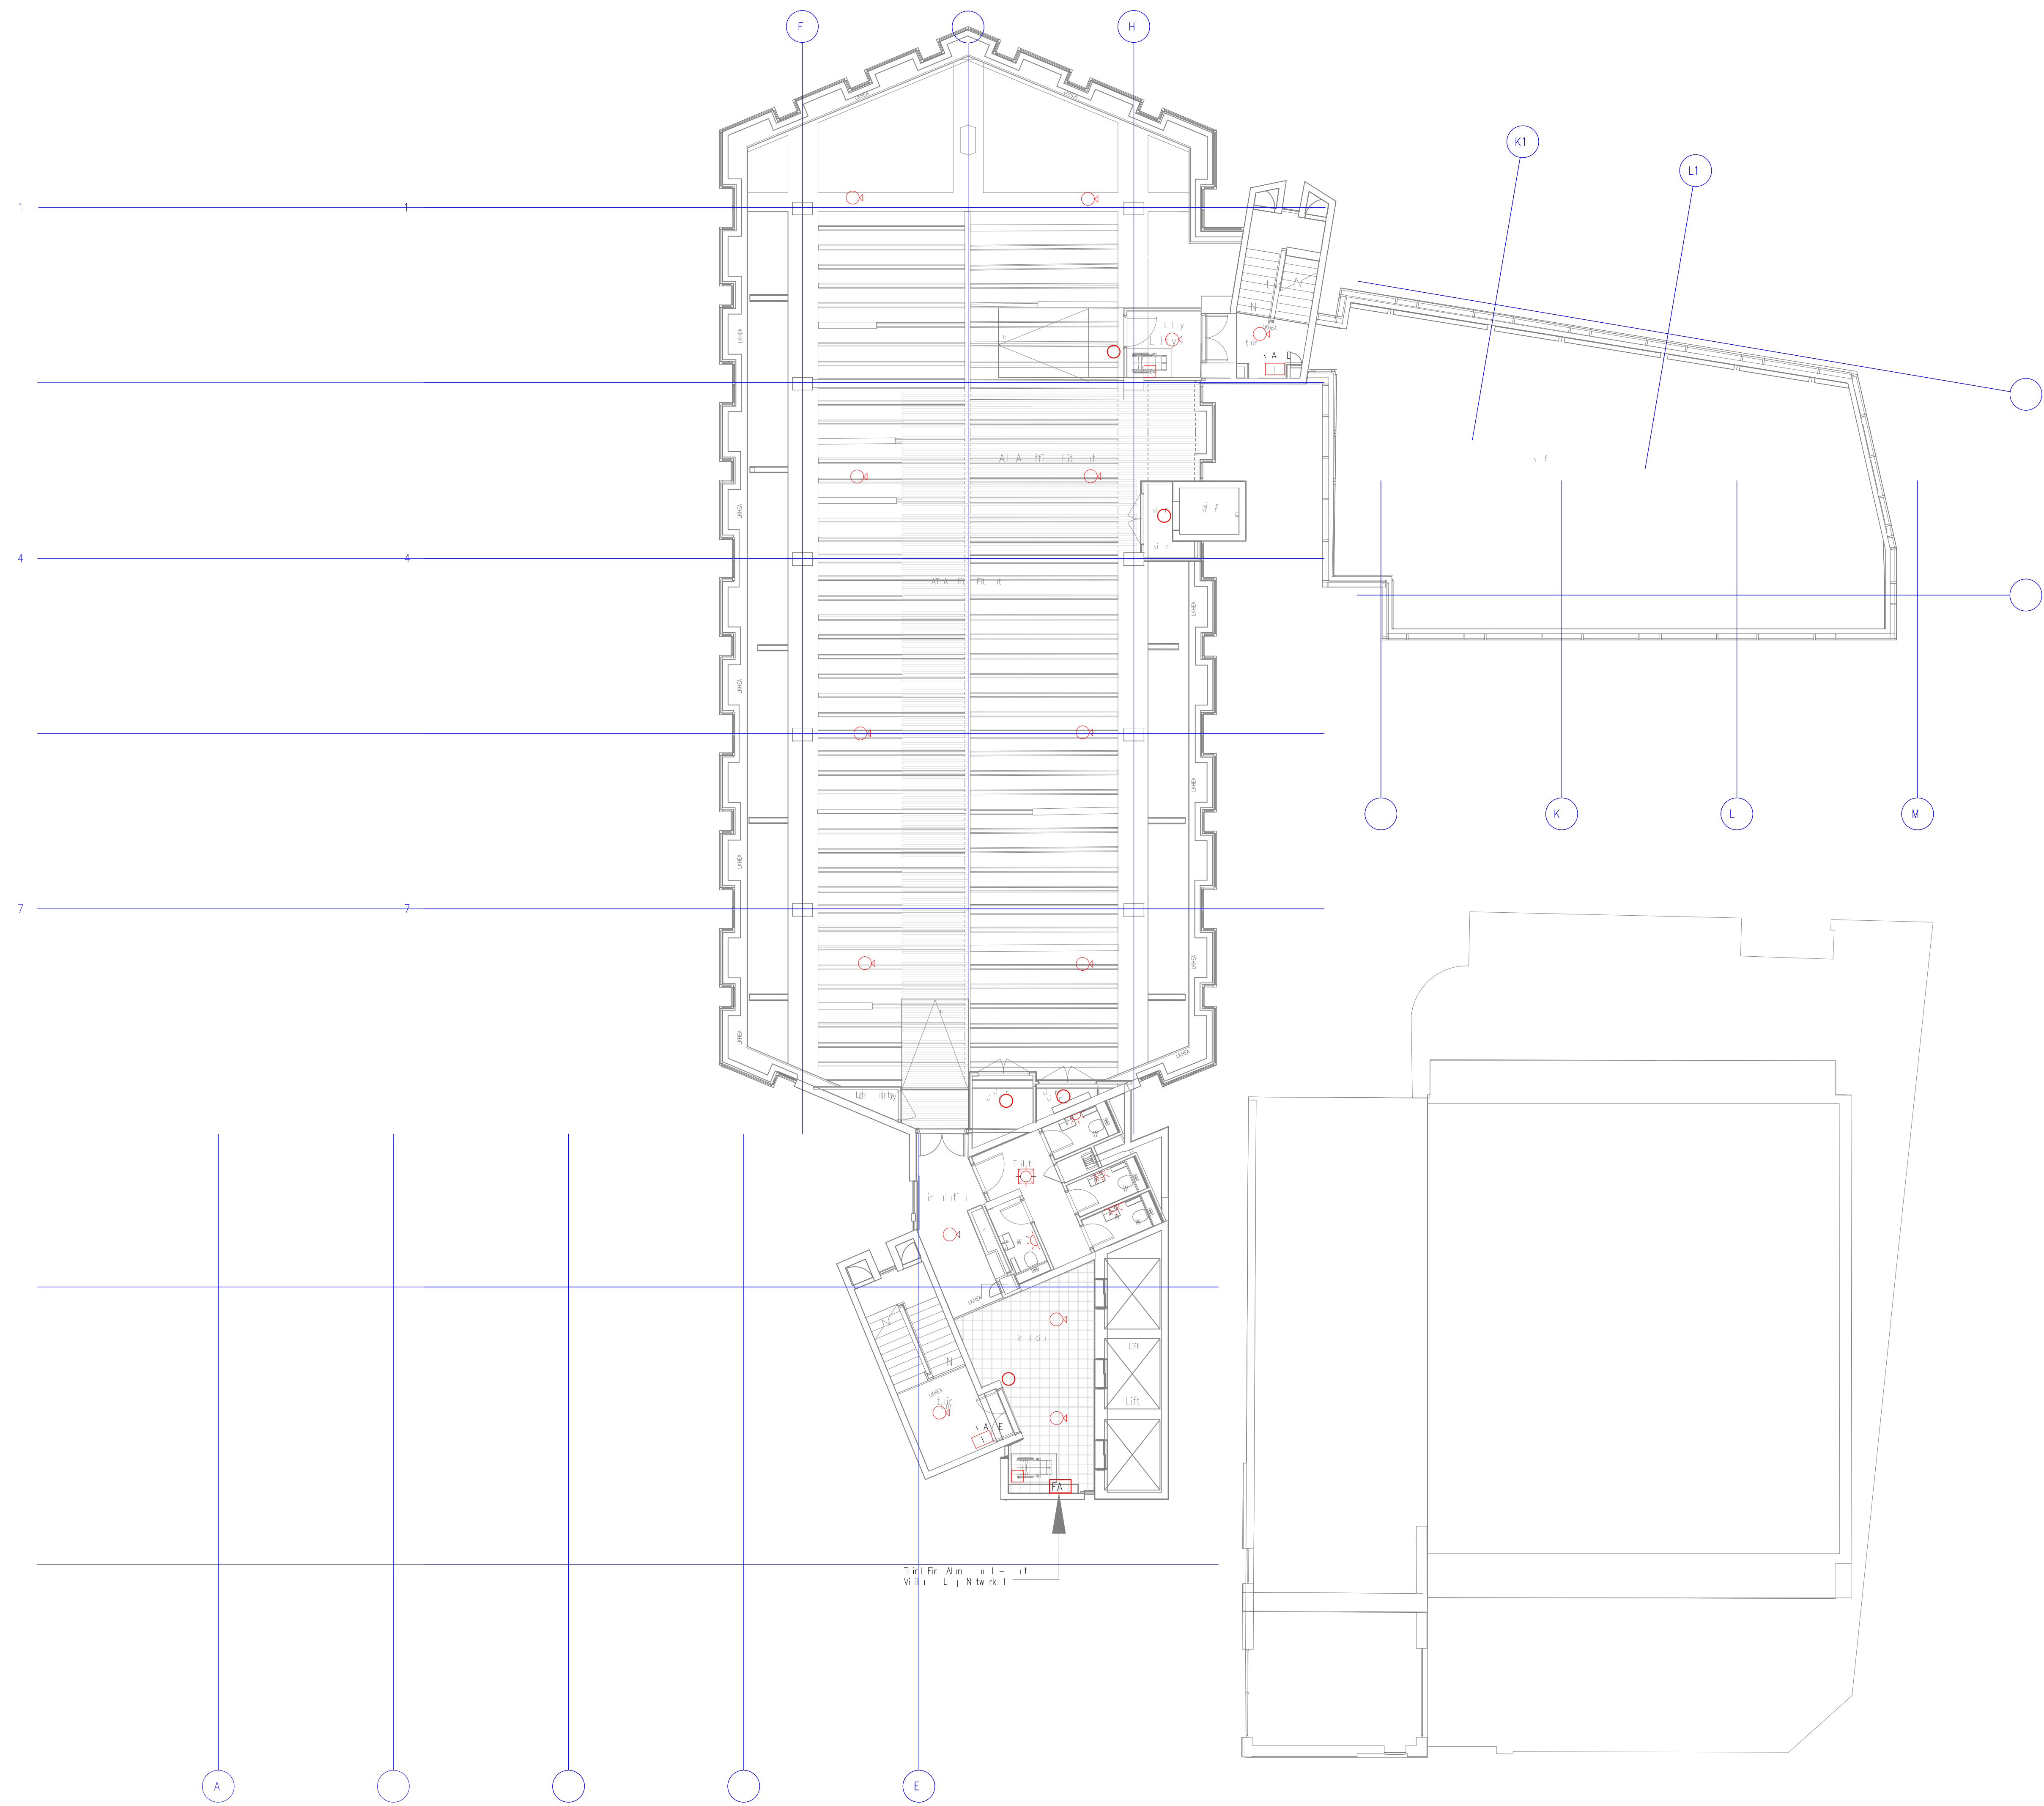

	DEVILIN - FIVE ALA-MANIEL A E	K	A	
	DEVILIN A E N-AM LL MMENT - K	K	A	
1	FILIT E			
1	1951	1951	1951	1951

BASED ON: 35207 Level 07 to 10 Ceiling Plan XREF CLEANED

PRELIMINARY



Unit 6, North Staffs Business Park
Innovation Way, Staffs ST64BF.
Email : info@carterelectrical.co.uk
Telephone: 01782 822250
www.carterelectrical.co.uk



PALL MALL
MANCHESTER

SEVENTH FLOOR
FIRE DETECTION & ALARM
LAYOUT


Architect: SHEPPARD ROBSON

Consultant: **RAMBOLL**



Designer: PG	Project Manager: CB	CAD: PG	Checked: MD
Date: 06.02.2023	Project Number: CES561	Scale: 1:100	A0

Drawing No. 6911-CES-XX-07-DR-E-6709 Rev.

 Copyright, Carter Electrical Services LTD
Contractors are to check all dimensions on site and refer any
discrepancies to Carter Electrical immediately



FIXE ALA-M	
YM L	E N T I N
	FI-E ALA-M ANEL
	ANAL E TI AL M KE ETE T V
	M KE ETE T V x N E V
	M KE ETE T V x N E V EA N
	HEAT ETE T V
	HEAT ETE T V x N E V
	HEAT ETE T V x N E V EA N
	MAN AL ALL INT
	A E A LE N LE HANNEL -CLAY
	N E V EA N
	-EF E ALA-M ANEL

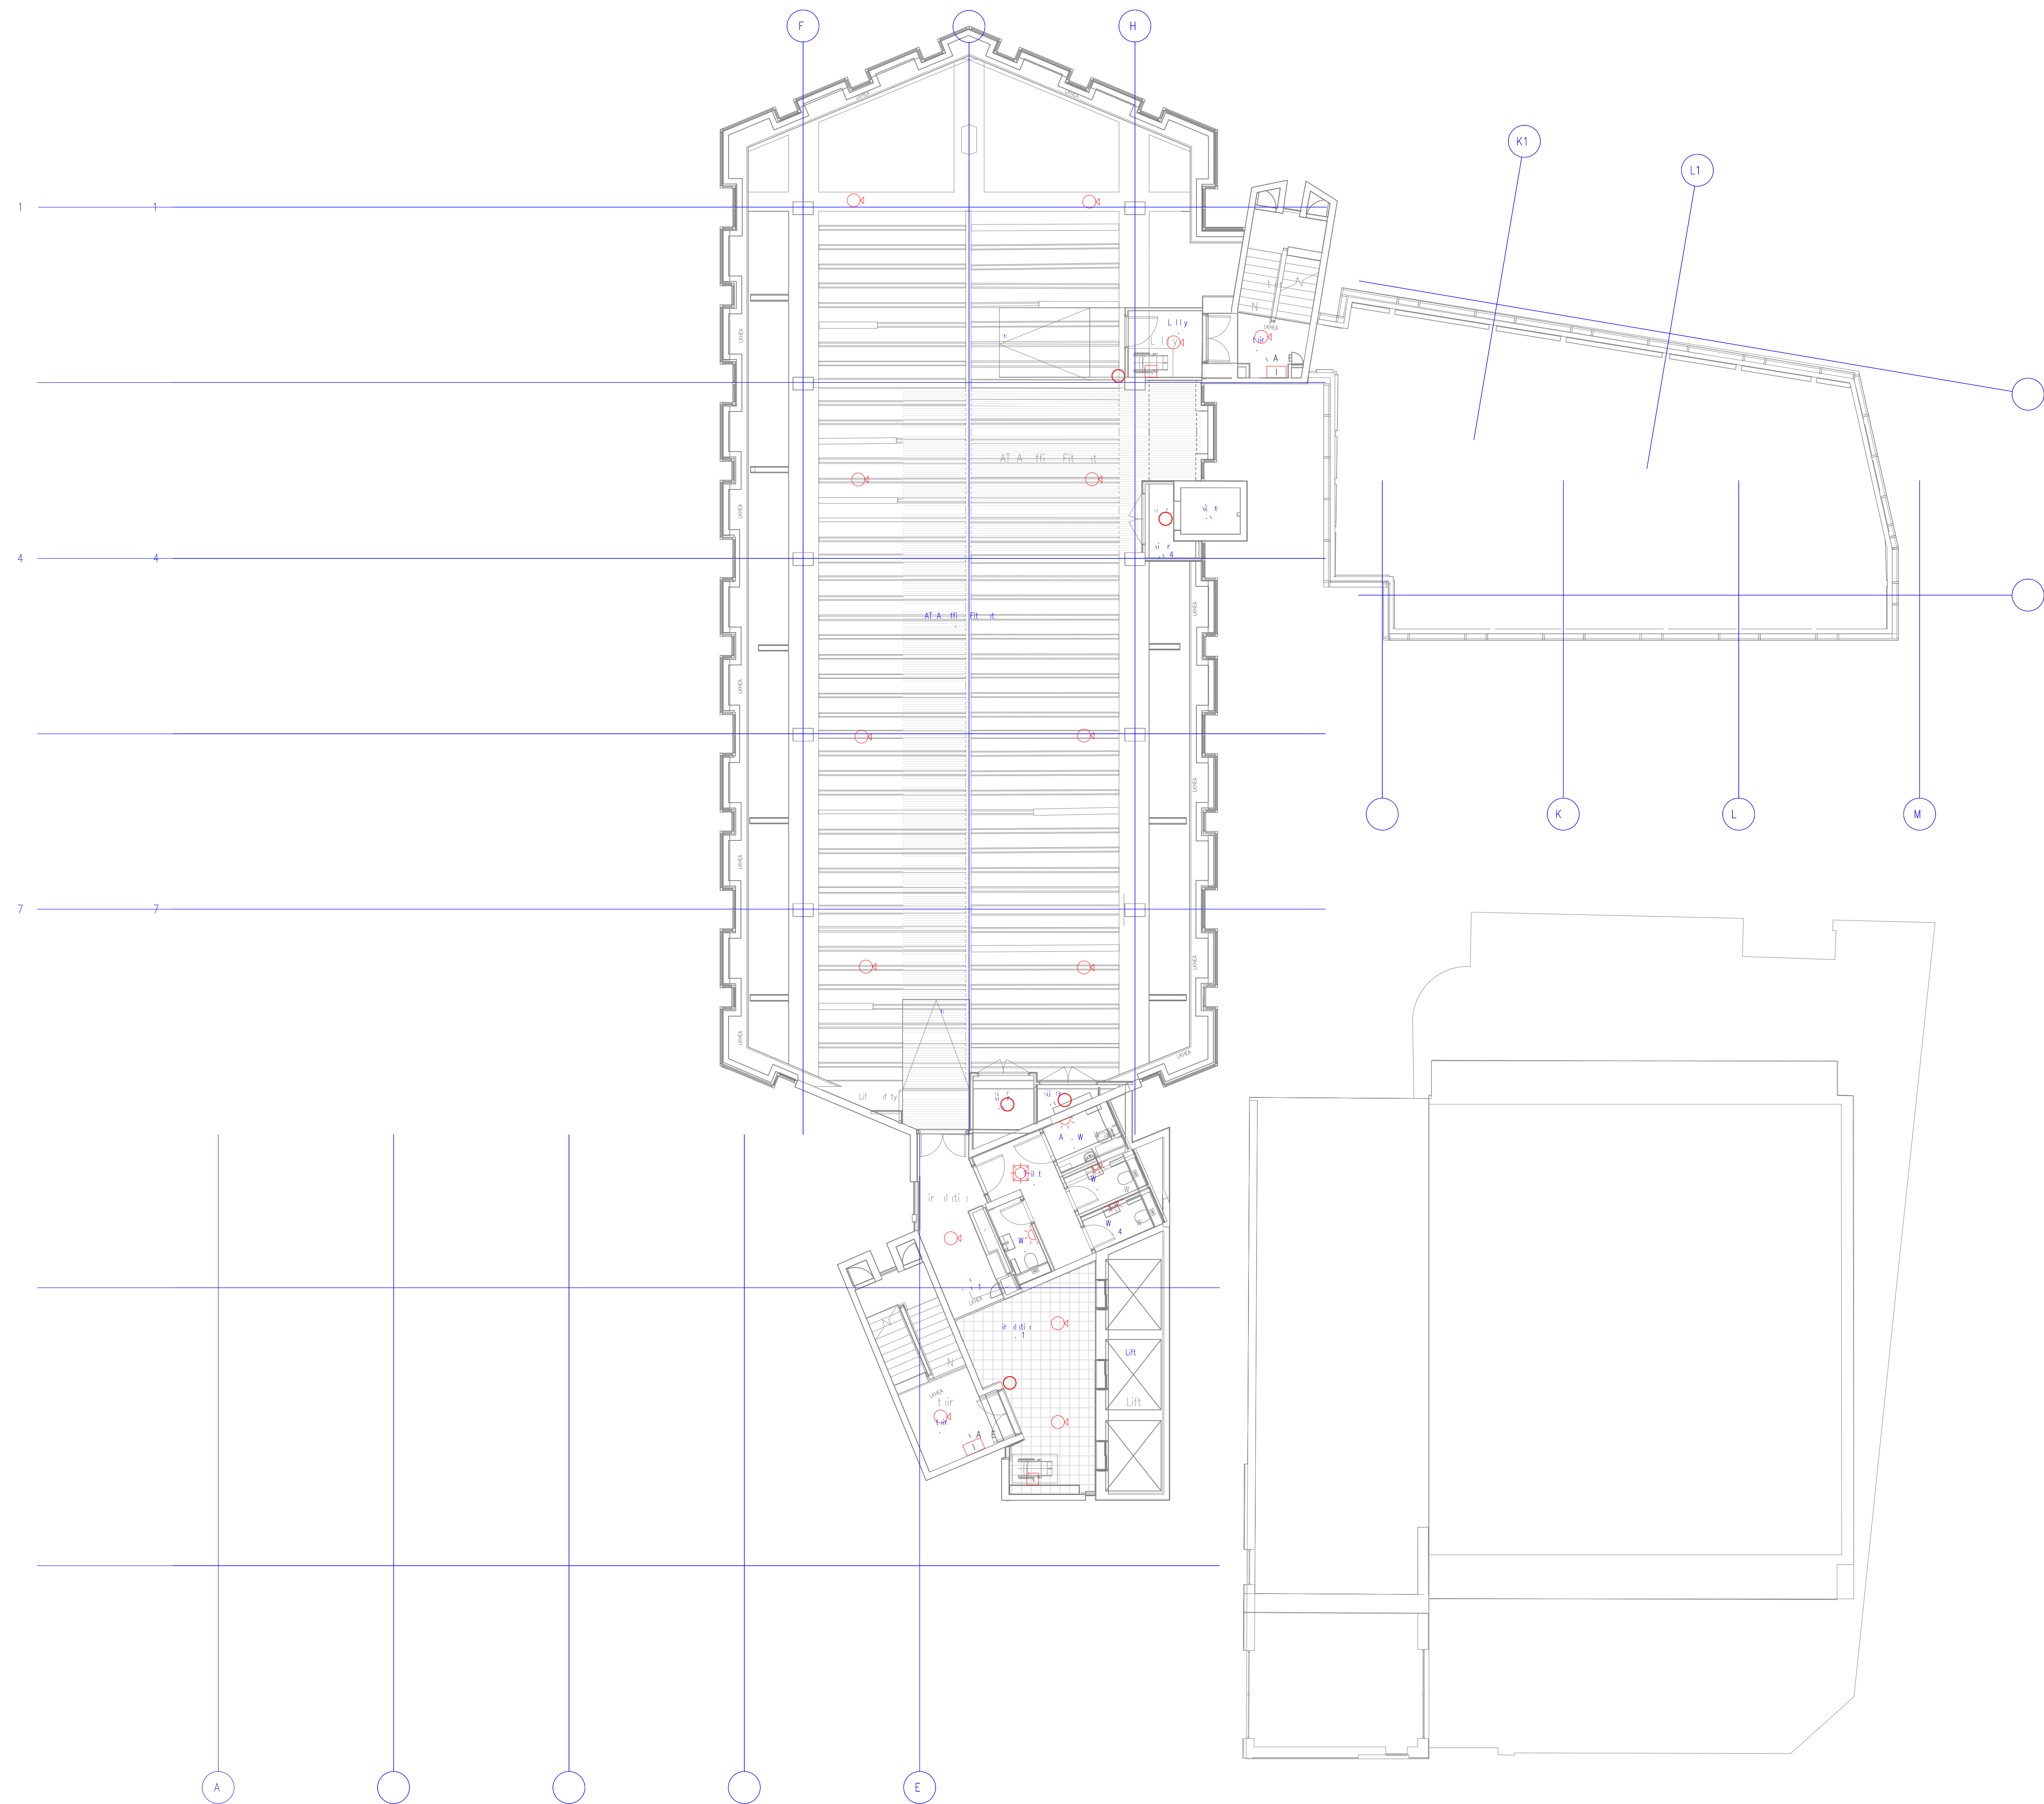 

	J	E	V	I	N	A	E	N	J	A	M	L	M	E	N	T	-	K		A		B	A
1	F	I	T	E															K		A	B	

BASED ON: 35200 Level 07 to 10 To Ceiling Plan VREF CLEANED - P10

Drawing Status:

PRELIMINARY

Unit 4, North Staffs Business Park,
Inceston Way, Salfy 314349
Email : info@conferencedirect.co.uk
Telephone: 01782 822230
www.conferencedirect.co.uk



Project:

PALL MALL MANCHESTER

The

EIGHTH FLOOR

FIRE DETECTION & ALARM LAYOUT

SHEPPARD ROBSON

RAMBOLL


Designer: PG	Project Number: CB	Drawn: PG	Checked: MD
Date: 06.02.2023		Project Number: CES561	
Drawing No: 6911-CES--XX-08-UR-E-6710		Scale: 1:100 <div>A0</div>	

Copyright, Carter Electrical Services Ltd
Customers are to check all dimensions on site and refer any
discrepancies to Carter Electrical immediately

1:1 1 4 7 10 11 12 13 14 15m

1. I want that this is a A. I want.
N. I want that this is a A. I want.
I want that this is a A. I want.
I want that this is a A. I want.

FIXE ALAM	
YM L	E N I T I N
	FI-E ALAM ANEL
	ANAL E TI AL M KE ET V
	M KE ETET V w N E
	M KE ETET V w N E V EA N
	HEAT ETET V
	HEAT ETET V w N E
	HEAT ETET V w N E V EA N
	MAN AL ALL INT
	A LE A LE IN LE HANNEL LAY
	N E EA N
	JE E ALAM ANEL

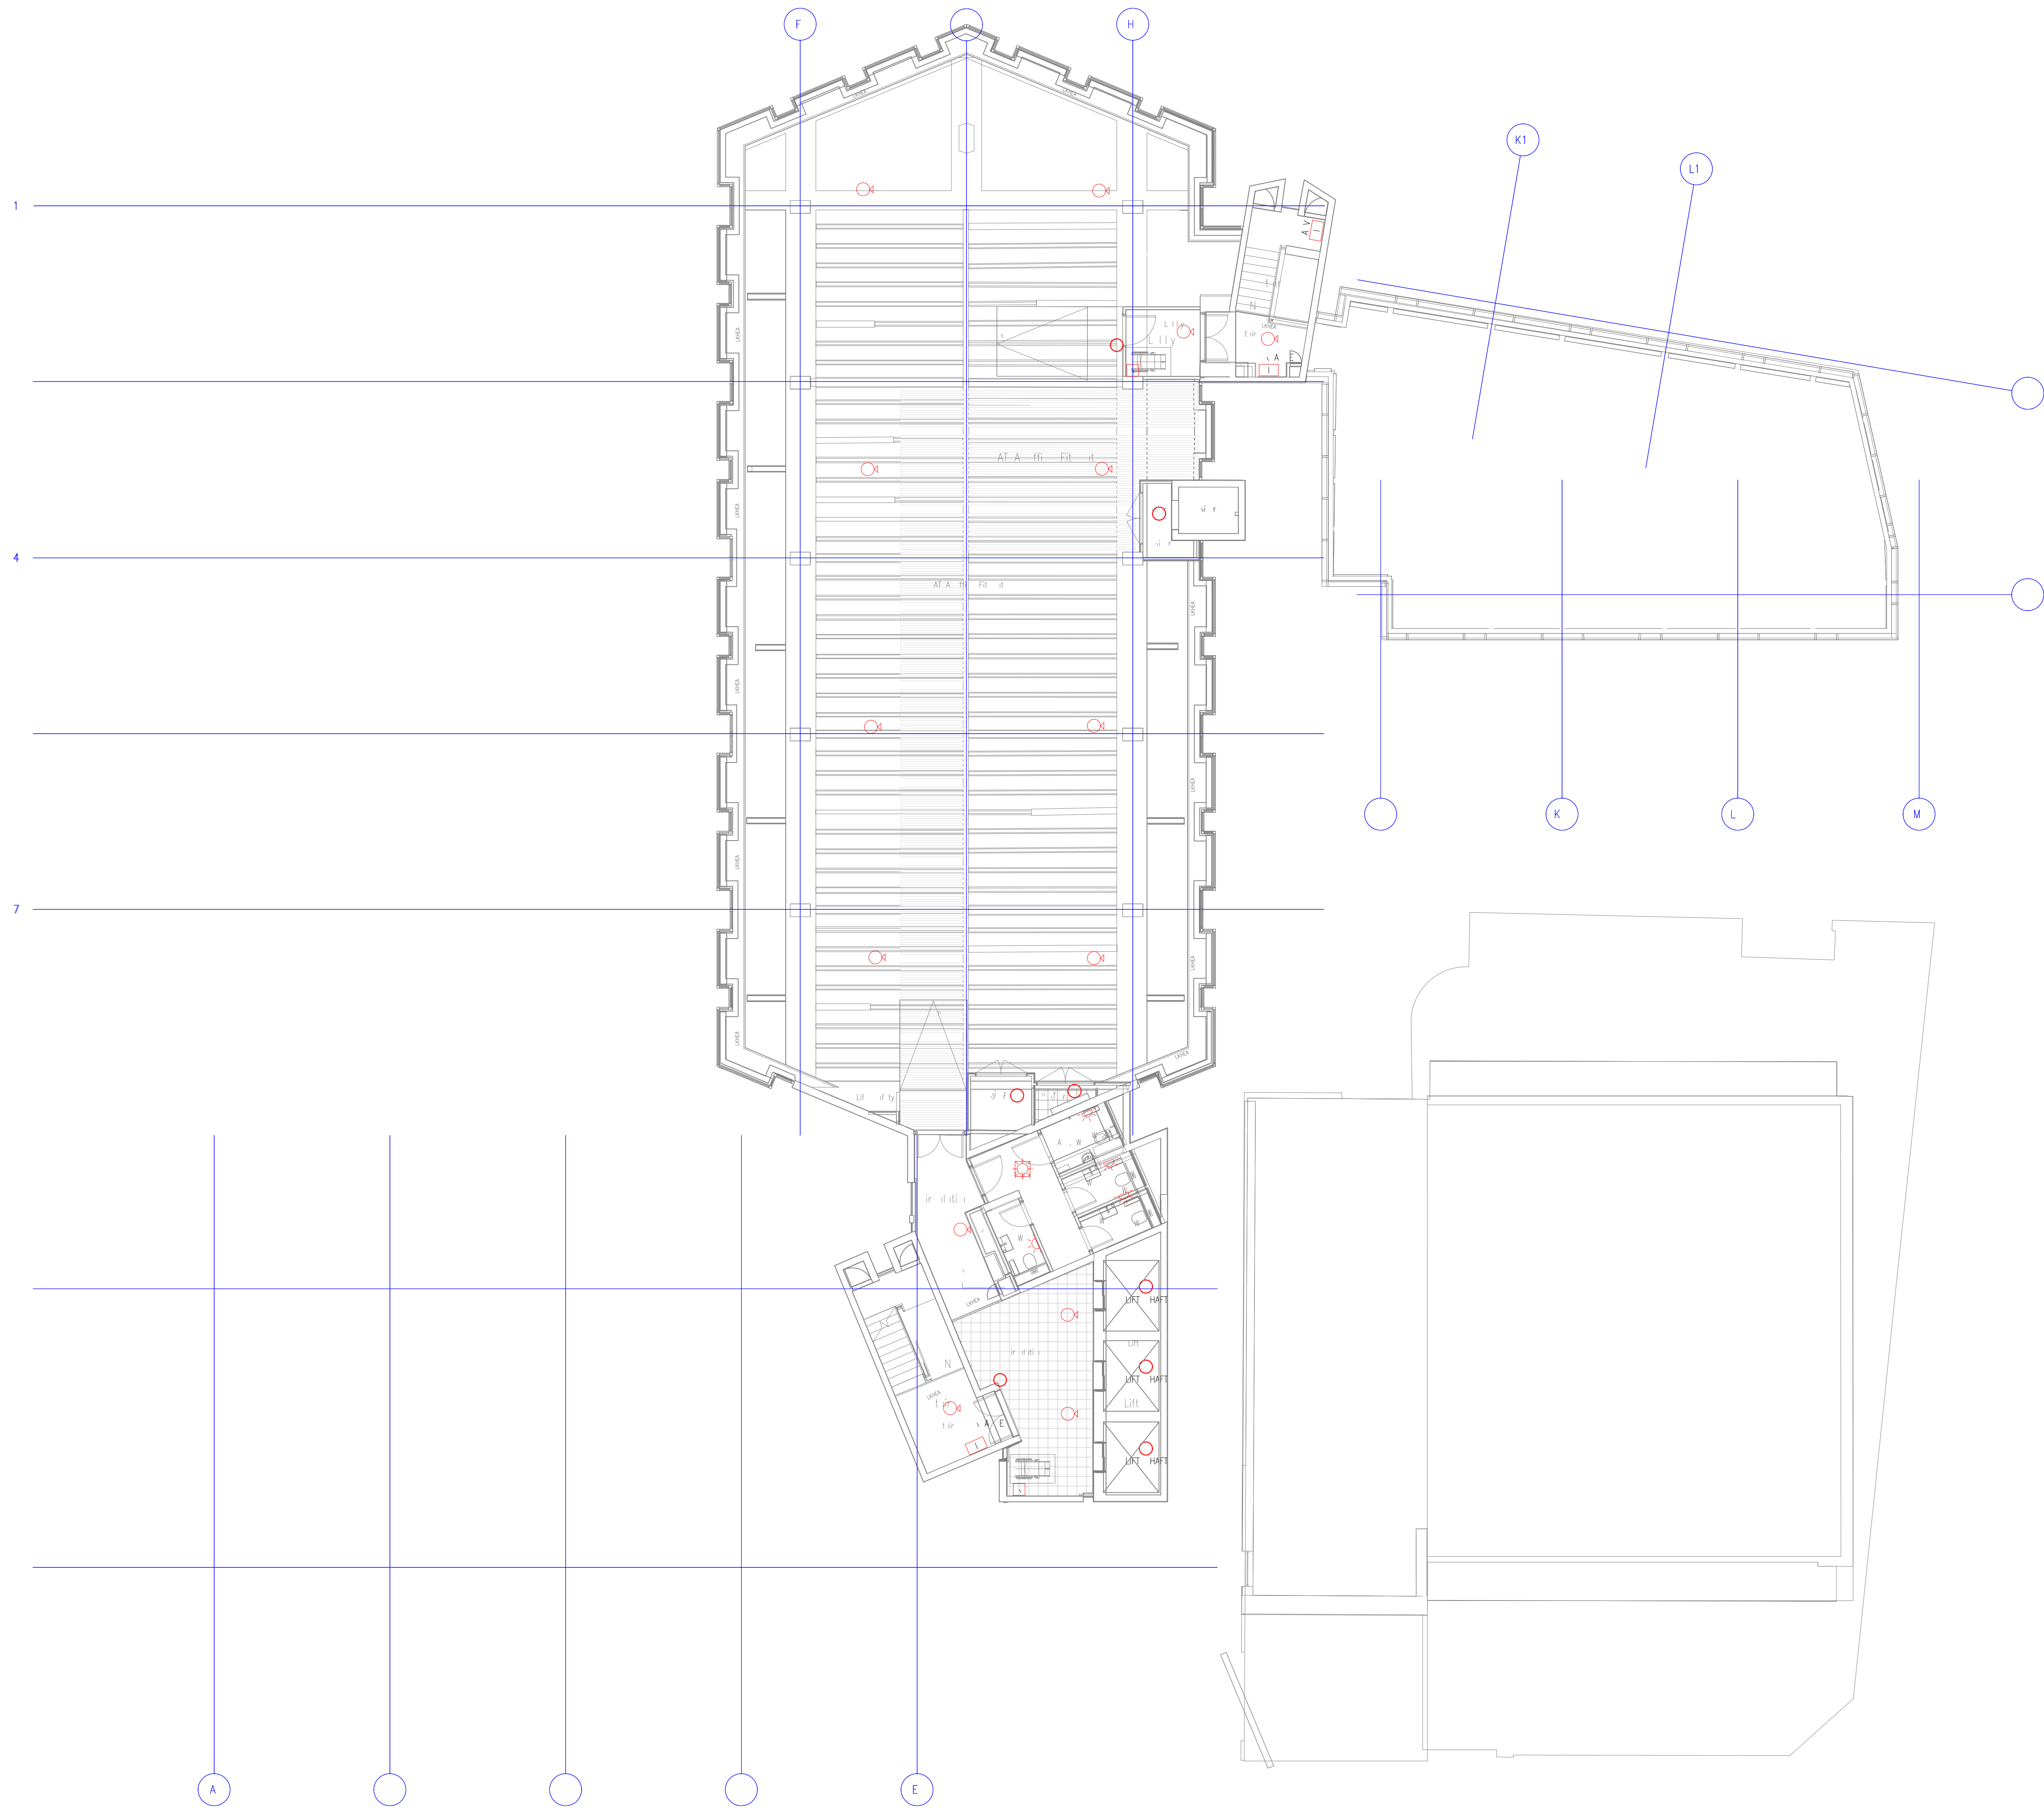

	EVIN AEN AM LL MMENT -K	K	A	Mc 4.
1	FL T I E			
1.1	FL T I E	FL T I E	FL T I E	FL T I E

BASED ON: 35207 Level 07 to 10 Ceiling Plan XREF CLEANED

PRELIMINARY



Unit 6, North Staffs Business Park
Innovation Way, Staffs ST64BF.
Email : info@carterelectrical.co.uk
Telephone: 01782 822250



PALL MALL
MANCHESTER

TEN
TENTH FLOOR

Architect: SHEPPARD ROBSON


Consultant: **RAMBOLL**

Designer: PG	Project Manager: CB	CAD: PG	Checked: MD
Date: 06/02/2023	Project Number: C55561	Scale: 1:100	40

6011	056	XX	10	00	5	6710	6	△
------	-----	----	----	----	---	------	---	---


09111-CL5-XX-10-DR-E-0712	P02
Copyright: Carter Electrical Services LTD	

 Contractors are to check all dimensions on site and refer any discrepancies to Carter Electrical immediately



1. I want that this is a A. I want.
N. I want that this is a A. I want.
I want that this is a A. I want.
I want that this is a A. I want.

YM	L	E	N	T	I	N
		F	I	E	A	A-M ANEL
		A	N	E	E	T
		M	N	E	E	T
		M	N	E	E	T
		H	E	A	T	E
		H	E	A	T	E
		H	E	A	T	E
		M	A	N	A	L
		A	E	A	L	E
		N	E	E	A	N
		J	E	F	E	A

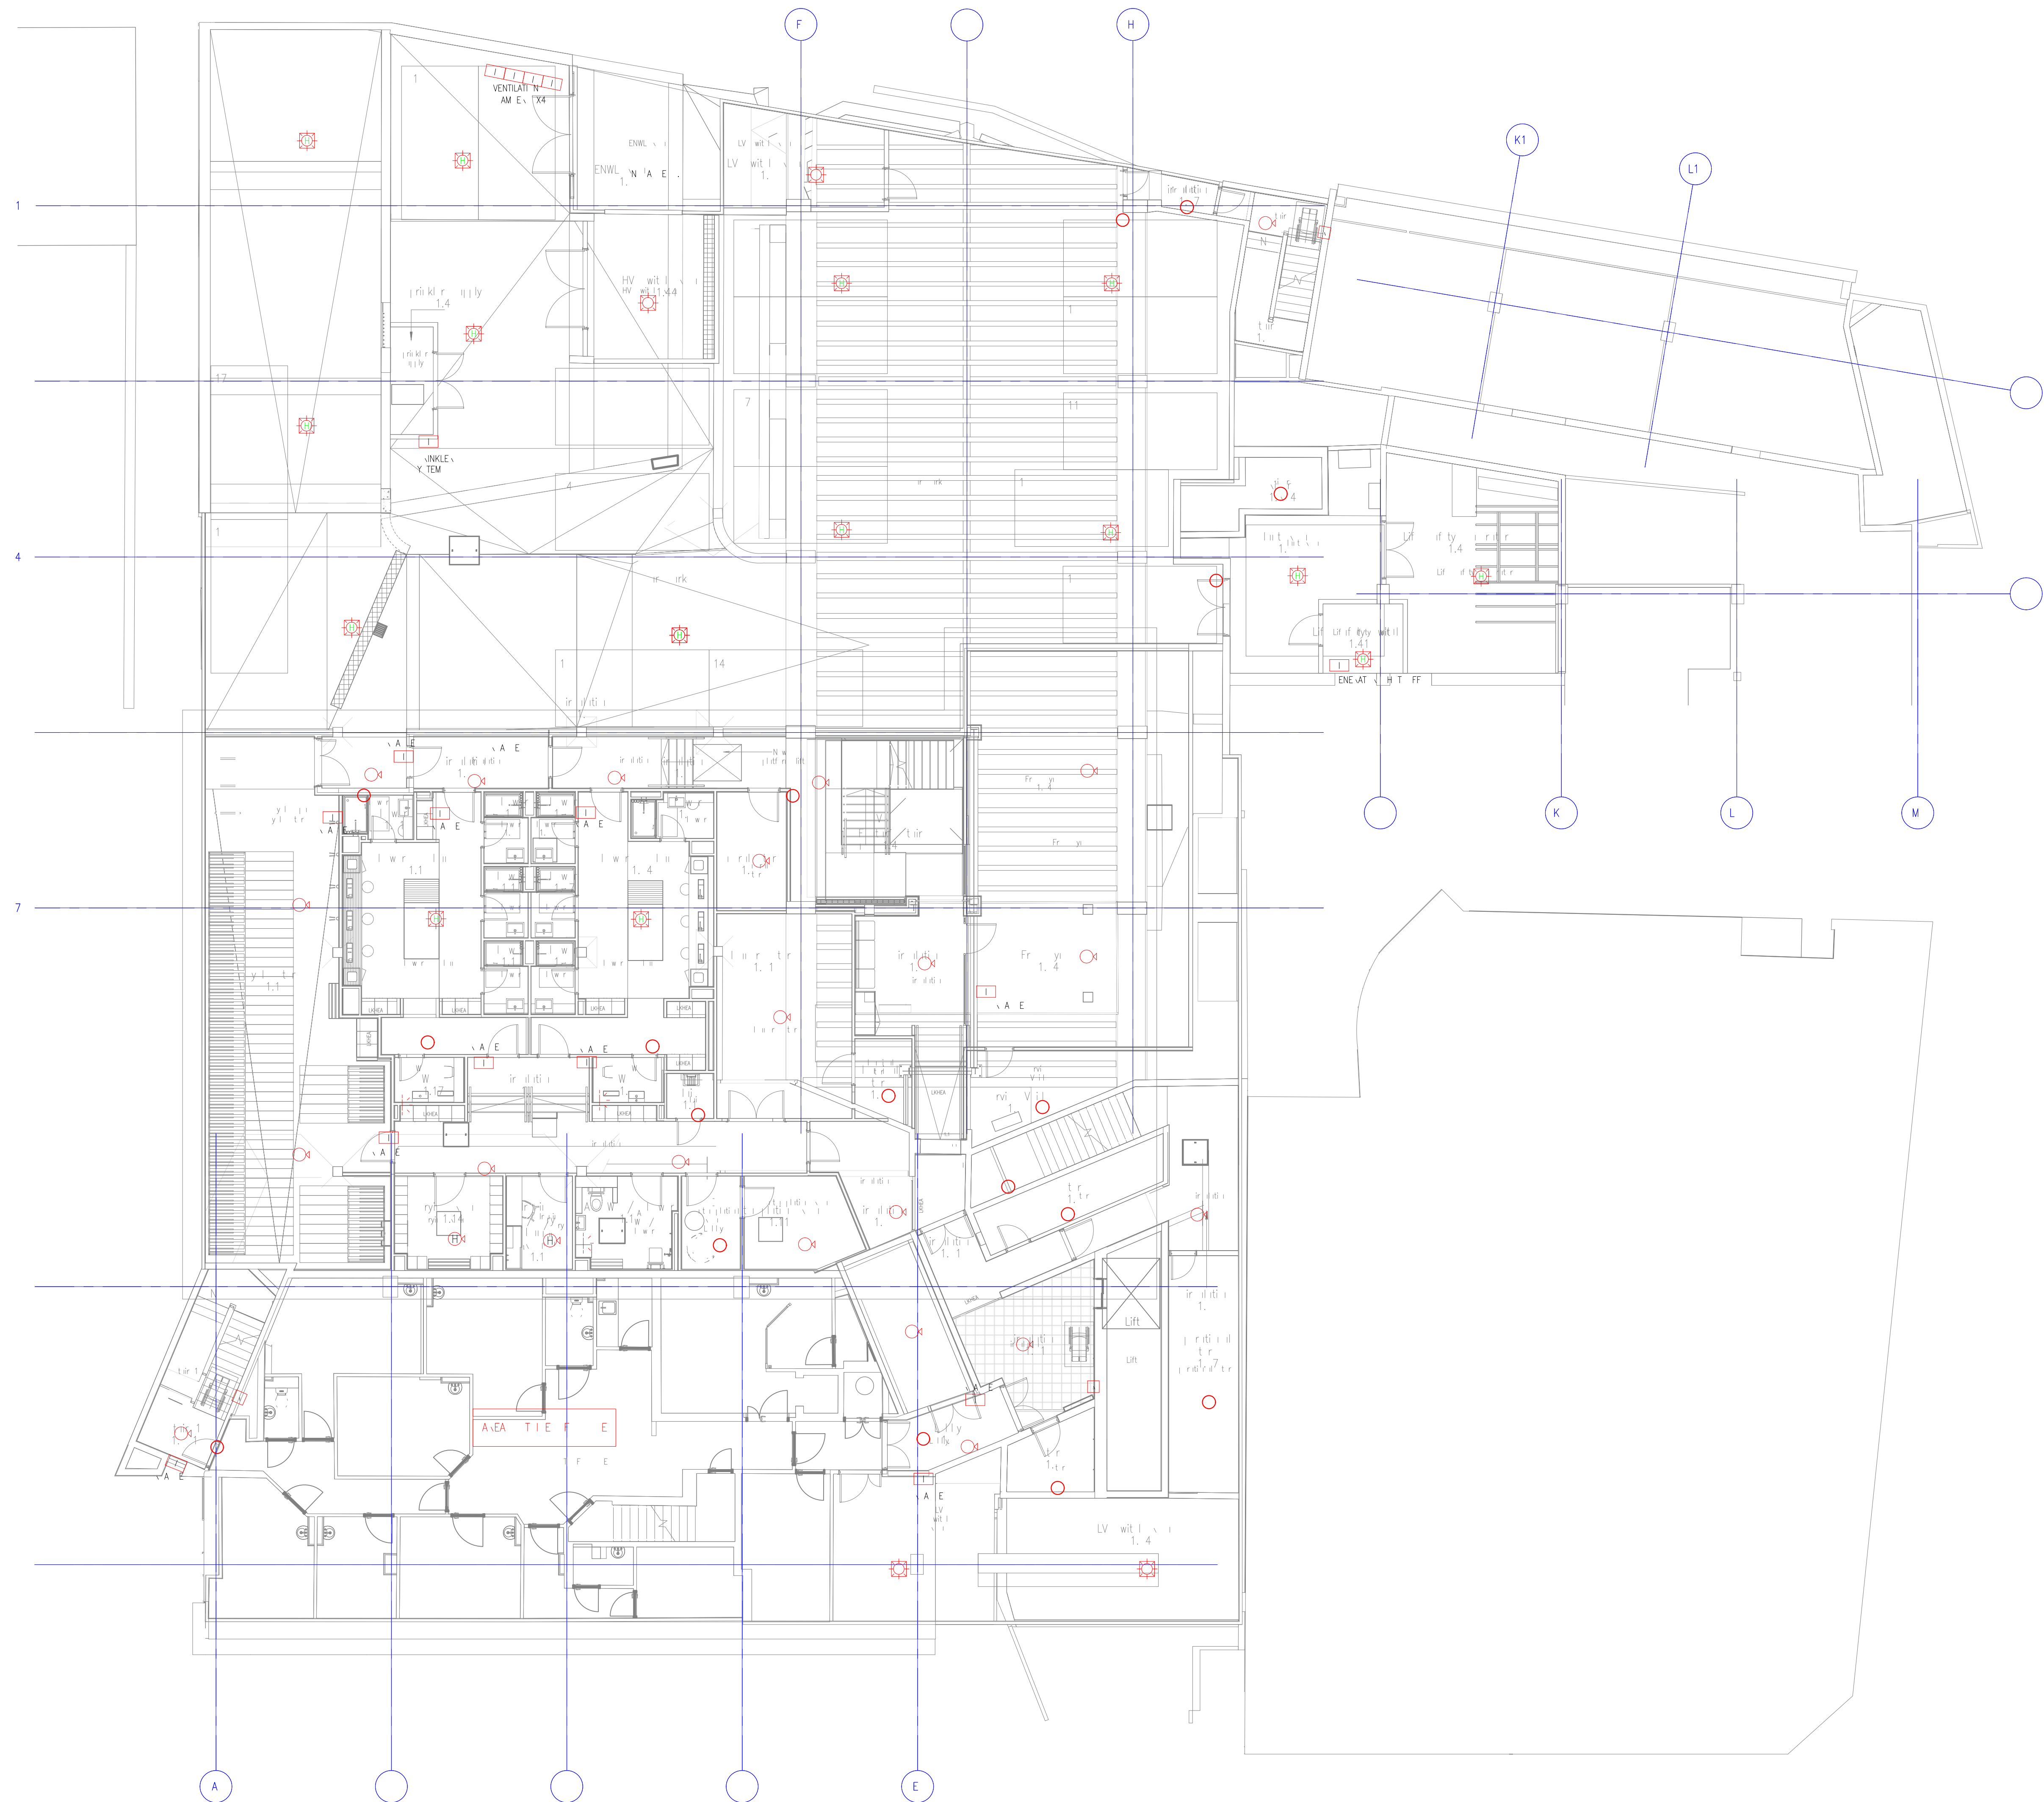

	DEVIN A E N JAM LL MMENT -K	K	A	2
1	FL T I E			

BASED ON 35198 Level Basement Ceiling Plan XREF CLEANED - P10

PRELIMINARY

Unit 6, North Staffs Business Park
Innovation Way, Staffs ST64BF.
Email : info@carterelectrical.co.uk
Telephone: 01782 822250

Project:
PALL MALL
MANCHESTER

BASEMENT
FIRE DETECTION & ALARM
LAYOUT

PPARD ROBSON

BOLL


Project Manager, CB	CEO, PG
---------------------	---------

Report Number: CE3301

CES-XX-B1-DR-E-670

Copyright: Carter Electrical Services LTD
Contractors are to check all dimensions on site and refer any
discrepancies to Carter Electrical immediately

FIVE ALA M	
YM L	E T I N
	FIVE ALA M ANEL
	ANAL E T I AL M KE ETE T
	M KE ETE T, M N E
	M KE ETE T, M N E/ EA N
	HEAT ETE T
	HEAT ETE T, M N E
	HEAT ETE T, M N E/ EA N
	MAN AL ALL INT
	A E ALE IN LE HANNE LAY
	N E, EA N
	JE F ALA M ANEL

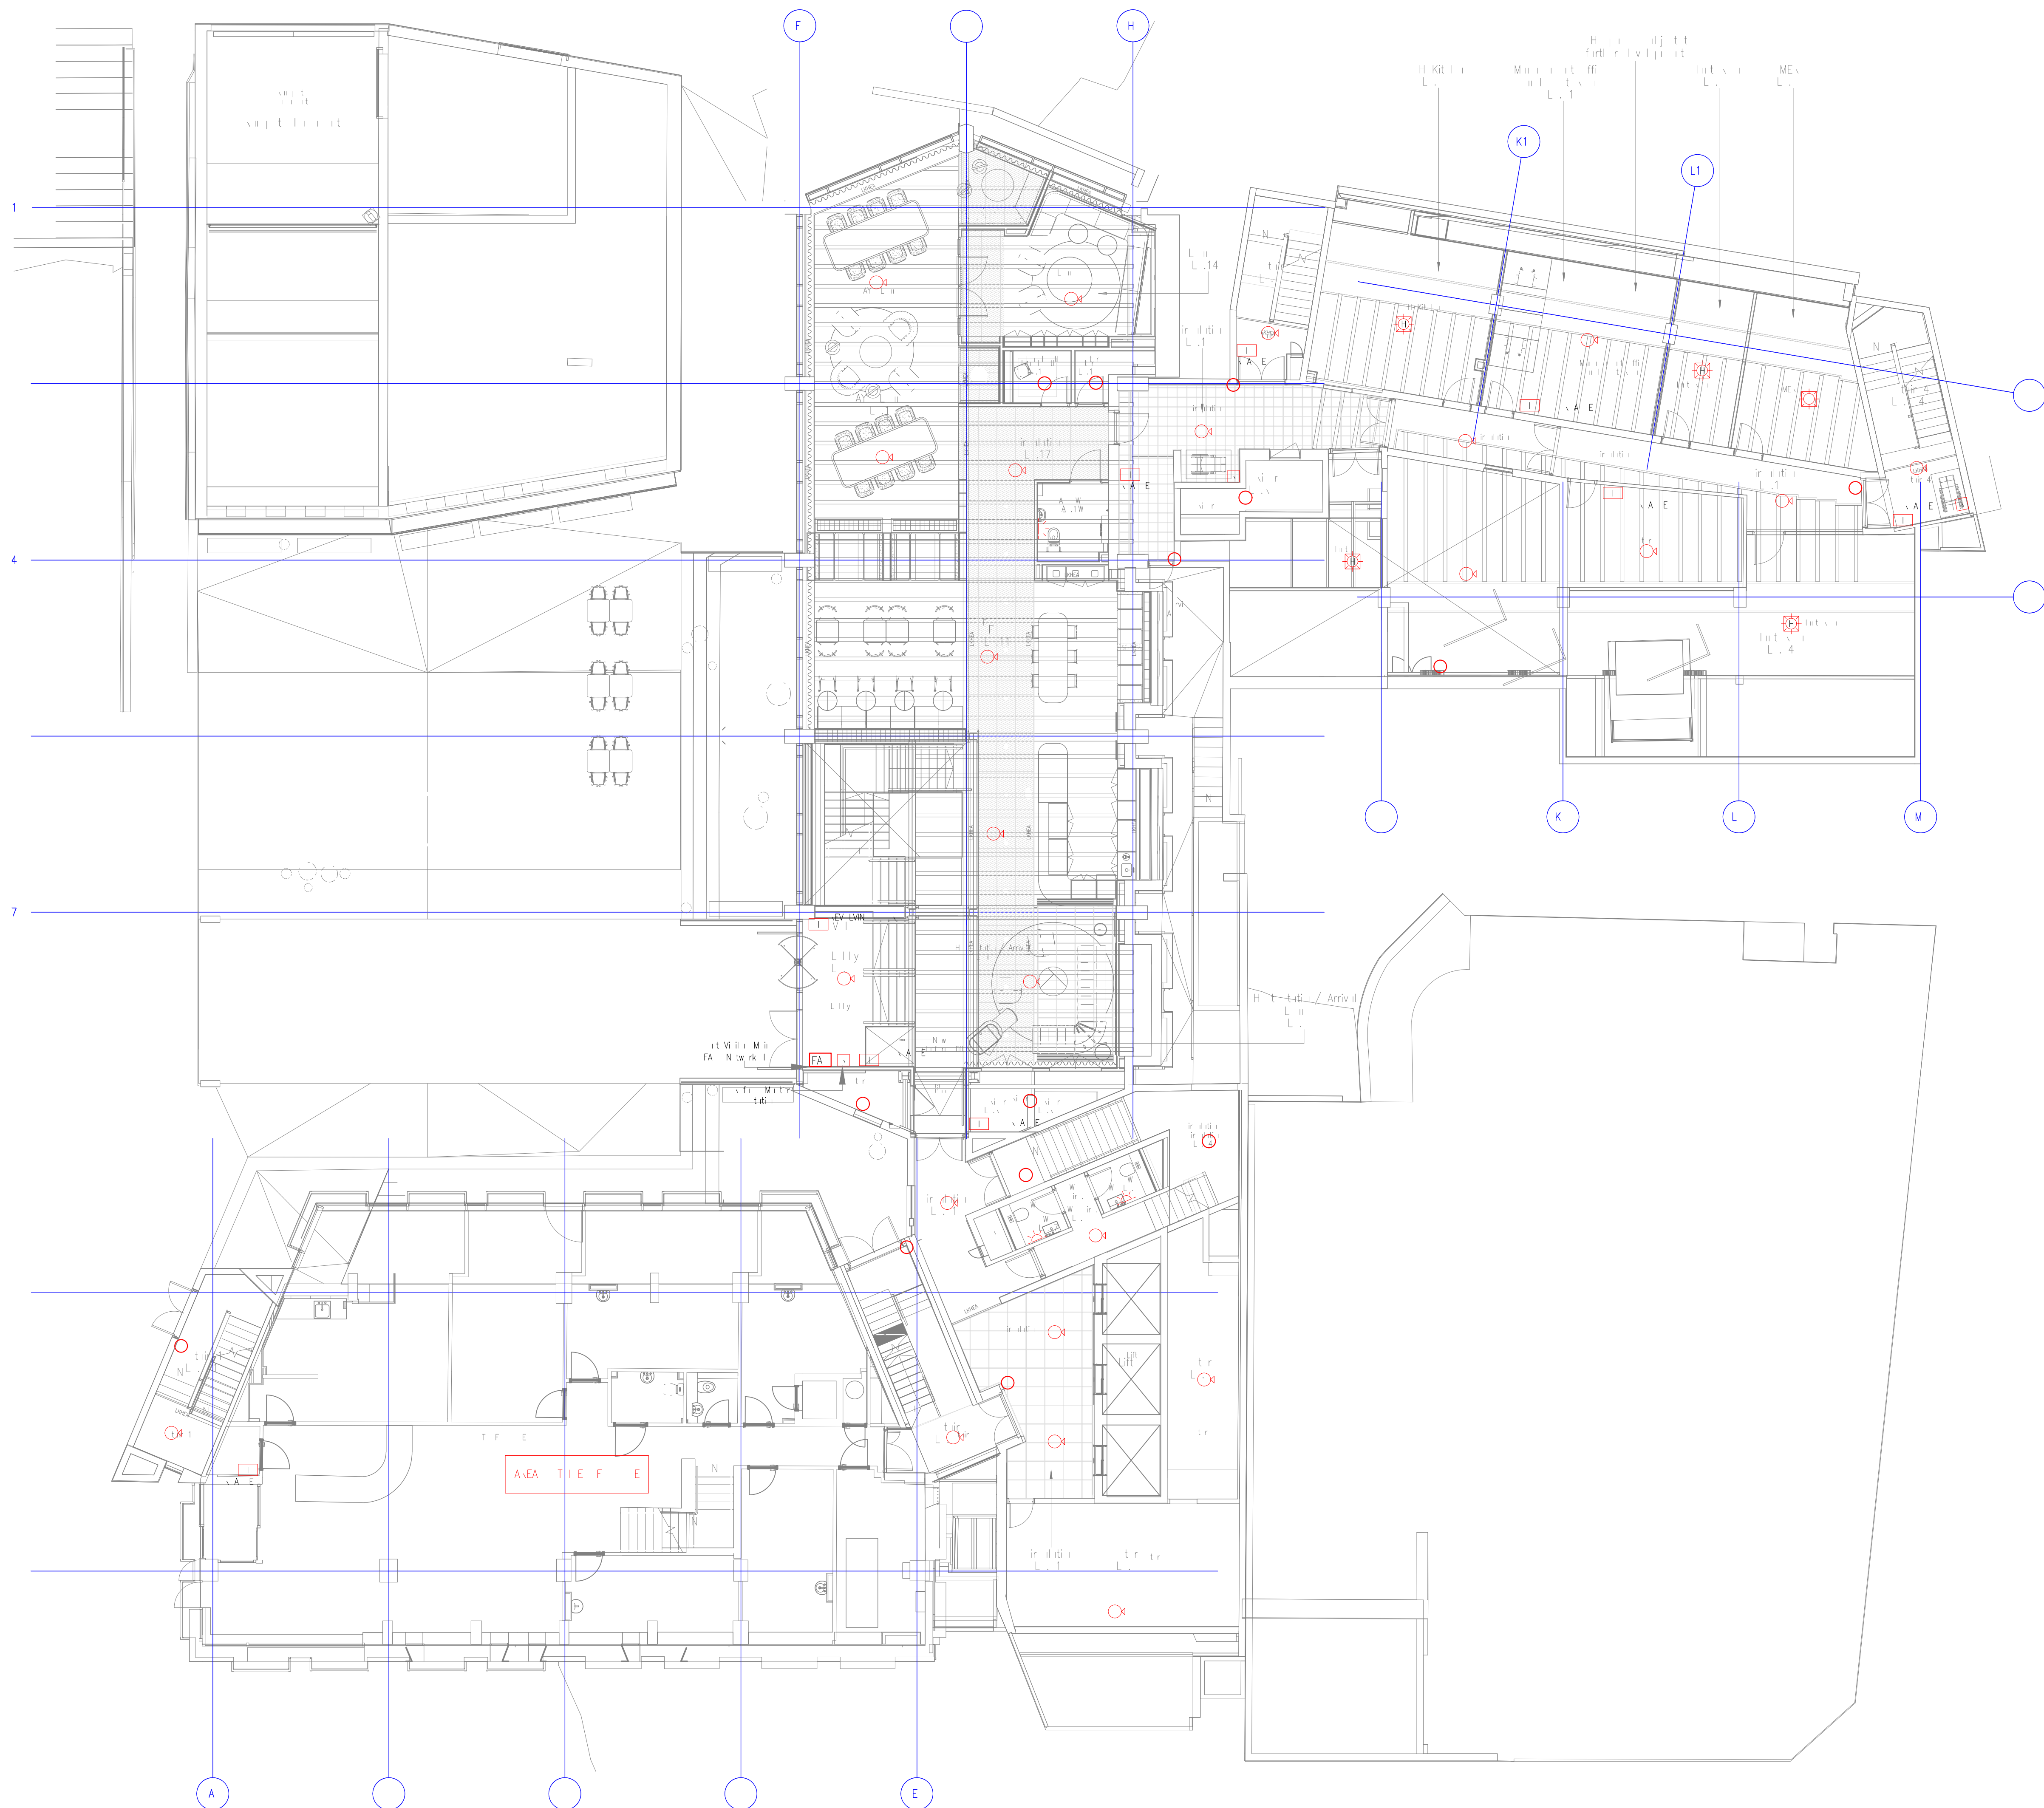

	DEVIN A E N JAM LL MMENT -K	K	A	me
1	FLA T I E			

BASED ON 35189 Level Lower Ground Ceiling Plan XREF CLEANED - P11

PRELIMINARY

114

Unit 6, North Staffs Business Park
Innovation Way, Staffs ST64BF.
Email : info@carterelectrical.co.uk
Telephone: 01782 822250



Project.

PALL MALL
MANCHESTER

LOWER GROUND FLOOR
FIRE DETECTION & ALARM
LAYOUT

Architect: SHEPPARD ROBSON

Consultant	RAMBOLL
------------	---------

Designer, PG	Project Manager, CB	CAO, PO
--------------	---------------------	---------

Date: 06.02.2023	Project Number: CES561	Scale: 1:100	AO
------------------	------------------------	--------------	----


Drawing No. 6911-CFS-XX-LG-DB-F-670

Copyright, Carter Electrical Services LTD
Contractors are to check all dimensions on site and refer any
discrepancies to Carter Electrical immediately

1. I want that this is a A. I want.
N. I want that this is a A. I want.
I want that this is a A. I want.
I want that this is a A. I want.

FIXE ALAM	
YM L	E N I T I N
	FI-E ALA-M ANEL
	ANAL E TI AL M KE ETE T v
	M KE ETE T v w N E v
	M KE ETE T v w N E v EA N
	HEAT ETE T v
	HEAT ETE T v w N E v
	HEAT ETE T v w N E v EA N
	MAN AL ALL INT
	A LE A LE IN LE HANNEL LELAY
	N E v EA N
	JEFF E ALA-M ANEL


	EVIN A E N AM LL MMENT -K	K	A	Mc 4.
1	FL T I E			
1.1	FL T I E	FL T I E	FL T I E	FL T I E

 BASED ON: 20111 Dewhurst Floor Layout Arrangement. XREF: CLEANED - P20 Drawing Status: PRELIMINARY					
 Unit 4, North Staffs Business Park, Inceston Way, Staffs ST16 4HE Email: info@crestedsteel.co.uk Telephone: 01782 822250 www.crestedsteel.co.uk					
					
Project: PALL MALL MANCHESTER					
Title: FIRE DETECTION & ALARM LAYOUT					
SHEPPARD ROBSON					
Consultant: RAMBOLL					
Design: PS Drawn: PS Date: 06.02.2023	Project: CB Project: CES561	Job: PS Scale: 1:100	Drawn: MD Date:	A0	
Drawing No: 69111-CES-XX-RF-DR-E-6713				Rev: 	
Copyright, Carter Electrical Services LTD Customers are to check all dimensions on site and refer any discrepancies to Carter Electrical immediately					

CONTAINMENT

1. This drawing is a preliminary drawing and is not for construction. All dimensions are approximate and subject to change without notice.

CONTAINMENT	
SYM	DESCRIPTION
	LVITATION
	LAKET
	VIEATAKET
	FILEALAMTAY
	LIFEAFETYTAY
	HAETITINATION
	DN
	ATTANVEENT
	INTERSECTION
	INTERSECTION

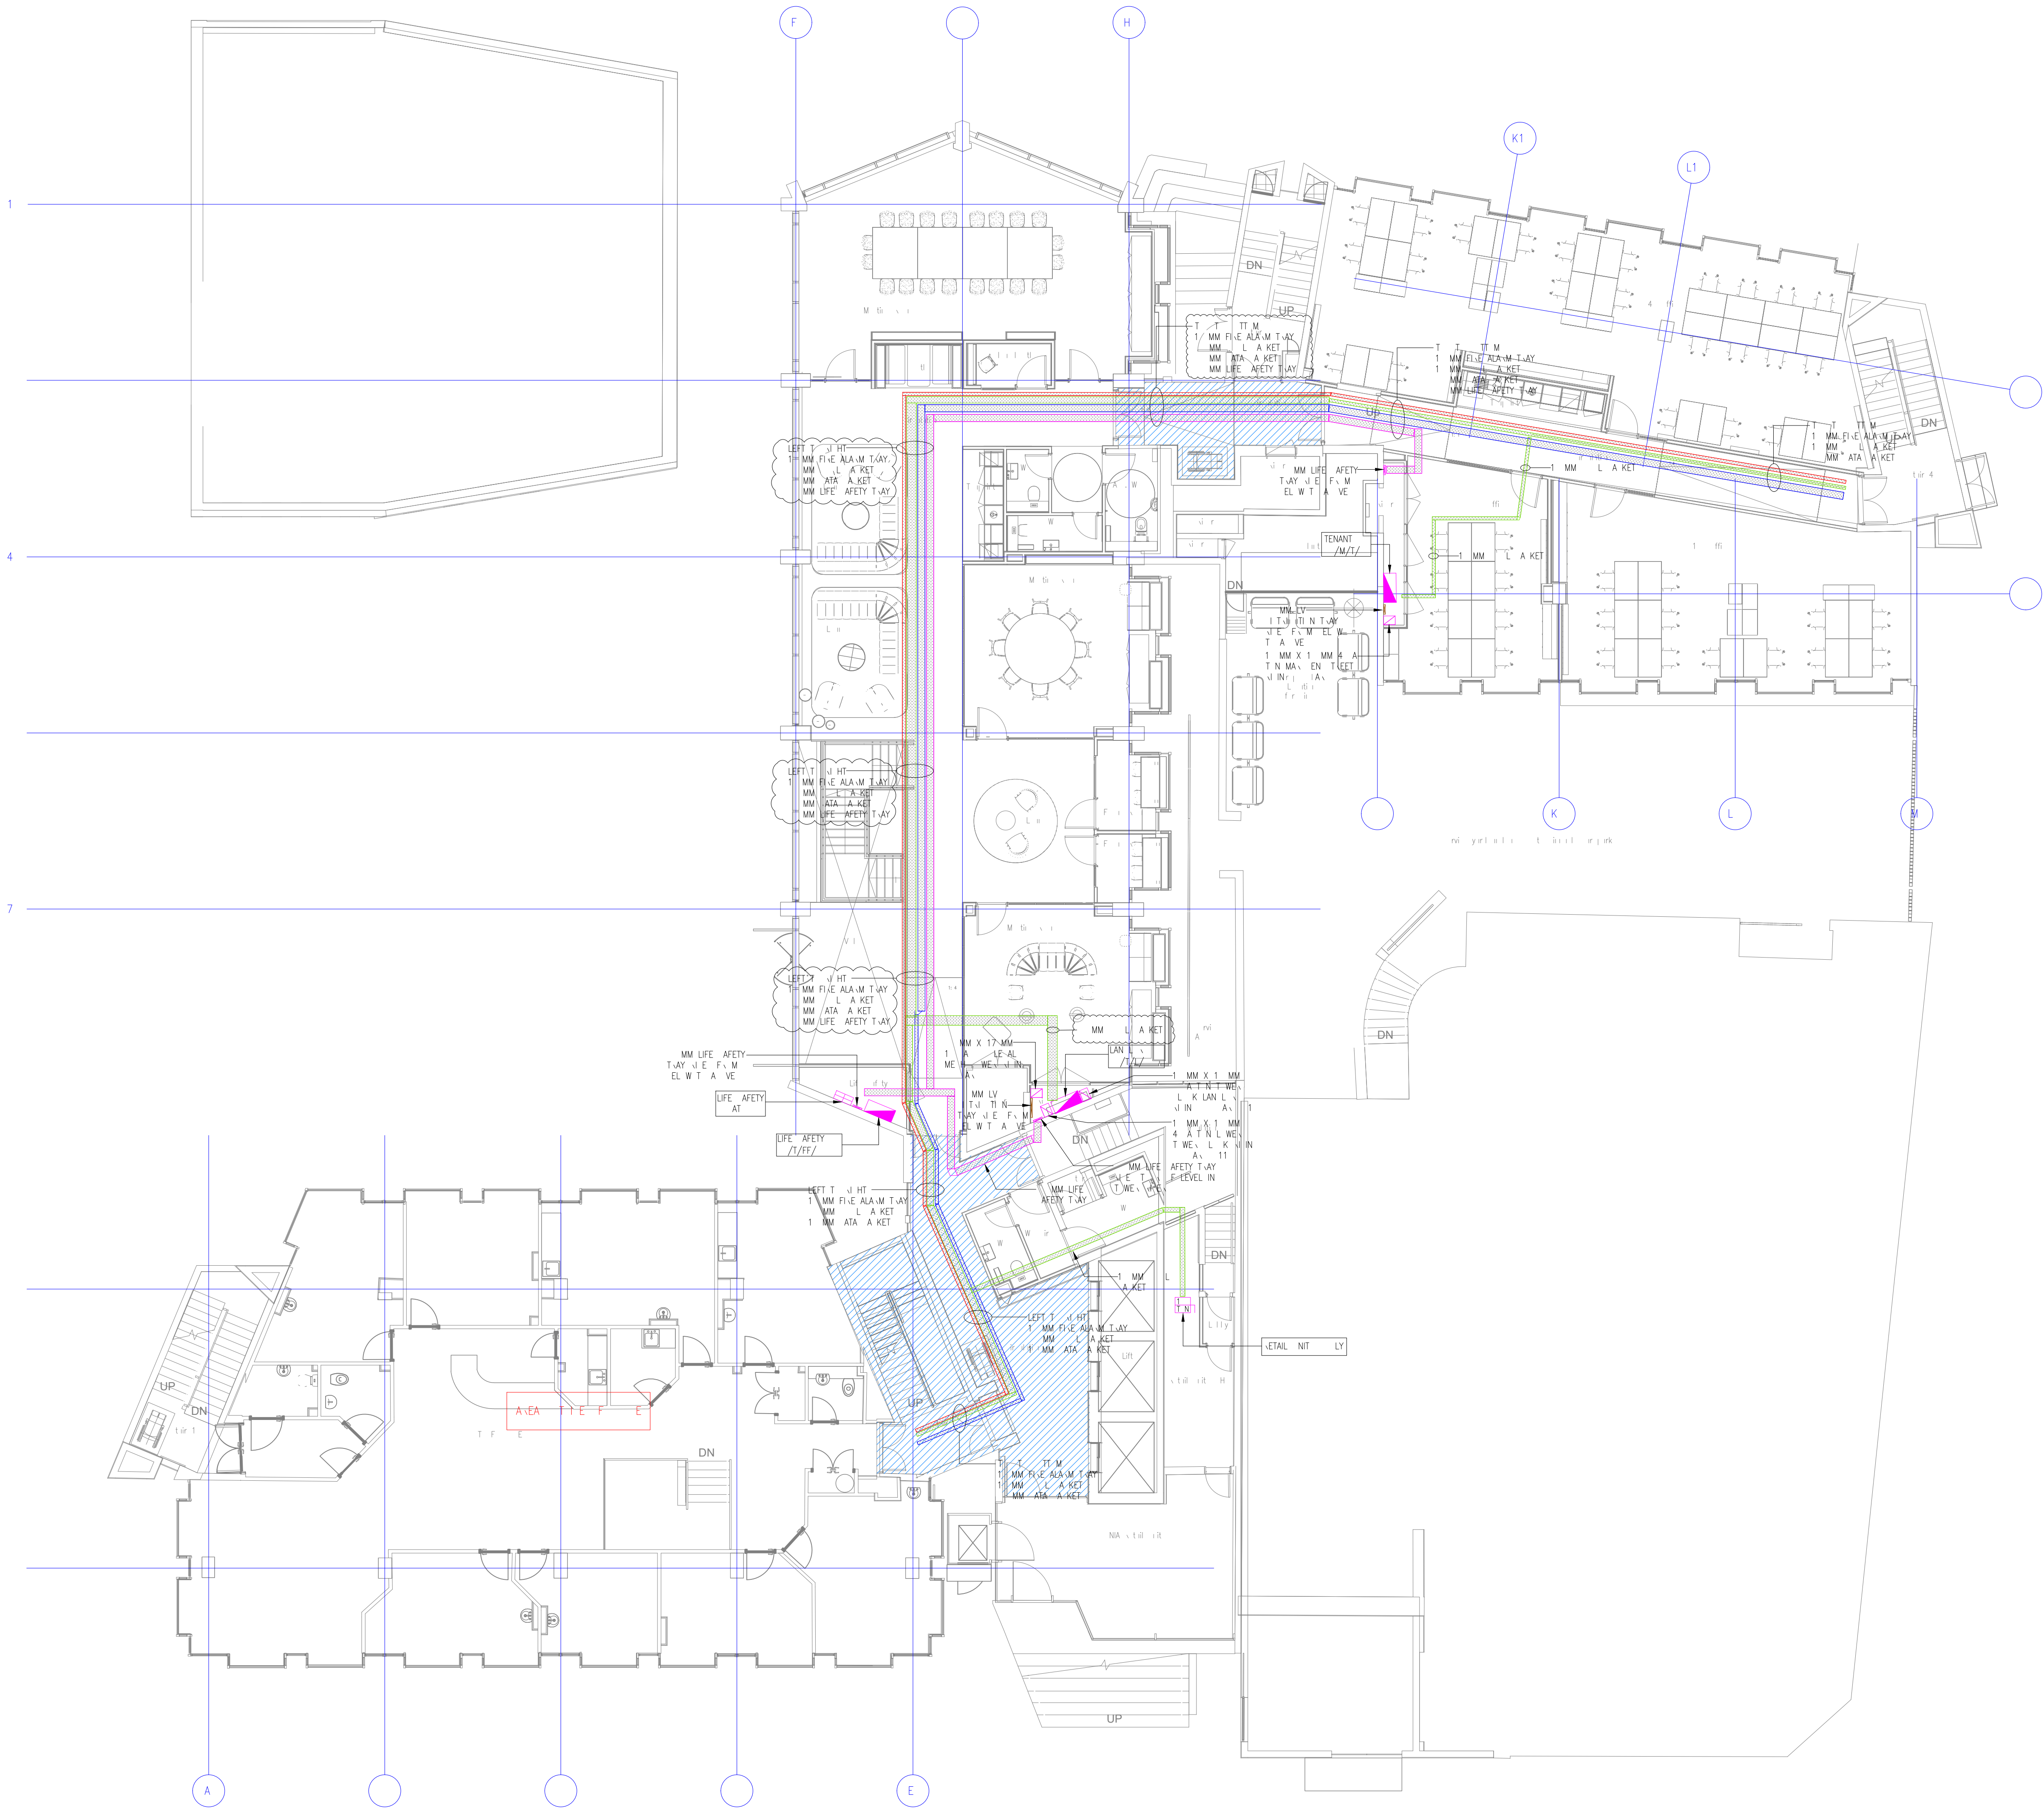

UHTN	WEATAKETAMEN	K	
AMENET	MAENIT	K	
UHTN	WEATAKETAMEN	K	

Drawing Status: PRELIMINARY

Unit 6, North Staffs Business Park,
Innovation Way, Staffs, ST44 9F
Email: info@carterelectrical.co.uk
Telephone: 01782 822250
www.carterelectrical.co.uk

Project:
**PALL MALL
MANCHESTER**

THE
GROUND FLOOR
HIGH LEVEL CONTAINMENT
LAYOUT

Architect: SHEPPARD ROBSON

Consultant: RAMBOLL

Designer: PG	Project: CB	Doc: PG	Checked: MD
Date: 02.12.2022	Project Number: CES561	Scale: 1:100	A0

Drawing No: 6911-CES-XX-00-DR-E-6602 Rev: 003

Copyright: Carter Electrical Services Ltd
Contractors are to check all dimensions on site and refer any discrepancies to Carter Electrical immediately

1. I want that this is a law.
 . No possibility of getting it
 in front of the law by the. All
 in front of the law by the. All
 in front of the law by the. All

1. I want that this is a law.
 . Necessarily and yet in error
 in front of law by the. All
 in front of all take for fear
 in front of all take it.

01/10/2012 Second Floor Speed Arrangement REF: CESS4 - FCB
 Drawing Status: **PRELIMINARY**

 Unit 4, North Staffs Business Park,
 Innovation Way, Staffs ST16 4RF
 Email: info@ceespeed.co.uk
 Telephone: 01782 822250
www.ceespeed.co.uk





 Project:
**PALL MALL
 MANCHESTER**
 The
 SECOND FLOOR
 HIGH LEVEL CONTAINMENT
 LAYOUT
 SHEPPARD ROBSON
 RABWALL

Designer: PC	Project: Reference: CB	AO	PD	Checked: MD
Date: 02.12.2012	Project Code: CESS561			Scale: 1:100

 Drawing No. 69111-CES-XX-02-DR-E-6604
 Copyright, Carter Electrical Services LTD
 Contractors are to check all dimensions on site and refer any
 discrepancies to Carter Electrical immediately


1. I want that this is a law.
 . Necessarily and yet in error
 in front of law by the. All
 in front of all take for fear
 in front of all take it.

NTAINMENT	
YM L	E ÷ l T I N
	L A KET
	V I E ATA A KET
	F I E A L A M T A Y
	H A E I T I T I N A
	I N I A T E A N NTAINMENT ÷ N N I N T H I H D I E ÷ T E T E L Y A S A T E E N A E I N T M F I E T I N



	LI HTIN WE\ A KET IZE AMEN E	K			1
	AMEN E T MMMENT	K			1
1	FL T T E				
1					

Drawing Status: PRELIMINARY

Unit 6, North Staffs Business Park,
Innovation Way, Staffs ST64BF.
Email : info@carterelectrical.co.uk
Telephone: 01782 822250
www.carterelectrical.co.uk

Project.
PALL MALL
MANCHESTER

Architect	SHEPPARD ROBSON
Consultant	RAMBOLL

Drawing No. 6911-CES-XX-03-DR-E-6605 Rev. 

Contractors are to check all dimensions on site and refer any discrepancies to Carter Electrical immediately

[illegible]

LI HTIN	WE\ A KET IZE AMEN E	K			1	4
AMEN E T	NMENT	K				
1	FL\ T I E					
u						

Drawing Title: 2014 Fourth Floor General Arrangement XREF CLEANED - P19					
<div style="text-align: center;"> <h1>PRELIMINARY</h1>  <p>Unit 4, North Staffs Business Park, Innovation Way, Staffs ST16 6HF Email : info@carter-electrical.co.uk Telephone: 01827 822250 www.carterelectrical.co.uk</p> </div>					
					
Project					
<h2>PALL MALL MANCHESTER</h2>					
The <h3>FOURTH FLOOR</h3> HIGH LEVEL CONTAINMENT LAYOUT					
SHEPPARD ROBSON					
RAMBOLL					
Designer: PCP	Project Manager: CB	Unit: PG	Checked: MD		
Date: 06.01.2013	Project: CCS561	Scale: 1:100	As		
Drawing No: 6911-CC-XS-04-DR-E-6608			Rev:		
Copyright: Carter Electrical Services Ltd Customers are to check all dimensions on site and refer any discrepancies to Carter Electrical immediately					

[illegible]

[illegible]

	5 F A E A A L E T W A E	K			
	A M E T M M E N T	K			
1	F L T I E				
18	651				

BASED ON: 20106 Sixth Floor General Arrangement XREF CLEANED - P19

PRELIMINARY



Unit 6, North Staffs Business Park,
Innovation Way, Staffs ST64BF.
Email : info@carterelectrical.co.uk
Telephone: 01782 822250



Project:
PALL MALL
MANCHESTER

SIXTH FLOOR
HIGH LEVEL CONTAINMENT
LAYOUT

Architect: SHEPPARD ROBSON

Consultant:	RAMBOLL
-------------	---------

Designer: PG	Project Manager: CB	CAD: PG	Checked: MD
--------------	---------------------	---------	-------------

Date: 02.12.2022	Project Number: CES561	Scale: 1:100	A0
		^	


Drawing No. 6911-CES-XX-06-DR-E-6608 Rev.

Copyright, Carter Electrical Services LTD
Contractors are to check all dimensions on site and refer any
discrepancies to the Client immediately

discrepancies to Carter Electrical immediately

1. This drawing is a preliminary drawing and is not to be used for construction purposes. All dimensions are approximate and subject to change without notice.

CONTAINMENT	
SYM. L.	DESCRIPTION
	LV. ITD. TINT. AY
	L. A. KET
	V. I. E. A. A. KET
	F. I. E. A. A. M. T. AY
	L. I. F. E. A. P. E. T. AY
	LV. I. N. A.
	H. A. E. I. T. D. T. N. A.
	V. I. N. A.
	A. T. H. A. N. E. V. E. N. T.
	I. L. A. T. A. N. T. - U. E. A. N. - N. F. I. E.
	I. N. I. T. A. T. I. O. N. A. R. E. A. M. E. N. T. H. E. I. T. E. L. Y. A. G. A. I. E. N. A. E. N. T. M. O. D. E. L. I. N. G.

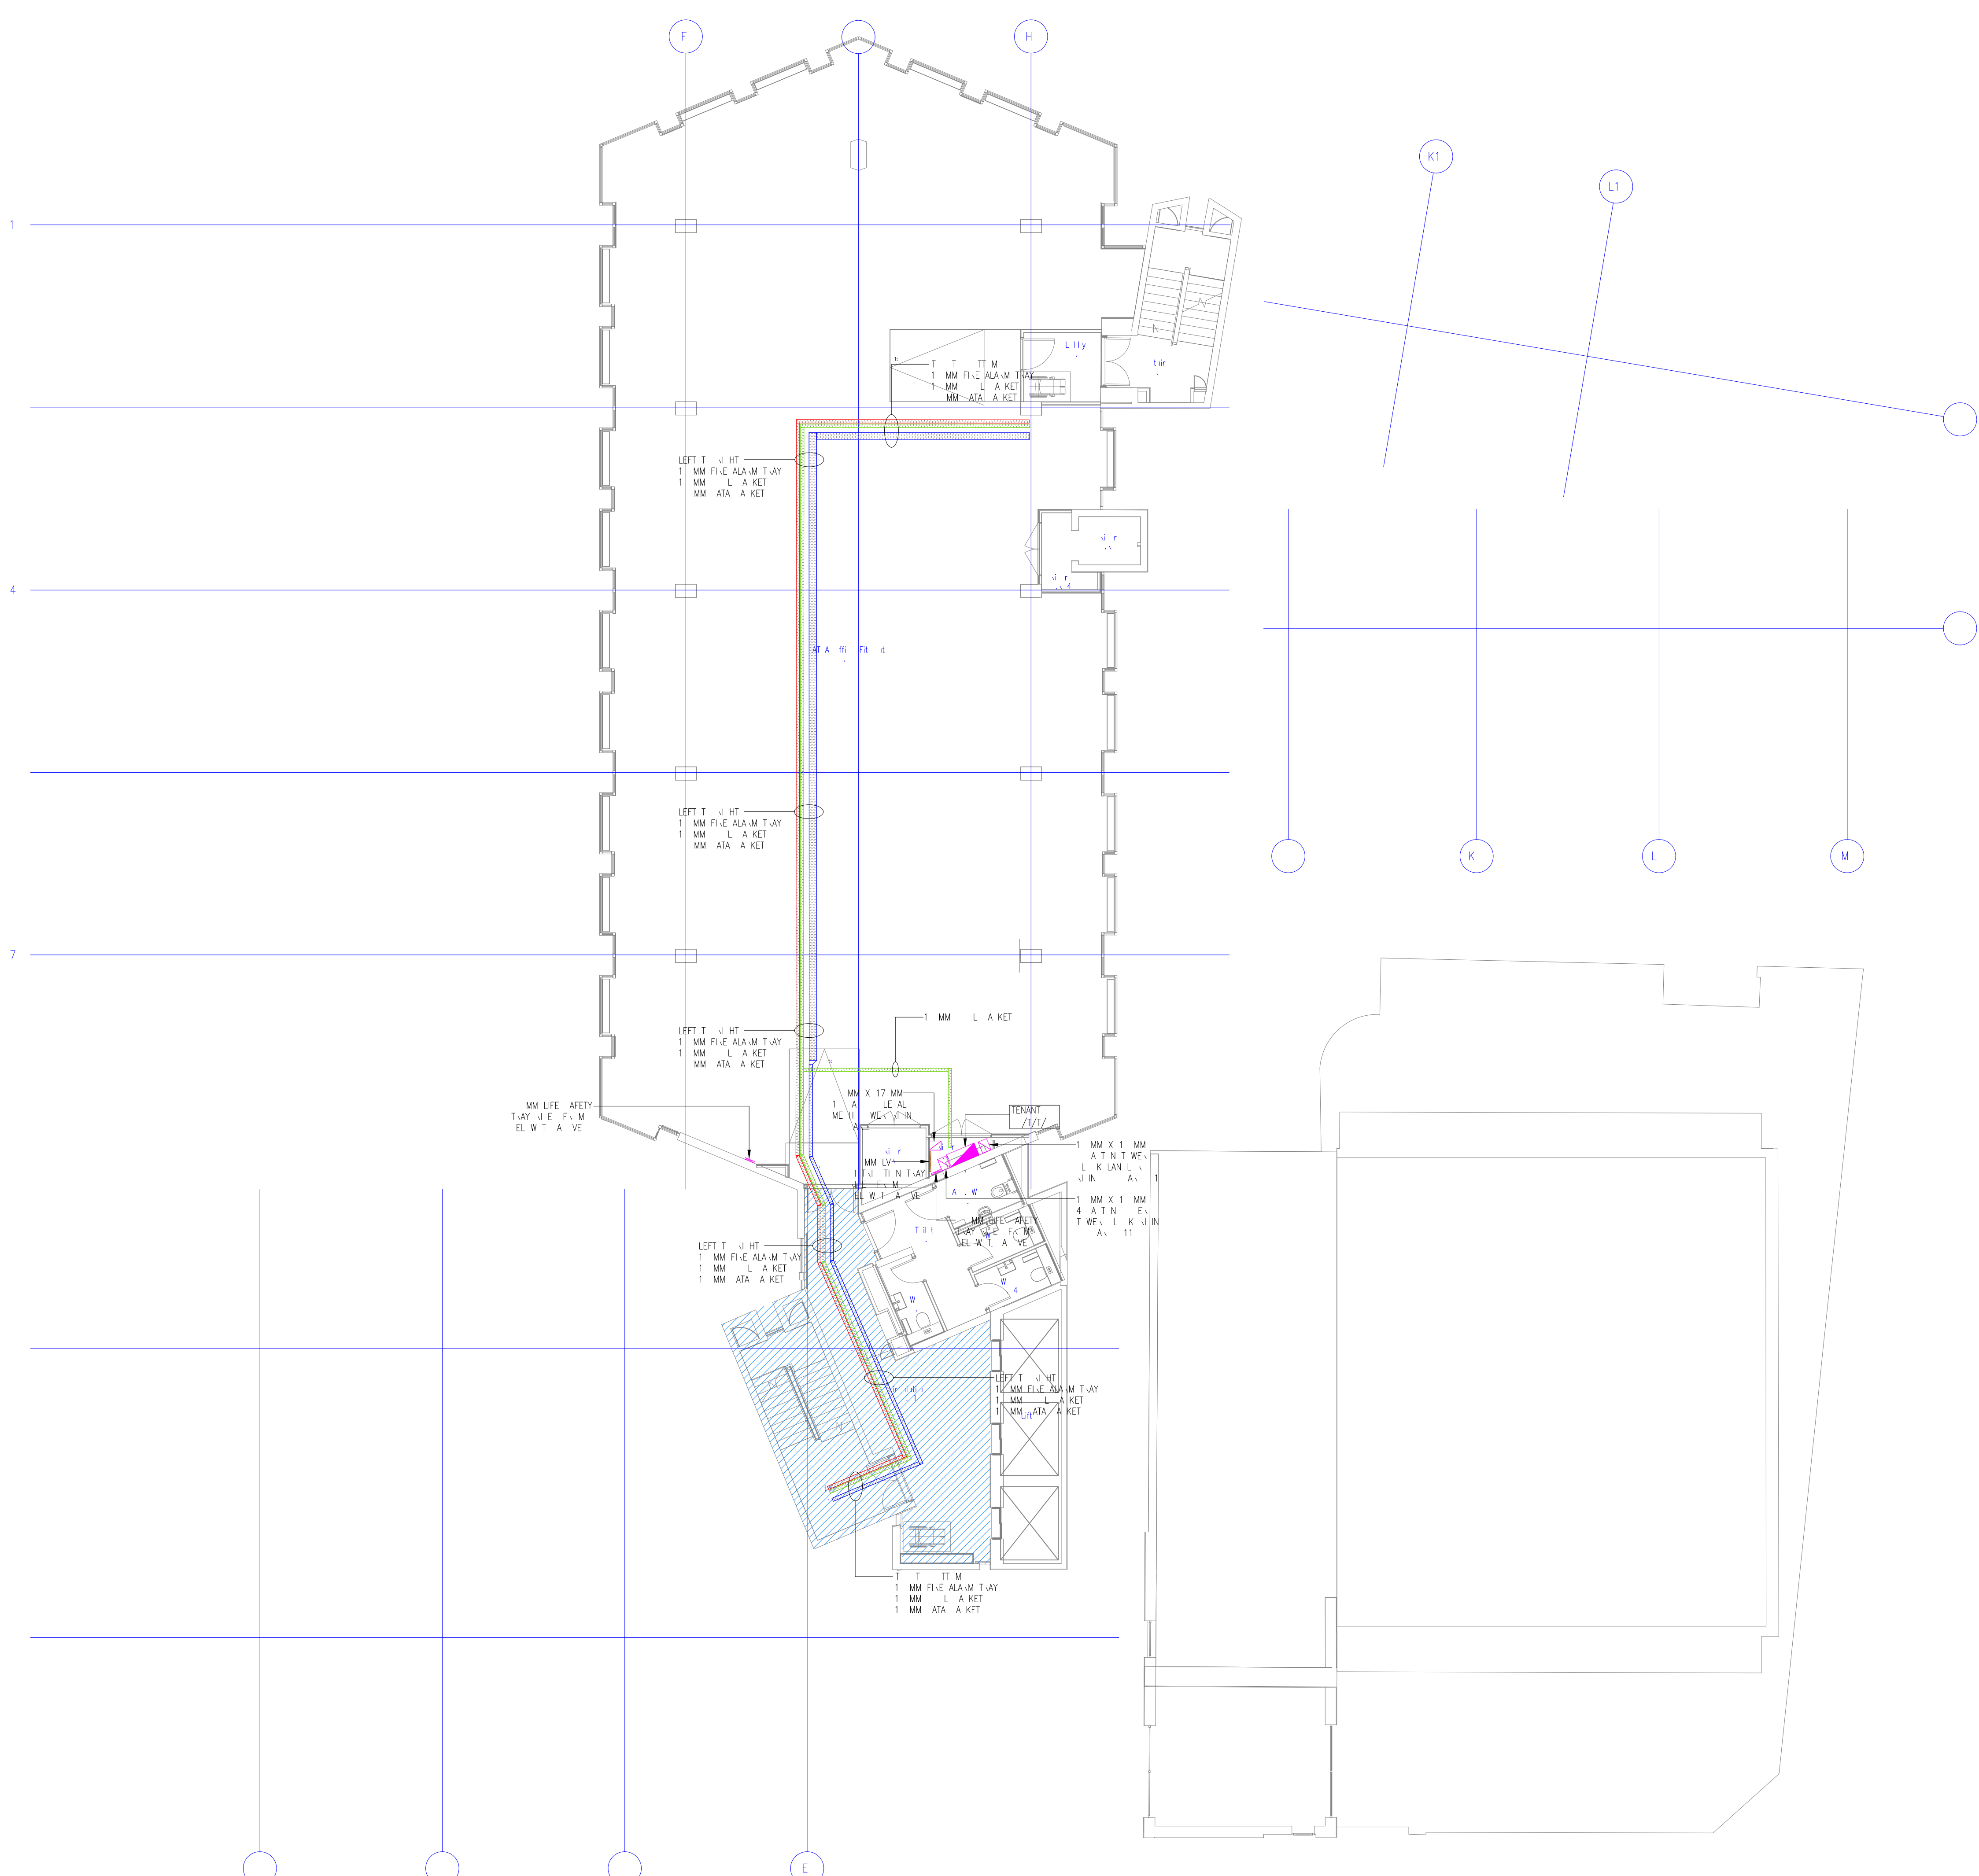

AMEN. T. MENT		K	
I. T. I. E			
Drawing Status:		PRELIMINARY	
Unit 6, North Staffs. Business Park, Innovation Way, Staffs. ST449F. Email: info@carterelectrical.co.uk Telephone: 01782 822250 www.carterelectrical.co.uk			
Project: PALL MALL MANCHESTER			
The EIGHTH FLOOR HIGH LEVEL CONTAINMENT LAYOUT			
Architect: SHEPPARD ROBSON			
Consultant: RAMBOLL			
Designer: PG	Project: CB	Rev: PG	Checked: MD
Date: 02.12.2022	Project Number: CES561	Scale: 1:100	A0
Drawing No: 6911-CES-XX-08-DR-E-6610			Rev: 001
Copyright: Carter Electrical Services Ltd. Contractors are to check all dimensions on site and refer any discrepancies to Carter Electrical immediately.			


1. I want to tell you a story.
 . Responsibility is a job for
 all of us. It is a job for all of us.
 It is a job for all of us. It is a job
 for all of us. It is a job for all of us.

4	U HTIN WE\ A KET IZE AMEN E	K		1
	TAY\ T U HTIN A\ A E	K		4
	AMEN E T MMENT	K		1
1	FL\ T I E			
1				

CONTAINMENT

1. This drawing is a preliminary drawing and is not for construction. It is for information only and is not to be used for any other purpose. It is not to be used for any other purpose.

SYM	DESCRIPTION
1	LV ITD TINTAY
2	LV ITD TINTAY
3	VIE ATA A KET
4	FILE ALAM TAY
5	LIFE AFETY TAY
6	LV JIN A
7	HA E ITD TINTAY
8	VIN A
9	AT HAN EVEL NT
10	I LAT NT = IZE AN = N F LE
11	IN IATE ANY NTAMENT < MIN TH > H THE < T E T E L Y A E T E E N A E I N T M F I E T I N

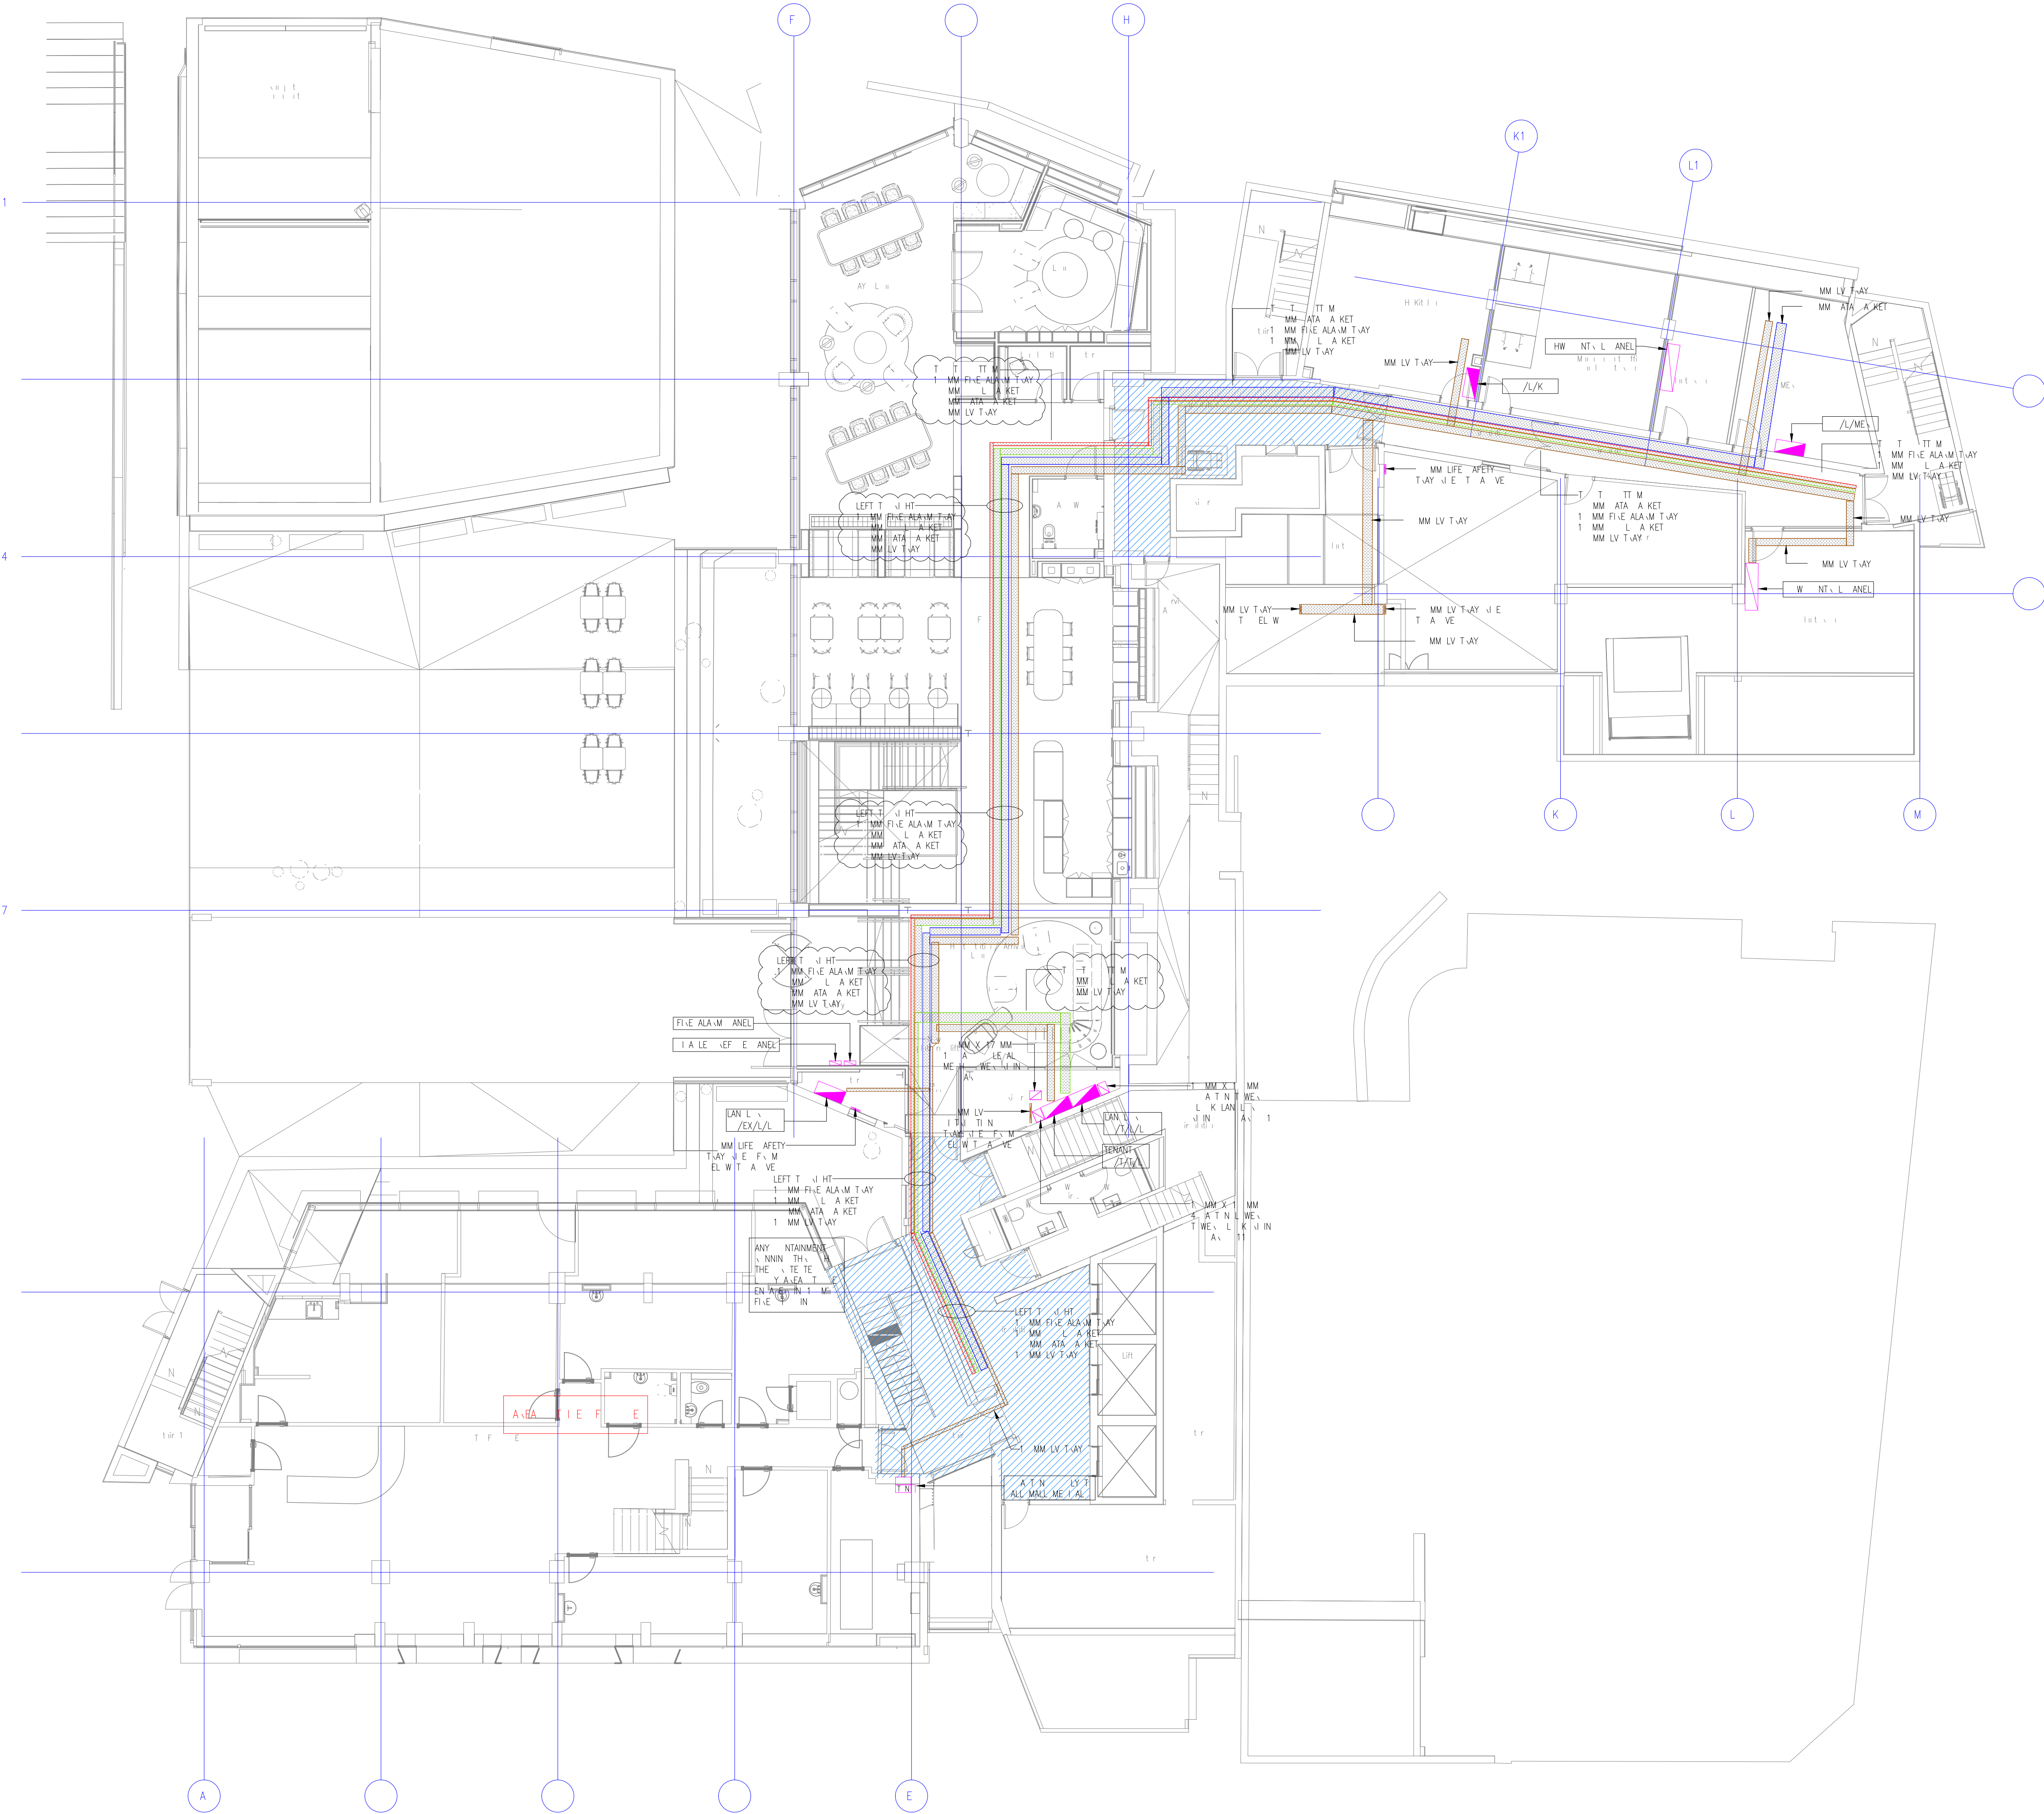

4	LV ITD TINTAY	WE, A KET IZE AMEN E	K	1
5	EXT. MAL LI HTN	As A E	K	1
6	AMEN E T MENT		K	1
7	FL T T E		K	1

BASED ON: 2019 Lower Ground Floor General Arrangement SHEP CLEANED - P03

Drawing Status: PRELIMINARY

Unit 6, North Staffs Business Park, Innovation Way, Staffs, ST44 8P, Email: info@carterelectrical.co.uk, Telephone: 01782 822250, www.carterelectrical.co.uk

Project: PALL MALL MANCHESTER

THE LOWER GROUND FLOOR HIGH LEVEL CONTAINMENT LAYOUT

Architect: SHEPPARD ROBSON

Consultant: RAMBOLL

Designer: PG, Project: CB, Date: 02.12.2022, Project Number: CES561, Scale: 1:100, A0

Drawing No: 6911-CES-XX-LG-DR-E-6601, Rev: 004


Copyright: Carter Electrical Services LTD. Contractors are to check all dimensions on site and refer any discrepancies to Carter Electrical immediately.

1. I want that this is a drawing.
 . Necessarily, it is a picture of
 the first drawing by the artist. All
 the more I will take for granted
 the more I will like it.

[illegible]

Drawing: Shading	<h1 style="text-align: center;">PRELIMINARY</h1>			
    	 <p>Unit 6, North Star Business Park, Innovation Way, Slough SL1 0AF info@electrical.co.uk Telephone: 01753 822250 www.electrical.co.uk</p>			
	<p>Project</p> <h2 style="text-align: center;">PALL MALL COURT</h2>			
	<p>GROUND FLOOR LIGHTING AND EXTERIOR LIGHTING LAYOUT</p>			
<h3 style="text-align: center;">SHEPPARD ROBSON</h3>				
Author:	RAMBOLL			
Consult:				
Designer: PG	Project: CB	Job: PG		Checked: MD
Date: 02.12.2022	Project Number: CF5561			Scale: 1:100
Drawing No: 6311-CB-XX-00-DR-C-6302	Rev.	<div style="border: 1px solid black; padding: 5px; display: inline-block;"> 603 </div>		
<p>Copyright, Crown Electrical Services LTD Contractors use to check all alterations on site and refer only to discrepancies to Crown Electrical immediately</p>				

1. I want that this is a law.
 . Necessarily and yet in error
 in front of law by the. All
 in front of all take for fear
 in front of all take it.

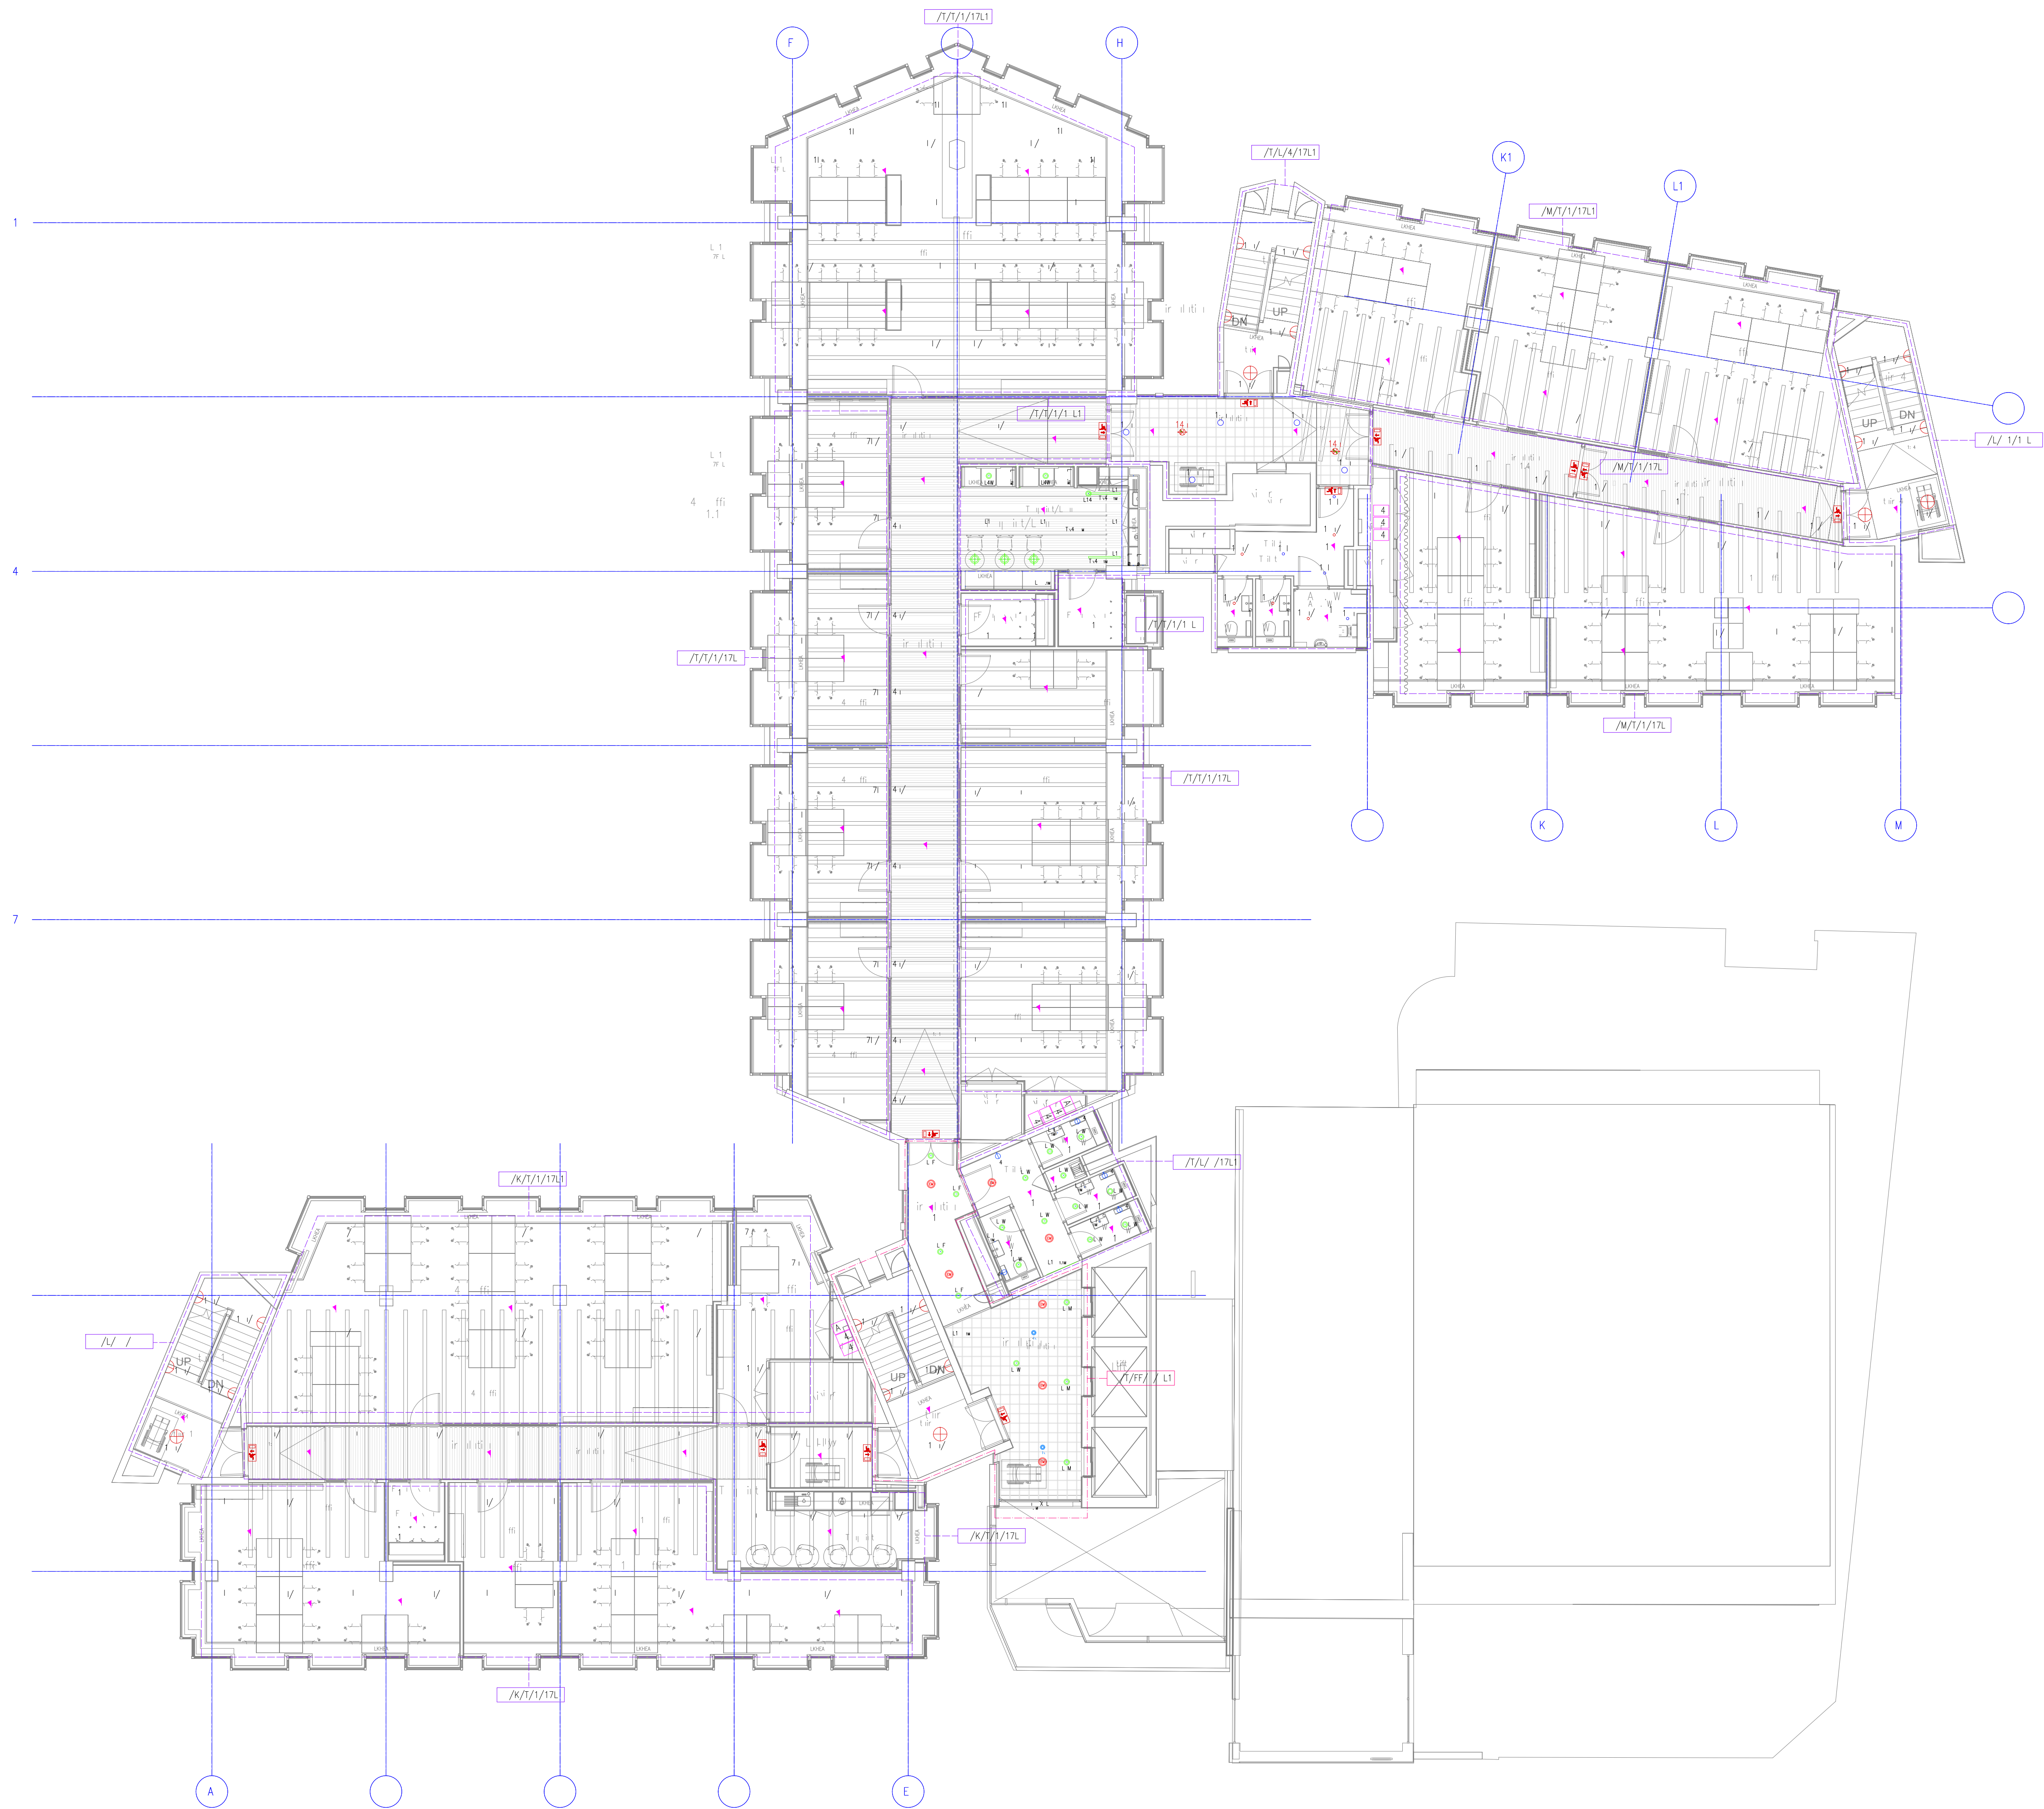[illegible]

1. I want that this is a law.
 . Necessarily and yet in error
 in front of law by the. All
 in front of all take for fear
 in front of all take it.

BASED ON: 35202 Level 02 Ceiling Plan XREF CLEANED - P10

□ □ □ □ □


Unit 6, North Staffs Business Park,
Innovation Way, Staffs ST64BF.
Email : info@carterelectrical.co.uk
Telephone: 01782 822250
www.carterelectrical.co.uk

PALL MALL
MANCHESTER


	LAYOUT
Architect,	SHEPPARD ROBSON

Drawing No. 6911-CES-XX-02-DR-E-6304		Rev.
--------------------------------------	--	------

1. I n o t t h a t i n A l w i n .
N e r i l l i t y u l i t l i n e r r f
a n f r e l i w i n l y t h e . A l l
i n i r i t l l l t k i f r e f i n l
l i n i n l k l i t .

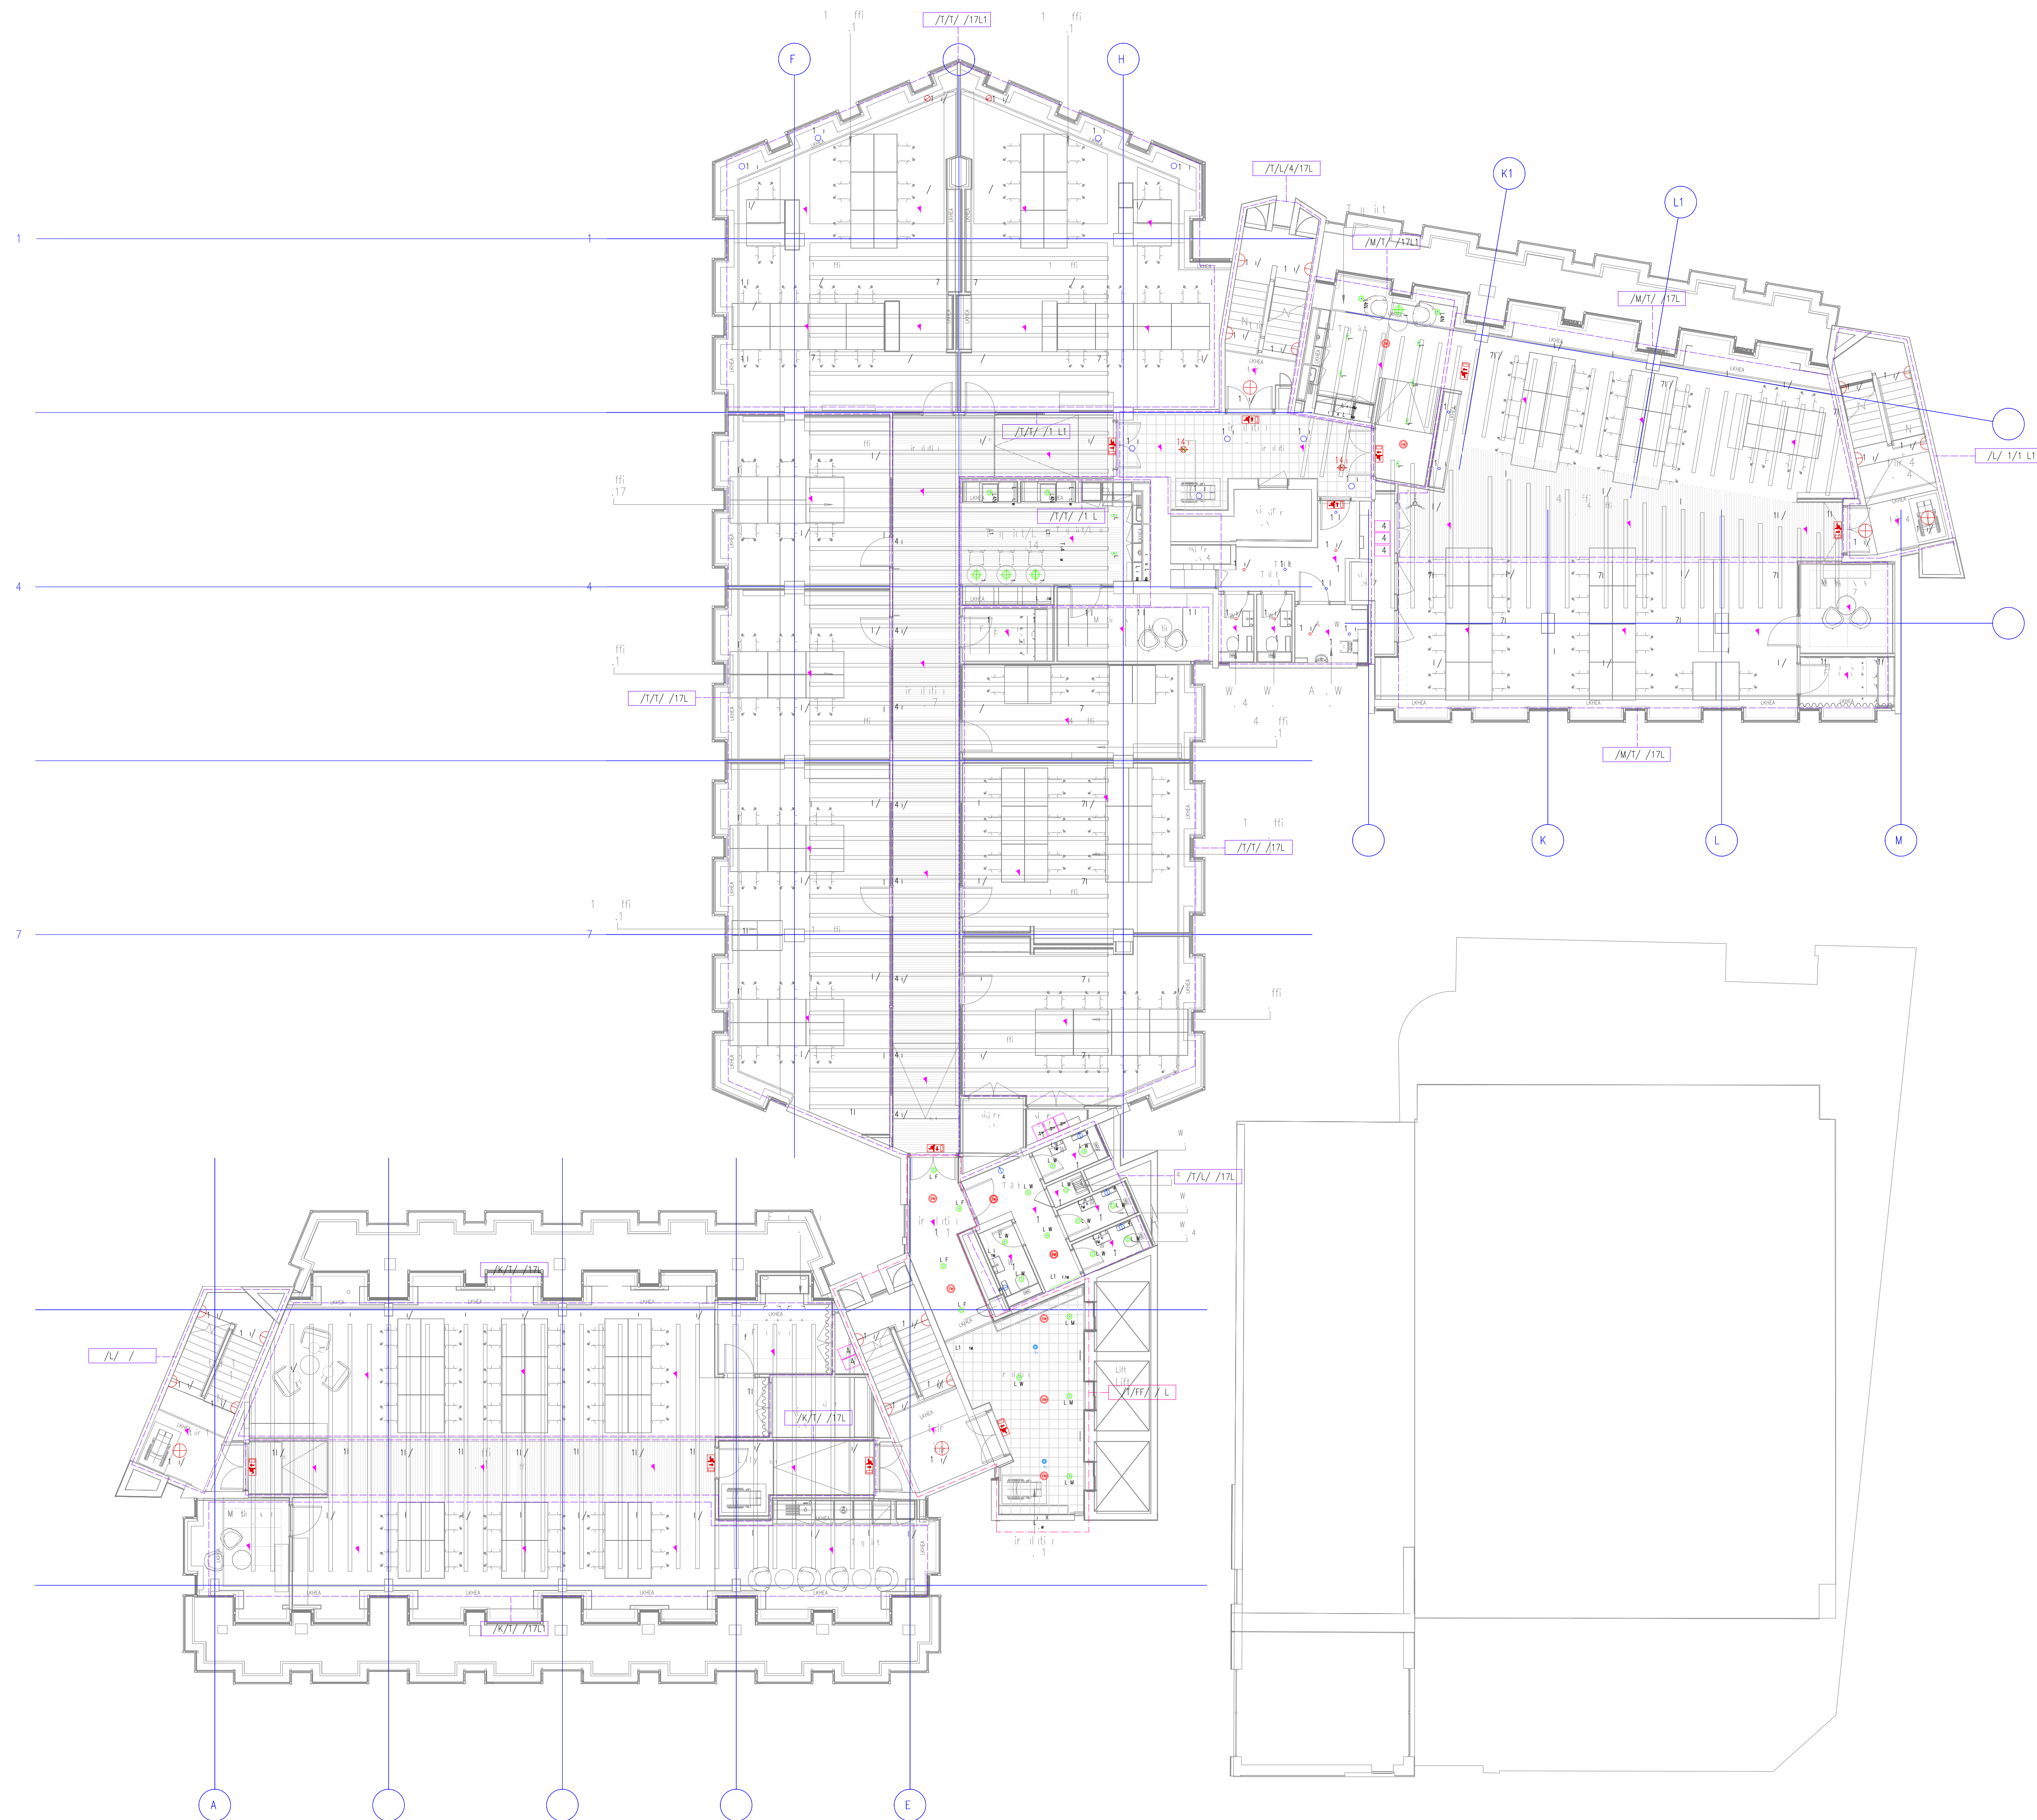
[illegible]

1. I want that this is a law.
 . Necessarily and yet in error
 in front of law by the. All
 in front of all take for fear
 in front of all take it.

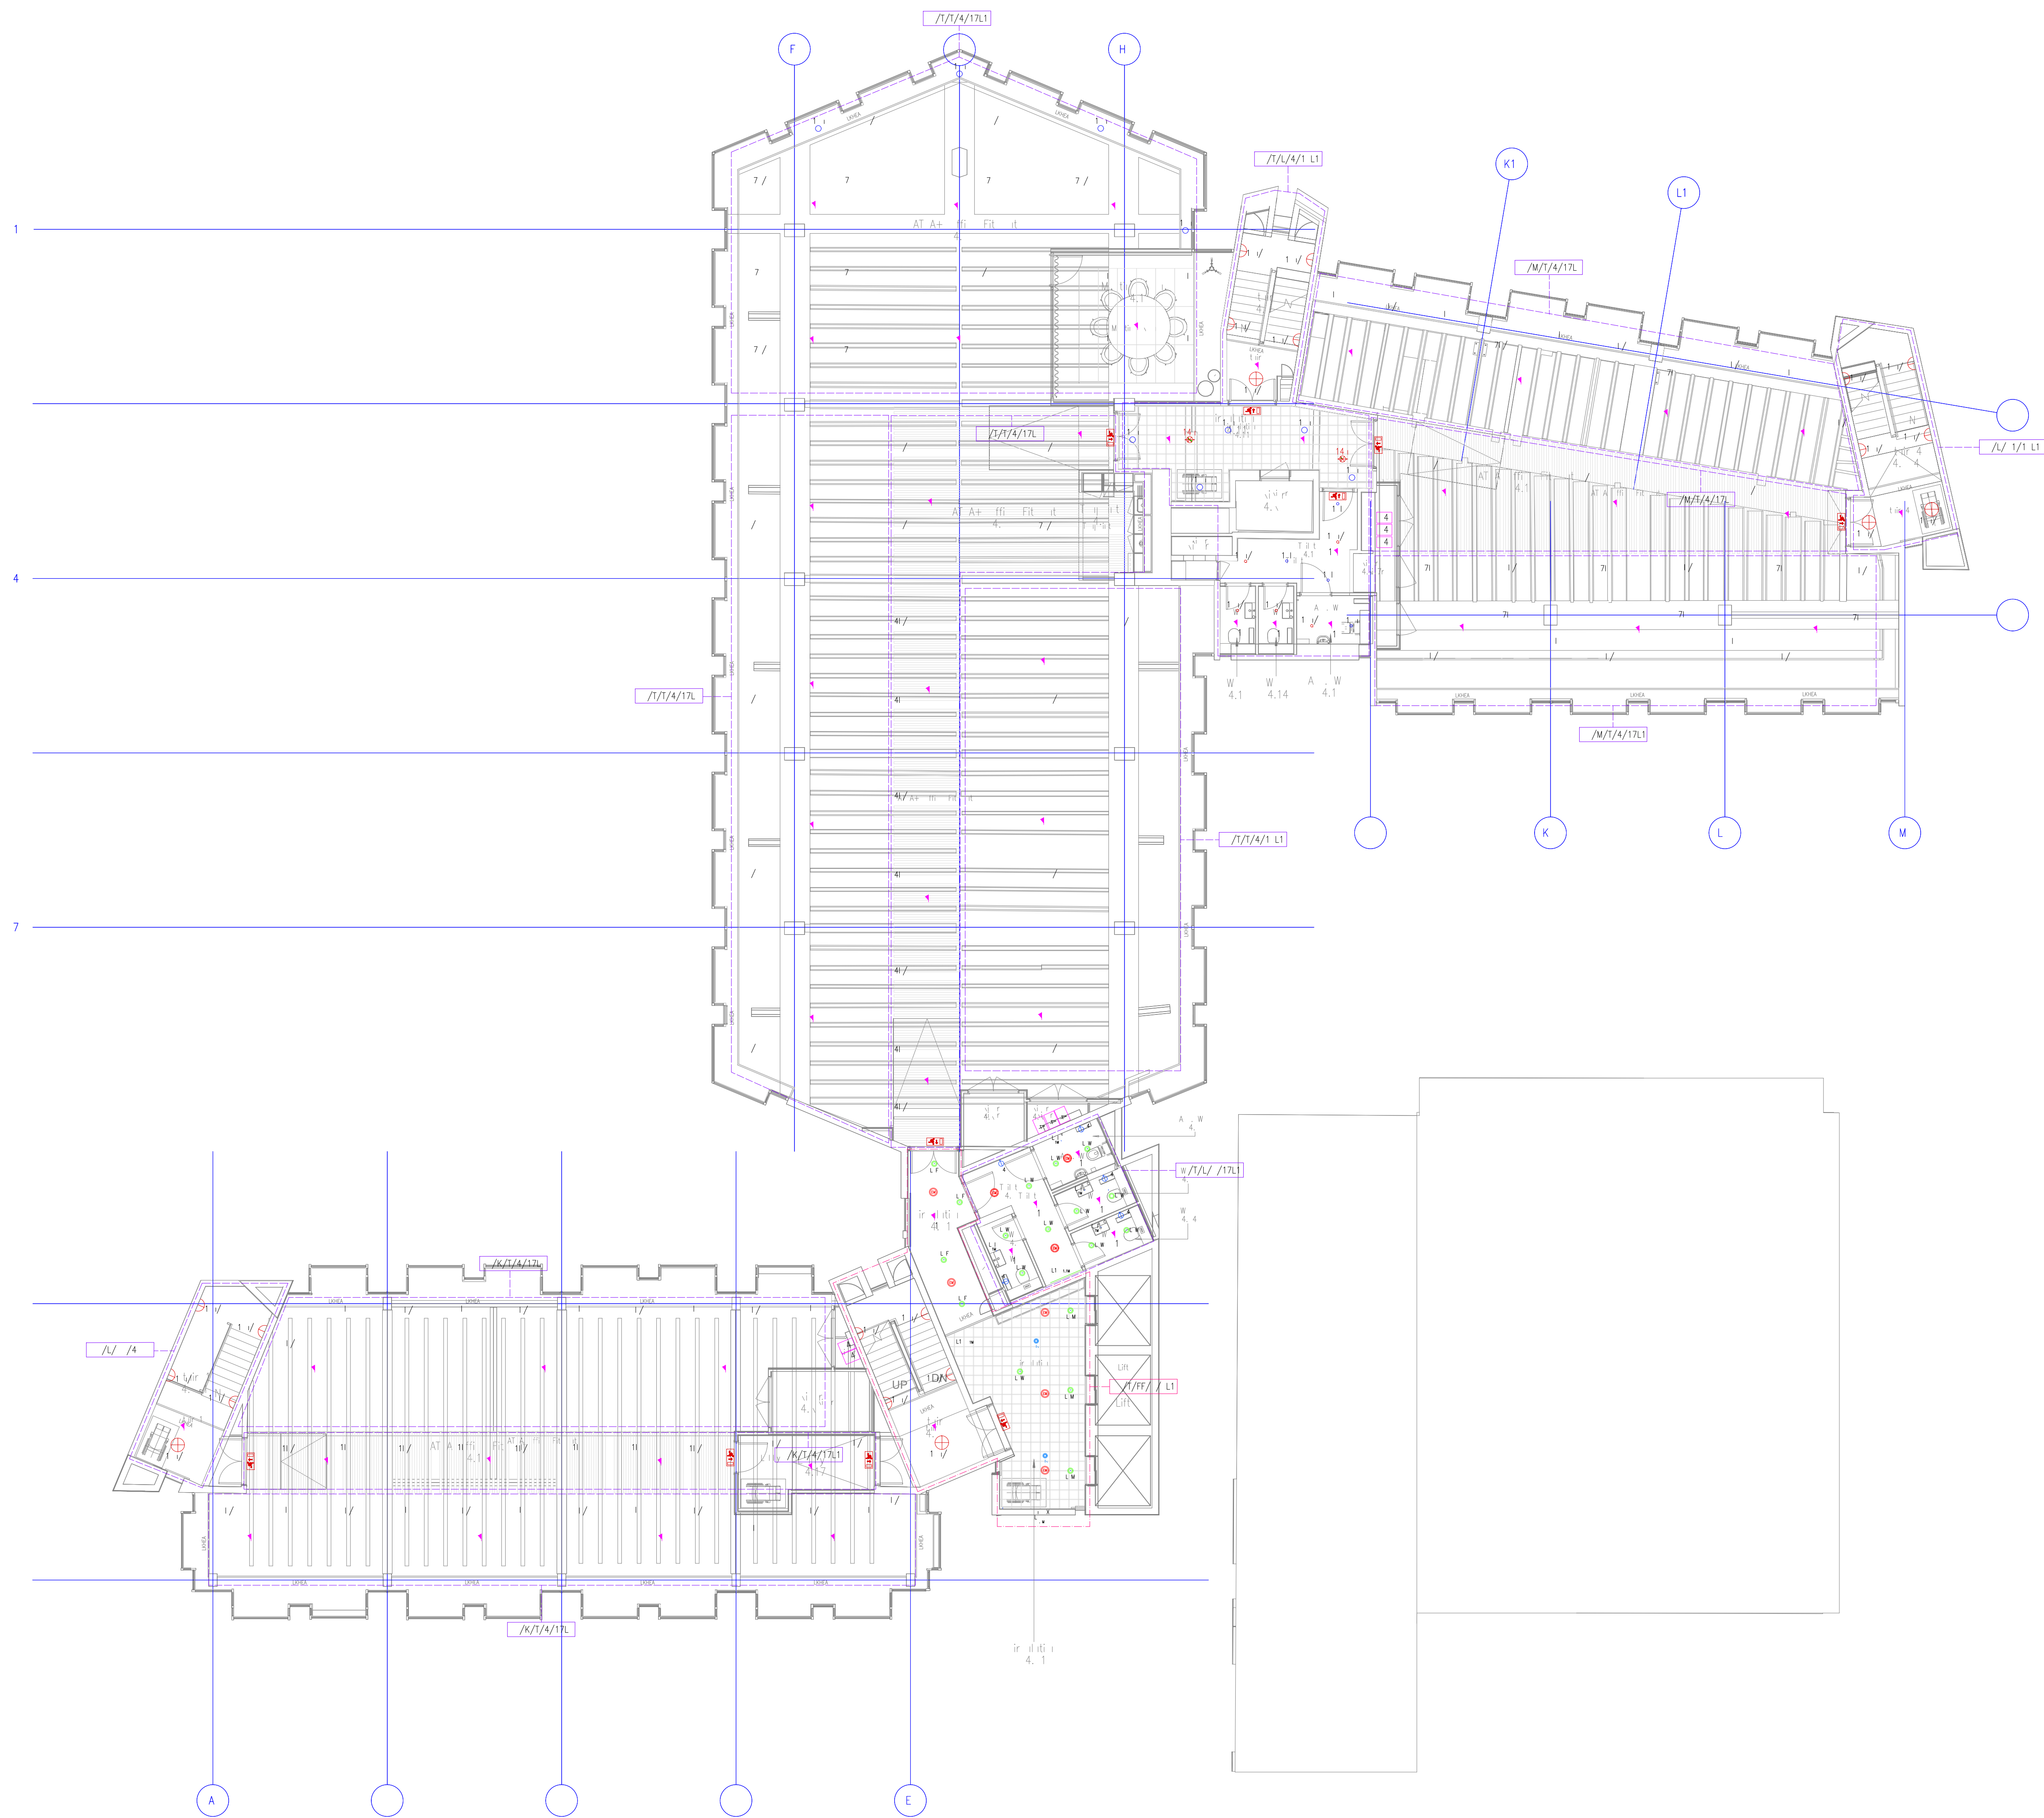[illegible]

ENE VAL N TE

1. L I T T E R A T U R E
2. N E T W O R K I N G
3. F I R E F I G H T I N G
4. P R O T E C T I O N
5. S E C U R I T Y
6. I N F O R M A T I O N
7. E N V I R O N M E N T
8. H E A L T H
9. W E L F A R E
10. S O C I A L
11. C U L T U R E
12. S P O R T
13. A R T
14. S C I E N C E
15. T E C H N O L O G Y
16. B U S I N E S S
17. L E I S U R E
18. P E A C E
19. J U S T I C E
20. F A I T H
21. H O P E
22. C A R I T Y
23. G O D
24. S P I R I T
25. L O V E

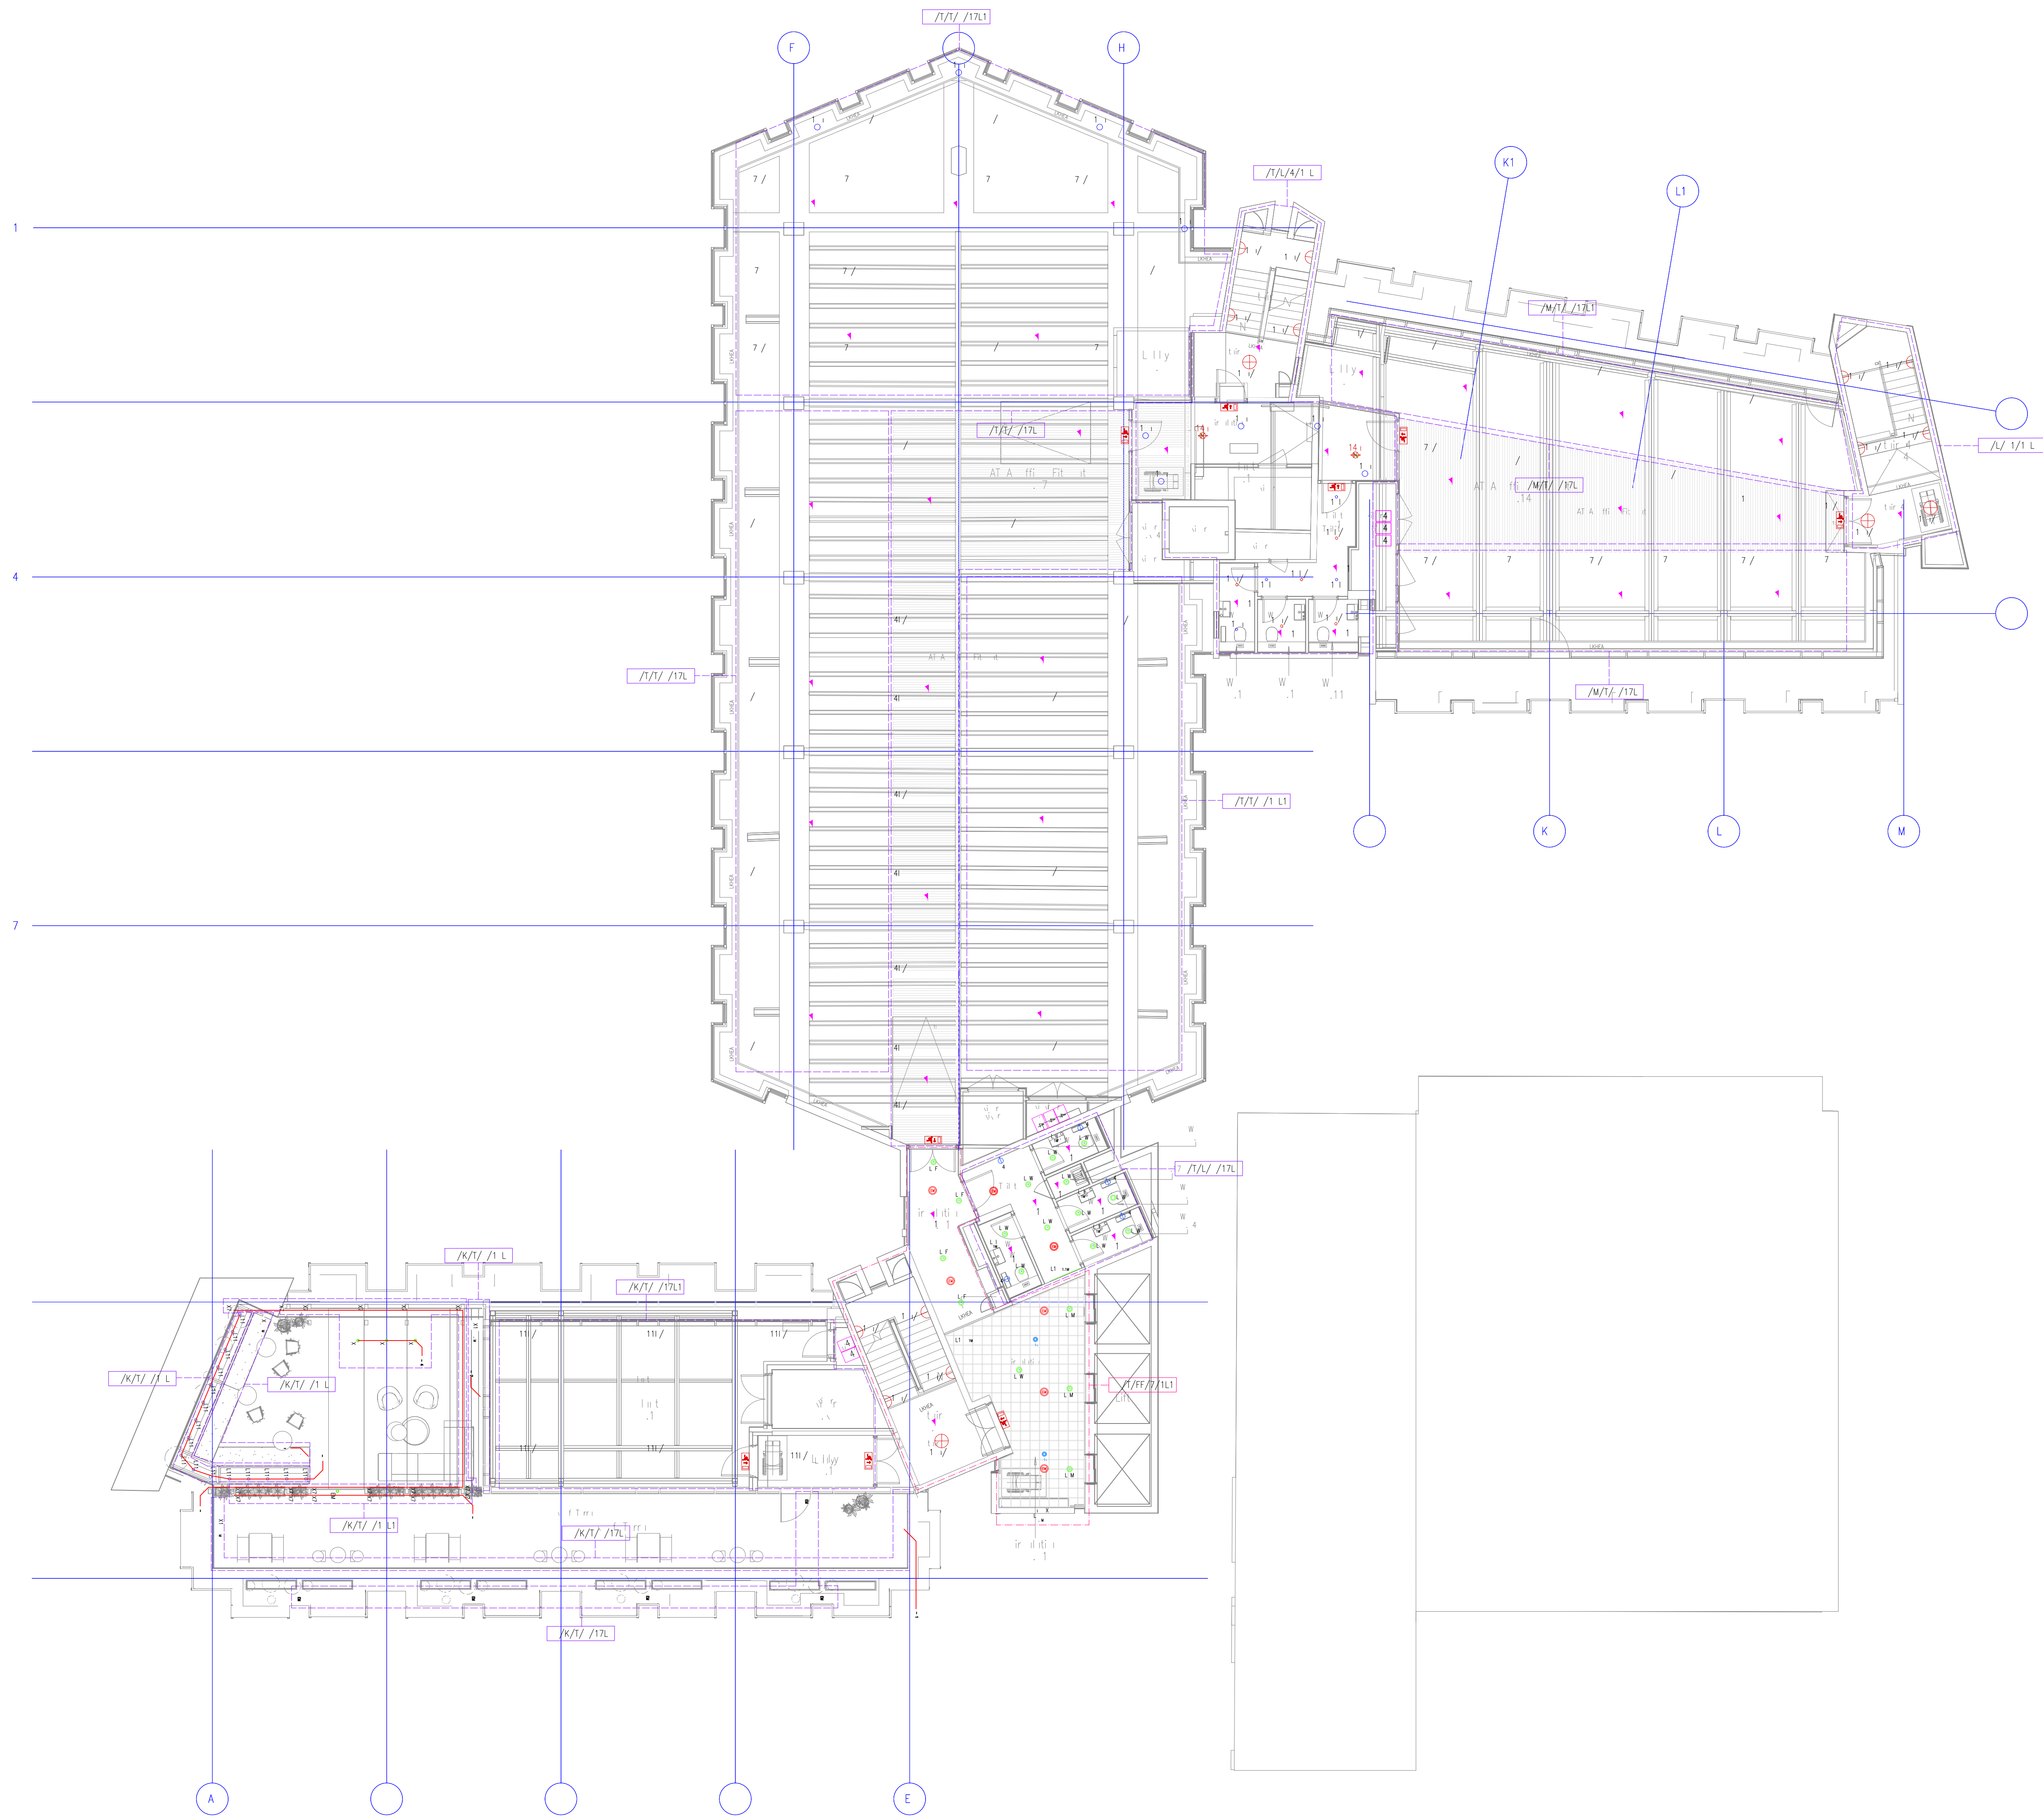

[illegible]

	L M N A J E	K							
	E F E S E N E A M E N E								
	E L I M N A Y I V I T E T A L A E	K							
1	F I L T I E								
1									

BASED ON: 30.00E Load On Ceiling Panel: SHEET CLEARED - P10 Drawing Status: PRELIMINARY <div style="text-align: center;">  </div>				
IRIH & North Staffs Business Park, Invercukry Way, Staffs ST16 5TAF Email: info@irih-electric.co.uk Telephone: 01782 822250 www.irih-electric.co.uk				
<div style="display: flex; justify-content: space-around; align-items: center;">    </div>				
Project: PALL MALL MANCHESTER Title: SIXTH FLOOR LIGHTING & EMERGENCY LIGHTING LAYOUT				
SHEPPARD ROBSON				
Worksheet: _____ Consultant: RAMBOLL				
Designer: PC	Project Manager: CB	Lead: PC	Checked: MD	
Date: 02.12.2022	Project Number: CES561	Scale: 1:100	A5	
Drawing No: 6911-CES-XX-06-DR-E-6308			Rev:	
Copyright: Carter Electrical Services Ltd Contractors are to check all dimensions on site and refer any discrepancies to Carter Electrical Services Ltd				

1. I want that this is a law.
 . Necessarily and yet in error
 in front of law by the. All
 in front of all take for fear
 in front of all take it.

BASED ON: 35207 Level 07 to 10 Ceiling Plan XREF CLEANED - P10


ENE VAL N TE

1. L I T T E R A T U R E
2. N E T W O R K I N G
3. F R I E N D L Y
4. P R O F E S S I O N A L
5. B R I T I S H
6. R E S E A R C H
7. I N F O R M A T I O N
8. C O M M U N I C A T I O N
9. E N V I R O N M E N T
10. S O C I E T Y
11. C U L T U R E
12. A R T
13. S C I E N C E
14. T E C H N O L O G Y
15. B U S I N E S S
16. L E A R N I N G
17. H E A L T H
18. S P O R T S
19. P L A Y
20. F I T N E S S
21. F O O D
22. D R I N K S
23. S H O P P I N G
24. T R A V E L
25. H O M E
26. W O R K
27. S C H O O L
28. U N I V E R S I T Y
29. H O S P I T A L
30. G O V E R N M E N T
31. M I L I T A R Y
32. R E L I G I O N
33. A R M Y
34. N A V Y
35. A I R F O R C E
36. S P A C E F O R C E
37. P O L I C E
38. F I R E D E P A R T M E N T
39. P R I M E R I A
40. S E C U R I T Y
41. I N T E L L I G E N C E
42. D I F F E R E N C E
43. A B I L I T Y
44. S K I L L S
45. T A L E N T
46. P A S S I O N
47. I N T E R E S T
48. H O B B Y
49. S P O R T
50. A R T
51. M U S I C
52. D A N C E
53. G A M I N G
54. C O L L E C T I N G
55. R E A D I N G
56. W R I T I N G
57. S P E E K I N G
58. L I S T E N I N G
59. T H I N K I N G
60. P R O B L E M S O L V I N G
61. D E C I S I O N M A K I N G
62. C R E A T I V I T Y
63. I M A G I N A T I O N
64. I N N O V A T I O N
65. E N T E R P R E N E U R S H I P
66. L E A D E R S H I P
67. T E A M W O R K
68. C O M M U N I C A T I O N
69. C O L L A B O R A T I O N
70. N E T W O R K I N G
71. P A R T N E R S H I P
72. C O M M U N I T Y
73. S O C I E T Y
74. C U L T U R E
75. B U S I N E S S
76. L E A R N I N G
77. H E A L T H
78. S P O R T S
79. P L A Y
80. F I T N E S S
81. F O O D
82. D R I N K S
83. S H O P P I N G
84. T R A V E L
85. H O M E
86. W O R K
87. S C H O O L
88. U N I V E R S I T Y
89. H O S P I T A L
90. G O V E R N M E N T
91. M I L I T A R Y
92. R E L I G I O N
93. A R M Y
94. N A V Y
95. A I R F O R C E
96. S P A C E F O R C E
97. P O L I C E
98. F I R E D E P A R T M E N T
99. P R I M E R I A
100. S E C U R I T Y
101. I N T E L L I G E N C E
102. D I F F E R E N C E
103. A B I L I T Y
104. S K I L L S
105. T A L E N T
106. P A S S I O N
107. I N T E R E S T
108. H O B B Y
109. S P O R T
110. A R T
111. M U S I C
112. D A N C E
113. G A M I N G
114. C O L L E C T I N G
115. R E A D I N G
116. W R I T I N G
117. S P E E K I N G
118. L I S T E N I N G
119. T H I N K I N G
120. P R O B L E M S O L V I N G
121. D E C I S I O N M A K I N G
122. C R E A T I V I T Y
123. I M A G I N A T I O N
124. I N N O V A T I O N
125. E N T E R P R E N E U R S H I P
126. L E A D E R S H I P
127. T E A M W O R K
128. C O M M U N I C A T I O N
129. C O L L A B O R A T I O N
130. N E T W O R K I N G
131. P A R T N E R S H I P
132. C O M M U N I T Y
133. S O C I E T Y
134. C U L T U R E
135. B U S I N E S S
136. L E A R N I N G
137. H E A L T H
138. S P O R T S
139. P L A Y
140. F I T N E S S
141. F O O D
142. D R I N K S
143. S H O P P I N G
144. T R A V E L
145. H O M E
146. W O R K
147. S C H O O L
148. U N I V E R S I T Y
149. H O S P I T A L
150. G O V E R N M E N T
151. M I L I T A R Y
152. R E L I G I O N
153. A R M Y
154. N A V Y
155. A I R F O R C E
156. S P A C E F O R C E
157. P O L I C E
158. F I R E D E P A R T M E N T
159. P R I M E R I A
160. S E C U R I T Y
161. I N T E L L I G E N C E
162. D I F F E R E N C E
163. A B I L I T Y
164. S K I L L S
165. T A L E N T
166. P A S S I O N
167. I N T E R E S T
168. H O B B Y
169. S P O R T
170. A R T
171. M U S I C
172. D A N C E
173. G A M I N G
174. C O L L E C T I N G
175. R E A D I N G
176. W R I T I N G
177. S P E E K I N G
178. L I S T E N I N G
179. T H I N K I N G
180. P R O B L E M S O L V I N G
181. D E C I S I O N M A K I N G
182. C R E A T I V I T Y
183. I M A G I N A T I O N
184. I N N O V A T I O N
185. E N T E R P R E N E U R S H I P
186. L E A D E R S H I P
187. T E A M W O R K
188. C O M M U N I C A T I O N
189. C O L L A B O R A T I O N
190. N E T W O R K I N G
191. P A R T N E R S H I P
192. C O M M U N I T Y
193. S O C I E T Y
194. C U L T U R E
195. B U S I N E S S
196. L E A R N I N G
197. H E A L T H
198. S P O R T S
199. P L A Y
200. F I T N E S S
201. F O O D
202. D R I N K S
203. S H O P P I N G
204. T R A V E L
205. H O M E
206. W O R K
207. S C H O O L
208. U N I V E R S I T Y
209. H O S P I T A L
210. G O V E R N M E N T
211. M I L I T A R Y
212. R E L I G I O N
213. A R M Y
214. N A V Y
215. A I R F O R C E
216. S P A C E F O R C E
217. P O L I C E
218. F I R E D E P A R T M E N T
219. P R I M E R I A
220. S E C U R I T Y
221. I N T E L L I G E N C E
222. D I F F E R E N C E
223. A B I L I T Y
224. S K I L L S
225. T A L E N T
226. P A S S I O N
227. I N T E R E S T
228. H O B B Y
229. S P O R T
230. A R T
231. M U S I C
232. D A N C E
233. G A M I N G
234. C O L L E C T I N G
235. R E A D I N G
236. W R I T I N G
237. S P E E K I N G
238. L I S T E N I N G
239. T H I N K I N G
240. P R O B L E M S O L V I N G
241. D E C I S I O N M A K I N G
242. C R E A T I V I T Y
243. I M A G I N A T I O N
244. I N N O V A T I O N
245. E N T E R P R E N E U R S H I P
246. L E A D E R S H I P
247. T E A M W O R K
248. C O M M U N I C A T I O N
249. C O L L A B O R A T I O N
250. N E T W O R K I N G
251. P A R T N E R S H I P
252. C O M M U N I T Y
253. S O C I E T Y
254. C U L T U R E
255. B U S I N E S S
256. L E A R N I N G
257. H E A L T H
258. S P O R T S
259. P L A Y
260. F I T N E S S
261. F O O D
262. D R I N K S
263. S H O P P I N G
264. T R A V E L
265. H O M E
266. W O R K
267. S C H O O L
268. U N I V E R S I T Y
269. H O S P I T A L
270. G O V E R N M E N T
271. M I L I T A R Y
272. R E L I G I O N
273. A R M Y
274. N A V Y
275. A I R F O R C E
276. S P A C E F O R C E
277. P O L I C E
278. F I R E D E P A R T M E N T
279. P R I M E R I A
280. S E C U R I T Y
281. I N T E L L I G E N C E
282. D I F F E R E N C E
283. A B I L I T Y
284. S K I L L S
285. T A L E N T
286. P A S S I O N
287. I N T E R E S T
288. H O B B Y
289. S P O R T
290. A R T
291. M U S I C
292. D A N C E
293. G A M I N G
294. C O L L E C T I N G
295. R E A D I N G
296. W R I T I N G
297. S P E E K I N G
298. L I S T E N I N G
299. T H I N K I N G
300. P R O B L E M S O L V I N G
301. D E C I S I O N M A K I N G
302. C R E A T I V I T Y
303. I M A G I N A T I O N
304. I N N O V A T I O N
305. E N T E R P R E N E U R S H I P
306. L E A D E R S H I P
307. T E A M W O R K
308. C O M M U N I C A T I O N
309. C O L L A B O R A T I O N
310. N E T W O R K I N G
311. P A R T N E R S H I P
312. C O M M U N I T Y
313. S O C I E T Y
314. C U L T U R E
315. B U S I N E S S
316. L E A R N I N G
317. H E A L T H
318. S P O R T S
319. P L A Y
320. F I T N E S S
321. F O O D
322. D R I N K S
323. S H O P P I N G
324. T R A V E L
325. H O M E
326. W O R K
327. S C H O O L
328. U N I V E R S I T Y
329. H O S P I T A L
330. G O V E R N M E N T
331. M I L I T A R Y
332. R E L I G I O N
333. A R M Y
334. N A V Y
335. A I R F O R C E
336. S P A C E F O R C E
337. P O L I C E
338. F I R E D E P A R T M E N T
339. P R I M E R I A
340. S E C U R I T Y
341. I N T E L L I G E N C E
342. D I F F E R E N C E
343. A B I L I T Y
344. S K I L L S
345. T A L E N T
346. P A S S I O N
347. I N T E R E S T
348. H O B B Y
349. S P O R T
350. A R T
351. M U S I C
352. D A N C E
353. G A M I N G
354. C O L L E C T I N G
355. R E A D I N G
356. W R I T I N G
357. S P E E K I N G
358. L I S T E N I N G
359. T H I N K I N G
360. P R O B L E M S O L V I N G
361. D E C I S I O N M A K I N G
362. C R E A T I V I T Y
363. I M A G I N A T I O N
364. I N N O V A T I O N
365. E N T E R P R E N E U R S H I P
366. L E A D E R S H I P
367. T E A M W O R K
368. C O M M U N I C A T I O N
369. C O L L A B O R A T I O N
370. N E T W O R K I N G
371. P A R T N E R S H I P
372. C O M M U N I T Y
373. S O C I E T Y
374. C U L T U R E
375. B U S I N E S S
376. L E A R N I N G
377. H E A L T H
378. S P O R T S
379. P L A Y
380. F I T N E S S
381. F O O D
382. D R I N K S
383. S H O P P I N G
384. T R A V E L
385. H O M E
386. W O R K
387. S C H O O L
388. U N I V E R S I T Y
389. H O S P I T A L
390. G O V E R N M E N T
391. M I L I T A R Y
392. R E L I G I O N
393. A R M Y
394. N A V Y
395. A I R F O R C E
396. S P A C E F O R C E
397. P O L I C E
398. F I R E D E P A R T M E N T
399. P R I M E R I A
400. S E C U R I T Y
401. I N T E L L I G E N C E
402. D I F F E R E N C E
403. A B I L I T Y
404. S K I L L S
405. T A L E N T
406. P A S S I O N
407. I N T E R E S T
408. H O B B Y
409. S P O R T
410. A R T
411. M U S I C
412. D A N C E
413. G A M I N G
414. C O L L E C T I N G
415. R E A D I N G
416. W R I T I N G
417. S P E E K I N G
418. L I S T E N I N G
419. T H I N K I N G
420. P R O B L E M S O L V I N G
421. D E C I S I O N M A K I N G
422. C R E A T I V I T Y
423. I M A G I N A T I O N
424. I N N O V A T I O N
425. E N T E R P R E N E U R S H I P
426. L E A D E R S H I P
427. T E A M W O R K
428. C O M M U N I C A T I O N
429. C O L L A B O R A T I O N
430. N E T W O R K I N G
431. P A R T N E R S H I P
432. C O M M U N I T Y
433. S O C I E T Y
434. C U L T U R E
435. B U S I N E S S
436. L E A R N I N G
437. H E A L T H
438. S P O R T S
439. P L A Y
440. F I T N E S S
441. F O O D
442. D R I N K S
443. S H O P P I N G
444. T R A V E L
445. H O M E
446. W O R K
447. S C H O O L
448. U N I V E R S I T Y
449. H O S P I T A L
450. G O V E R N M E N T
451. M I L I T A R Y
452. R E L I G I O N
453. A R M Y
454. N A V Y
455. A I R F O R C E
456. S P A C E F O R C E
457. P O L I C E
458. F I R E D E P A R T M E N T
459. P R I M E R I A
460. S E C U R I T Y
461. I N T E L L I G E N C E
462. D I F F E R E N C E
463. A B I L I T Y
464. S K I L L S
465. T A L E N T
466. P A S S I O N
467. I N T E R E S T
468. H O B B Y
469. S P O R T
470. A R T
471. M U S I C
472. D A N C E
473. G A M I N G
474. C O L L E C T I N G
475. R E A D I N G
476. W R I T I N G
477. S P E E K I N G
478. L I S T E N I N G
479. T H I N K I N G
480. P R O B L E M S O L V I N G
481. D E C I S I O N M A K I N G
482. C R E A T I V I T Y
483. I M A G I N A T I O N
484. I N N O V A T I O N
485. E N T E R P R E N E U R S H I P
486. L E A D E R S H I P
487. T E A M W O R K
488. C O M M U N I C A T I O N
489. C O L L A B O R A T I O N
490. N E T W O R K I N G
491. P A R T N E R S H I P
492. C O M M U N I T Y
493. S O C I E T Y
494. C U L T U R E
495. B U S I N E S S
496. L E A R N I N G
497. H E A L T H
498. S P O R T S
499. P L A Y
500. F I T N E S S
501. F O O D
502. D R I N K S
503. S H O P P I N G
504. T R A V E L
505. H O M E
506. W O R K
507. S C H O O L
508. U N I V E R S I T Y
509. H O S P I T A L
510. G O V E R N M E N T
511. M I L I T A R Y
512. R E L I G I O N
513. A R M Y
514. N A V Y
515. A I R F O R C E
516. S P A C E F O R C E
517. P O L I C E
518. F I R E D E P A R T M E N T
519. P R I M E R I A
520. S E C U R I T Y
521. I N T E L L I G E N C E
522. D I F F E R E N C E
523. A B I L I T Y
524. S K I L L S
525. T A L E N T
526. P A S S I O N
527. I N T E R E S T
528. H O B B Y
529. S P O R T
530. A R T
531. M U S I C
532. D A N C E
533. G A M I N G
534. C O L L E C T I N G
535. R E A D I N G
536. W R I T I N G
537. S P E E K I N G
538. L I S T E N I N G
539. T H I N K I N G
540. P R O B L E M S O L V I N G
541. D E C I S I O N M A K I N G
542. C R E A T I V I T Y
543. I M A G I N A T I O N
544. I N N O V A T I O N
545. E N T E R P R E N E U R S H I P
546. L E A D E R S H I P
547. T E A M W O R K
548. C O M M U N I C A T I O N
549. C O L L A B O R A T I O N
550. N E T W O R K I N G
551. P A R T N E R S H I P
552. C O M M U N I T Y
553. S O C I E T Y
554. C U L T U R E
555. B U S I N E S S
556. L E A R N I N G
557. H E A L T H
558. S P O R T S
559. P L A Y
560. F I T N E S S
561. F O O D
562. D R I N K S
563. S H O P P I N G
564. T R A V E L
565. H O M E
566. W O R K
567. S C H O O L
568. U N I V E R S I T Y
569. H O S P I T A L
570. G O V E R N M E N T
571. M I L I T A R Y
572. R E L I G I O N
573. A R M Y
574. N A V Y
575. A I R F O R C E
576. S P A C E F O R C E
577. P O L I C E
578. F I R E D E P A R T M E N T
579. P R I M E R I A
580. S E C U R I T Y
581. I N T E L L I G E N C E
582. D I F F E R E N C E
583. A B I L I T Y
584. S K I L L S
585. T A L E N T
586. P A S S I O N
587. I N T E R E S T
588. H O B B Y
589. S P O R T
590. A R T
591. M U S I C
592. D A N C E
593. G A M I N G
594. C O L L E C T I N G
595. R E A D I N G
596. W R I T I N G
597. S P E E K I N G
598. L I S T E N I N G
599. T H I N K I N G
600. P R O B L E M S O L V I N G
601. D E C I S I O N M A K I N G
602. C R E A T I V I T Y
603. I M A G I N A T I O N
604. I N N O V A T I O N
605. E N T E R P R E N E U R S H I P
606. L E A D E R S H I P
607. T E A M W O R K
608. C O M M U N I C A T I O N
609. C O L L A B O R A T I O N
610. N E T W O R K I N G
611. P A R T N E R S H I P
612. C O M M U N I T Y
613. S O C I E T Y
614. C U L T U R E
615. B U S I N E S S
616. L E A R N I N G
617. H E A L T H
618. S P O R T S
619. P L A Y
620. F I T N E S S
621. F O O D
622. D R I N K S
623. S H O P P I N G
624. T R A V E L
625. H O M E
626. W O R K
627. S C H O O L
628. U N I V E R S I T Y
629. H O S P I T A L
630. G O V E R N M E N T
631. M I L I T A R Y
632. R E L I G I O N
633. A R M Y
634. N A V Y
635. A I R F O R C E
636. S P A C E F O R C E
637. P O L I C E
638. F I R E D E P A R T M E N T
639. P R I M E R I A
640. S E C U R I T Y
641. I N T E L L I G E N C E
642. D I F F E R E N C E
643. A B I L I T Y
644. S K I L L S
645. T A L E N T
646. P A S S I O N
647. I N T E R E S T
648. H O B B Y
649. S P O R T
650. A R T
651. M U S I C
652. D A N C E
653. G A M I N G
654. C O L L E C T I N G
655. R E A D I N G
656. W R I T I N G
657. S P E E K I N G
658. L I S T E N I N G
659. T H I N K I N G
660. P R O B L E M S O L V I N G
661. D E C I S I O N M A K I N G
662. C R E A T I V I T Y
663. I M A G I N A T I O N
664. I N N O V A T I O N
665. E N T E R P R E N E U R S H I P
666. L E A D E R S H I P
667. T E A M W O R K
668. C O M M U N I C A T I O N
669. C O L L A B O R A T I O N
670. N E T W O R K I N G
671. P A R T N E R S H I P
672. C O M M U N I T Y
673. S O C I E T Y
674. C U L T U R E
675. B U S I N E S S
676. L E A R N I N G
677. H E A L T H
678. S P O R T S
679. P L A Y
680. F I T N E S S
681. F O O D
682. D R I N K S
683. S H O P P I N G
684. T R A V E L
685. H O M E
686. W O R K
687. S C H O O L
688. U N I V E R S I T Y
689. H O S P I T A L
690. G O V E R N M E N T
691. M I L I T A R Y
692. R E L I G I O N
693. A R M Y
694. N A V Y
695. A I R F O R C E
696. S P A C E F O R C E
697. P O L I C E
698. F I R E D E P A R T M E N T
699. P R I M E R I A
700. S E C U R I T Y
701. I N T E L L I G E N C E
702. D I F F E R E N C E
703. A B I L I T Y
704. S K I L L S
705. T A L E N T
706. P A S S I O N
707. I N T E R E S T
708. H O B B Y
709. S P O R T
710. A R T
711. M U S I C
712. D A N C E
713. G A M I N G
714. C O L L E C T I N G
715. R E A D I N G
716. W R I T I N G
717. S P E E K I N G
718. L I S T E N I N G
719. T H I N K I N G
720. P R O B L E M S O L V I N G
721. D E C I S I O N M A K I N G
722. C R E A T I V I T Y
723. I M A G I N A T I O N
724. I N N O V A T I O N
725. E N T E R P R E N E U R S H I P
726. L E A D E R S H I P
727. T E A M W O R K
728. C O M M U N I C A T I O N
729. C O L L A B O R A T I O N
730. N E T W O R K I N G
731. P A R T N E R S H I P
732. C O M M U N I T Y
733. S O C I E T Y
734. C U L T U R E
735. B U S I N E S S
736. L E A R N I N G
737. H E A L T H
738. S P O R T S
739. P L A Y
740. F I T N E S S
741. F O O D
742. D R I N K S
743. S H O P P I N G
744. T R A V E L
745. H O M E
746. W O R K
747. S C H O O L
748. U N I V E R S I T Y
749. H O S P I T A L
750. G O V E R N M E N T
751. M I L I T A R Y
752. R E L I G I O N
753. A R M Y
754. N A V Y
755. A I R F O R C E
756. S P A C E F O R C E
757. P O L I C E
758. F I R E D E P A R T M E N T
759. P R I M E R I A
760. S E C U R I T Y
761. I N T E L L I G E N C E
762. D I F F E R E N C E
763. A B I L I T Y
764. S K I L L S
765. T A L E N T
766. P A S S I O N
767. I N T E R E S T
768. H O B B Y
769. S P O R T
770. A R T
771. M U S I C
772. D A N C E
773. G A M I N G
774. C O L L E C T I N G
775. R E A D I N G
776. W R I T I N G
777. S P E E K I N G
778. L I S T E N I N G
779. T H I N K I N G
780. P R O B L E M S O L V I N G
781. D E C I S I O N M A K I N G
782. C R E A T I V I T Y
783. I M A G I N A T I O N
784. I N N O V A T I O N
785. E N T E R P R E N E U R S H I P
786. L E A D E R S H I P
787. T E A M W O R K
788. C O M M U N I C A T I O N
789. C O L L A B O R A T I O N
790. N E T W O R K I N G
791. P A R T N E R S H I P
792. C O M M U N I T Y
793. S O C I E T Y
794. C U L T U R E
795. B U S I N E S S
796. L E A R N I N G
797. H E A L T H
798. S P O R T S
799. P L A Y
800. F I T N E S S
801. F O O D
802. D R I N K S
803. S H O P P I N G
804. T R A V E L
805. H O M E
806. W O R K
807. S C H O O L
808. U N I V E R S I T Y
809. H O S P I T A L
810. G O V E R N M E N T
811. M I L I T A R Y
812. R E L I G I O N
813. A R M Y
814. N A V Y
815. A I R F O R C E
816. S P A C E F O R C E
817. P O L I C E
818. F I R E D E P A R T M E N T
819. P R I M E R I A
820. S E C U R I T Y
821. I N T E L L I G E N C E
822. D I F F E R E N C E
823. A B I L I T Y
824. S K I L L S
825. T A L E N T
826. P A S S I O N
827. I N T E R E S T
828. H O B B Y
829. S P O R T
830. A R T
831. M U S I C
832. D A N C E
833. G A M I N G
834. C O L L E C T I N G
835. R E A D I N G
836. W R I T I N G
837. S P E E K I N G
838. L I S T E N I N G
839. T H I N K I N G
840. P R O B L E M S O L V I N G
841. D E C I S I O N M A K I N G
842. C R E A T I V I T Y
843. I M A G I N A T I O N
844. I N N O V A T I O N
845. E N T E R P R E N E U R S H I P
846. L E A D E R S H I P
847. T E A M W O R K
848. C O M M U N I C A T I O N
849. C O L L A B O R A T I O N
850. N E T W O R K I N G
851. P A R T N E R S H I P
852. C O M M U N I T Y
853. S O C I E T Y
854. C U L T U R E
855. B U S I N E S S
856. L E A R N I N G
857. H E A L T H
858. S P O R T S
859. P L A Y
860. F I T N E S S
861. F O O D
862. D R I N K S
863. S H O P P I N G
864. T R A V E L
865. H O M E
866. W O R K
867. S C H O O L
868. U N I V E R S I T Y
869. H O S P I T A L
870. G O V E R N M E N T
871. M I L I T A R Y
872. R E L I G I O N
873. A R M Y
874. N A V Y
875. A I R F O R C E
876. S P A C E F O R C E
877. P O L I C E
878. F I R E D E P A R T M E N T
879. P R I M E R I A
880. S E C U R I T Y
881. I N T E L L I G E N C E
882. D I F F E R E N C E
883. A B I L I T Y
884. S K I L L S
885. T A L E N T
886. P A S S I O N
887. I N T E R E S T
888. H O B B Y
889. S P O R T
890

1. I want that this is a law.
 . Necessarily and yet in error
 in front of law by the. All
 in front of all take for fear
 in front of all take it.




4	LIMNAEAE EPEGENEAMENE	K		
	ITAMENE	K		4.4
	ELIMNAEYITETALAE	K		4.4
1	FLITIE			
18	651			

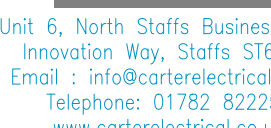SHEED CH. 35198 Level Basement Ceiling Plan REF. C1488 - P10 Drawing Status: PRELIMINARY			
<div style="text-align: center;">  <p>Unit 4, North Staffs Business Park, Incewood Way, Staffs, ST16 4BH Email - info@electrical.co.uk Telephone: 01782 822250 www.electrical.co.uk</p> </div>			
			
Project:			
PALL MALL MANCHESTER			
The BASEMENT LIGHTING & EMERGENCY LAYOUT			
SHEPPARD ROBSON			
Architect:	<div style="border: 1px solid black; padding: 5px; text-align: center;"> RAMBOLL </div>		
Designer: PC	Project: MB	DO: PC	Drawn: MD
Date: 02.12.2022	Project Number: CES561	Scale: 1:100	A0
Drawing No: 6911-CES-XX-B1-DR-E-6300			
Copyright, Central Electrical Services Ltd Contractors are to check all dimensions on site and refer any discrepancies to Central Electrical immediately			

ENE VAL N TE

1. L I T T E R A T U R E
2. N E T W O R K I N G
3. P R O J E C T I N G
4. B I L D I N G
5. I N S T A L L A T I O N
6. M A I N T E N A N C E
7. R E P A I R I N G
8. D I S M A N T L I N G
9. R E C Y C L I N G
10. E N E R G Y E F F I C I E N C Y
11. S U S T A I N A B L E D E V E L O P M E N T
12. C O M M U N I T Y
13. E N V I R O N M E N T
14. H E A L T H
15. W E L F A R E
16. E D U C A T I O N
17. E M P L O Y M E N T
18. C U L T U R E
19. S O C I A L
20. E C O N O M I C

L I N E I N T E R P R E T A T I O N	
YM	E
1	L I N E I N T E R P R E T A T I O N
2	L I N E I N T E R P R E T A T I O N
3	L I N E I N T E R P R E T A T I O N
100	L I N E I N T E R P R E T A T I O N

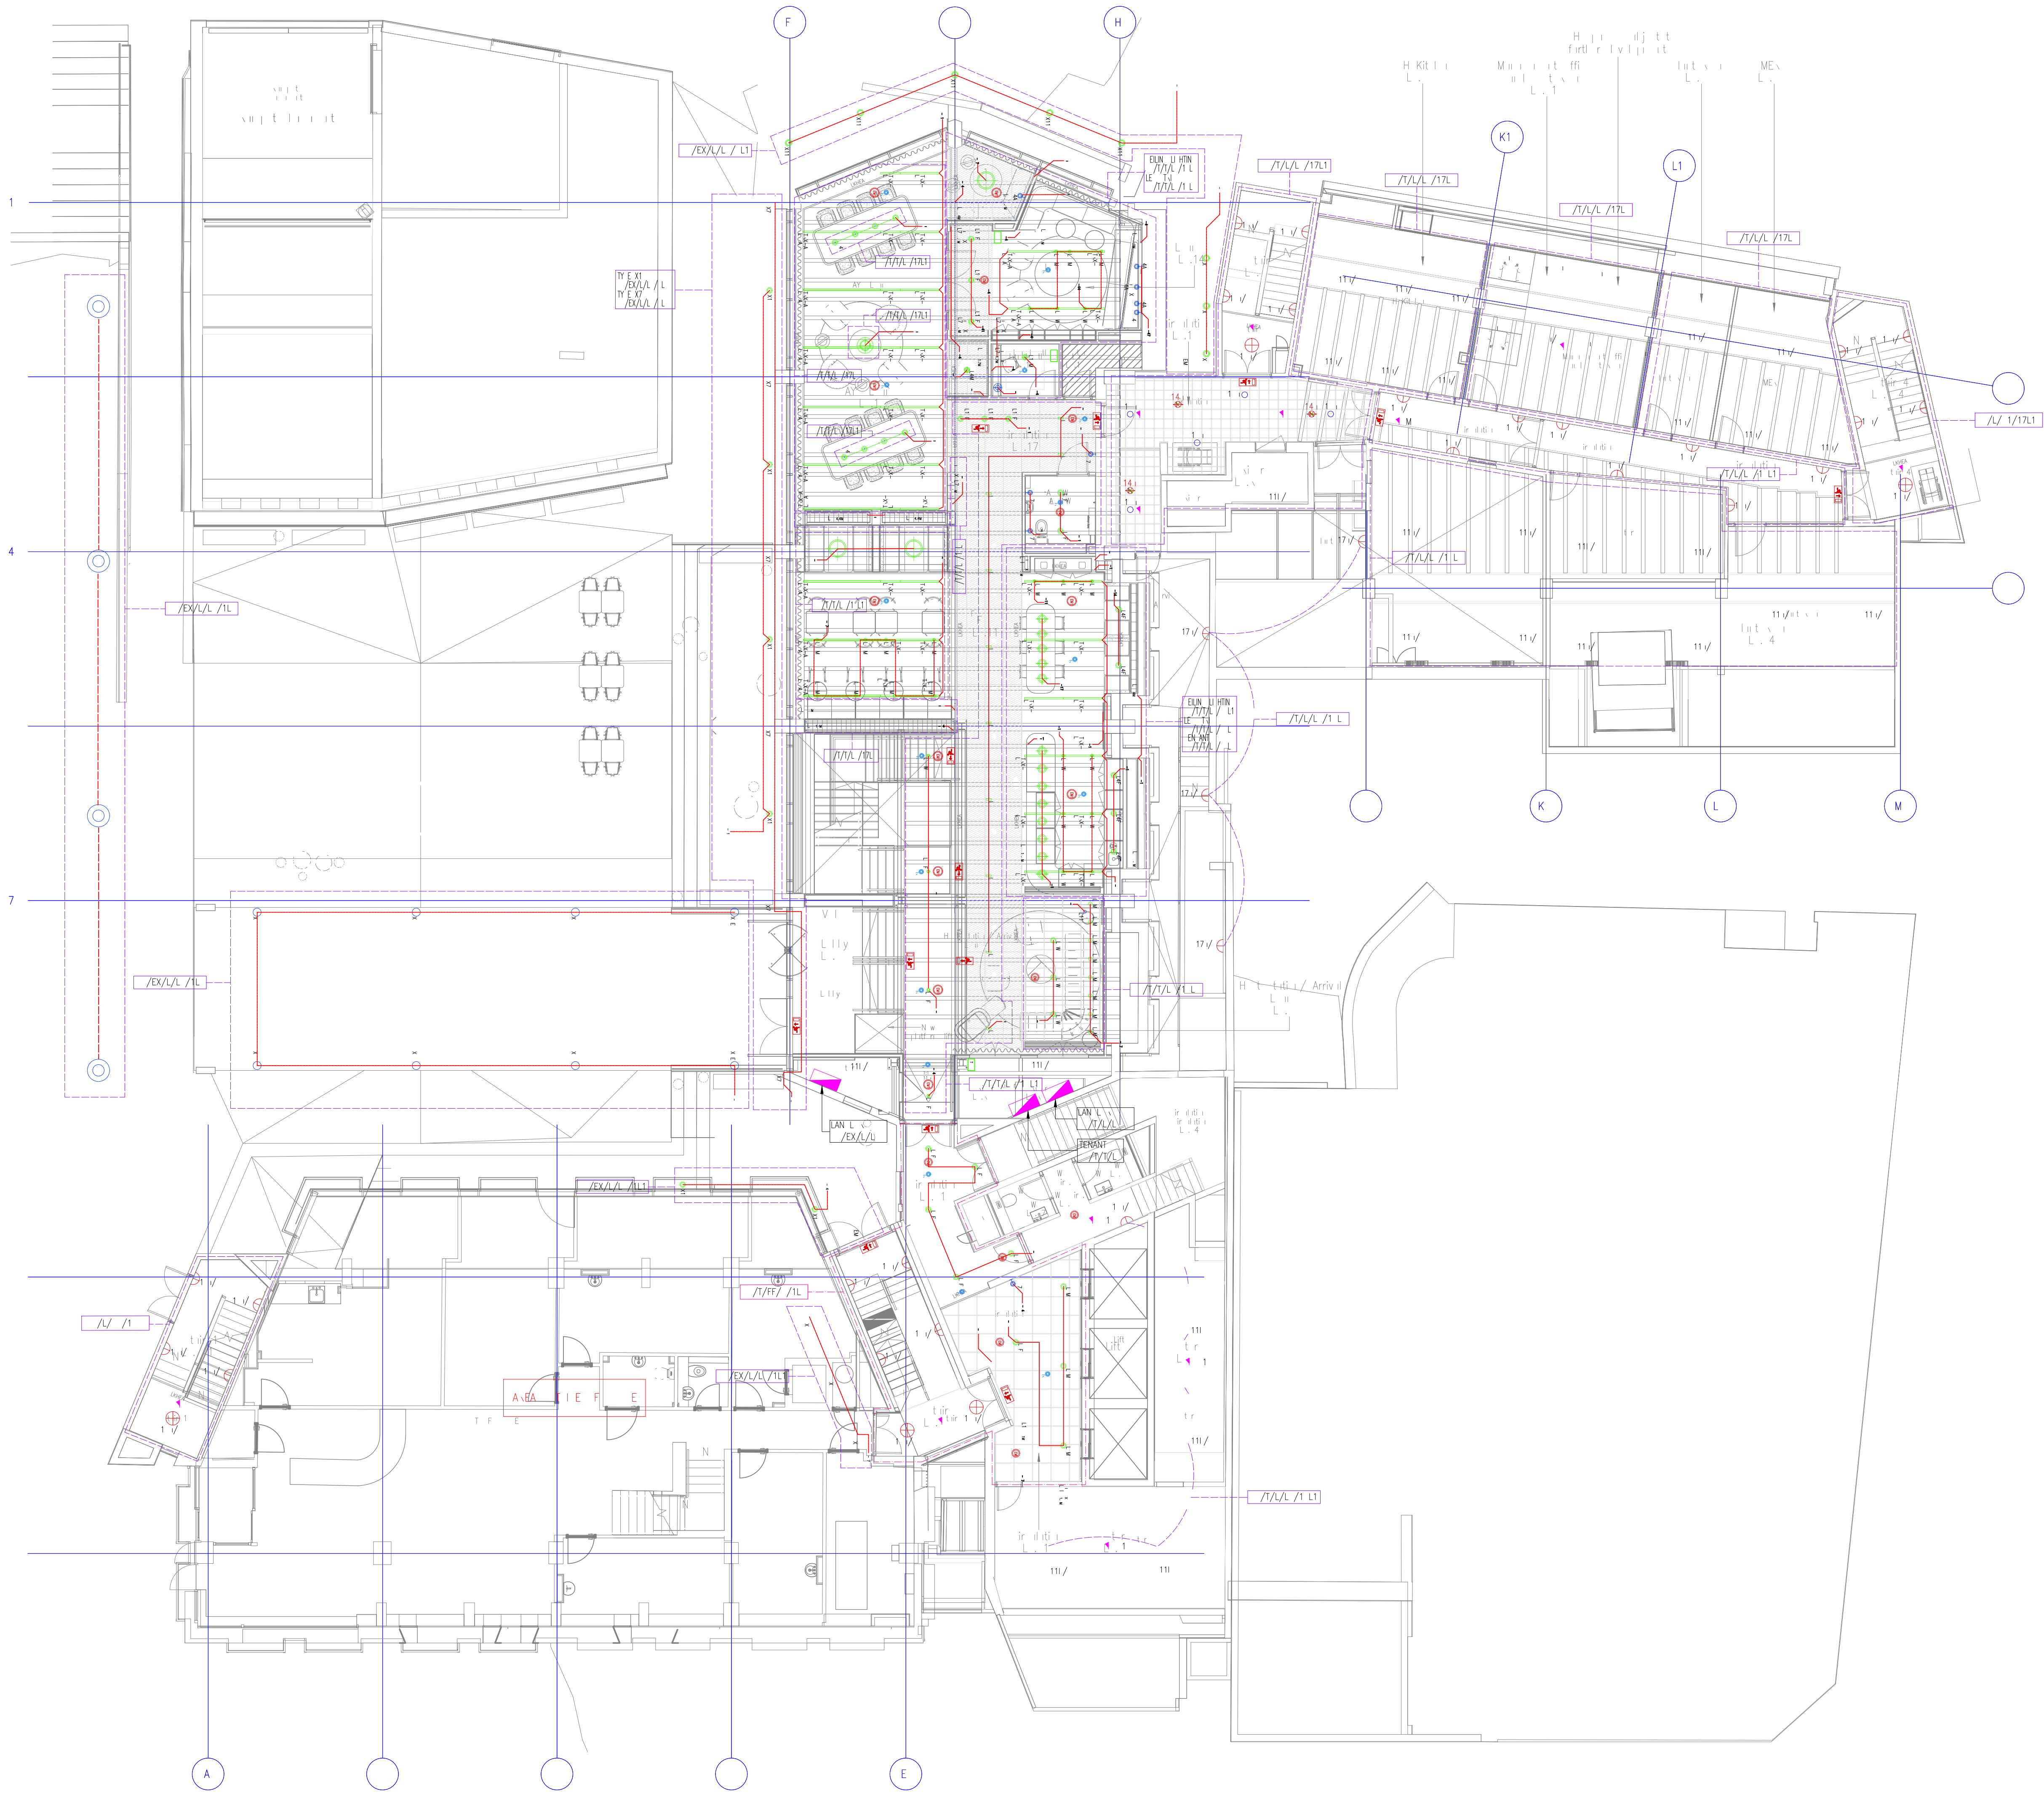

4	L I N E I N T E R P R E T A T I O N	K	1
5	L I N E I N T E R P R E T A T I O N	K	2
6	L I N E I N T E R P R E T A T I O N	K	3
100	L I N E I N T E R P R E T A T I O N	K	97

BASED ON: 35109 Lower Ground Ceiling Plan REF: CLEARED - P11

Drawing Status: **PRELIMINARY**

Unit 6, North Staffs Business Park,
Innovation Way, Staffs, ST4 4SF
Email: info@carterelectrical.co.uk
Telephone: 01782 822250
www.carterelectrical.co.uk

Project:
**PALL MALL
MANCHESTER**

THE
LOWER GROUND FLOOR
LIGHTING & EMERGENCY LIGHTING
LAYOUT

Architect: SHEPPARD ROBSON

Consultant: RAMBOLL


Designer: PG Project: CB Date: 02.12.2022 Project Number: CES561 Scale: 1:100 Drawn: MD

Drawing No: 6911-CES-XX-LG-DR-E-6301 Rev: 001

Copyright: Carter Electrical Services Ltd
Contractors are to check all dimensions on site and refer any discrepancies to Carter Electrical immediately

ENE VAL N TE

1. I want that this is a law.
 . Necessarily and yet in error
 in front of law by the. All
 in front of all take for fear
 in front of all take it.


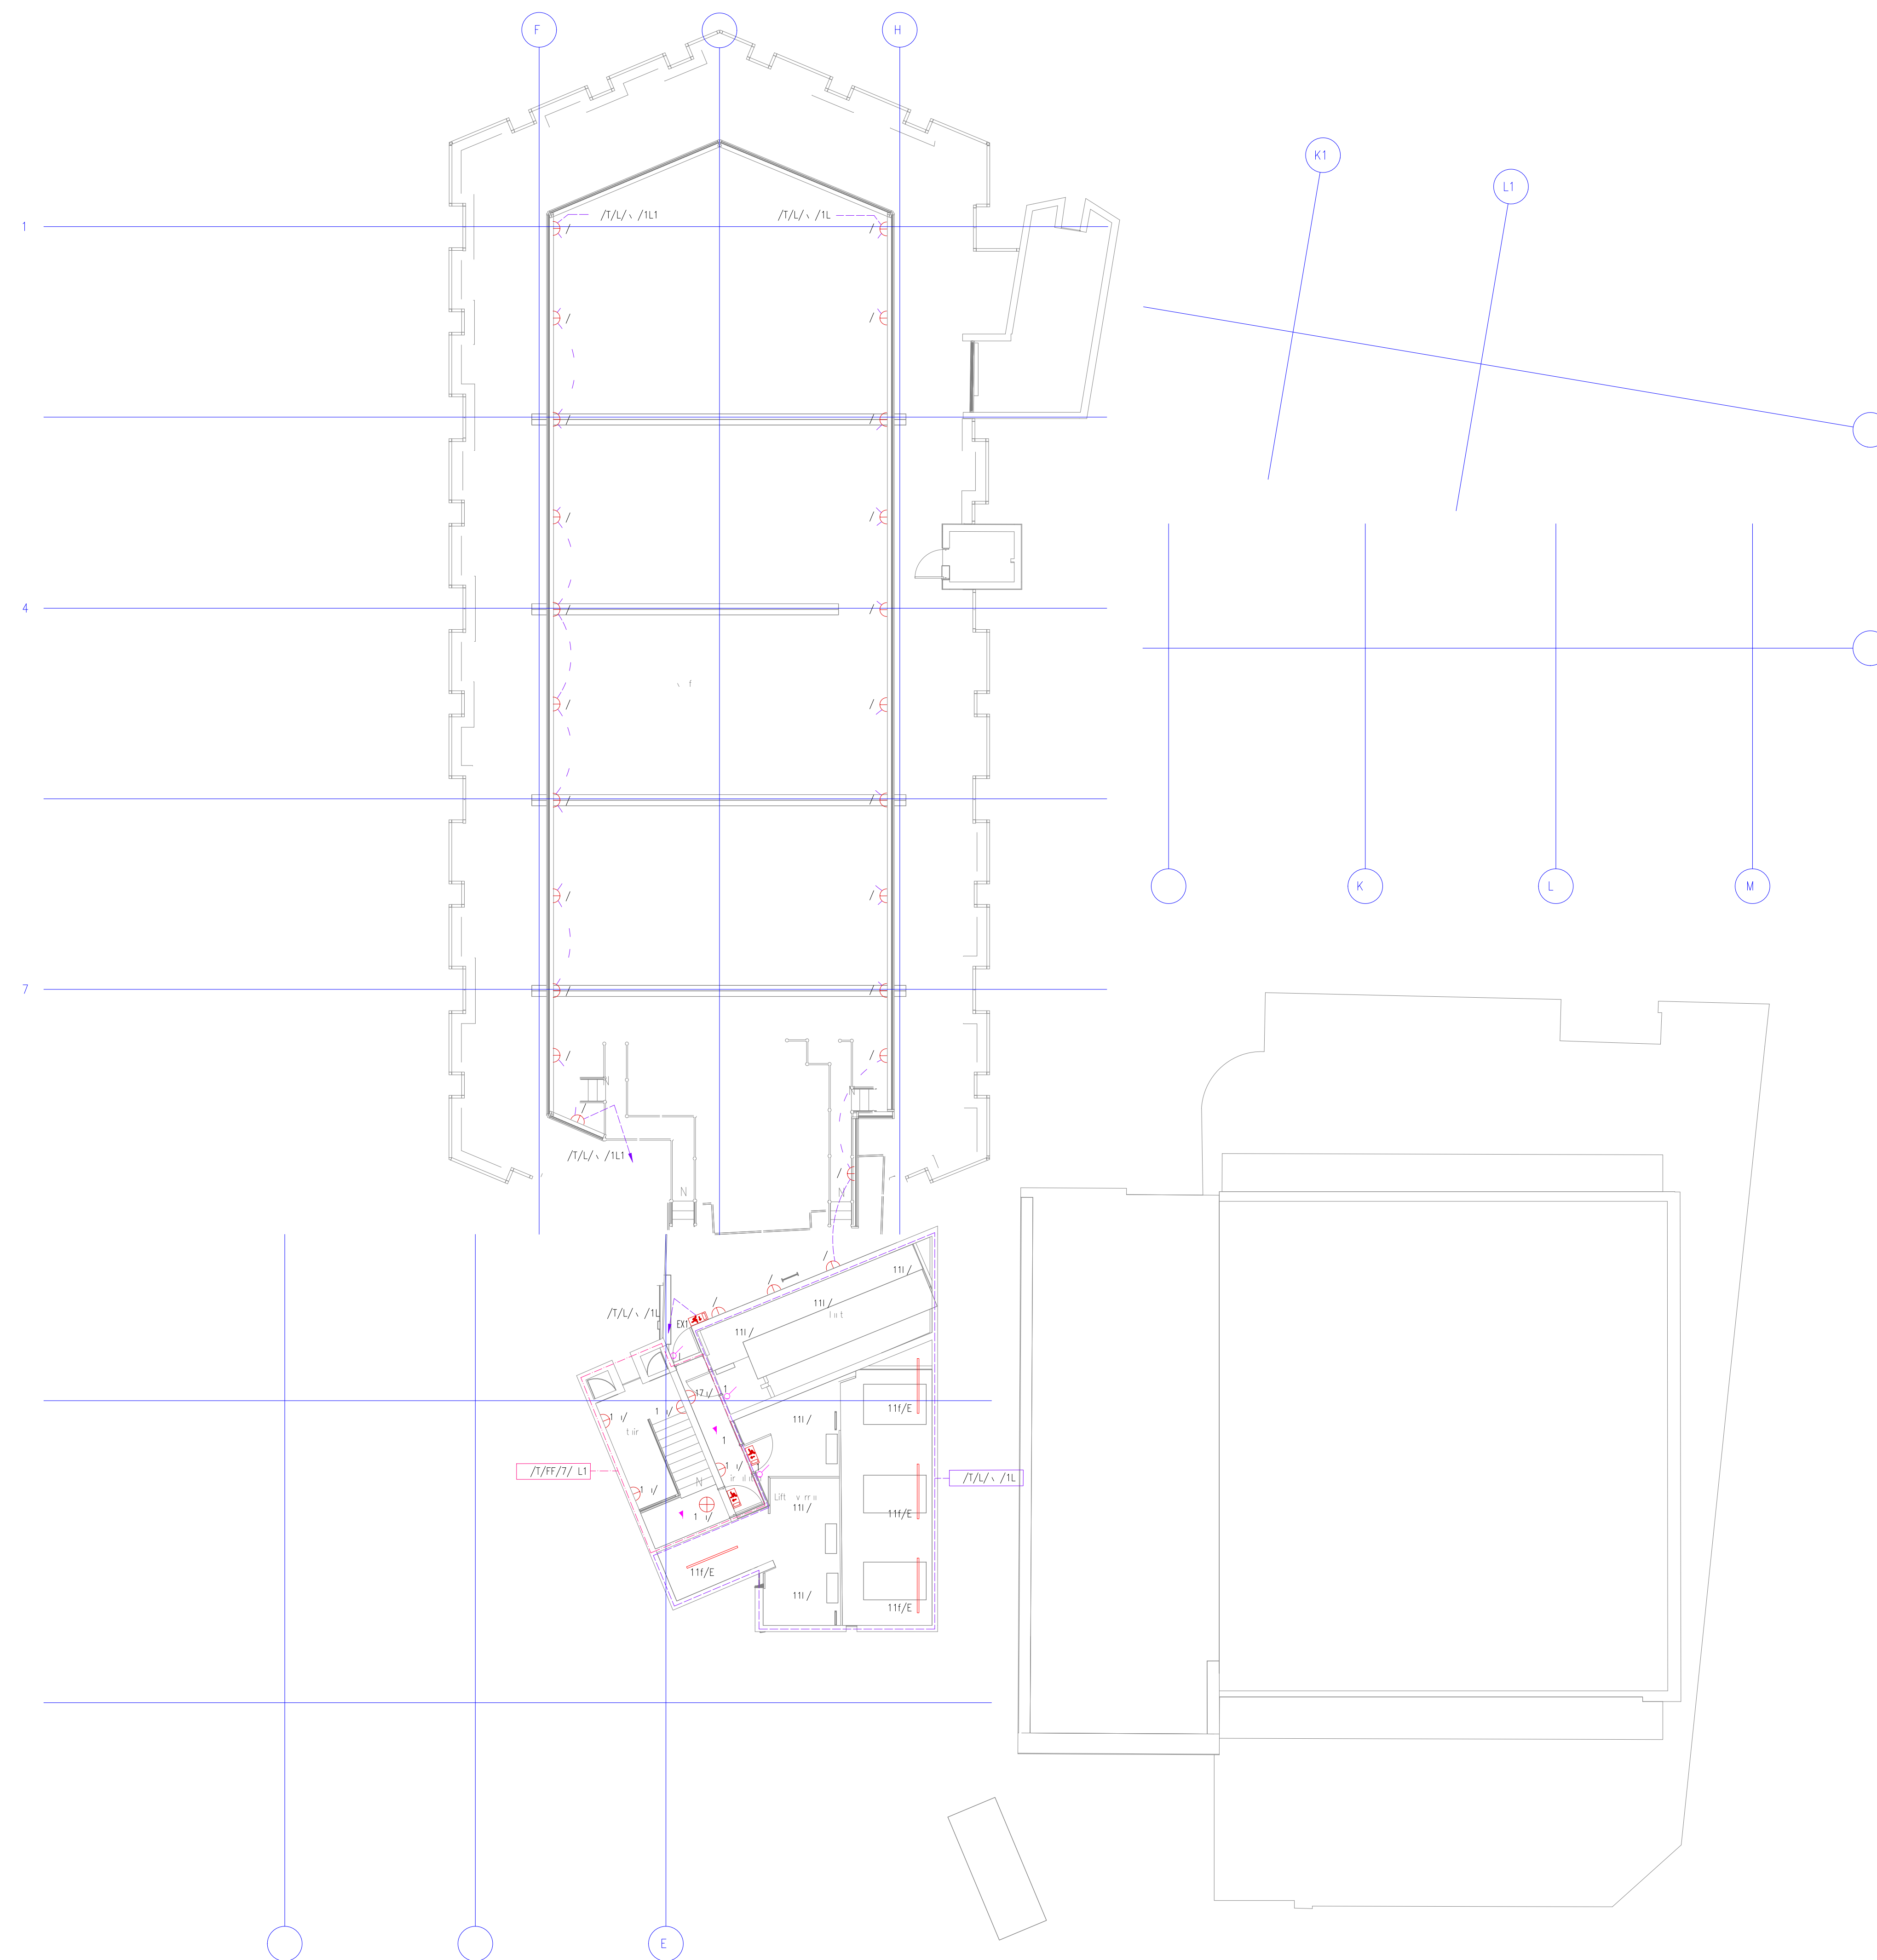


YM L	E	NT \ L
	WALL M NTE L MINA-E	
	WALL M NTE L MINA-E /W EME\ EN Y	
	JFA E I\ LA\ L MINA-E	
	JFA E I\ LA\ L MINA-E /W EME\ EN Y	
	\E E E WULL HT L MINA-E	
	\E E E WULL HT /W EME\ EN Y	
	\E E E MIN WULL HT L MINA-E	
	\E E E MIN WULL HT /W EME\ EN Y	
	I-E T/M I-E T LINEA LE L MINA-E	
	I-E T/M I-E T LINEA LE L MINA-E /W EME\ EN Y	
	ELE T\ N E I\ -M LI HTN ETE T \	
	ELE T\ N E I\ -M -M LI HTN ETE T \	
	ELE T\ N E E\ -M AU LI HTN ETE T \	
	ELE T\ N MW -M AU LI HTN M\ WAVE ETE T \	
	I WAY MIT H EN TE N M E F AN I EN TE \ WATE	
	ELF NTANE /N N MANTANE EME\ EN Y UOHEA	
	ELF NTANE /N N MANTANE EME\ EN Y UOHEA WITH NMIN MAN EXIT LE EN	
	EN A EA E A E T	
	\ \ \ E A E T	
	EME\ EN Y TAIN T	
	EME\ EN Y EXIT I N MIN	
	EME\ EN Y EXIT I N LEFT	
	EME\ EN Y EXIT I N \ HT	
	EME\ EN Y EXIT I N	
	\E E E I\	
	\E E E I\ H T ELL	
	WALL M NTE T I\	
	WALL M NTE T I\ H T ELL	
	H T ELL HEA	
	I WAY MIT H	
	WAY MIT H	
	INTE MATE MIT H	
	KEY MIT H	
	LI \	
	LI HTN NTS L M LE	

GENERAL NOTE

1. This drawing is a preliminary drawing and is not for construction. It is for information only and is not to be used for any other purpose.

CONTAINMENT	
SYMBOL	DESCRIPTION
	LV TIE
	VIA A KET
	HA E I T I N A
	ELE T A K A A
	ELE T A K F T A A E E

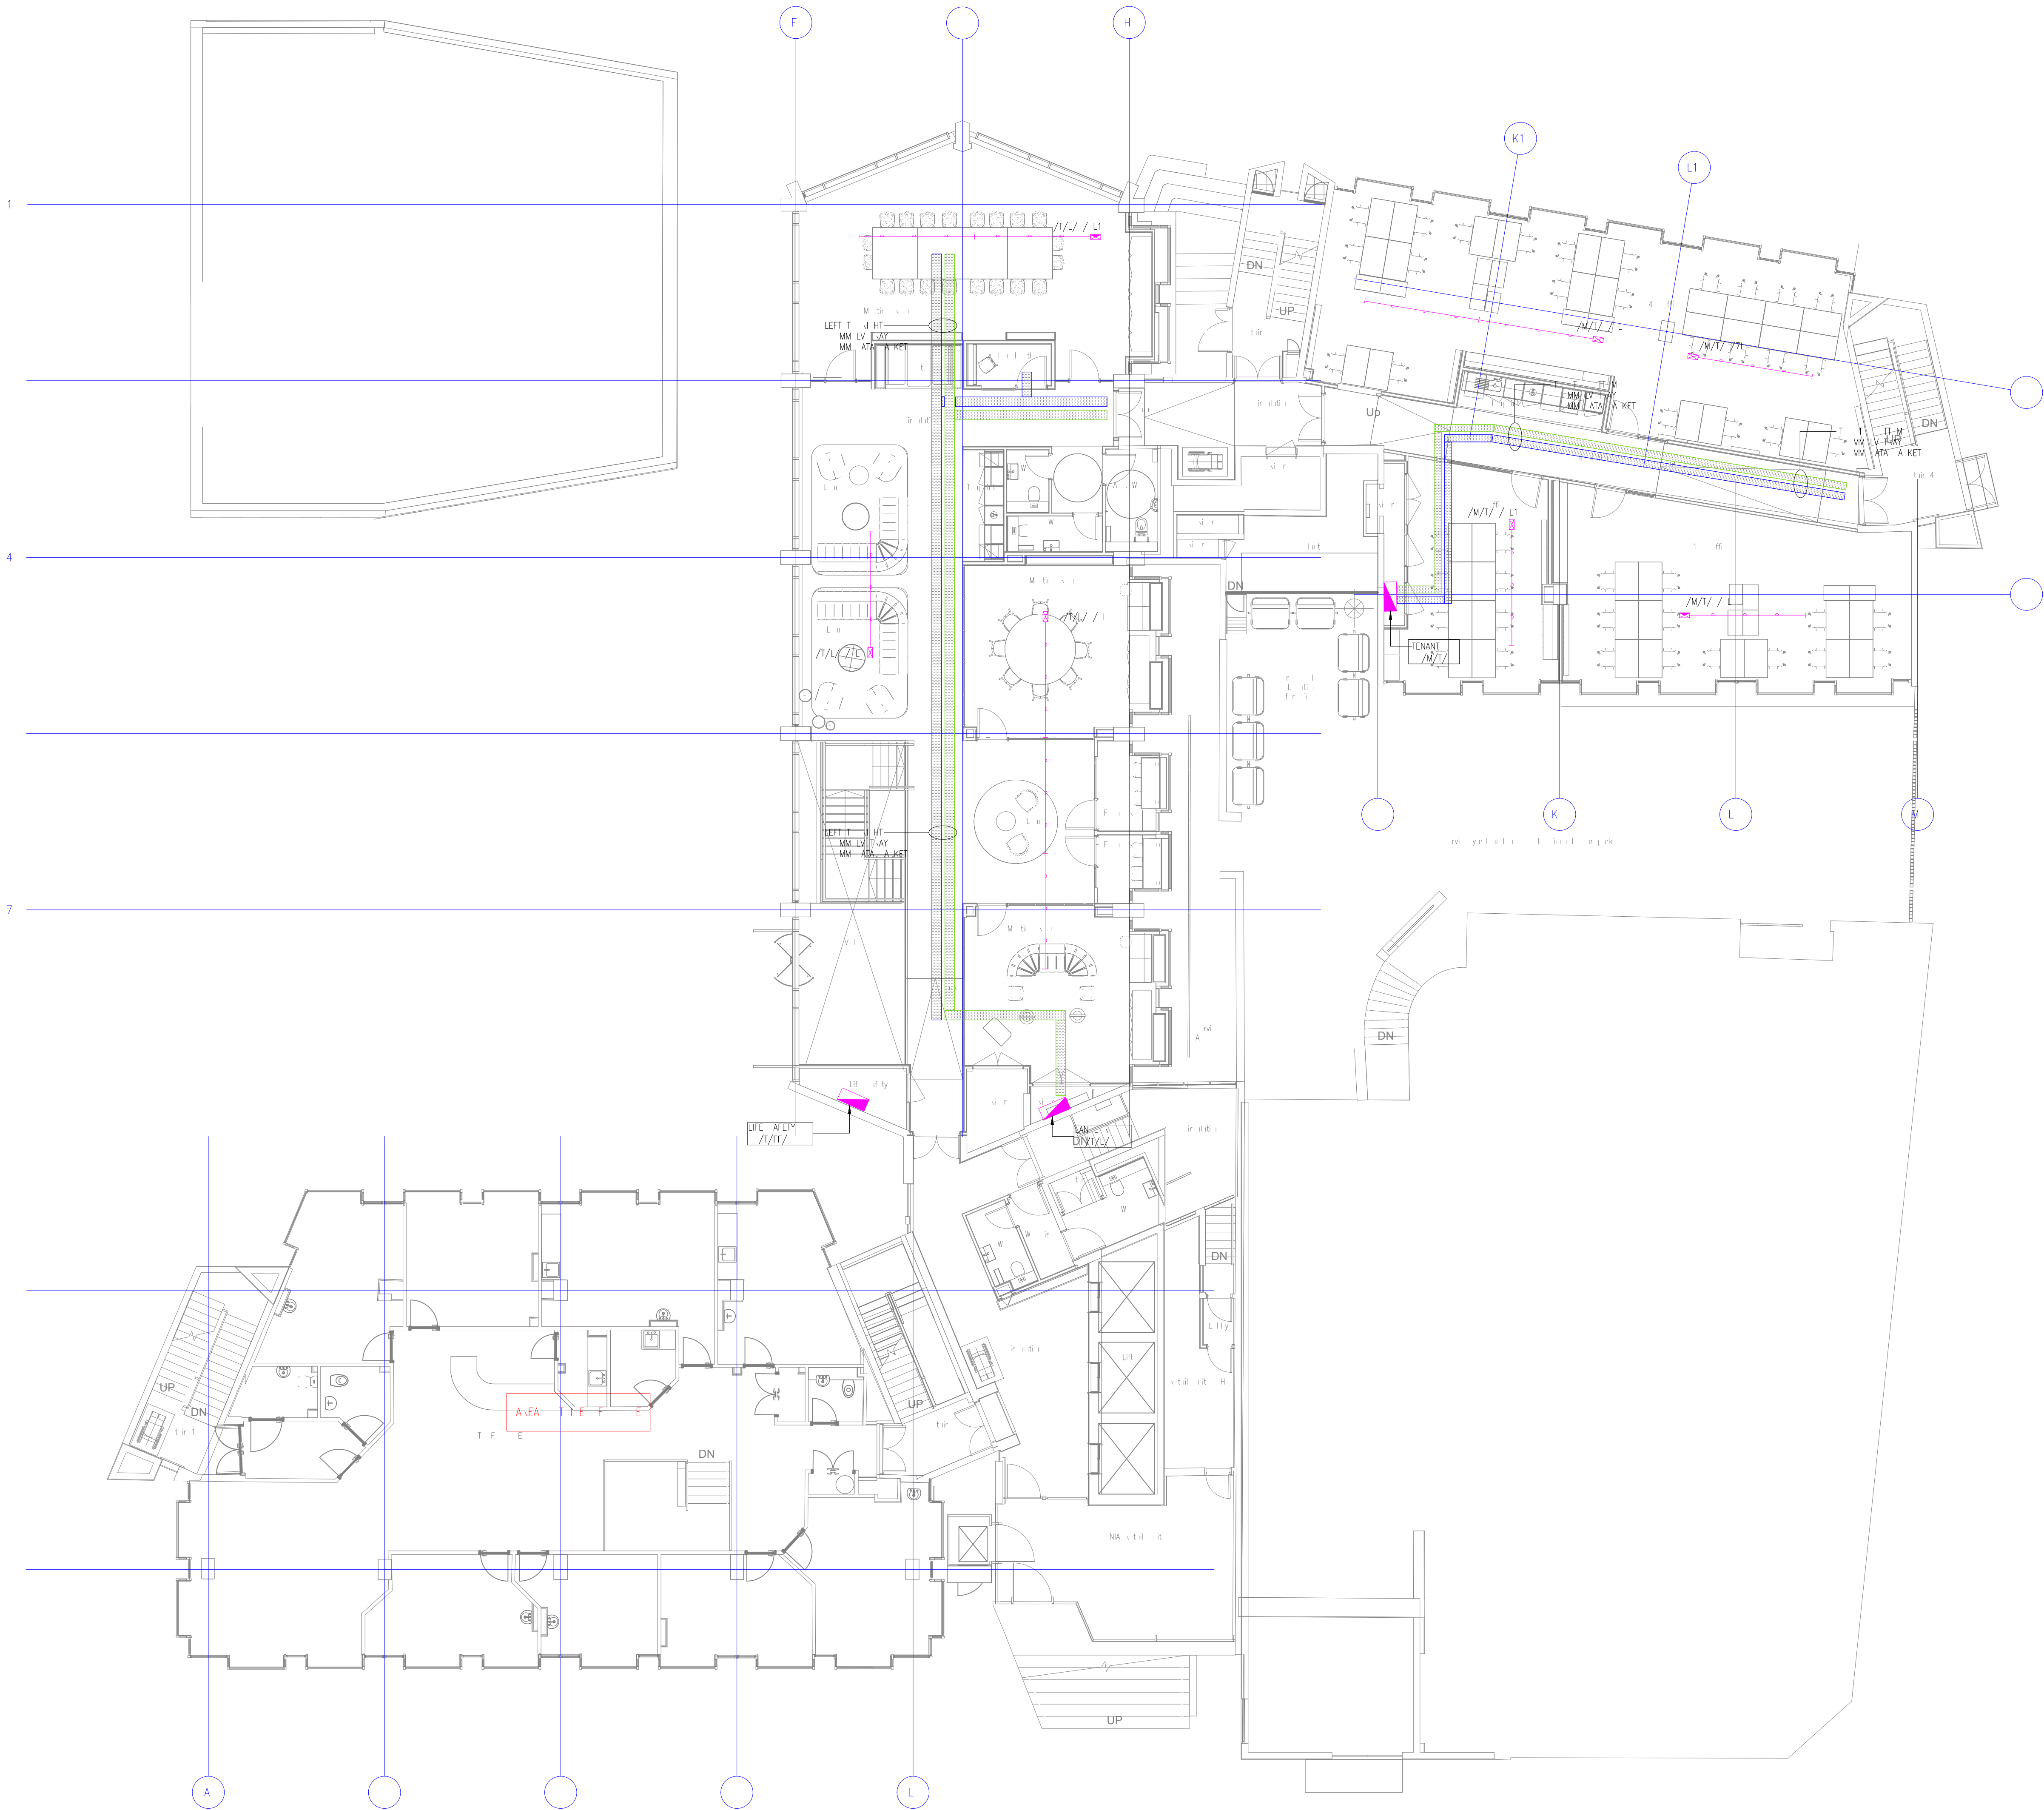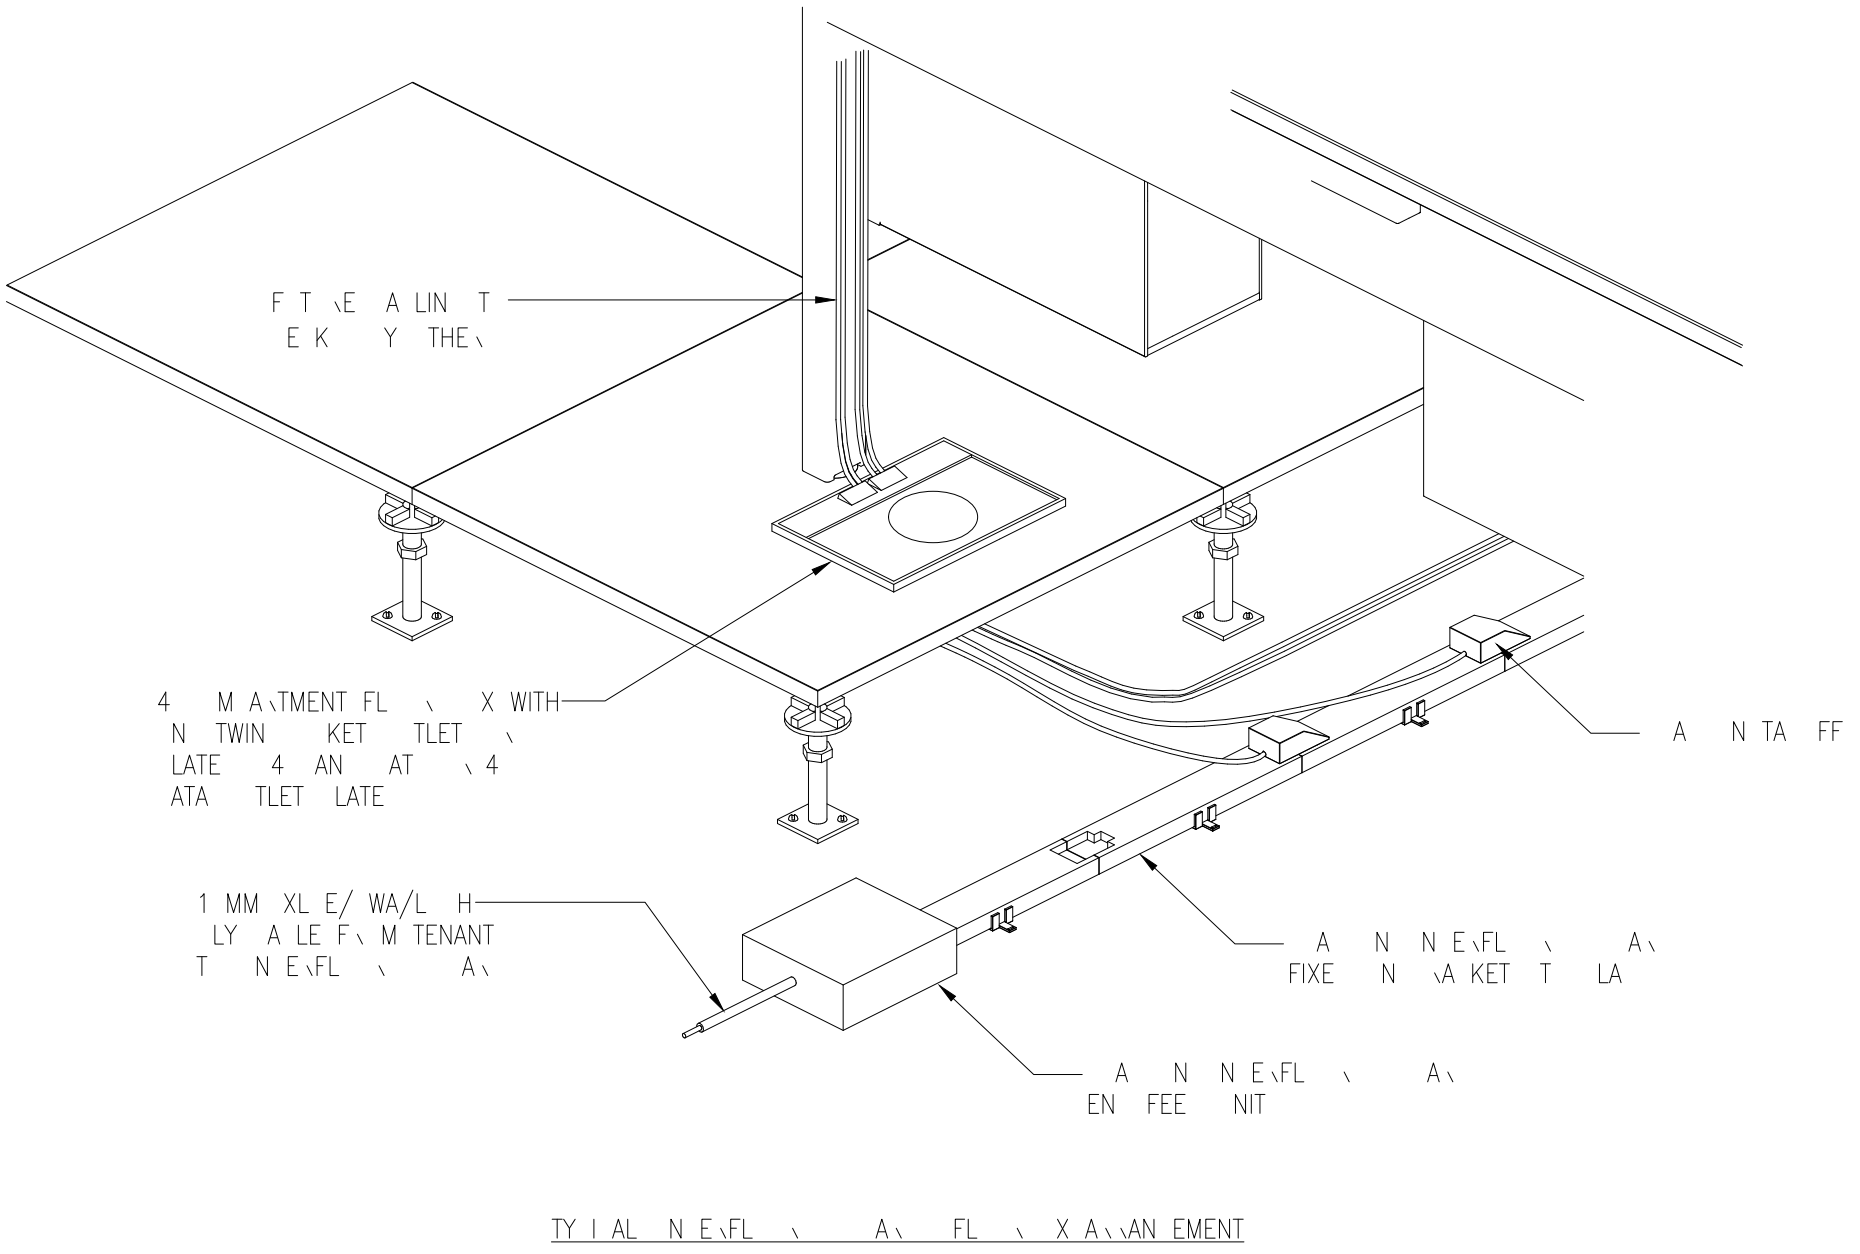


AMEN E T MENT		K	
P R E			
Drawing Status		PRELIMINARY	
Unit 6, North Staffs Business Park, Innovation Way, Staffs, ST4 4SF Email: info@carterelectrical.co.uk Telephone: 01782 822250 www.carterelectrical.co.uk			
Project			
PALL MALL MANCHESTER			
The GROUND FLOOR LOW LEVEL CONTAINMENT LAYOUT			
Architect: SHEPPARD ROBSON			
Consultant: RAMBOLL			
Designer: PG	Project: CB	Doc: PG	Checked: MD
Date: 06.01.2023	Project Number: CES561	Scale: 1:100	AO
Drawing No: 6911-CES-XX-00-DR-E-6615			Rev: 1
Copyright: Carter Electrical Services Ltd. Contractors are to check all dimensions on site and refer any discrepancies to Carter Electrical immediately.			

GENERAL NOTE

- 1. This drawing is a preliminary drawing and is not for construction purposes. All dimensions are approximate and subject to change without notice.



CONTAINMENT	
SYM	DESCRIPTION
LV	LV TRAY
VIA	VIA A KET
HA	HA EIT D N A
EL	EL T A K A A
EL	EL T A K F T A A EN FEE

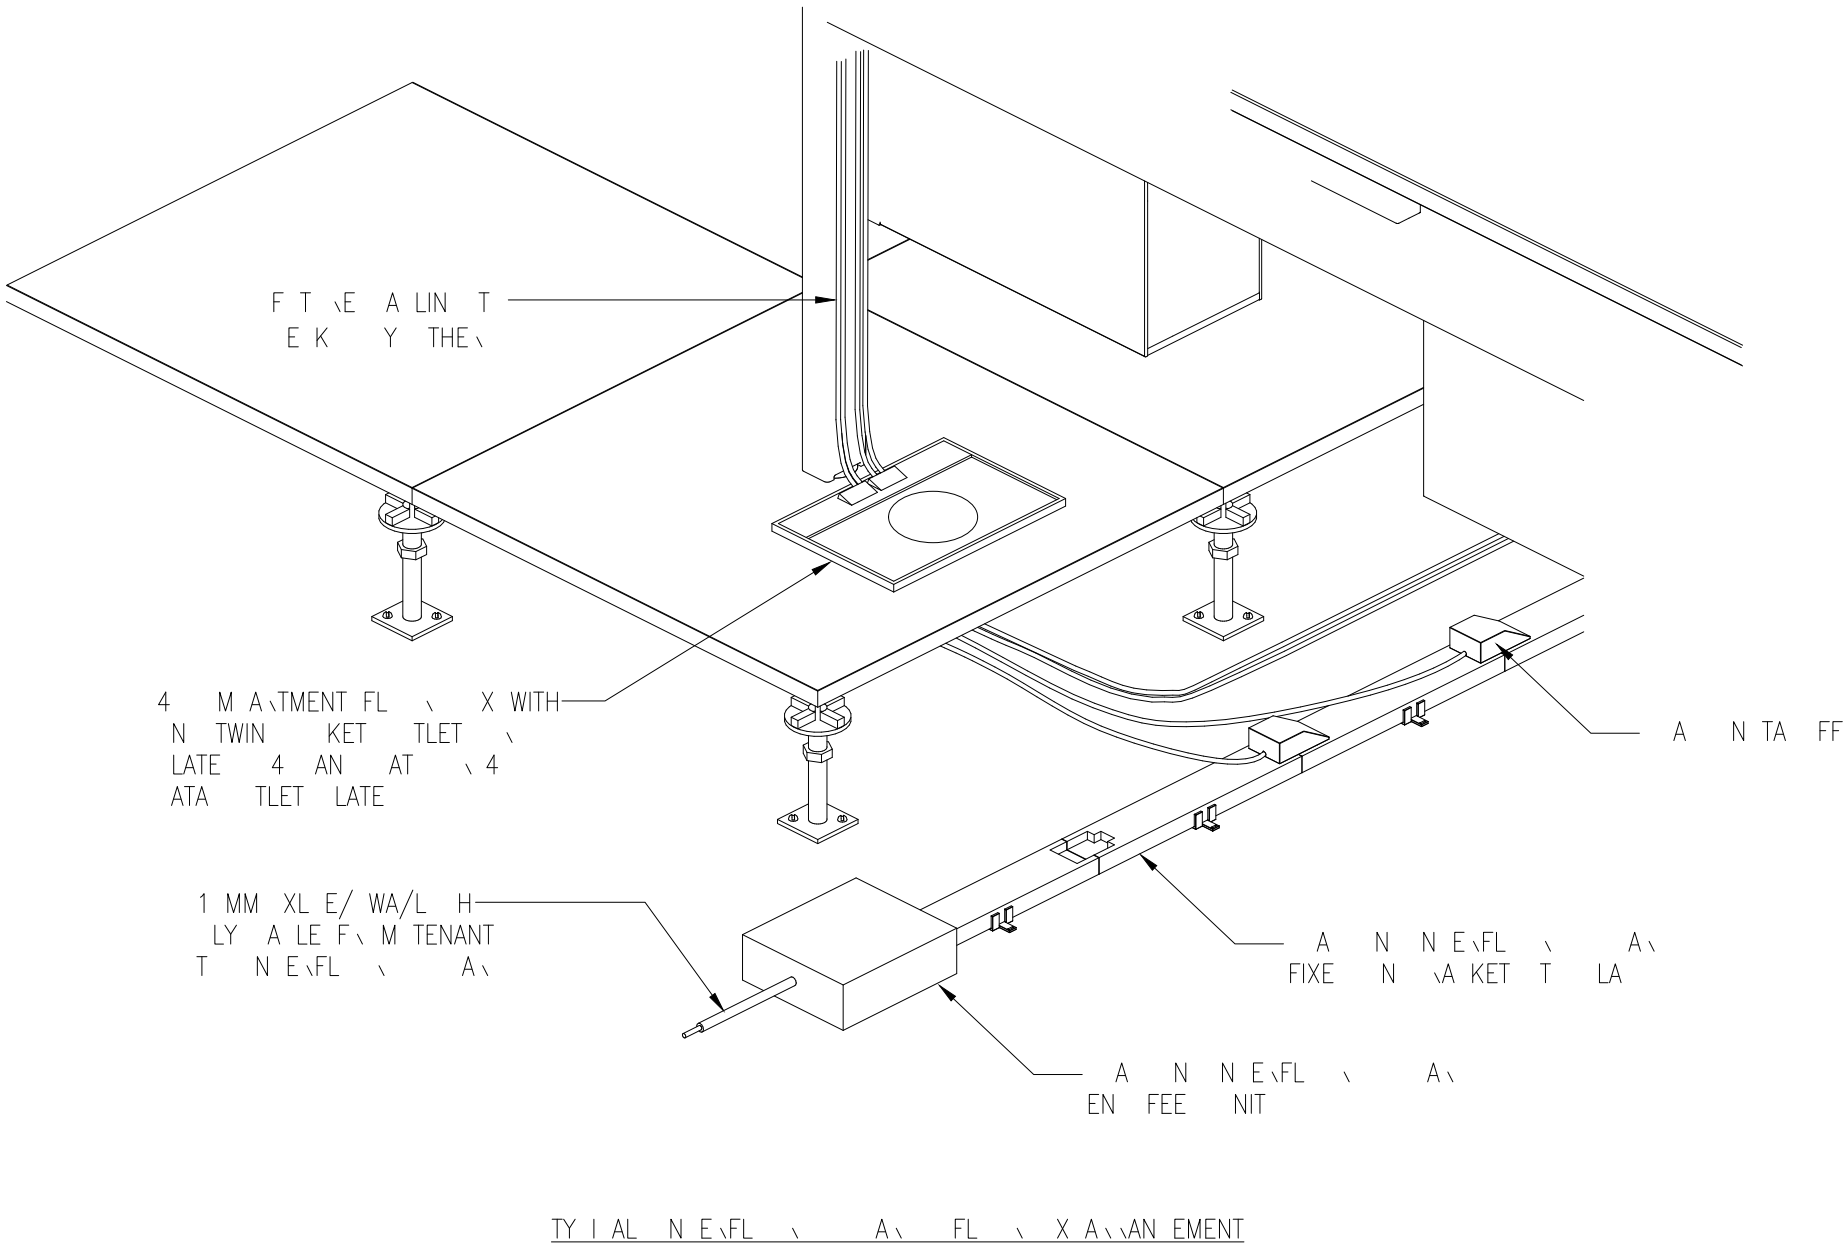

AMEN E T MENT		K
P R E L I M I N A R Y		
Drawing Status: PRELIMINARY		
Unit 6, North Staffs Business Park, Innovation Way, Staffs, ST4 9RF. Email: info@carterelectrical.co.uk Telephone: 01782 822250 www.carterelectrical.co.uk		
Project: PALL MALL MANCHESTER		
Title: FIRST FLOOR LOW LEVEL CONTAINMENT LAYOUT		
Architect: SHEPPARD ROBSON		
Consultant: RAMBOLL		
Designer: PG	Project: CB	Scale: PG
Date: 06.01.2023	Project Number: CES561	Scale: 1:100 A0
Drawing No: 6911-CES-XX-01-DR-E-6616		Rev: 1
Copyright: Carter Electrical Services Ltd. Contractors are to check all dimensions on site and refer any discrepancies to Carter Electrical immediately.		

1. I n t t t t t i i n A l r w n .
N r r i l l t y u l i t l i n r r r f
u f r t l i r w n l y t r . A l l
r r r t l l l t k f r f i r l
l i i i u l l k i t .

ENTAINMENT	
YM L	E d T I N
	LV TAY
	V I E ATA A KET
	H A E I T U T I N A
	ELE T A K I I A A
	ELE T A K F I A EN FEE

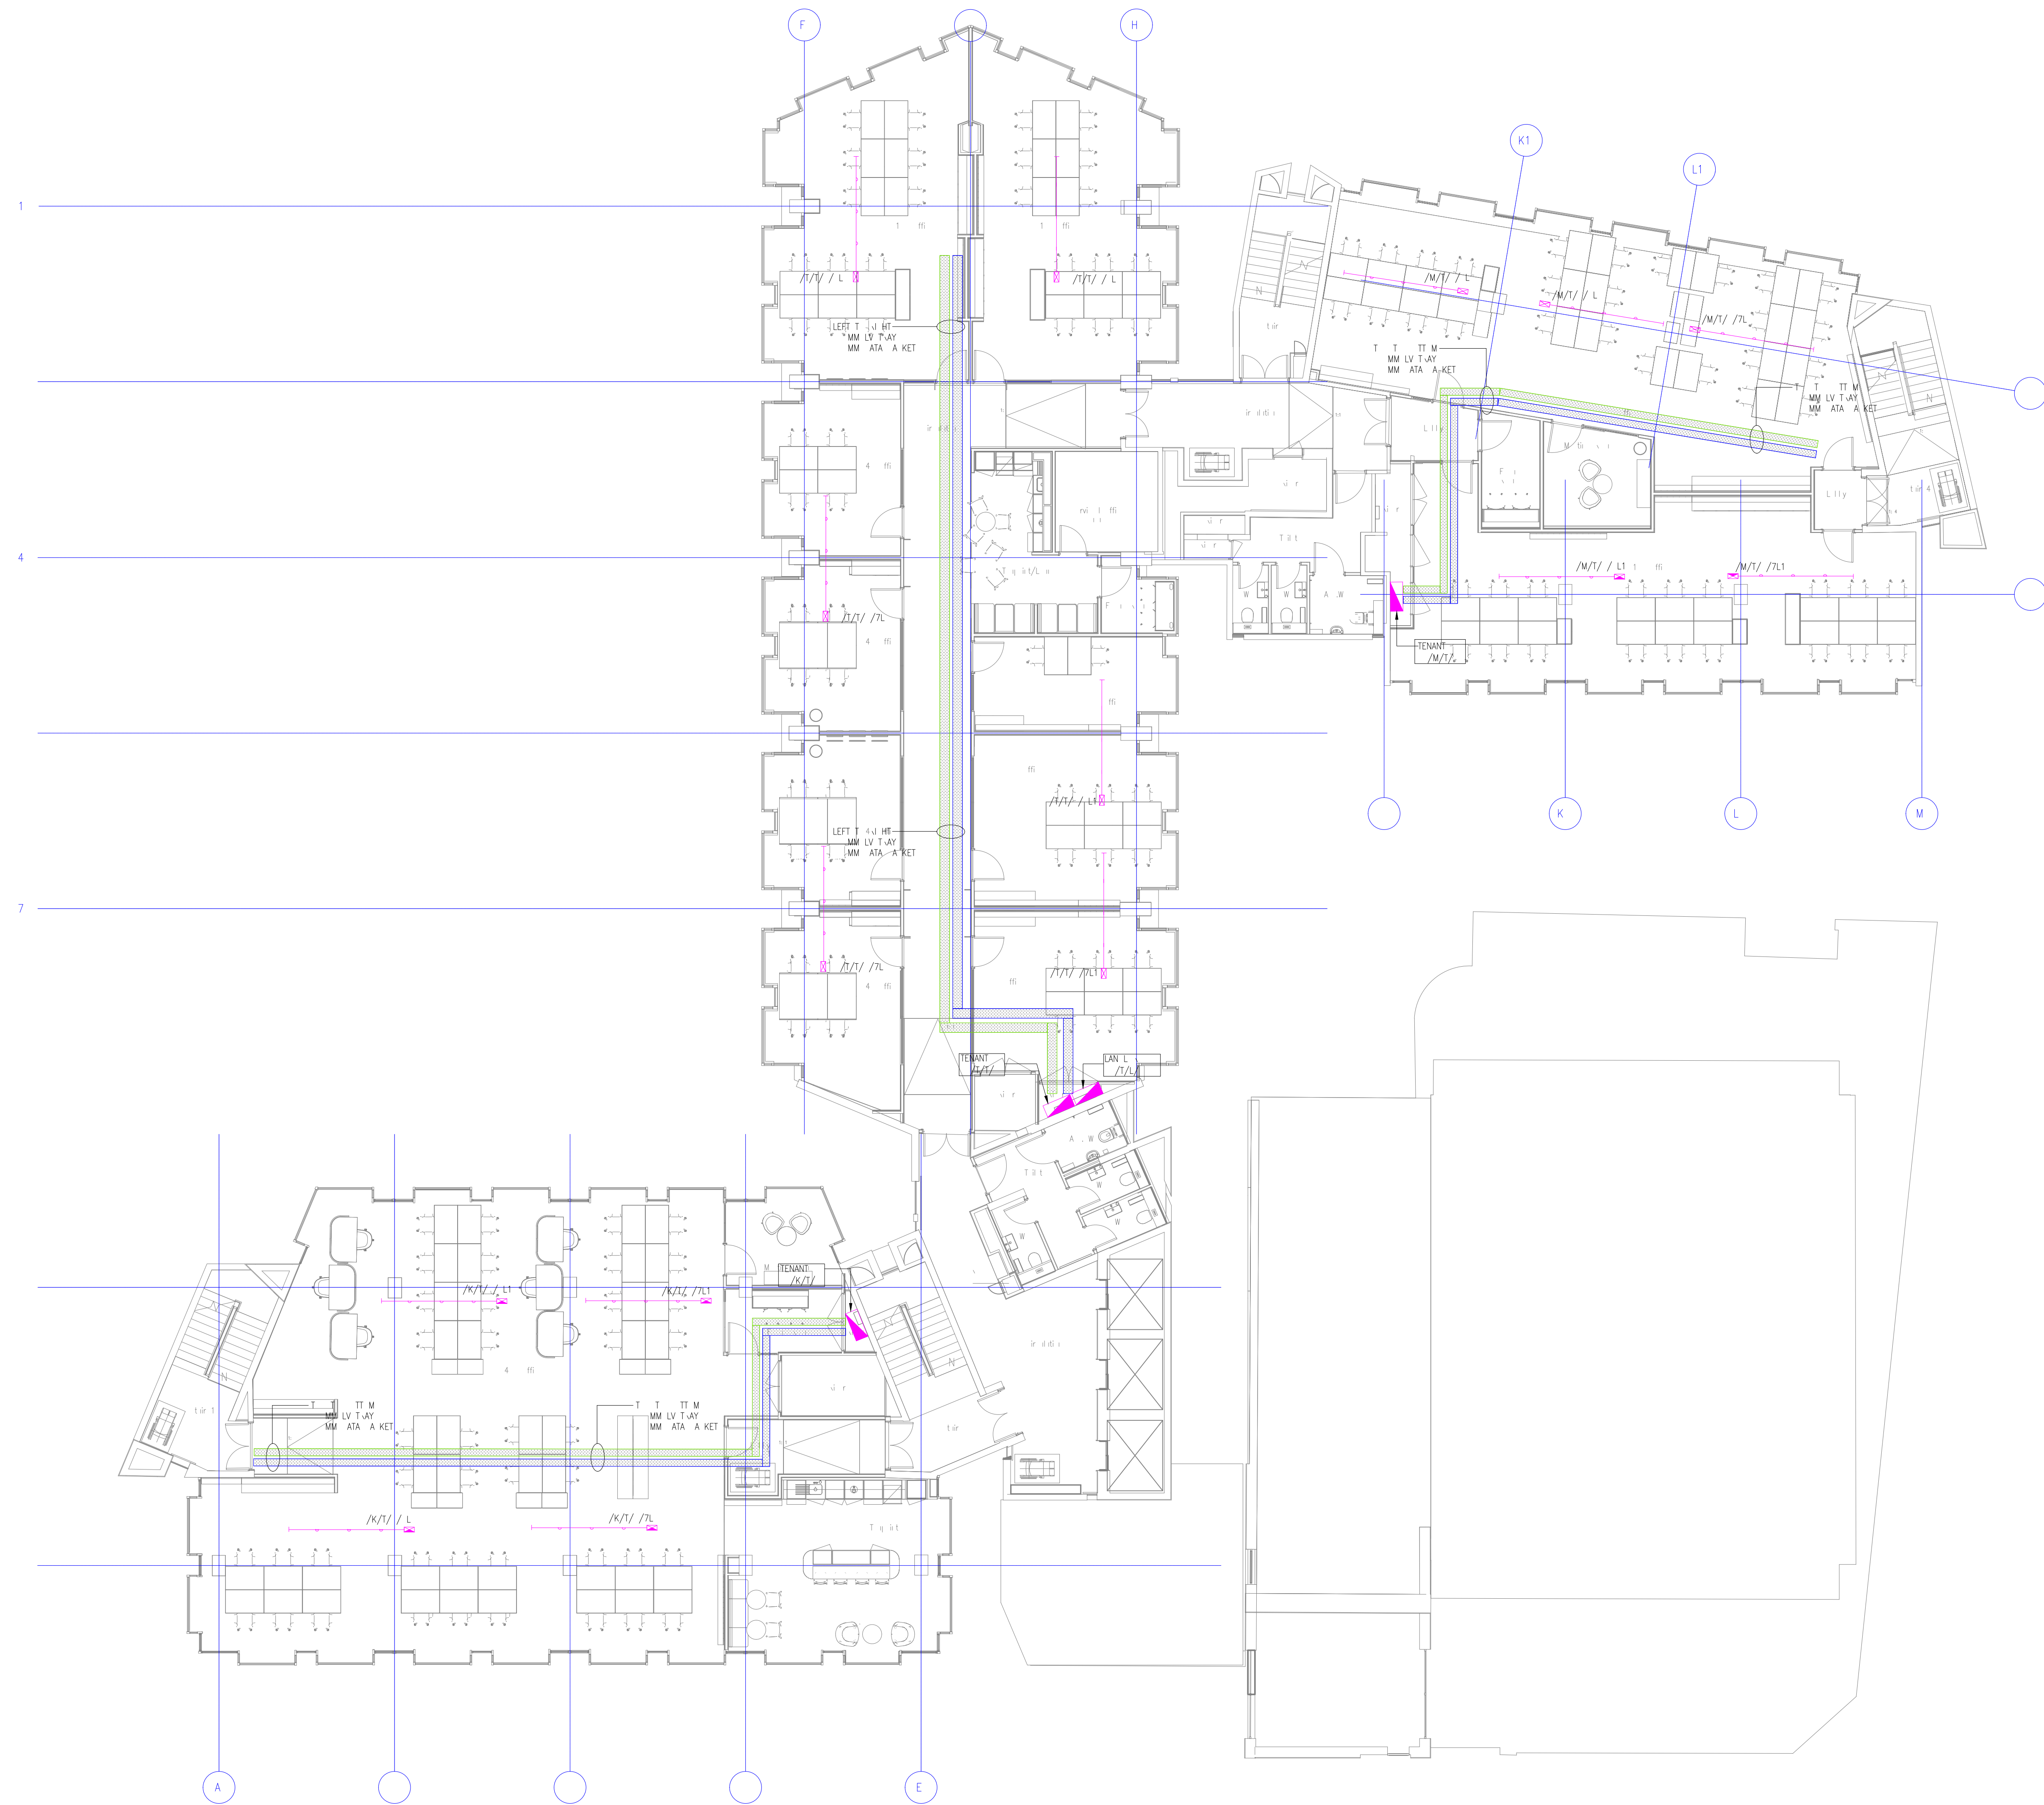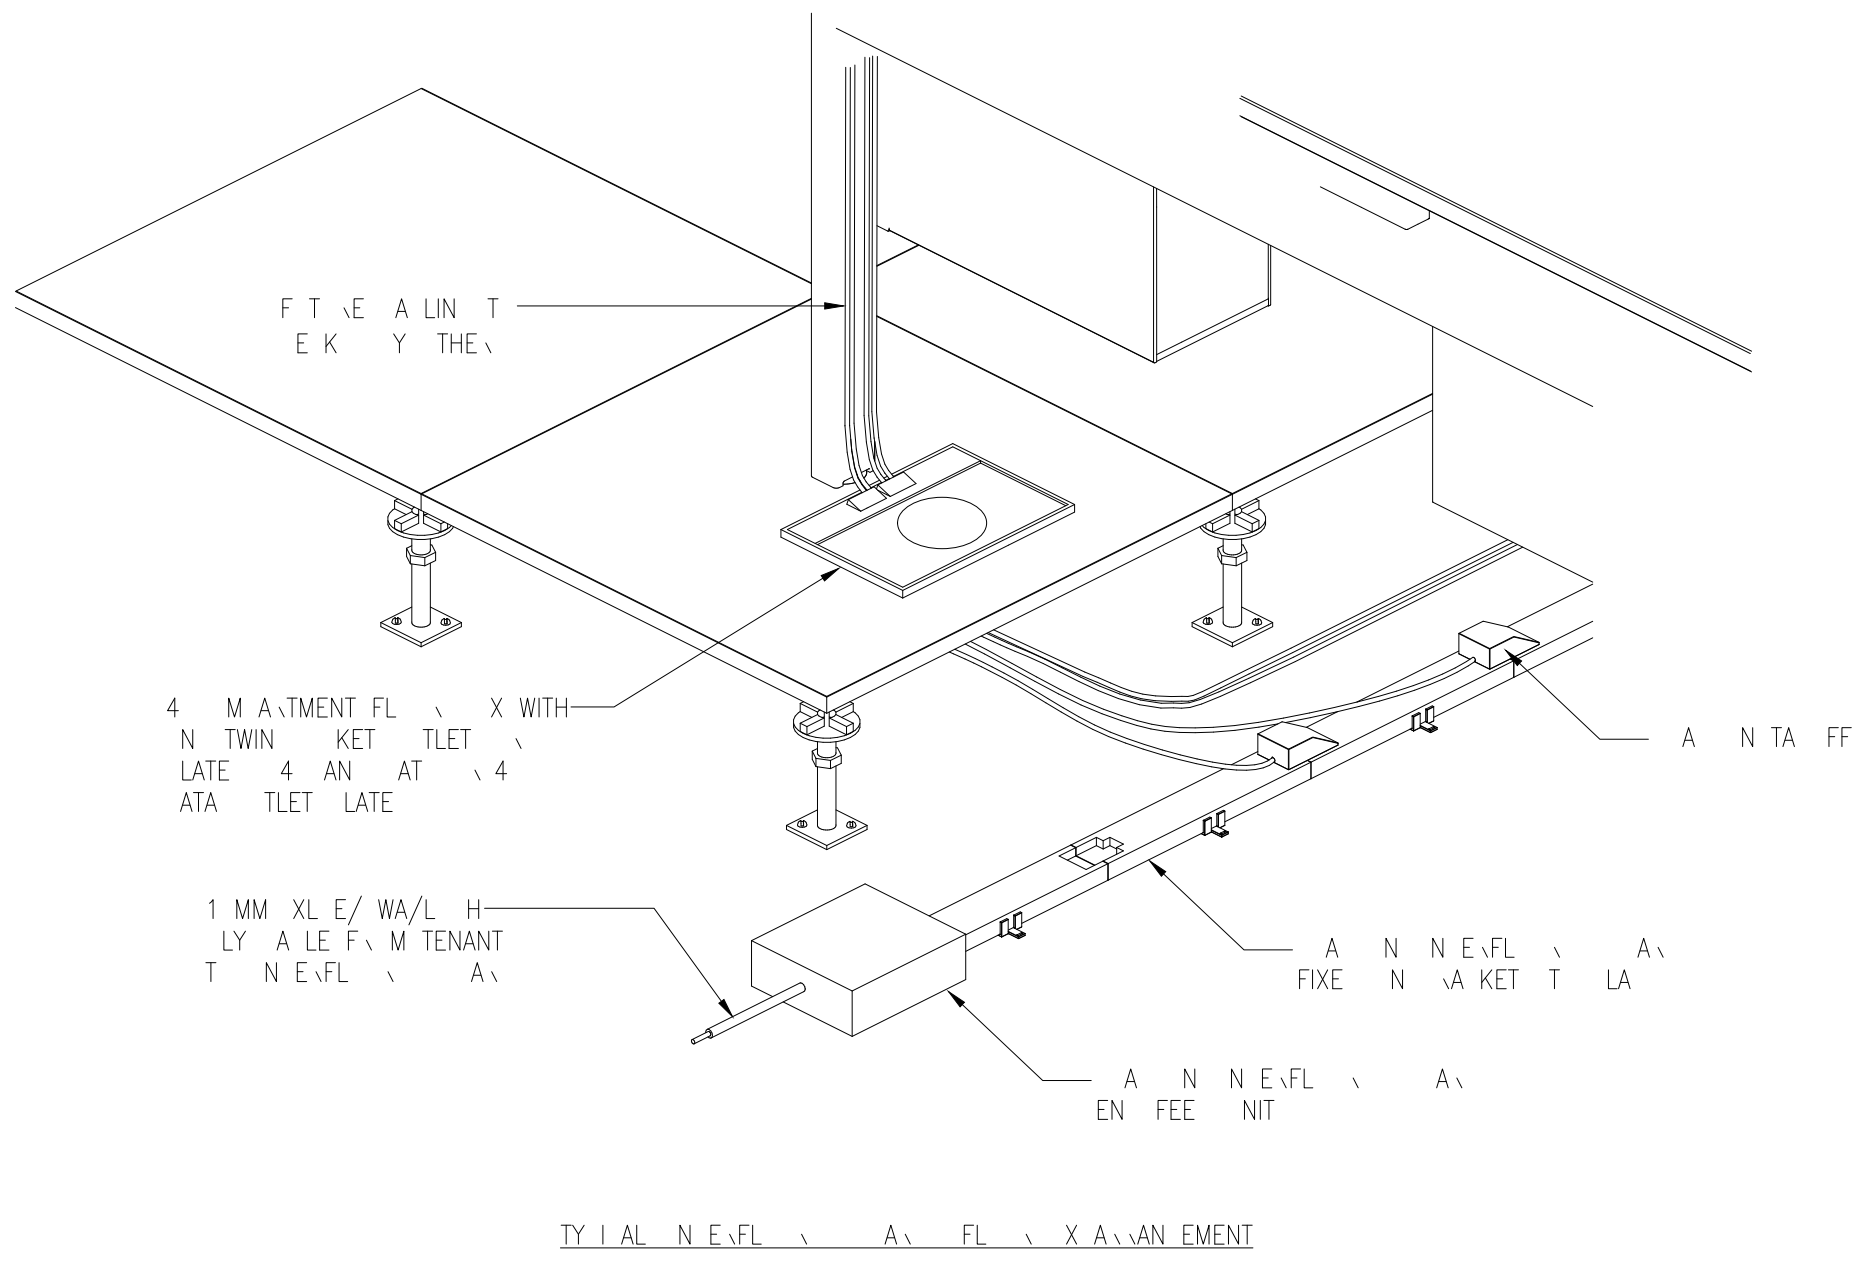

J A M E N E T		I M M E N T		K		L	
1	2	3	4	5	6	7	8
F	T	T	F				
Date: 01/04/2012				Page: 1 of 1			

BASED ON: 20102 Second Floor General Amendment. XREF CLEANED = P20
 Drawing Status: PRELIMINARY

Unit 6, North Staffa Business Park,
 Inverness Way, Staffa 31348F
 Email: info@centralsteel.co.uk
 Telephone: 01782 822250
www.centralsteel.co.uk

Project:
 PALL MALL
 MANCHESTER

The:
 SECOND FLOOR
 LOW LEVEL CONTAINMENT
 LAYOUT

SHEPPARD ROBSON

Architect: RAMBOLL

Designer: PG	Project: CB	AO: PG	Drawn: MD
Date: 06.01.2013	Project Number: CES561	Scale: 1:100	AO


Drawing No: 6911-CES-XX-02-DR-E-6617

Rev: 

Copyright: Carter Electrical Services Ltd
 Customers are to check all dimensions on site and refer any discrepancies to Carter Electrical immediately.

1. This drawing is a preliminary drawing and is not for construction. All dimensions are approximate and subject to change without notice.



CONTAINMENT	
SYMBOL	DESCRIPTION
	LV TAY
	VIE ATAKET
	HEAT DRAIN
	ELECTRICAL
	ELECTRICAL

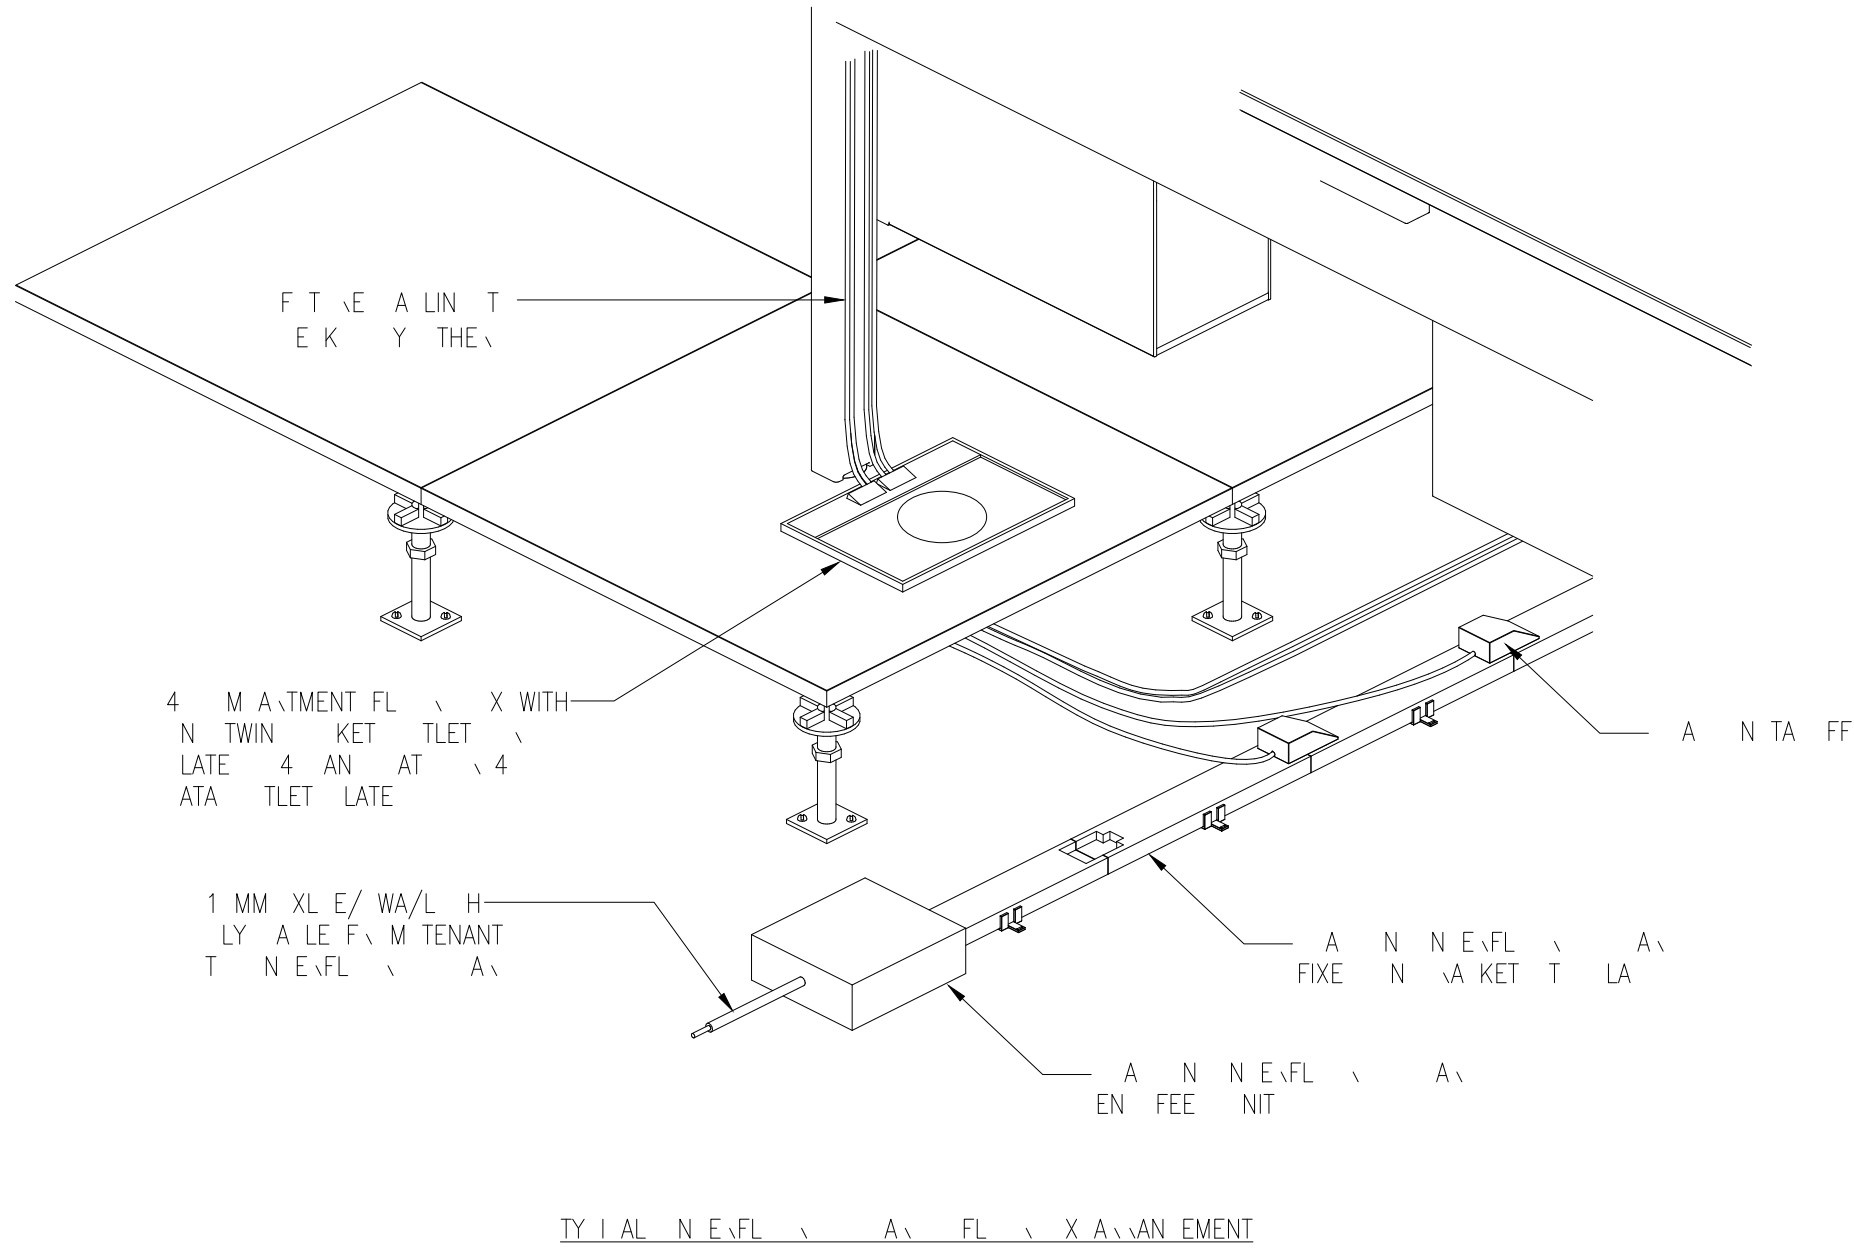

AMENITY		K	
PRELIMINARY		K	
Drawing Status: PRELIMINARY			
Unit 6, North Staffs Business Park, Innovation Way, Staffs, ST44 9F, Email: info@pallmallmanchester.co.uk, Telephone: 01782 822250, www.pallmallmanchester.co.uk			
Project: PALL MALL MANCHESTER			
Title: THIRD FLOOR LOW LEVEL CONTAINMENT LAYOUT			
Architect: SHEPPARD ROBSON			
Consultant: RAMBOLL			
Designer: PG	Project: CB	Scale: PG	Checked: MD
Date: 06.01.2023	Project Number: CES561	Scale: 1:100	AD
Drawing No: 6911-CES-XX-03-DR-E-6616			Rev: 001
Copyright: Carter Electrical Services Ltd. Contractors are to check all dimensions on site and refer any discrepancies to Carter Electrical immediately.			

1. l i t t l e t t l e t t i n A l r i n .
N e r i l i t y u l i t l i n r r f
u f r t l i r w i l y t r . A l l
i r i t l l l t i k i f r f i r l
l i i u l l k l i t .

NTAINMENT	
YM L	E NTAIN
	LV TAY
	V IE ATA A KET
	MA E ITD TTN A
	ELE T AK I A A
	ELE T AK F I A EN FEE

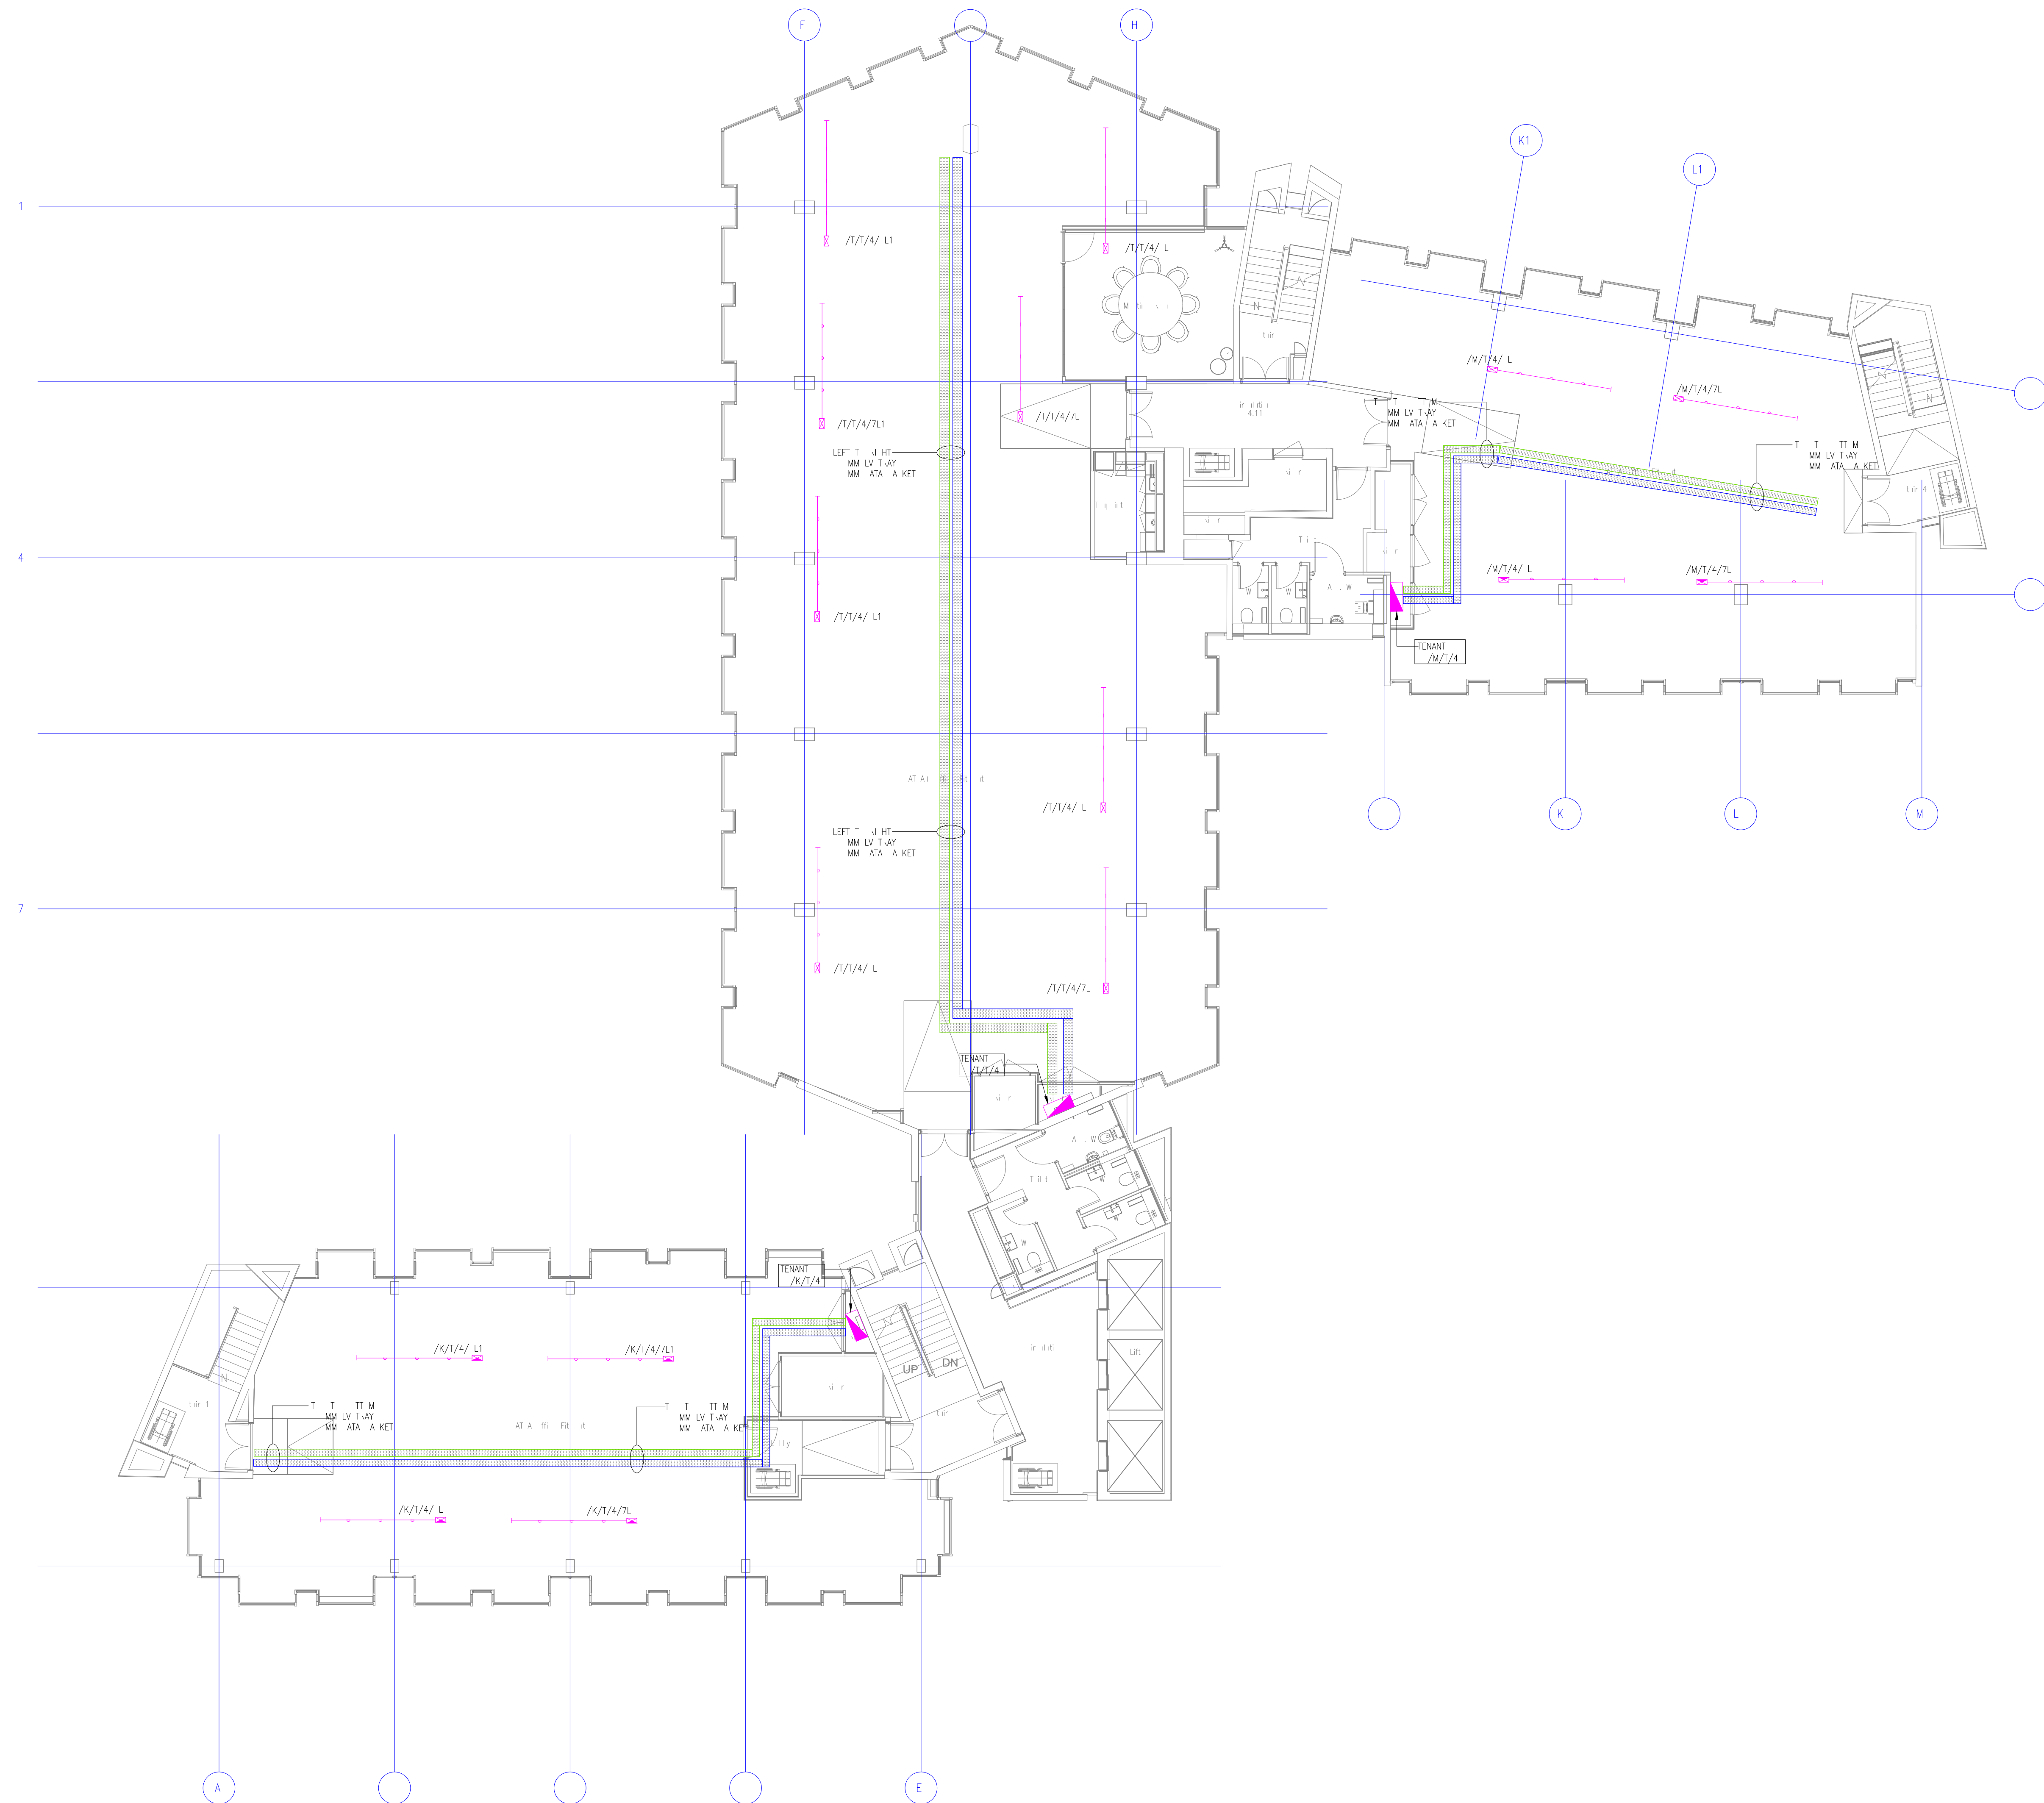
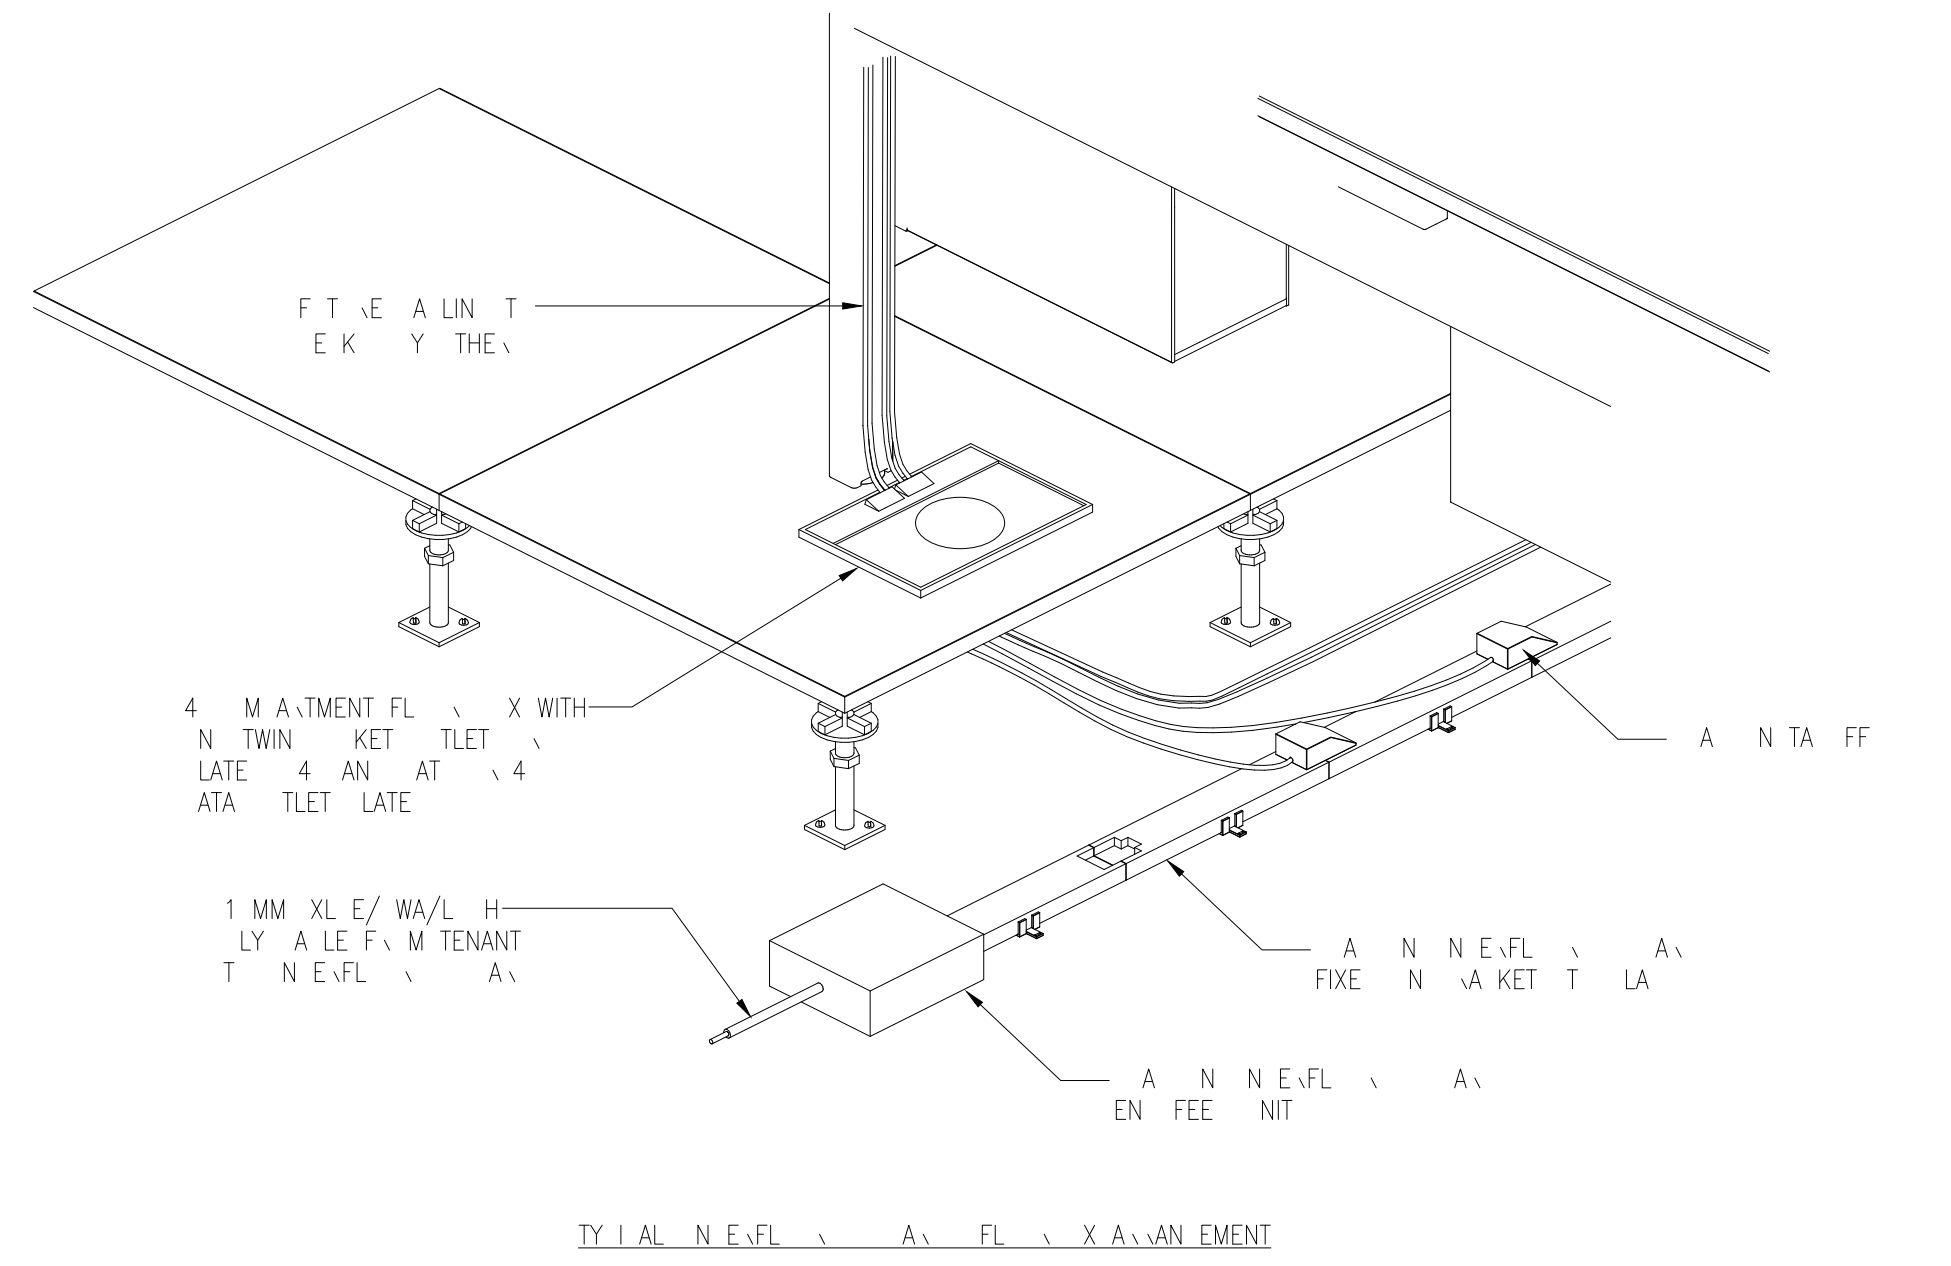


AMEN E T		MMENT		K			
1	T	T	E				
Drawing Date: 04-11-2014				Date: 04-11-2014			
BASED ON: 20104-Fourth Floor General Arrangement WEST CLEANED - P19							
Drawing Status: PRELIMINARY							
							
Unit 4, South Staffs Business Park, Innovation Way, Staffs ST16 6PH. Email: info@newmedicals.co.uk Telephone: 01782 822250 www.newmedicals.co.uk							
							
Project: MALL PALM HALL MANCHESTER Site: FOURTH FLOOR LOW LEVEL CONTAINMENT LAYOUT							
SHEPPARD ROBSON							
Consultant: RAMBOLL							
Designer: PGC		Project: CES-XX		MD: PGC		Checked: MD	
Date: 06.01.2023				Project Code: CES561		Scale: 1:100 A0	
Drawing No: 6911-CES-XX-04-DR-E-6619						Yes: 	
Copyright: Carter Electrical Services Ltd Contractors are to check all dimensions on site and refer any discrepancies to Carter Electrical Services Limited							

CONTAINMENT

1. This drawing is a preliminary drawing and is not for construction. All dimensions are approximate and subject to change without notice.



CONTAINMENT	
YM L	E V T I N
LV TAY	LV TAY
V I E A K E T	V I E A K E T
H A E I T I N A	H A E I T I N A
E L E T A A	E L E T A A
E L E T A F A E E	E L E T A F A E E

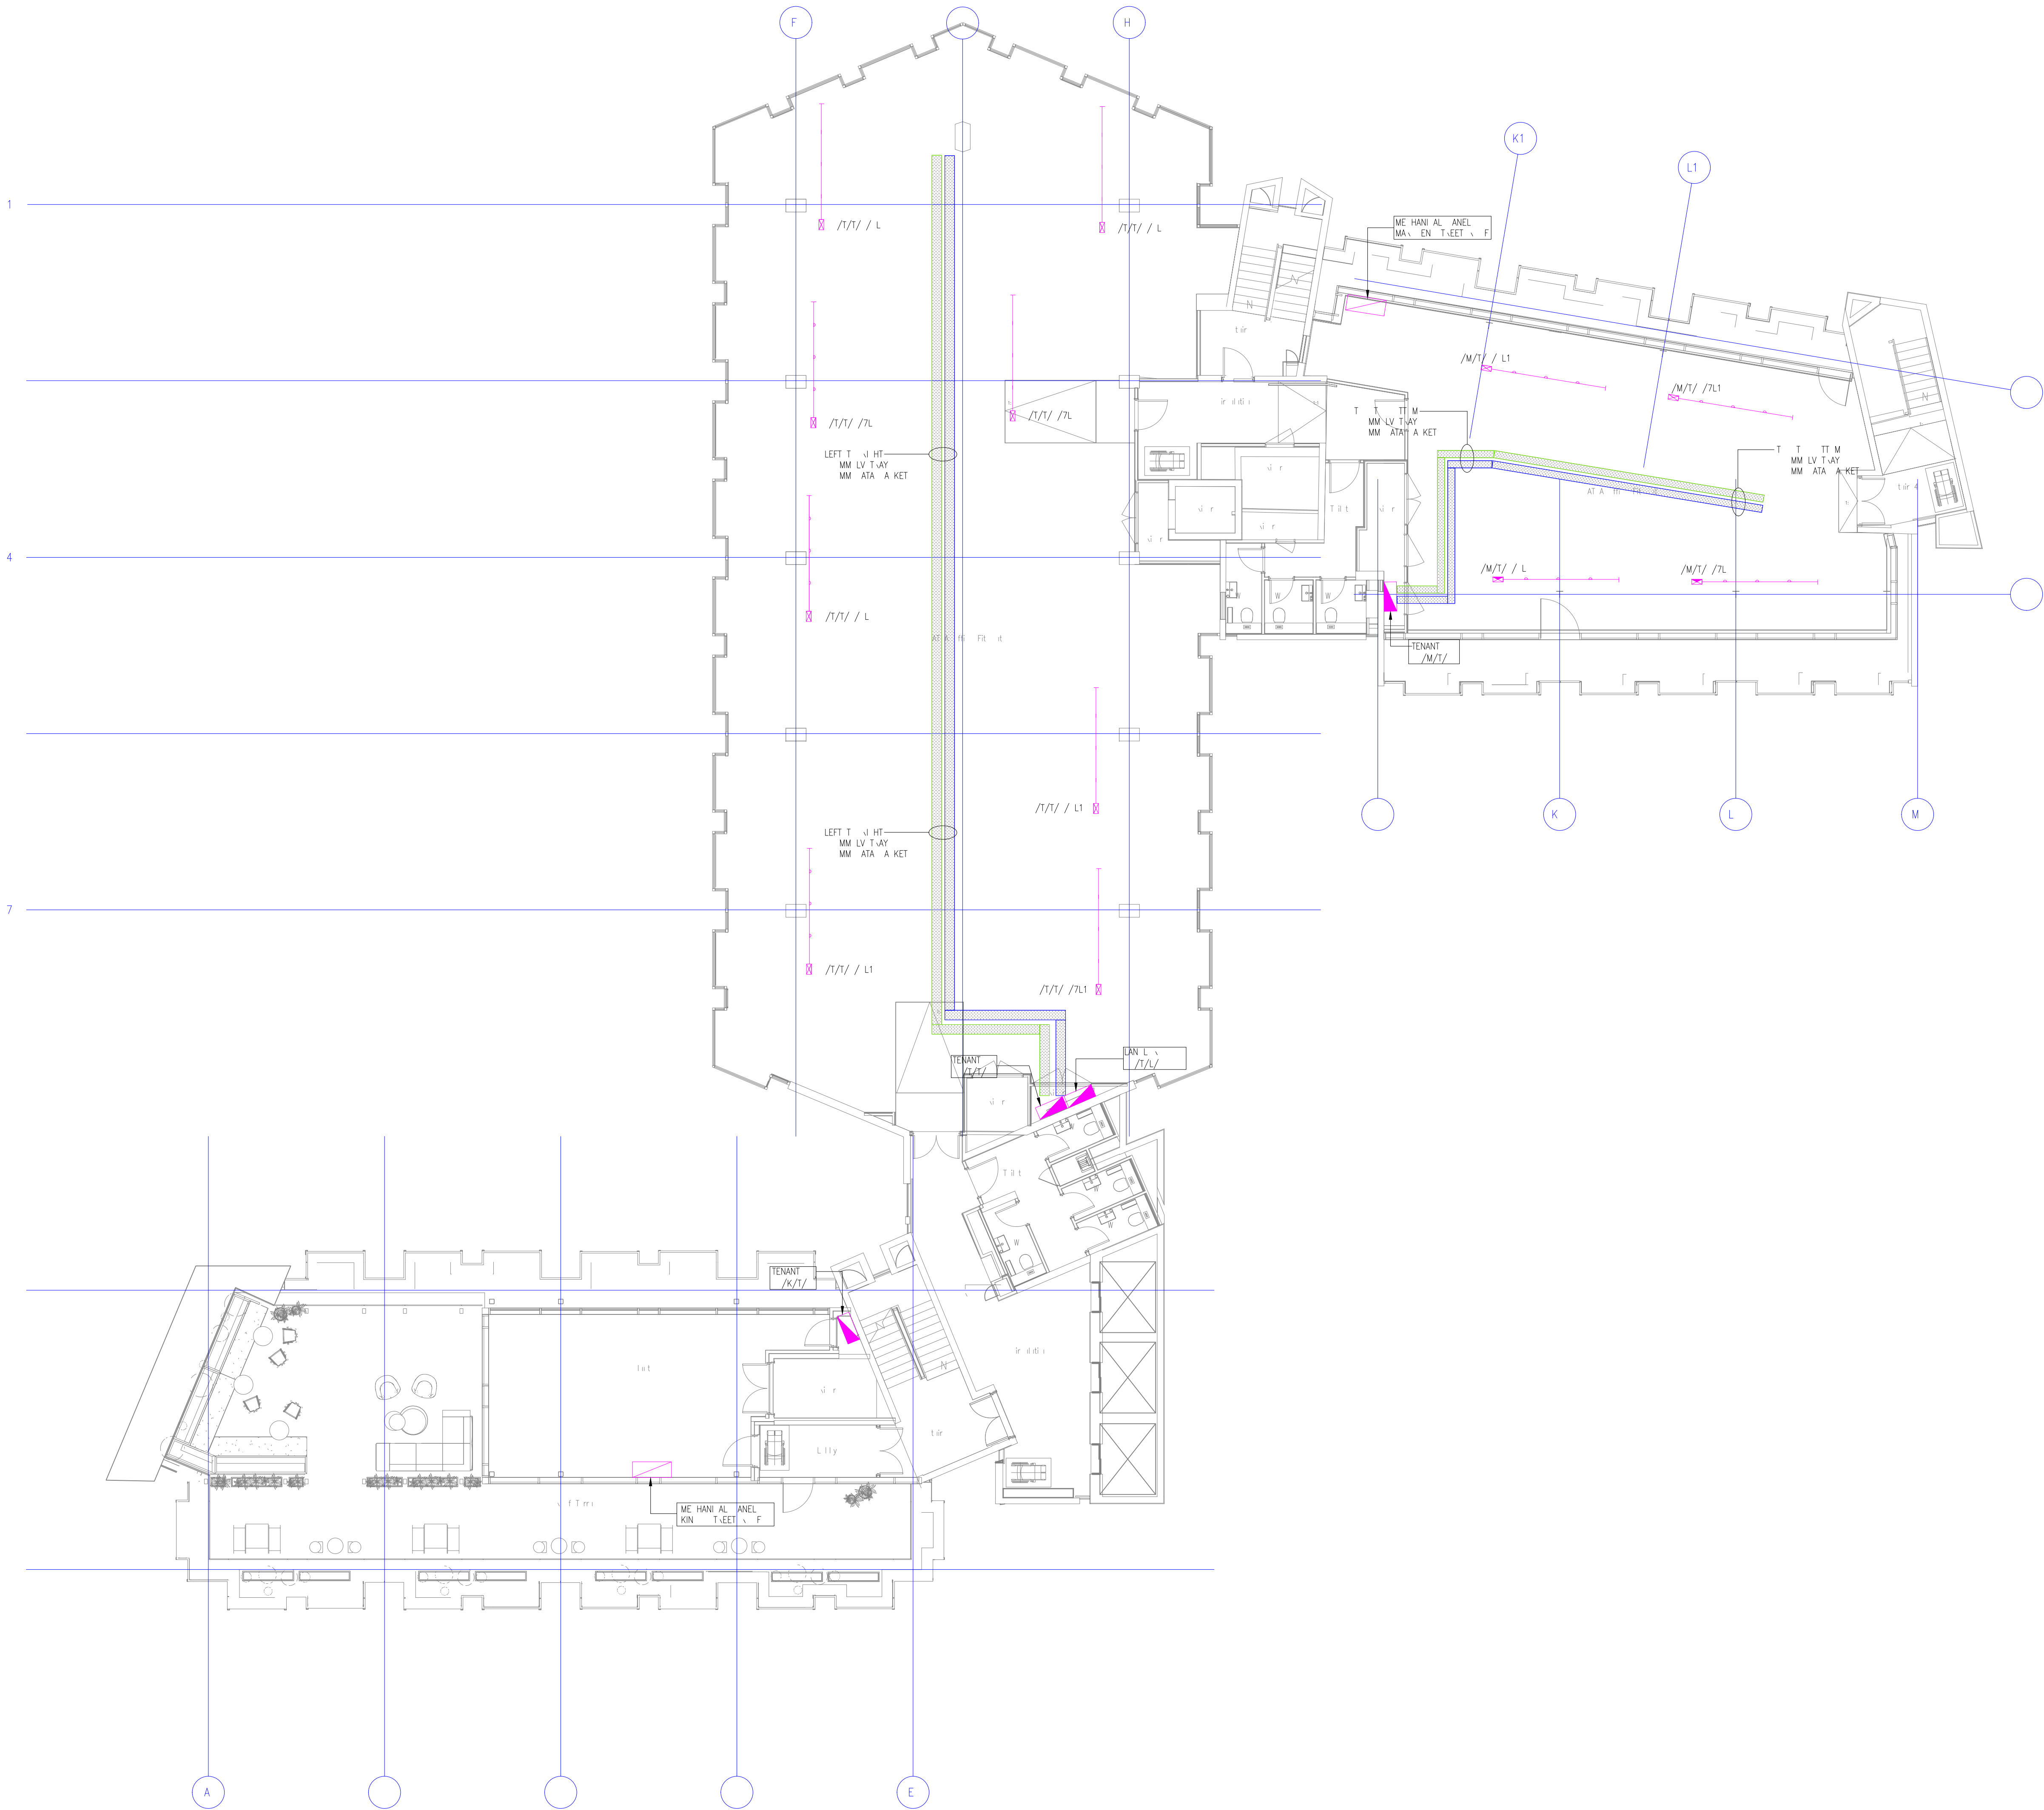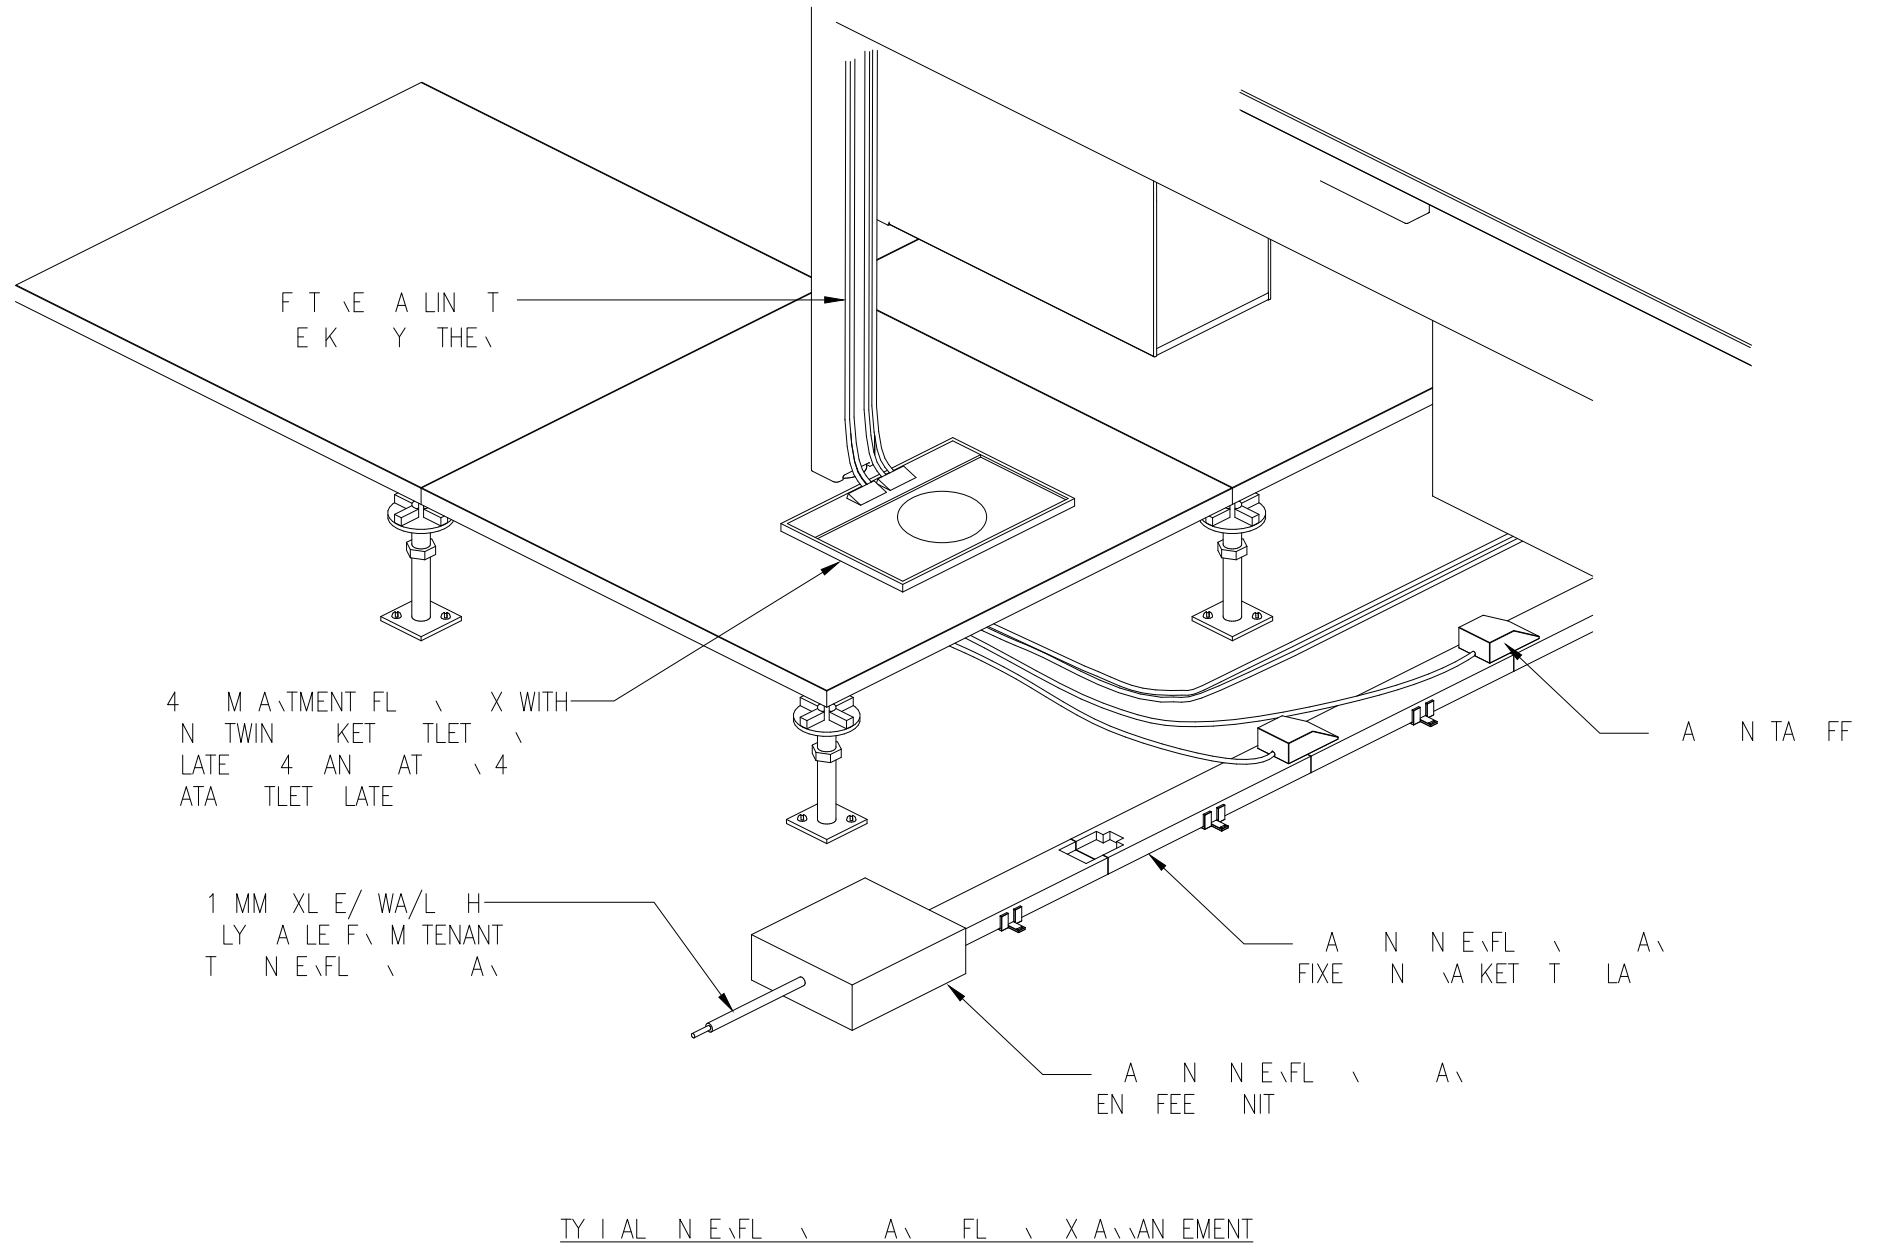

AMEN E T MENT		K	
V I T I E			
Drawing Status:		PRELIMINARY	
Project:		PALL MALL MANCHESTER	
Architect:		SHEPPARD ROBSON	
Consultant:		RAMBOLL	
Designer: PG	Project: CB	Scale: PG	Checked: MD
Date: 06.01.2023	Project Number: CES561	Scale: 1:100	Rev: A0
Drawing No: 6911-CES-XX-05-DR-E-6620		Rev: A0	
Copyright: Carter Electrical Services Ltd Contractors are to check all dimensions on site and refer any discrepancies to Carter Electrical immediately			

1. I want to tell you a story.
 . Responsibility is a job for
 all of us. It is a job for all of us.
 It is a job for all of us. It is a
 job for all of us. It is a job for
 all of us. It is a job for all of us.

STAINMENT	
YM L	E A T I N
	LV TAY
	V I E A T A K E T
	H R E I T A T I N A
	E L E T A K E I A A
	E L E T A K E F I A E N F E E

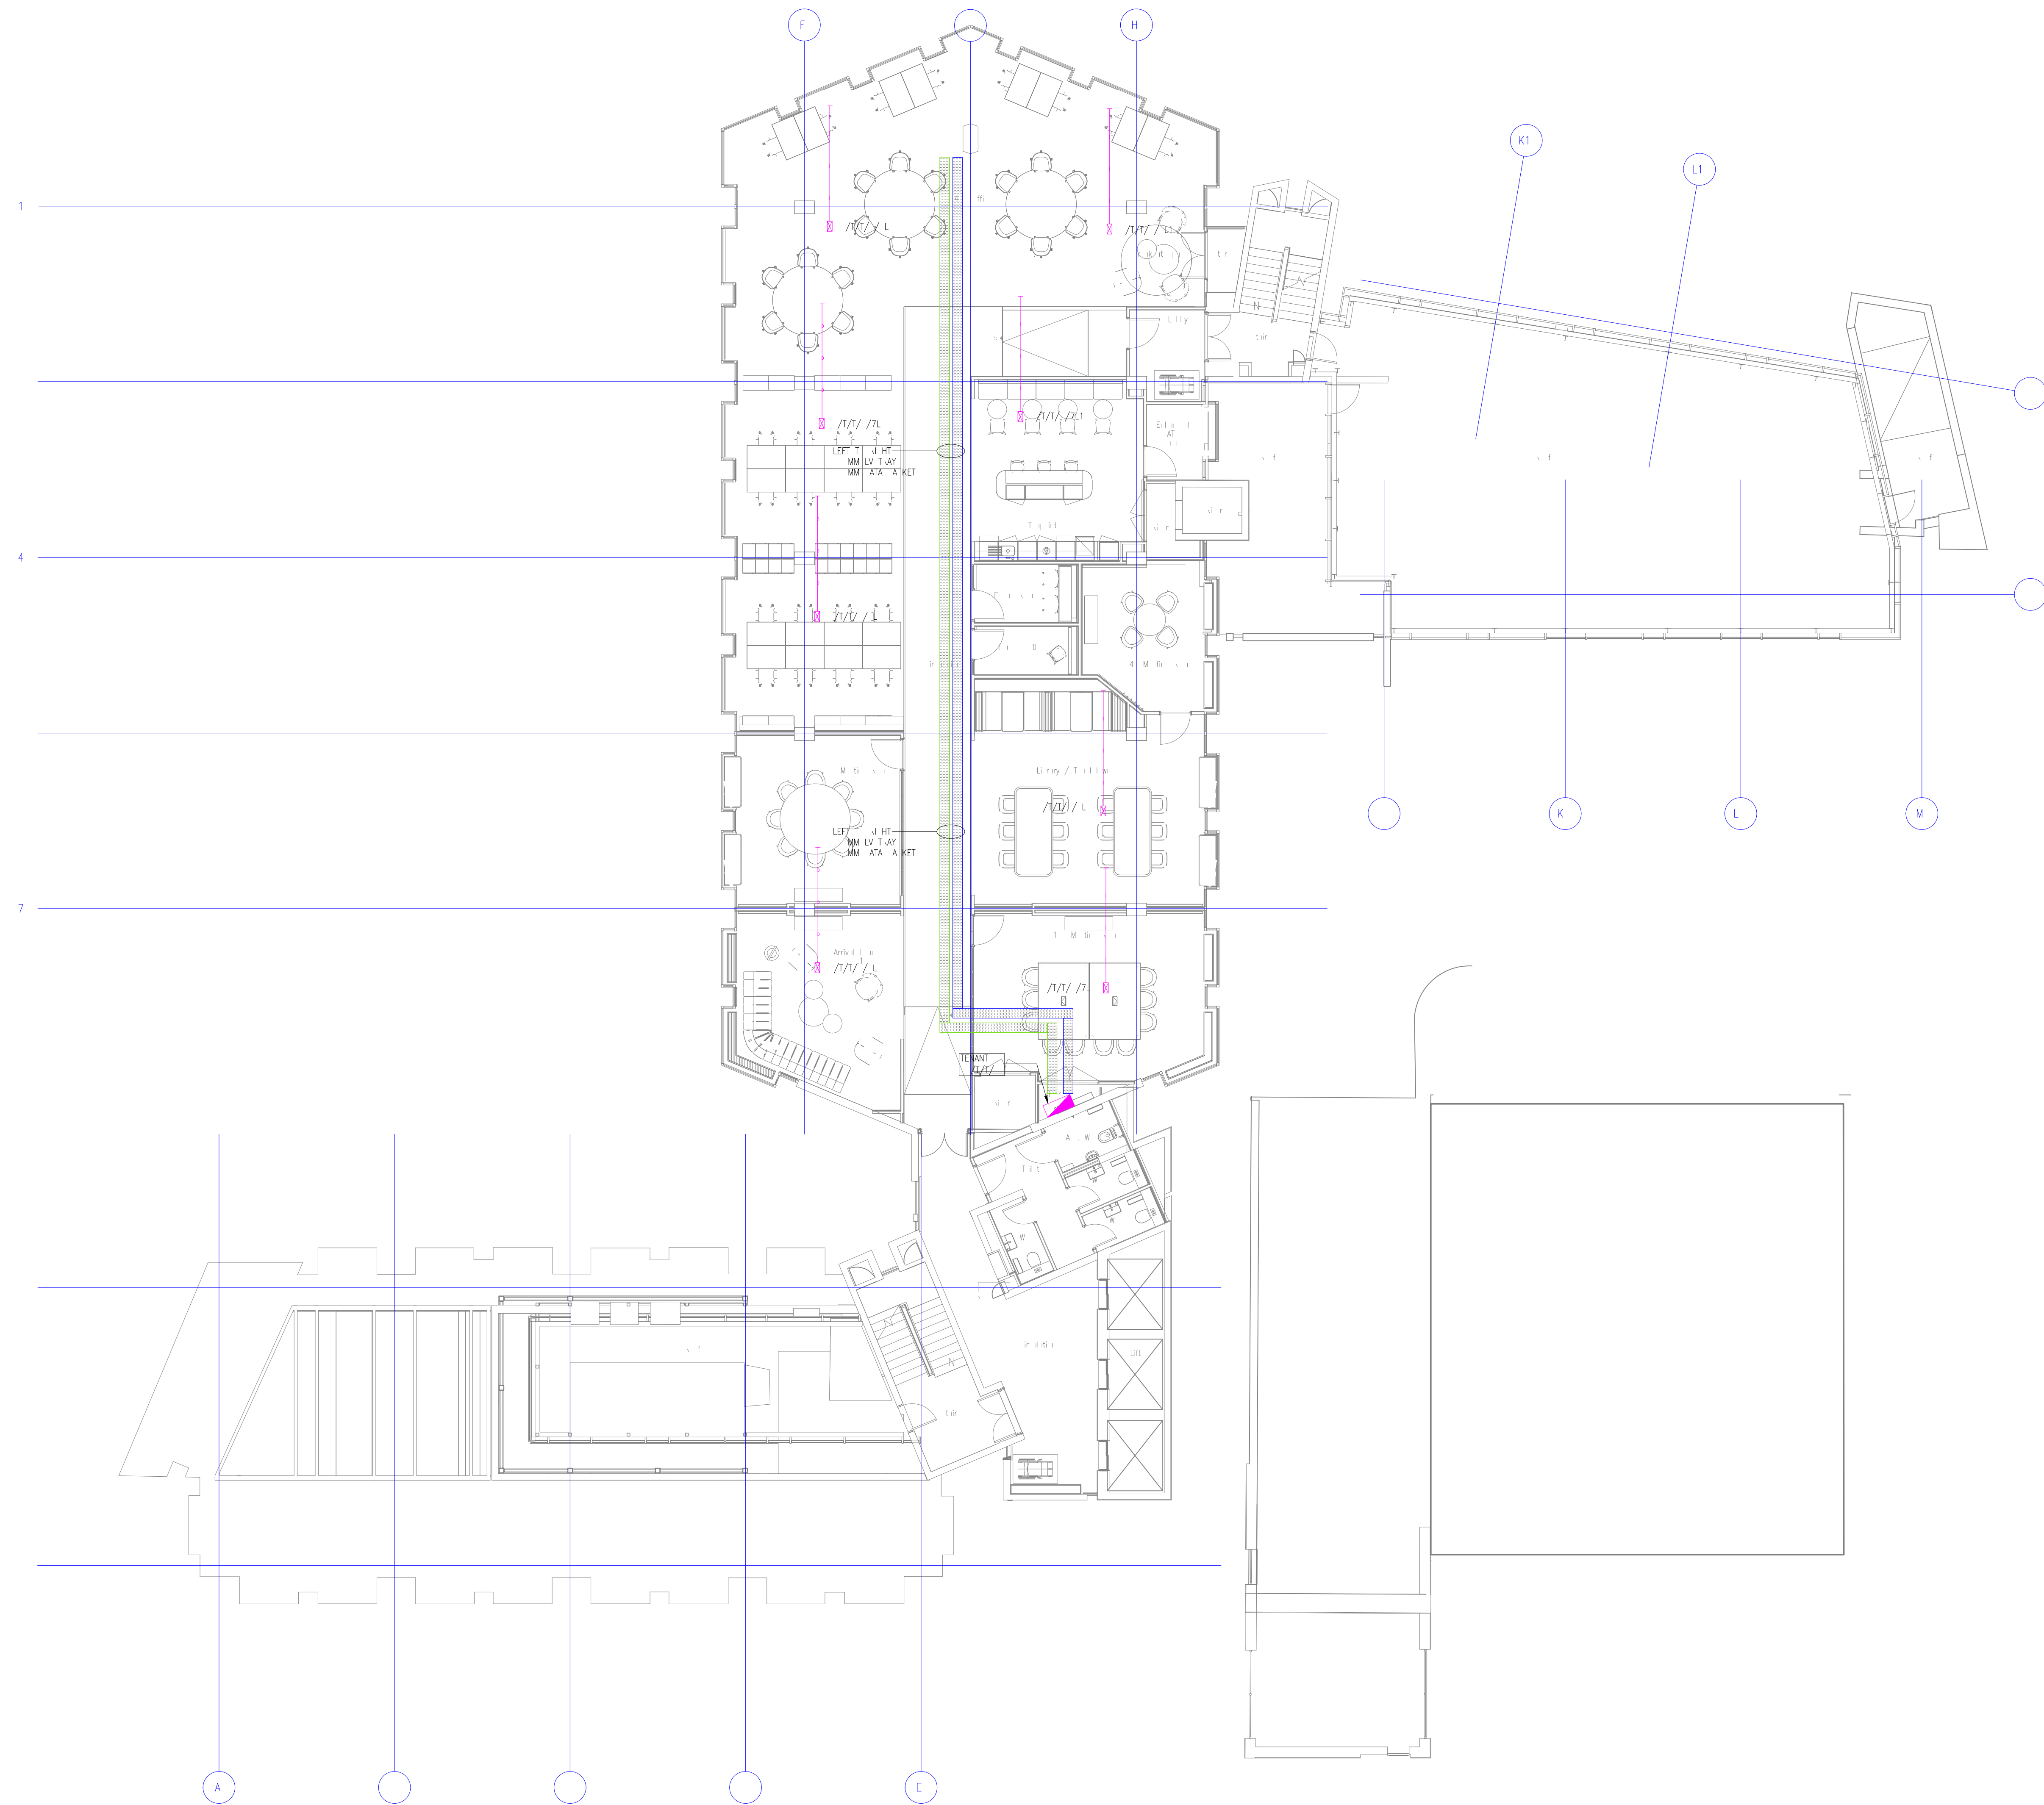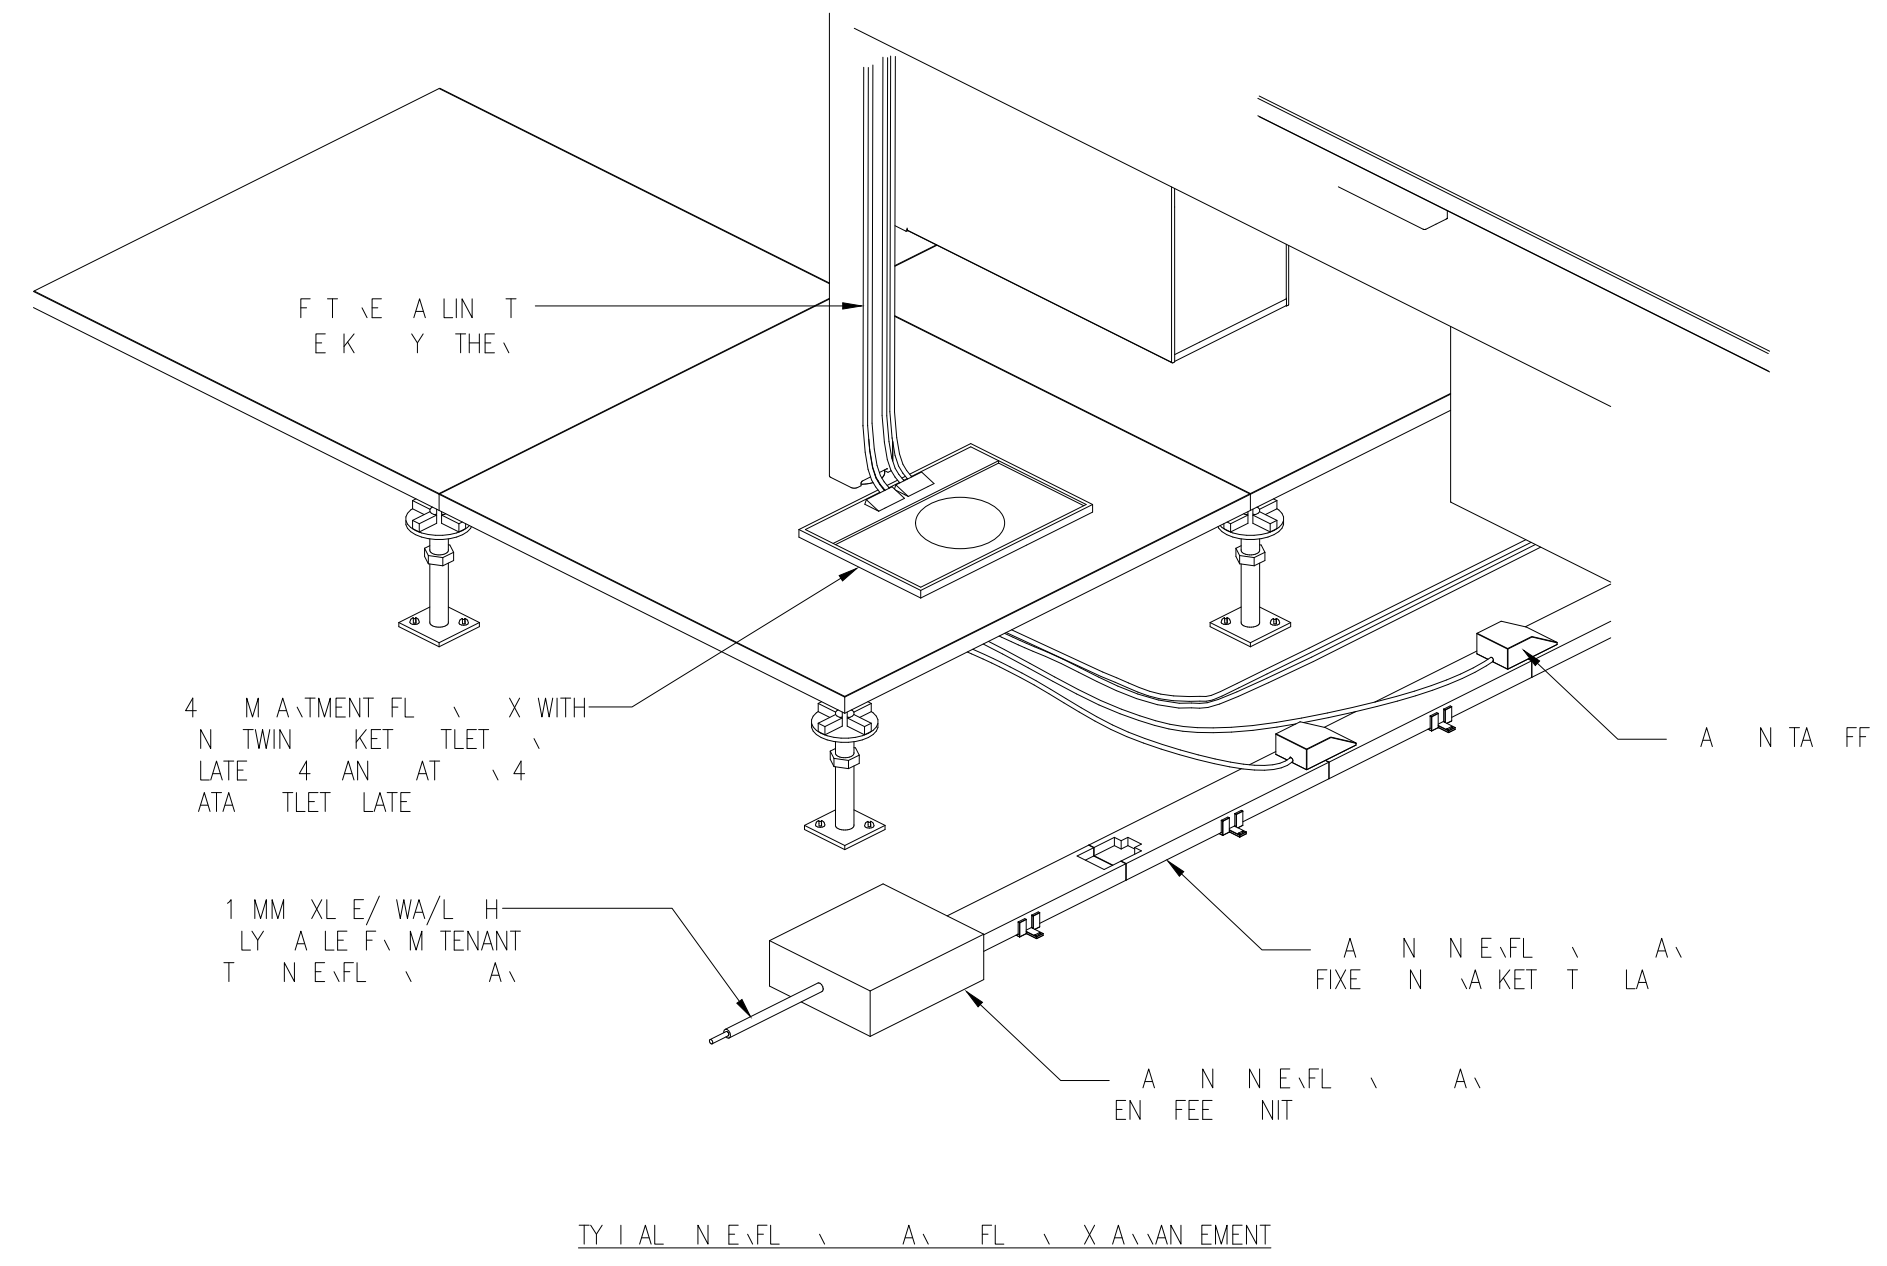

AMEN E T VMENT		K			
1	PL T I E				
4		4		10	
4		4		10	

BASED ON: 20106 Sixth Floor General Arrangement XREF CLEANED - P19

Drawing Status:

PRELIMINARY

UNIT 4, North Staffs Business Park,
Innovation Way, South 57548
Email: info@corinerelectrical.co.uk
Telephone: 01782 822250
www.corinerelectrical.co.uk

Project

PALL MALL MANCHESTER

Title

SIXTH FLOOR LOW LEVEL CONTAINMENT LAYOUT

SHEPPARD ROBSON

Consultant

RAMBOLL

Designer: PC

Project Manager: CB

Scale: 1:100

Drawn: 06.01.2023

Checked: MD



Scale: 1:100

Proj. No: 6911-CES-XX-06-DR-E-6621

Copyright: Carter Electrical Services Ltd
Consenters are to check all dimensions on site and refer any discrepancies to Carter Electrical immediately.

1. I want that this is a law.
 . Necessarily and yet in error
 in front of law by the. All
 in front of all taken for fear
 in front of all of it.

ENTAINMENT	
YM L	E A T I N
	LV TAY
	V I E A T A K E T
	H A E I T A B N A
	E L E T A K I I A A
	E L E T A K I F I A E N F E E

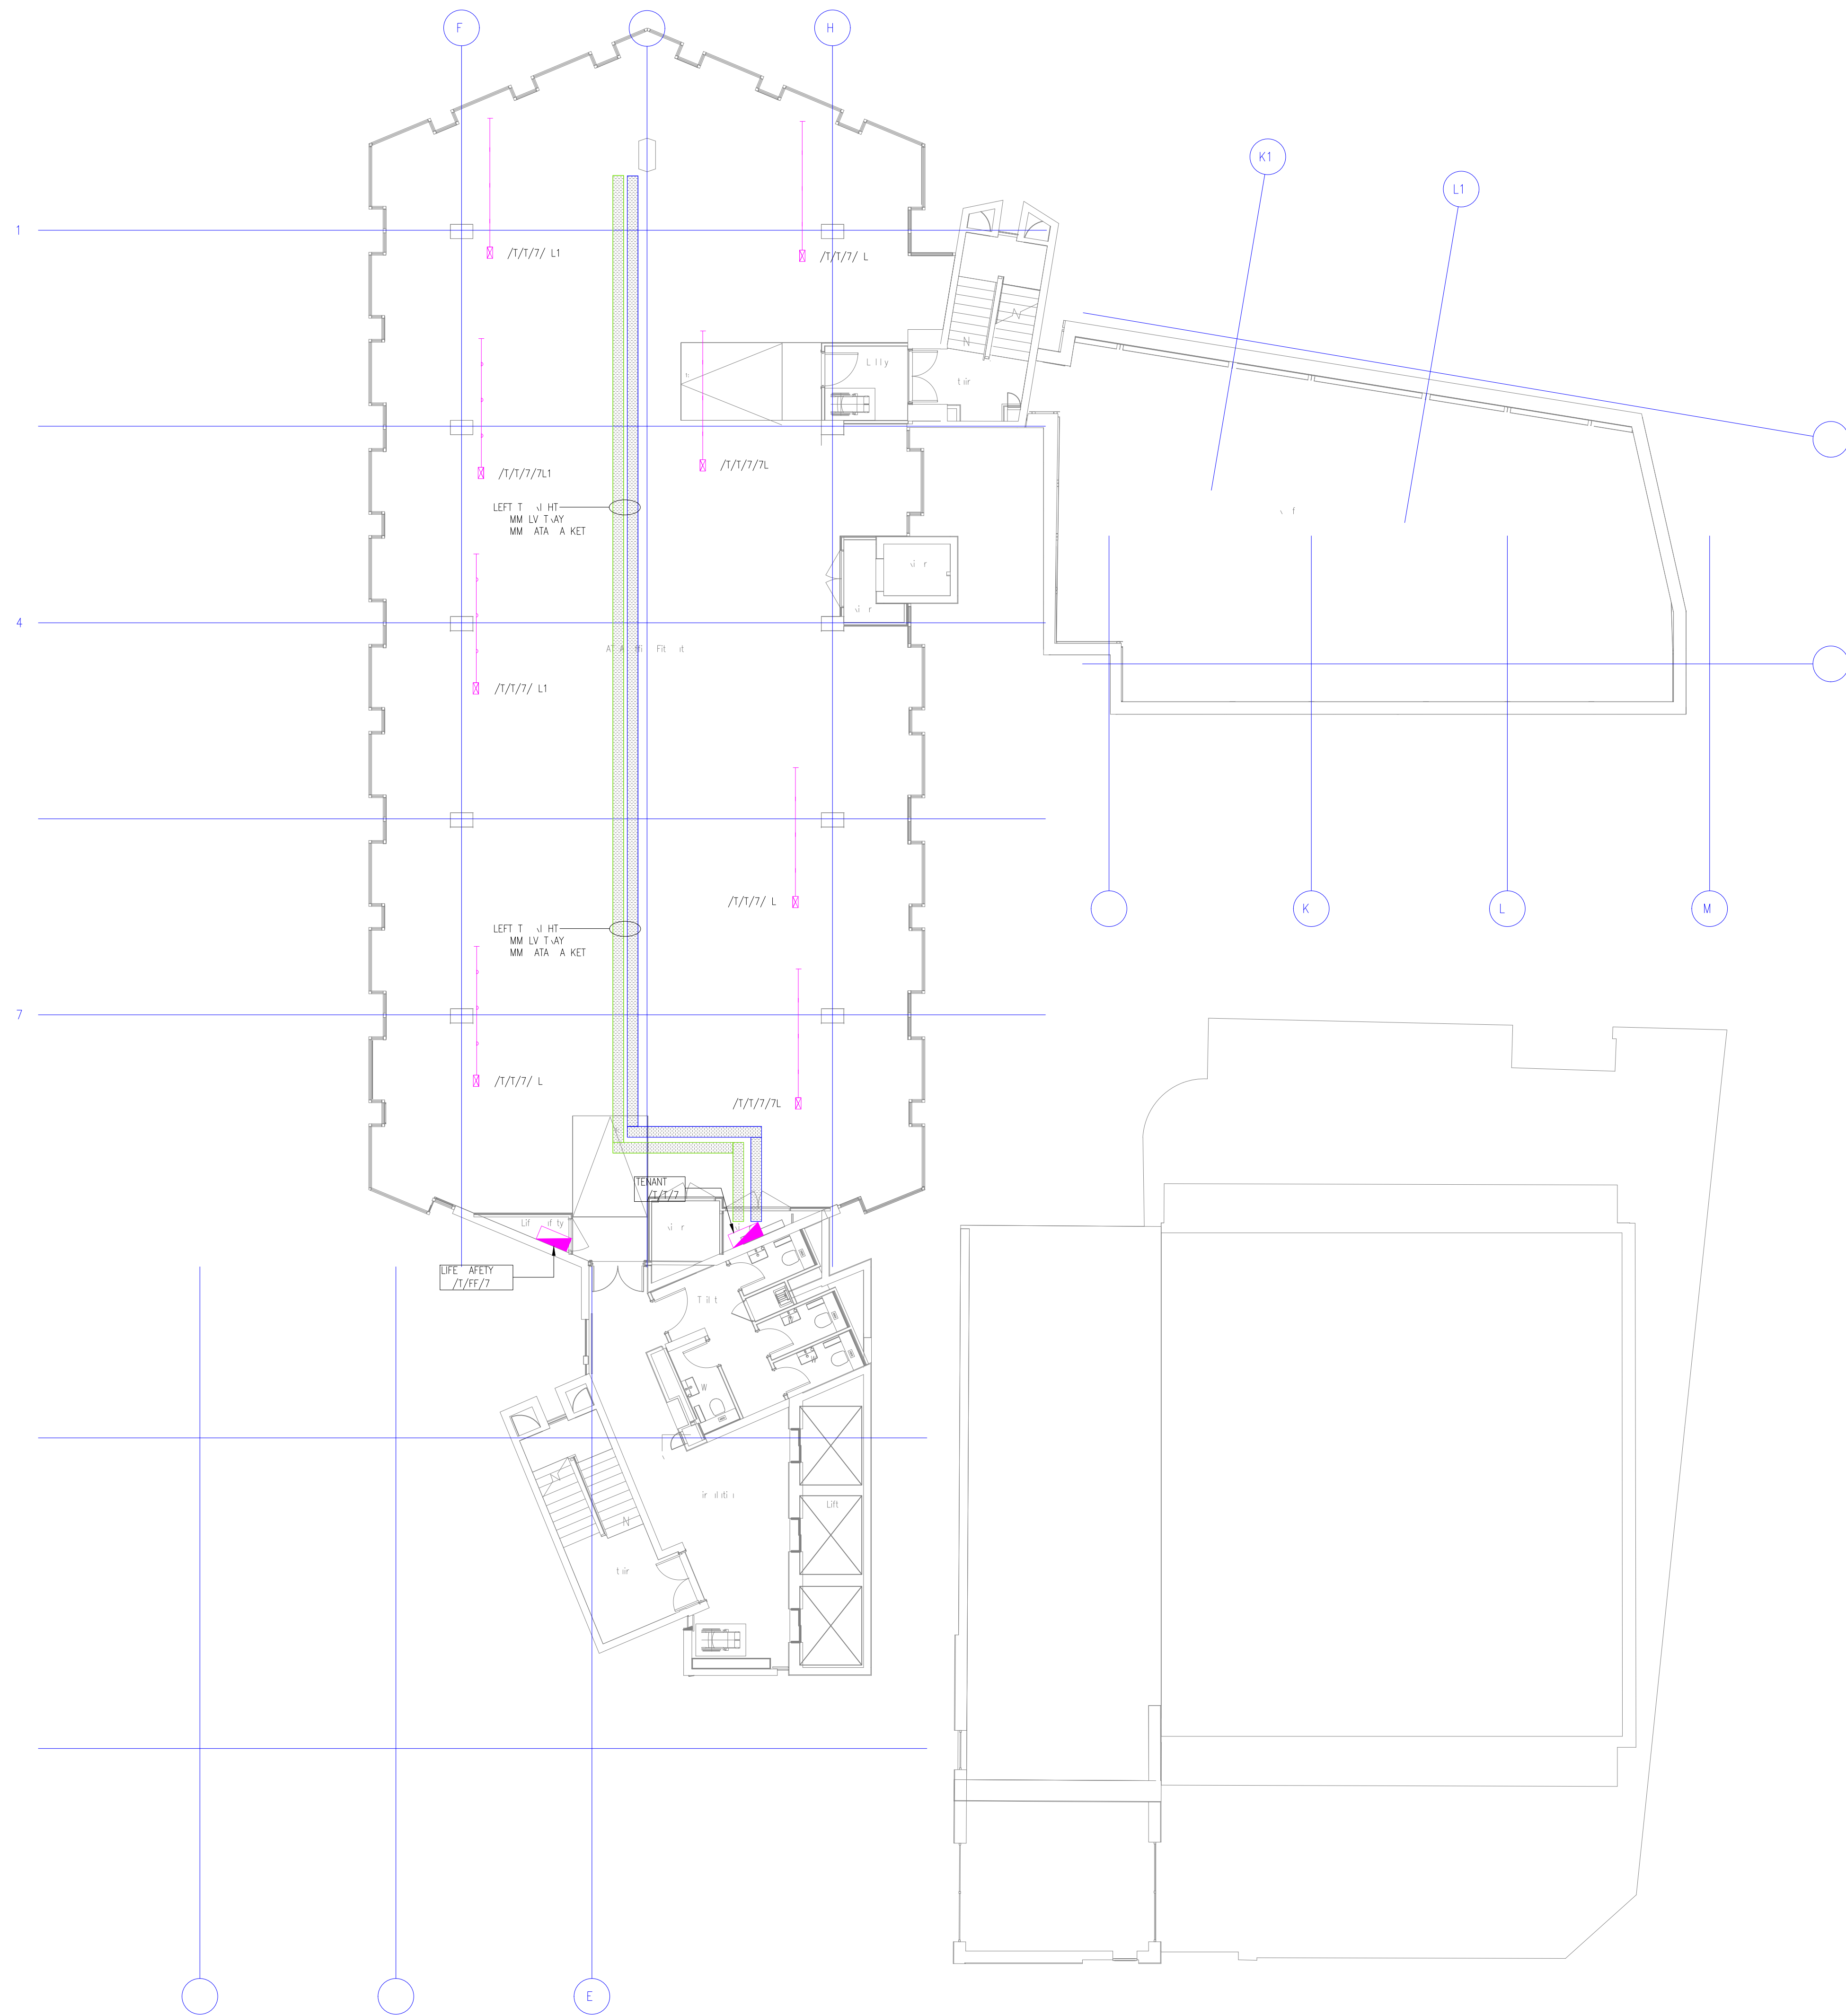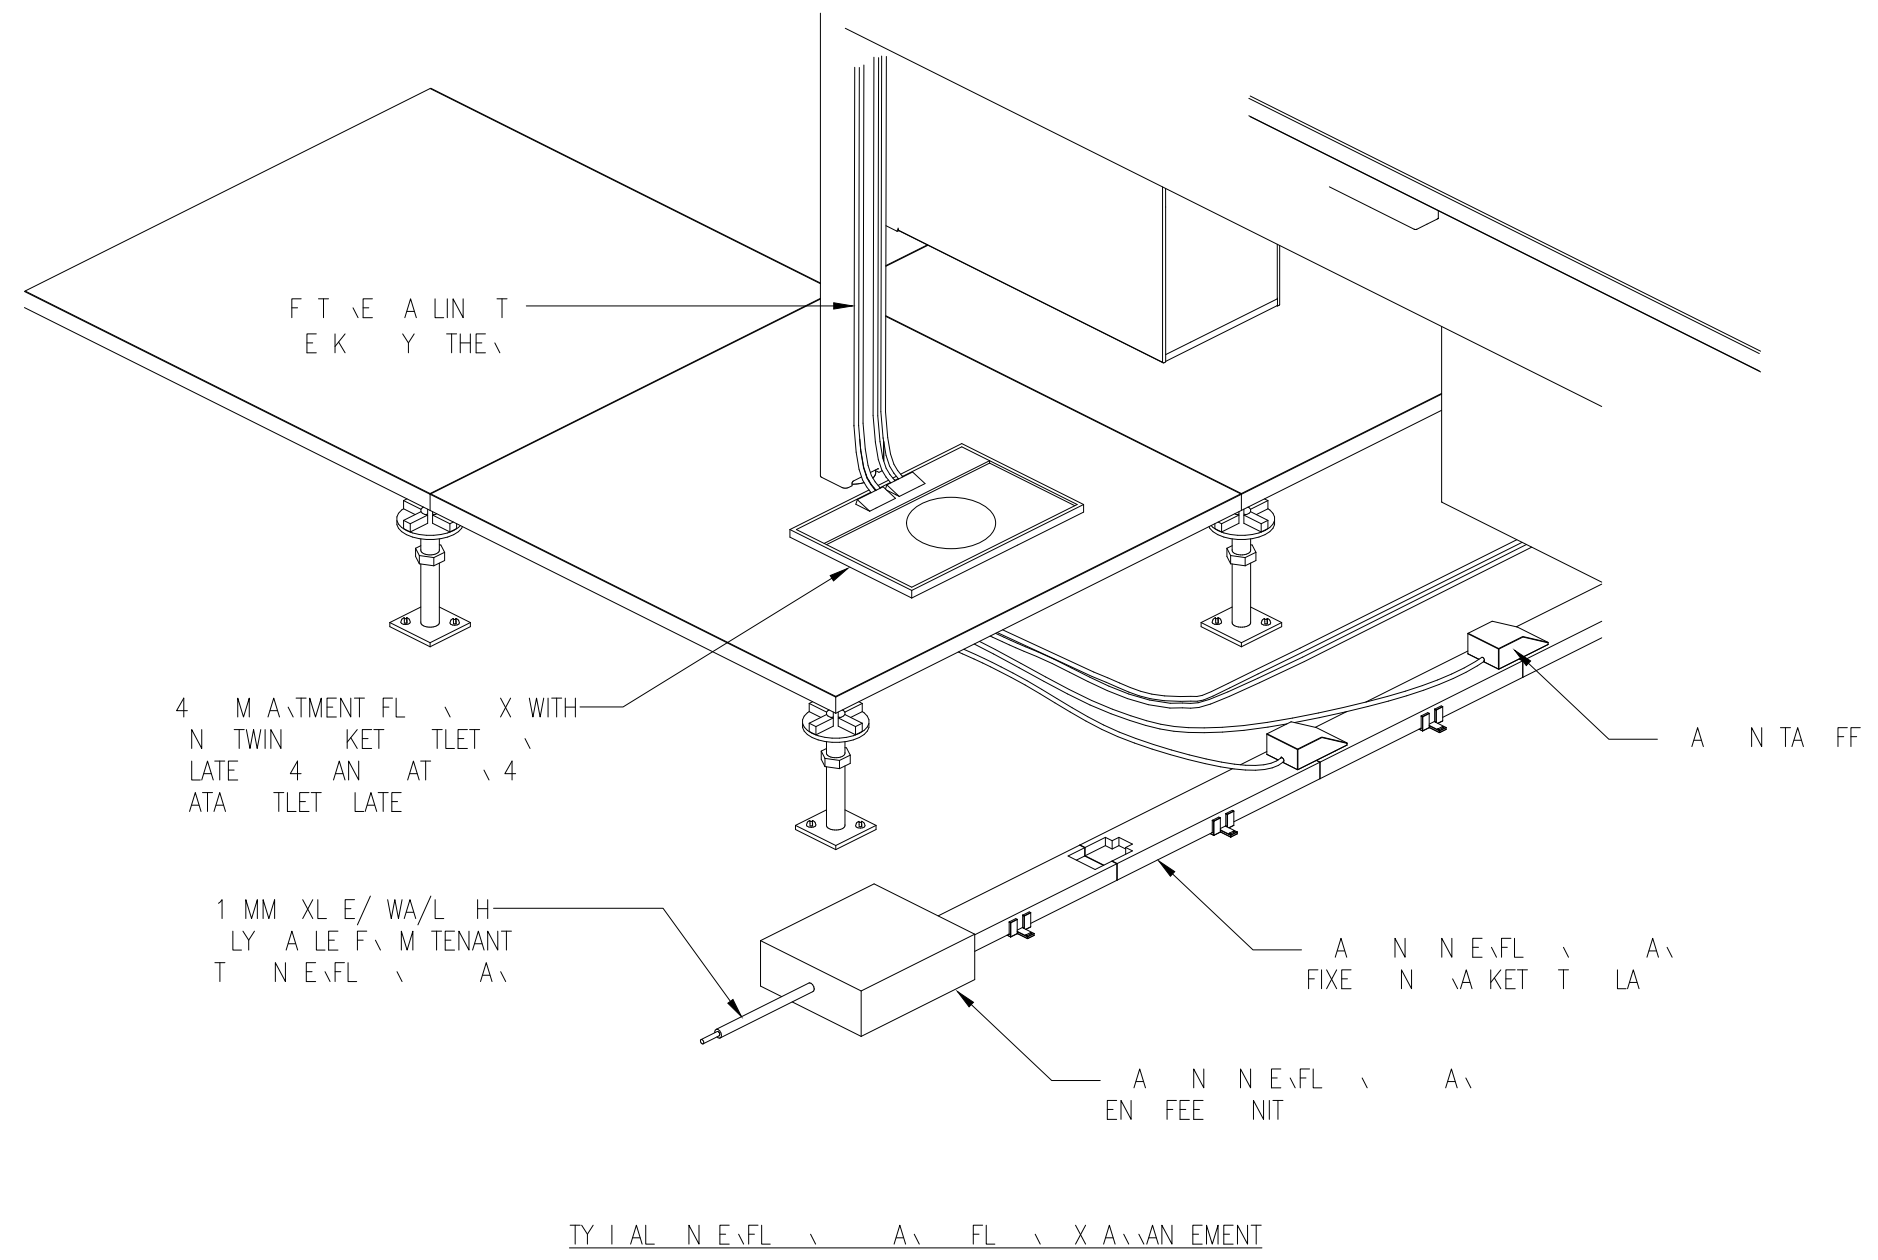

JAHEN E T VMENT		K			
1	Fl, T, E			2	Fl, T, E
4		4		4	

USED ON: 2017 Seventh Floor General Arrangement WRET CLEANED - P18
 Drawing Status:

PRELIMINARY

Unit 4, North Staffs Business Park,
 Inceston Way, Sully S134BH
 Email : info@crenford.co.uk
 Telephone: 01782 822250
www.crenford.co.uk

Project:

PALL MALL MANCHESTER

Title:

SEVENTH FLOOR LOW LEVEL CONTAINMENT LAYOUT

SHEPPARD ROBSON



Architect:	SHEPPARD ROBSON			
Consultant:	RAMBOLL			
Designer: PG	Project Number: CB	Job: PG	Drawn: MD	
Date: 06.01.2023	Project Number: CES561	Scale: 1:100	A0	
Drawing No: 6911-CES-XX-07-UR-E-6622	Rev:			

Copyright, Carter Electrical Services Ltd
 Customers are to check all dimensions on site and refer any
 discrepancies to Carter Electrical immediately

GENERAL NOTE

1. This drawing is a preliminary drawing and is not for construction. All dimensions are approximate and subject to change without notice.

CONTAINMENT	
SYMBOL	DESCRIPTION
	LOW VOLTAGE
	VOLTA-GE
	HIGH VOLTAGE
	ELECTRICITY
	ELECTRICITY

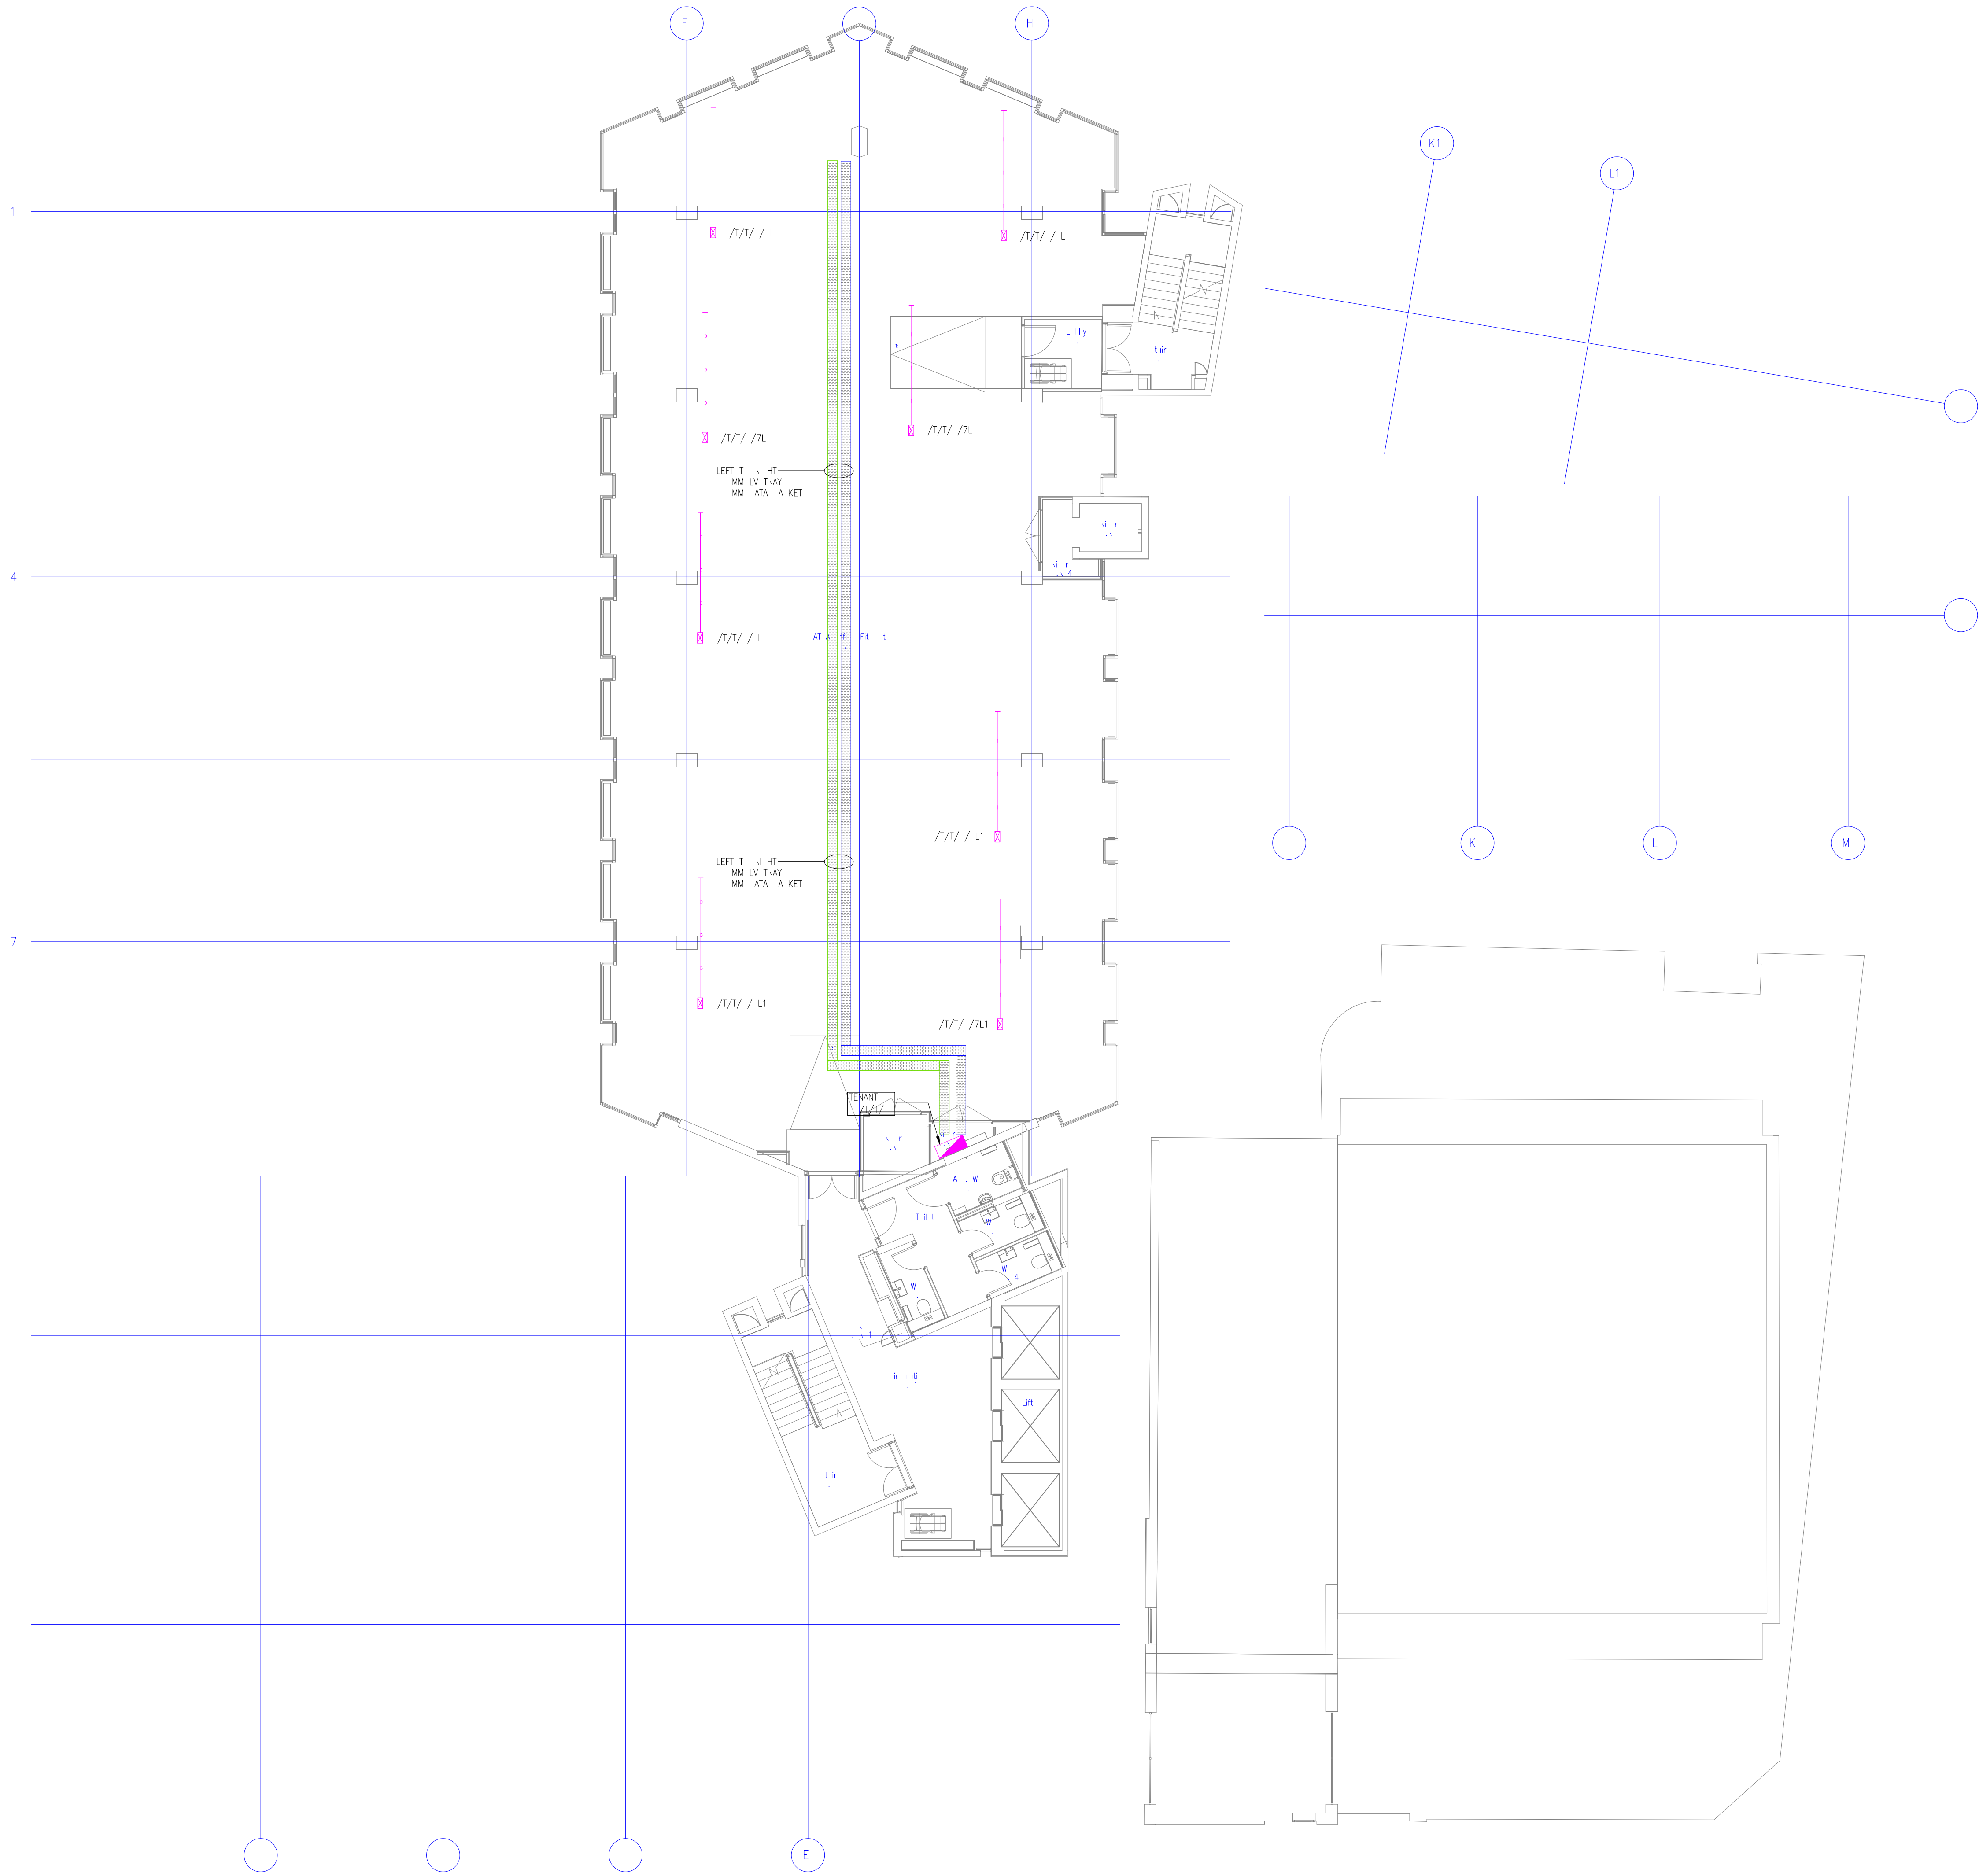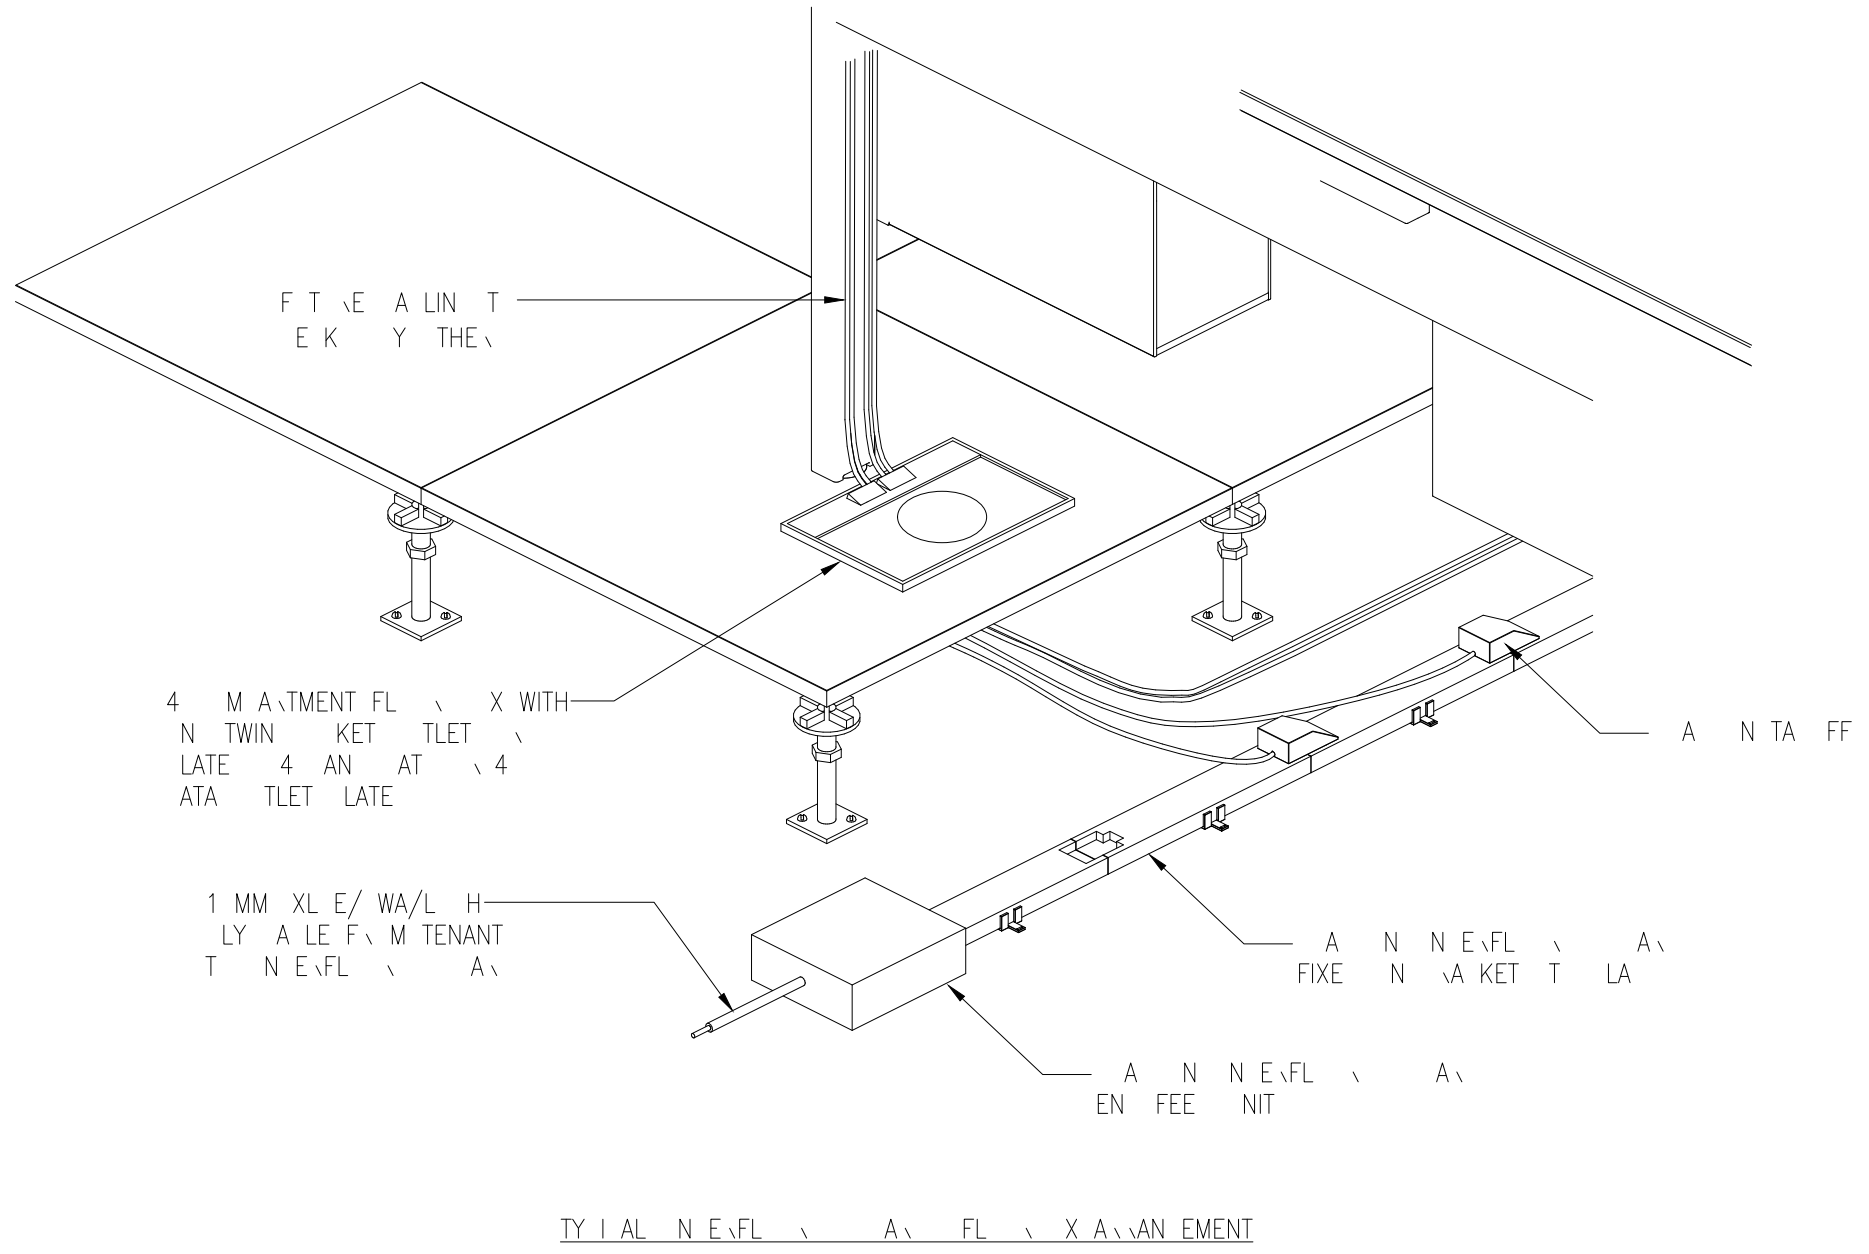


AMENITY		K	
TENT			
Drawing Status:			
PRELIMINARY			
Unit 6, North Staffs Business Park, Innovation Way, Staffs, ST44 9F Email: info@carterelectrical.co.uk Telephone: 01782 822250 www.carterelectrical.co.uk			
Project:			
PALL MALL MANCHESTER			
THE EIGHTH FLOOR LOW LEVEL CONTAINMENT LAYOUT			
Architect: SHEPPARD ROBSON			
Consultant: RAMBOLL			
Designer: PG	Project: CB	Scale: PG	Checked: MD
Date: 06.01.2023	Project Number: CES561	Scale: 1:100	Rev: A0
Drawing No: 6911-CES-XX-08-DR-E-6623			
Copyright: Carter Electrical Services Ltd. Contractors are to check all dimensions on site and refer any discrepancies to Carter Electrical immediately.			

GENERAL NOTE

1. This drawing is a preliminary drawing and is not for construction. All dimensions are to be confirmed by the contractor.

CONTAINMENT		
SYMBOL	DESCRIPTION	NOTES
	LOW LEVEL	
	VENTILATION	
	HEATING	
	ELECTRICAL	
	ELECTRICAL	

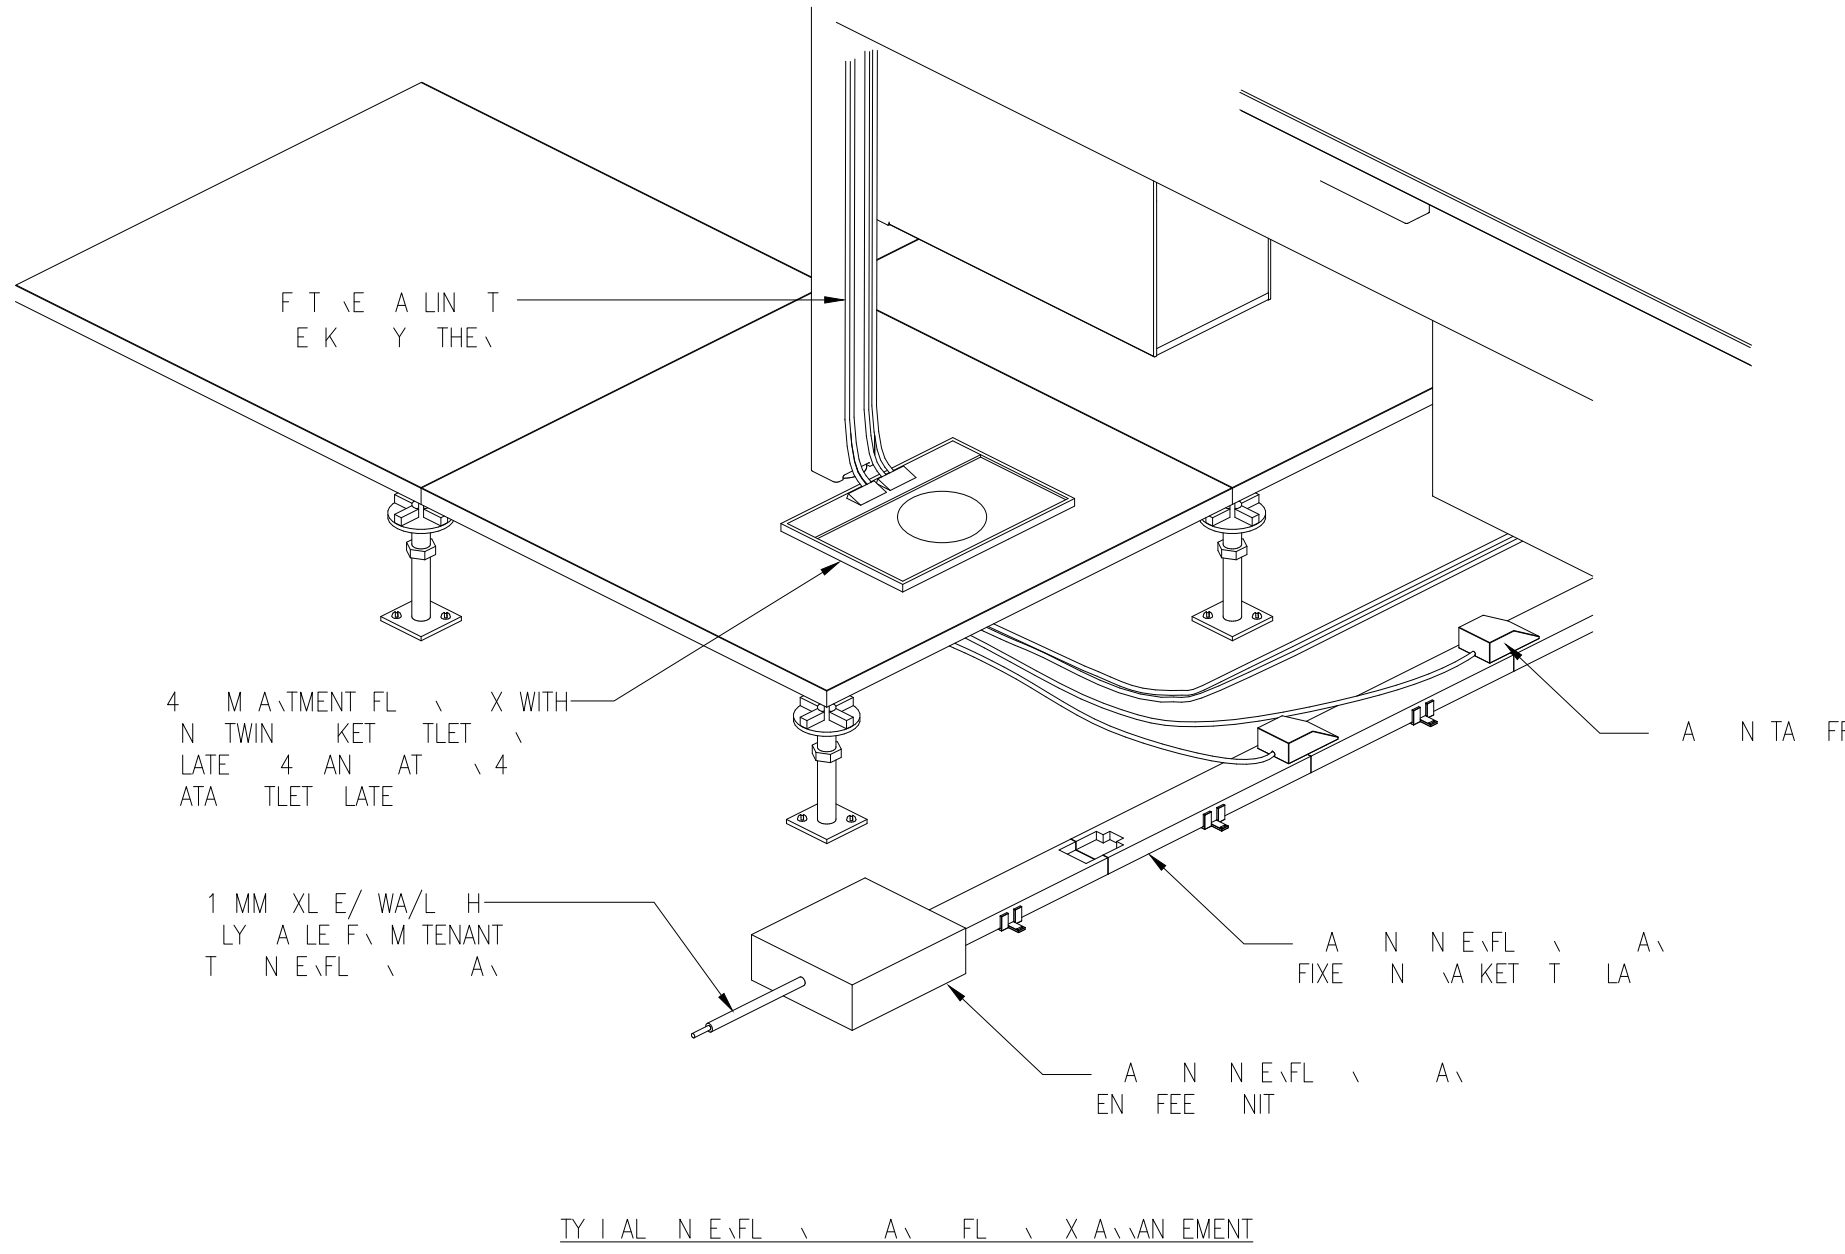


AMENITY		K	
FLOOR			
Drawing Status			
PRELIMINARY			
Unit 6, North Staffs Business Park, Innovation Way, Staffs, ST44RF Email: info@carterelectrical.co.uk Telephone: 01782 822250 www.carterelectrical.co.uk			
Project			
PALL MALL MANCHESTER			
THE TENTH FLOOR LOW LEVEL CONTAINMENT LAYOUT			
Architect: SHEPPARD ROBSON			
Consultant: RAMBOLL			
Designer: PG	Project: CB	Scale: PG	Checked: MD
Date: 06.01.2023	Project Number: CES561	Scale: 1:100	Rev: A0
Drawing No: 6911-CES-XX-10-DR-E-6625			Rev: A0
Copyright: Carter Electrical Services Ltd. Contractors are to check all dimensions on site and refer any discrepancies to Carter Electrical immediately.			

GENERAL NOTE

1. This drawing is a draft.
2. No responsibility is accepted for the use of this drawing for any purpose other than that for which it was prepared.

CONTAINMENT	
SYMBOL	DESCRIPTION
	LV TAY
	VIE DATA KET
	HA E ITU TIN A
	ELE TANK A A
	ELE TANK F A EN FEE

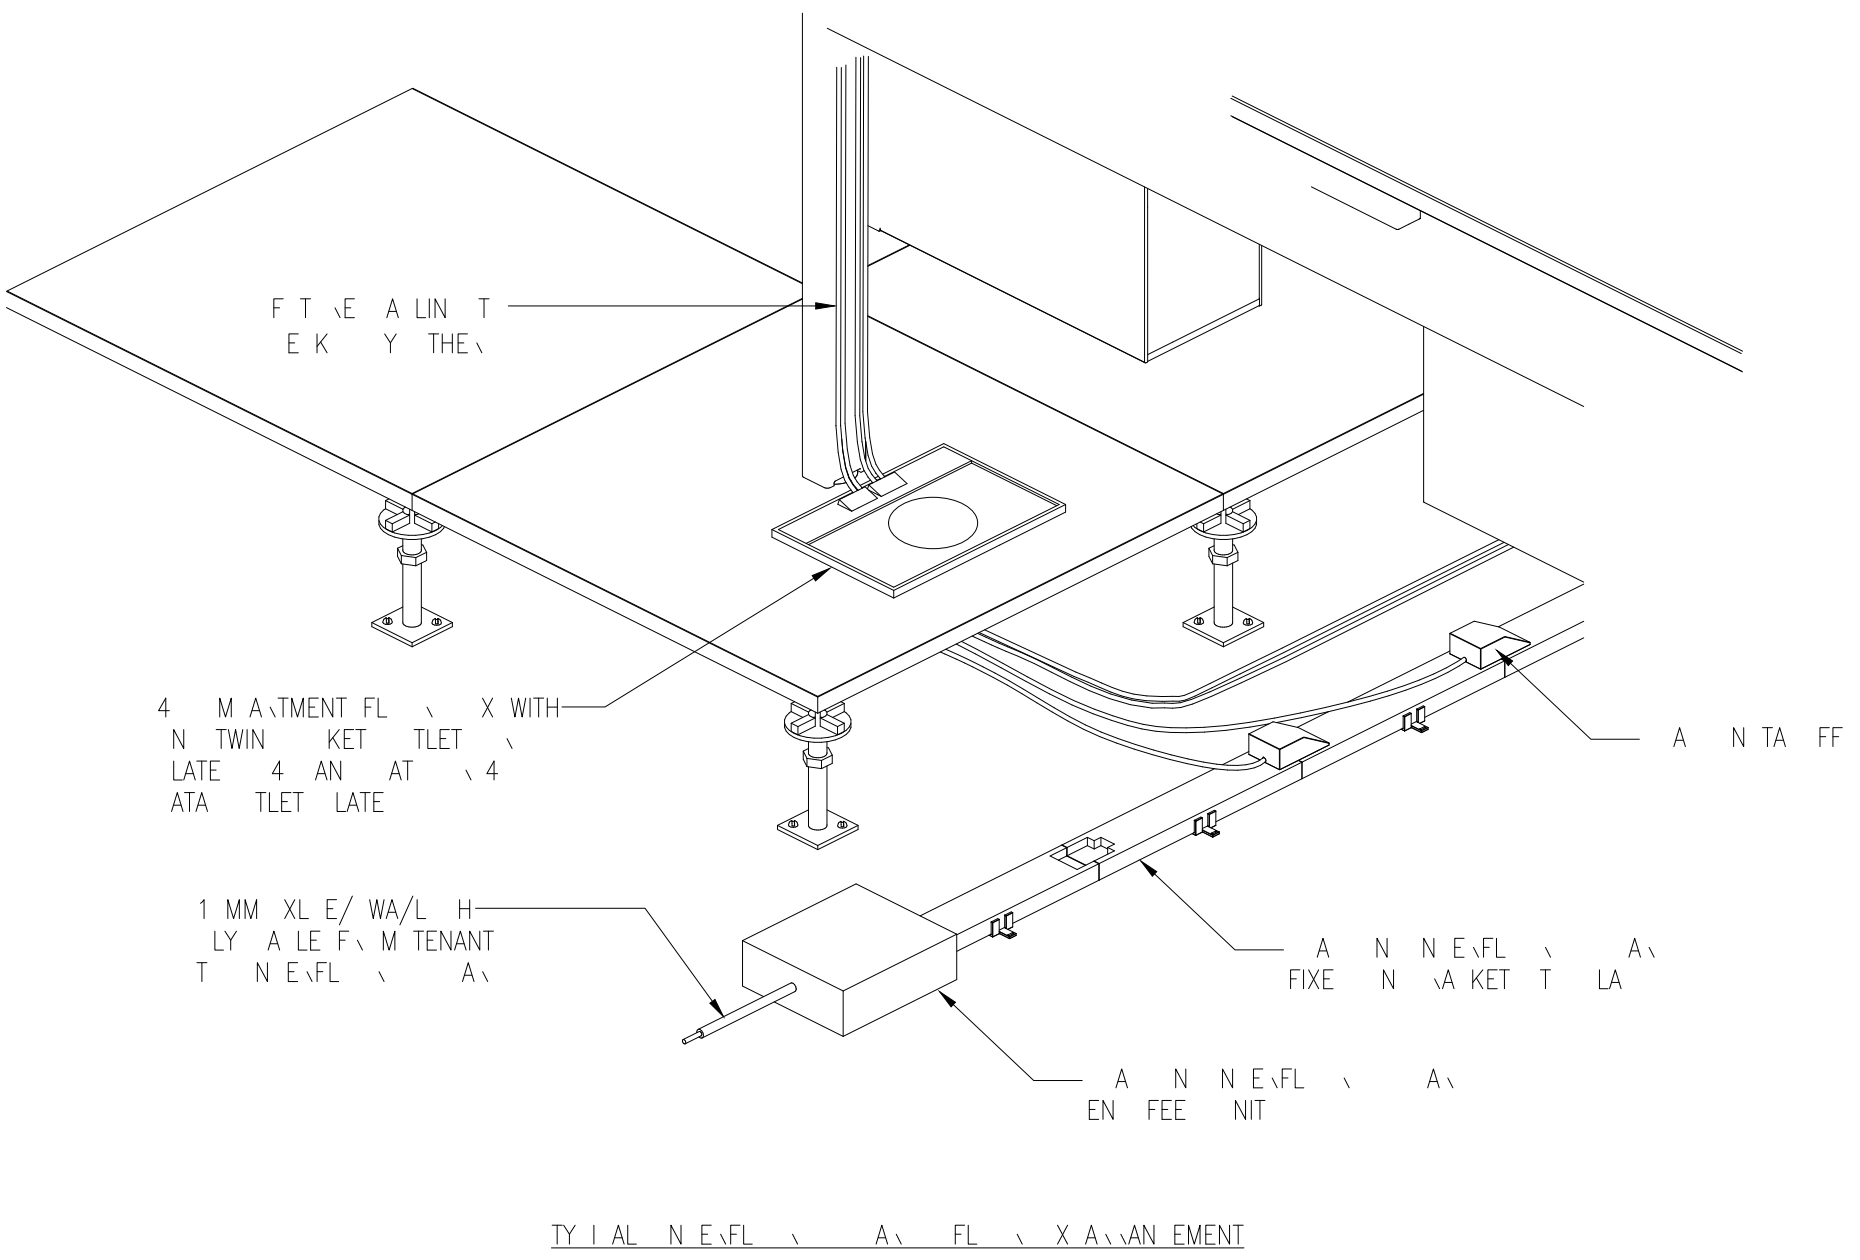

4	A. I. IT -ET AMEN E	K	
	EXTENAL LI HTN A. A E	K	
	AMEN E T MENT	K	
	FL T T E	K	

BASED ON: 2009 Lower Ground Floor General Arrangement SHEET CLEARED - PG 1

Drawing Status: PRELIMINARY

Unit 6, North Staffs Business Park, Innovation Way, Staffs, ST44 9F.
Email: info@carterelectrical.co.uk
Telephone: 01782 822250
www.carterelectrical.co.uk

Project: PALL MALL MANCHESTER

THE LOWER GROUND FLOOR LOW LEVEL CONTAINMENT LAYOUT

Architect: SHEPPARD ROBSON

Consultant: RAMBOLL

Designer: PG Project: CB Date: 06.01.2023
Checker: MD Project Number: CES561 Scale: 1:100 | A0

Drawing No: 6911-CES-XX-LG-DR-E-6614 Rev: 004

Copyright: Carter Electrical Services Ltd
Contractors are to check all dimensions on site and refer any discrepancies to Carter Electrical immediately



SYMBOLS	
MALL	WE
YM L	E J T I N
▲	N LE ADA INT AT
⬇	TWN WIT HE KET TLET
⬇	N WIT HE N LE KET TLET
⬇	N WIT HE TWN KET TLET
⬇	4 M AMENT FL X WITH N TWN KET TLET
⬇	LATE 4 AN AT 4 ADA TLET LATE
⬇	WIT HE F E
⬇	WIT HE F E WITH FLEX TLET
⬇	N WIT HE F E
⬇	N WIT HE F E WITH FLEX TLET
⬇	N LE HA E N WIT HE IN TUAL KET EN
⬇	HAN YE WITH A VE
⬇	HA E T T N A
⬇	N LE WIT HE LEANE KET TLET
⬇	WIT HE F E NT LIN IN LE KET AT
⬇	WIT HE F E WITH FLEX TLET ME HAN AL ITEM
EFFECTS	
TEXT	E J T I N
A	A T A VE
A	A E NT L NT
AF	A T FL H NT
AT	A T TA NT
	AN H NT LLE
M	IL N MANA EVENT Y TEM
TV	L E L T TELN I N
I	I A LE ALA M
	I A LE EF E ANEL
	I A LE EF E E EATE ANEL
W	I HAN HE
E H	ELE T J ANEL HEATE
EV	EMV EN Y V I E MM N AN N NT ANEL
FA	FILE ALA M ANEL
FA	FILE ALA M E EATE ANEL
F	FAN IL NT
H/L	HI H LEVEL
H	HEAT E VE Y NT
L	LI HEN NT L ANEL
L/L	L W LEVEL
A	LI A E ANEL
	LEV LVN
E	E JTY ANEL
E	E JTY ANEL
V	LEN I VALVE
WF1	WI ELE A E
W/L	W KT LEVEL
ZI	ZI TA
	M NTIN HEI HT
W	WEATHE F T I

AMEN E T MENT		K
P R E		
Drawing Status: PRELIMINARY		
<p>Unit 6, North Staffs Business Park, Innovation Way, Staffs, ST4 4SF Email: info@carterelectrical.co.uk Telephone: 01782 822250 www.carterelectrical.co.uk</p>		
Project: PALL MALL MANCHESTER		
Title: FIRST FLOOR SMALL POWER & DATA LAYOUT		
Architect: SHEPPARD ROBSON		
Consultant: RAMBOLL		
Designer: PG	Project: CB	Scale: PG
Date: 06.01.2023	Project Number: CES561	Checked: MD
Drawing No: 6911-CES-XX-01-DR-E-6203		Rev: 002
Copyright: Carter Electrical Services LTD Contractors are to check all dimensions on site and refer any discrepancies to Carter Electrical immediately		

1. I want that this is a law.
 . Necessarily and yet in error
 in front of law by the. All
 in front of all take for fear
 in front of all take it.



J A H E N E T M I N N E T		K		L	
1	11	1	1	1	1
<div style="text-align: center;">  </div>				<div style="text-align: center;">  </div>	

BASED ON: 20102 Second Floor General Amendment XREF CLEANED - P20
 Drawing Status: PRELIMINARY



Unit 6, North Staris Business Park,
 Emerson Way, South St. Paul
 Email: info@cornerstoneelectrical.com
 Telephone: 612-822-2501
www.cornerstoneelectrical.com






Project:

PALL MALL MANICHER

THE
 SECOND FLOOR
 SMALL POWER & DATA
 LAYOUT

SHEPPARD ROBSON

Worksheet:					
Consultant: RAMBOLL					
Designer: PG	Project Manager: CB	NO	PG	Checked: MD	
Date: 06.01.2013		Project Number: CES561		Scale: 1=100	A0
Drawing No: 8911-CES-XX-02-DR-E-6204					Rev: 


Copyright, Carter Electrical Services Ltd
 Contractors are to check all dimensions on site and refer any discrepancies to Carter Electrical immediately

GENERAL NOTE

1. This drawing is a draft.
2. No liability is accepted for the use of this drawing for any purpose other than that intended by the client.

MALL	WE
YM L	E L T I N
▲	IN LE ATA INT AT
△	TWIN WIT HE KET TLET
△	N WIT HE IN LE KET TLET
△	N WIT HE TWIN KET TLET
△	4 M ALMENT FL X WITH N TWIN KET TLET X LATE 4 AN AT 4 A TLET LATE
△	WIT HE F E
△	WIT HE F E WITH FLEX TLET
△	N WIT HE F E
△	N WIT HE F E WITH FLEX TLET
△	IN LE HA E N WIT HE IN TUAL KET EN
□	HAN YE WITH A VE
■	HA E IT T I N A
△	IN LE WIT HE LEANE KET TLET
△	WIT HE F E INT LLEN IN LE KET AT L W LEVEL F A LAN E
△	WIT HE F E WITH FLEX TLET ME HAN AL ITEM

TEXT	E L T I N
A	A A VE
A	A E NT L NT
AF	A T FL H NT
AT	A T TA NT
	AN H NT LLE
M	IL IN MANA ENENT Y TDM
TV	L E IT TELEVIN
I	I A LE ALAM
△	I A LE EF E ANEL
△	I A LE EF E E EATE ANEL
W	I HMA HE
E H	ELE T J ANEL HEATE
EV	ENE EN Y I E MM NI AT N NT ANEL
FA	FLE ALAM ANEL
FA	FLE ALAM E EATE ANEL
F	FAN L NT
H/L	HI H LEVEL
H	HEAT E VE NT
L	LI HIN NT L ANEL
L/L	L W LEVEL
A	LI A E ANEL
△	LEV LVN
E	E JTY ANEL
E	E JTY ANEL
V	LDN I VALVE
W/I	WGLE A E
W/L	W XT LEVEL
Z	Z TA
	M NTN HEI HT
W	WEATHE FT I

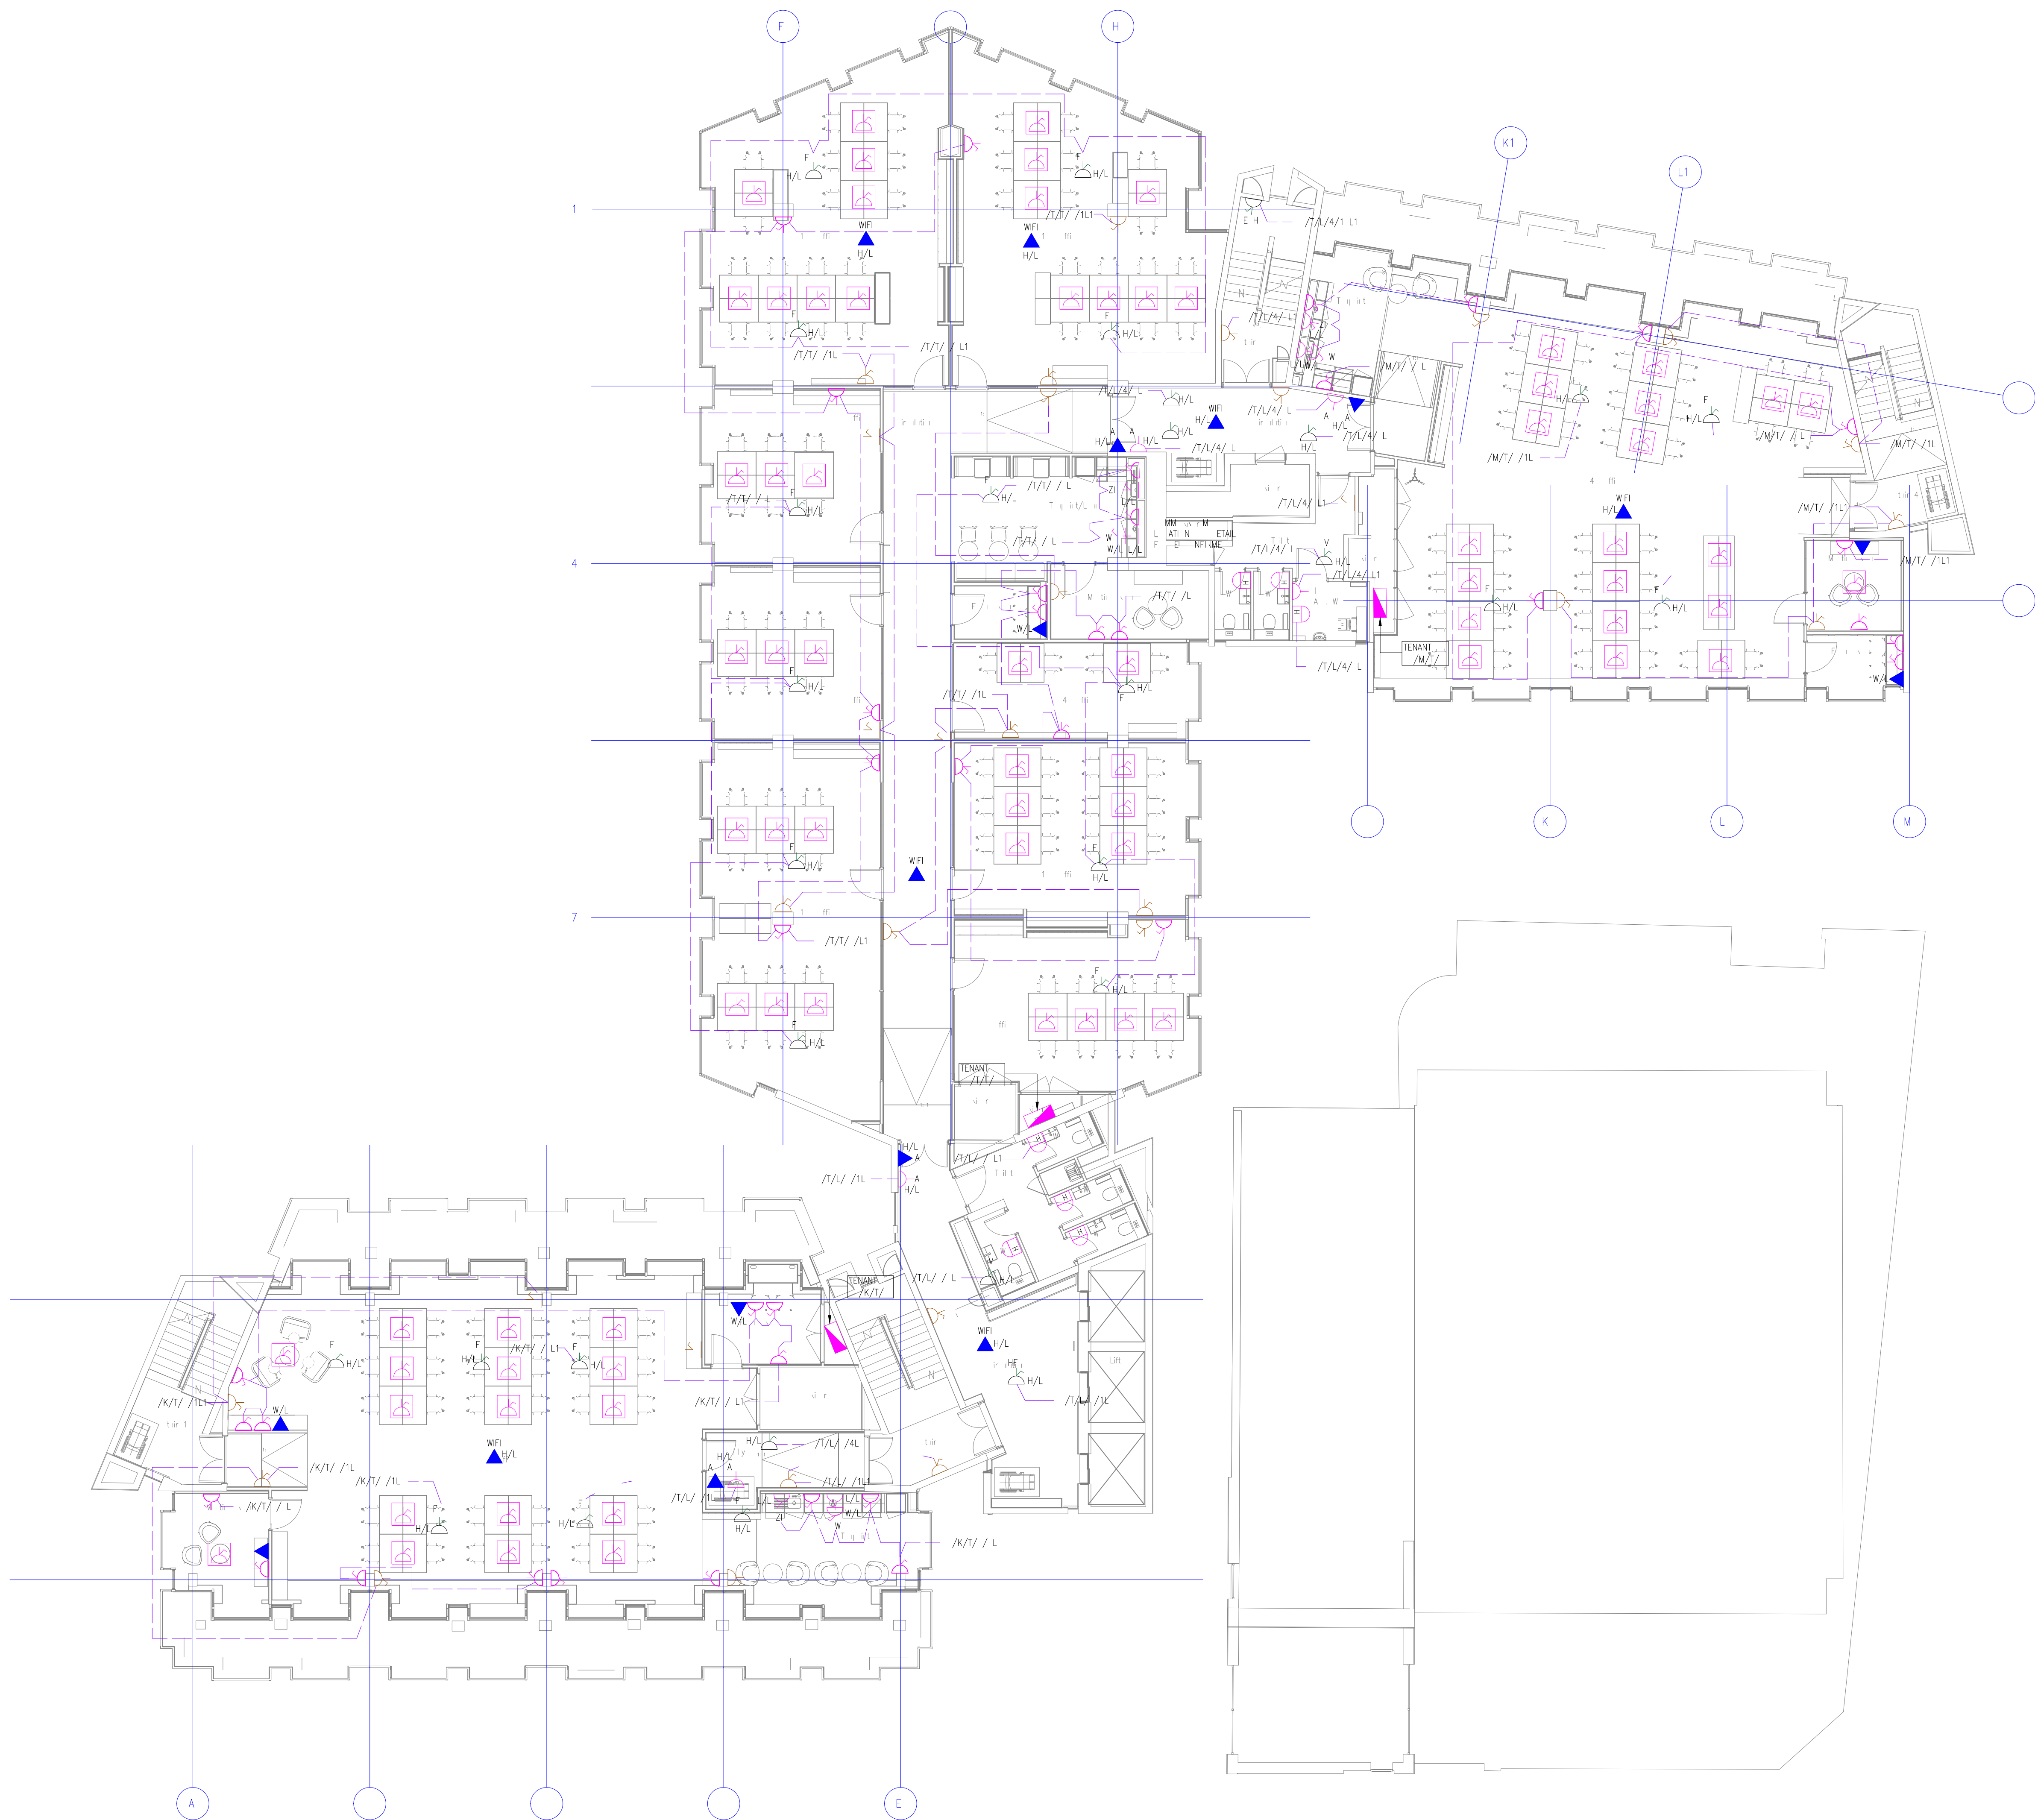

AMEN E T MENT		K
P L T E		
Drawing Status: PRELIMINARY		
<p>Unit 6, North Staffs Business Park, Innovation Way, Staffs, ST44 9F Email: info@carterelectrical.co.uk Telephone: 01782 822250 www.carterelectrical.co.uk</p>		
Project: PALL MALL MANCHESTER		
Title: THIRD FLOOR SMALL POWER & DATA LAYOUT		
Architect: SHEPPARD ROBSON		
Consultant: RAMBOLL		
Designer: PG	Project: CB	Doc: PG
Date: 06.01.2023	Project Number: CES561	Checked: MD
Drawing No: 6911-CES-XX-03-DR-E-6205		Scale: 1:100
Copyright: Carter Electrical Services LTD Contractors are to check all dimensions on site and refer any discrepancies to Carter Electrical immediately.		

GENERAL NOTE

1. This drawing is a draft.
2. No liability is accepted for any errors or omissions.
3. It is the responsibility of the client to ensure that the drawing is used for the intended purpose only.



MALL WE	
YM L	E
▲	IN LE ADA INT AT
⌂	TWIN WIT HE KET TLET
⌂	N WIT HE IN LE KET TLET
⌂	N WIT HE TWIN KET TLET
4	4 M ALIMENT FL X WITH N TWIN KET TLET LATE 4 AN AT 4 4 ADA TLET LATE
⌂	WIT HE F E
⌂	WIT HE F E WITH FLEX TLET
⌂	N WIT HE F E
⌂	N WIT HE F E WITH FLEX TLET
⌂	IN LE HA E N WIT HE IN TUAL KET EN
⌂	HAN OVE WITH A VE
⌂	HA E IT J TIN A
⌂	IN LE WIT HE LEANE KET TLET
⌂	WIT HE F E INT LUN IN LE KET AT L W LEVEL F A LAN E
⌂	WIT HE F E WITH FLEX TLET ME HAN AL ITEM

REFERENCE	
TEXT	E
A	A T AVE
A	A E INT L INT
AT	A T FL H INT
AT	A T TA INT
	AN H INT LLE
M	IL IN MANA EMENT Y TEM
TV	L E IL IT TELEVI N
I	I A LE ALA M
✓	I A LE SET E ANEL
✓✓	I A LE SET E E EATE ANEL
W	I HWA HE
E H	ELE T J ANEL HEATE
EV	EME EN Y Y I E MM NI ATIN NIT ANEL
FA	FL E ALA M ANEL
FA	FL E ALA M E E EATE ANEL
F	FAN IL INT
H/L	HI H LEVEL
H	HEAT E VE Y NIT
L	LI MTIN NT L ANEL
L/L	L W LEVEL
A	LI A E ANEL
✓	LEV LVN
E	E CITY ANEL
E	E CITY ANEL
V	LEN I VALVE
WF1	WI ELE A E
W/L	W RT LEVEL
ZI	ZI TA
	M NTH HDI HT
W	WEATHE V F T I

AMEN E T MENT		K	
1. PRELIMINARY			
Drawing Status: PRELIMINARY			
Unit & North Staffs Business Park, Innovation Way, Staffs, ST4 4SF. Email: info@carterelectrical.co.uk Telephone: 01782 822250 www.carterelectrical.co.uk			
Project: PALL MALL MANCHESTER			
Title: FOURTH FLOOR SMALL POWER & DATA LAYOUT			
Architect: SHEPPARD ROBSON			
Consultant: RAMBOLL			
Designer: PG	Project: CB	Draw: PG	Checked: MD
Date: 06.02.2023	Project Number: CES561	Scale: 1:100	AG
Drawing No: 6911-CES-XX-04-DR-E-6206			Rev: 1
Copyright: Carter Electrical Services LTD. Contractors are to check all dimensions on site and refer any discrepancies to Carter Electrical immediately.			

1. I want that this is a law.
 . Necessarily and yet in error
 in front of law by the. All
 in front of all take for fear
 in front of all take it.



AMEN E T		MENT		K			
1	11	1	1	1	1	1	1
+ - + - + -						+ - + - + -	

BASED ON: 20106 Sixth Floor General Arrangement XREF CLEANED = P19
 Drawing Status:

PRELIMINARY



Unit 6, North Station Business Park,
 Inverness Way, Salford S15 4AD
 Email - info@cornersteel.co.uk
 Telephone: 01752 822250
www.cornersteel.co.uk






Project


PALL MALL MANCHESTER

The

SIXTH FLOOR SMALL POWER & DATA LAYOUT

SHEPPARD ROBSON

Architect	Project Name			Client	Drawn	Checked
Consultant	RAMBOLL			Client	Scale: 1:100	A0
Designer: PG	Project: MB	Unit: CB	Area: PG	Client: CES561		
Issued: 06.02.2023				Rev: 6911-CES-XX-06-UR-E-6208		

 

Copyright, Carter Electrical Services Ltd
 Confirmation to be checked all dimensions on site and refer any
 discrepancies to Carter Electrical immediately

GENERAL NOTE

1. This drawing is a draft.
2. Not to be used for construction.
3. All dimensions are in millimetres.
4. If there is a conflict between the text and the drawing, the text shall prevail.




MALL WE	
YM L	E S T I N
▲	IN LE ATA INT AT
⬇	TWIN WIT HE KET TLET
⬇	N WIT HE IN LE KET TLET
⬇	N WIT HE TWIN KET TLET
⬇	4 M A TMENT FL X WITH N TWIN KET TLET LATE 4 AN AT 4 ATA TLET LATE
⬇	WIT HE F E
⬇	WIT HE F E WITH FLEX TLET
⬇	N WIT HE F E
⬇	N WIT HE F E WITH FLEX TLET
⬇	IN LE HA E N WIT HE IN T JAL KET EN
⬇	HAN YE WITH A VE
⬇	HA E IT U T N A
⬇	IN LE WIT HE LEANE KET TLET
⬇	WIT HE F E NT LON IN LE KET AT L W LEVEL F A LUN E
⬇	WIT HE F E WITH FLEX TLET ME HAN AL TEM
⬇	I LAT ME HAN AL LY NT OEE A N N F LE
REFERENCE	
TEXT	E S T I N
A	A T A E
A	A E NT L NT
AF	A T FL H NT
AT	A T TA NT
	AN H NT LLE
M	IL IN MAN EMENT Y TEM
TV	L E L T TELEPH N
I	I A LE ALA M
⬇	I A LE E F E ANEL
⬇	I A LE E F E E DATE ANEL
W	I HAN HE
E H	ELE T J ANEL HEATE
EV	EMEL EN Y V I E NM NI AT N NT ANEL
FA	FILE ALA M ANEL
FA	FILE ALA M E DATE ANEL
F	FAN IL NT
H/L	H H LEVEL
H/L	HEAT LE VE M NT
L	LI HTIN NT L ANEL
L/L	L W LEVEL
A	LI A E ANEL
⬇	LEV LON
E	E JTY ANEL
E	E JTY ANEL
V	LEN I VALVE
WFI	WIELE A E
W/L	W KT LEVEL
ZI	ZI TA
	M NTIN HEI HT
W	WEATHE F T I

AMEN E T MENT
I T T E
K
1:100

BASED ON: 20107 Seventh Floor General Arrangement SHEET CLEANED - P19
Drawing Status: PRELIMINARY
Unit & North: South Business Park, Innovation Way, Stuffs, ST49F
Email: info@carterelectrical.co.uk
Telephone: 01782 822250
www.carterelectrical.co.uk
Project: PALL MALL MANCHESTER
THE SEVENTH FLOOR SMALL POWER & DATA LAYOUT
Architect: SHEPPARD ROBSON
Consultant: RAMBOLL
Designer: PG
Project: CB
Date: 06.02.2023
Project Number: CES561
Scale: 1:100
Drawing No: 6911-CES-XX-07-DR-E-6203
Copyright: Carter Electrical Services LTD
Contractors are to check all dimensions on site and refer any discrepancies to Carter Electrical immediately

GENERAL NOTE

1. This drawing is a preliminary drawing and is not to be used for construction purposes. All dimensions are given in millimetres unless otherwise stated.

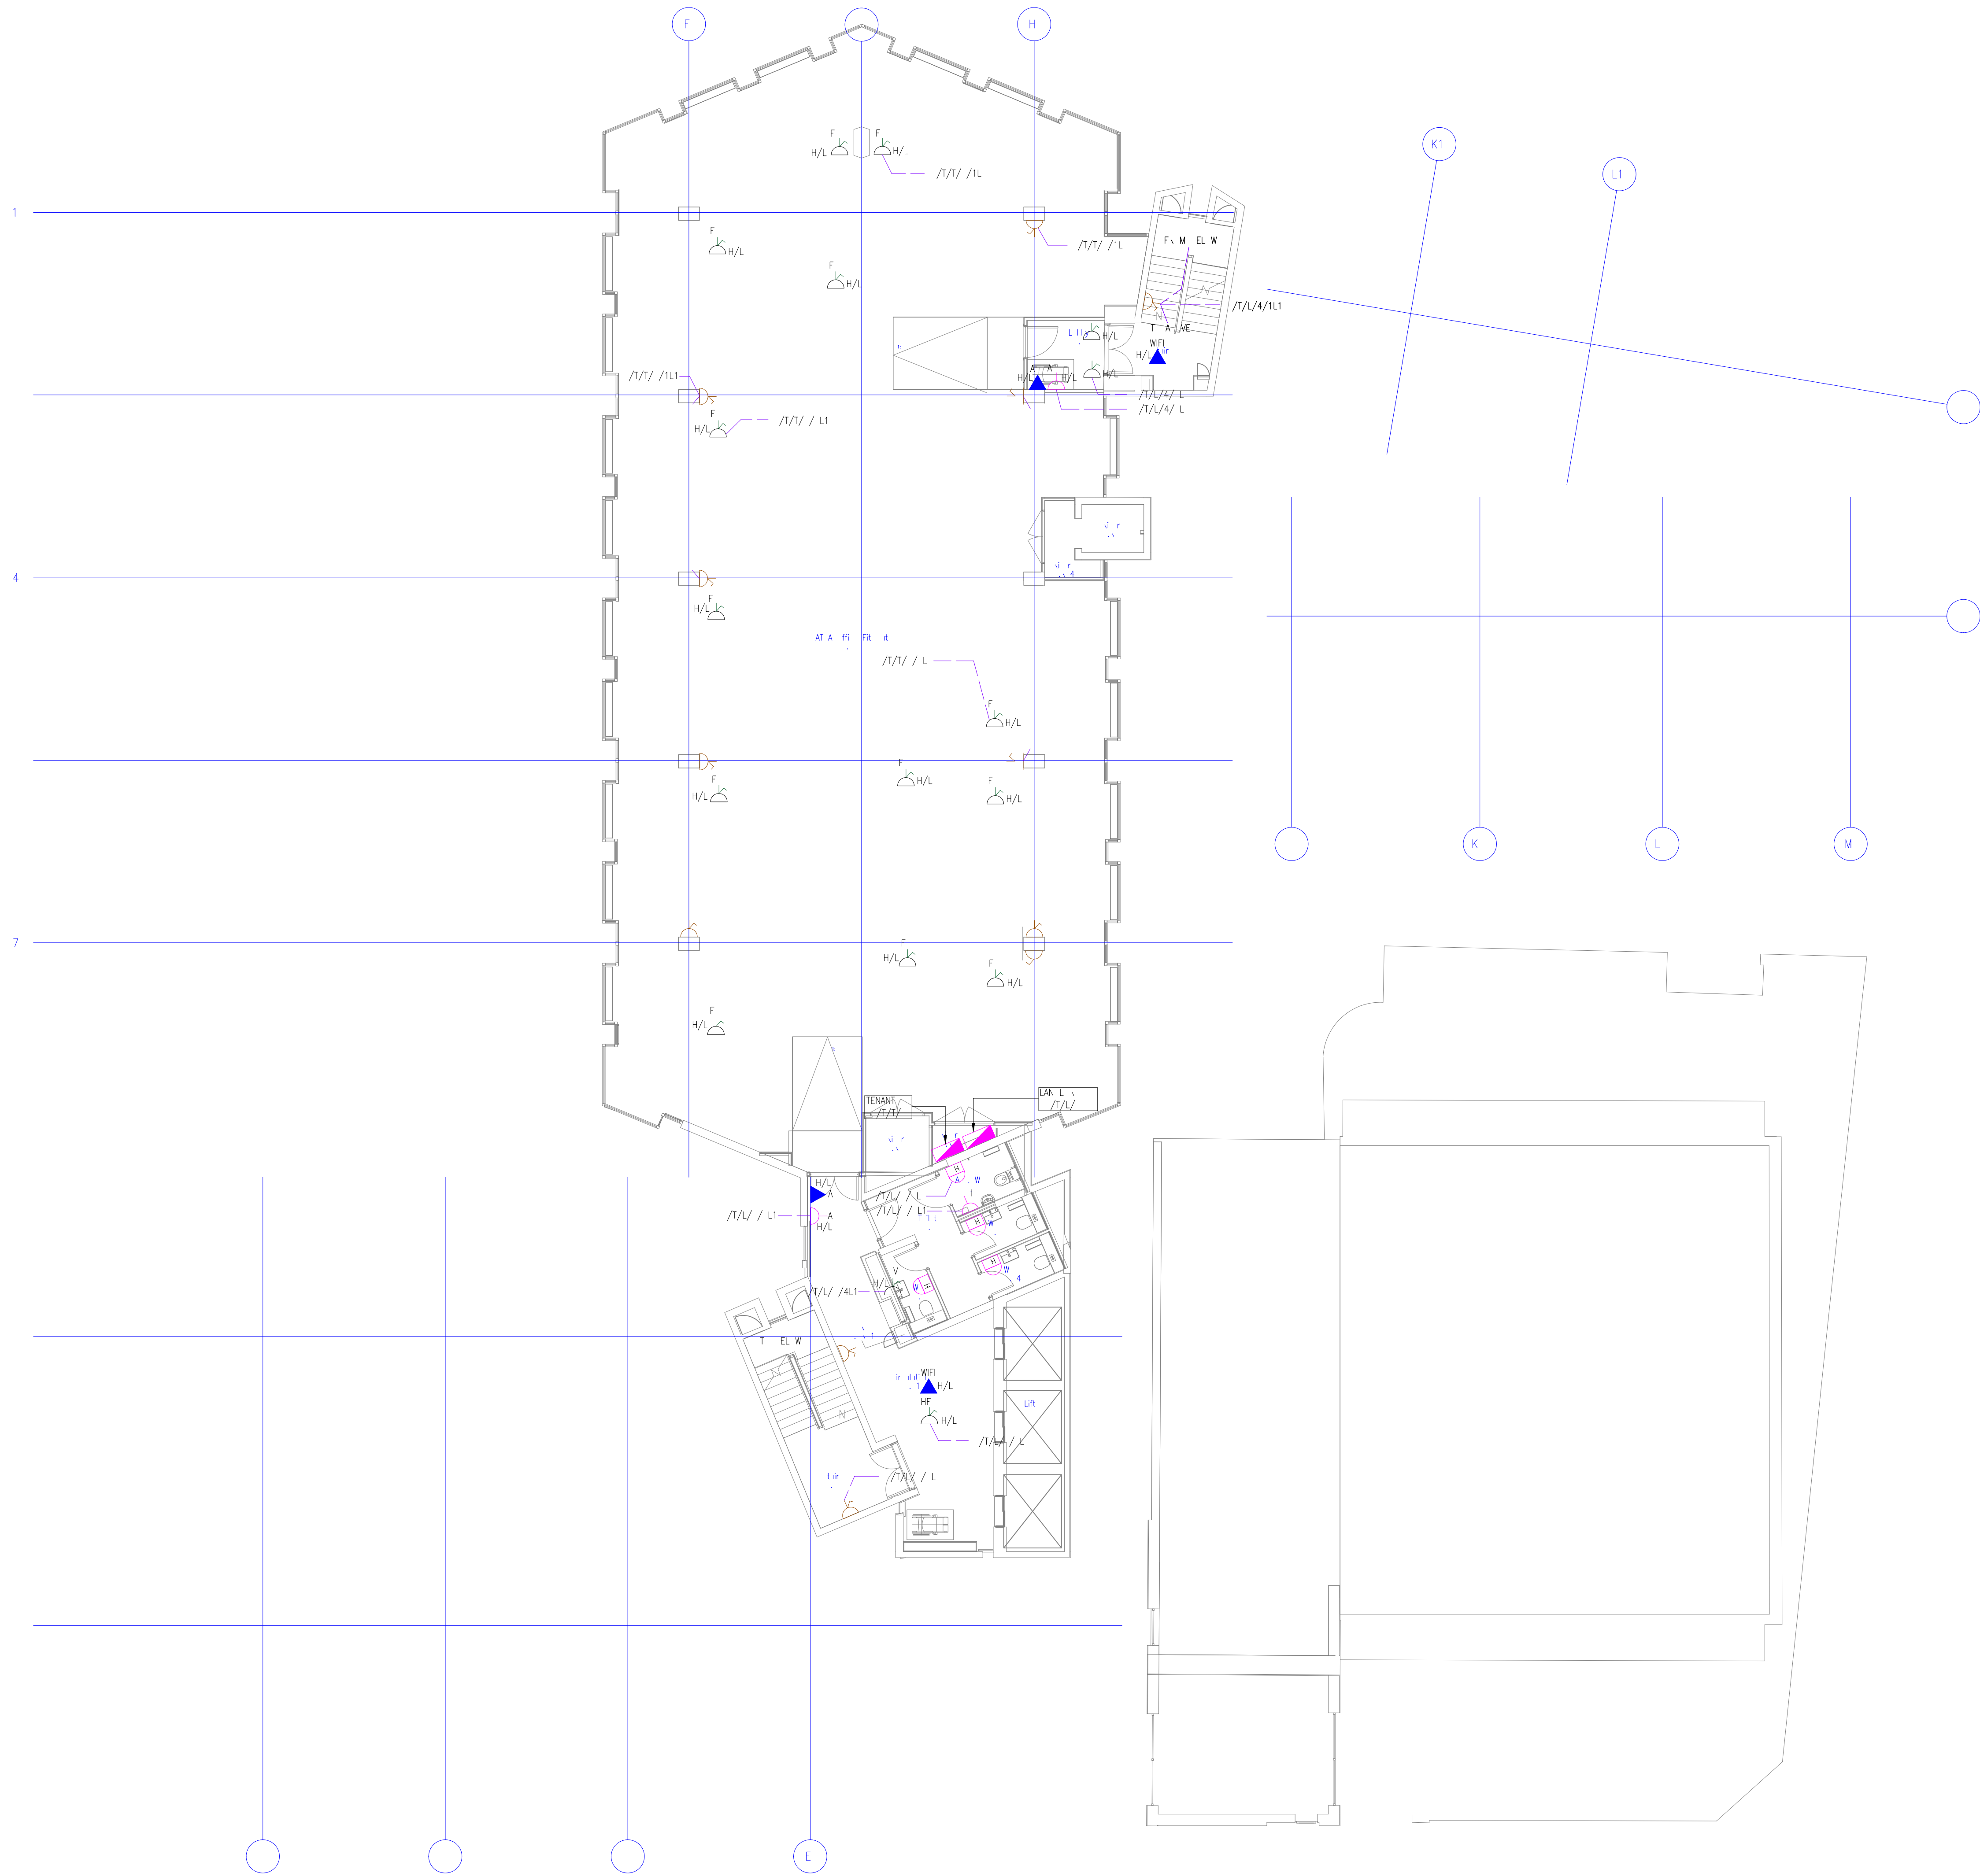

MALL WE	
YM L	E N T I N
▲	IN LE ATA INT AT
△	TWIN WITH HE KET TLET
△	N WITH HE IN LE KET TLET
△	N WITH HE TWIN KET TLET
△	N WITH HE TWIN KET TLET
△	4 M A TMENT FL X WITH N TWIN KET TLET
△	LATE 4 AN AT 4 ATA TLET LATE
△	WIT HE F E
△	WIT HE F E WITH FLEX TLET
△	N WITH HE F E
△	N WITH HE F E WITH FLEX TLET
△	IN LE HA E N WITH HE IN TUAL KET EN
△	HAN VE WITH A VE
△	HA E I T U T I N A
△	IN LE WIT HE LEANE KET TLET
△	WIT HE F E N T LUN IN LE KET AT
△	L W LEVEL F A LUN E
△	WIT HE F E WITH FLEX TLET ME HAN AL REM
△	I LAT ME HAN AL LY NT = IZE A N = N F LE
REFERENCE	
TEXT	E N T I N
A	A T A VE
A	A E N T L NIT
AF	A T FL H NIT
AT	A T TA NIT
	AN H N T LLE
W	IL IN MAN EMENT Y TEM
TV	L E L IT TELEVI N
I	I A LE ALAM
△	I A LE EF E ANEL
△	I A LE EF E E EATE ANEL
W	I HAN HE
E H	ELE T J ANEL HEATE
EV	EME EN Y I E MM N ARI N NIT ANEL
FA	FL E ALAM ANEL
FA	FL E ALAM E EATE ANEL
F	FAN IL NIT
H/L	HI H LEVEL
H	HEAT E VE Y NIT
L	LI HTN N T L ANEL
L/L	L W LEVEL
A	LI A E ANEL
△	EV LUN
E	E JTY ANEL
E	E JTY ANEL
V	LEN I VALVE
WH	W ELE A E
W/L	W XT LEVEL
ZI	ZI TA
	M NTN HEI HT
W	WEATHE F T I

AMEN E T MENT

PRELIMINARY

Unit 6, North Staffs Business Park,
Innovation Way, Staffs, ST4 4SF
Email: info@carterelectrical.co.uk
Telephone: 01782 822250
www.carterelectrical.co.uk

Project
PALL MALL
MANCHESTER

THE
EIGHTH FLOOR
SMALL POWER & DATA
LAYOUT

Architect
SHEPPARD ROBSON

Consultant
RAMBOLL

Designer: PG
Project: CB
Date: 06.02.2023
Project Number: CES561
Drawing No: 6911-CES-XX-08-DR-E-6210

Scale: 1:100
A0

Copyright: Carter Electrical Services Ltd
Contractors are to check all dimensions on site and refer any
discrepancies to Carter Electrical immediately



GENERAL NOTE	
1. All dimensions are in millimetres. 2. All dimensions are to the centre of the symbol unless otherwise stated. 3. All dimensions are to the face of the symbol unless otherwise stated. 4. All dimensions are to the centre of the symbol unless otherwise stated.	
MALL WE	SECTION
YM L	SECTION
▲	IN LE ADA INT AT
⌂	TWIN WIT HE KET TLET
⌂	N WIT HE IN LE KET TLET
⌂	N WIT HE TWIN KET TLET
⌂	N WIT HE TWIN KET TLET
⌂	4 M AUMENT FL X WITH N TWIN KET TLET LATE 4 AN AT X 4 ADA TLET LATE
⌂	WIT HE F E
⌂	WIT HE F E WITH FLEX TLET
⌂	N WIT HE F E
⌂	N WIT HE F E WITH FLEX TLET
⌂	IN LE HA E N WIT HE IN TUAL KET EN
⌂	HAN VE WITH A VE
⌂	HA E IT T N A
⌂	IN LE WIT HE LEANE KET TLET
⌂	WIT HE F E NT LUN IN LE KET AT L W LEVEL F A LAN E
⌂	WIT HE F E WITH FLEX TLET ME HAN AL ITEM
⌂	I LAT ME HAN AL LY NT IDE A N N F LE
REFERENCE	
TEXT	SECTION
A	A T A VE
A	A E NT L NT
AT	A T FL H NT
AT	A T TA NT
	AN H NT LLE
M	IL IN MANA EMENT Y TEM
TV	L E I IF TELEVI N
I	I A LE ALAM
⌂	I A LE EF E ANEL
⌂	I A LE EF E E DATE ANEL
M	I HAN HE
E H	ELE T J ANEL HEATE
EV	EME EN Y I E WM NI ATI N NT ANEL
FA	FL E ALAM ANEL
FA	FL E ALAM E DATE ANEL
F	FAN IL NT
H/L	H H LEVEL
HF	HEATIN FAN NVE T
L	LI HTIN NT L ANEL
L/L	L W LEVEL
A	LI A E ANEL
⌂	LEV LUN
E	E JTY ANEL
E	E JTY ANEL
V	LEN I VALVE
WFI	WLELE A E
W/L	W RT LEVEL
ZI	ZI TA
	M NTIN HEI HT
W	WEATHE F T I

AMEN E T MENT		K	:
I T T E			
Drawing Status:		Drawing Status:	
PRELIMINARY			
Unit & North Staffs Business Park, Innovation Way, Staffs, ST449F, Email: info@carterelectrical.co.uk Telephone: 01782 822250 www.carterelectrical.co.uk			
Project: PALL MALL MANCHESTER			
Title: TENTH FLOOR SMALL POWER & DATA LAYOUT			
Architect: SHEPPARD ROBSON			
Consultant: RAMBOLL			
Designer: PG	Project: CB	Doc: PG	Checked: MD
Date: 06.02.2023	Project Number: CES561	Scale: 1:100	A0
Drawing No: 6911-CES-XX-10-DR-E-6212			Rev: 001
Copyright: Carter Electrical Services LTD Contractors are to check all dimensions on site and refer any discrepancies to Carter Electrical immediately			

1. Please note that this is unreviewed.
2. No responsibility can be accepted in error or scaling from this drawing by others. All measurements should be taken from figured dimensions and checked on site.

REFERENCES

ad	ADU District
----	--------------

	0	1	2	523
--	---	---	---	---	---	---	---	---	---	---	----	----	-----	-----	
BMC	BILLING MANAGER
-----	-----------------

DIS	DISABLED ALARM
-----	----------------

DRRP	DISABLED REFUGE
1	1
2	2
3	3
100	100

	5
5	5

FAD	DBF ALIGN PAUTH
-----	-----------------

11.0	WIND LEVEL
------	------------

LOW LEVEL	μ
-----------	-------

RD	REVOLVING DOOR
----	----------------

[illegible]


W/L	WORKTOP LEVEL
-----	---------------

(30)	MOUNING HELPI
------	---------------

BOOKS: *THE GROWING STATE*
 BOOKS: *THE GROWING STATE*

CARTERPALL MALL

SHEPPARD ROBSON

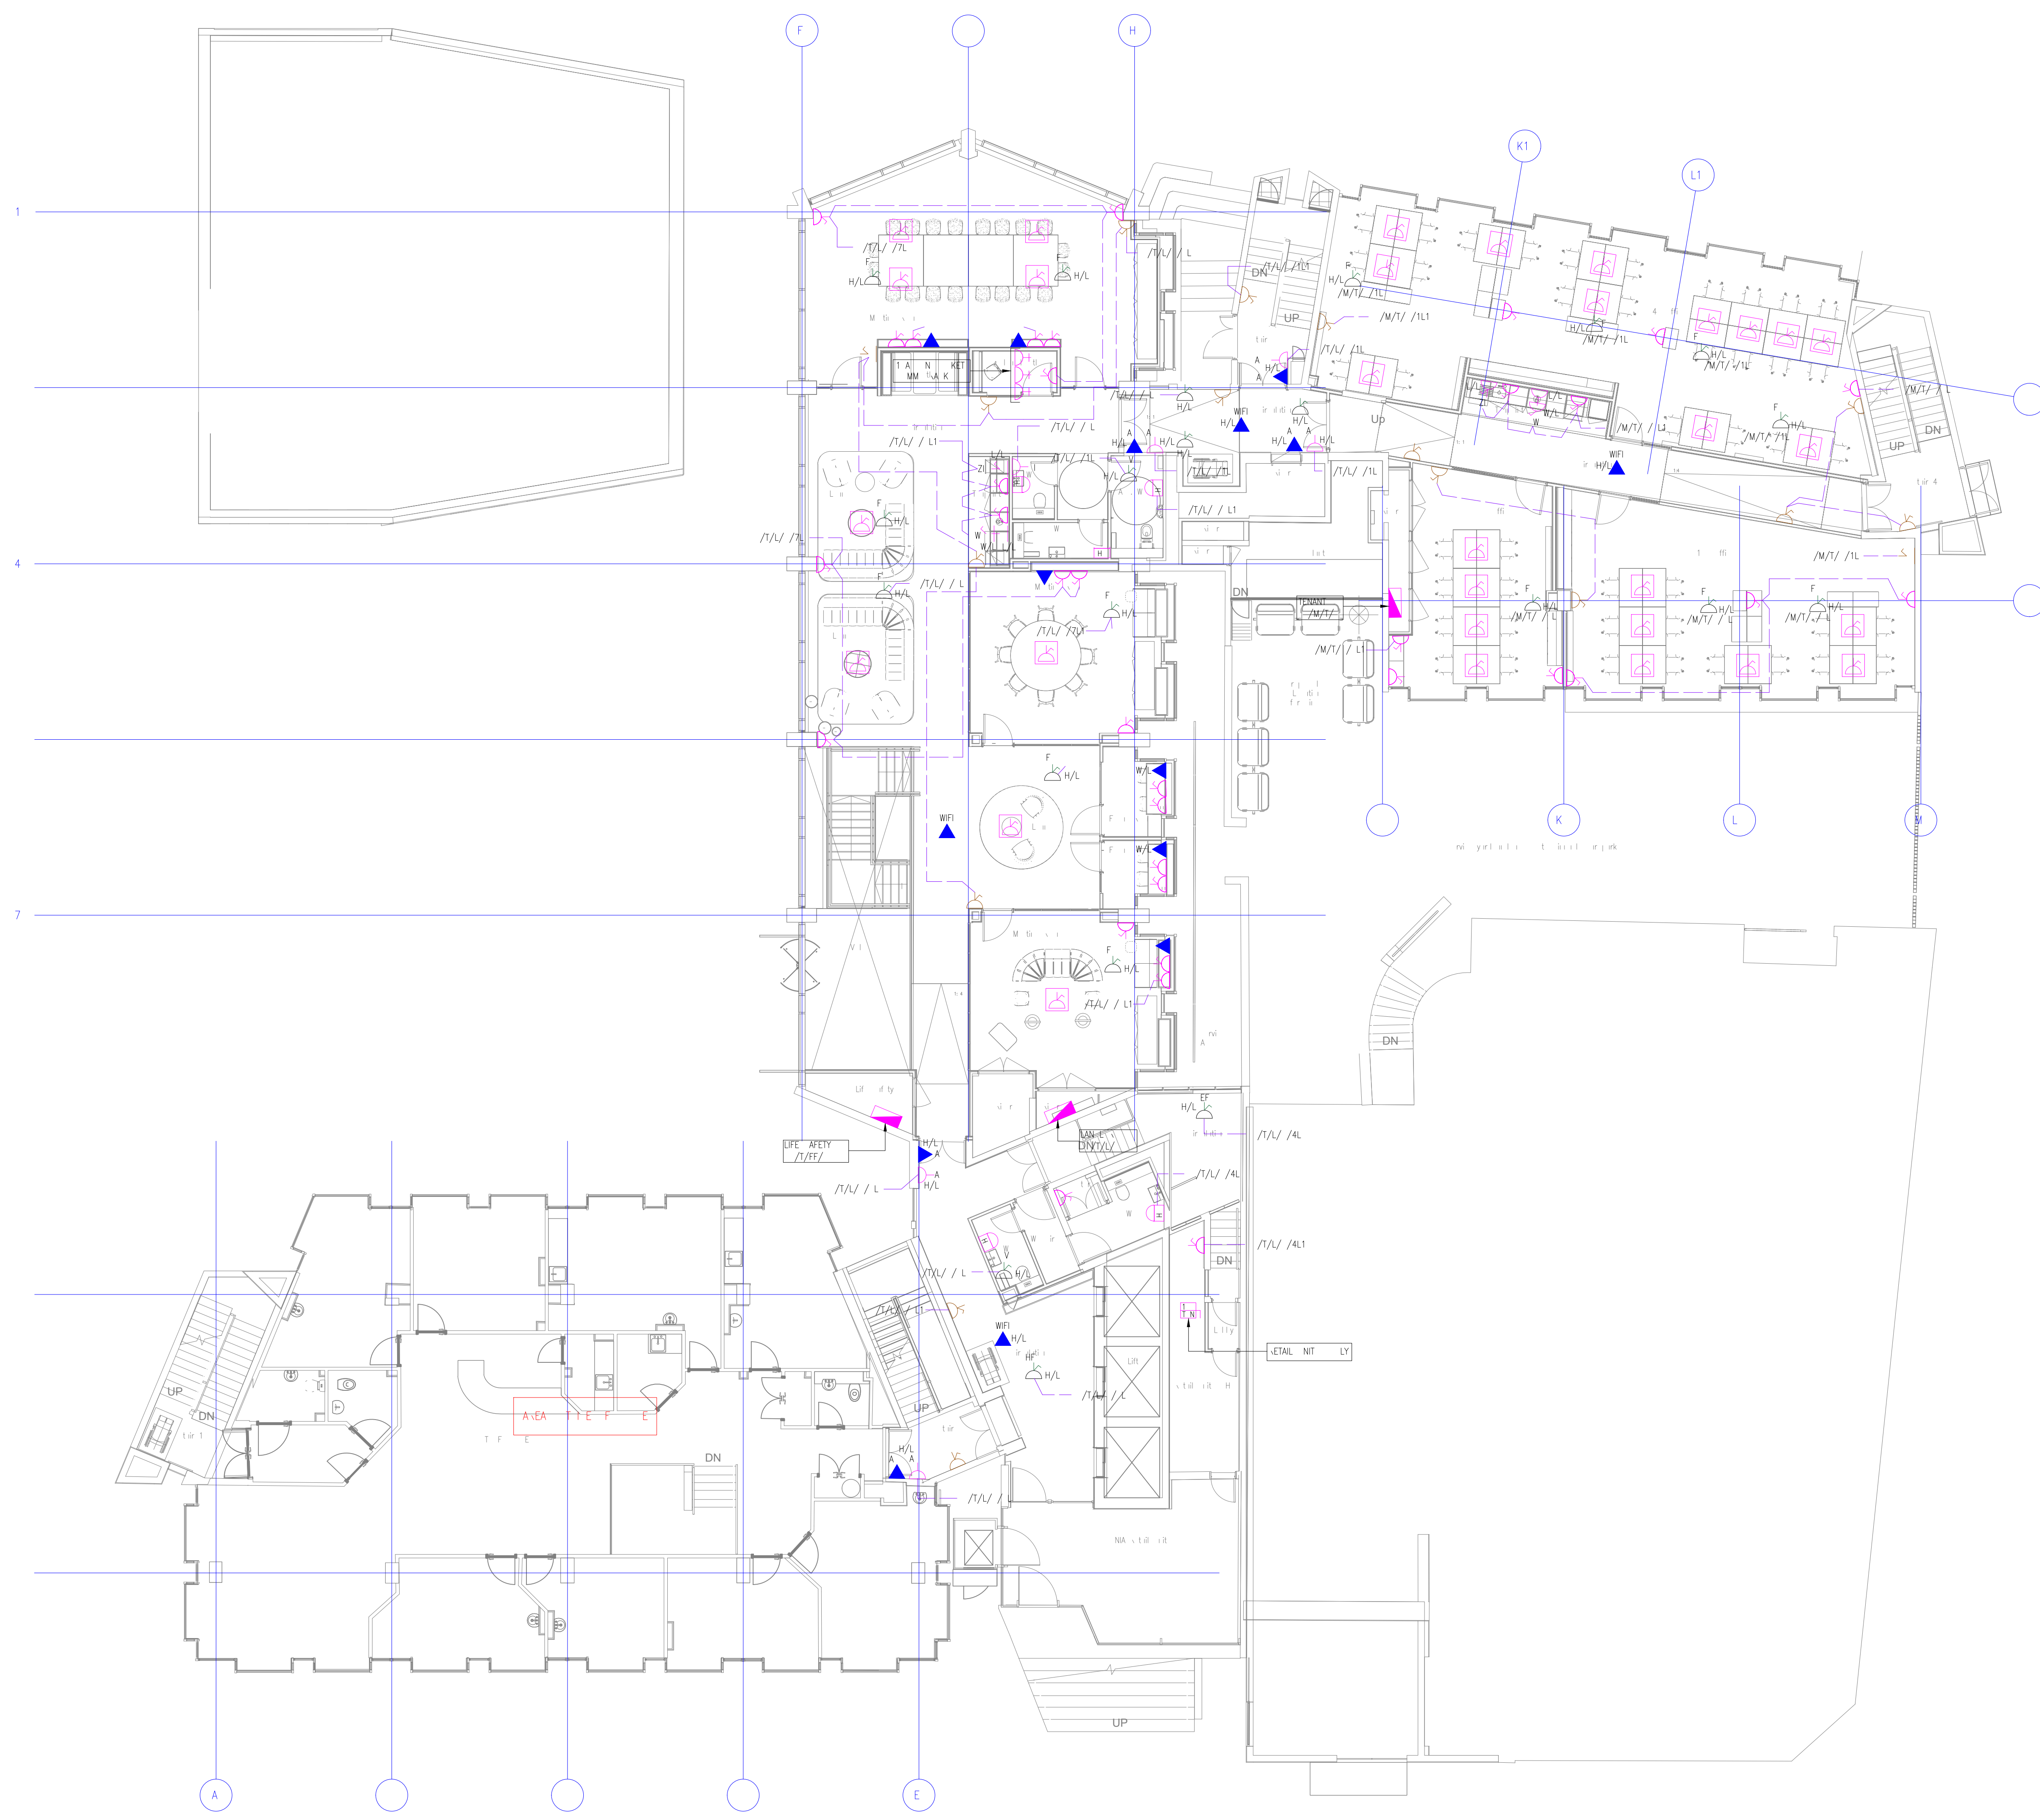

GENERAL NOTE

1. This drawing is a preliminary drawing and is not to be used for construction. All dimensions are given in millimeters and are to be checked on site and refer any discrepancies to Carter Electrical immediately.

MALL WE	
YM L	E J T I N
IN L A T = D E A N = N F L E	
IN L E A T A N T A T	
T W N W I T H E K E T T L E T	
N W I T H E N L E K E T T L E T	
N W I T H E T W N K E T T L E T	
4 M A J O R T M F L X X W I T H N T W N K E T T L E T L A T E 4 A N A T 4 A T A T L E T L A T E	
W I T H E F E	
W I T H E F E W I T H F L E X T L E T	
N W I T H E F E	
N W I T H E F E W I T H F L E X T L E T	
IN L E H A E N W I T H E N T A L K E T E N	
H A N Y E W I T H A V E	
H A E I T A T I N A	
IN L E W I T H E L E A N E K E T T L E T	
W I T H E F E N T L I N N L E K E T A T L W L E V E L F A L A N E	
W I T H E F E W I T H F L E X T L E T W E H A N A L I T E M	
REFERENCE	
TEXT	E J T I N
A	A T A N E L
A	A E N T L N I T
A F	A T F L H N I T
A T	A T D A N I T
	A N H N T L L E
M	I L I N M A N A E M E N T Y T E M
T V	L E I S I T T E L E V I N
I	I A L E A L A M
	I A L E E F E A N E L
	I A L E E F E E G A T E A N E L
W	I H W A H E
E F	E X T A T F A N
E H	E L E T A N E L H E A T E
E V	E M E N Y V I E W M N I A T I N N I T A N E L
F A	F I L E A L A M A N E L
F A	F I L E A L A M E G A T E A N E L
F	F A N I L N I T
H/L	H I H L E V E L
H	H E A T E V E Y N I T
L	L I H T I N N T L A N E L
L/L	L W L E V E L
A	L I A E A N E L
	E V L I N
E	E J T Y A N E L
E	E J T Y A N E L
V	L E N I V A L V E
W/I	W I E L E A E
W/L	W A K T L E V E L
ZI	Z I T A
	M N I N H E I H T
W	W E A T H E F T I

AMENITY	
1	1

PRELIMINARY

Unit 6, North Staffs Business Park,
Innovation Way, Staffs, ST49F
Email: info@carterelectrical.co.uk
Telephone: 01782 822550
www.carterelectrical.co.uk

Project:
**PALL MALL
MANCHESTER**

Task:
**GROUND FLOOR
SMALL POWER & DATA
LAYOUT**

Architect:
SHEPPARD ROBSON

Consultant:
RAMBOLL

Designer: PG Project: CB Date: 06.01.2023
Checker: MD Project Number: CESS61 Scale: 1:100
Drawing No: 6911-CES-XX-GF-DR-E-6202 Rev: 001

Copyright: Carter Electrical Services LTD
Contractors are to check all dimensions on site and refer any
discrepancies to Carter Electrical immediately.

1. I want that this is a law.
 . No possibility will let me see
 in front of the law by the. All
 I want to tell you, for fear
 I will not let it.



1	AMEN E	T	UMENT		K				
2	1	T	F						
3				0	0	0	0	0	0

BASED ON: 20099 Lower Ground Floor General Assemblage XREF CLEANED - P23
 Drawing Status:

PRELIMINARY



Unit 6, North Staffs Business Park,
 Incewath Way, Staffs ST14 4NF
 Email : info@staffsmedical.co.uk
 Telephone: 01827 822250
www.staffsmedical.co.uk






Project:

PALL MALL MANCHESTER

1st.

LOWER GROUND FLOOR

SMALL POWER & DATA

LAYOUT

SHEPPARD ROBSON
 RAMBOLL

Designer: PC	Project Manager: CB	DOB: PG	Checked: MD
Date: 06.01.2023	Project Number: CES561	Scale: 1:100	A0

Drawing No: 6911-CES-XX-LG-LR-E-6201

Copyright: Carter Electrical Services Ltd
 Contractors are to check all dimensions on site and refer any discrepancies to Carter Electrical immediately

No. 602

