



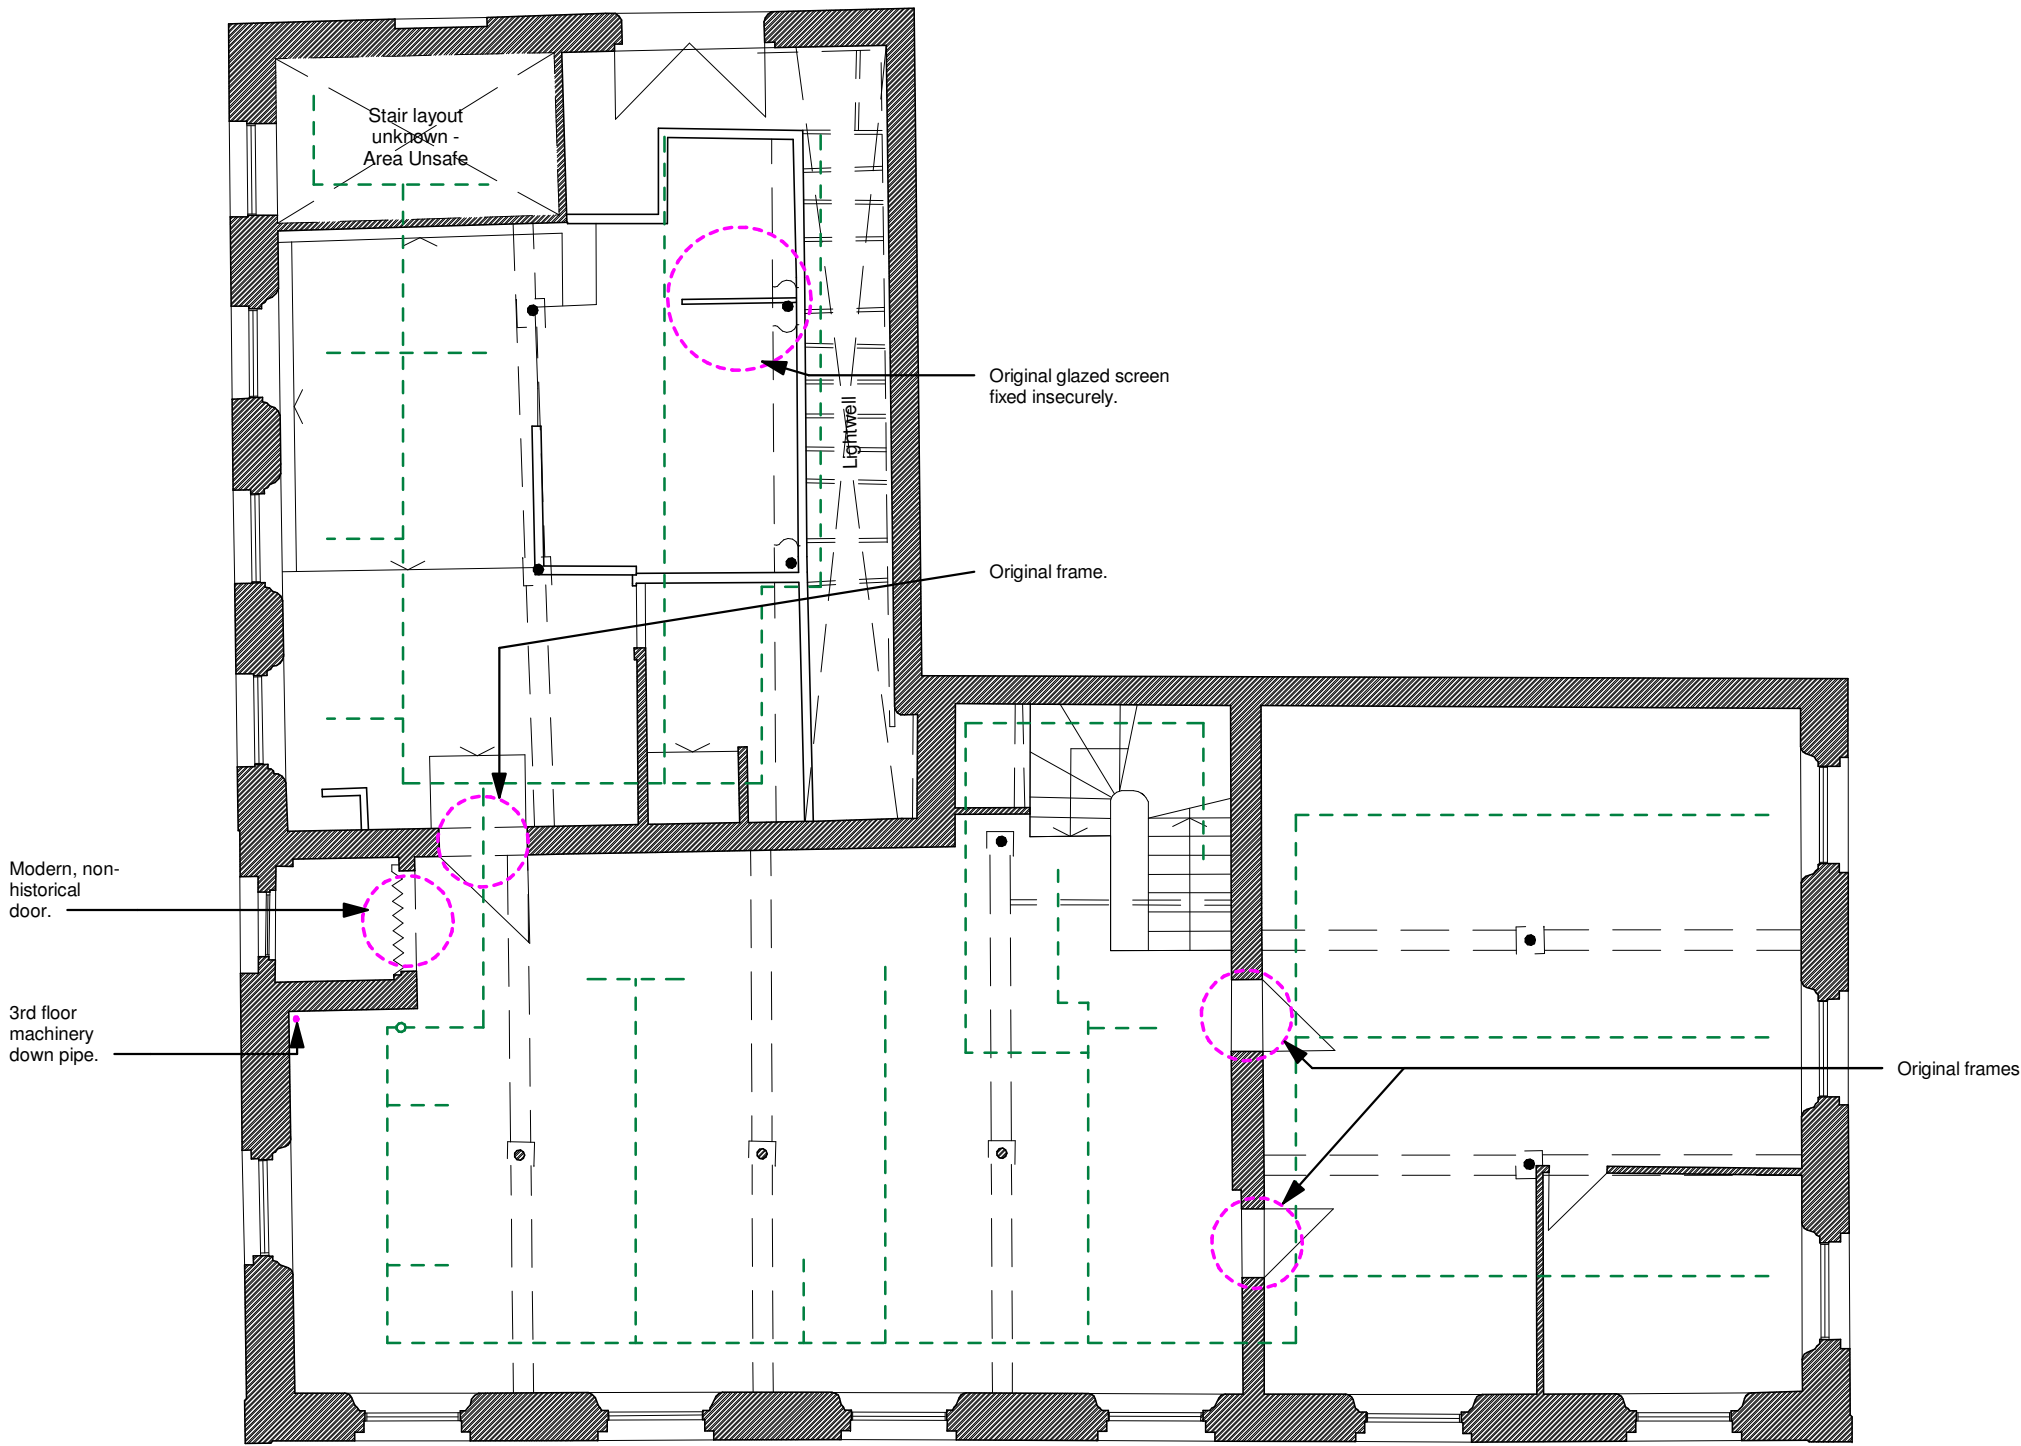

Existing 2nd Floor Plan

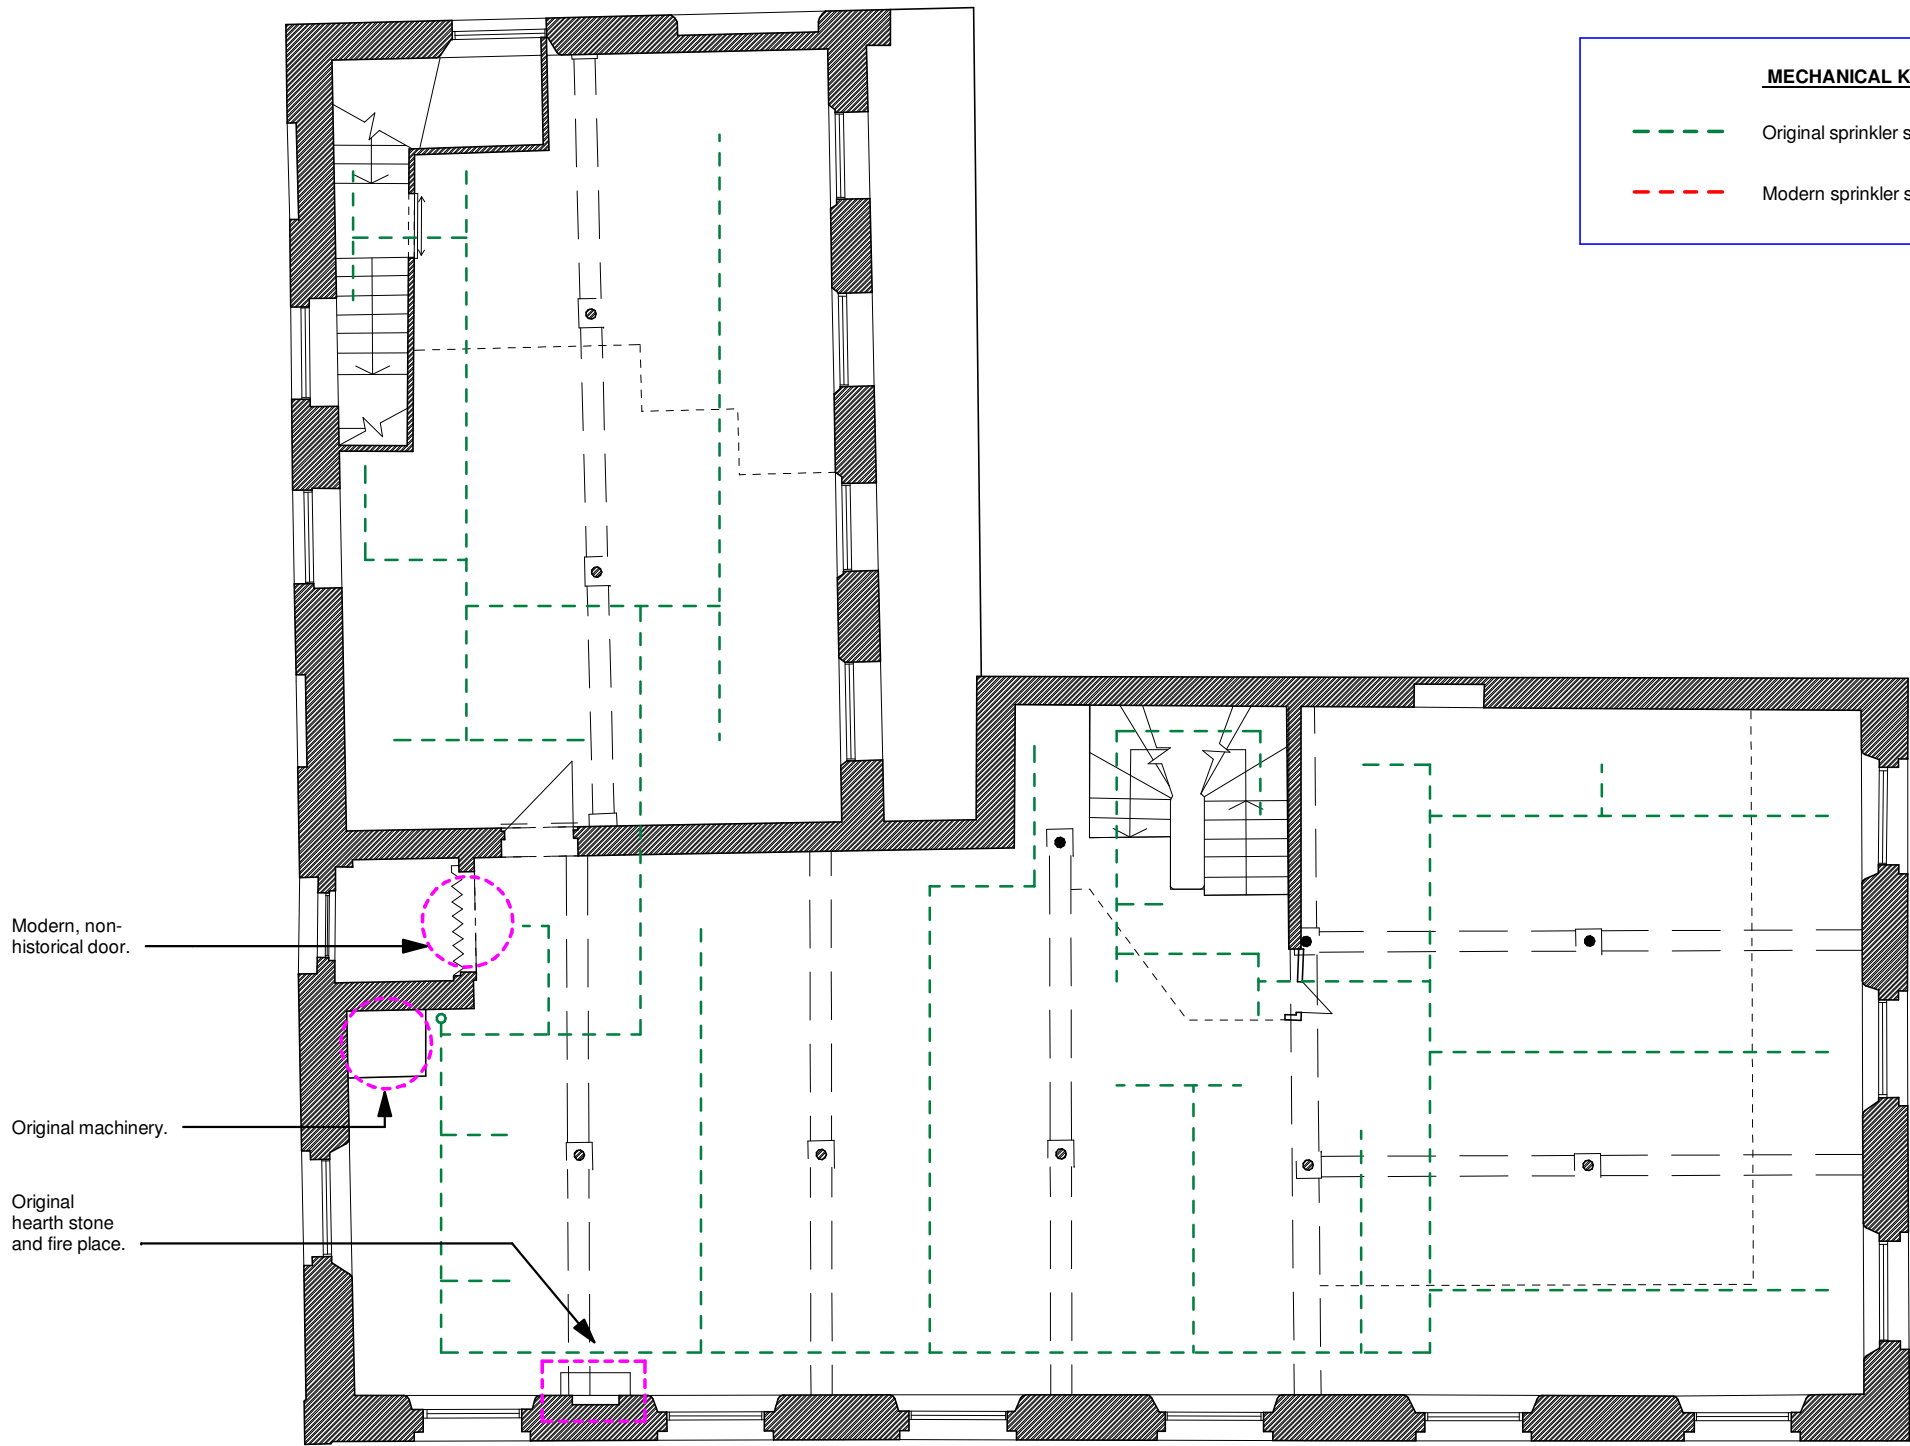

Existing 3rd Floor Plan

MECHANICAL KEY

- Original sprinkler system mains.
- Modern sprinkler system mains.

PARKdesigned
architects

Leeds: The Loft, 13 Carlton Mills, Armley, LS12 2QG	Tel: 0113 819 8057	
London: Hamilton House, Mabledon Place, Bloomsbury, WC1H 9BB	E-mail: info@parkdesigned.com	
Client:	Date:	Scale:
T&M Investment	March 2022	As indicated A1
Project Name:	Drawn:	Reviewed:
34 Charlotte Street	JAH	JAH
Drawing Title:	Drawing No:	Revision:
Existing Plans - Sheet 2	021	B
Drawing Status:	Project No:	
Preliminary	2022.04	