


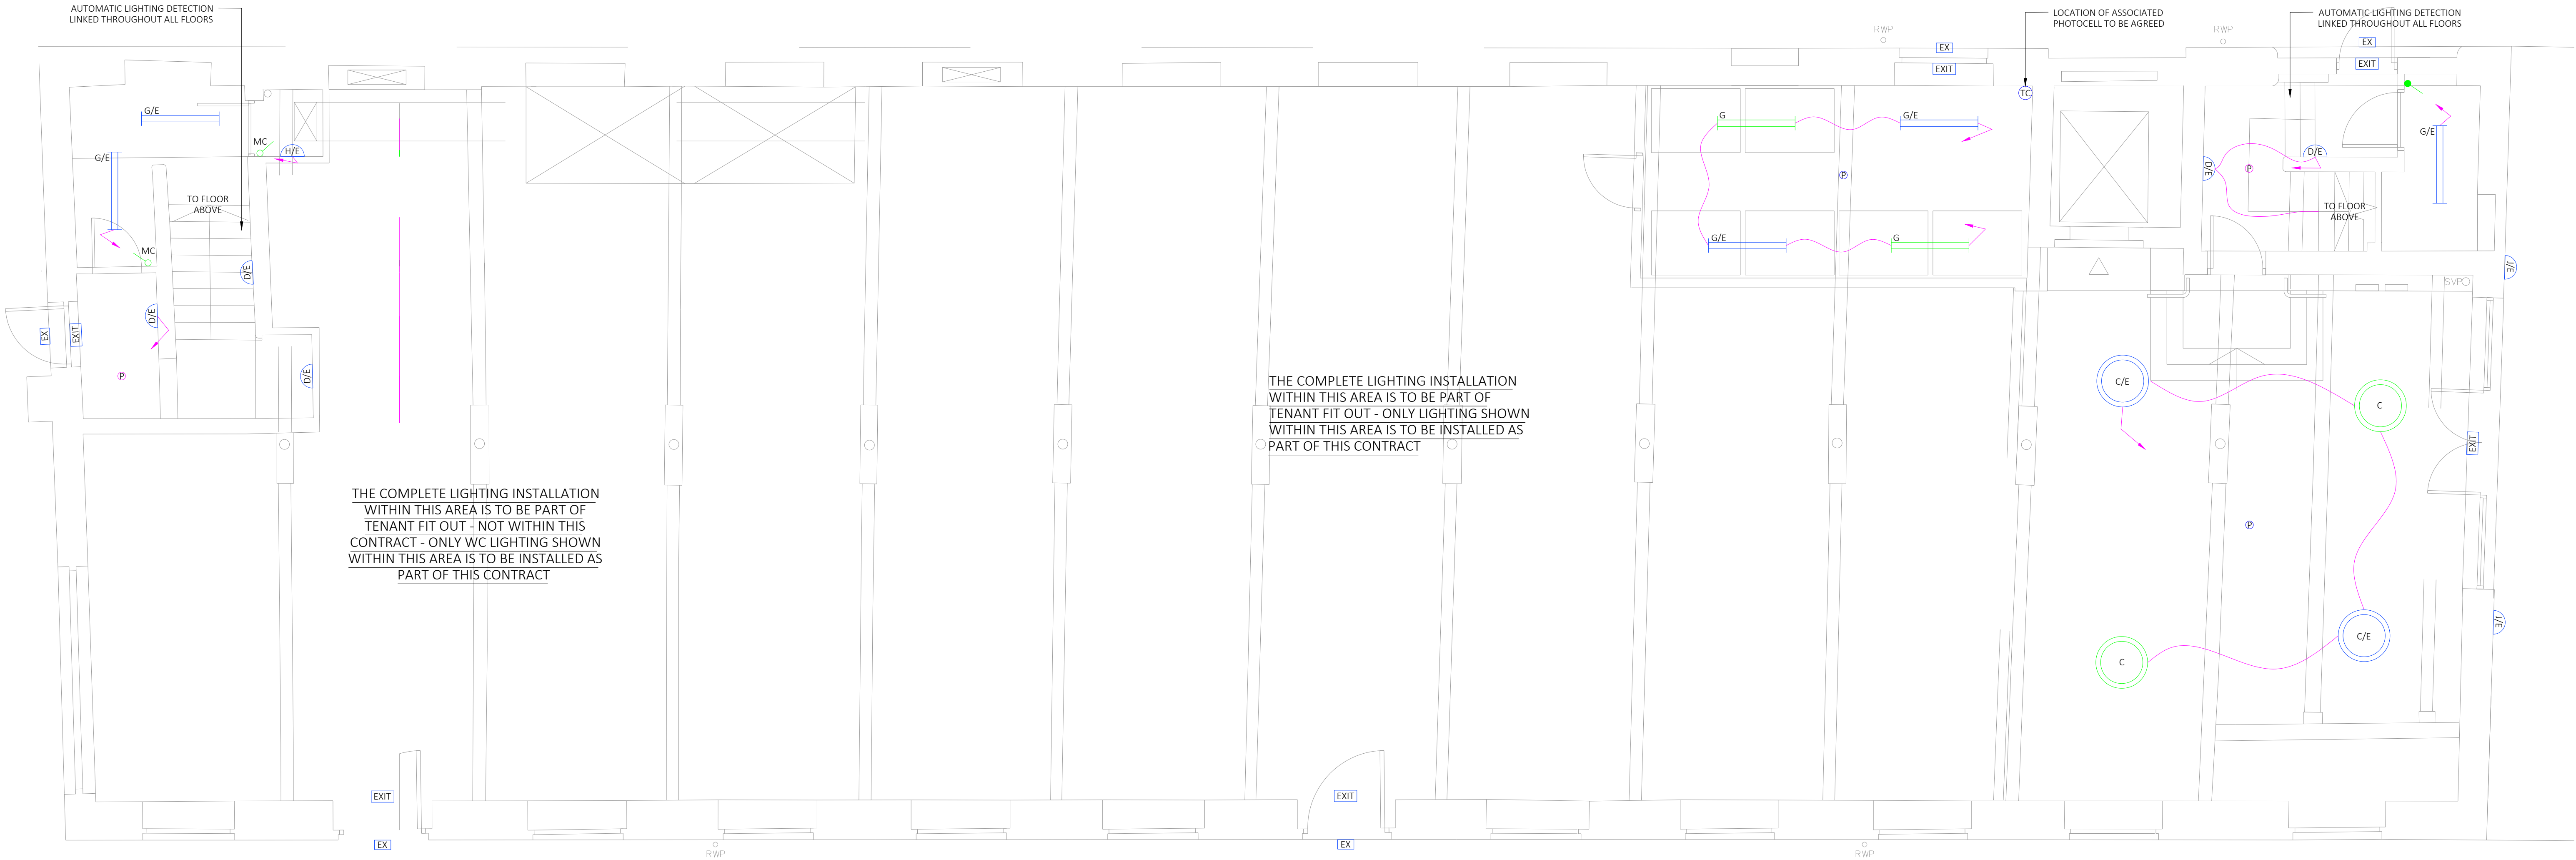

LIGHTING LEGEND

	SUSPENDED, 33W LED LINEAR UPWARD/DOWNWARD LIGHT LUMINAIRE WITH POLYCARBONATE DIFFUSER AS PER TAMLITE EDGE. 'E' DENOTES INTEGRAL EMERGENCY VERSION - BLACK FINISH. 4000K		SURFACE MOUNTED, EXTERNAL, 11W LED LUMINAIRE WITH OPAL DIFFUSER AS PER TAMLITE CITY WL T2. 'E' DENOTES INTEGRAL EMERGENCY VERSION - INTEGRAL PHOTOCELL - BLACK - 4000K		LIGHT SWITCH: G - DENOTES NUMBER OF GANGS 2 - DENOTES 2 WAY SWITCHING IP - DENOTES IP RATED D - DENOTES DIMMABLE
	SUSPENDED, 33W LED LINEAR UPWARD/DOWNWARD LIGHT LUMINAIRE WITH POLYCARBONATE DIFFUSER AS PER TAMLITE SIGNUM D. 'E' DENOTES INTEGRAL EMERGENCY VERSION - BLACK FINISH. 4000K - DALI		SURFACE MOUNTED, 9W LED LUMINAIRE AS PER TAMLITE ATHENS. WHITE IN FINISH - 3000K		RECESSED/SURFACE MOUNTED AUTOMATIC LIGHTING DETECTOR - WHITE IN FINISH M - DENOTES LONG RANGE MICROWAVE DETECTION P - DENOTES PRESENCE DETECTION
	SUSPENDED, 89W LED CIRCULAR DECORATIVE LUMINAIRE WITH OPAL DIFFUSER AS PER TAMLITE AIR. 'E' DENOTES INTEGRAL EMERGENCY VERSION - BLACK FINISH. 4000K - DALI		RECESSED MOUNTED, 20W LED DOWNLIGHT LUMINAIRE WITH OPAL POLYCARBONATE DIFFUSER AS PER TAMLITE IKON S. 'E' DENOTES INTEGRAL EMERGENCY VERSION - WHITE - 4000K		SURFACE MOUNTED LED DIRECTIONAL EXIT LUMINAIRE AS PER TAMLITE ELITE EB
	SURFACE MOUNTED, LARGE, 25W LED CIRCULAR DECORATIVE LUMINAIRE WITH OPAL POLYCARBONATE DIFFUSER, HALO BACKLIT AS PER TAMLITE SOLAR. 'E' DENOTES INTEGRAL EMERGENCY VERSION - WHITE WITH SATIN TRIM FINISH. 4000K		SUSPENDED MOUNTED, 38W LED LUMINAIRE WITH OPAL DIFFUSER AS PER TAMLITE OLYMPIAN. 'E' DENOTES INTEGRAL EMERGENCY VERSION - WHITE - 4000K		FINAL EXIT EMERGENCY LED BULKHEAD LUMINAIRE AS PER TAMLITE ELITE EB
	RECESSED MOUNTED, 20W LED DOWNLIGHT LUMINAIRE WITH OPAL POLYCARBONATE DIFFUSER AS PER TAMLITE ASTRO. 'E' DENOTES INTEGRAL EMERGENCY VERSION - WHITE - 4000K		SUSPENDED MOUNTED, 22W LED LUMINAIRE WITH OPAL DIFFUSER AS PER TAMLITE OLYMPIAN - WHITE - 4000K		EXTERNAL LED EMERGENCY EXIT LUMINAIRE AS PER TAMLITE ELITE BH
	SURFACE MOUNTED, 28W LED LINEAR LUMINAIRE WITH OPAL DIFFUSER AS PER TAMLITE PRIMA. 'E' DENOTES INTEGRAL EMERGENCY VERSION - WHITE - 4000K		SURFACE MOUNTED, TRACK LIGHT (TRIO) LED LUMINAIRES AS PER TAMLITE SONATA RANGE - BLACK - 3000K - DALI		LIGHTING CONNECTION POINT, PHOTOCELL & TIMECLOCK FOR EXTERNAL SIGNAGE
	SURFACE MOUNTED, 20W LED LUMINAIRE WITH OPAL DIFFUSER AS PER TAMLITE MERIDIAN. 'E' DENOTES INTEGRAL EMERGENCY VERSION - WHITE - 4000K		SURFACE MOUNTED, LED TAPE AS PER TAMLITE FX LED - 3000K - DALI - IP65		

Notes:

- This drawing is subject to copyright and is not to be reproduced in part or whole without approval.
- Do not scale this drawing - check all dimensions on site.
- This drawing shall be read in conjunction with the project specification(s) and all other contract documentation.
- All dimensions are in millimetres unless otherwise stated.
- Location of all equipment shown shall be confirmed/approved with the Client/Architect/Engineer prior to any installation.
- This drawing must be read in conjunction with Mechanical and Electrical performance specifications and all other drawings as issued by the Architect, Structural Engineer and Watt Energy and Consulting Engineers.
- The location of equipment is typical only. The Contractor shall perform all calculations to determine the exact quantity and agree the final locations with the Architect.
- This drawing shows the intended location of building services plant and service routes in such detail as to indicate the design. The drawing does not show all components that may be necessary to provide a full working installation.
- The positions of connection points, accessories and building services items are approximate and shown for guidance to assist during the tender process.
- Fully co-ordinated drawings, Construction drawings and Builderswork drawings shall be produced by the contractor. Under no circumstances shall the tender drawings be used as installation drawings.

WE&CE DRAWINGS ARE FOR DESIGN INTENT ONLY.
THE MEP CONTRACTOR IS RESPONSIBLE FOR THE
FINAL INSTALLATION DRAWINGS INCLUDING ALL
SETTING OUT, DIMENSIONS, ALIGNMENT AND
COORDINATION WITH THE ARCHITECTS
REQUIREMENTS.

T1	11/04/23	TENDER ISSUE	DK
P2	24/03/23	PRELIMINARY ISSUE	NJF
P1	10/03/23	PRELIMINARY ISSUE	NJF
Rev:	Date:	Status/Amendments:	By:




40 KING STREET, MANCHESTER, M2 6BA
TEL: 0161 434 3103 EMAIL: office@wece.co.uk

Client:
CAPITAL AND CENTRIC

Project:
CHAPELTOWN WAREHOUSE

Drawing Title:
ELECTRICAL SERVICES
LIGHTING LAYOUT
GROUND FLOOR

Drawn By: NJF	Checked By: DW	Cad By: DK
Scale: 1:50	Paper Size: A1	Date Created: 15/02/2023
Drawing Number: WECE / 353 / E / 100	Drawing Revision: T1	

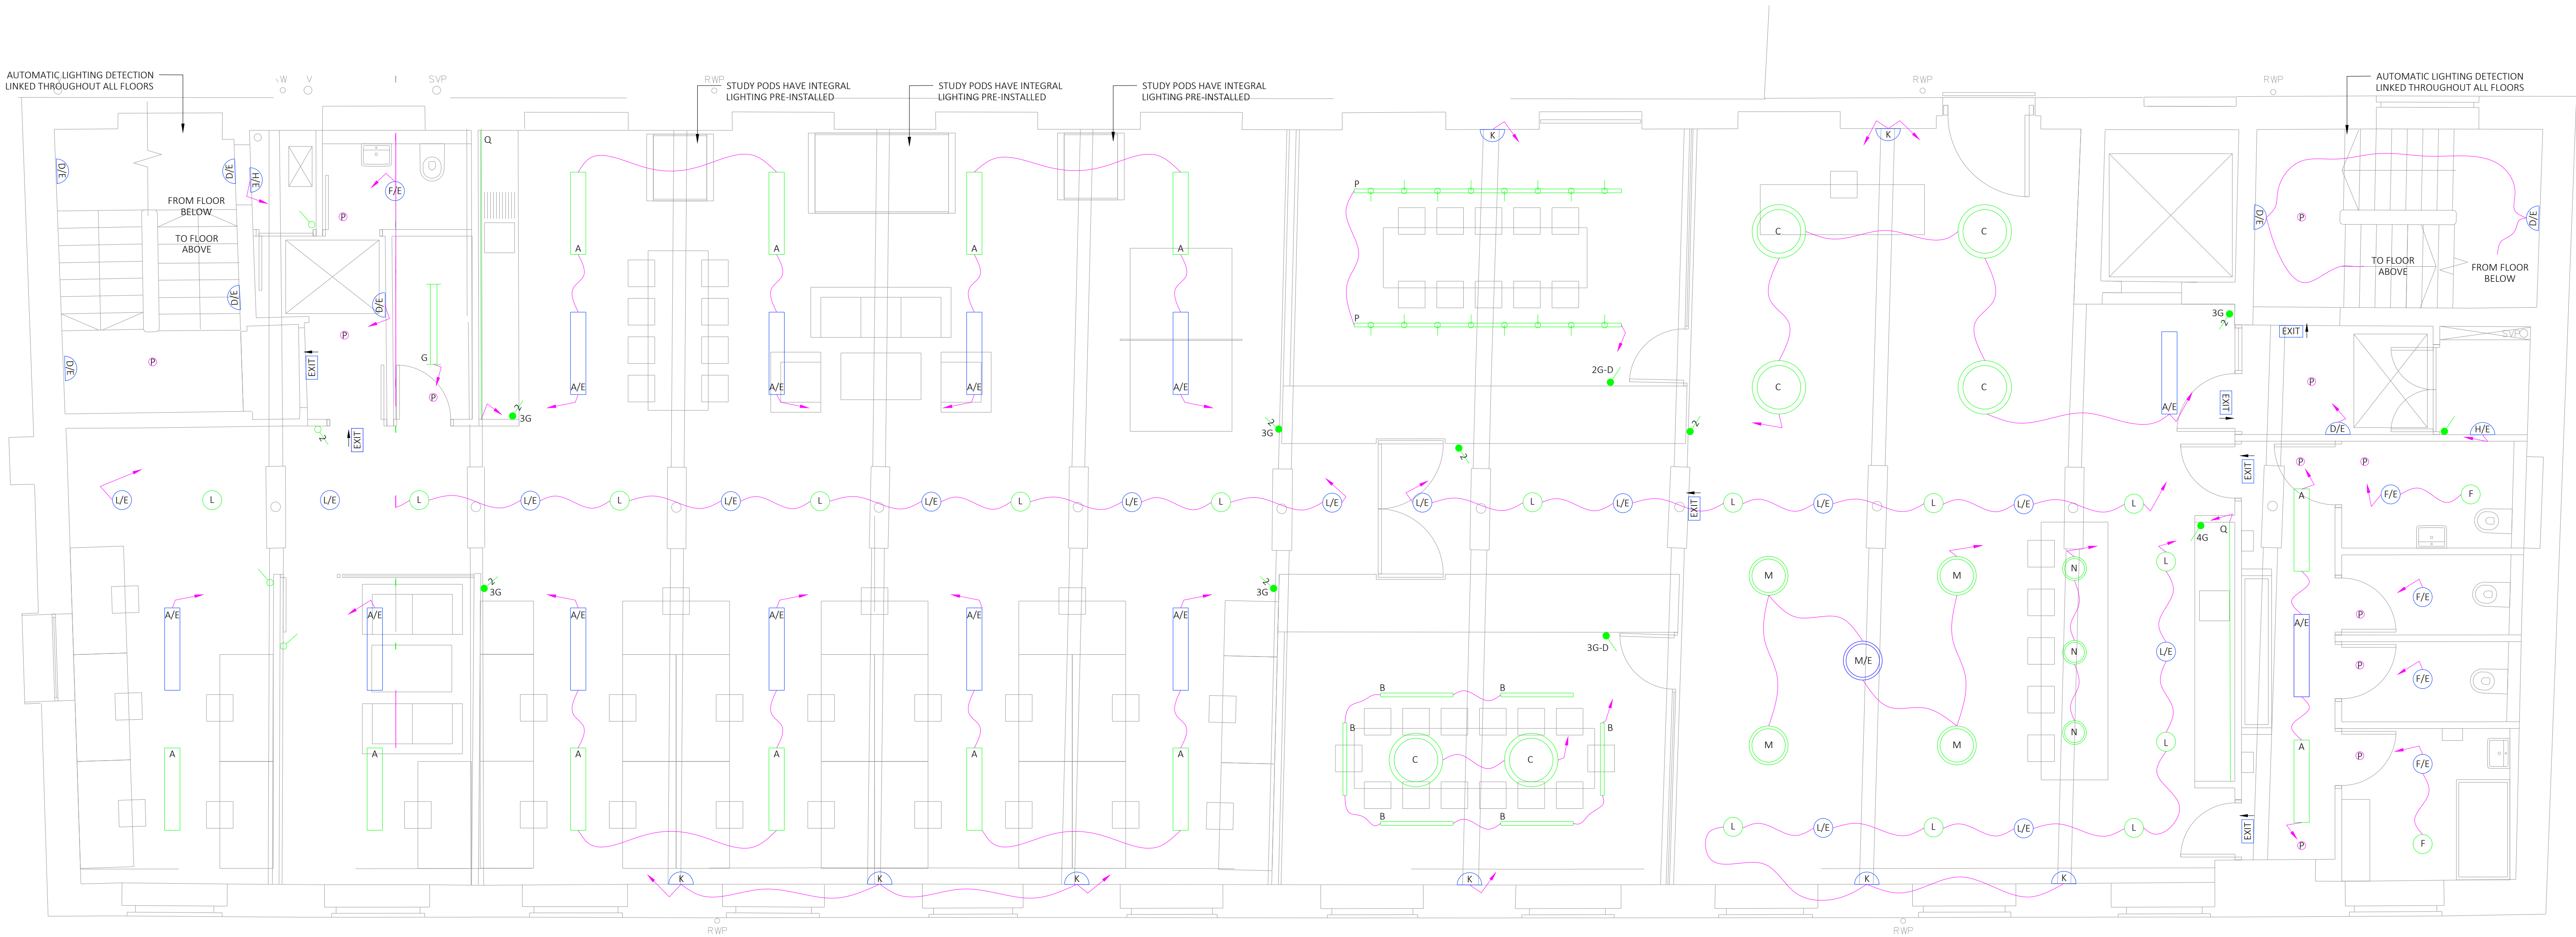

LIGHTING LEGEND

	SUSPENDED, 33W LED LINEAR UPWARD/DOWNWARD LIGHT LUMINAIRE WITH POLYCARBONATE DIFFUSER AS PER TAMLITE EDGE. 'E' DENOTES INTEGRAL EMERGENCY VERSION - BLACK FINISH. 4000K		SURFACE MOUNTED, EXTERNAL, 11W LED LUMINAIRE WITH OPAL DIFFUSER AS PER TAMLITE CITY WL T2. 'E' DENOTES INTEGRAL EMERGENCY VERSION - INTEGRAL PHOTOCELL - BLACK - 4000K		LIGHT SWITCH: G - DENOTES NUMBER OF GANGS 2 - DENOTES 2 WAY SWITCHING IP - DENOTES IP RATED D - DENOTES DIMMABLE
	SUSPENDED, 33W LED LINEAR UPWARD/DOWNWARD LIGHT LUMINAIRE WITH POLYCARBONATE DIFFUSER AS PER TAMLITE SIGNUM O. 'E' DENOTES INTEGRAL EMERGENCY VERSION - BLACK FINISH. 4000K - DALI		SURFACE MOUNTED, 9W LED LUMINAIRE AS PER TAMLITE ATHENS. WHITE IN FINISH - 3000K		RECESSED/SURFACE MOUNTED AUTOMATIC LIGHTING DETECTOR - WHITE IN FINISH M - DENOTES LONG RANGE MICROWAVE DETECTION P - DENOTES PRESENCE DETECTION
	SUSPENDED, 89W LED CIRCULAR DECORATIVE LUMINAIRE WITH OPAL DIFFUSER AS PER TAMLITE AIR. 'E' DENOTES INTEGRAL EMERGENCY VERSION - BLACK FINISH. 4000K - DALI		RECESSED MOUNTED, 20W LED DOWNLIGHT LUMINAIRE WITH OPAL POLYCARBONATE DIFFUSER AS PER TAMLITE IKON S. 'E' DENOTES INTEGRAL EMERGENCY VERSION - WHITE - 4000K		SURFACE MOUNTED LED DIRECTIONAL EXIT LUMINAIRE AS PER TAMLITE ELITE EB
	SURFACE MOUNTED, LARGE, 25W LED CIRCULAR DECORATIVE LUMINAIRE WITH OPAL POLYCARBONATE DIFFUSER, HALO BACKLIT AS PER TAMLITE SOLAR. 'E' DENOTES INTEGRAL EMERGENCY VERSION - WHITE WITH SATIN TRIM FINISH. 4000K		SUSPENDED MOUNTED, 38W LED LUMINAIRE WITH OPAL DIFFUSER AS PER TAMLITE OLYMPIAN. 'E' DENOTES INTEGRAL EMERGENCY VERSION - WHITE - 4000K		FINAL EXIT EMERGENCY LED BULKHEAD LUMINAIRE AS PER TAMLITE ELITE EB
	RECESSED MOUNTED, 20W LED DOWNLIGHT LUMINAIRE WITH OPAL POLYCARBONATE DIFFUSER AS PER TAMLITE ASTRO. 'E' DENOTES INTEGRAL EMERGENCY VERSION - WHITE - 4000K		SUSPENDED MOUNTED, 22W LED LUMINAIRE WITH OPAL DIFFUSER AS PER TAMLITE OLYMPIAN - WHITE - 4000K		EXTERNAL LED EMERGENCY EXIT LUMINAIRE AS PER TAMLITE ELITE BH
	SURFACE MOUNTED, 28W LED LINEAR LUMINAIRE WITH OPAL DIFFUSER AS PER TAMLITE PRIMA. 'E' DENOTES INTEGRAL EMERGENCY VERSION - WHITE - 4000K		SURFACE MOUNTED, TRACK LIGHT (TRIO) LED LUMINAIRES AS PER TAMLITE SONATA RANGE - BLACK - 3000K - DALI		LIGHTING CONNECTION POINT, PHOTOCELL & TIMECLOCK FOR EXTERNAL SIGNAGE
	SURFACE MOUNTED, 20W LED LUMINAIRE WITH OPAL DIFFUSER AS PER TAMLITE MERIDIAN. 'E' DENOTES INTEGRAL EMERGENCY VERSION - WHITE - 4000K		SURFACE MOUNTED, LED TAPE AS PER TAMLITE FX LED - 3000K - DALI - IP65		

Notes:

- This drawing is subject to copyright and is not to be reproduced in part or whole without approval.
- Do not scale this drawing - check all dimensions on site.
- This drawing shall be read in conjunction with the project specification(s) and all other contract documentation.
- All dimensions are in millimetres unless otherwise stated.
- Location of all equipment shown shall be confirmed/approved with the Client/Architect/Engineer prior to any installation.
- This drawing must be read in conjunction with Mechanical and Electrical performance specifications and all other drawings as issued by the Architect, Structural Engineer and Watt Energy and Consulting Engineers.
- The location of equipment is typical only. The Contractor shall perform all calculations to determine the exact quantity and agree the final locations with the Architect.
- This drawing shows the intended location of building services plant and service routes in such detail as to indicate the design. The drawing does not show all components that may be necessary to provide a full working installation.
- The positions of connection points, accessories and building services items are approximate and shown for guidance to assist during the tender process.
- Fully co-ordinated drawings, Construction drawings and Builderswork drawings shall be produced by the contractor. Under no circumstances shall the tender drawings be used as installation drawings.

WE&CE DRAWINGS ARE FOR DESIGN INTENT ONLY.
THE MEP CONTRACTOR IS RESPONSIBLE FOR THE
FINAL INSTALLATION DRAWINGS INCLUDING ALL
SETTING OUT, DIMENSIONS, ALIGNMENT AND
COORDINATION WITH THE ARCHITECTS
REQUIREMENTS.

T1	11/04/23	TENDER ISSUE	DK
P2	24/03/23	PRELIMINARY ISSUE	NJF
P1	10/03/23	PRELIMINARY ISSUE	NJF
Rev:	Date:	Status/Amendments:	By:




40 KING STREET, MANCHESTER, M2 6BA
TEL: 0161 434 3103 EMAIL: office@wece.co.uk

Client:
CAPITAL AND CENTRIC

Project:
CHAPELTOWN WAREHOUSE

Drawing Title:
ELECTRICAL SERVICES
LIGHTING LAYOUT
FIRST FLOOR

Drawn By: NJF	Checked By: DW	Cad By: DK
Scale: 1:50	Paper Size: A1	Date Created: 15/02/2023
Drawing Number: WECE / 353 / E / 101	Drawing Revision: T1	

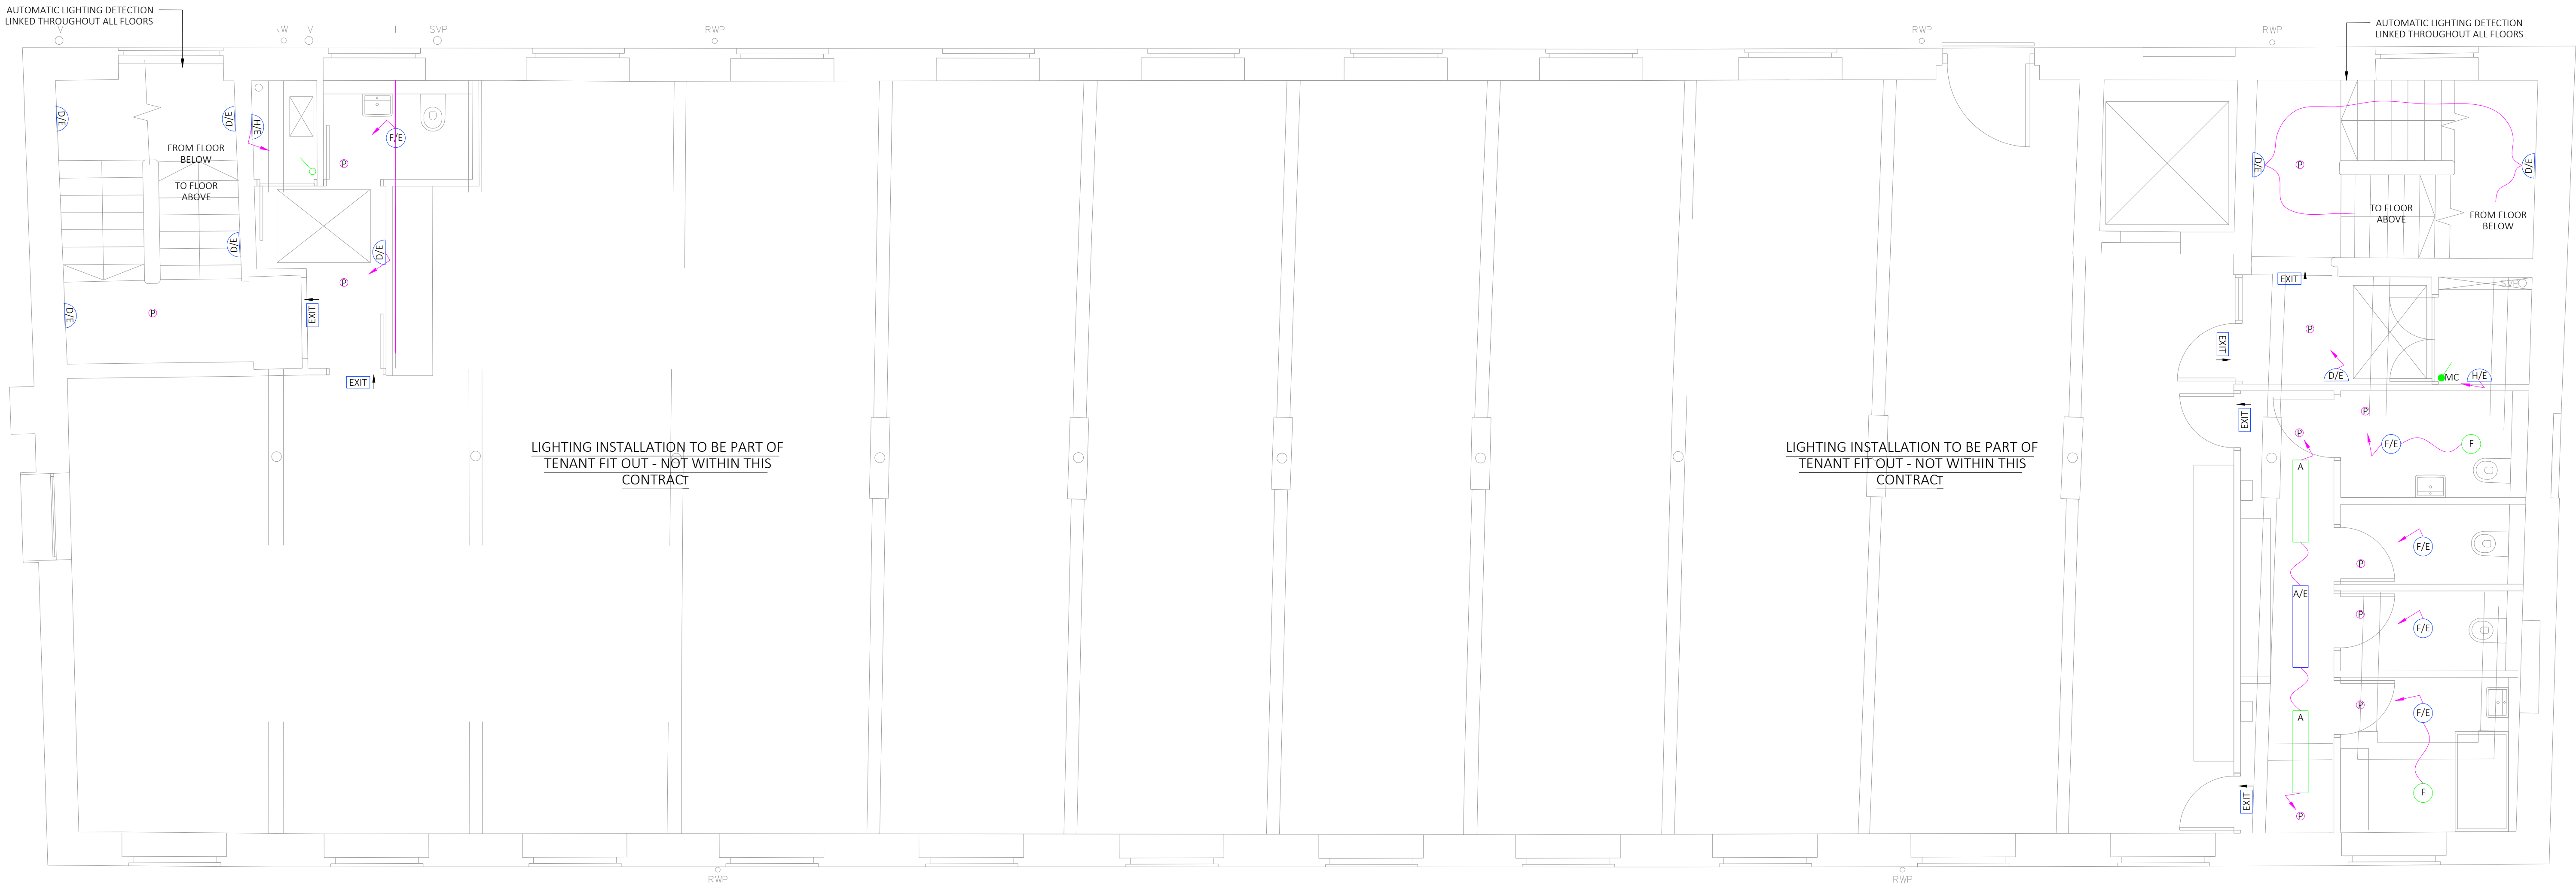

LIGHTING LEGEND

	SUSPENDED, 33W LED LINEAR UPWARD/DOWNWARD LIGHT LUMINAIRE WITH POLYCARBONATE DIFFUSER AS PER TAMLITE EDGE. 'E' DENOTES INTEGRAL EMERGENCY VERSION - BLACK FINISH. 4000K		SURFACE MOUNTED, EXTERNAL, 11W LED LUMINAIRE WITH OPAL DIFFUSER AS PER TAMLITE CITY WL T2. 'E' DENOTES INTEGRAL EMERGENCY VERSION - INTEGRAL PHOTOCELL - BLACK - 4000K		LIGHT SWITCH: G - DENOTES NUMBER OF GANGS 2 - DENOTES 2 WAY SWITCHING IP - DENOTES IP RATED D - DENOTES DIMMABLE
	SUSPENDED, 33W LED LINEAR UPWARD/DOWNWARD LIGHT LUMINAIRE WITH POLYCARBONATE DIFFUSER AS PER TAMLITE SIGNUM D. 'E' DENOTES INTEGRAL EMERGENCY VERSION - BLACK FINISH. 4000K - DALI		SURFACE MOUNTED, 9W LED LUMINAIRE AS PER TAMLITE ATHENS. WHITE IN FINISH - 3000K		RECESSED/SURFACE MOUNTED AUTOMATIC LIGHTING DETECTOR - WHITE IN FINISH M - DENOTES LONG RANGE MICROWAVE DETECTION P - DENOTES PRESENCE DETECTION
	SUSPENDED, 89W LED CIRCULAR DECORATIVE LUMINAIRE WITH OPAL DIFFUSER AS PER TAMLITE AIR. 'E' DENOTES INTEGRAL EMERGENCY VERSION - BLACK FINISH. 4000K - DALI		RECESSED MOUNTED, 20W LED DOWNLIGHT LUMINAIRE WITH OPAL POLYCARBONATE DIFFUSER AS PER TAMLITE IKON S. 'E' DENOTES INTEGRAL EMERGENCY VERSION - WHITE - 4000K		SURFACE MOUNTED LED DIRECTIONAL EXIT LUMINAIRE AS PER TAMLITE ELITE EB
	SURFACE MOUNTED, LARGE, 25W LED CIRCULAR DECORATIVE LUMINAIRE WITH OPAL POLYCARBONATE DIFFUSER, HALO BACKLIT AS PER TAMLITE SOLAR. 'E' DENOTES INTEGRAL EMERGENCY VERSION - WHITE WITH SATIN TRIM FINISH. 4000K		SUSPENDED MOUNTED, 38W LED LUMINAIRE WITH OPAL DIFFUSER AS PER TAMLITE OLYMPIAN. 'E' DENOTES INTEGRAL EMERGENCY VERSION - WHITE - 4000K		FINAL EXIT EMERGENCY LED BULKHEAD LUMINAIRE AS PER TAMLITE ELITE EB
	RECESSED MOUNTED, 20W LED DOWNLIGHT LUMINAIRE WITH OPAL POLYCARBONATE DIFFUSER AS PER TAMLITE ASTRO. 'E' DENOTES INTEGRAL EMERGENCY VERSION - WHITE - 4000K		SUSPENDED MOUNTED, 22W LED LUMINAIRE WITH OPAL DIFFUSER AS PER TAMLITE OLYMPIAN - WHITE - 4000K		EXTERNAL LED EMERGENCY EXIT LUMINAIRE AS PER TAMLITE ELITE BH
	SURFACE MOUNTED, 28W LED LINEAR LUMINAIRE WITH OPAL DIFFUSER AS PER TAMLITE PRIMA. 'E' DENOTES INTEGRAL EMERGENCY VERSION - WHITE - 4000K		SURFACE MOUNTED, TRACK LIGHT (TRIO) LED LUMINAIRES AS PER TAMLITE SONATA RANGE - BLACK - 3000K - DALI		LIGHTING CONNECTION POINT, PHOTOCELL & TIMECLOCK FOR EXTERNAL SIGNAGE
	SURFACE MOUNTED, 20W LED LUMINAIRE WITH OPAL DIFFUSER AS PER TAMLITE MERIDIAN. 'E' DENOTES INTEGRAL EMERGENCY VERSION - WHITE - 4000K		SURFACE MOUNTED, LED TAPE AS PER TAMLITE FX LED - 3000K - DALI - IP65		

Notes:

- This drawing is subject to copyright and is not to be reproduced in part or whole without approval.
- Do not scale this drawing - check all dimensions on site.
- This drawing shall be read in conjunction with the project specification(s) and all other contract documentation.
- All dimensions are in millimetres unless otherwise stated.
- Location of all equipment shown shall be confirmed/approved with the Client/Architect/Engineer prior to any installation.
- This drawing must be read in conjunction with Mechanical and Electrical performance specifications and all other drawings as issued by the Architect, Structural Engineer and Watt Energy and Consulting Engineers.
- The location of equipment is typical only. The Contractor shall perform all calculations to determine the exact quantity and agree the final locations with the Architect.
- This drawing shows the intended location of building services plant and service routes in such detail as to indicate the design. The drawing does not show all components that may be necessary to provide a full working installation.
- The positions of connection points, accessories and building services items are approximate and shown for guidance to assist during the tender process.
- Fully co-ordinated drawings, Construction drawings and Builderswork drawings shall be produced by the contractor. Under no circumstances shall the tender drawings be used as installation drawings.

WE&CE DRAWINGS ARE FOR DESIGN INTENT ONLY.
THE MEP CONTRACTOR IS RESPONSIBLE FOR THE
FINAL INSTALLATION DRAWINGS INCLUDING ALL
SETTING OUT, DIMENSIONS, ALIGNMENT AND
COORDINATION WITH THE ARCHITECTS
REQUIREMENTS.

T1	11/04/23	TENDER ISSUE	DK
P2	24/03/23	PRELIMINARY ISSUE	NJF
P1	10/03/23	PRELIMINARY ISSUE	NJF
Rev:	Date:	Status/Amendments:	By:




40 KING STREET, MANCHESTER, M2 6BA
TEL: 0161 434 3103 EMAIL: office@wece.co.uk

Client:
CAPITAL AND CENTRIC

Project:
CHAPELTOWN WAREHOUSE

Drawing Title:
ELECTRICAL SERVICES
LIGHTING LAYOUT
SECOND FLOOR

Drawn By: NJF	Checked By: DW	Cad By: DK
Scale: 1:50	Paper Size: A1	Date Created: 15/02/2023
Drawing Number: WECE / 353 / E / 102	Drawing Revision: T1	

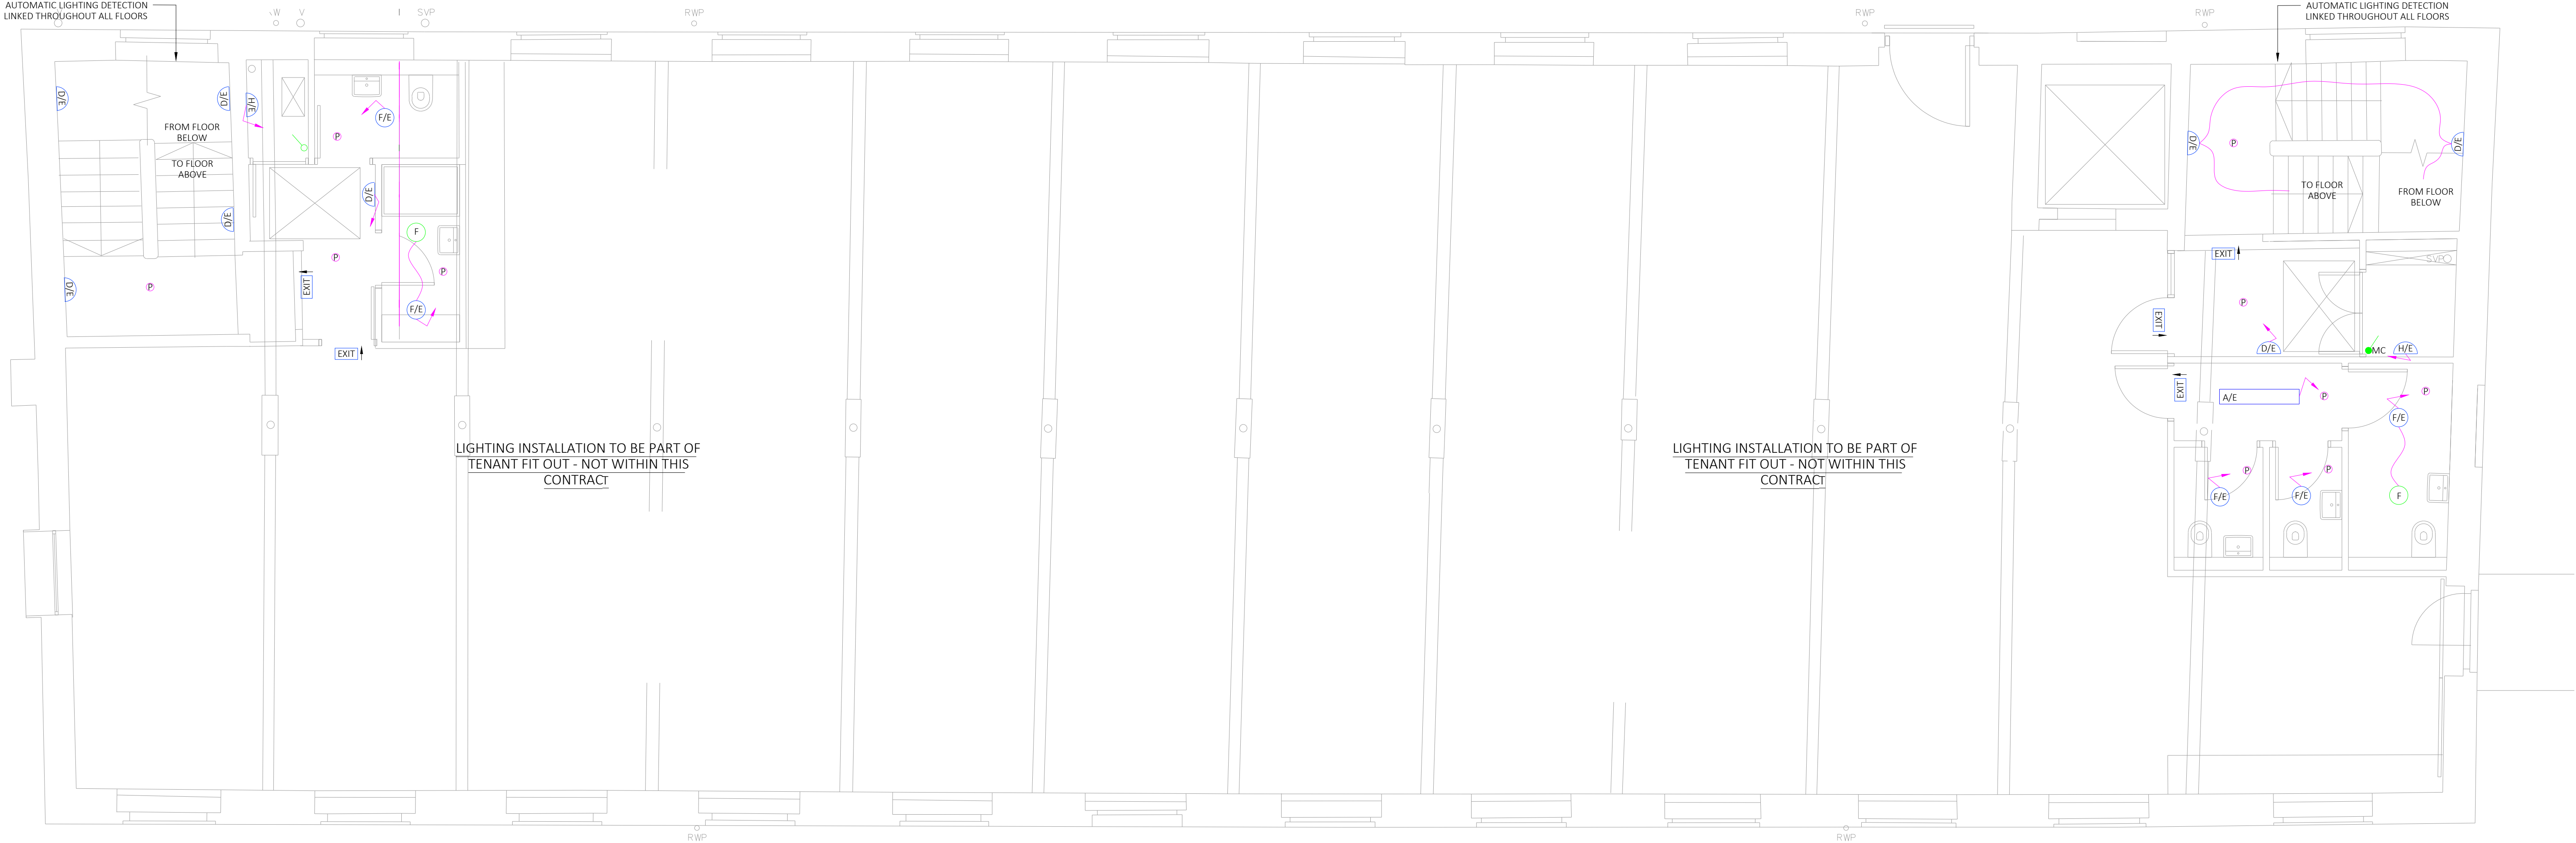

LIGHTING LEGEND

	SUSPENDED, 33W LED LINEAR UPWARD/DOWNWARD LIGHT LUMINAIRE WITH POLYCARBONATE DIFFUSER AS PER TAMLITE LUMINAIRE WITH POLYCARBONATE DIFFUSER AS PER TAMLITE CITY WL T2. 'E' DENOTES INTEGRAL EMERGENCY VERSION - BLACK FINISH. 4000K		SURFACE MOUNTED, EXTERNAL, 11W LED LUMINAIRE WITH OPAL DIFFUSER AS PER TAMLITE CITY WL T2. 'E' DENOTES INTEGRAL EMERGENCY VERSION - INTEGRAL PHOTOCELL - BLACK - 4000K		LIGHT SWITCH: G - DENOTES NUMBER OF GANGS 2 - DENOTES 2 WAY SWITCHING IP - DENOTES IP RATED D - DENOTES DIMMABLE
	SUSPENDED, 33W LED LINEAR UPWARD/DOWNWARD LIGHT LUMINAIRE WITH POLYCARBONATE DIFFUSER AS PER TAMLITE SIGNUM D. 'E' DENOTES INTEGRAL EMERGENCY VERSION - BLACK FINISH. 4000K - DALI		SURFACE MOUNTED, 9W LED LUMINAIRE AS PER TAMLITE ATHENS. WHITE IN FINISH - 3000K		RECESSED/SURFACE MOUNTED AUTOMATIC LIGHTING DETECTOR - WHITE IN FINISH M - DENOTES LONG RANGE MICROWAVE DETECTION P - DENOTES PRESENCE DETECTION
	SUSPENDED, 89W LED CIRCULAR DECORATIVE LUMINAIRE WITH OPAL DIFFUSER AS PER TAMLITE AIR. 'E' DENOTES INTEGRAL EMERGENCY VERSION - BLACK FINISH. 4000K - DALI		RECESSED MOUNTED, 20W LED DOWNLIGHT LUMINAIRE WITH OPAL POLYCARBONATE DIFFUSER AS PER TAMLITE IKON S. 'E' DENOTES INTEGRAL EMERGENCY VERSION - WHITE - 4000K		SURFACE MOUNTED LED DIRECTIONAL EXIT LUMINAIRE AS PER TAMLITE ELITE EB
	SURFACE MOUNTED, LARGE, 25W LED CIRCULAR DECORATIVE LUMINAIRE WITH OPAL POLYCARBONATE DIFFUSER, HALO BACKLIT AS PER TAMLITE SOLAR. 'E' DENOTES INTEGRAL EMERGENCY VERSION - WHITE WITH SATIN TRIM FINISH. 4000K		SUSPENDED MOUNTED, 38W LED LUMINAIRE WITH OPAL DIFFUSER AS PER TAMLITE OLYMPIAN. 'E' DENOTES INTEGRAL EMERGENCY VERSION - WHITE - 4000K		FINAL EXIT EMERGENCY LED BULKHEAD LUMINAIRE AS PER TAMLITE ELITE EB
	RECESSED MOUNTED, 20W LED DOWNLIGHT LUMINAIRE WITH OPAL POLYCARBONATE DIFFUSER AS PER TAMLITE ASTRO. 'E' DENOTES INTEGRAL EMERGENCY VERSION - WHITE - 4000K		SUSPENDED MOUNTED, 22W LED LUMINAIRE WITH OPAL DIFFUSER AS PER TAMLITE OLYMPIAN - WHITE - 4000K		EXTERNAL LED EMERGENCY EXIT LUMINAIRE AS PER TAMLITE ELITE BH
	SURFACE MOUNTED, 28W LED LINEAR LUMINAIRE WITH OPAL DIFFUSER AS PER TAMLITE PRIMA. 'E' DENOTES INTEGRAL EMERGENCY VERSION - WHITE - 4000K		SURFACE MOUNTED, TRACK LIGHT (TRIO) LED LUMINAIRES AS PER TAMLITE SONATA RANGE - BLACK - 3000K - DALI		LIGHTING CONNECTION POINT, PHOTOCELL & TIMECLOCK FOR EXTERNAL SIGNAGE
	SURFACE MOUNTED, 20W LED LUMINAIRE WITH OPAL DIFFUSER AS PER TAMLITE MERIDIAN. 'E' DENOTES INTEGRAL EMERGENCY VERSION - WHITE - 4000K		SURFACE MOUNTED, LED TAPE AS PER TAMLITE FX LED - 3000K - DALI - IP65		

Notes:

- This drawing is subject to copyright and is not to be reproduced in part or whole without approval.
- Do not scale this drawing - check all dimensions on site.
- This drawing shall be read in conjunction with the project specification(s) and all other contract documentation.
- All dimensions are in millimetres unless otherwise stated.
- Location of all equipment shown shall be confirmed/approved with the Client/Architect/Engineer prior to any installation.
- This drawing must be read in conjunction with Mechanical and Electrical performance specifications and all other drawings as issued by the Architect, Structural Engineer and Watt Energy and Consulting Engineers.
- The location of equipment is typical only. The Contractor shall perform all calculations to determine the exact quantity and agree the final locations with the Architect.
- This drawing shows the intended location of building services plant and service routes in such detail as to indicate the design. The drawing does not show all components that may be necessary to provide a full working installation.
- The positions of connection points, accessories and building services items are approximate and shown for guidance to assist during the tender process.
- Fully co-ordinated drawings, Construction drawings and Builderswork drawings shall be produced by the contractor. Under no circumstances shall the tender drawings be used as installation drawings.

WE&CE DRAWINGS ARE FOR DESIGN INTENT ONLY.
THE MEP CONTRACTOR IS RESPONSIBLE FOR THE
FINAL INSTALLATION DRAWINGS INCLUDING ALL
SETTING OUT, DIMENSIONS, ALIGNMENT AND
COORDINATION WITH THE ARCHITECTS
REQUIREMENTS.

T1	11/04/23	TENDER ISSUE	DK
P2	24/03/23	PRELIMINARY ISSUE	NJF
P1	10/03/23	PRELIMINARY ISSUE	NJF
Rev:	Date	Status/Amendments	By:




40 KING STREET, MANCHESTER, M2 6BA
TEL: 0161 434 3103 EMAIL: office@wece.co.uk

Client:
CAPITAL AND CENTRIC

Project:
CHAPELTOWN WAREHOUSE

Drawing Title:
ELECTRICAL SERVICES
LIGHTING LAYOUT
THIRD FLOOR

Drawn By: NJF	Checked By: DW	Cad By: DK
Scale: 1:50	Paper Size: A1	Date Created: 15/02/2023
Drawing Number: WECE / 353 / E / 103	Drawing Revision: T1	

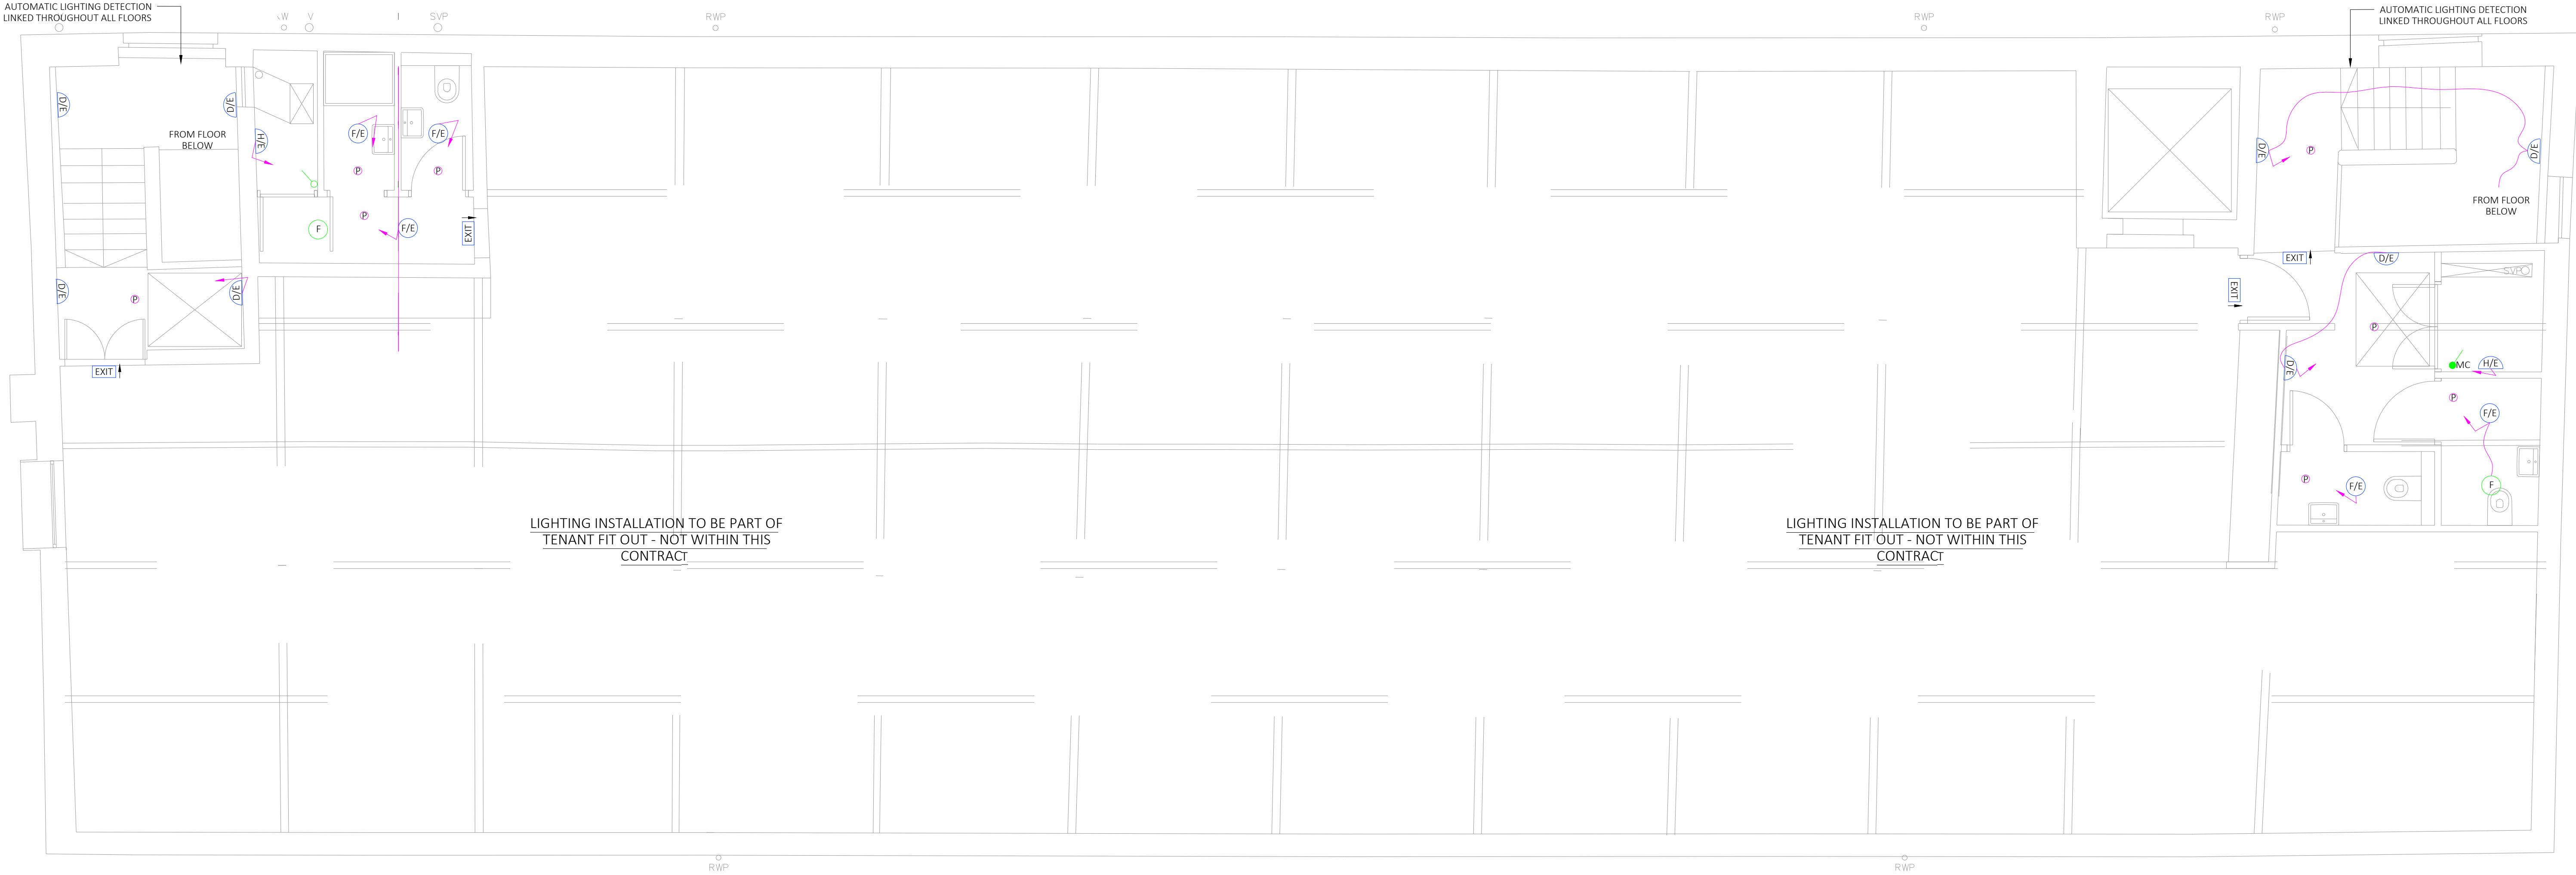

LIGHTING LEGEND

A/E

B/E

C/E

D/E

F/E

G/E

H/E

SUSPENDED, 33W LED LINEAR UPWARD/DOWNWARD LIGHT LUMINAIRE WITH POLYCARBONATE DIFFUSER AS PER TAMLITE CITY WL T2. 'E' DENOTES INTEGRAL EMERGENCY VERSION - BLACK FINISH. 4000K

SUSPENDED, 33W LED LINEAR UPWARD/DOWNWARD LIGHT LUMINAIRE WITH POLYCARBONATE DIFFUSER AS PER TAMLITE SIGNUM D. 'E' DENOTES INTEGRAL EMERGENCY VERSION - BLACK FINISH. 4000K - DALI

SUSPENDED, 89W LED CIRCULAR DECORATIVE LUMINAIRE WITH OPAL DIFFUSER AS PER TAMLITE AIR. 'E' DENOTES INTEGRAL EMERGENCY VERSION - BLACK FINISH. 4000K - DALI

SURFACE MOUNTED, LARGE, 25W LED CIRCULAR DECORATIVE LUMINAIRE WITH OPAL POLYCARBONATE DIFFUSER, HALO BACKLIT AS PER TAMLITE SOLAR. 'E' DENOTES INTEGRAL EMERGENCY VERSION - WHITE WITH SATIN TRIM FINISH. 4000K

RECESSED MOUNTED, 20W LED DOWNLIGHT LUMINAIRE WITH OPAL POLYCARBONATE DIFFUSER AS PER TAMLITE ASTRO. 'E' DENOTES INTEGRAL EMERGENCY VERSION - WHITE - 4000K

SURFACE MOUNTED, 28W LED LINEAR LUMINAIRE WITH OPAL DIFFUSER AS PER TAMLITE PRIMA. 'E' DENOTES INTEGRAL EMERGENCY VERSION - WHITE - 4000K

SURFACE MOUNTED, 20W LED LUMINAIRE WITH OPAL DIFFUSER AS PER TAMLITE MERIDIAN. 'E' DENOTES INTEGRAL EMERGENCY VERSION - WHITE - 4000K

J/E

K

L/E

M/E

N

P

Q

SURFACE MOUNTED, EXTERNAL, 11W LED LUMINAIRE WITH OPAL DIFFUSER AS PER TAMLITE CITY WL T2. 'E' DENOTES INTEGRAL EMERGENCY VERSION - INTEGRAL PHOTOCELL - BLACK - 4000K

SURFACE MOUNTED, 9W LED LUMINAIRE AS PER TAMLITE ATHENS. WHITE IN FINISH - 3000K

RECESSED MOUNTED, 20W LED DOWNLIGHT LUMINAIRE WITH OPAL POLYCARBONATE DIFFUSER AS PER TAMLITE IKON S. 'E' DENOTES INTEGRAL EMERGENCY VERSION - WHITE - 4000K

SUSPENDED MOUNTED, 38W LED LUMINAIRE WITH OPAL DIFFUSER AS PER TAMLITE OLYMPIAN. 'E' DENOTES INTEGRAL EMERGENCY VERSION - WHITE - 4000K

SUSPENDED MOUNTED, 22W LED LUMINAIRE WITH OPAL DIFFUSER AS PER TAMLITE OLYMPIAN - WHITE - 4000K

SURFACE MOUNTED, TRACK LIGHT (TRIO) LED LUMINAIRES AS PER TAMLITE SONATA RANGE - BLACK - 3000K - DALI

SURFACE MOUNTED, LED TAPE AS PER TAMLITE FX LED - 3000K - DALI - IP65

G

P

EXIT

EXIT

EX

TC

LIGHT SWITCH:
G - DENOTES NUMBER OF GANGS
2 - DENOTES 2 WAY SWITCHING
IP - DENOTES IP RATED
D - DENOTES DIMMABLE

RECESSED/SURFACE MOUNTED AUTOMATIC LIGHTING DETECTOR - WHITE IN FINISH
M - DENOTES LONG RANGE MICROWAVE DETECTION
P - DENOTES PRESENCE DETECTION

SURFACE MOUNTED LED DIRECTIONAL EXIT LUMINAIRE AS PER TAMLITE ELITE EB

FINAL EXIT EMERGENCY LED BULKHEAD LUMINAIRE AS PER TAMLITE ELITE EB

EXTERNAL LED EMERGENCY EXIT LUMINAIRE AS PER TAMLITE ELITE BH

LIGHTING CONNECTION POINT, PHOTOCELL & TIMECLOCK FOR EXTERNAL SIGNAGE

Notes:

- This drawing is subject to copyright and is not to be reproduced in part or whole without approval.
- Do not scale this drawing - check all dimensions on site.
- This drawing shall be read in conjunction with the project specification(s) and all other contract documentation.
- All dimensions are in millimetres unless otherwise stated.
- Location of all equipment shown shall be confirmed/approved with the Client/Architect/Engineer prior to any installation.
- This drawing must be read in conjunction with Mechanical and Electrical performance specifications and all other drawings as issued by the Architect, Structural Engineer and Watt Energy and Consulting Engineers.
- The location of equipment is typical only. The Contractor shall perform all calculations to determine the exact quantity and agree the final locations with the Architect.
- This drawing shows the intended location of building services plant and service routes in such detail as to indicate the design. The drawing does not show all components that may be necessary to provide a full working installation.
- The positions of connection points, accessories and building services items are approximate and shown for guidance to assist during the tender process.
- Fully co-ordinated drawings, Construction drawings and Builderswork drawings shall be produced by the contractor. Under no circumstances shall the tender drawings be used as installation drawings.

WE&CE DRAWINGS ARE FOR DESIGN INTENT ONLY.
THE MEP CONTRACTOR IS RESPONSIBLE FOR THE
FINAL INSTALLATION DRAWINGS INCLUDING ALL
SETTING OUT, DIMENSIONS, ALIGNMENT AND
COORDINATION WITH THE ARCHITECTS
REQUIREMENTS.

T1	11/04/23	TENDER ISSUE	DK
P2	24/03/23	PRELIMINARY ISSUE	NJF
P1	10/03/23	PRELIMINARY ISSUE	NJF
Rev:	Date:	Status/Amendments:	By:



40 KING STREET, MANCHESTER, M2 6BA
TEL: 0161 434 3103 EMAIL: office@wece.co.uk


Client:
CAPITAL AND CENTRIC

Project:
CHAPELTOWN WAREHOUSE

Drawing Title:
ELECTRICAL SERVICES
LIGHTING LAYOUT
FOURTH FLOOR

Drawn By: NJF	Checked By: DW	Cad By: DK
Scale: 1:50	Paper Size: A1	Date Created: 15/02/2023
Drawing Number: WECE / 353 / E / 104	Drawing Revision: T1	

- WE&CE DRAWINGS ARE FOR DESIGN INTENT ONLY.
THE MEP CONTRACTOR IS RESPONSIBLE FOR THE
FINAL INSTALLATION DRAWINGS INCLUDING ALL
SETTING OUT, DIMENSIONS, ALIGNMENT AND
COORDINATION WITH THE ARCHITECTS
REQUIREMENTS.

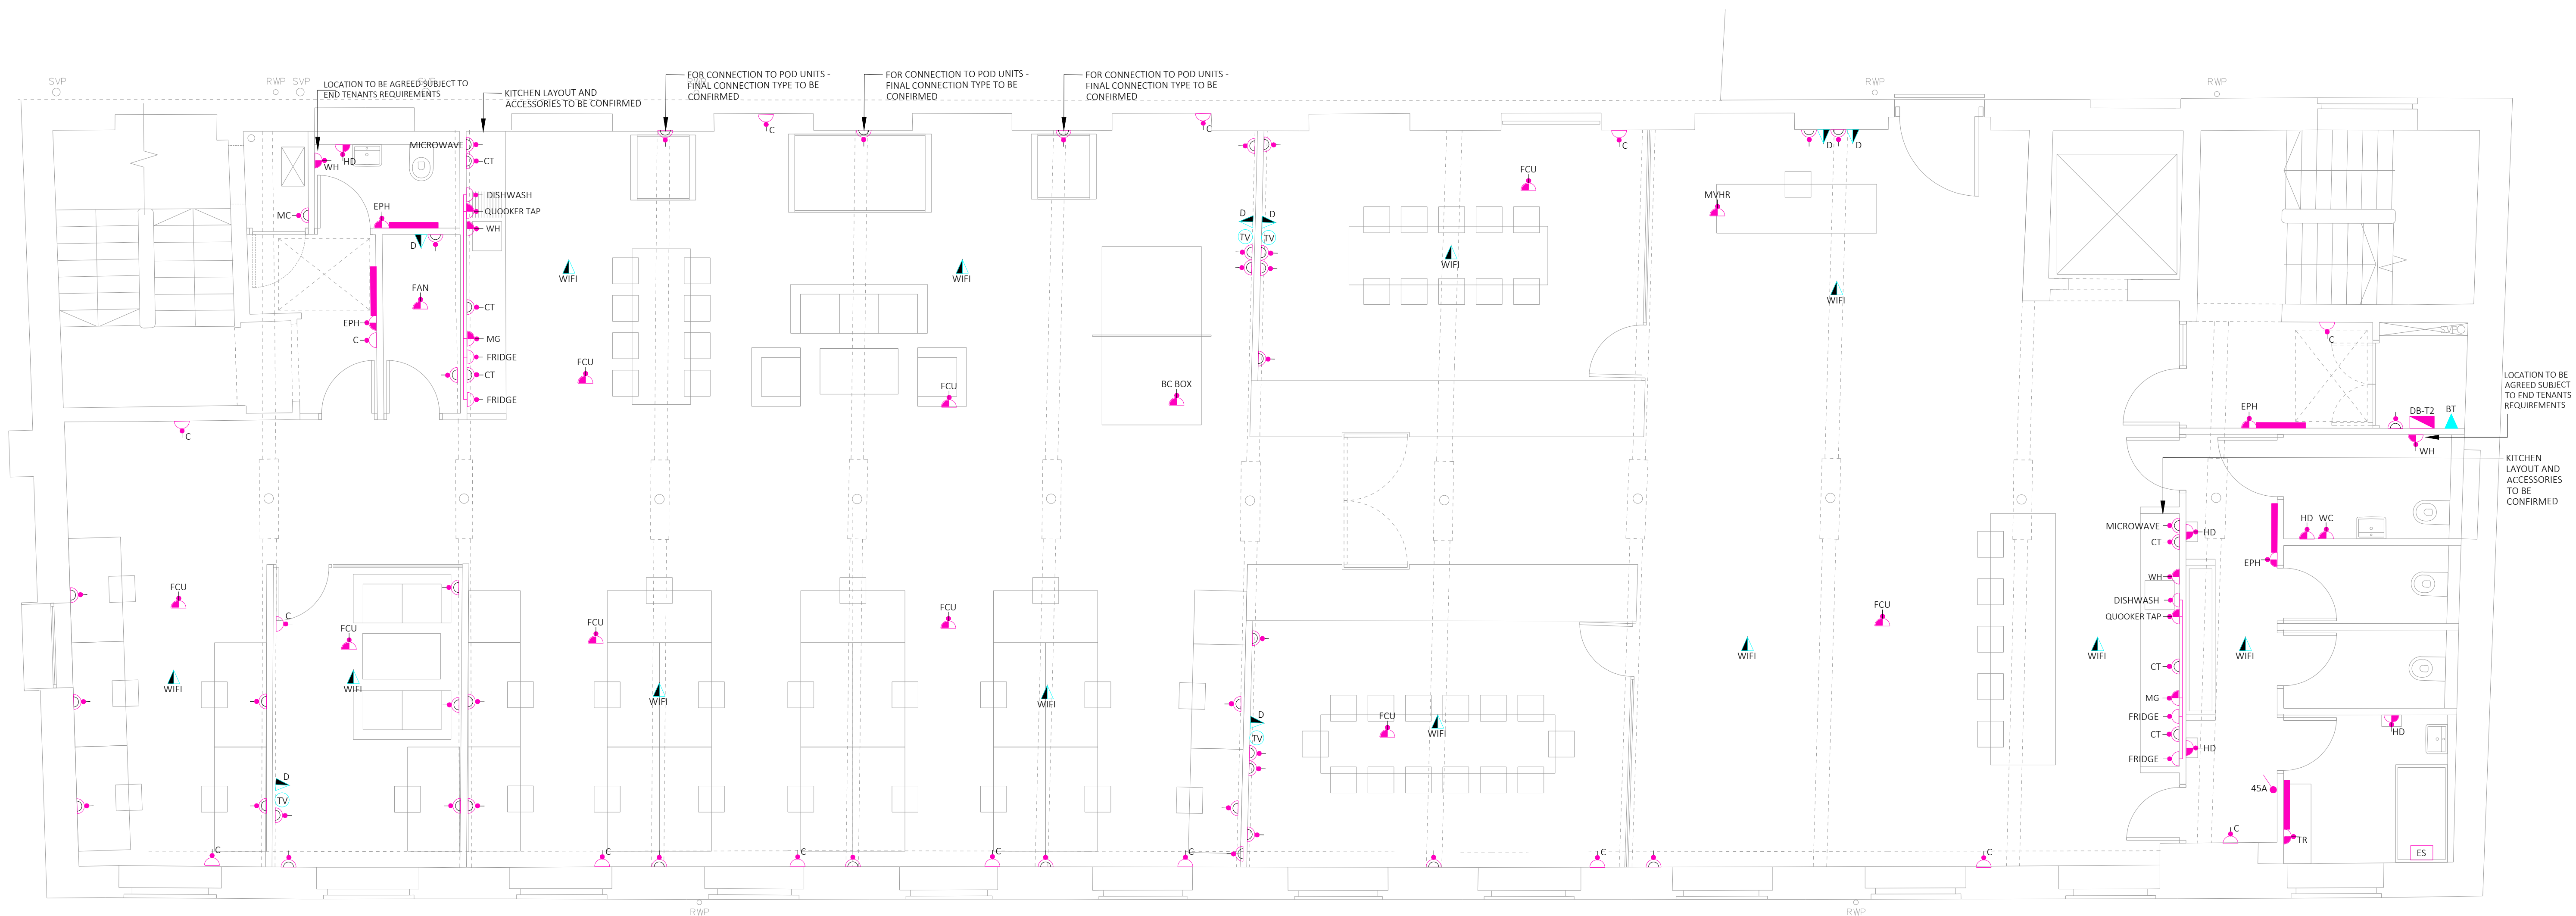

SMALL POWER & COMMS LEGEND



T2	22/06/23	TENDER ISSUE	NJF
T1	11/04/23	TENDER ISSUE	DK
P2	24/03/23	PRELIMINARY ISSUE	NJF
P1	10/03/23	PRELIMINARY ISSUE	NJF
Rev:	Date:	Status/Amendments:	By:

40 KING STREET, MANCHESTER, M2 6BA
TEL: 0161 434 3103 EMAIL: office@wece.co.uk

Client:
CAPITAL AND CENTRIC

Project:
CHAPELTOWN WAREHOUSE

Drawing Title:


ELECTRICAL SERVICES
SMALL POWER AND COMMUNICATIONS LAYOUT
FIRST FLOOR

Drawn By: NJF	Checked By: DW	Cad By: DK
Scale: 1:50	Paper Size: A1	Date Created: 15/02/2023
Drawing Number: WECE / 353 / E / 201		Drawing Revision: T2


WE&CE DRAWINGS ARE FOR DESIGN INTENT ONLY.
THE MEP CONTRACTOR IS RESPONSIBLE FOR THE
FINAL INSTALLATION DRAWINGS INCLUDING ALL
SETTING OUT, DIMENSIONS, ALIGNMENT AND
COORDINATION WITH THE ARCHITECTS
REQUIREMENTS.

Notes:

1. This drawing is subject to copyright and is not to be reproduced in part or whole without approval.
2. Do not scale this drawing - check all dimensions on site.
3. This drawing shall be read in conjunction with the project specification(s) and all other contract documentation.
4. All dimensions are in millimetres unless otherwise stated.
5. Location of all equipment shown shall be confirmed/approved with the Client/Architect/Engineer prior to any installation.
6. This drawing must be read in conjunction with Mechanical and Electrical performance specifications and all other drawings as issued by the Architect, Structural Engineer and Watt Energy and Consulting Engineers.
7. The location of equipment is typical only. The Contractor shall perform all calculations to determine the exact quantity and agree the final locations with the Architect.
8. This drawing shows the intended location of building services plant and service routes in such detail as to indicate the design. The drawing does not show all components that may be necessary to provide a full working installation.
9. The positions of connection points, accessories and building services items are approximate and shown for guidance to assist during the tender process.
10. Fully co-ordinated drawings, Construction drawings and Builderswork drawings shall be produced by the contractor. Under no circumstances shall the tender drawings be used as installation drawings.

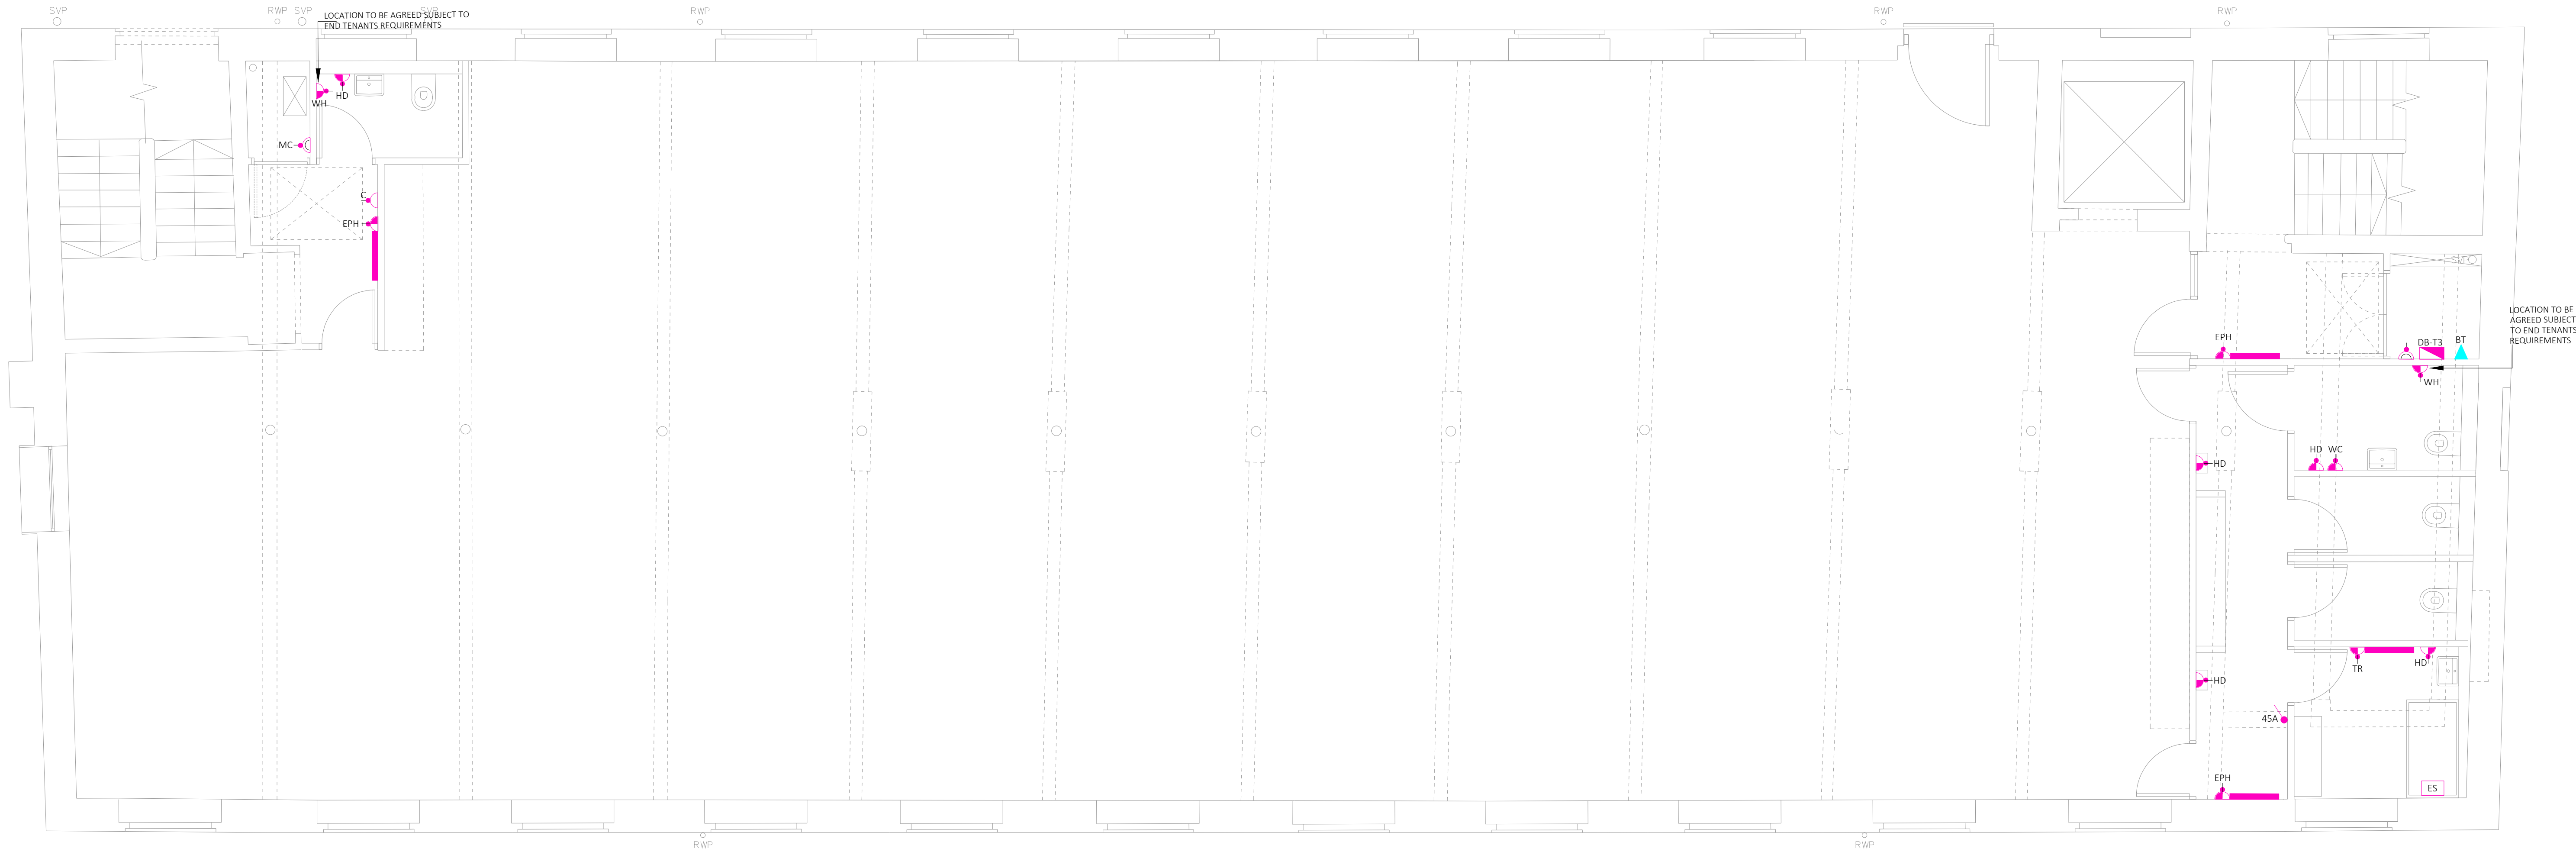

SMALL POWER & COMMS LEGEND

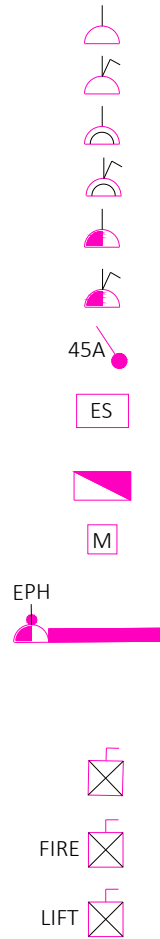

UNSWITCHED SINGLE SOCKET OUTLET
SWITCHED SINGLE SOCKET OUTLET
UNSWITCHED DOUBLE SOCKET OUTLET
SWITCHED DOUBLE SOCKET OUTLET
UNSWITCHED FUSED CONNECTION UNIT
SWITCHED FUSED CONNECTION UNIT
45A DOUBLE POLE SHOWER ISOLATOR
9kW ELECTRIC SHOWER - REFER TO MECHANICAL SPECIFICATION FOR SHOWER SPECIFICATION
SPLIT LOAD LIGHTING AND POWER DISTRIBUTION BOARD C/W SUB METERING
UTILITY METER
ELECTRIC WALL HEATER C/W FUSED CONNECTION UNIT WITH FLEX OUTLET PLATE:
TR - TOWEL RADIATOR
EPH - PANEL HEATER
ODH - OVERDOOR HEATER
IP RATED ROTARY LOCKABLE ISOLATOR
DENOTED LOCALLY OF INTENDED USE
BSS839 COMPLIANT FIRE ALARM ISOLATOR
IP RATED ROTARY LOCKABLE ISOLATOR FOR CONNECTION TO PASSENGER LIFT

TV AERIAL POINT
BT FIBRE CONNECTION OUTLET
R45 DOUBLE DATA OUTLET

ABBREVIATION:

AC ACCESS CONTROL/INTERCOM
BT BOOSTER TANK
C CLEANERS SOCKET
CV CEILING VOID
CT COUNTER TOP
DW DISHWASHER
EF EXTRACT FAN
EPH ELECTRIC PANEL HEATER
FAN MECHANICAL FAN
FAP FIRE ALARM PANEL
FR FRIDGE/FREEZER
HD HAND DRYER
L LOCKABLE
MC METAL CLAD
MVHR MECHANICAL HEAT VENTILATION RECOVERY
ODH OVERDOOR HEATER
EPH PANEL HEATER
TR TOWEL RAIL
USB C/W DUAL USB OUTLET
IPES IPES RATED
WC WC ALARM
WIFI WIRELESS ACCESS POINT (WIFI)
WH WATER HEATER

Notes:

- This drawing is subject to copyright and is not to be reproduced in part or whole without approval.
- Do not scale this drawing - check all dimensions on site.
- This drawing shall be read in conjunction with the project specification(s) and all other contract documentation.
- All dimensions are in millimetres unless otherwise stated.
- Location of all equipment shown shall be confirmed/approved with the Client/Architect/Engineer prior to any installation.
- This drawing must be read in conjunction with Mechanical and Electrical performance specifications and all other drawings as issued by the Architect, Structural Engineer and Watt Energy and Consulting Engineers.
- The location of equipment is typical only. The Contractor shall perform all calculations to determine the exact quantity and agree the final locations with the Architect.
- This drawing shows the intended location of building services plant and service routes in such detail as to indicate the design. The drawing does not show all components that may be necessary to provide a full working installation.
- The positions of connection points, accessories and building services items are approximate and shown for guidance to assist during the tender process.
- Fully co-ordinated drawings, Construction drawings and Builderswork drawings shall be produced by the contractor. Under no circumstances shall the tender drawings be used as installation drawings.

WE&CE DRAWINGS ARE FOR DESIGN INTENT ONLY.
THE MEP CONTRACTOR IS RESPONSIBLE FOR THE
FINAL INSTALLATION DRAWINGS INCLUDING ALL
SETTING OUT, DIMENSIONS, ALIGNMENT AND
COORDINATION WITH THE ARCHITECTS
REQUIREMENTS.

T1	11/04/23	TENDER ISSUE	DK
P2	24/03/23	PRELIMINARY ISSUE	NJF
P1	10/03/23	PRELIMINARY ISSUE	NJF
Rev:	Date:	Status/Amendments:	By:



40 KING STREET, MANCHESTER, M2 6BA
TEL: 0161 434 3103 EMAIL: office@wece.co.uk


Client:
CAPITAL AND CENTRIC

Project:
CHAPELTOWN WAREHOUSE

Drawing Title:
ELECTRICAL SERVICES
SMALL POWER AND COMMUNICATIONS LAYOUT
SECOND FLOOR

Drawn By: NJF	Checked By: DW	Cad By: DK
Scale: 1:50	Paper Size: A1	Date Created: 15/02/2023
Drawing Number: WECE / 353 / E / 202	Drawing Revision: T1	

- WE&CE DRAWINGS ARE FOR DESIGN INTENT ONLY.
THE MEP CONTRACTOR IS RESPONSIBLE FOR THE
FINAL INSTALLATION DRAWINGS INCLUDING ALL
SETTING OUT, DIMENSIONS, ALIGNMENT AND
COORDINATION WITH THE ARCHITECTS
REQUIREMENTS.

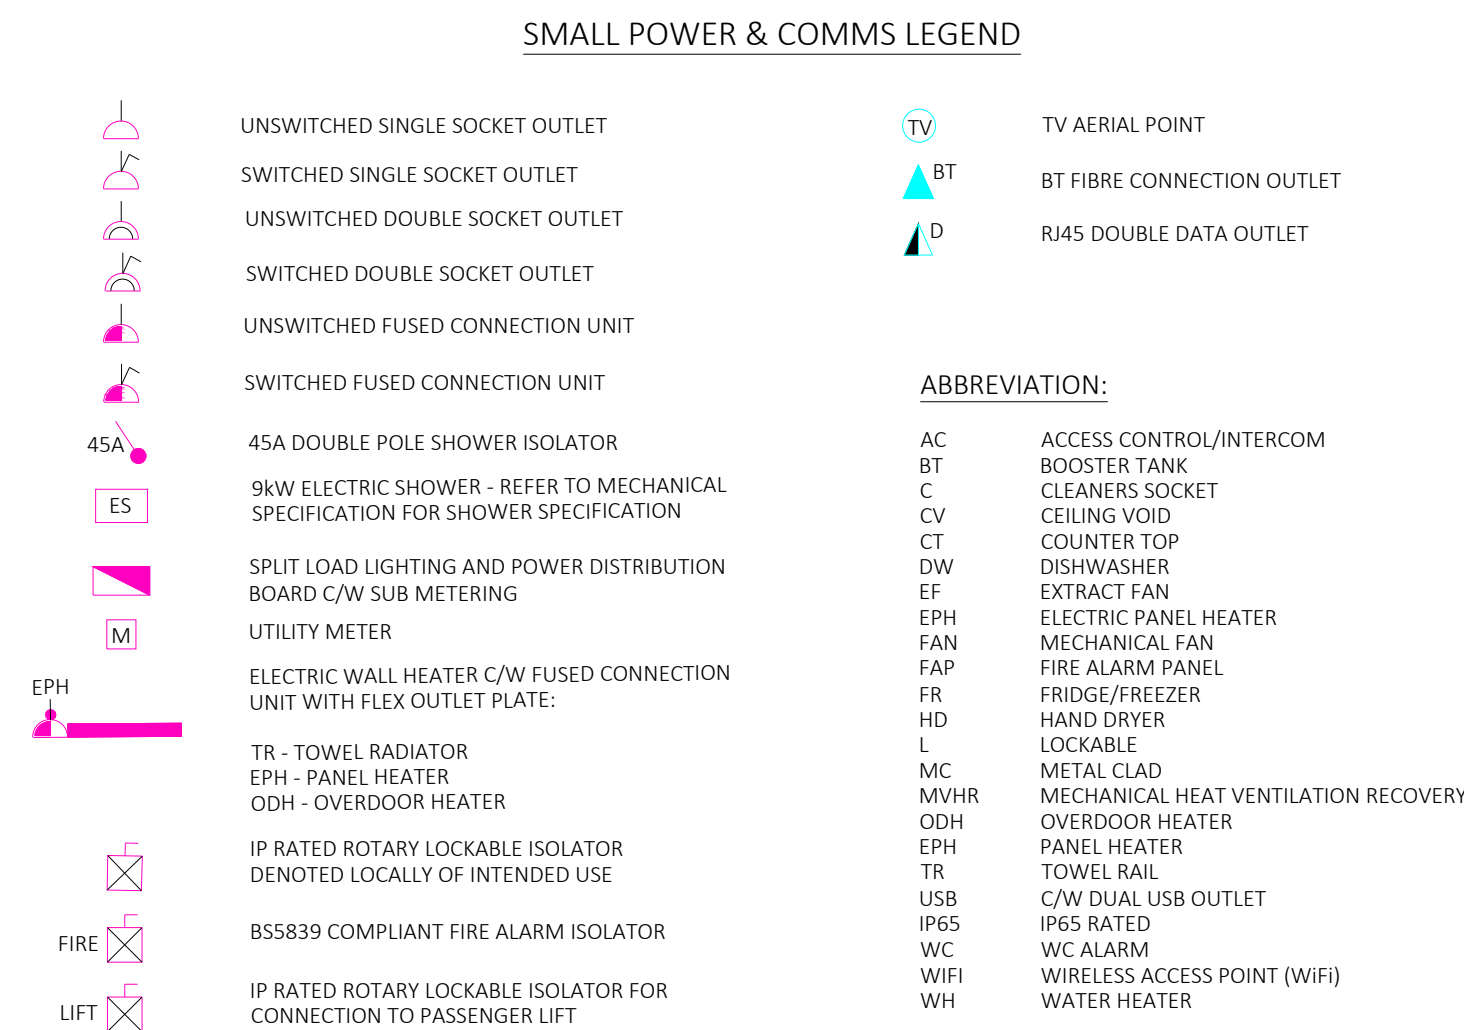

ABBREVIATION:

AC	ACCESS CONTROL/INTERCOM
BT	BOOSTER TANK
CV	CLEANER'S SOCKET
CT	CEILING VOID
CT	COUNTER TOP
DW	DISHWASHER
EF	EXTRACT FAN
EPH	ELECTRIC PANEL HEATER
FAN	MECHANICAL FAN
FAP	FIRE ALARM PANEL
FR	FRIDGE/FREEZER
HD	HAND DRYER
L	LOCKABLE
MC	METAL CLAD
MVHR	MECHANICAL HEAT VENTILATION RECOVERY
ODH	OVERDOOR HEATER
PH	PANEL HEATER
TR	TOWEL RAIL
US8	C/W DUAL USE OUTLET
IP65	IP65 RATED
WC	W/C W/ ALARM
WIFI	WIRELESS ACCESS POINT (WIFI)
WH	WATER HEATER

T1	11/04/23	TENDER ISSUE	DK
P2	24/03/23	PRELIMINARY ISSUE	NJF
P1	10/03/23	PRELIMINARY ISSUE	NJF
Rev:	Date:	Status/Amendments:	By:

40 KING STREET, MANCHESTER, M2 6BA
TEL: 0161 434 3103 EMAIL: office@wece.co.uk

Client: CAPITAL AND CENTRIC

Project:
CHAPELTOWN WAREHOUSE


Drawing Title:

ELECTRICAL SERVICES
SMALL POWER AND COMMUNICATIONS LAYOUT
FOURTH FLOOR

Drawn By: NJF	Checked By: DW	Cad By: DK
Scale: 1:50	Paper Size: A1	Date Created: 15/02/2023
Drawing Number: WECE / 353 / E / 204		Drawing Revision: T1

1. This drawing is subject to copyright and is not to be reproduced in part or whole without approval.
2. Do not scale this drawing - check all dimensions on site.
3. This drawing shall be read in conjunction with the project specification(s) and all other contract documentation.
4. All dimensions are in millimetres unless otherwise stated.
5. Location of all equipment shown shall be confirmed/approved with the Client/Architect/Engineer prior to any installation.
6. This drawing must be read in conjunction with Mechanical and Electrical performance specifications and all other drawings as issued by the Architect, Structural Engineer and Watt Energy and Consulting Engineers.
7. The location of equipment is typical only. The Contractor shall perform all calculations to determine the exact quantity and agree the final locations with the Architect.
8. This drawing shows the intended location of building services plant and service routes in such detail as to indicate the design. The drawing does not show all components that may be necessary to provide a full working installation.
9. The positions of connection points, accessories and building services items are approximate and shown for guidance to assist during the tender process.
10. Fully co-ordinated drawings, Construction drawings and Builderswork drawings shall be produced by the contractor. Under no circumstances shall the tender drawings be used as installation drawings.

WE&CE DRAWINGS ARE FOR DESIGN INTENT ONLY.
THE MEP CONTRACTOR IS RESPONSIBLE FOR THE
FINAL INSTALLATION DRAWINGS INCLUDING ALL
SETTING OUT, DIMENSIONS, ALIGNMENT AND
COORDINATION WITH THE ARCHITECTS
REQUIREMENTS.

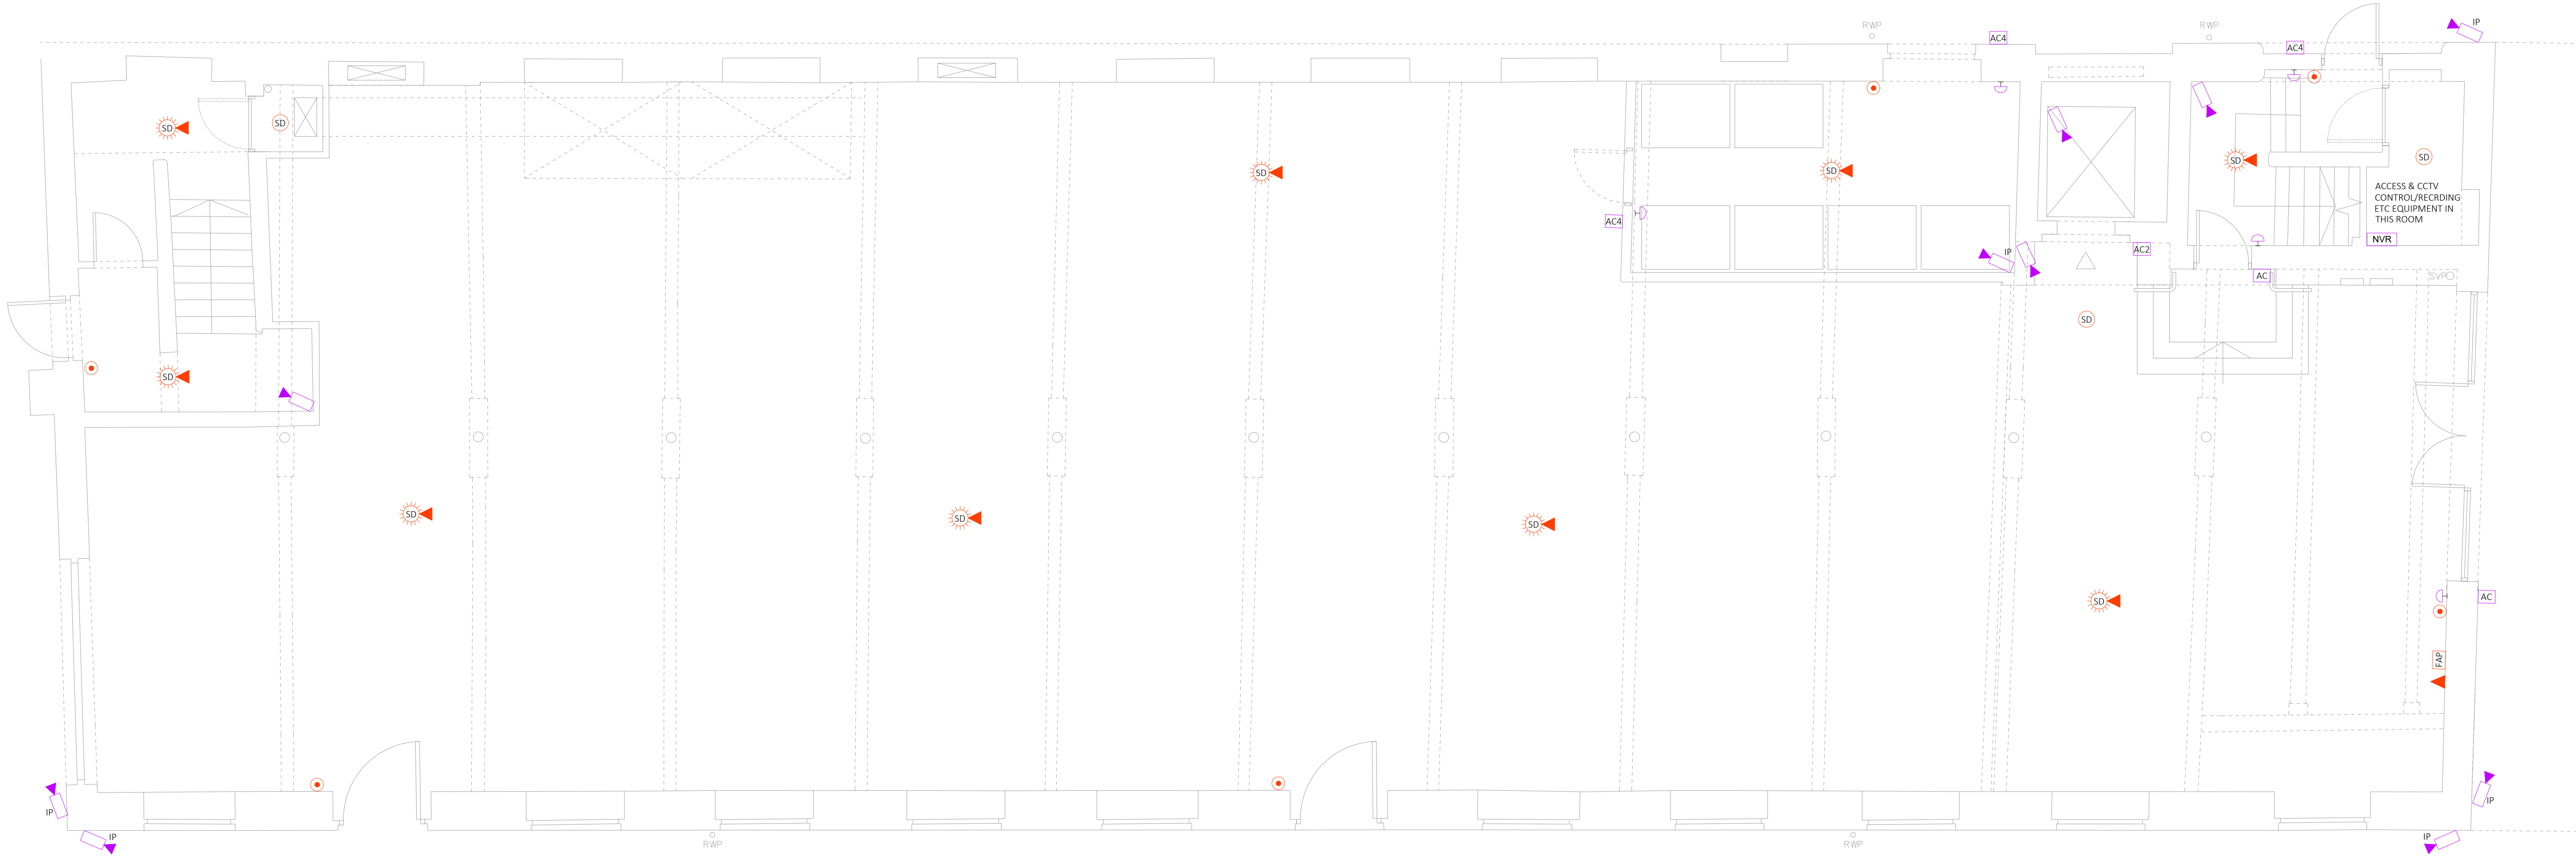

FIRE ALARM LEGEND

- HD HEAT DETECTOR
- SD SMOKE DETECTOR
- HD SMOKE DETECTOR WITH SOUNDER
- SD SMOKE DETECTOR WITH SOUNDER
- HD HEAT DETECTOR WITH SOUNDER & FLASHING BEACON
- SD SMOKE DETECTOR WITH SOUNDER & FLASHING BEACON
- FAP DIGITAL ADDRESSABLE FIRE ALARM PANEL
- FAI FIRE ALARM INTERFACE UNIT DENOTED LOCALLY AS TO INTENDED USE
- FIRE ALARM BREAK GLASS
- FIRE ALARM SOUNDER UNIT
- SOUNDER WITH FLASHING BEACON
- FIRE ALARM MONITORING LINE
- WALL MOUNTED BEACON FOR EMERGENCY EVACUATION

SECURITY LEGEND

- AC COMELIT ULTRA TOUCH PANEL & ACCESS CONTROL FOB READER
- AC1 SINGLE INTERCOM CALL UNIT WITH FOB CONTROL READER
- AC2 LIFT CALL FOB CONTROL READER
- AC3 WALL/DESK MOUNTED MONITOR/RECEIVER UNIT AND REMOTE DOOR RELEASE
- AC4 FOB CONTROL READER
- DOOR RELEASE BUTTON & EMERGENCY BREAK GLASS UNIT
- FIXED POSITION DOME CCTV CAMERA. IP DENOTES AN EXTERNAL IP RATED VERSION
- NVR 40 CHANNEL CCTV NETWORK VIDEO RECORDER

WC ALARM LEGEND

- WC ALARM PULL CORD
- WC ALARM RESET UNIT
- WC ALARM OVER DOOR INDICATOR

Notes:

- This drawing is subject to copyright and is not to be reproduced in part or whole without approval.
- Do not scale this drawing - check all dimensions on site.
- This drawing shall be read in conjunction with the project specification(s) and all other contract documentation.
- All dimensions are in millimetres unless otherwise stated.
- Location of all equipment shown shall be confirmed/approved with the Client/Architect/Engineer prior to any installation.
- This drawing must be read in conjunction with Mechanical and Electrical performance specifications and all other drawings as issued by the Architect, Structural Engineer and Watt Energy and Consulting Engineers.
- The location of equipment is typical only. The Contractor shall perform all calculations to determine the exact quantity and agree the final locations with the Architect.
- This drawing shows the intended location of building services plant and service routes in such detail as to indicate the design. The drawing does not show all components that may be necessary to provide a full working installation.
- The positions of connection points, accessories and building services items are approximate and shown for guidance to assist during the tender process.
- Fully co-ordinated drawings, Construction drawings and Builderswork drawings shall be produced by the contractor. Under no circumstances shall the tender drawings be used as installation drawings.

WE&CE DRAWINGS ARE FOR DESIGN INTENT ONLY.
THE MEP CONTRACTOR IS RESPONSIBLE FOR THE
FINAL INSTALLATION DRAWINGS INCLUDING ALL
SETTING OUT, DIMENSIONS, ALIGNMENT AND
COORDINATION WITH THE ARCHITECTS
REQUIREMENTS.

T1	11/04/23	TENDER ISSUE	DK
P2	24/03/23	PRELIMINARY ISSUE	NJF
P1	10/03/23	PRELIMINARY ISSUE	NJF
Rev:	Date:	Status/Amendments:	By:




40 KING STREET, MANCHESTER, M2 6BA
TEL: 0161 434 3103 EMAIL: office@wece.co.uk

Client:
CAPITAL AND CENTRIC

Project:
CHAPELTOWN WAREHOUSE

Drawing Title:
ELECTRICAL SERVICES
FIRE ALARM AND SECURITY LAYOUT
GROUND FLOOR

Drawn By: NJF	Checked By: DW	Cad By: DK
Scale: 1:50	Paper Size: A1	Date Created: 15/02/2023
Drawing Number: WECE / 353 / E / 300	Drawing Revision: T1	

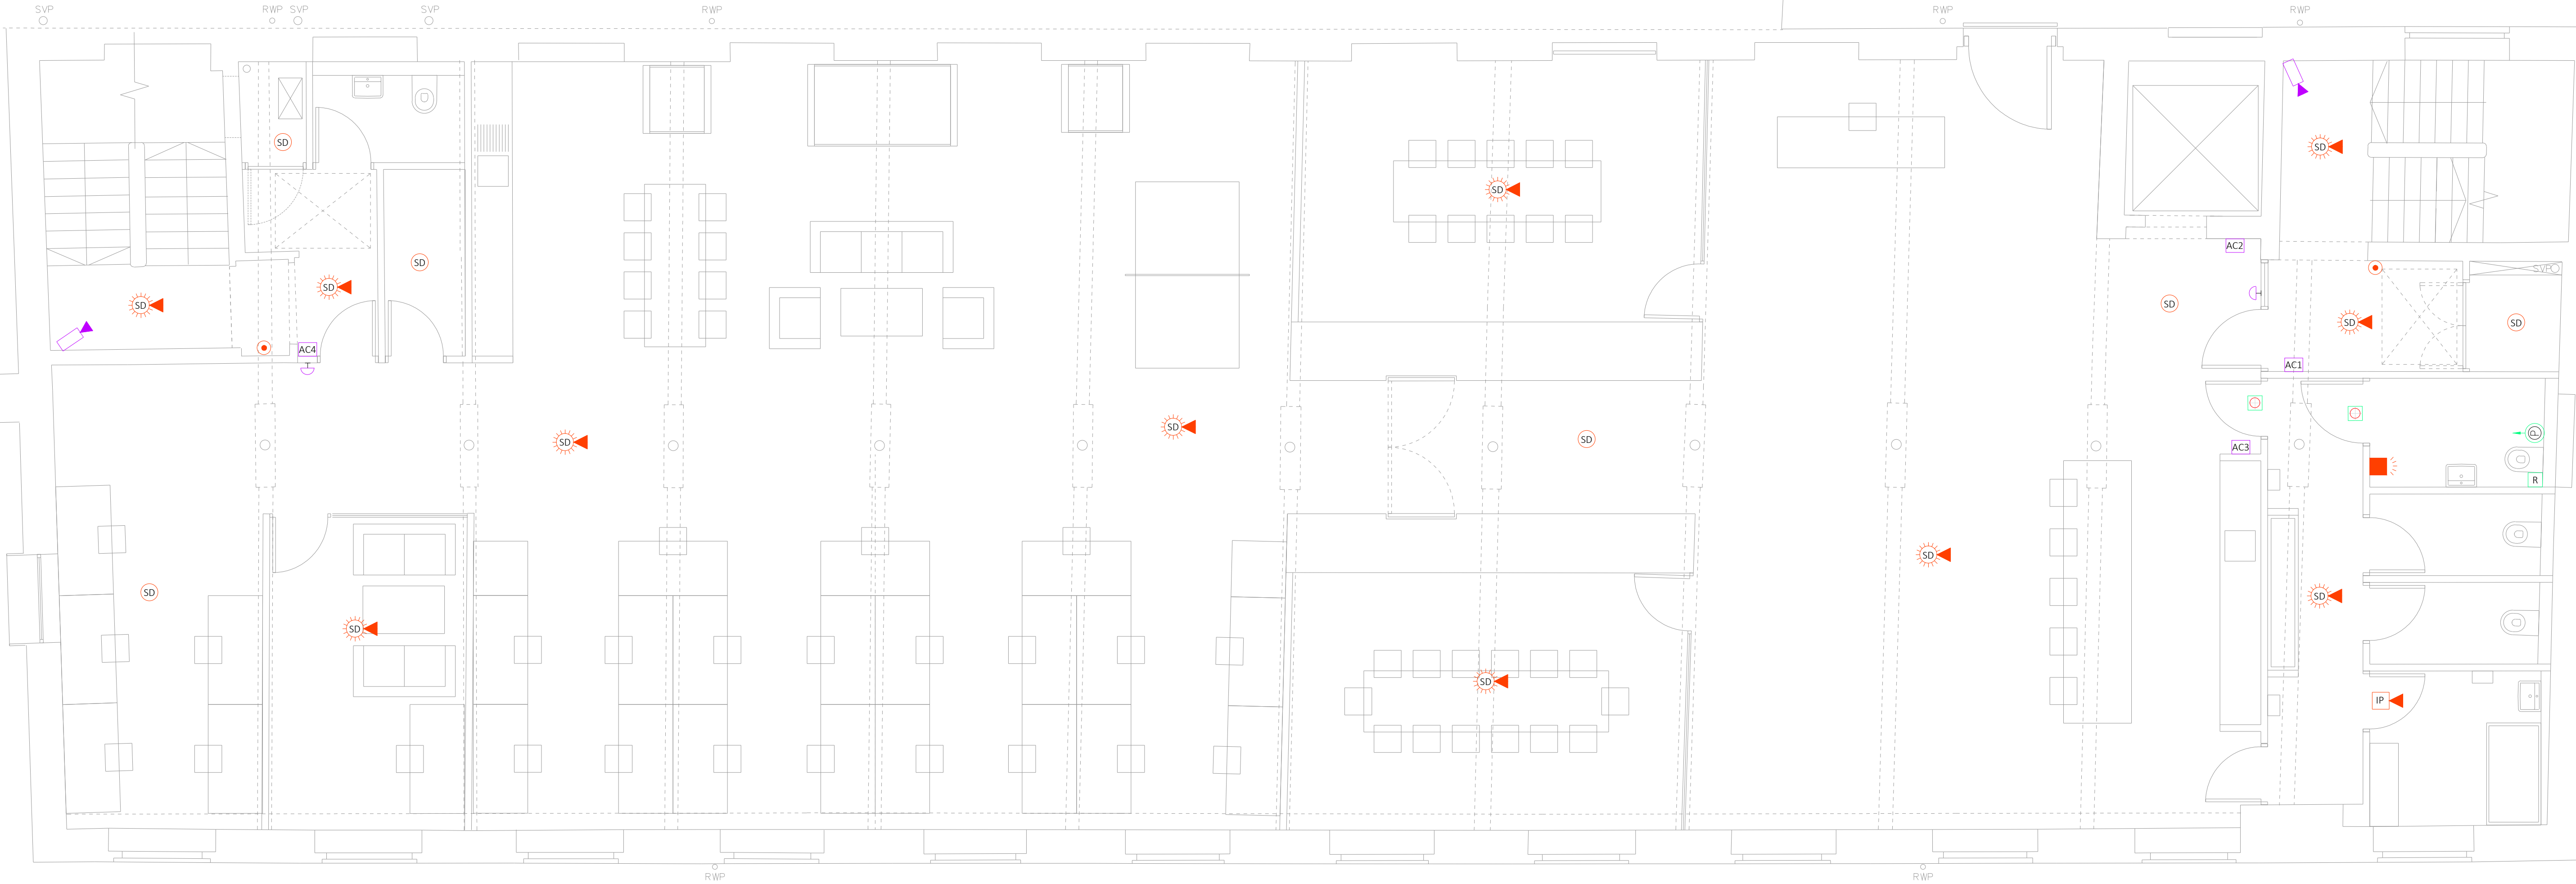

FIRE ALARM LEGEND

- HD HEAT DETECTOR
- SD SMOKE DETECTOR
- HD HEAT DETECTOR WITH SOUNDER
- SD SMOKE DETECTOR WITH SOUNDER
- HD HEAT DETECTOR WITH SOUNDER & FLASHING BEACON
- SD SMOKE DETECTOR WITH SOUNDER & FLASHING BEACON
- FAP DIGITAL ADDRESSABLE FIRE ALARM PANEL
- FAI FIRE ALARM INTERFACE UNIT DENOTED LOCALLY AS TO INTENDED USE
- FIRE ALARM BREAK GLASS
- FIRE ALARM SOUNDER UNIT
- SOUNDER WITH FLASHING BEACON
- FIRE ALARM MONITORING LINE
- WALL MOUNTED BEACON FOR EMERGENCY EVACUATION

SECURITY LEGEND

- AC COMELIT ULTRA TOUCH PANEL & ACCESS CONTROL FOB READER
- AC1 SINGLE INTERCOM CALL UNIT WITH FOB CONTROL READER
- AC2 LIFT CALL FOB CONTROL READER
- AC3 WALL/DESK MOUNTED MONITOR/RECEIVER UNIT AND REMOTE DOOR RELEASE
- AC4 FOB CONTROL READER
- DOOR RELEASE BUTTON & EMERGENCY BREAK GLASS UNIT
- FIXED POSITION DOME CCTV CAMERA. IP DENOTES AN EXTERNAL IP RATED VERSION
- NVR 40 CHANNEL CCTV NETWORK VIDEO RECORDER
- WC ALARM PULL CORD
- WC ALARM RESET UNIT
- WC ALARM OVER DOOR INDICATOR

Notes:

- This drawing is subject to copyright and is not to be reproduced in part or whole without approval.
- Do not scale this drawing - check all dimensions on site.
- This drawing shall be read in conjunction with the project specification(s) and all other contract documentation.
- All dimensions are in millimetres unless otherwise stated.
- Location of all equipment shown shall be confirmed/approved with the Client/Architect/Engineer prior to any installation.
- This drawing must be read in conjunction with Mechanical and Electrical performance specifications and all other drawings as issued by the Architect, Structural Engineer and Watt Energy and Consulting Engineers.
- The location of equipment is typical only. The Contractor shall perform all calculations to determine the exact quantity and agree the final locations with the Architect.
- This drawing shows the intended location of building services plant and service routes in such detail as to indicate the design. The drawing does not show all components that may be necessary to provide a full working installation.
- The positions of connection points, accessories and building services items are approximate and shown for guidance to assist during the tender process.
- Fully co-ordinated drawings, Construction drawings and Builderswork drawings shall be produced by the contractor. Under no circumstances shall the tender drawings be used as installation drawings.

WE&CE DRAWINGS ARE FOR DESIGN INTENT ONLY.
THE MEP CONTRACTOR IS RESPONSIBLE FOR THE
FINAL INSTALLATION DRAWINGS INCLUDING ALL
SETTING OUT, DIMENSIONS, ALIGNMENT AND
COORDINATION WITH THE ARCHITECTS
REQUIREMENTS.

T1	11/04/23	TENDER ISSUE	DK
P2	24/03/23	PRELIMINARY ISSUE	NJF
P1	10/03/23	PRELIMINARY ISSUE	NJF
Rev:	Date:	Status/Amendments:	By:




40 KING STREET, MANCHESTER, M2 6BA
TEL: 0161 434 3103 EMAIL: office@wece.co.uk

Client:
CAPITAL AND CENTRIC

Project:
CHAPELTOWN WAREHOUSE

Drawing Title:
ELECTRICAL SERVICES
FIRE ALARM AND SECURITY LAYOUT
FIRST FLOOR

Drawn By: NJF	Checked By: DW	Cad By: DK
Scale: 1:50	Paper Size: A1	Date Created: 15/02/2023
Drawing Number: WECE / 353 / E / 301	Drawing Revision: T1	

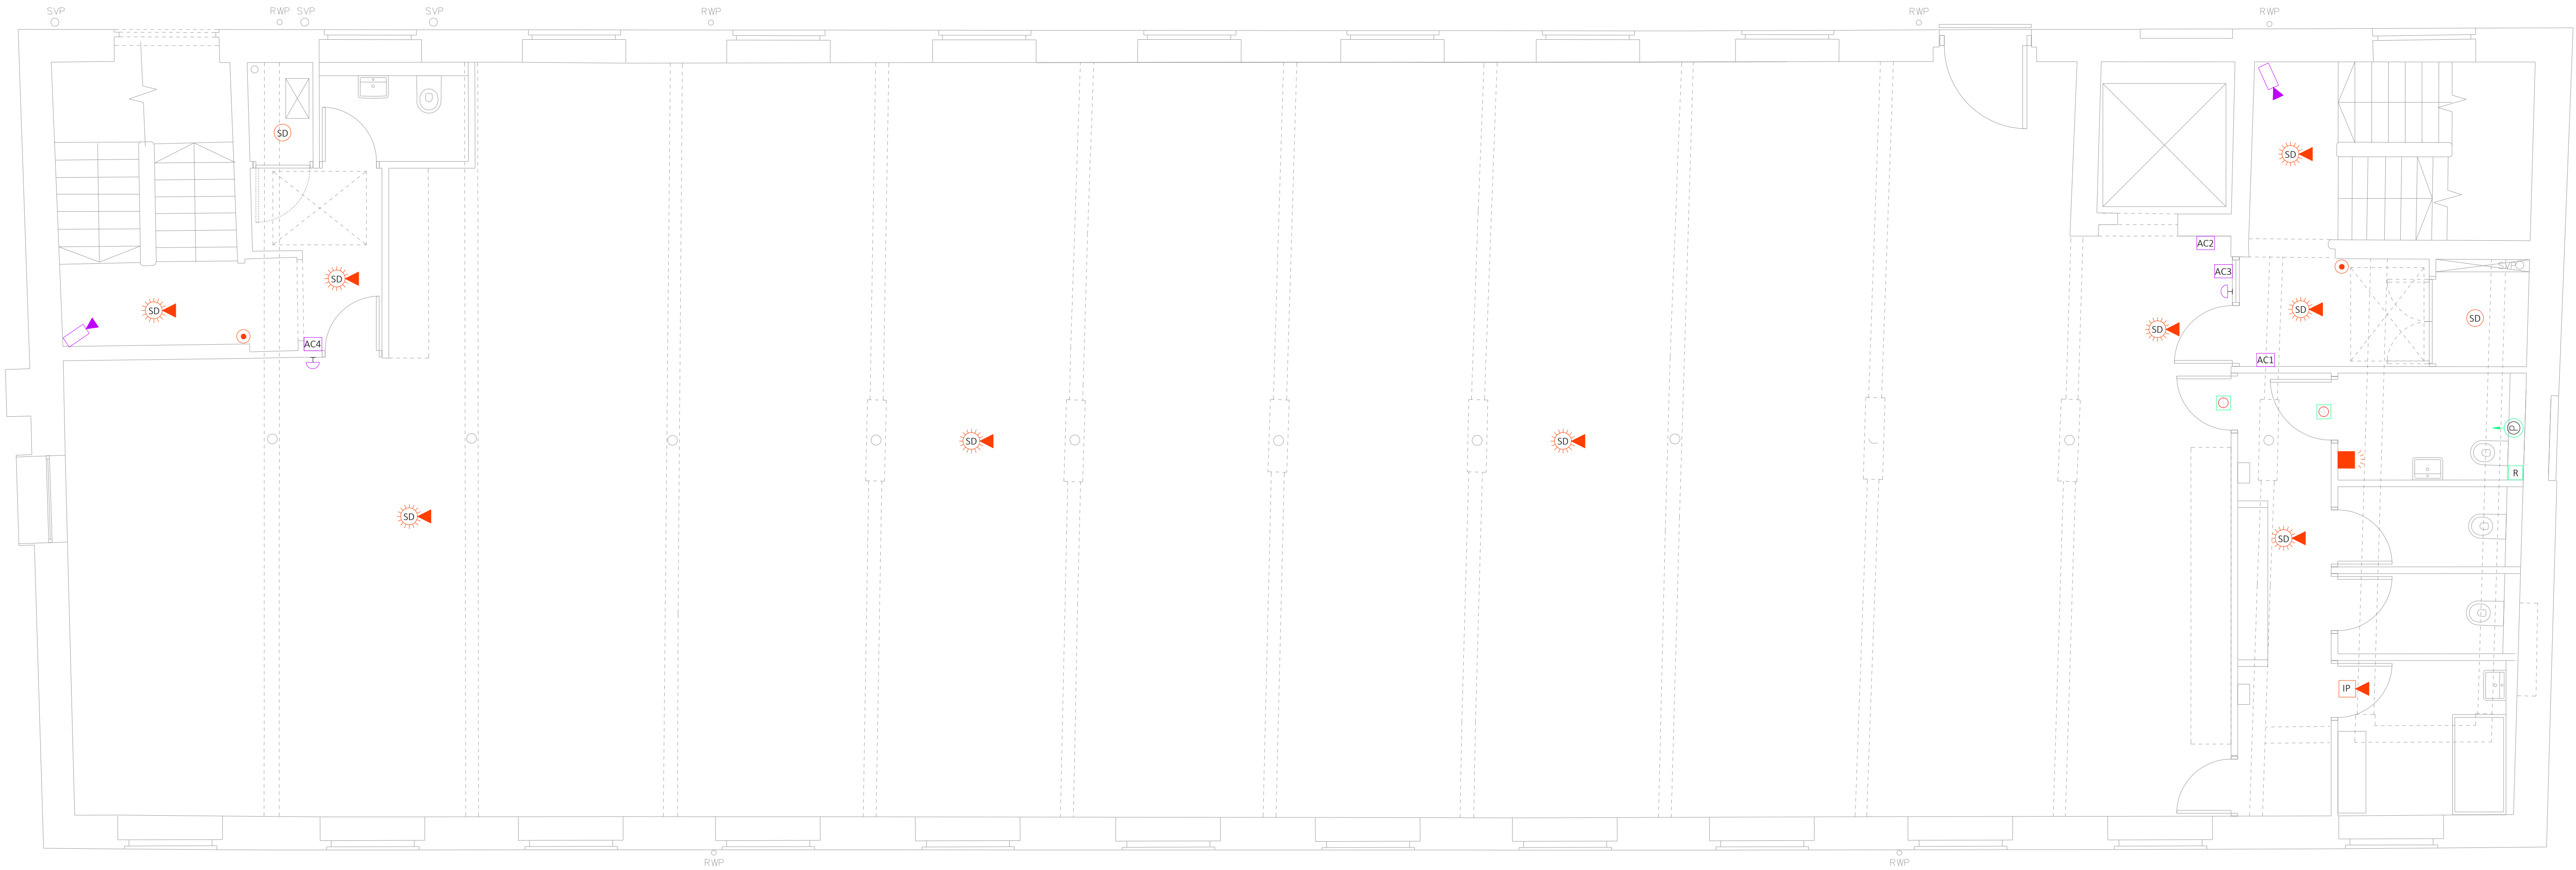

FIRE ALARM LEGEND

- HD HEAT DETECTOR
- SD SMOKE DETECTOR
- HD SD HEAT DETECTOR WITH SOUNDER
- SD SD SMOKE DETECTOR WITH SOUNDER
- HD SD HEAT DETECTOR WITH SOUNDER & FLASHING BEACON
- SD SD SMOKE DETECTOR WITH SOUNDER & FLASHING BEACON
- FAP DIGITAL ADDRESSABLE FIRE ALARM PANEL
- FAI FIRE ALARM INTERFACE UNIT DENOTED LOCALLY AS TO INTENDED USE
- FIRE ALARM BREAK GLASS
- FIRE ALARM SOUNDER UNIT
- SOUNDER WITH FLASHING BEACON
- ▲ FIRE ALARM MONITORING LINE
- WALL MOUNTED BEACON FOR EMERGENCY EVACUATION

SECURITY LEGEND

- AC COMELIT ULTRA TOUCH PANEL & ACCESS CONTROL FOB READER
- AC1 SINGLE INTERCOM CALL UNIT WITH FOB CONTROL READER
- AC2 LIFT CALL FOB CONTROL READER
- AC3 WALL/DESK MOUNTED MONITOR/RECEIVER UNIT AND REMOTE DOOR RELEASE
- AC4 FOB CONTROL READER
- ⤴ DOOR RELEASE BUTTON & EMERGENCY BREAK GLASS UNIT
- ◀ FIXED POSITION DOME CCTV CAMERA. IP DENOTES AN EXTERNAL IP RATED VERSION
- NVR 40 CHANNEL CCTV NETWORK VIDEO RECORDER
- ⬆ WC ALARM PULL CORD
- ⬆ WC ALARM RESET UNIT
- ⬆ WC ALARM OVER DOOR INDICATOR

WC ALARM LEGEND

Notes:

- This drawing is subject to copyright and is not to be reproduced in part or whole without approval.
- Do not scale this drawing - check all dimensions on site.
- This drawing shall be read in conjunction with the project specification(s) and all other contract documentation.
- All dimensions are in millimetres unless otherwise stated.
- Location of all equipment shown shall be confirmed/approved with the Client/Architect/Engineer prior to any installation.
- This drawing must be read in conjunction with Mechanical and Electrical performance specifications and all other drawings as issued by the Architect, Structural Engineer and Watt Energy and Consulting Engineers.
- The location of equipment is typical only. The Contractor shall perform all calculations to determine the exact quantity and agree the final locations with the Architect.
- This drawing shows the intended location of building services plant and service routes in such detail as to indicate the design. The drawing does not show all components that may be necessary to provide a full working installation.
- The positions of connection points, accessories and building services items are approximate and shown for guidance to assist during the tender process.
- Fully co-ordinated drawings, Construction drawings and Builderswork drawings shall be produced by the contractor. Under no circumstances shall the tender drawings be used as installation drawings.

WE&CE DRAWINGS ARE FOR DESIGN INTENT ONLY.
THE MEP CONTRACTOR IS RESPONSIBLE FOR THE
FINAL INSTALLATION DRAWINGS INCLUDING ALL
SETTING OUT, DIMENSIONS, ALIGNMENT AND
COORDINATION WITH THE ARCHITECTS
REQUIREMENTS.

T1	11/04/23	TENDER ISSUE	DK
P2	24/03/23	PRELIMINARY ISSUE	NJF
P1	10/03/23	PRELIMINARY ISSUE	NJF
Rev:	Date:	Status/Amendments:	By:




40 KING STREET, MANCHESTER, M2 6BA
TEL: 0161 434 3103 EMAIL: office@wece.co.uk

Client:
CAPITAL AND CENTRIC

Project:
CHAPELTOWN WAREHOUSE

Drawing Title:
ELECTRICAL SERVICES
FIRE ALARM AND SECURITY LAYOUT
SECOND FLOOR

Drawn By: NJF	Checked By: DW	Cad By: DK
Scale: 1:50	Paper Size: A1	Date Created: 15/02/2023
Drawing Number: WECE / 353 / E / 302	Drawing Revision: T1	

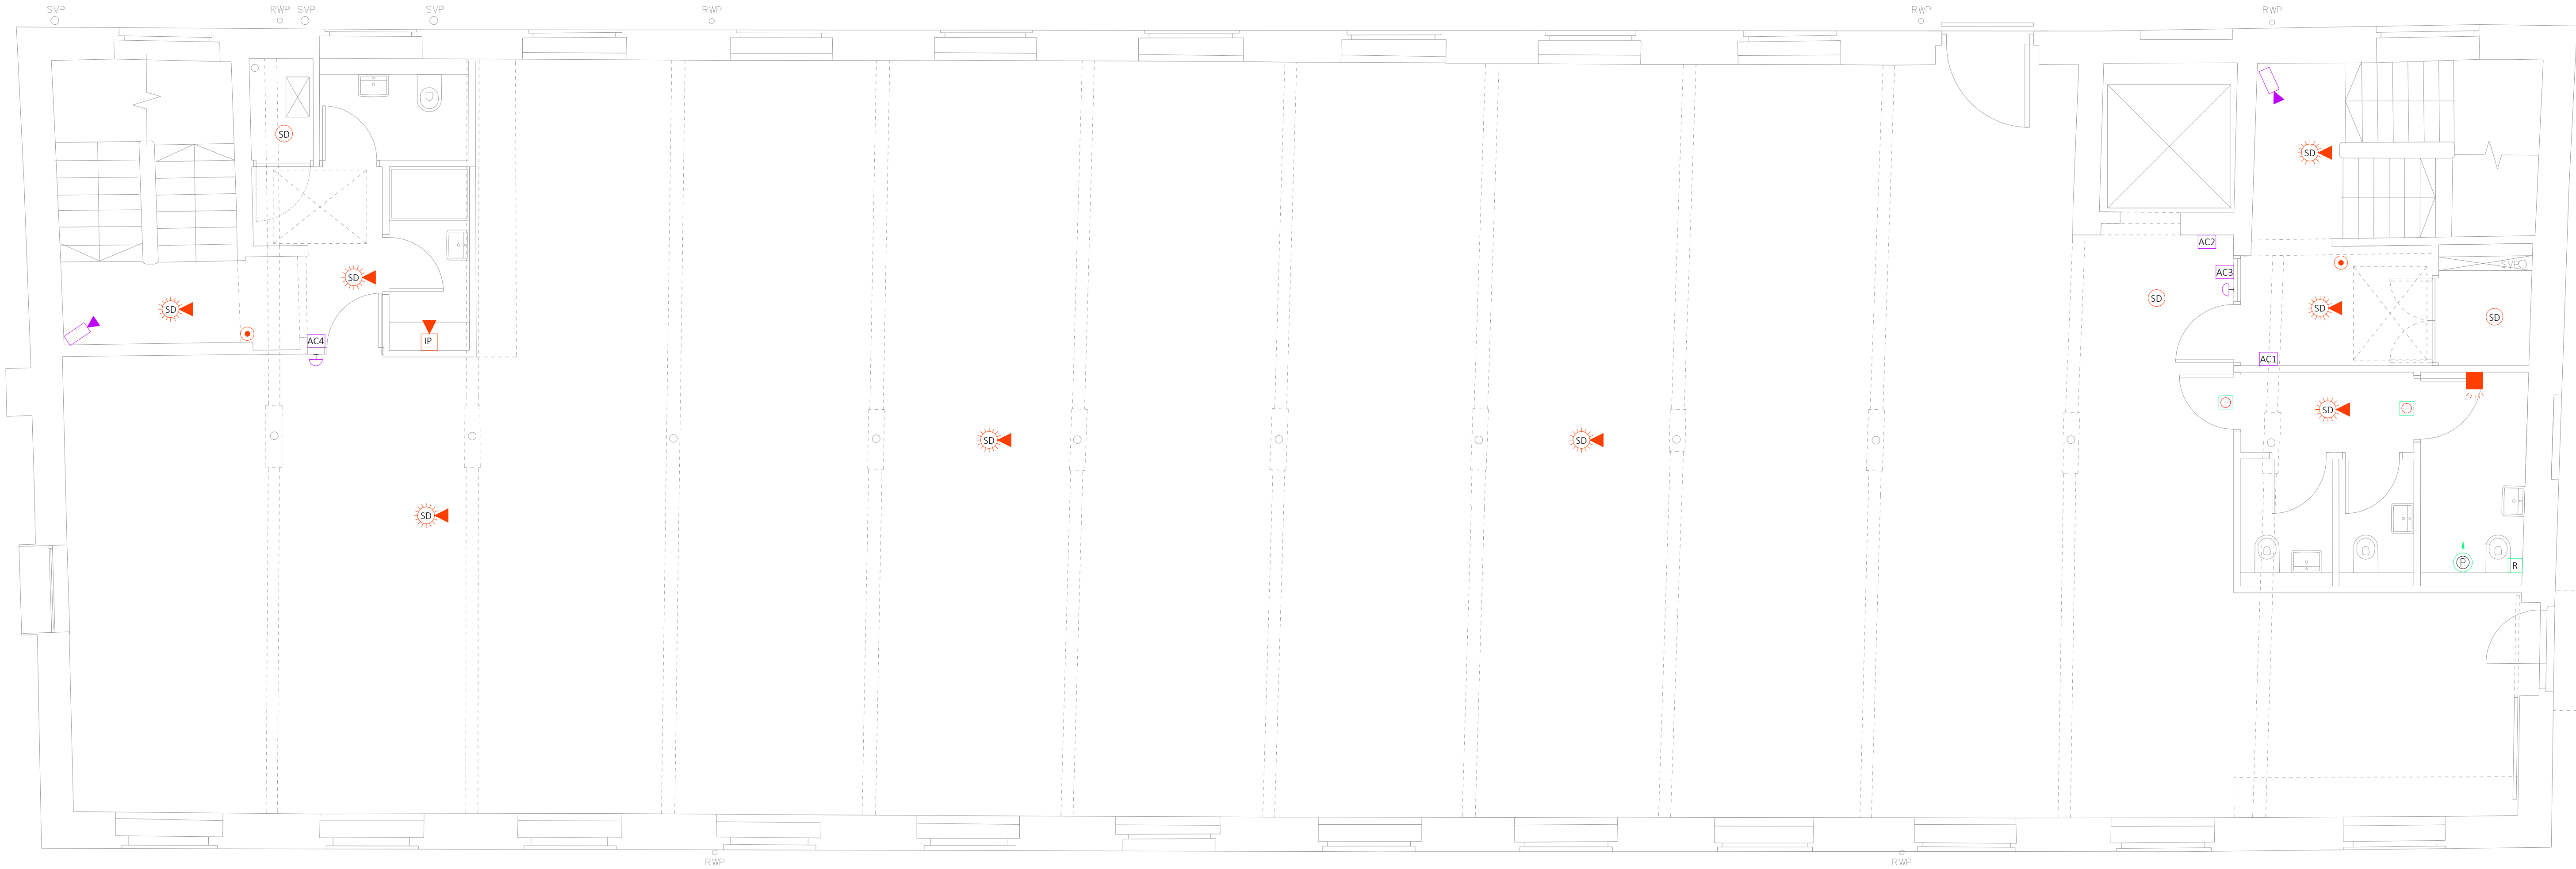

FIRE ALARM LEGEND

- HD HEAT DETECTOR
- SD SMOKE DETECTOR
- HD SMOKE DETECTOR WITH SOUNDER
- SD SMOKE DETECTOR WITH SOUNDER
- HD SMOKE DETECTOR WITH SOUNDER & FLASHING BEACON
- SD SMOKE DETECTOR WITH SOUNDER & FLASHING BEACON
- FAP DIGITAL ADDRESSABLE FIRE ALARM PANEL
- FAL FIRE ALARM INTERFACE UNIT DENOTED LOCALLY AS TO INTENDED USE
- Fire alarm break glass
- Fire alarm sounder unit
- Sounder with flashing beacon
- Fire alarm monitoring line
- Wall mounted beacon for emergency evacuation

SECURITY LEGEND

- AC COMELIT ULTRA TOUCH PANEL & ACCESS CONTROL FOB READER
- AC1 SINGLE INTERCOM CALL UNIT WITH FOB CONTROL READER
- AC2 LIFT CALL FOB CONTROL READER
- AC3 WALL/DESK MOUNTED MONITOR/RECEIVER UNIT AND REMOTE DOOR RELEASE
- AC4 FOB CONTROL READER
- Door release button & emergency break glass unit
- Fixed position dome CCTV camera. IP denotes an external IP rated version
- NVR 40 CHANNEL CCTV NETWORK VIDEO RECORDER
- WC ALARM LEGEND
- WC ALARM PULL CORD
- WC ALARM RESET UNIT
- WC ALARM OVER DOOR INDICATOR

- Notes:
- This drawing is subject to copyright and is not to be reproduced in part or whole without approval.
 - Do not scale this drawing - check all dimensions on site.
 - This drawing shall be read in conjunction with the project specification(s) and all other contract documentation.
 - All dimensions are in millimetres unless otherwise stated.
 - Location of all equipment shown shall be confirmed/approved with the Client/Architect/Engineer prior to any installation.
 - This drawing must be read in conjunction with Mechanical and Electrical performance specifications and all other drawings as issued by the Architect, Structural Engineer and Watt Energy and Consulting Engineers.
 - The location of equipment is typical only. The Contractor shall perform all calculations to determine the exact quantity and agree the final locations with the Architect.
 - This drawing shows the intended location of building services plant and service routes in such detail as to indicate the design. The drawing does not show all components that may be necessary to provide a full working installation.
 - The positions of connection points, accessories and building services items are approximate and shown for guidance to assist during the tender process.
 - Fully co-ordinated drawings, Construction drawings and Builderswork drawings shall be produced by the contractor. Under no circumstances shall the tender drawings be used as installation drawings.

WE&CE DRAWINGS ARE FOR DESIGN INTENT ONLY.
THE MEP CONTRACTOR IS RESPONSIBLE FOR THE
FINAL INSTALLATION DRAWINGS INCLUDING ALL
SETTING OUT, DIMENSIONS, ALIGNMENT AND
COORDINATION WITH THE ARCHITECTS
REQUIREMENTS.

T1	11/04/23	TENDER ISSUE	DK
P2	24/03/23	PRELIMINARY ISSUE	NJF
P1	10/03/23	PRELIMINARY ISSUE	NJF
Rev:	Date:	Status/Amendments:	By:




40 KING STREET, MANCHESTER, M2 6BA
TEL: 0161 434 3103 EMAIL: office@wece.co.uk

Client:
CAPITAL AND CENTRIC

Project:
CHAPELTOWN WAREHOUSE

Drawing Title:
ELECTRICAL SERVICES
FIRE ALARM AND SECURITY LAYOUT
THIRD FLOOR

Drawn By: NJF	Checked By: DW	Cad By: DK
Scale: 1:50	Paper Size: A1	Date Created: 15/02/2023
Drawing Number: WECE / 353 / E / 303	Drawing Revision: T1	

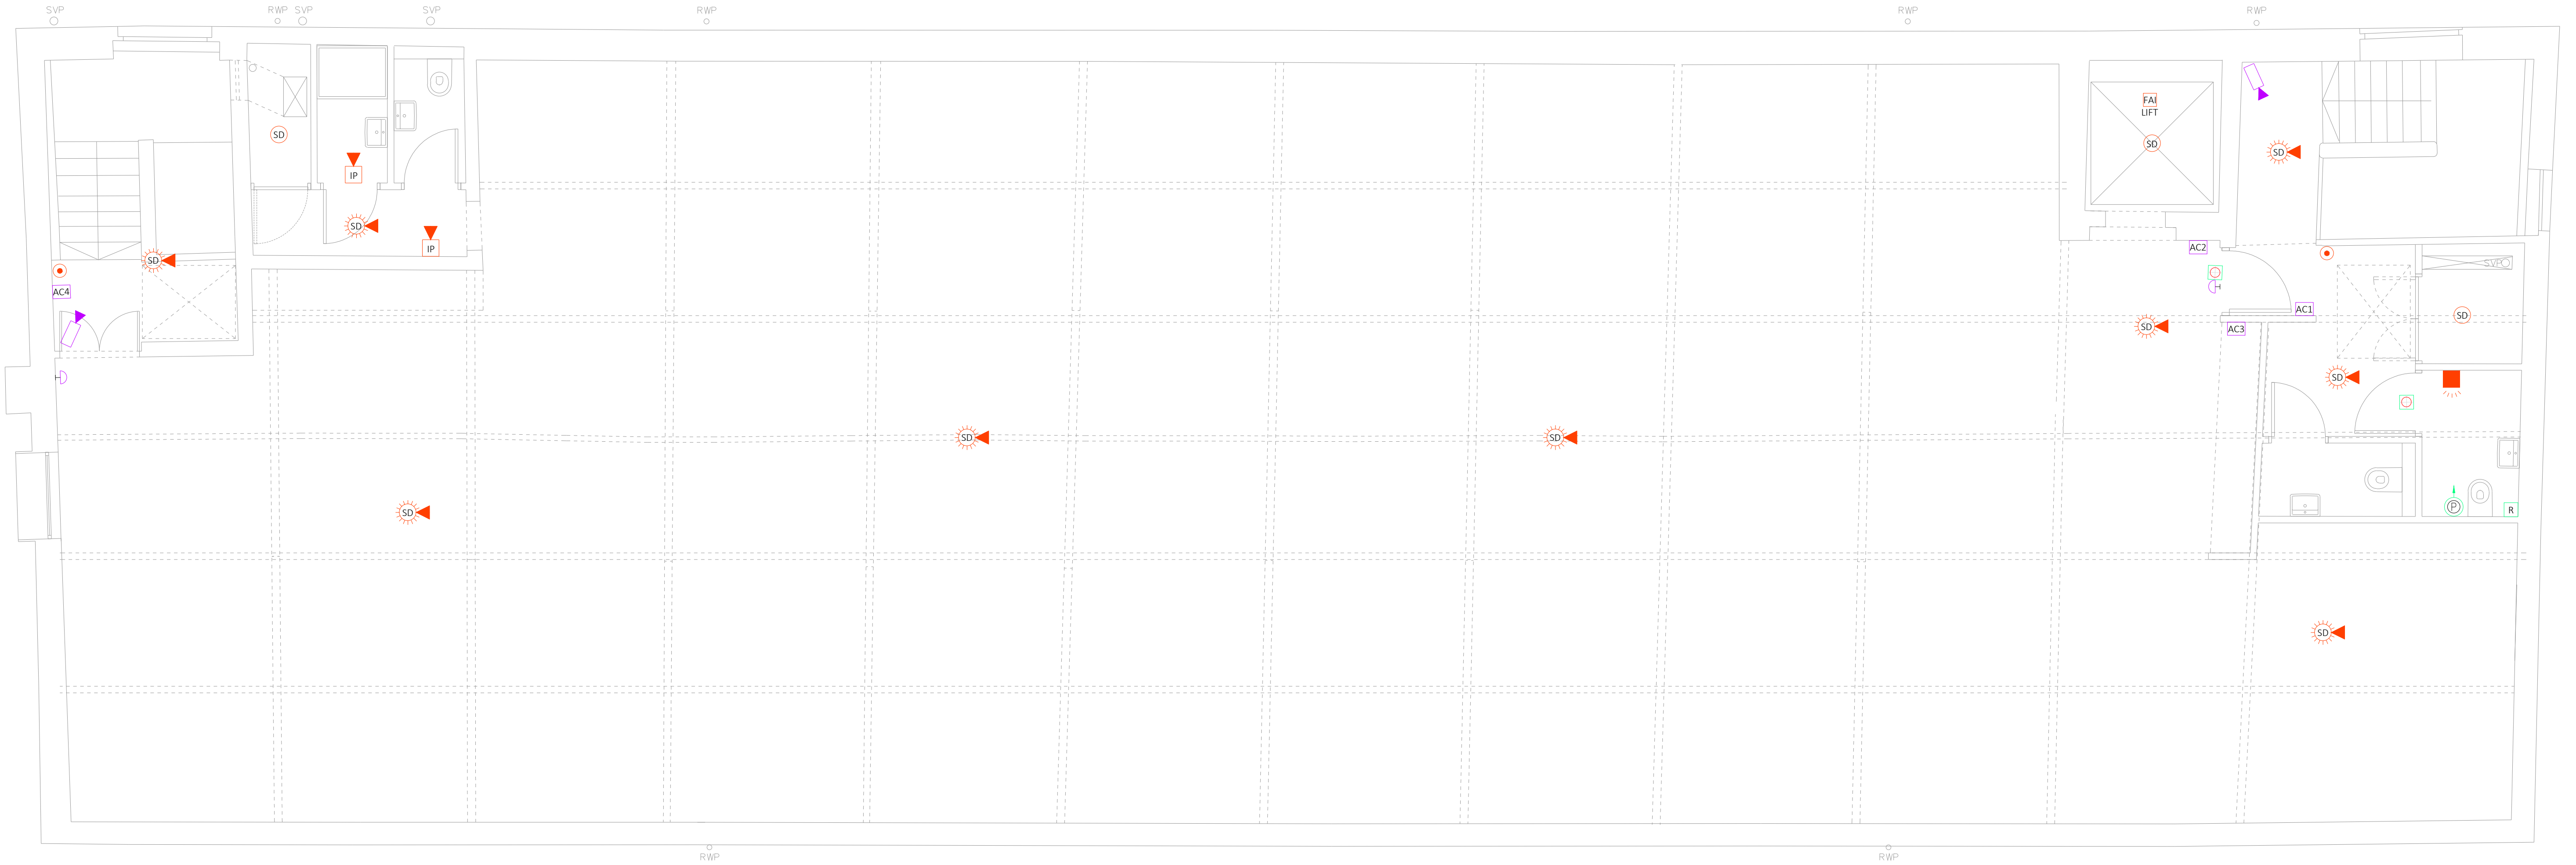

FIRE ALARM LEGEND

- HD HEAT DETECTOR
- SD SMOKE DETECTOR
- HD SMOKE DETECTOR WITH SOUNDER
- SD SMOKE DETECTOR WITH SOUNDER
- HD SMOKE DETECTOR WITH SOUNDER & FLASHING BEACON
- SD SMOKE DETECTOR WITH SOUNDER & FLASHING BEACON
- FAP DIGITAL ADDRESSABLE FIRE ALARM PANEL
- FAI FIRE ALARM INTERFACE UNIT DENOTED LOCALLY AS TO INTENDED USE
- FIRE ALARM BREAK GLASS
- FIRE ALARM SOUNDER UNIT
- SOUNDER WITH FLASHING BEACON
- ▲ FIRE ALARM MONITORING LINE
- WALL MOUNTED BEACON FOR EMERGENCY EVACUATION

SECURITY LEGEND

- AC COMELIT ULTRA TOUCH PANEL & ACCESS CONTROL FOB READER
- AC1 SINGLE INTERCOM CALL UNIT WITH FOB CONTROL READER
- AC2 LIFT CALL FOB CONTROL READER
- AC3 WALL/DESK MOUNTED MONITOR/RECEIVER UNIT AND REMOTE DOOR RELEASE
- AC4 FOB CONTROL READER
- ⤴ DOOR RELEASE BUTTON & EMERGENCY BREAK GLASS UNIT
- ◀ FIXED POSITION DOME CCTV CAMERA. IP DENOTES AN EXTERNAL IP RATED VERSION
- NVR 40 CHANNEL CCTV NETWORK VIDEO RECORDER
- ⬆ WC ALARM PULL CORD
- Ⓡ WC ALARM RESET UNIT
- Ⓢ WC ALARM OVER DOOR INDICATOR

Notes:

- This drawing is subject to copyright and is not to be reproduced in part or whole without approval.
- Do not scale this drawing - check all dimensions on site.
- This drawing shall be read in conjunction with the project specification(s) and all other contract documentation.
- All dimensions are in millimetres unless otherwise stated.
- Location of all equipment shown shall be confirmed/approved with the Client/Architect/Engineer prior to any installation.
- This drawing must be read in conjunction with Mechanical and Electrical performance specifications and all other drawings as issued by the Architect, Structural Engineer and Watt Energy and Consulting Engineers.
- The location of equipment is typical only. The Contractor shall perform all calculations to determine the exact quantity and agree the final locations with the Architect.
- This drawing shows the intended location of building services plant and service routes in such detail as to indicate the design. The drawing does not show all components that may be necessary to provide a full working installation.
- The positions of connection points, accessories and building services items are approximate and shown for guidance to assist during the tender process.
- Fully co-ordinated drawings, Construction drawings and Builderswork drawings shall be produced by the contractor. Under no circumstances shall the tender drawings be used as installation drawings.

WE&CE DRAWINGS ARE FOR DESIGN INTENT ONLY.
THE MEP CONTRACTOR IS RESPONSIBLE FOR THE
FINAL INSTALLATION DRAWINGS INCLUDING ALL
SETTING OUT, DIMENSIONS, ALIGNMENT AND
COORDINATION WITH THE ARCHITECTS
REQUIREMENTS.

T1	11/04/23	TENDER ISSUE	DK
P2	24/03/23	PRELIMINARY ISSUE	NJF
P1	10/03/23	PRELIMINARY ISSUE	NJF
Rev:	Date:	Status/Amendments:	By:




40 KING STREET, MANCHESTER, M2 6BA
TEL: 0161 434 3103 EMAIL: office@wece.co.uk

Client:
CAPITAL AND CENTRIC

Project:
CHAPELTOWN WAREHOUSE

Drawing Title:
ELECTRICAL SERVICES
FIRE ALARM AND SECURITY LAYOUT
FOURTH FLOOR

Drawn By: NJF	Checked By: DW	Cad By: DK
Scale: 1:50	Paper Size: A1	Date Created: 15/02/2023
Drawing Number: WECE / 353 / E / 304	Drawing Revision: T1	

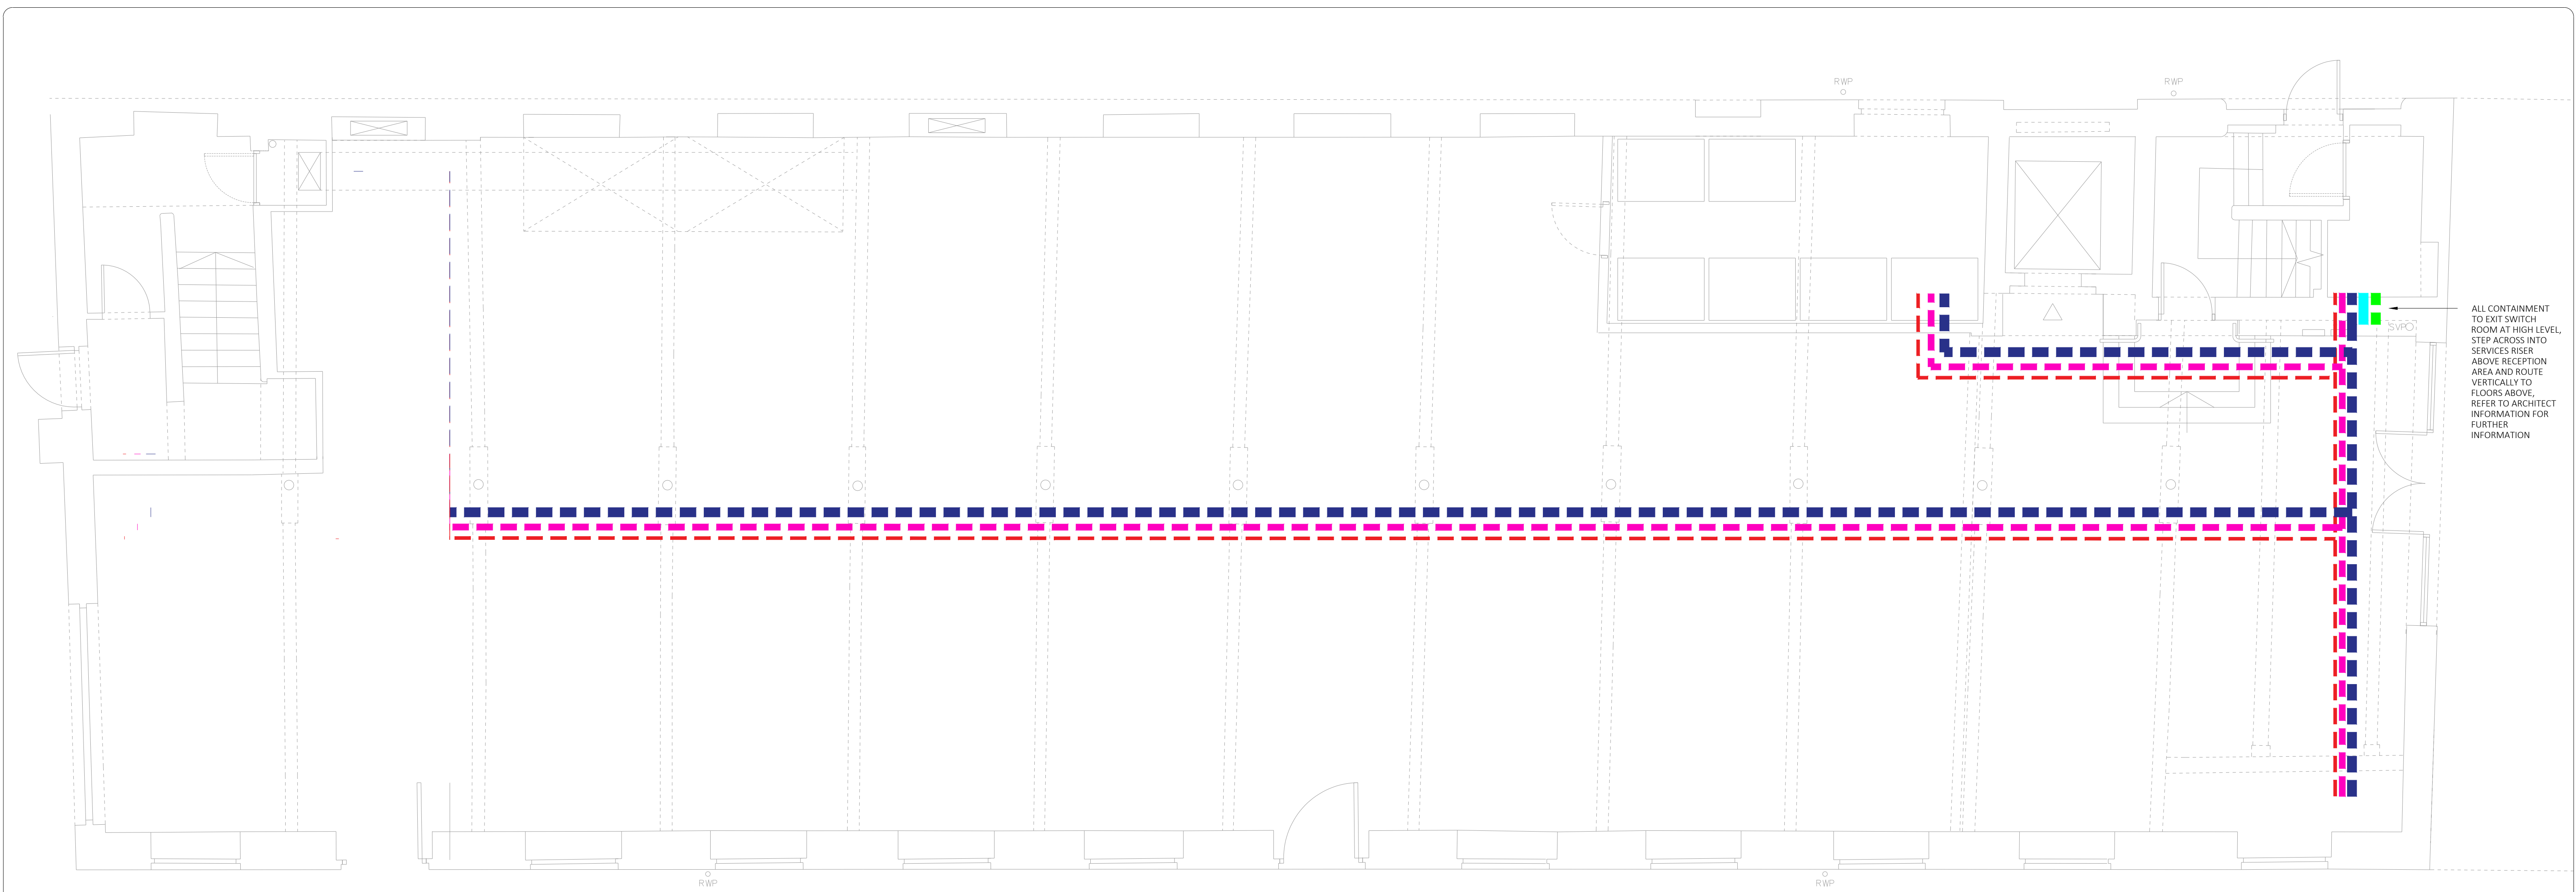

CONTAINMENT LEGEND:

100mm COMMS/DATA - BASKET

150mm POWER & LIGHTING - TRAY

100mm COMMS (FIBRE) - BASKET

50mm FIRE ALARM - TRAY

150mm SUB MAIN - TRAY

- Notes:
- This drawing is subject to copyright and is not to be reproduced in part or whole without approval.
 - Do not scale this drawing - check all dimensions on site.
 - This drawing shall be read in conjunction with the project specification(s) and all other contract documentation.
 - All dimensions are in millimetres unless otherwise stated.
 - Location of all equipment shown shall be confirmed/approved with the Client/Architect/Engineer prior to any installation.
 - This drawing must be read in conjunction with Mechanical and Electrical performance specifications and all other drawings as issued by the Architect, Structural Engineer and Watt Energy and Consulting Engineers.
 - The location of equipment is typical only. The Contractor shall perform all calculations to determine the exact quantity and agree the final locations with the Architect.
 - This drawing shows the intended location of building services plant and service routes in such detail as to indicate the design. The drawing does not show all components that may be necessary to provide a full working installation.
 - The positions of connection points, accessories and building services items are approximate and shown for guidance to assist during the tender process.
 - Fully co-ordinated drawings, Construction drawings and Builderswork drawings shall be produced by the contractor. Under no circumstances shall the tender drawings be used as installation drawings.

WE&CE DRAWINGS ARE FOR DESIGN INTENT ONLY.
THE MEP CONTRACTOR IS RESPONSIBLE FOR THE
FINAL INSTALLATION DRAWINGS INCLUDING ALL
SETTING OUT, DIMENSIONS, ALIGNMENT AND
COORDINATION WITH THE ARCHITECTS
REQUIREMENTS.

T1	11/04/23	TENDER ISSUE	DK
P1	10/03/23	PRELIMINARY ISSUE	NJF
Rev:	Date:	Status/Amendments:	By:



40 KING STREET, MANCHESTER, M2 6BA
TEL: 0161 434 3103 EMAIL: office@wece.co.uk

Client:
CAPITAL AND CENTRIC

Project:
CHAPELTOWN WAREHOUSE

Drawing Title:
ELECTRICAL SERVICES
CONTAINMENT LAYOUT
GROUND FLOOR

Drawn By: NJF	Checked By: DW	Cad By: DK
Scale: 1:50	Paper Size: A1	Date Created: 15/02/2023
Drawing Number: WECE / 353 / E / 400	Drawing Revision: T1	



CONTAINMENT LEGEND:

100mm COMMS/DATA - BASKET

150mm POWER & LIGHTING - TRAY

100mm COMMS (FIBRE) - BASKET

50mm FIRE ALARM - TRAY

150mm SUB MAIN - TRAY

- Notes:
- This drawing is subject to copyright and is not to be reproduced in part or whole without approval.
 - Do not scale this drawing - check all dimensions on site.
 - This drawing shall be read in conjunction with the project specification(s) and all other contract documentation.
 - All dimensions are in millimetres unless otherwise stated.
 - Location of all equipment shown shall be confirmed/approved with the Client/Architect/Engineer prior to any installation.
 - This drawing must be read in conjunction with Mechanical and Electrical performance specifications and all other drawings as issued by the Architect, Structural Engineer and Watt Energy and Consulting Engineers.
 - The location of equipment is typical only. The Contractor shall perform all calculations to determine the exact quantity and agree the final locations with the Architect.
 - This drawing shows the intended location of building services plant and service routes in such detail as to indicate the design. The drawing does not show all components that may be necessary to provide a full working installation.
 - The positions of connection points, accessories and building services items are approximate and shown for guidance to assist during the tender process.
 - Fully co-ordinated drawings, Construction drawings and Builderswork drawings shall be produced by the contractor. Under no circumstances shall the tender drawings be used as installation drawings.

WE&CE DRAWINGS ARE FOR DESIGN INTENT ONLY.
THE MEP CONTRACTOR IS RESPONSIBLE FOR THE
FINAL INSTALLATION DRAWINGS INCLUDING ALL
SETTING OUT, DIMENSIONS, ALIGNMENT AND
COORDINATION WITH THE ARCHITECTS
REQUIREMENTS.

T1	11/04/23	TENDER ISSUE	DK
P1	10/03/23	PRELIMINARY ISSUE	NJF
Rev:	Date:	Status/Amendments:	By:


40 KING STREET, MANCHESTER, M2 6BA
TEL: 0161 434 3103 EMAIL: office@wece.co.uk

Client:
CAPITAL AND CENTRIC

Project:
CHAPELTOWN WAREHOUSE

Drawing Title:
ELECTRICAL SERVICES
CONTAINMENT LAYOUT
FIRST FLOOR

Drawn By: NJF	Checked By: DW	Cad By: DK
Scale: 1:60	Paper Size: A1	Date Created: 15/02/2023
Drawing Number: WECE / 353 / E / 401		Drawing Revision: T1

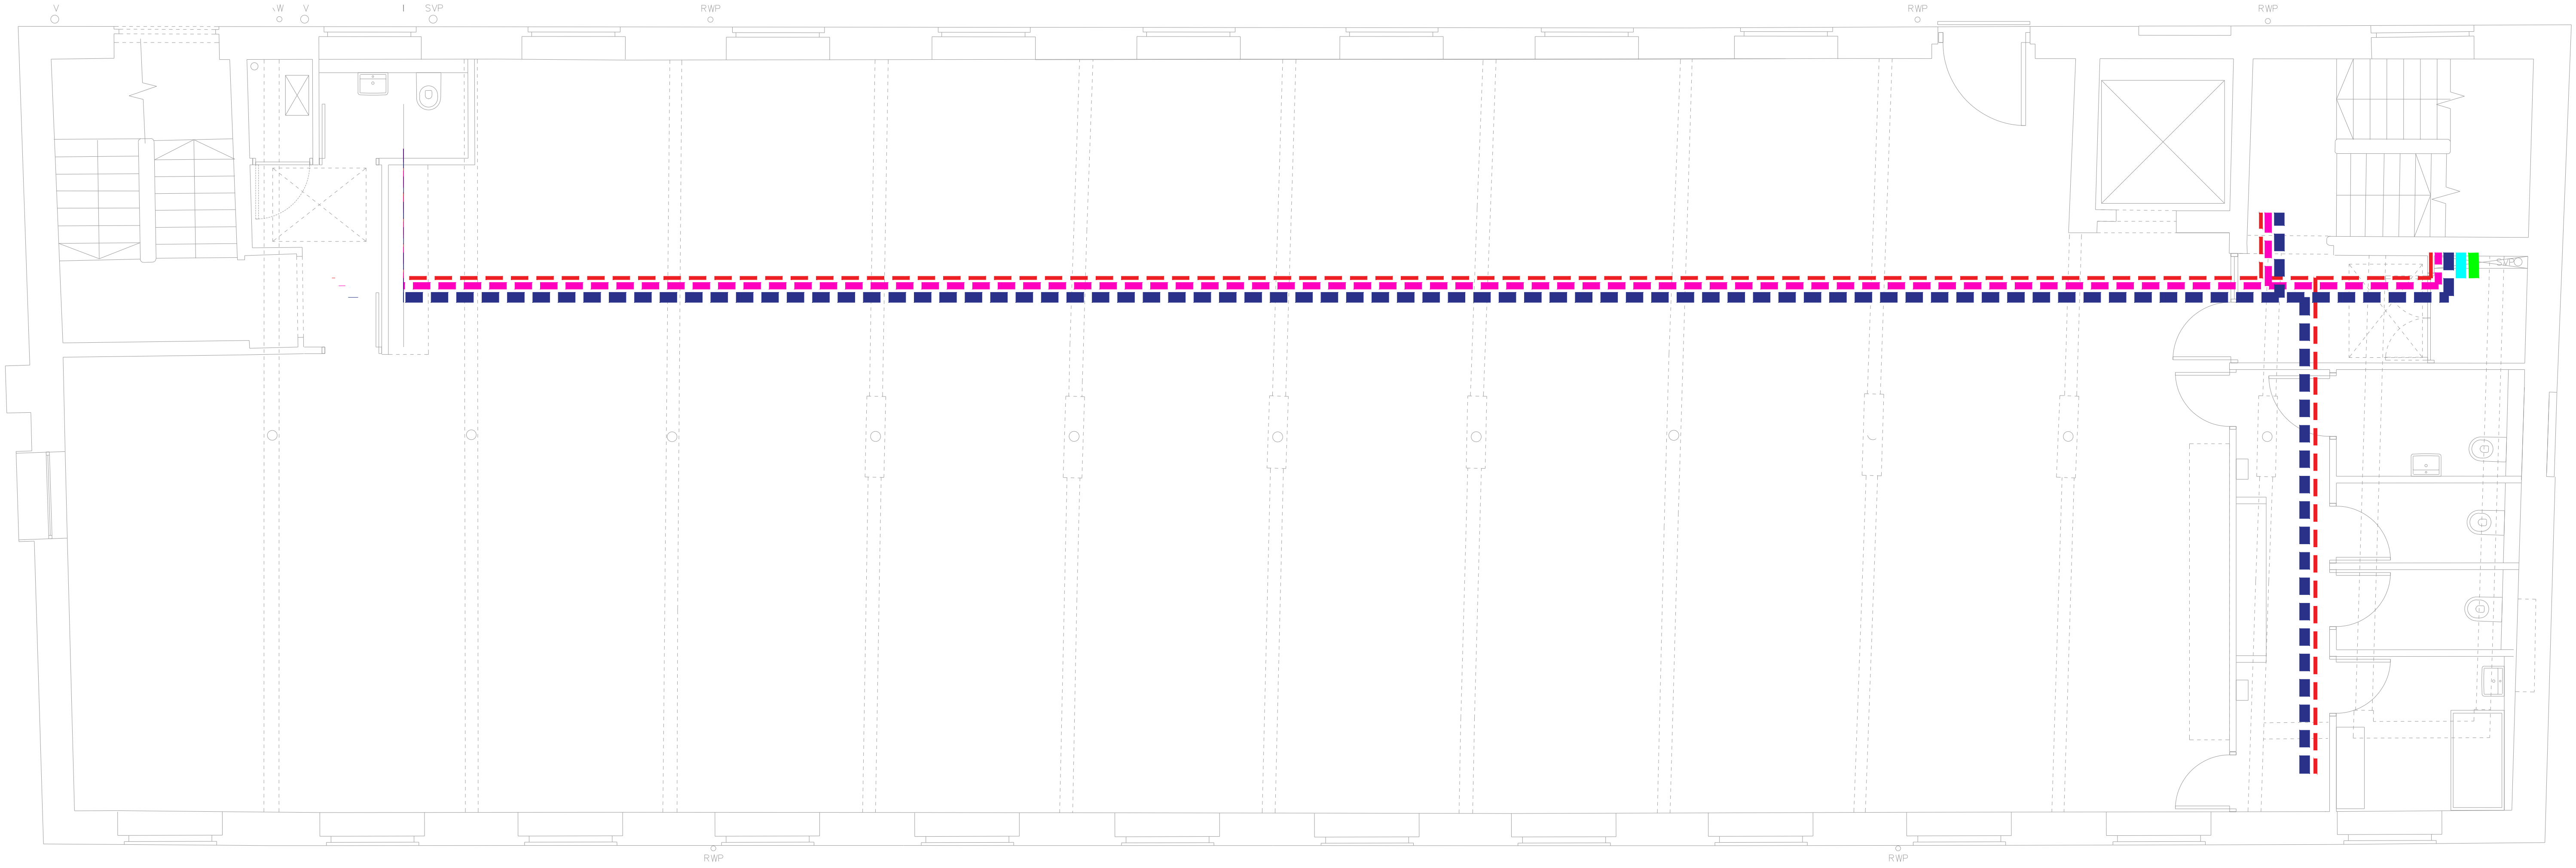

CONTAINMENT LEGEND:

100mm COMMS/DATA - BASKET

150mm POWER & LIGHTING - TRAY

100mm COMMS (FIBRE) - BASKET

50mm FIRE ALARM - TRAY

150mm SUB MAIN - TRAY

Notes:

- This drawing is subject to copyright and is not to be reproduced in part or whole without approval.
- Do not scale this drawing - check all dimensions on site.
- This drawing shall be read in conjunction with the project specification(s) and all other contract documentation.
- All dimensions are in millimetres unless otherwise stated.
- Location of all equipment shown shall be confirmed/approved with the Client/Architect/Engineer prior to any installation.
- This drawing must be read in conjunction with Mechanical and Electrical performance specifications and all other drawings as issued by the Architect, Structural Engineer and Watt Energy and Consulting Engineers.
- The location of equipment is typical only. The Contractor shall perform all calculations to determine the exact quantity and agree the final locations with the Architect.
- This drawing shows the intended location of building services plant and service routes in such detail as to indicate the design. The drawing does not show all components that may be necessary to provide a full working installation.
- The positions of connection points, accessories and building services items are approximate and shown for guidance to assist during the tender process.
- Fully co-ordinated drawings, Construction drawings and Builderswork drawings shall be produced by the contractor. Under no circumstances shall the tender drawings be used as installation drawings.

WE&CE DRAWINGS ARE FOR DESIGN INTENT ONLY.
THE MEP CONTRACTOR IS RESPONSIBLE FOR THE
FINAL INSTALLATION DRAWINGS INCLUDING ALL
SETTING OUT, DIMENSIONS, ALIGNMENT AND
COORDINATION WITH THE ARCHITECTS
REQUIREMENTS.

T1	11/04/23	TENDER ISSUE	DK
P1	10/03/23	PRELIMINARY ISSUE	NJF
Rev:	Date:	Status/Amendments:	By:




40 KING STREET, MANCHESTER, M2 6BA
TEL: 0161 434 3103 EMAIL: office@wece.co.uk

Client:
CAPITAL AND CENTRIC

Project:
CHAPELTOWN WAREHOUSE

Drawing Title:
ELECTRICAL SERVICES
CONTAINMENT LAYOUT
SECOND FLOOR

Drawn By: NJF	Checked By: DW	Cad By: DK
Scale: 1:50	Paper Size: A1	Date Created: 15/02/2023
Drawing Number: WECE / 353 / E / 402		Drawing Revision: T1

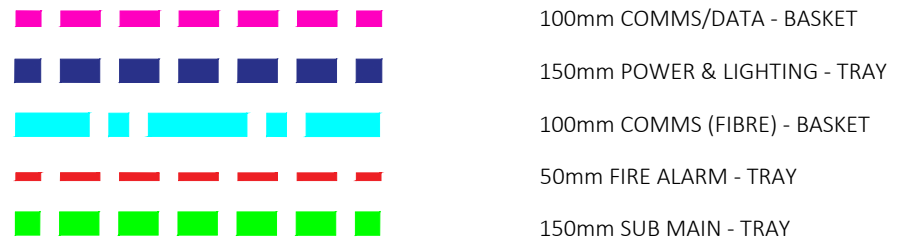

100mm COMMS/DATA - BASKET
150mm POWER & LIGHTING - TRAY
100mm COMMS (FIBRE) - BASKET
50mm FIRE ALARM - TRAY
150mm SUB MAIN - TRAY

1. This drawing is subject to copyright and is not to be reproduced in part or whole without approval.
2. Do not scale this drawing - check all dimensions on site.
3. This drawing shall be read in conjunction with the project specification(s) and all other contract documentation.
4. All dimensions are in millimetres unless otherwise stated.
5. Location of all equipment shown shall be confirmed/approved with the Client/Architect/Engineer prior to any installation.
6. This drawing must be read in conjunction with Mechanical and Electrical performance specifications and all other drawings as issued by the Architect, Structural Engineer and Watt Energy and Consulting Engineers.
7. The location of equipment is typical only. The Contractor shall perform all calculations to determine the exact quantity and agree the final locations with the Architect.
8. This drawing shows the intended location of building services plant and service routes in such detail as to indicate the design. The drawing does not show all components that may be necessary to provide a full working installation.
9. The positions of connection points, accessories and building services items are approximate and shown for guidance to assist during the tender process.
10. Fully co-ordinated drawings, Construction drawings and Builderswork drawings shall be produced by the contractor. Under no circumstances shall the tender drawings be used as installation drawings.

WE&CE DRAWINGS ARE FOR DESIGN INTENT ONLY.
THE MEP CONTRACTOR IS RESPONSIBLE FOR THE
FINAL INSTALLATION DRAWINGS INCLUDING ALL
SETTING OUT, DIMENSIONS, ALIGNMENT AND
COORDINATION WITH THE ARCHITECTS
REQUIREMENTS.

40 KING STREET, MANCHESTER, M2 6BA
TEL: 0161 434 3103 EMAIL: office@wece.co.uk


Client: CAPITAL AND CENTRIC

Project: CHAPELTOWN WAREHOUSE

Drawing Title:

ELECTRICAL SERVICES
CONTAINMENT LAYOUT
THIRD FLOOR

Drawn By: NJF	Checked By: DW	Cad By: DK
Scale: 1:50	Paper Size: A1	Date Created: 15/02/2023
Drawing Number: WECE / 353 / E / 403		Drawing Revision: T1

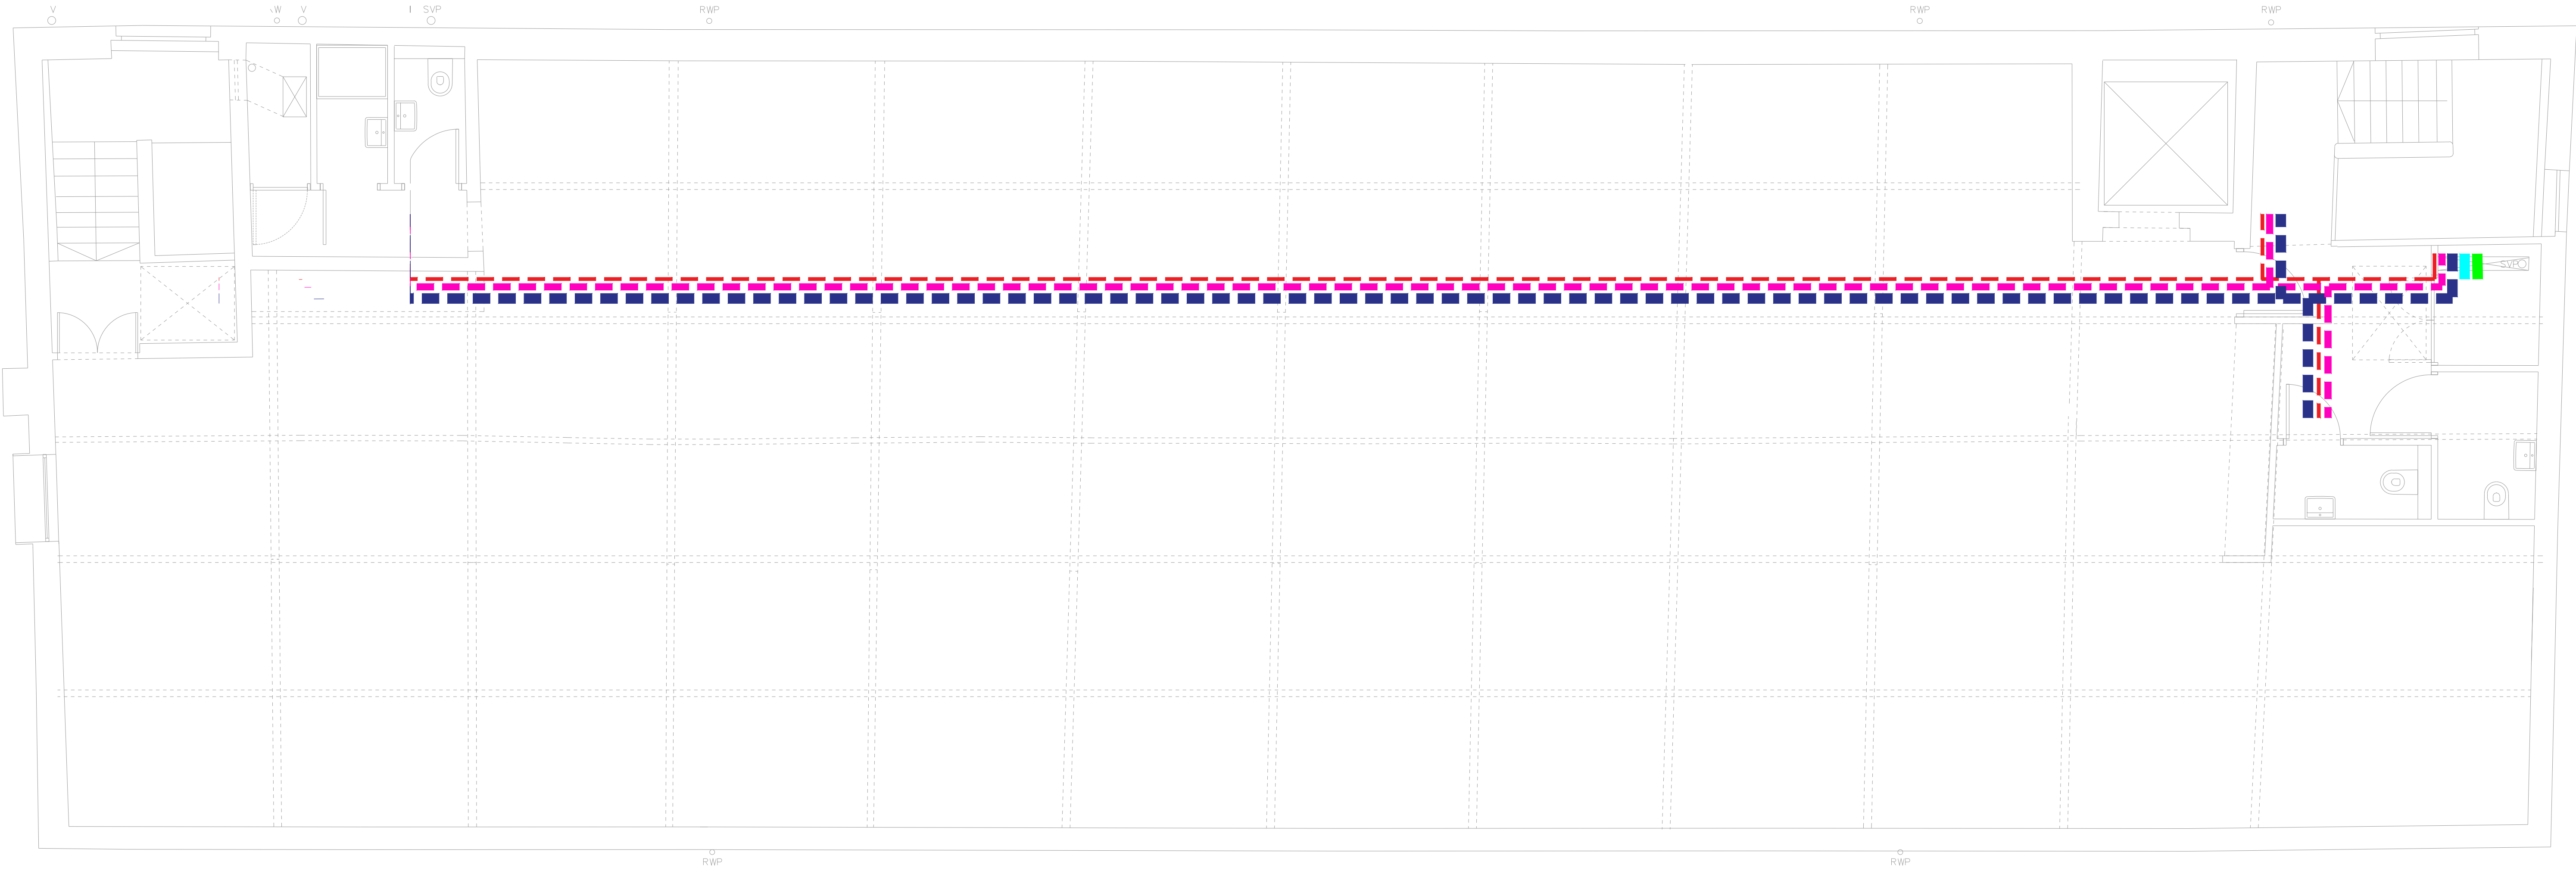

CONTAINMENT LEGEND:

100mm COMMS/DATA - BASKET

150mm POWER & LIGHTING - TRAY

100mm COMMS (FIBRE) - BASKET

50mm FIRE ALARM - TRAY

150mm SUB MAIN - TRAY

Notes:

- This drawing is subject to copyright and is not to be reproduced in part or whole without approval.
- Do not scale this drawing - check all dimensions on site.
- This drawing shall be read in conjunction with the project specification(s) and all other contract documentation.
- All dimensions are in millimetres unless otherwise stated.
- Location of all equipment shown shall be confirmed/approved with the Client/Architect/Engineer prior to any installation.
- This drawing must be read in conjunction with Mechanical and Electrical performance specifications and all other drawings as issued by the Architect, Structural Engineer and Watt Energy and Consulting Engineers.
- The location of equipment is typical only. The Contractor shall perform all calculations to determine the exact quantity and agree the final locations with the Architect.
- This drawing shows the intended location of building services plant and service routes in such detail as to indicate the design. The drawing does not show all components that may be necessary to provide a full working installation.
- The positions of connection points, accessories and building services items are approximate and shown for guidance to assist during the tender process.
- Fully co-ordinated drawings, Construction drawings and Builderswork drawings shall be produced by the contractor. Under no circumstances shall the tender drawings be used as installation drawings.

WE&CE DRAWINGS ARE FOR DESIGN INTENT ONLY.
THE MEP CONTRACTOR IS RESPONSIBLE FOR THE
FINAL INSTALLATION DRAWINGS INCLUDING ALL
SETTING OUT, DIMENSIONS, ALIGNMENT AND
COORDINATION WITH THE ARCHITECTS
REQUIREMENTS.

T1	11/04/23	TENDER ISSUE	DK
P1	10/03/23	PRELIMINARY ISSUE	NJF
Rev:	Date:	Status/Amendments:	By:



40 KING STREET, MANCHESTER, M2 6BA
TEL: 0161 434 3103 EMAIL: office@wece.co.uk

Client:
CAPITAL AND CENTRIC

Project:
CHAPELTOWN WAREHOUSE

Drawing Title:
ELECTRICAL SERVICES
CONTAINMENT LAYOUT
FOURTH FLOOR

Drawn By: NJF	Checked By: DW	Cad By: DK
Scale: 1:50	Paper Size: A1	Date Created: 15/02/2023
Drawing Number: WECE / 353 / E / 404		Drawing Revision: T1